

STANDARD MECHANICAL DESIGN DETAIL DRAWING FOR MECHANICAL SYSTEMS IN BUILDINGS



CAWANGAN KEJURUTERAAN MEKANIKAL
IBU PEJABAT JKR MALAYSIA

REVISION 2017

CONTENTS

1

Foreword

2

List of Drawings

✚ Section I :Air Conditioning & Mechanical Ventilation System

✚ Section II :Fire Fighting System

✚ Section III :Lift & Escalator System

✚ Section IV :Cold Water and Sanitary Plumbing System

3

Acknowledgement

Foreword

This **Standard Mechanical Design Detail Drawing For Mechanical Systems in Buildings** was prepared as a revised edition to the 1st edition published in 2011.

This 2nd edition 2017 is an improved version to enhance guidance and information for Mechanical Engineers with the latest requirement of the detailed installation of mechanical system specifically focus on Air Conditioning & Mechanical System, Fire Fighting System, Lift System and Cold Water and Sanitary Plumbing System in government building projects.

The revised edition have adopted latest requirement, standards and requirement such as standard JKR technical specification and criteria from lesson learned, do and dont's as well as good engineering practices.

The objectives of the standard detail drawings are as follows:

- ✓ Assist JKR professional with the latest requirement in the design and installation of mechanical system in the building
- ✓ Provide latest reference for JKR mechanical designers, project team and contractors
- ✓ To expedite time for preparing tender document as well as procurement of mechanical system in the building
- ✓ Improve quality of installation of mechanical system in the government building project implementation

Special thanks to committee members who were highly dedicated and who contributed towards the successful completion of this standard drawings.

IR. GOPAL NARIAN KUTTY JMW,AMN
PENGARAH KANAN
CAWANGAN KEJURUTERAAN MEKANIKAL
IBU PEJABAT JKR MALAYSIA
KUALA LUMPUR

Acknowledgement

Special thanks to the following for making the revision of this publication possible.

- | | | |
|-----|-------------------------------------|--|
| 1. | Ir. Razdwan bin Kasim | Pengarah Khidmat Pakar Cawangan Kejuruteraan Mekanikal |
| 2. | Ir. Mamat Rohizan bin Abdullah | Pengarah Rekabentuk Cawangan Kejuruteraan Mekanikal |
| 3. | Ir. Hj. Zulkifli bin Abdul Rashad | Cawangan Kejuruteraan Mekanikal |
| 4. | En. Che Hasim bin Awang | Cawangan Kejuruteraan Mekanikal |
| 5. | Pn. Syarifah Dzain binti Syed Yusof | Cawangan Kejuruteraan Mekanikal |
| 6. | En. Azrul Nizam bin Adenan | Cawangan Kejuruteraan Mekanikal |
| 7. | En. Mohd Hairie bin Abdul Halim | Cawangan Kejuruteraan Mekanikal |
| 8. | En. Afdhal bin Yusof | Cawangan Kejuruteraan Mekanikal |
| 9. | En. Bong Boon Kang | Cawangan Kejuruteraan Mekanikal |
| 10. | En. Ramli bin Husin | Cawangan Kejuruteraan Mekanikal |
| 11. | En. Mohd Affendy bin Sukarseh | Cawangan Kejuruteraan Mekanikal |
| 12. | En. Mohd Hakim bin Awaluddin | Cawangan Kejuruteraan Mekanikal |
| 13. | En. Wan Hisyam bin Wan Mansor | Cawangan Kejuruteraan Mekanikal |
| 14. | En. Mohd Azhar bin Abd Razak | Cawangan Kejuruteraan Mekanikal |


Special thanks to the JKR committee members for Standard Mechanical Design Detail Drawing For Mechanical Systems in Buildings which consist of the following representatives:

- | | | |
|-----|---------------------------------------|---------------------------------|
| 1. | Ir. Mohamad Zaini bin Bakar | Cawangan Kejuruteraan Mekanikal |
| 2. | Ir. Yatim Selamat bin Latib | Cawangan Kejuruteraan Mekanikal |
| 3. | Ir. Hj. Hasbullah bin Osman | Cawangan Kejuruteraan Mekanikal |
| 4. | Ir. Mohamad Tarmuzi bin Mat Nor | CKM Negeri Selangor |
| 5. | En. Mohd Norddin bin Ismail | Cawangan Kerja Bangunan Am |
| 6. | Ir. Mohammad Nazri bin Sulaiman | Cawangan Kejuruteraan Mekanikal |
| 7. | En. Mohd Izzat Zumairi bin Che Harun | Cawangan Kejuruteraan Mekanikal |
| 8. | Ir. Mohd Azmi bin Hashim | Cawangan Kejuruteraan Mekanikal |
| 9. | Ir. Nor Haziman bin Noh | Cawangan Kejuruteraan Mekanikal |
| 10. | En. Azizul Rahim bin Mohamad Zulkifli | Cawangan Kejuruteraan Mekanikal |
| 11. | En. Mohd Maarif bin Abdul Malik | Cawangan Kejuruteraan Mekanikal |
| 12. | En. Mohd Faiz Fikri bin Yussoff | Cawangan Kejuruteraan Mekanikal |

STANDARD MECHANICAL DESIGN DETAIL DRAWING FOR MECHANICAL SYSTEMS IN BUILDINGS

SECTION 1 : AIR CONDITIONING AND MECHANICAL VENTILATION SYSTEM

CAWANGAN KEJURUTERAAN MEKANIKAL
IBU PEJABAT JKR MALAYSIA
KUALA LUMPUR

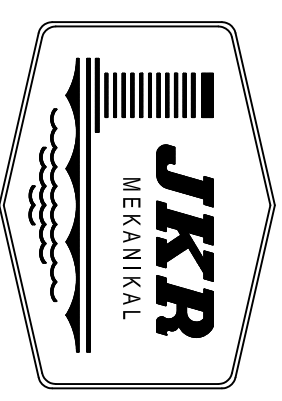

JASA KEPADA RAKYAT

2017

LIST OF DRAWINGS

A. CENTRALIZE SYSTEM

NO.	DRAWING TITLE	DRAWING NUMBER
1.0	WATER SIDE	
1.1	PLANT ROOM	
1	TYPICAL DETAIL OF WATER COOLED CHILLER CONNECTION	CKM/STD/AC/PLANT/REV2017/01
2	TYPICAL SCREW TYPE WATER COOLED CHILLER PIPING CONNECTION DETAILS	CKM/STD/AC/PLANT/REV2017/02
3	TYPICAL CENTRIFUGAL TYPE WATER COOLED CHILLER PIPING CONNECTION DETAILS	CKM/STD/AC/PLANT/REV2017/03
4	TYPICAL AIR COOLED CHILLER PIPING CONNECTION DETAILS	CKM/STD/AC/PLANT/REV2017/04
5	TYPICAL PUMP INSTALLATION DETAILS	CKM/STD/AC/PLANT/REV2017/05
6	TYPICAL PUMP INSTALLATION DETAILS	CKM/STD/AC/PLANT/REV2017/06
7	TYPICAL PUMP INSTALLATION DETAILS	CKM/STD/AC/PLANT/REV2017/07
8	TYPICAL PUMP INSTALLATION DETAILS	CKM/STD/AC/PLANT/REV2017/08
9	PUMP AND MOTOR BASE	CKM/STD/AC/PLANT/REV2017/09
10	TYPICAL COOLING TOWER INSTALLATION	CKM/STD/AC/PLANT/REV2017/10
11	TYPICAL PIPE FITTING CONNECTION DETAILS FOR COOLING TOWER	CKM/STD/AC/PLANT/REV2017/11
12	COOLING TOWER CONNECTION DETAILS (WITH STANDBY UNIT)	CKM/STD/AC/PLANT/REV2017/12
13	COOLING TOWER CONNECTION DETAILS	CKM/STD/AC/PLANT/REV2017/13
14	DETAIL OF TYPICAL CONDENSER WATER MAKE-UP TANK	CKM/STD/AC/PLANT/REV2017/14
15	CHILLED WATER EXPANSION TANK	CKM/STD/AC/PLANT/REV2017/15
16	CONDENSER WATER TREATMENT – FULLY AUTOMATIC DOSING SYSTEM	CKM/STD/AC/PLANT/REV2017/16
17	TYPICAL NEOPRENE PADS	CKM/STD/AC/PLANT/REV2017/17
1.2	PIPE	
18	PIPE HANGERS FOR INSULATED PIPE (OUTSIDE MECHANICAL ROOM)	CKM/STD/AC/PIPE/REV2017/01
19	PIPE HANGERS FOR INSULATED PIPE (INSIDE MECHANICAL ROOM)	CKM/STD/AC/PIPE/REV2017/02
20	FLOOR MOUNTED PIPE SUPPORT (OUTSIDE MECHANICAL ROOM)	CKM/STD/AC/PIPE/REV2017/03
21	FLOOR MOUNTED PIPE SUPPORT (INSIDE MECHANICAL ROOM)	CKM/STD/AC/PIPE/REV2017/04
22	PIPE SADDLE WITH 'U'-BOLT	CKM/STD/AC/PIPE/REV2017/05
23	CROSS SECTION OF UNDERGROUND PIPES	CKM/STD/AC/PIPE/REV2017/06
24	UNDERGROUND PIPE INSULATION JOINT AND SUPPORT	CKM/STD/AC/PIPE/REV2017/07
25	DETAIL DRAWING PRE-INSULATION PIPE BURIED UNDERGROUND	CKM/STD/AC/PIPE/REV2017/08
26	DETAILS OF PIPES HANGER AND BRACKETS	CKM/STD/AC/PIPE/REV2017/09
27	DETAILS OF PIPES THROUGH WALLS AND FLOOR	CKM/STD/AC/PIPE/REV2017/10
28	DETAIL OF JOINT FOR CHILLED WATER PIPE AT INTERFACING LINE	CKM/STD/AC/PIPE/REV2017/11
29	TYPICAL CHILLED WATER VALVE INSULATION DETAILS	CKM/STD/AC/PIPE/REV2017/12
30	DETAIL OF CHILLED WATER PIPE FITTINGS INSTALLATION	CKM/STD/AC/PIPE/REV2017/13
31	PIPE RISER THROUGH FLOOR SLAB MOUNTING DETAILS	CKM/STD/AC/PIPE/REV2017/14
32	CONDENSATE DRAIN DETAIL	CKM/STD/AC/PIPE/REV2017/15
33	CONDENSATE DRAIN DETAIL	CKM/STD/AC/PIPE/REV2017/16
34	PIPE MECHANICAL JOINT COUPLING	CKM/STD/AC/PIPE/REV2017/17



JASA KEPADA RAKYAT

CAWANGAN KEJURUTERAAN MEKANIKAL

Ibu Pejabat JKR Malaysia

AIR CONDITIONING AND MECHANICAL VENTILATION SYSTEM

LIST OF DRAWINGS

DATE2017SCALEN.T.S

BILANGAN LUKSANCKM/STD/AC/LOD/REV2017/01

LIST OF DRAWINGS (CONT')

NO.	DRAWING TITLE	DRAWING NUMBER
2.0	AIR SIDE	
2.1	AIR HANDLING UNIT	
35	TYPICAL FCU CONNECTION USING 2 WAY VALVE	CKM/STD/AC/AHU/REV2017/01
36	TYPICAL FCU CONNECTION USING 3 WAY VALVE	CKM/STD/AC/AHU/REV2017/02
37	TYPICAL AHU CONNECTION USING 2 WAY VALVE	CKM/STD/AC/AHU/REV2017/03
38	TYPICAL AHU CONNECTION USING 3 WAY VALVE	CKM/STD/AC/AHU/REV2017/04
39	TYPICAL AHU INSTALLATION WITH MIXING BOX	CKM/STD/AC/AHU/REV2017/05
40	TYPICAL AHU INSTALLATION WITHOUT MIXING BOX	CKM/STD/AC/AHU/REV2017/06
41	DETAIL OF AHU ROOM INSULATION	CKM/STD/AC/AHU/REV2017/07
42	FIRE DAMPER INSTALLATION DETAIL	CKM/STD/AC/AHU/REV2017/08
43	MOTORISED FIRE DAMPER DETAIL	CKM/STD/AC/AHU/REV2017/09
44	DETAILS OF CONDENSATE DRAIN	CKM/STD/AC/AHU/REV2017/10
2.2	DUCTING	
45	DUCT CONSTRUCTION DETAIL	CKM/STD/AC/DUCT/REV2017/01
46	DUCT CONSTRUCTION DETAIL	CKM/STD/AC/DUCT/REV2017/02
47	DUCT CONSTRUCTION DETAIL	CKM/STD/AC/DUCT/REV2017/03
48	VANES	CKM/STD/AC/DUCT/REV2017/04
49	GENERAL LAYOUT OF DUCT CONSTRUCTION	CKM/STD/AC/DUCT/REV2017/05
50	DUCT SUPPORT AND BRACKET DETAIL	CKM/STD/AC/DUCT/REV2017/06
51	TDC JOINT & REINFORCEMENT	CKM/STD/AC/DUCT/REV2017/07
52	DUCT JOINT DETAIL	CKM/STD/AC/DUCT/REV2017/08
53	DUCT CONSTRUCTION DETAIL	CKM/STD/AC/DUCT/REV2017/09
54	DUCT CONSTRUCTION DETAIL	CKM/STD/AC/DUCT/REV2017/10
55	INTERNAL DUCT INSULATION WITH POLYURETHANE (PU)	CKM/STD/AC/DUCT/REV2017/11
56	INTERNAL DUCT INSULATION WITH FIBREGLOSS MATERIAL	CKM/STD/AC/DUCT/REV2017/12
57	INTERNAL DUCT INSULATION WITH CLOSED CELL NITRILE RUBBER MATERIAL	CKM/STD/AC/DUCT/REV2017/13
58	TYPICAL DUCT INSULATION WITH POLYETHYLENE (PE) MATERIAL	CKM/STD/AC/DUCT/REV2017/14
59	DUCT SUPPORT DETAIL (OUTSIDE MECHANICAL ROOM)	CKM/STD/AC/DUCT/REV2017/15
60	DUCT SUPPORT DETAIL (INSIDE MECHANICAL ROOM)	CKM/STD/AC/DUCT/REV2017/16
61	DUCT SUPPORT DETAIL (UNDER THE ROOF)	CKM/STD/AC/DUCT/REV2017/17
62	DUCT SUPPORT DETAIL (UNDER THE ROOF)	CKM/STD/AC/DUCT/REV2017/18
63	DUCT SUPPORT AND BRACKET DETAIL	CKM/STD/AC/DUCT/REV2017/19
64	DUCT CONNECTION DETAIL FOR FAN COIL UNIT (FCU)	CKM/STD/AC/DUCT/REV2017/20
65	FLEXIBLE CONNECTION FOR RECTANGULAR (FAN OUTLET/INLET)	CKM/STD/AC/DUCT/REV2017/21
66	DETAIL OF VENTILATION SYSTEM INSTALLATION	CKM/STD/AC/DUCT/REV2017/22
67	DETAIL OF VENTILATION SYSTEM INSTALLATION	CKM/STD/AC/DUCT/REV2017/23
68	DUCT PENETRATION DETAIL	CKM/STD/AC/DUCT/REV2017/24



JASA KEPADA RAKYAT

CAWANGAN KEJURUTERAAN MEKANIKAL

Ibu Pejabat JKR Malaysia

AIR CONDITIONING AND MECHANICAL VENTILATION SYSTEM

LIST OF DRAWINGS

DATE2017SCALEN.T.S

BILANGAN LUKSANCKM/STD/AC/LOD/REV2017/02

LIST OF DRAWINGS (CONT')

NO.	DRAWING TITLE	DRAWING NUMBER
	DUCTING (CONT')	
69	DUCT SUPPORT & BRACKET DETAIL	CKM/STD/AC/DUCT/REV2017/25
70	DUCT SUPPORT & BRACKET DETAIL	CKM/STD/AC/DUCT/REV2017/26
71	SPLITTER DAMPER DETAIL	CKM/STD/AC/DUCT/REV2017/27
72	DUCTWORK ACCESS PANELS	CKM/STD/AC/DUCT/REV2017/28
73	SQUARE SWIRL DIFFUSER DETAIL	CKM/STD/AC/DUCT/REV2017/29
74	SQUARE DIFFUSER DETAIL	CKM/STD/AC/DUCT/REV2017/30
75	TYPICAL DETAIL OF SQUARE DIFFUSER CONNECTION WITHOUT PLENNUM BOX	CKM/STD/AC/DUCT/REV2017/31
76	TYPICAL DETAIL OF SQUARE DIFFUSER CONNECTION WITH PLENNUM BOX	CKM/STD/AC/DUCT/REV2017/32
77	TYPICAL DETAIL OF SQUARE DIFFUSER CONNECTION WITHOUT PLENNUM BOX (UNDER THE ROOF)	CKM/STD/AC/DUCT/REV2017/33
78	TYPICAL DETAIL OF SQUARE DIFFUSER CONNECTION WITH PLENNUM BOX (UNDER THE ROOF)	CKM/STD/AC/DUCT/REV2017/34
79	INSTALLATION OF SMOKE DETECTOR INSIDE DUCTING	CKM/STD/AC/DUCT/REV2017/35

B. UNITARY SYSTEM

NO.	DRAWING TITLE	DRAWING NUMBER
1.0	AIR COOLED SPLIT UNIT	
80	REFRIGERANT PIPING SCHEMATIC AND CONTROL DIAGRAM	CKM/STD/AC/SPLIT UNIT/REV2017/01
81	INSTALLATION OF SPLIT UNIT	CKM/STD/AC/SPLIT UNIT/REV2017/02
82	INSTALLATION OF SPLIT UNIT	CKM/STD/AC/SPLIT UNIT/REV2017/03
83	INSTALLATION OF SPLIT UNIT	CKM/STD/AC/SPLIT UNIT/REV2017/04
84	REFRIGERANT PIPE INSTALLATION CONCEALED IN BRICK WALL	CKM/STD/AC/SPLIT UNIT/REV2017/05
85	REFRIGERANT PIPE INSTALLATION USING GI TRUNKING	CKM/STD/AC/SPLIT UNIT/REV2017/06
86	INSTALLATION OF CENTRALISED DRAIN PIPE	CKM/STD/AC/SPLIT UNIT/REV2017/07



JASA KEPADA RAKYAT

CAWANGAN KEJURUTERAAN MEKANIKAL

Ibu Pejabat JKR Malaysia

AIR CONDITIONING AND MECHANICAL VENTILATION SYSTEM


LIST OF DRAWINGS

DATE	SCALE
2017	N.T.S

BILANGAN LUKSAN

CKM/STD/AC/LOD/REV2017/03

PLANT ROOM

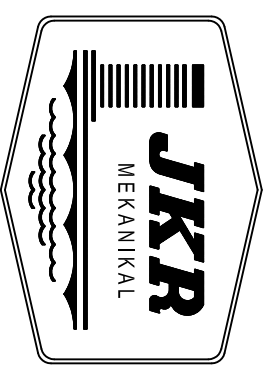


JASA KEPADA RAKYAT

NOTE:

LEGEND

- GATE VALVE
- MOTORIZED VALVE
- FLOW METER
- FLOW SWITCH
- FLEXIBLE COUPLING
- TEMPERATURE SENSOR (LINK TO BAS IF APPLICABLE)
- TEMPERATURE GAUGE
- HEAVY DUTY PRESSURE GAUGE C/W BALL VALVE
- ECCENTRIC REDUCER
- BALANCING VALVE
- DIFFERENTIAL PRESSURE FLOW SWITCH

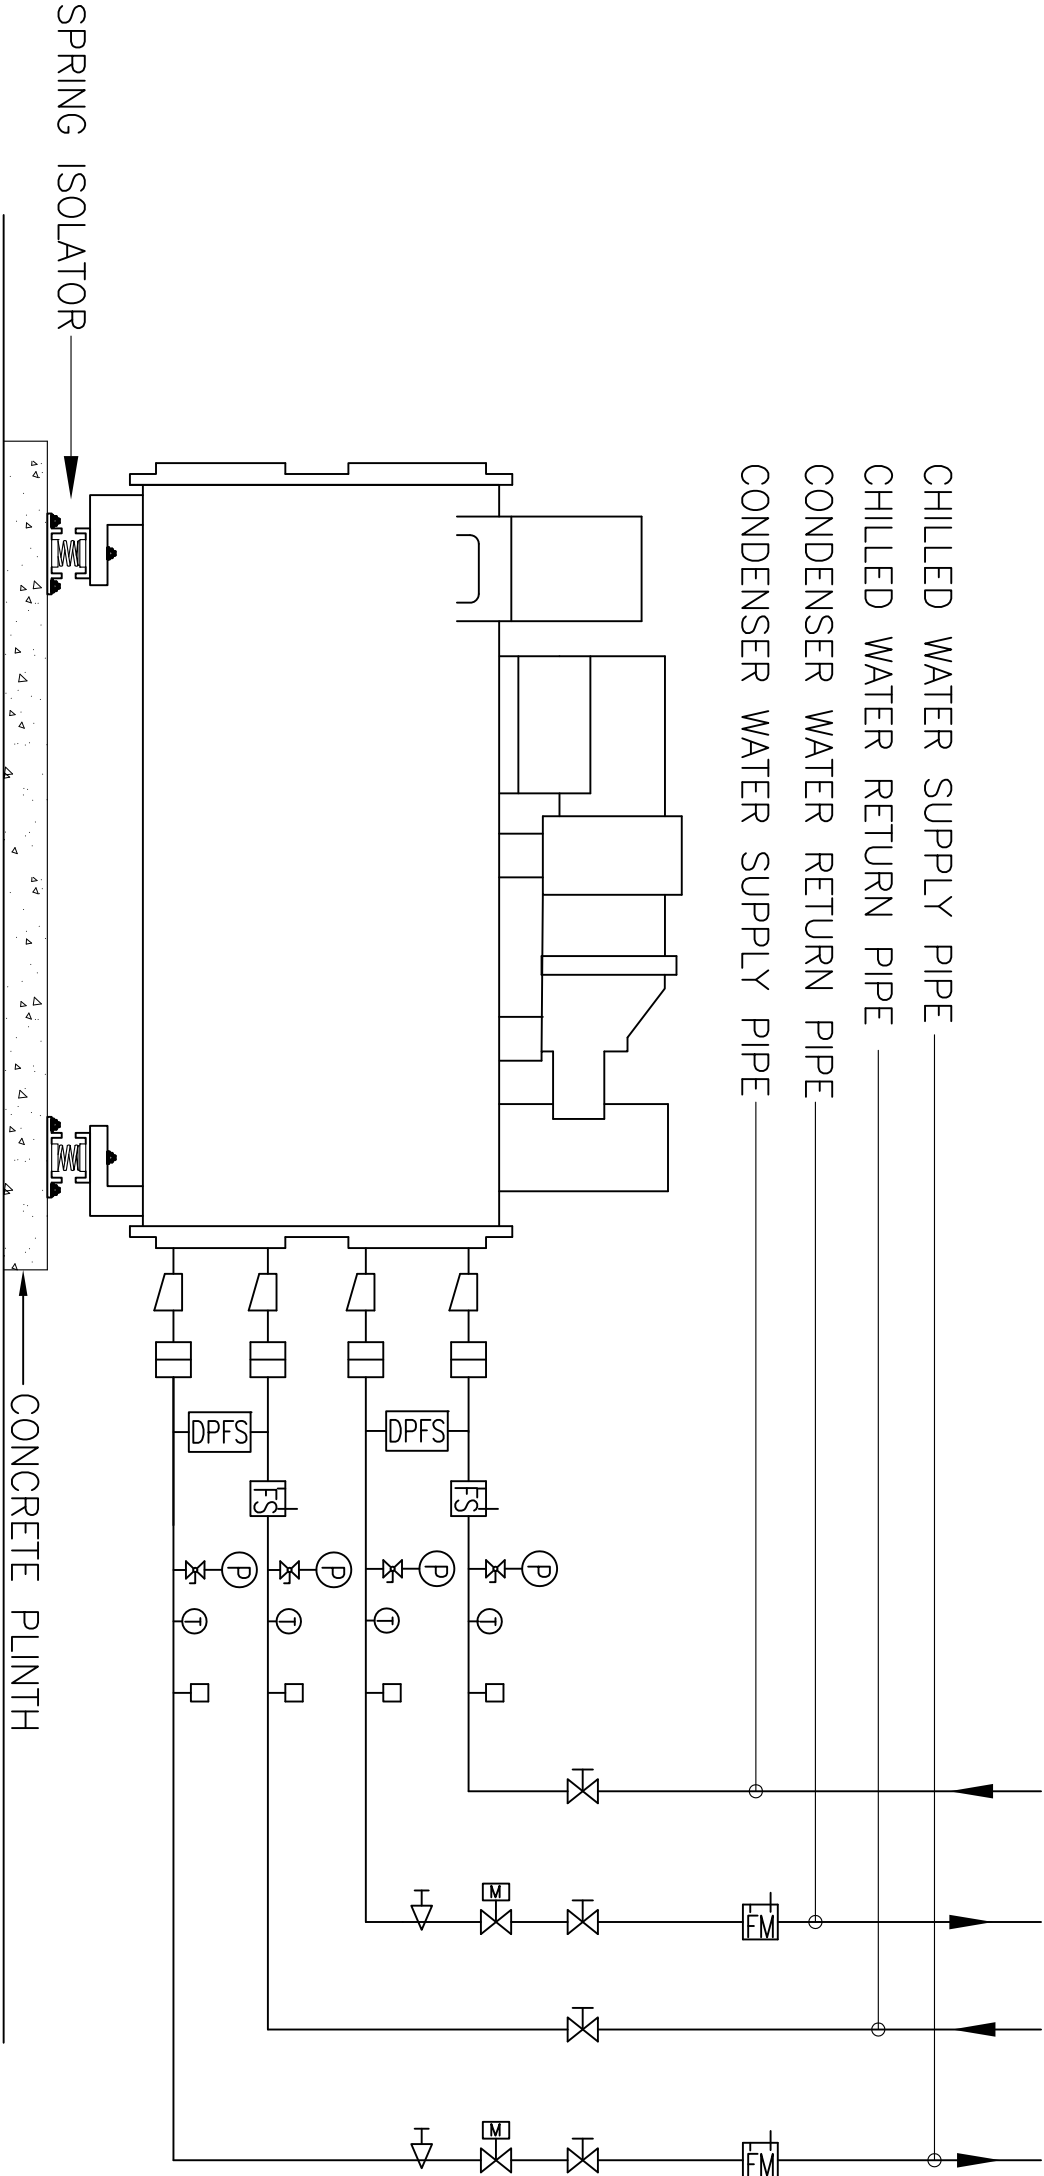

TYPICAL SCHEMATIC DETAIL OF WATER COOLED CHILLER CONNECTION



JASA KEPADA RAKYAT
CAWANGAN KEJURUTERAAN MEKANIKAL
Ibu Pejabat JKR Malaysia

AIR CONDITIONING SYSTEM

TYPICAL DETAIL OF WATER COOLED
CHILLER CONNECTION


DATE 2017 SCALE N.T.S

DRAWING NUMBER CKM/STD/AC/PLANT/REV/2017/01

NOTE:

LEGEND

-  GATE VALVE
-  MOTORIZED VALVE
-  BUTTERFLY VALVE
- CWR CONDENSER WATER RETURN
- CWS CONDENSER WATER SUPPLY

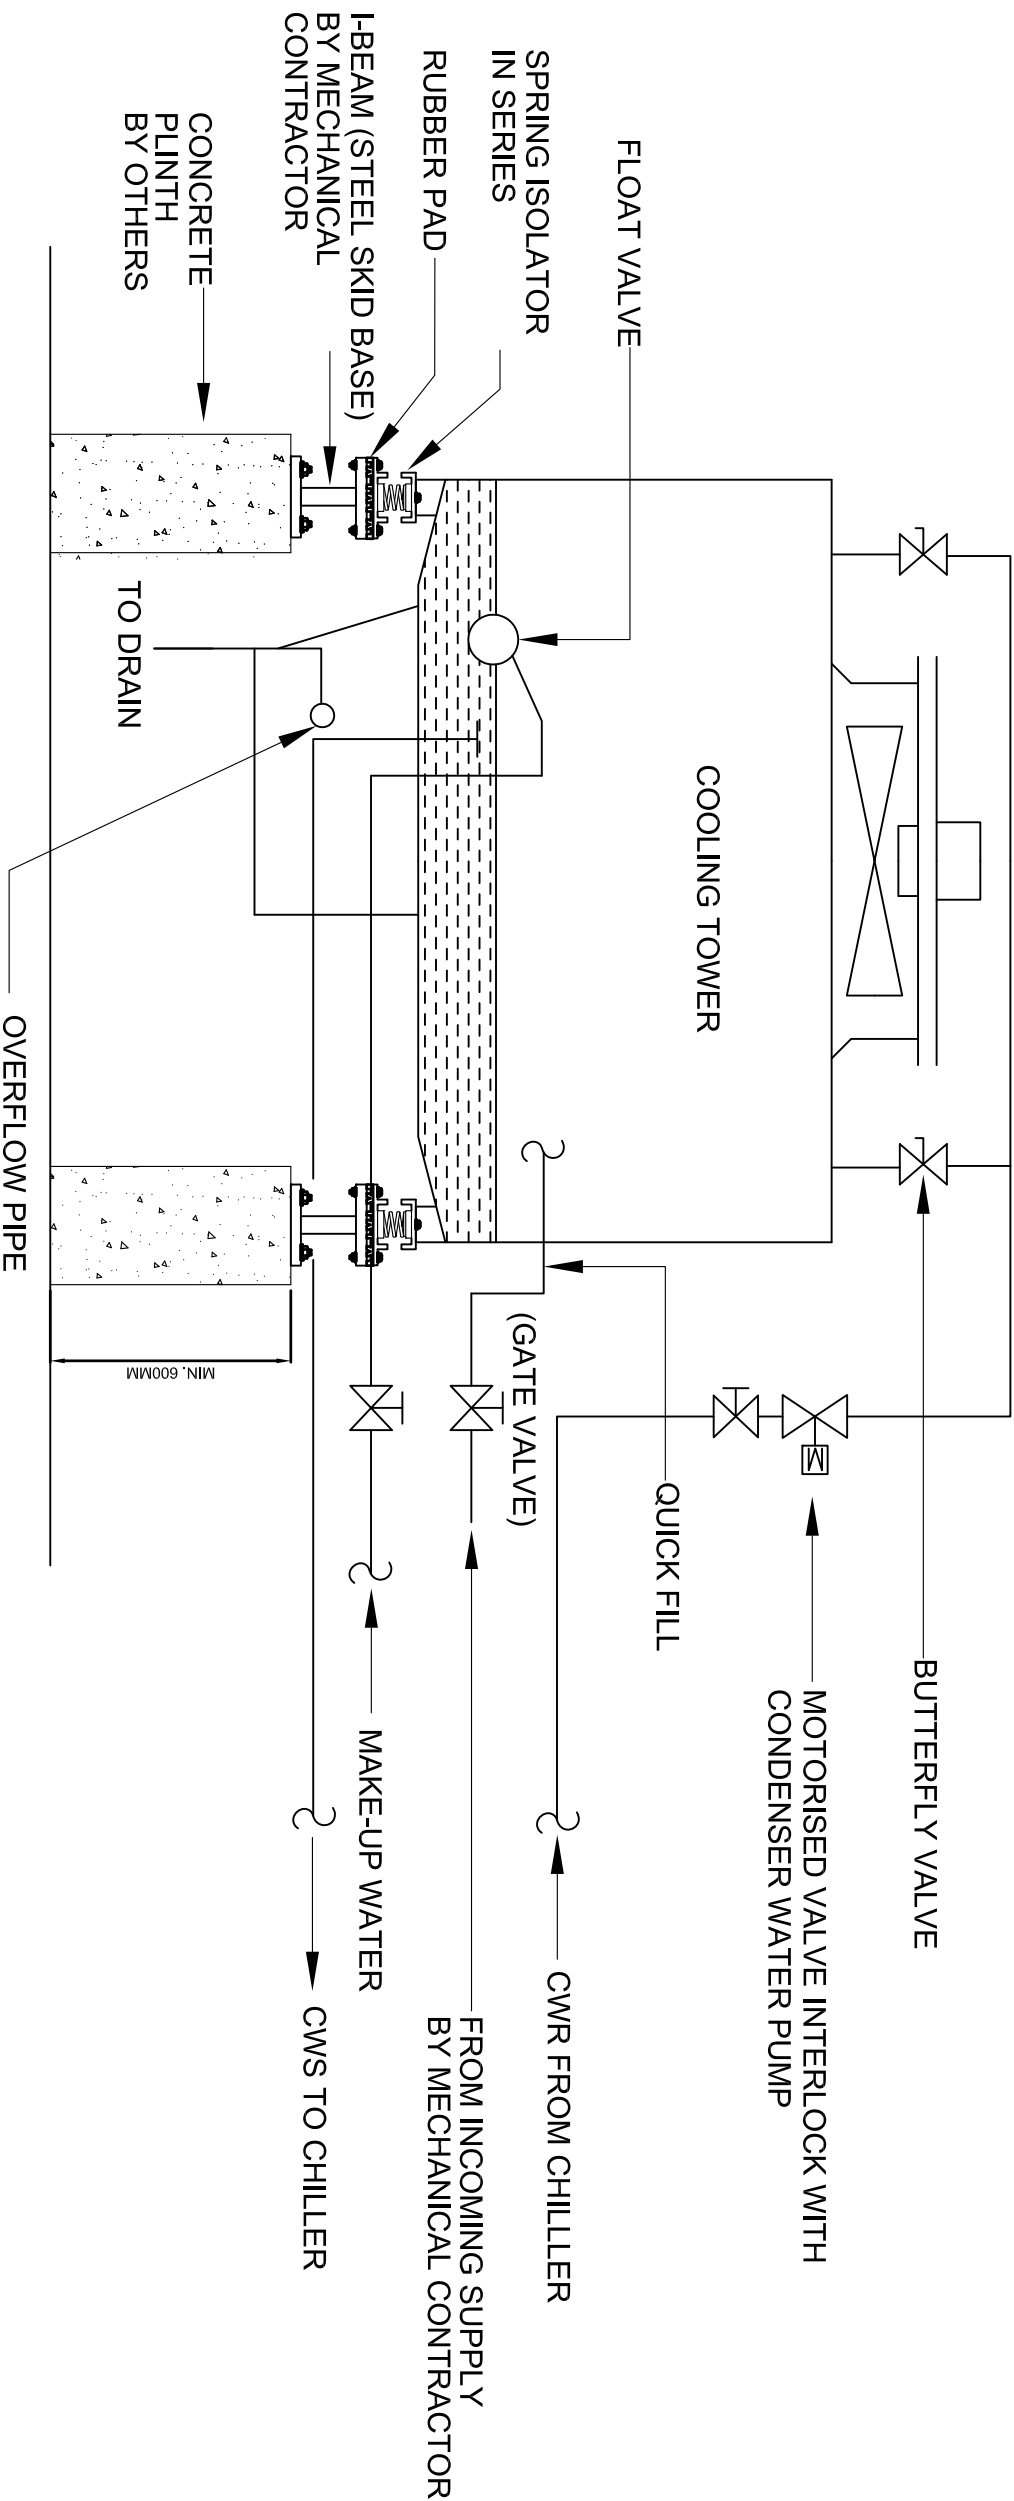

TYPICAL COOLING TOWER INSTALLATION



JASA KEPADA RAKYAT
CAWANGAN KEJURUTERAAN MEKANIKAL
Ibu Pejabat JKR Malaysia


AIR CONDITIONING SYSTEM
TYPICAL COOLING TOWER
INSTALLATION

DATE	SCALE	N.T.S
2017		
DRAWING NUMBER		
CKM/STD/AC/PLANT/REV/2017/10		

NOTE:

LEGEND

- GATE VALVE
- MOTORIZED VALVE
- BUTTERFLY VALVE
- FLEXIBLE CONNECTOR
- TEMPERATURE GAUGE

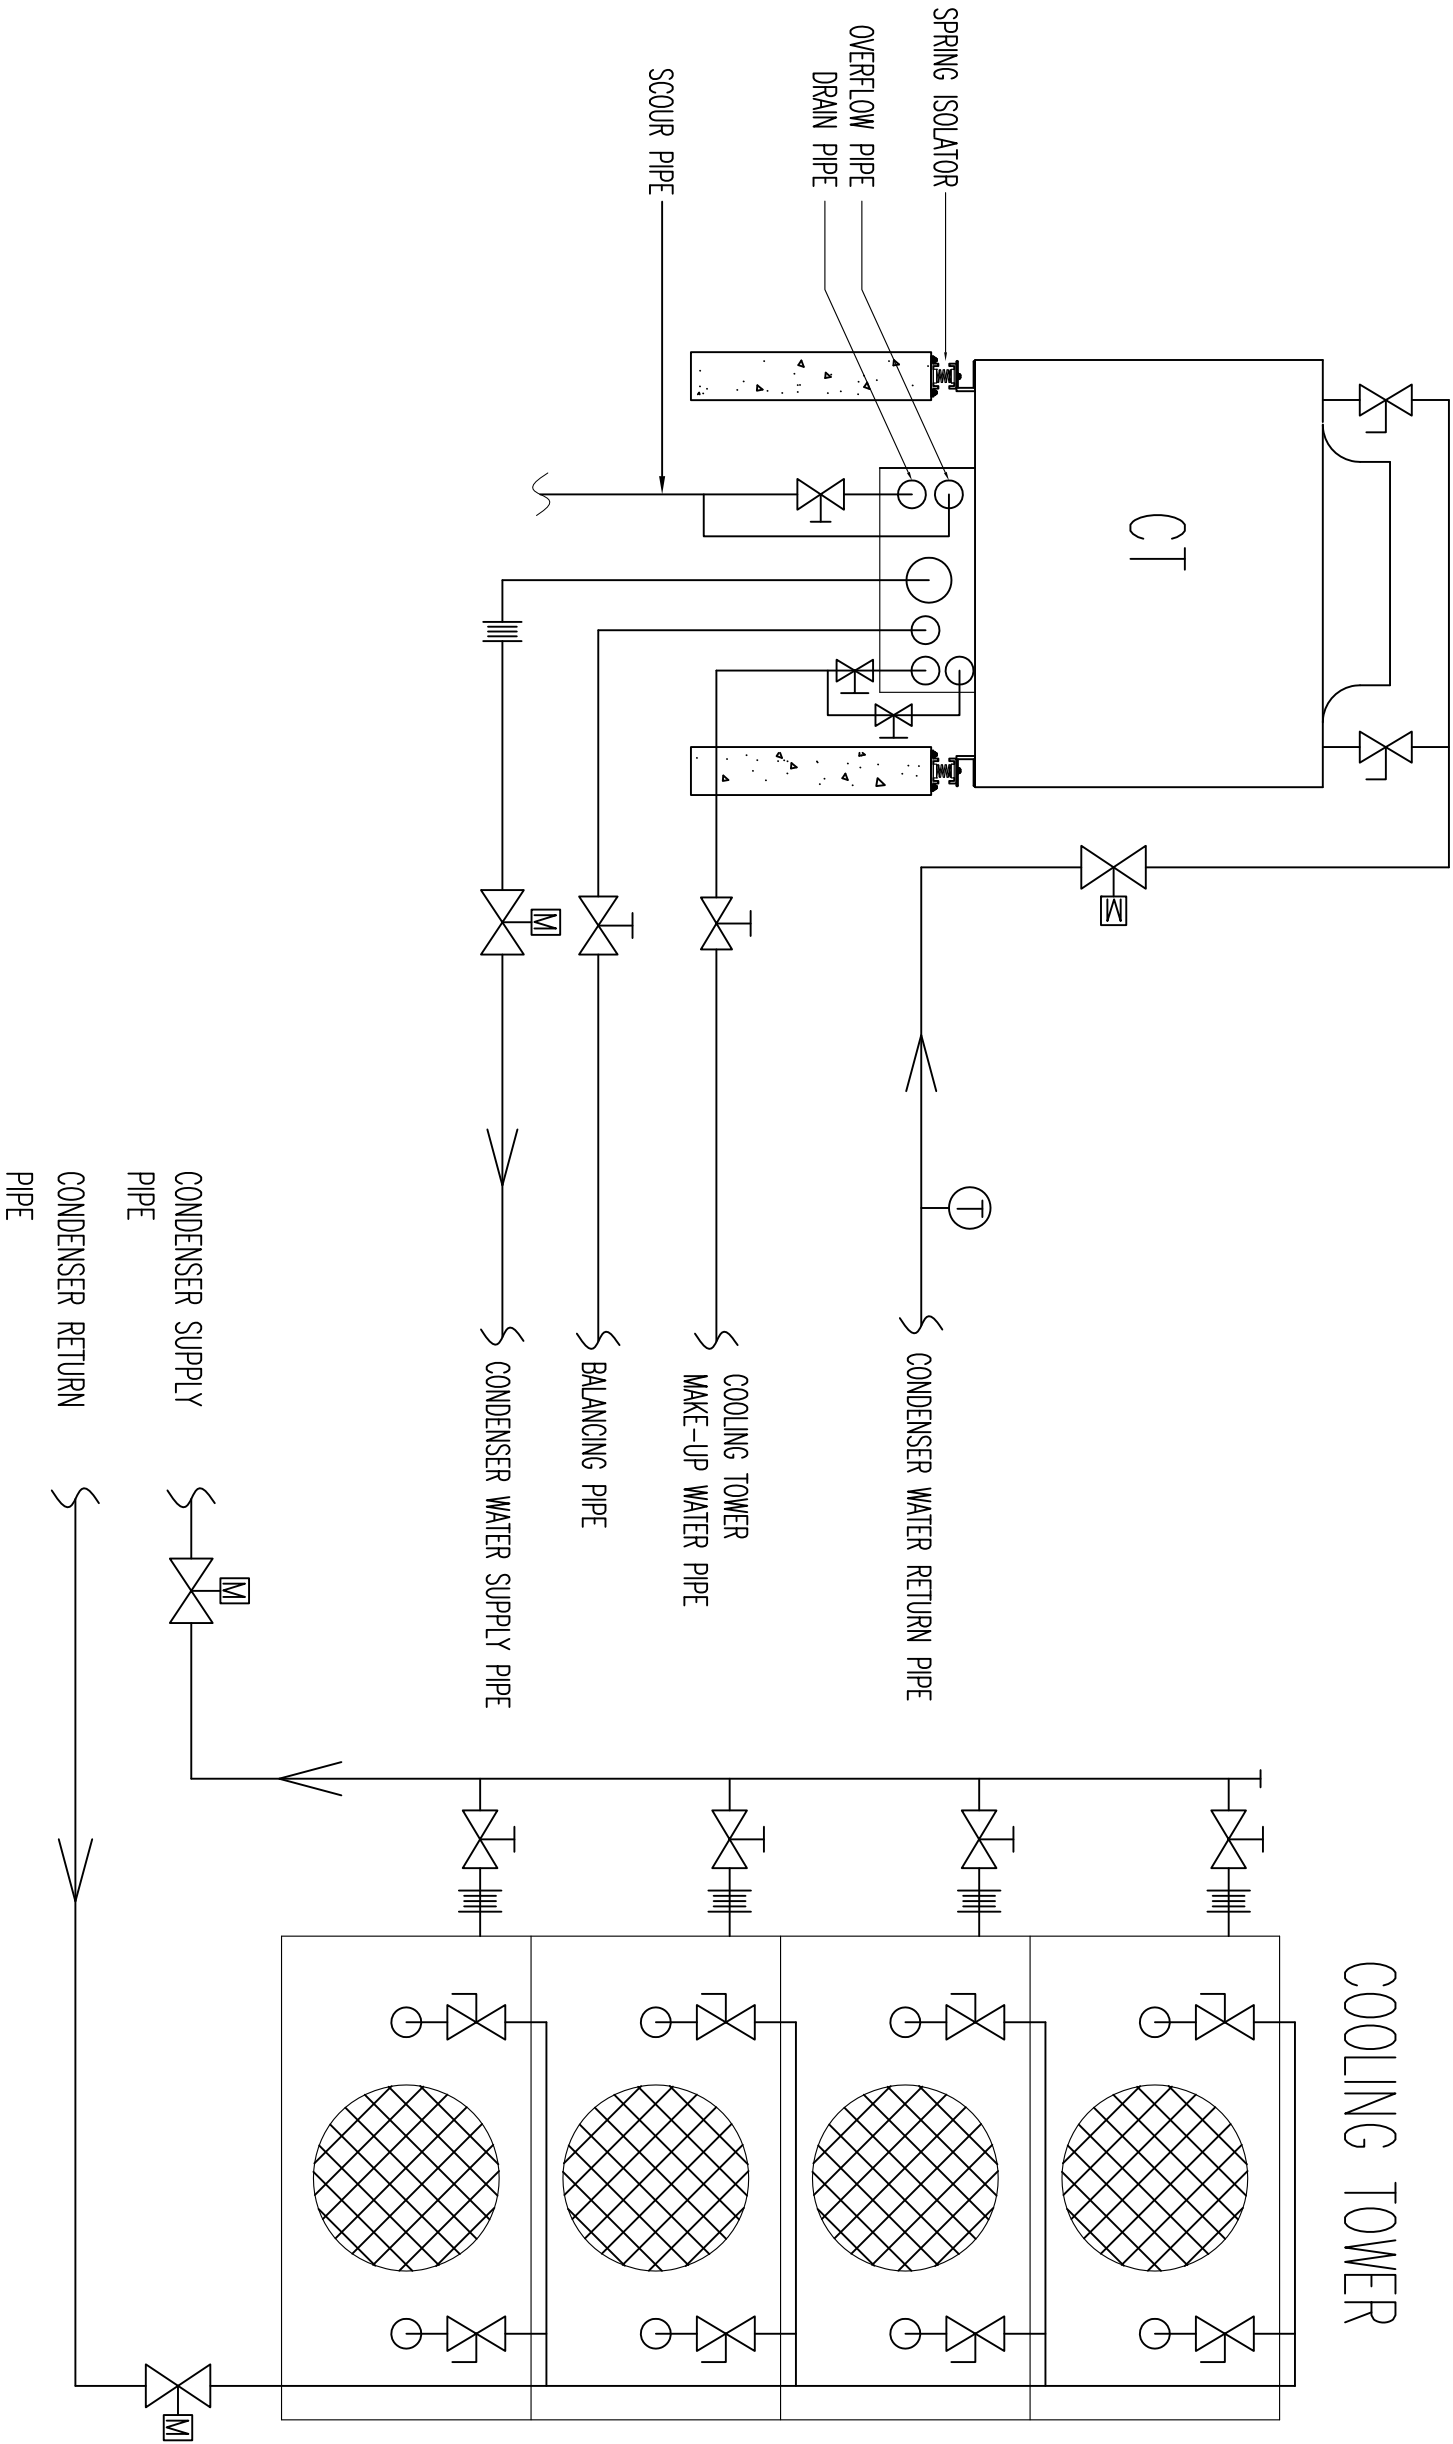

TYPICAL PIPE FITTING CONNECTION DETAILS

FOR COOLING TOWER

AIR CONDITIONING SYSTEM

TYPICAL PIPE FITTING CONNECTION DETAILS
FOR COOLING TOWER

DATE 2017 SCALE N.T.S


DRAWING NUMBER

CKM/STD/AC/PLANT/REV/2017/11



JASA KEPADA RAKYAT

CAWANGAN KEJURUTERAAN MEKANIKAL
Ibu Pejabat JKR Malaysia

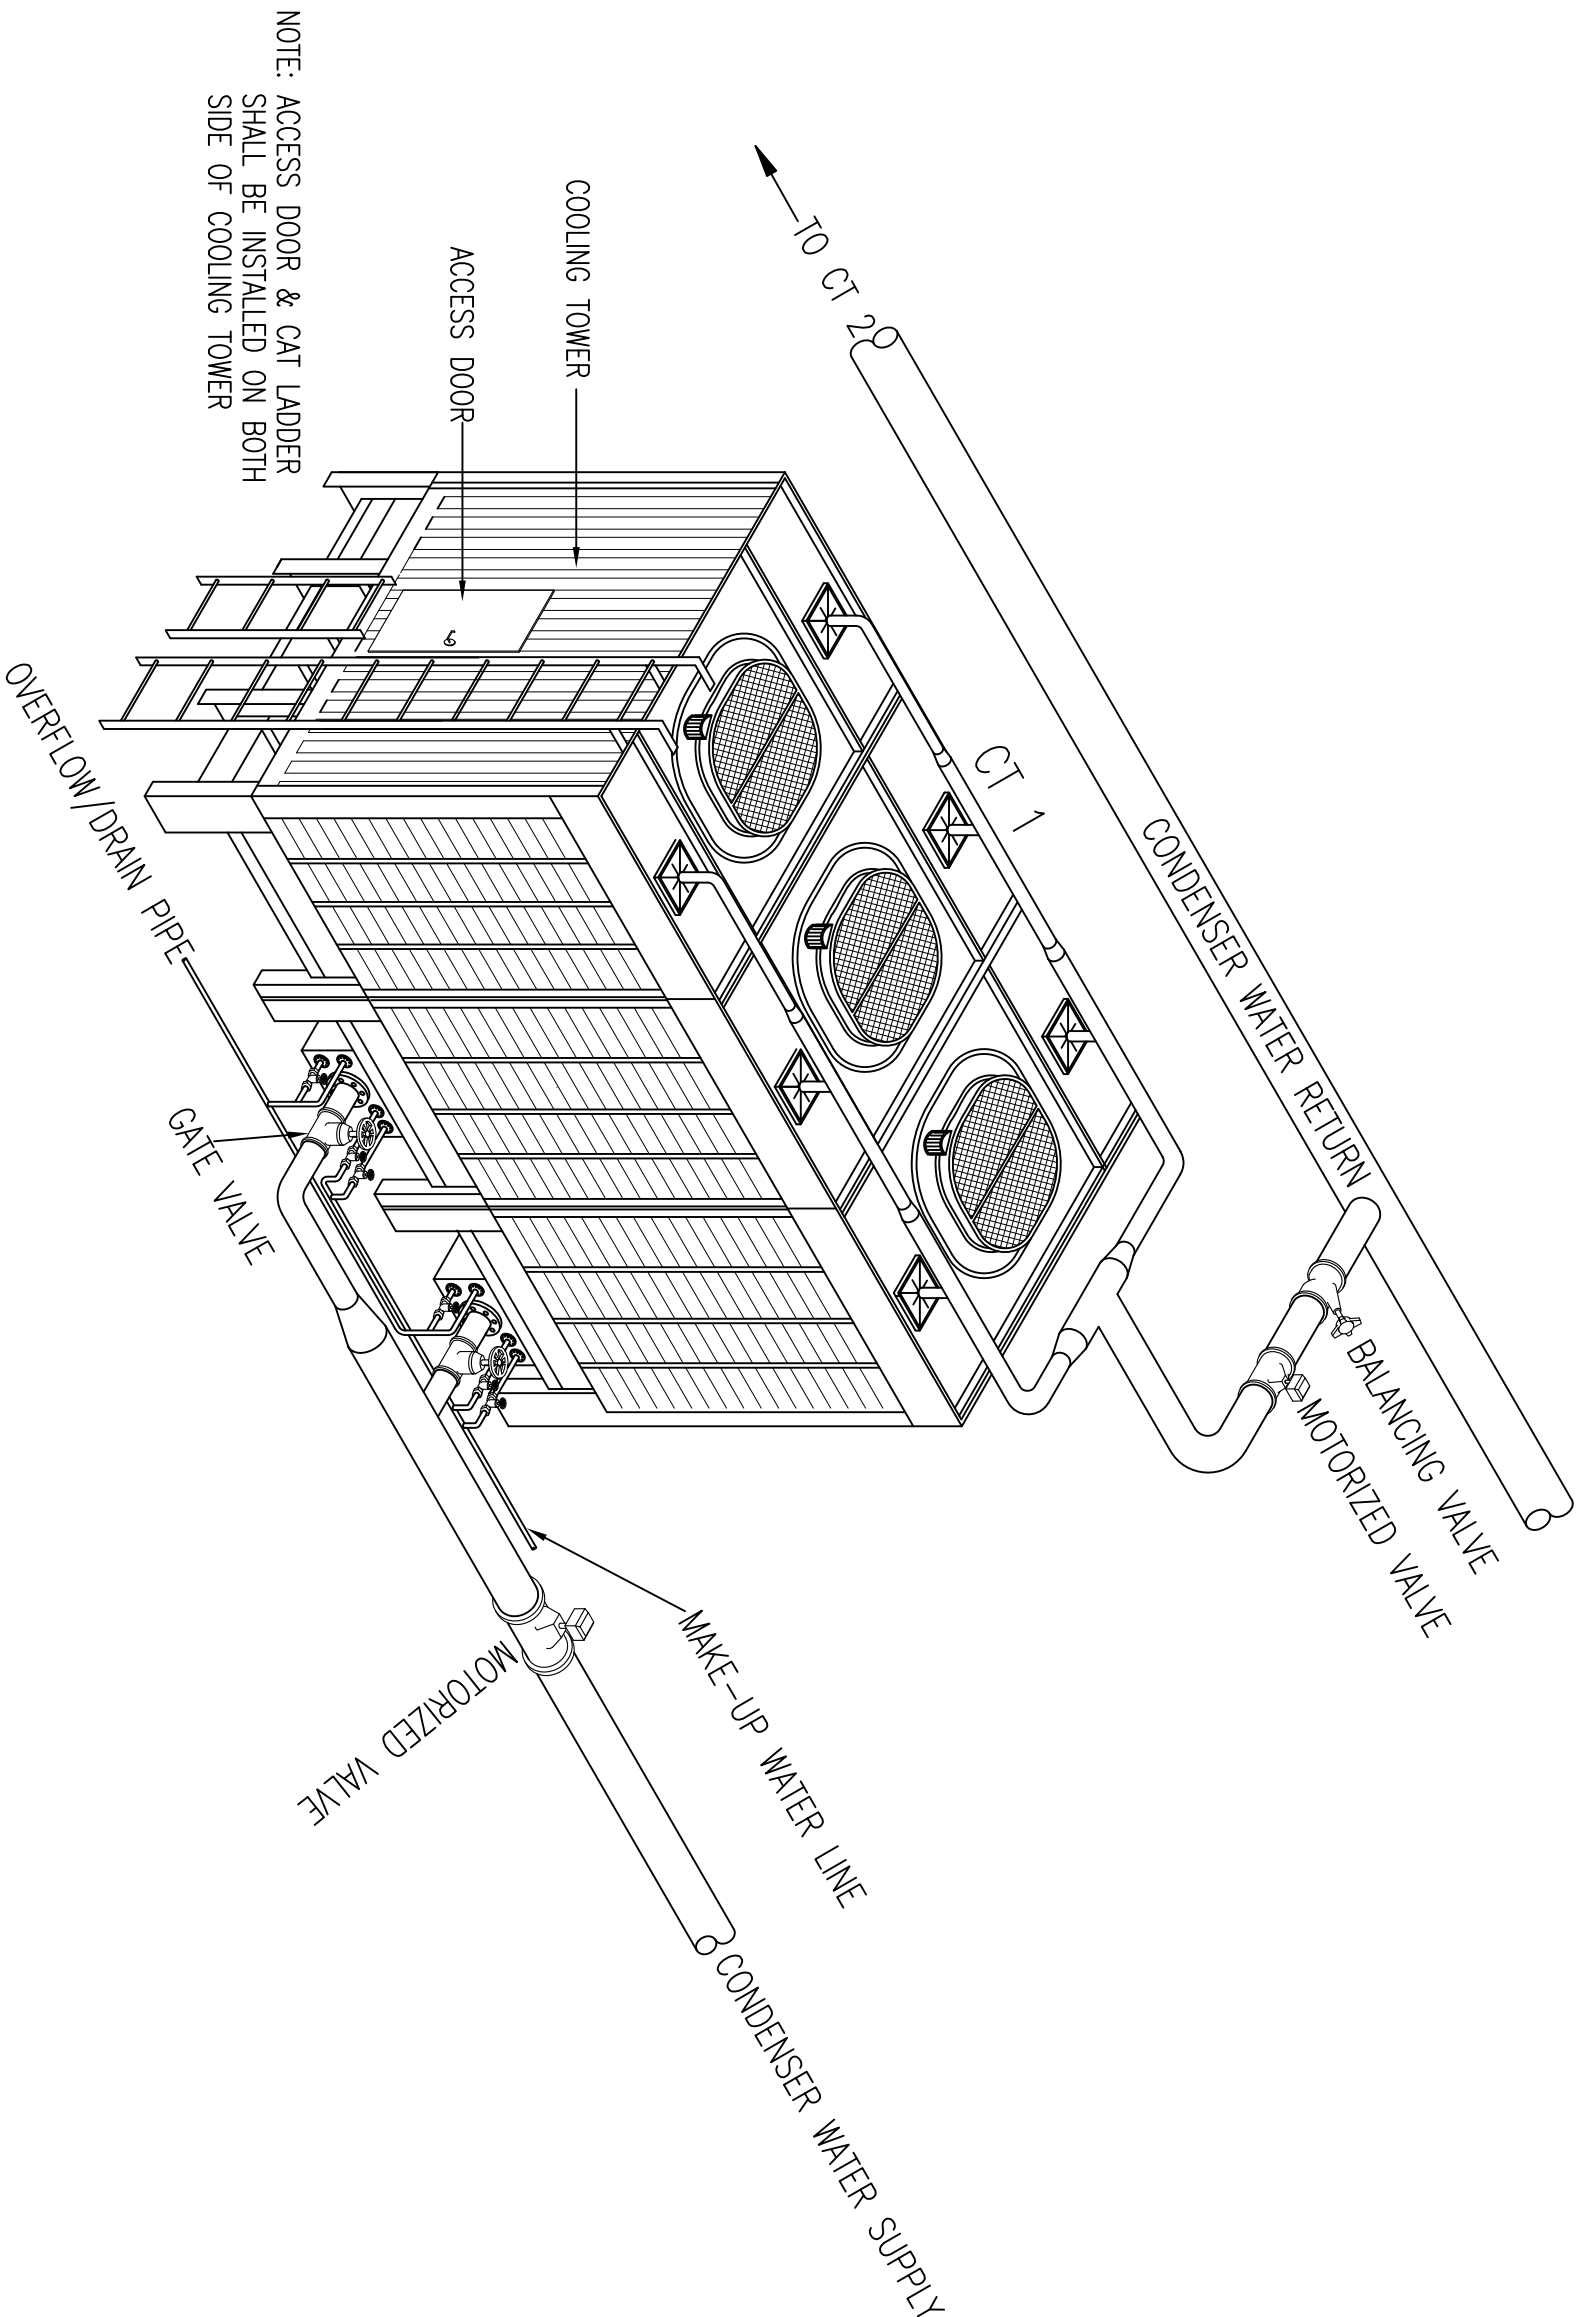

COOLING TOWER CONNECTION DETAILS (WITH STANDBY UNIT)


NOTE:



JASA KEPADA RAKYAT
CAWANGAN KEJURUTERAAN MEKANIKAL
Ibu Pejabat JKR Malaysia

AIR CONDITIONING SYSTEM
COOLING TOWER CONNECTION
DETAILS (THREE CELL)

DATE	SCALE	N.T.S
2017		
DRAWING NUMBER		
CKM/STD/AC/PLANT/REV/2017/12		

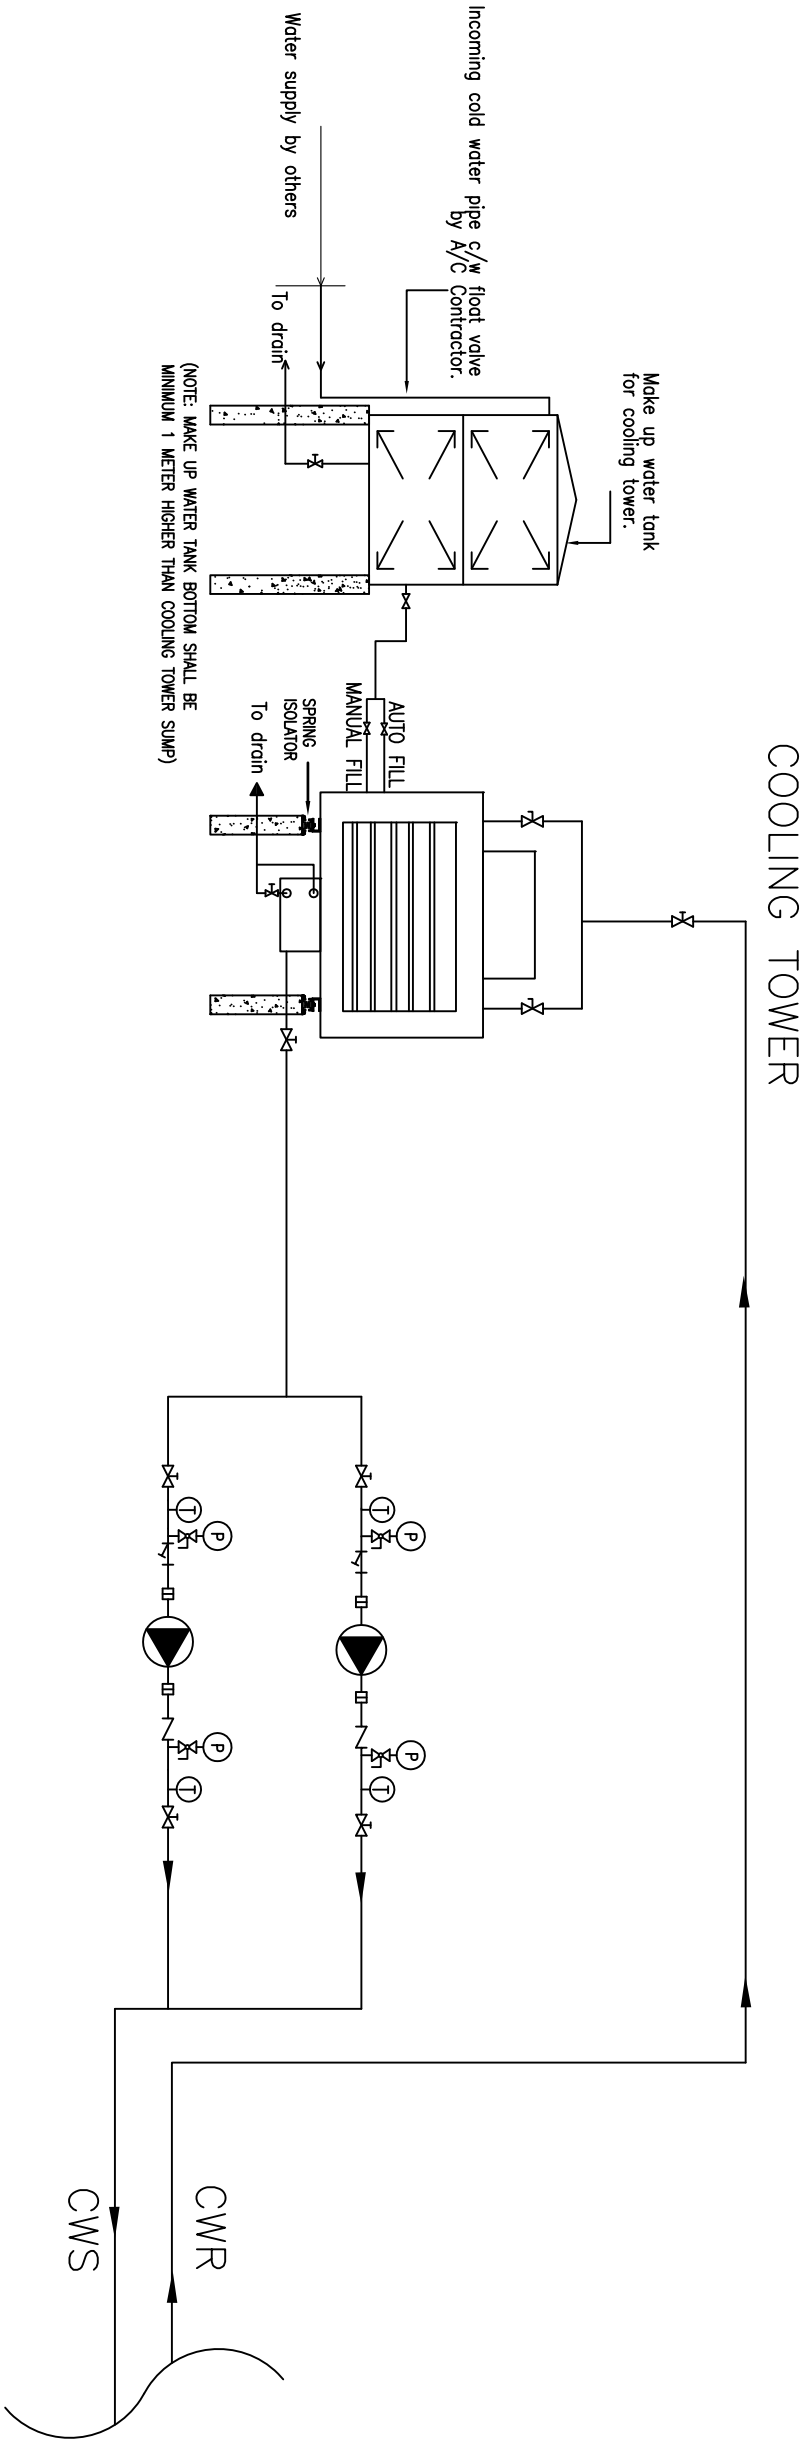

NOTE:

LEGEND

- GATE VALVE
- BUTTERFLY VALVE
- CHECK VALVE
- FLEXIBLE COUPLING
- HEAVY DUTY PRESSURE GAUGE CW BALL VALVE
- STRAINER
- TEMPERATURE GAUGE
- CONDENSER WATER RETURN
- CONDENSER WATER SUPPLY



CAWANGAN KEJURUTERAAN MEKANIKAL
Ibu Pejabat JKR Malaysia

AIR CONDITIONING SYSTEM

COOLING TOWER CONNECTION DETAILS

DATE 2017 SCALE N.T.S

DRAWING NUMBER


CKM/STD/AC/PLANT/REV/2017/13

NOTE:

LEGEND




GATE VALVE

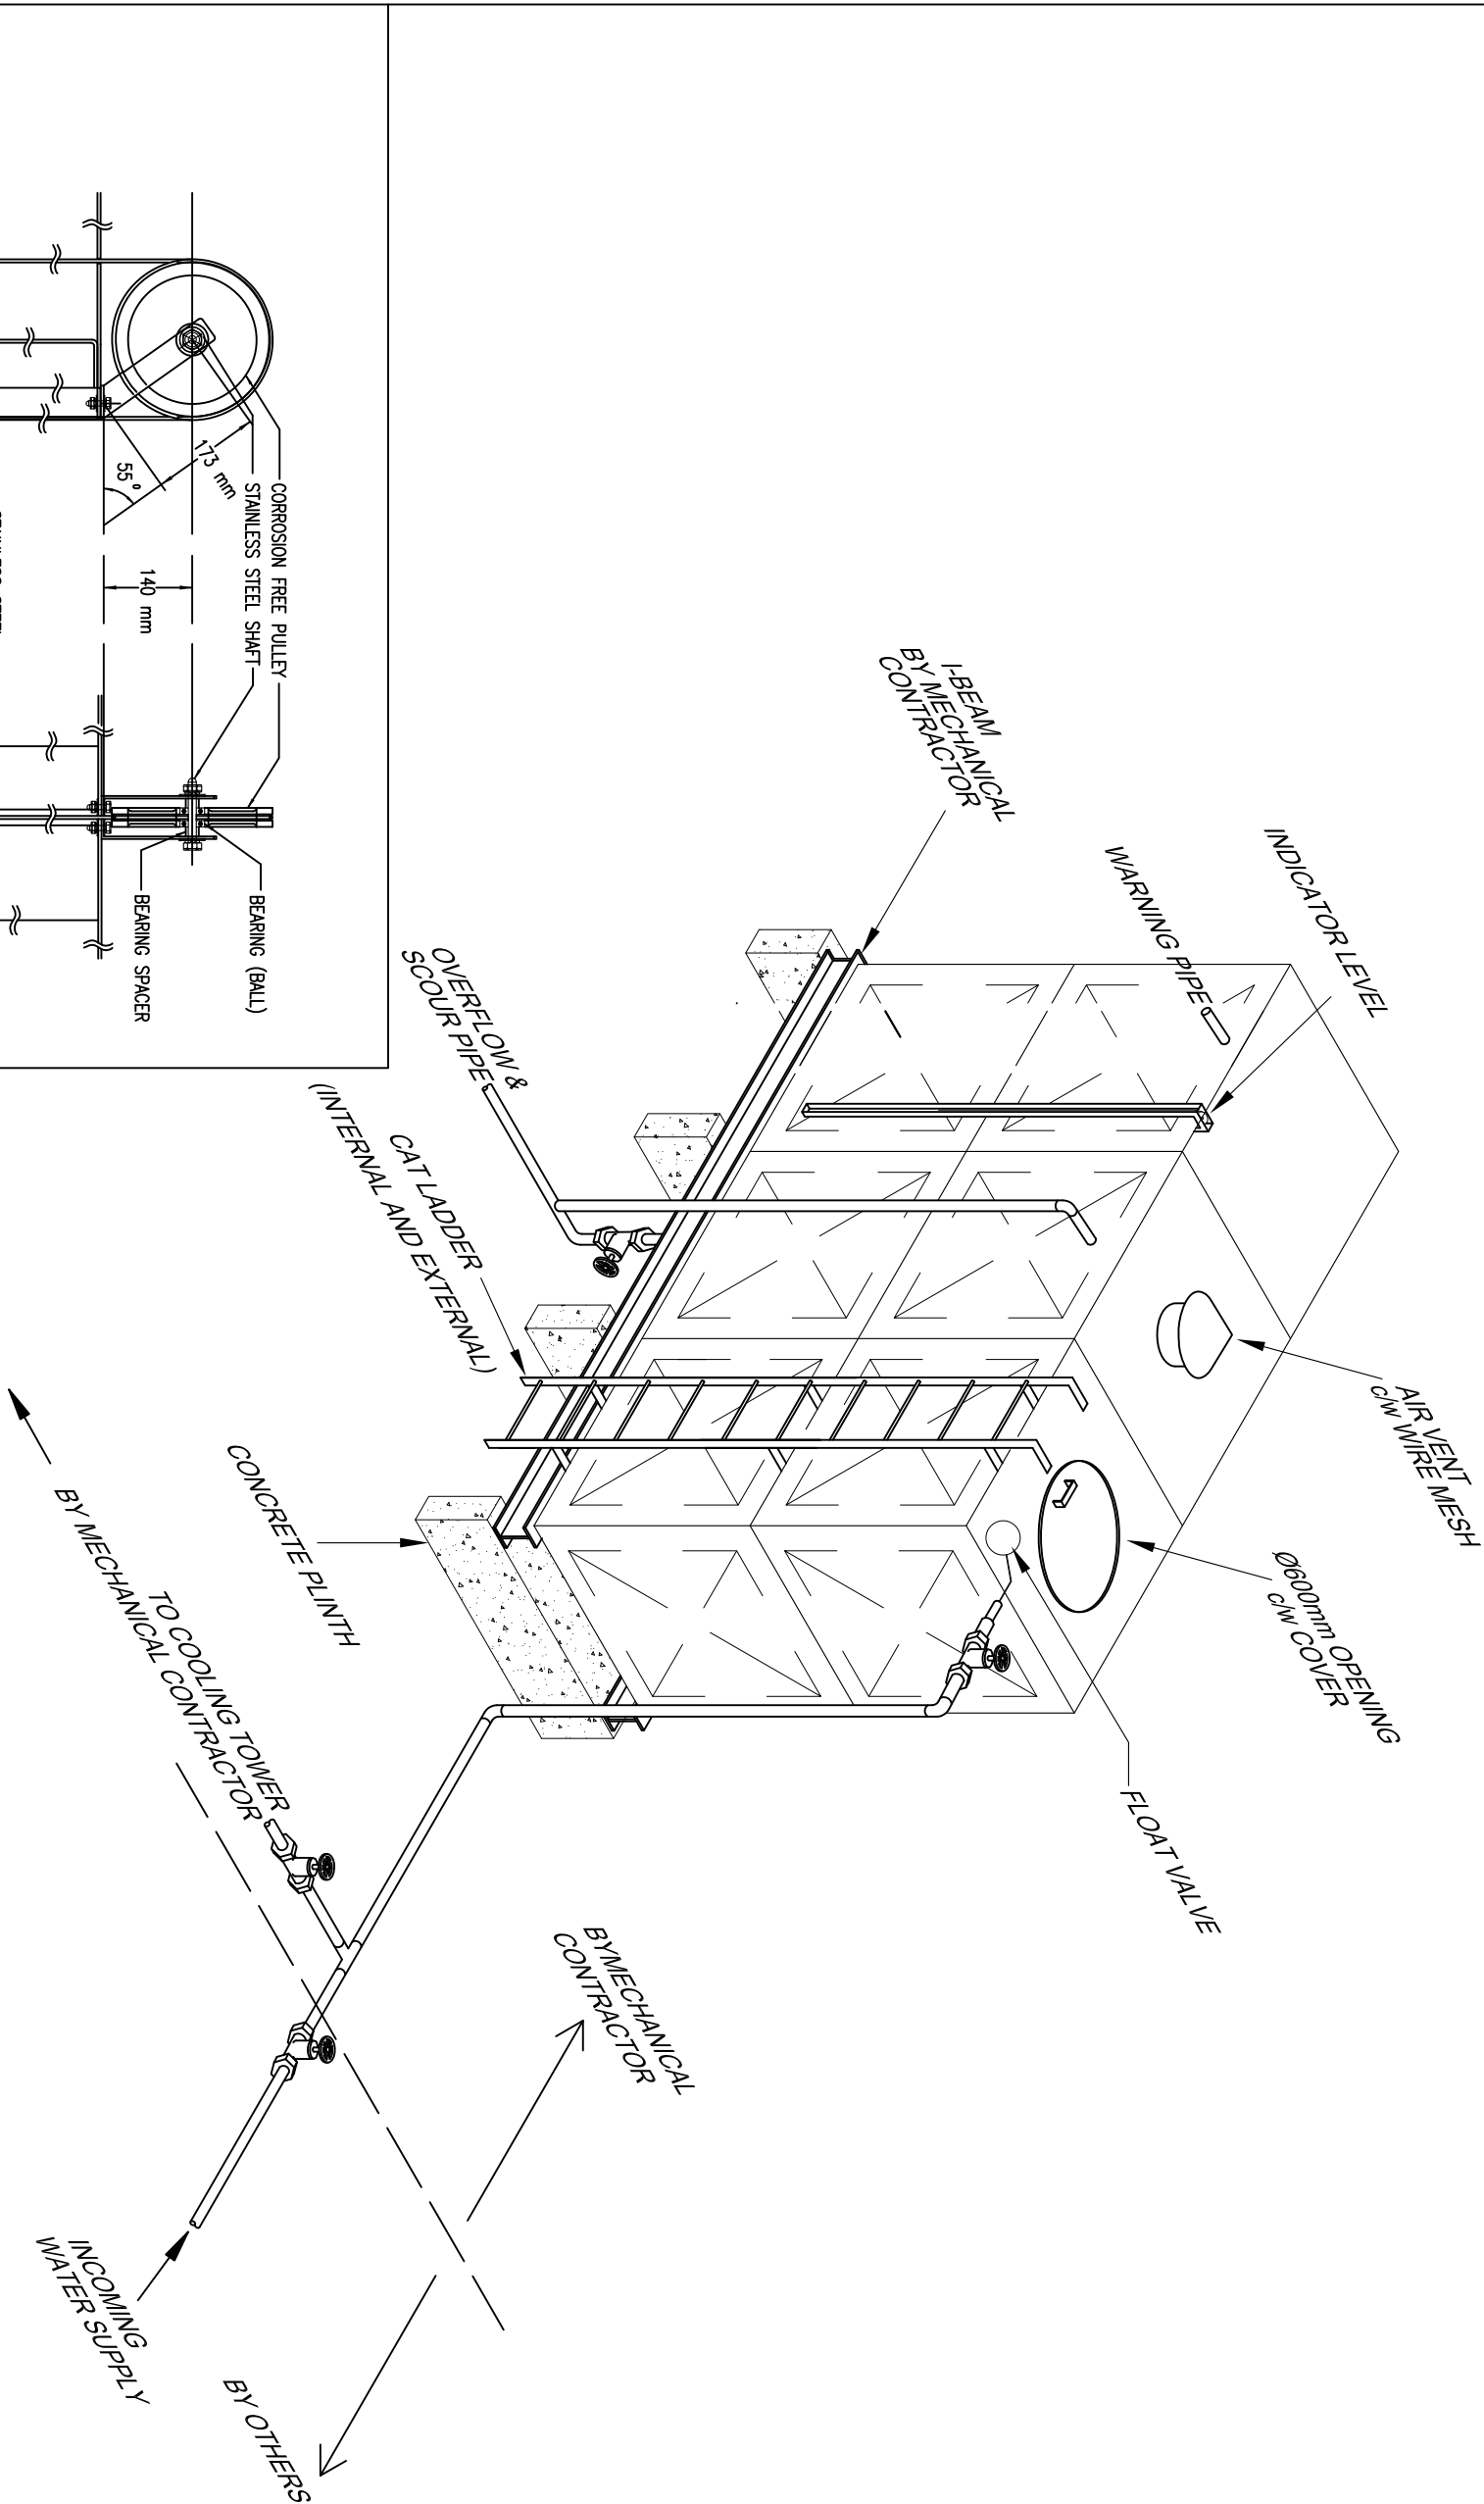

DETAIL OF TYPICAL CONDENSER WATER MAKE-UP TANK

DETAIL OF INDICATOR LEVEL

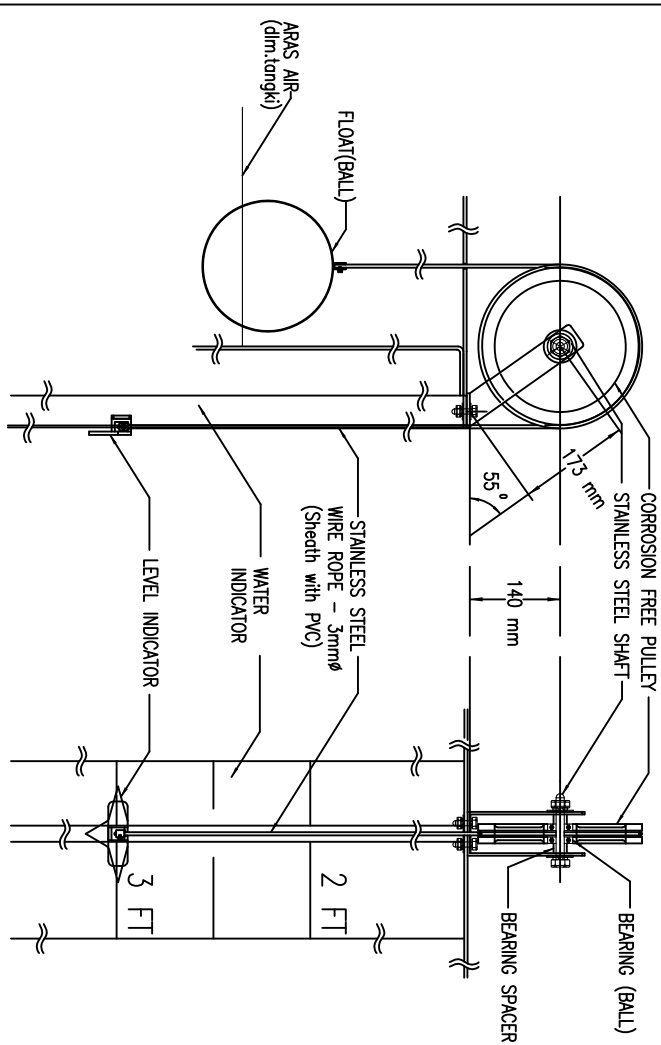

JASA KEPADA RAKYAT

CAWANGAN KEJURUTERAAN MEKANIKAL
Ibu Pejabat JKR Malaysia

AIR CONDITIONING SYSTEM

DETAIL OF TYPICAL CONDENSER
WATER MAKE-UP TANK

DATE

2017

SCALE

N.T.S

DRAWING NUMBER

CKM/STD/AC/PLANT/REV2017/14

 
NOTE:



AIR CONDITIONING SYSTEM


CHILLED WATER EXPANSION TANK

Pejabat JKR Malaysia



DATE	2017	SCALE	N.T.S
DRAWING NUMBER			

CKM/STD/AC/PLANT/REV2017/15

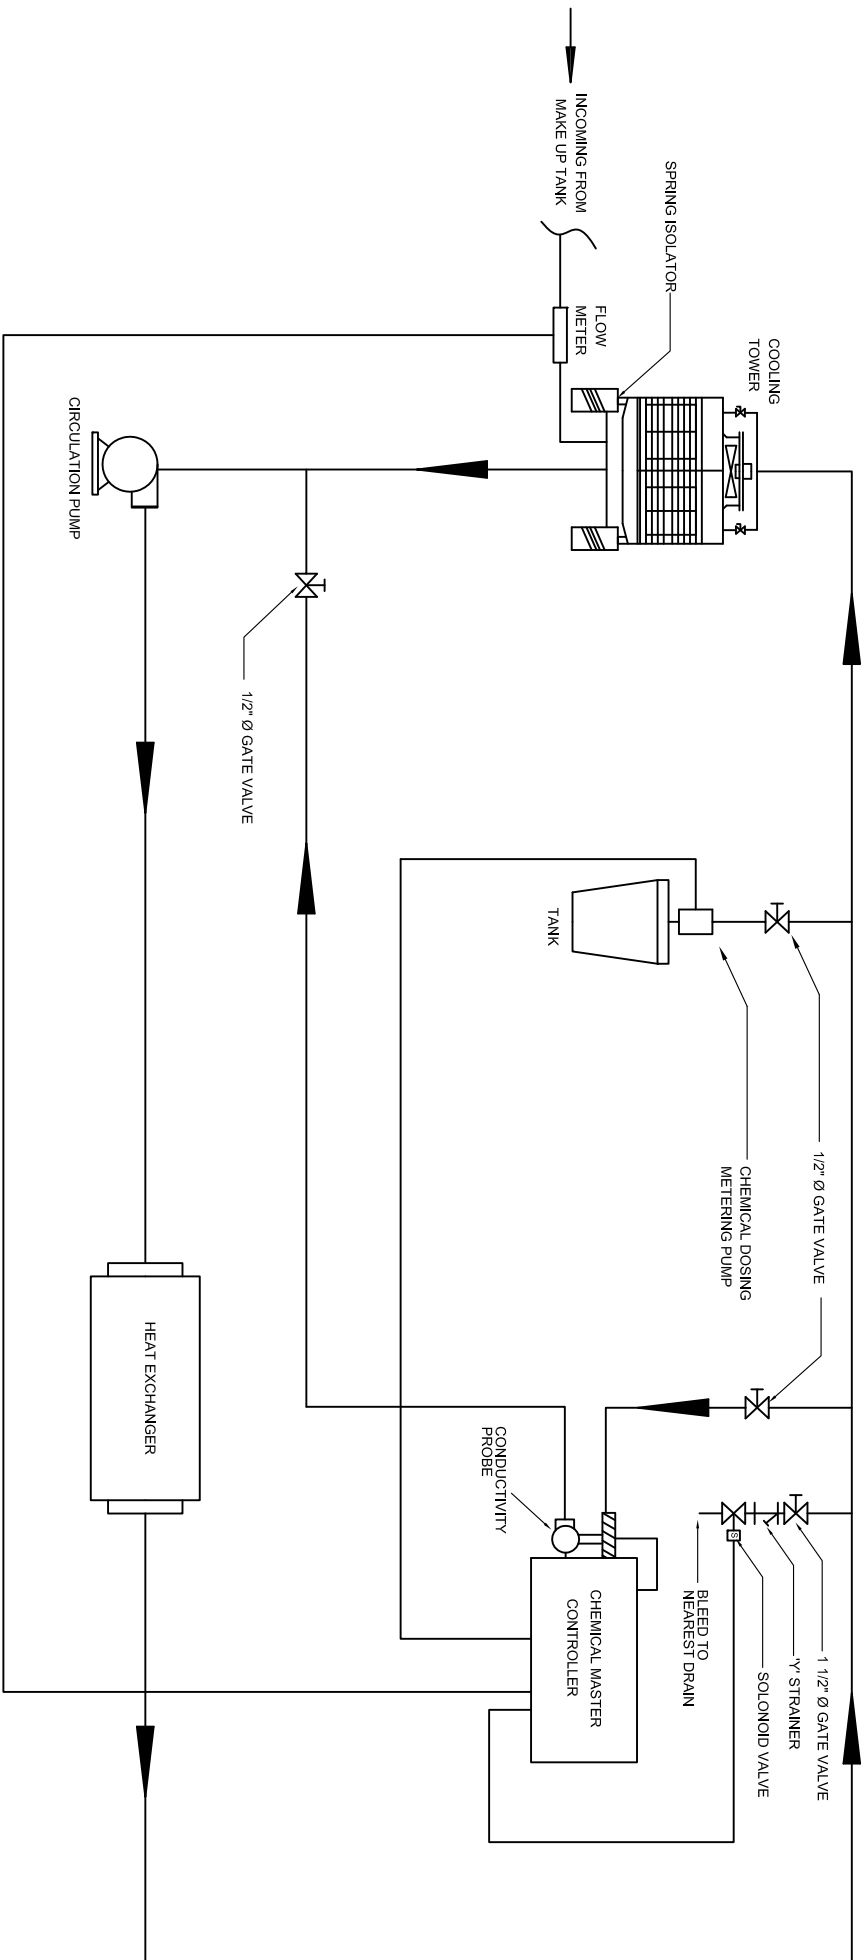

NOTE:-

- 1. THE CHEMICAL DOSING PUMP AND THE CONTROLLER SHALL BE MOUNTED ON THE WALL
- 2. THE 50 L HDPE CHEMICAL TANK, SHALL BE PLACED ON A PLATFORM
- 3. NUMBER OF CHEMICAL TANK TO BE DECIDED BY MECHANICAL CONTRACTOR

CONDENSER WATER TREATMENT
FULLY AUTOMATIC DOSING SYSTEM

NOTE:



JASA KEPADA RAKYAT
CAWANGAN KEJURUTERAAN MEKANIKAL
Ibu Pejabat JKR Malaysia



AIR CONDITIONING SYSTEM

CONDENSER WATER TREATMENT
- FULLY AUTOMATIC DOSING SYSTEM

DATE 2017 SCALE N.T'S

DRAWING NUMBER

CKM/STD/AC/PLANT/REV/2017/16

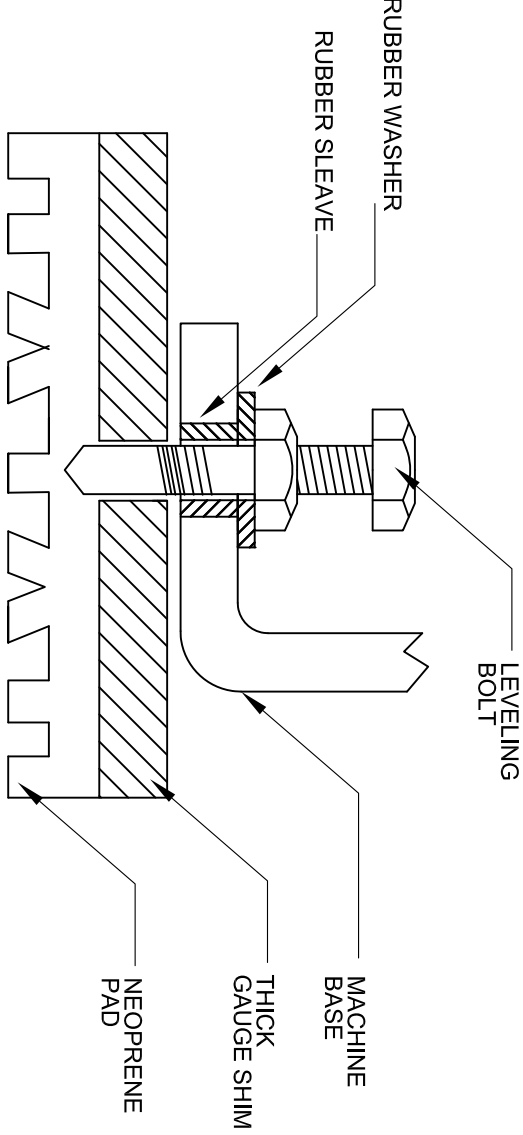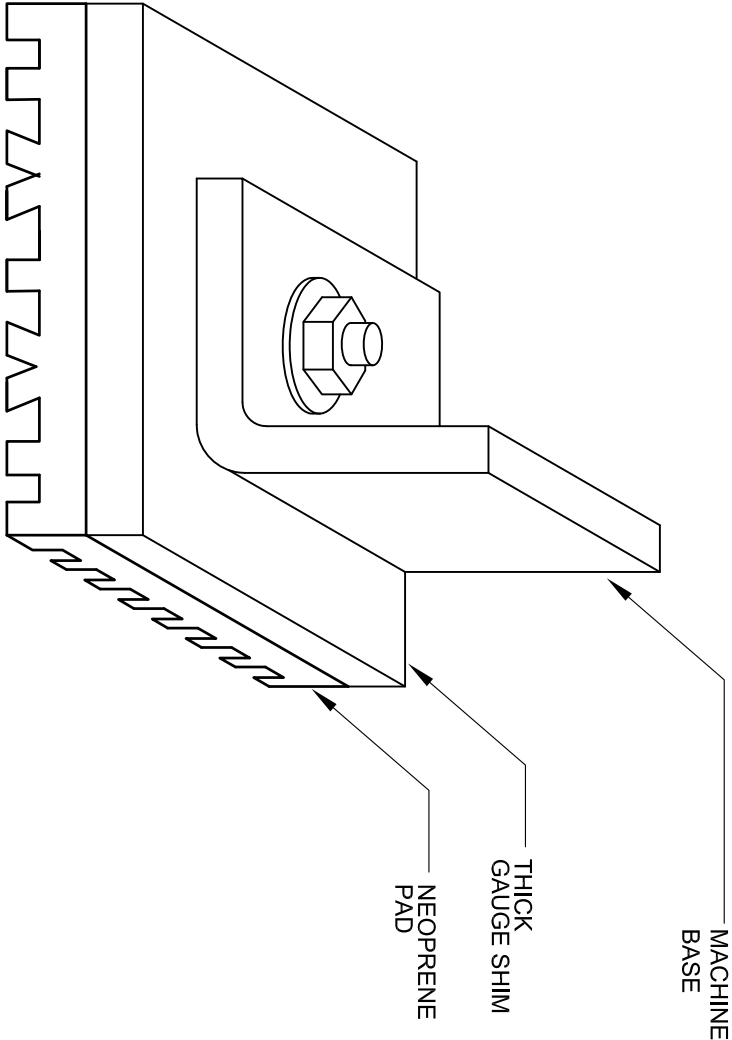

TYPICAL NEOPRENE PADS


- NOTE:-
- 1. RUBBER WASHER SIZE AS PER MANUFACTURER RECOMMENDED OR REFER TECHNICAL SPECIFICATION
 - 2. THICKNESS OF GAUGE SHIM & NEOPRENE PAD AS PER MANUFACTURE RECOMMENDED OR REFER TECHNICAL SPECIFICATION


NOTE:

		
JASA KEPADA RAKYAT		
CAWANGAN KEJUJUTERAAN MEKANIKAL		
Ibu Pejabat JKR Malaysia		
AIR CONDITIONING SYSTEM		
TYPICAL NEOPRENE PADS		
DATE	SCALE	N.T.S
2017		
DRAWING NUMBER		
CKM/STD/AC/PLANT/REV/2017/17		



JASA KEPADA RAKYAT
CAWANGAN KEJURUTERAAN MEKANIKAL
Ibu Pejabat JKR Malaysia

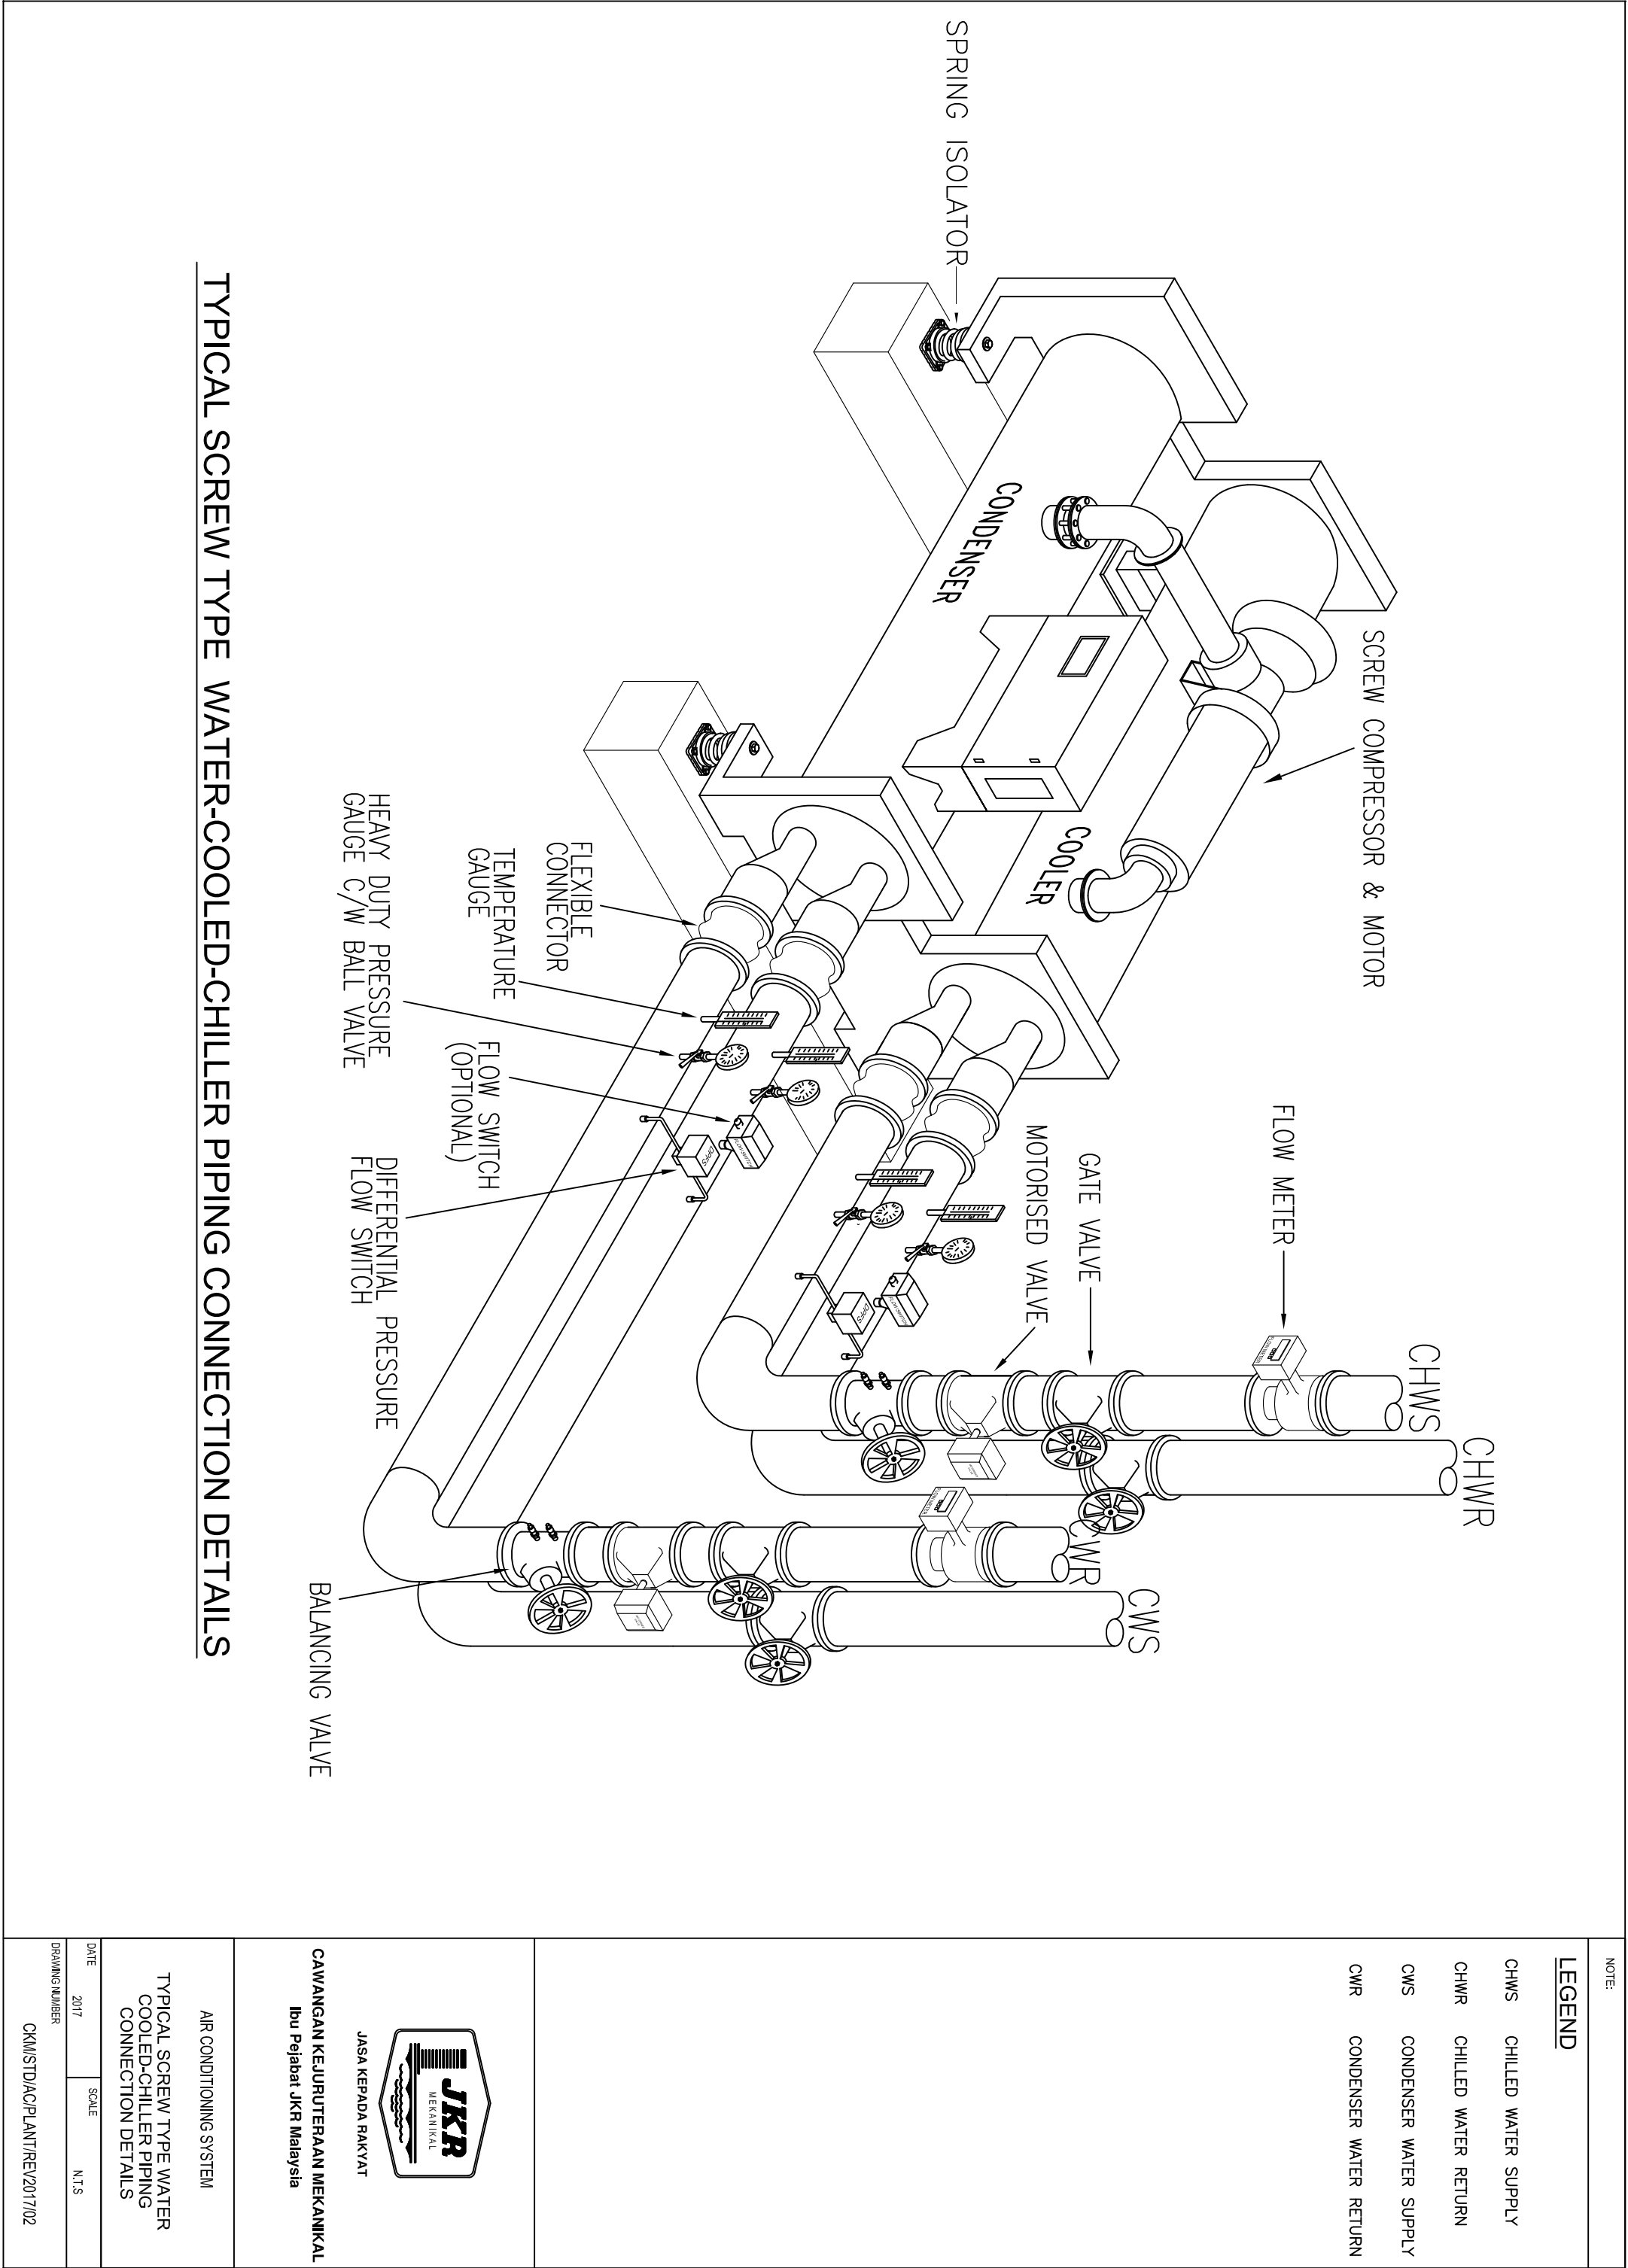

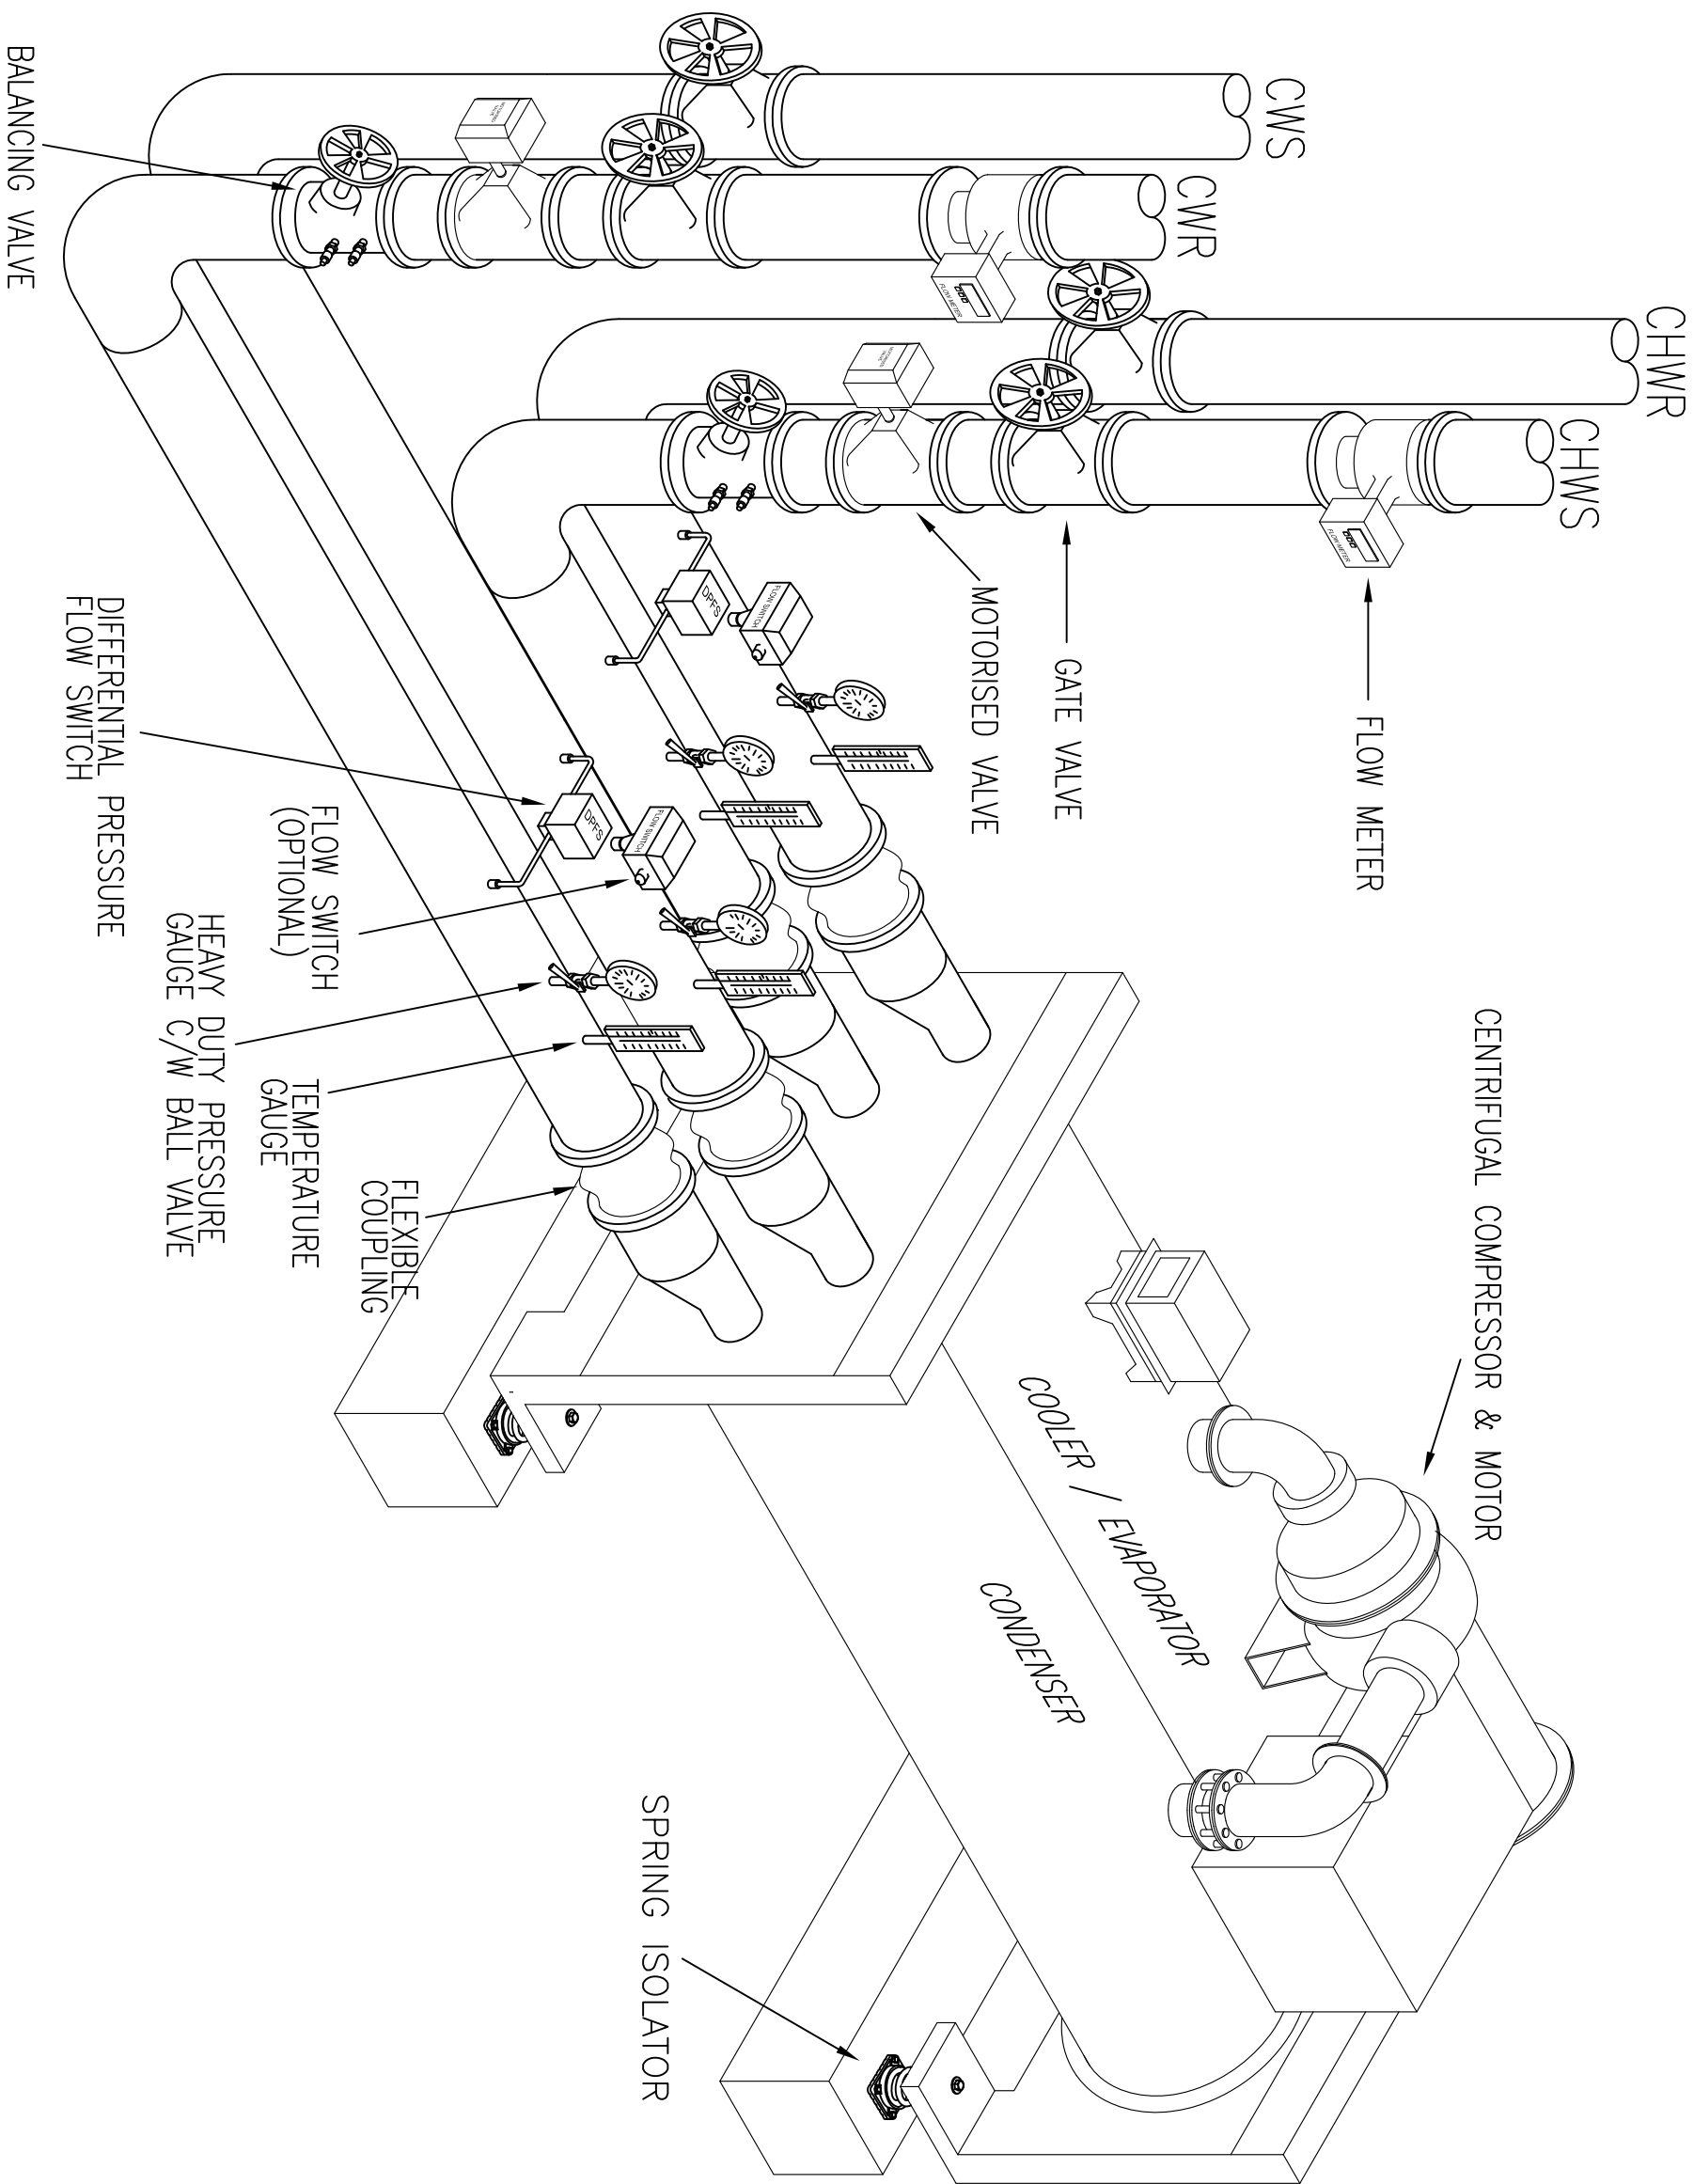

TYPICAL CENTRIFUGAL TYPE WATER-COOLED CHILLER PIPING CONNECTION DETAILS

NOTE:

LEGEND

- CHWS CHILLED WATER SUPPLY
- CHWR CHILLED WATER RETURN
- CWS CONDENSER WATER SUPPLY
- CWR CONDENSER WATER RETURN



JASA KEPADA RAKYAT
CAWANGAN KEJURUTERAAN MEKANIKAL
Ibu Pejabat JKR Malaysia

AIR CONDITIONING SYSTEM

TYPICAL CENTRIFUGAL TYPE
WATER-COOLED CHILLER PIPING
CONNECTION DETAILS

DATE 2017 SCALE N.T.S


DRAWING NUMBER

CKM/STD/AC/PLANT/REV2017/03

NOTE:

LEGEND

- CHWS CHILLED WATER SUPPLY
- CHWR CHILLED WATER RETURN

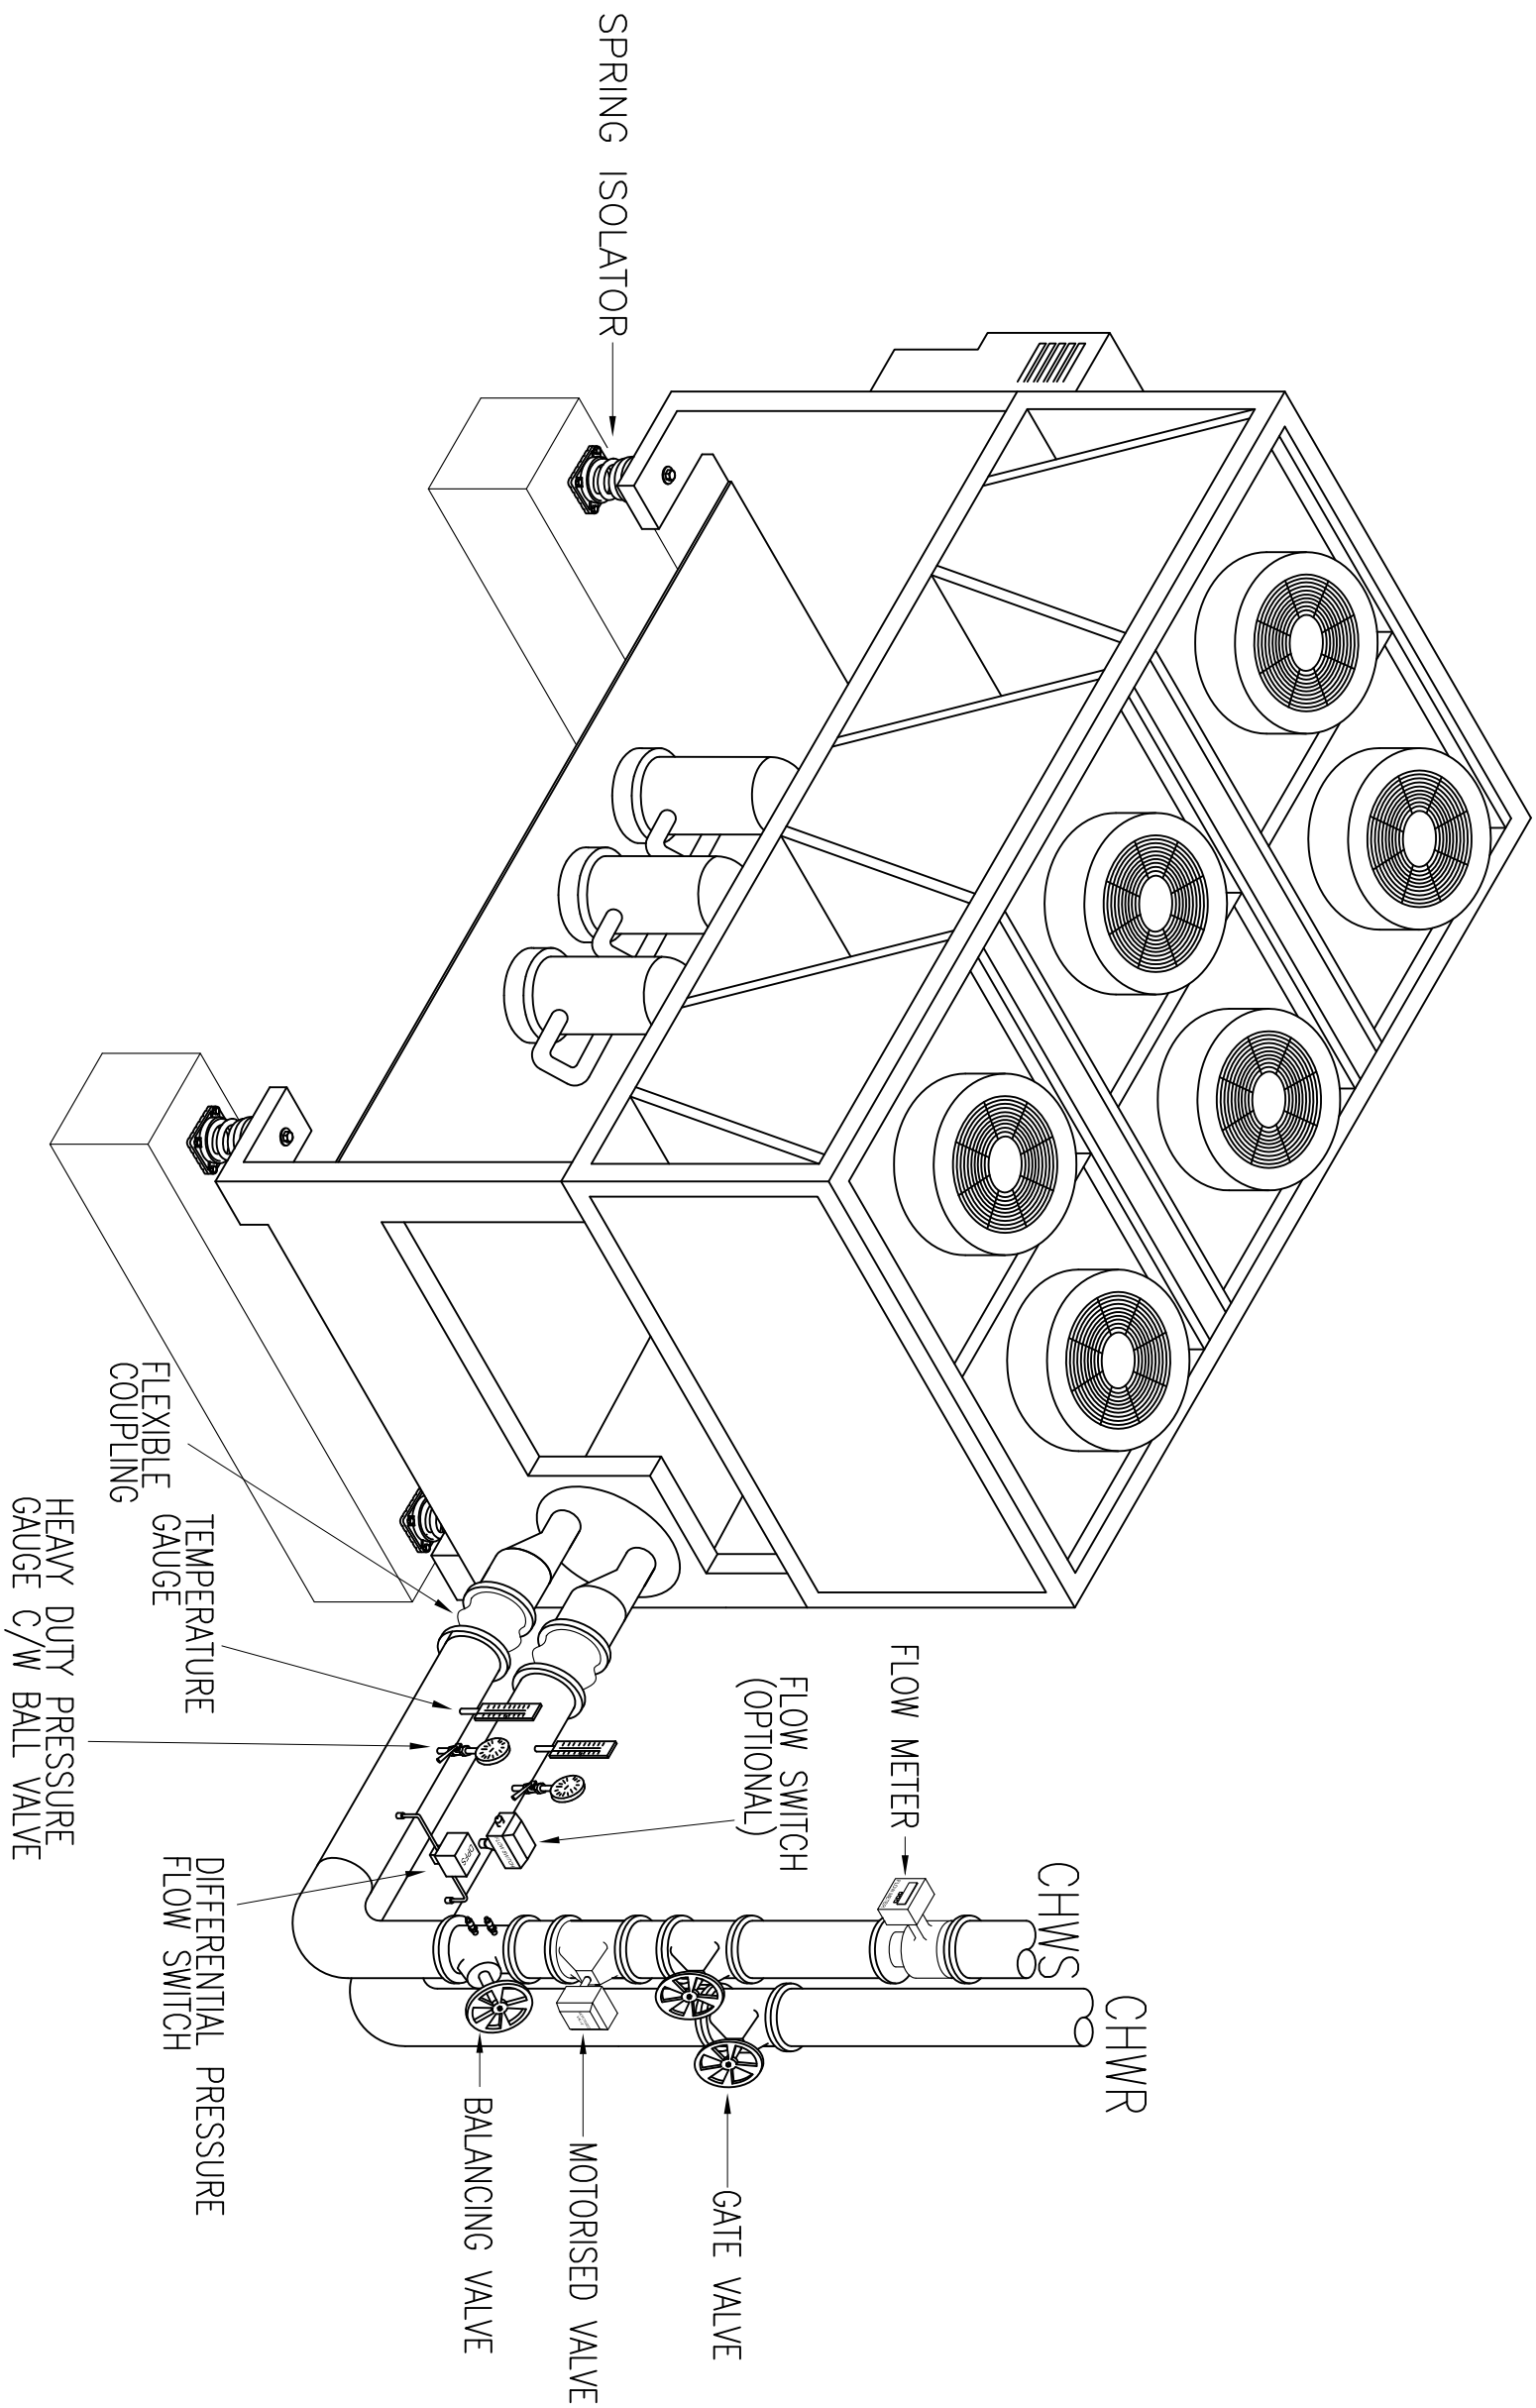

TYPICAL AIR-COOLED CHILLER PIPING CONNECTION DETAILS



JASA KEPADA RAKYAT


CAWANGAN KEJURUTERAAN MEKANIKAL

Ibu Pejabat JKR Malaysia


AIR CONDITIONING SYSTEM

TYPICAL AIR-COOLED CHILLER PIPING CONNECTION DETAILS

DATE	2017	SCALE	N.T.S
DRAWING NUMBER			
CKM/STD/AC/PLANT/REV2017/04			

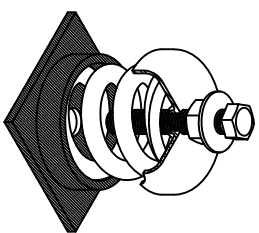

FREE-STANDING SPRING(FDS) ISOLATOR
ASHRAE TYPE 3

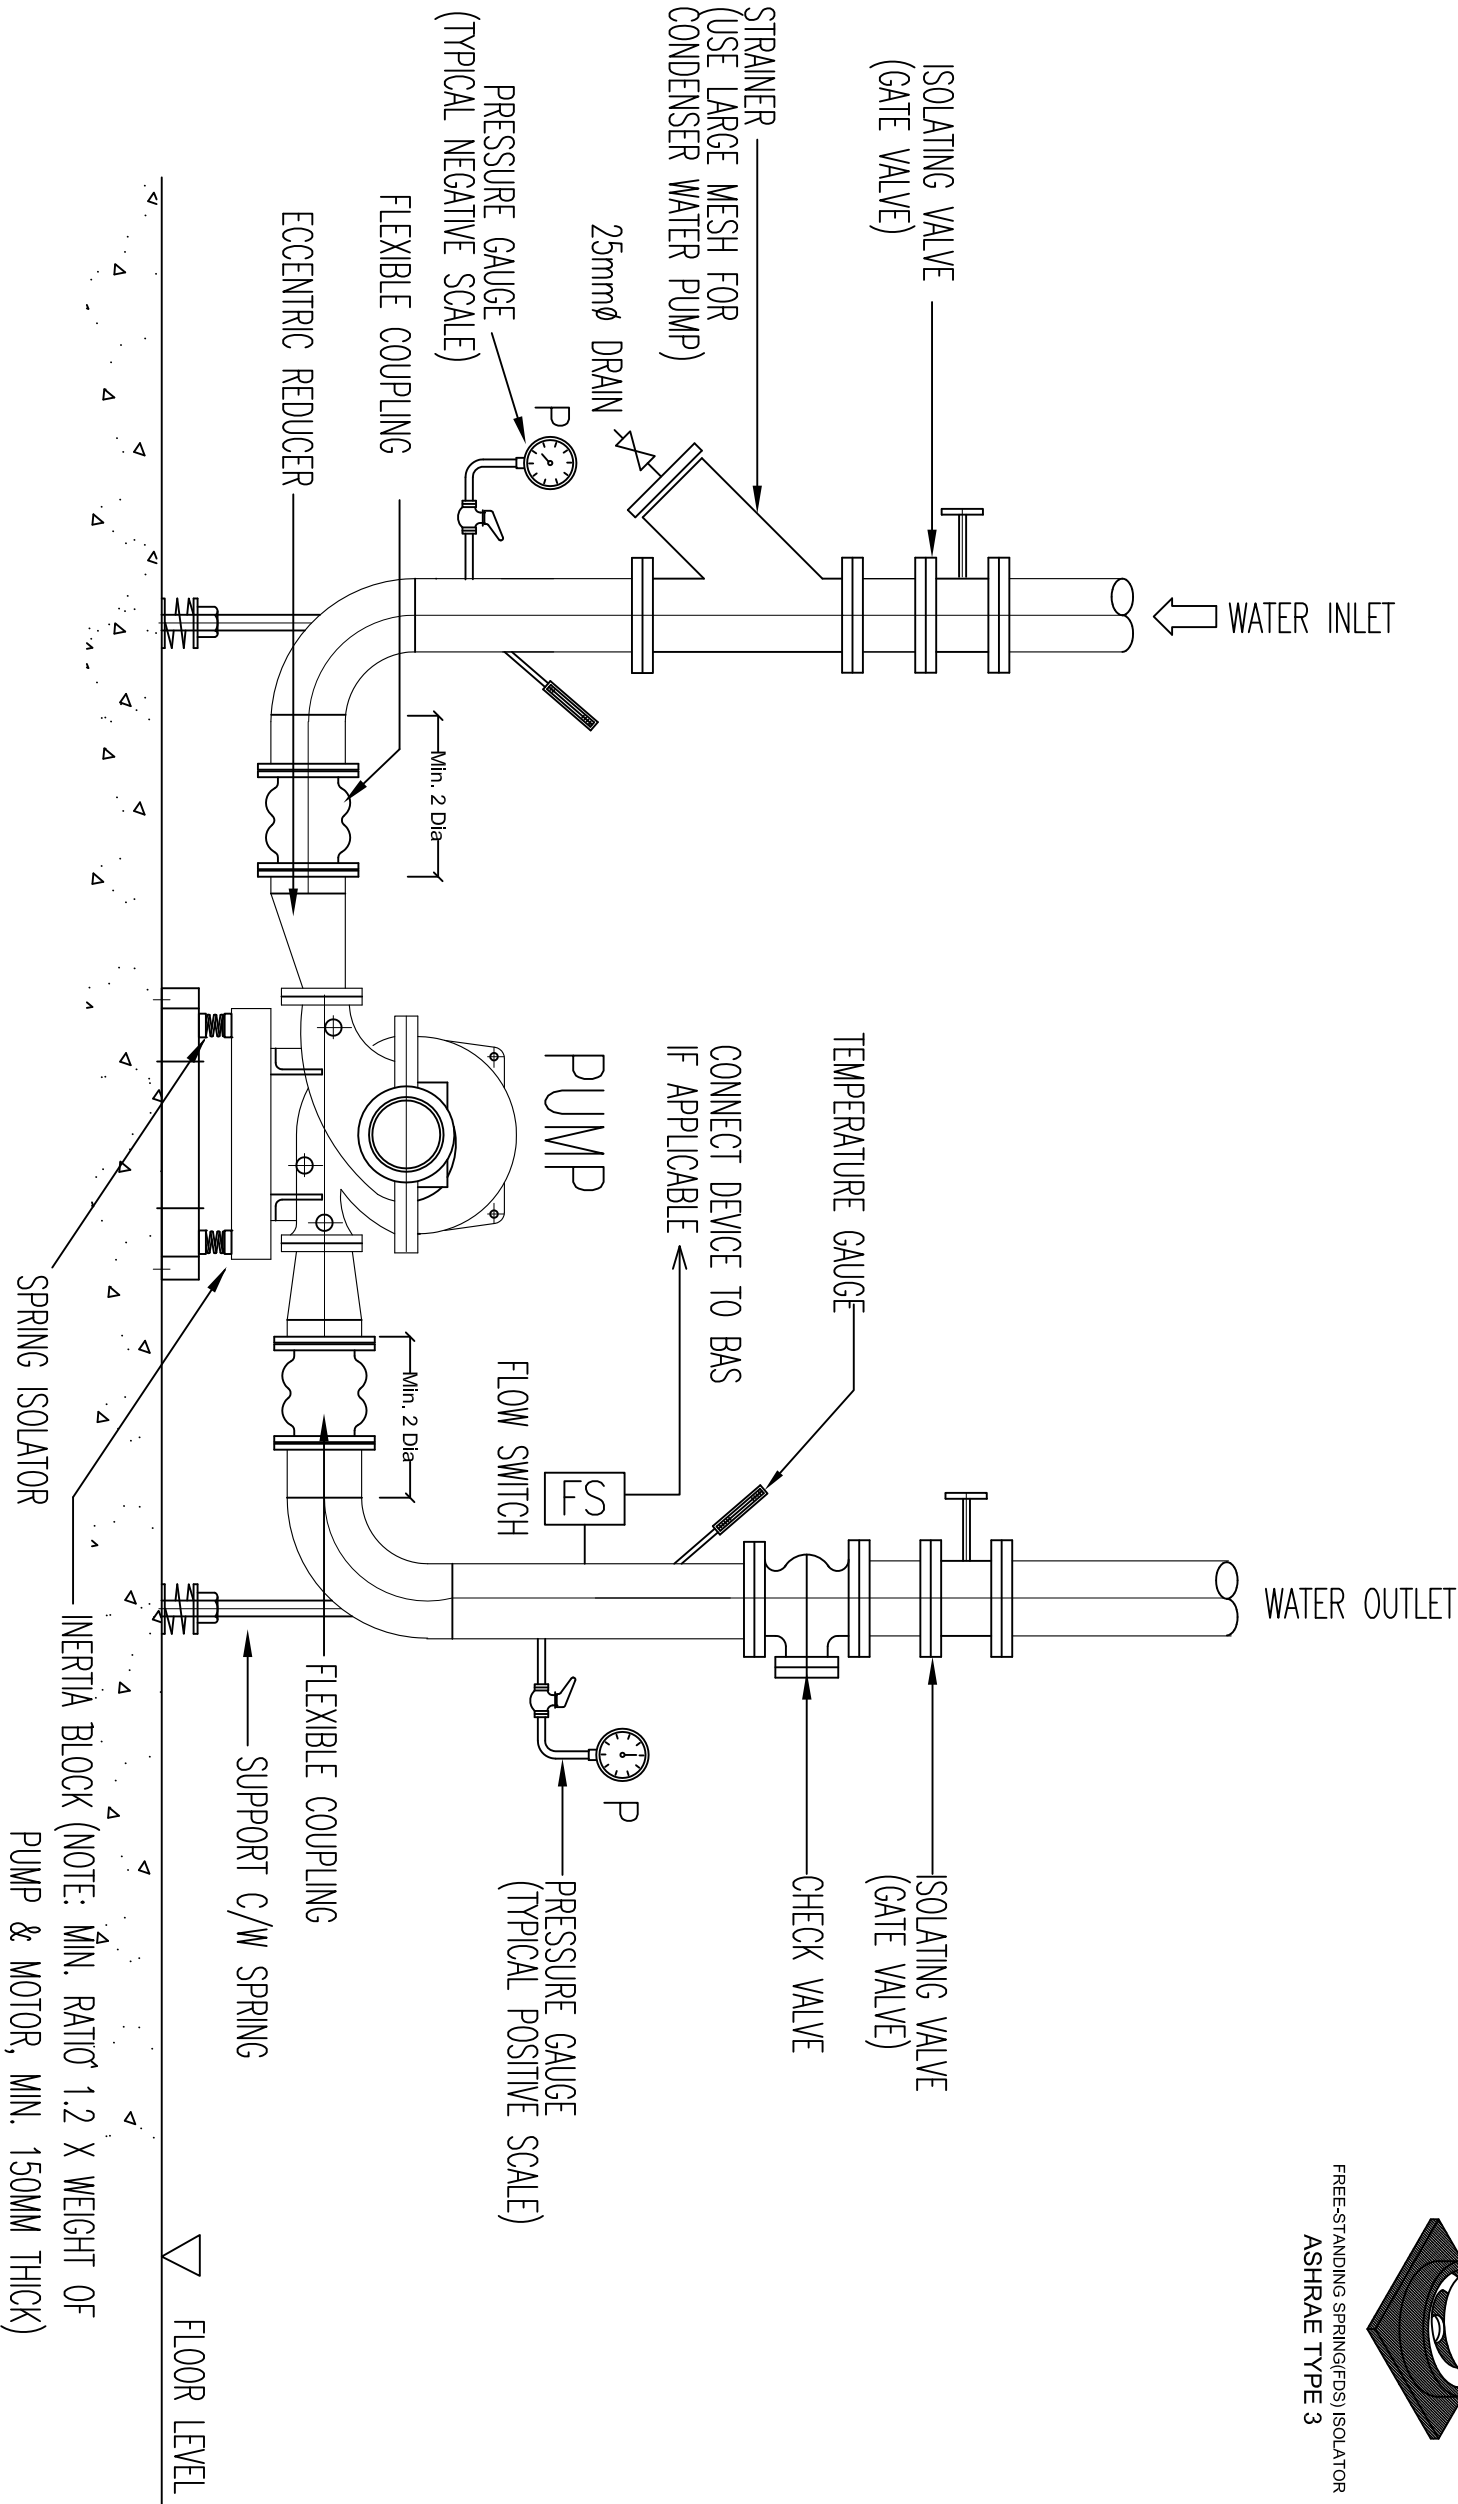

NOTE: REFER TECHNICAL SPECIFICATION FOR PIPE INSULATION DETAIL.

TYPICAL PUMP INSTALLATION DETAILS

(CWP/CHWP - HORIZONTAL SPLIT CASING)

NOTE:



JASA KEPADA RAKYAT

CAWANGAN KEJURUTERAAN MEKANIKAL

Ibu Pejabat JKR Malaysia


AIR CONDITIONING SYSTEM

TYPICAL PUMP INSTALLATION DETAILS


DATE 2017 SCALE N.T.S

DRAWING NUMBER

CKM/STD/AC/PLANT/REV/2017/05

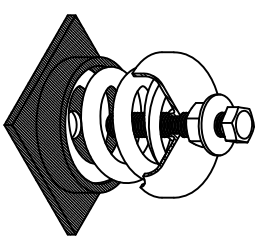

FREE-STANDING SPRING(FDS) ISOLATOR
ASHRAE TYPE 3

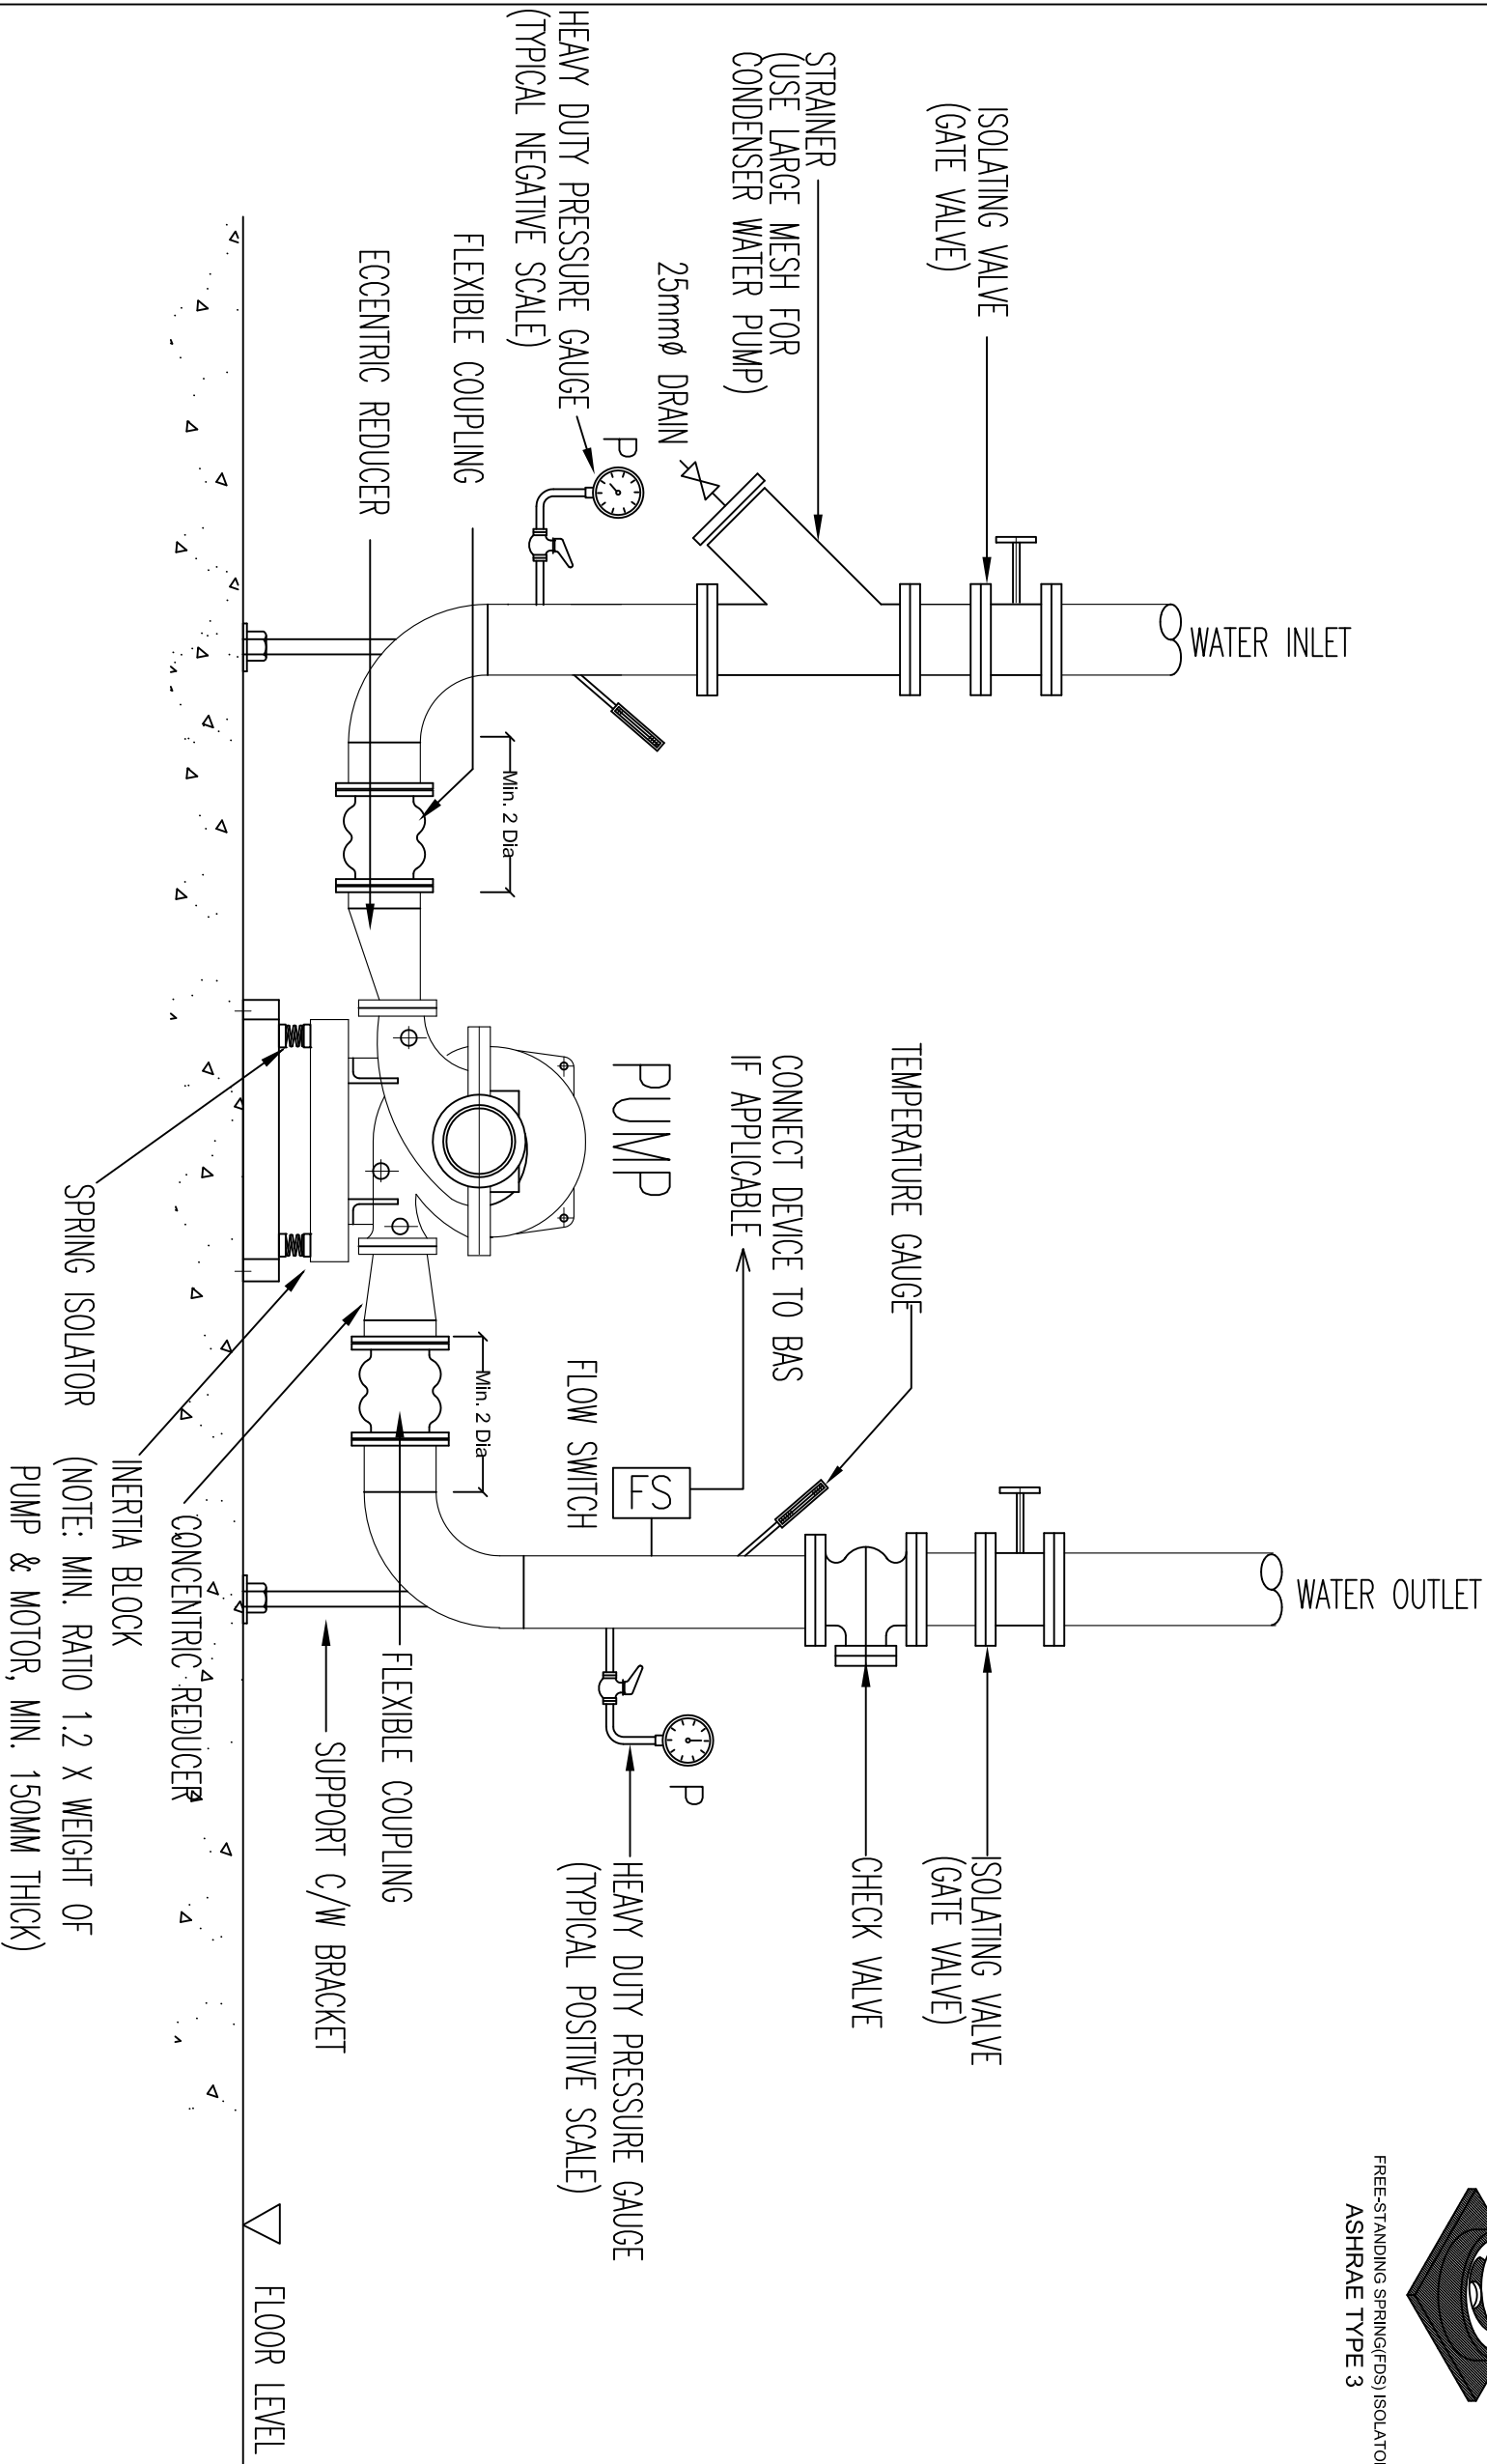

TYPICAL PUMP INSTALLATION DETAILS
(CWP/CHWP - HORIZONTAL SPLIT CASING)

NOTE:



JASA KEPADA RAKYAT

CAWANGAN KEJURUTERAAN MEKANIKAL
Ibu Pejabat JKR Malaysia


AIR CONDITIONING SYSTEM

TYPICAL PUMP INSTALLATION DETAILS


DATE 2017 SCALE N.T.S

DRAWING NUMBER

CKM/STD/AC/PLANT/REV/2017/06

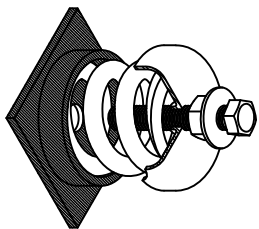

FREE-STANDING SPRING(FDS) ISOLATOR
ASHRAE TYPE 3

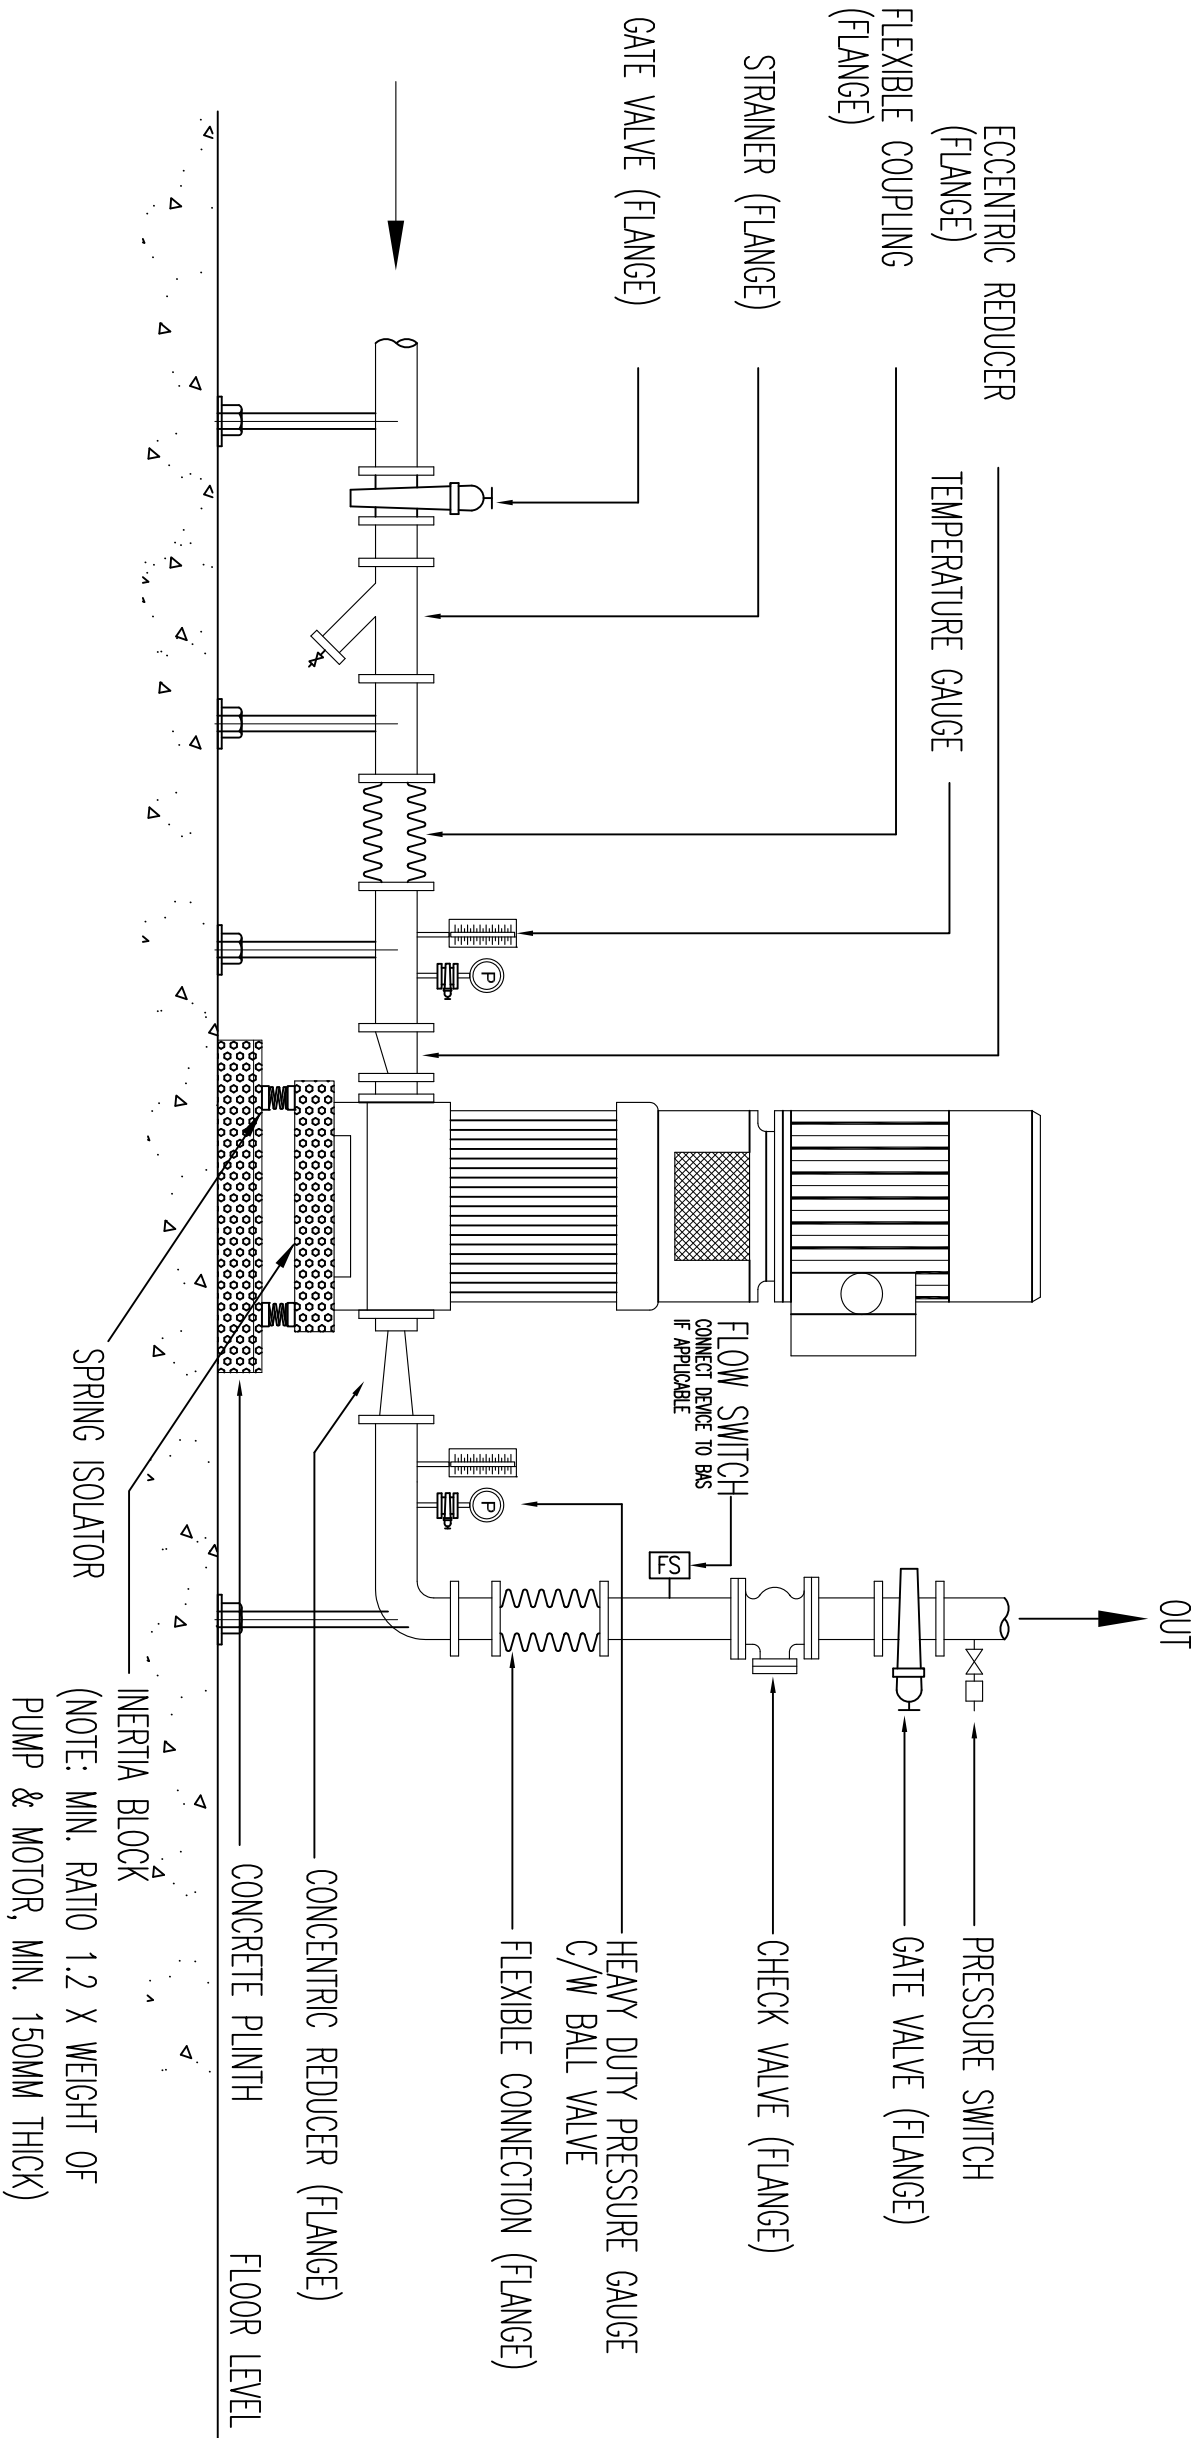

TYPICAL PUMP INSTALLATION DETAILS
(CWP/CHWP- Vertical Inline)

NOTE:



JASA KEPADA RAKYAT

CAWANGAN KEJURUTERAAN MEKANIKAL
Ibu Pejabat JKR Malaysia

AIR CONDITIONING SYSTEM

TYPICAL PUMP INSTALLATION DETAILS

DATE 2017 SCALE N.T.S

DRAWING NUMBER


CKM/STD/AC/PLANT/REV/2017/07

NOTE:




(CWP/CHWP- End Suction)

	
JASA KEPADA BAKYAT	
CAWANGAN KEJURUTERAN MEKANIKAL	
Ibu Pejabat JKR Malaysia	
AIR CONDITIONING SYSTEM	
TYPICAL PUMP INSTALLATION DETAILS	
DATE	2017
SCALE	N.T.S
DRAWING NUMBER	
CKM/STD/AC/PLANT/REV/2017/08	

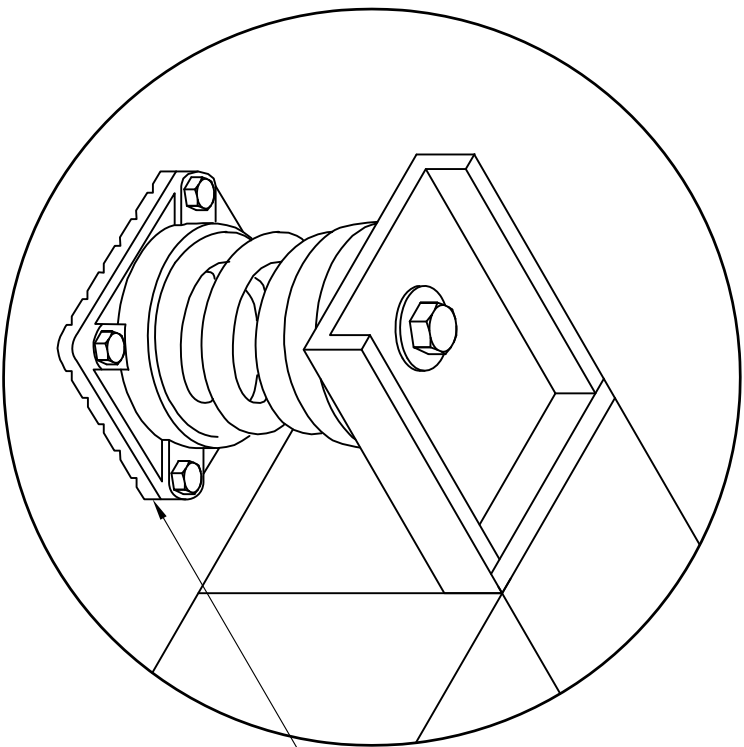

NEOPRENE PAD

DETAIL A

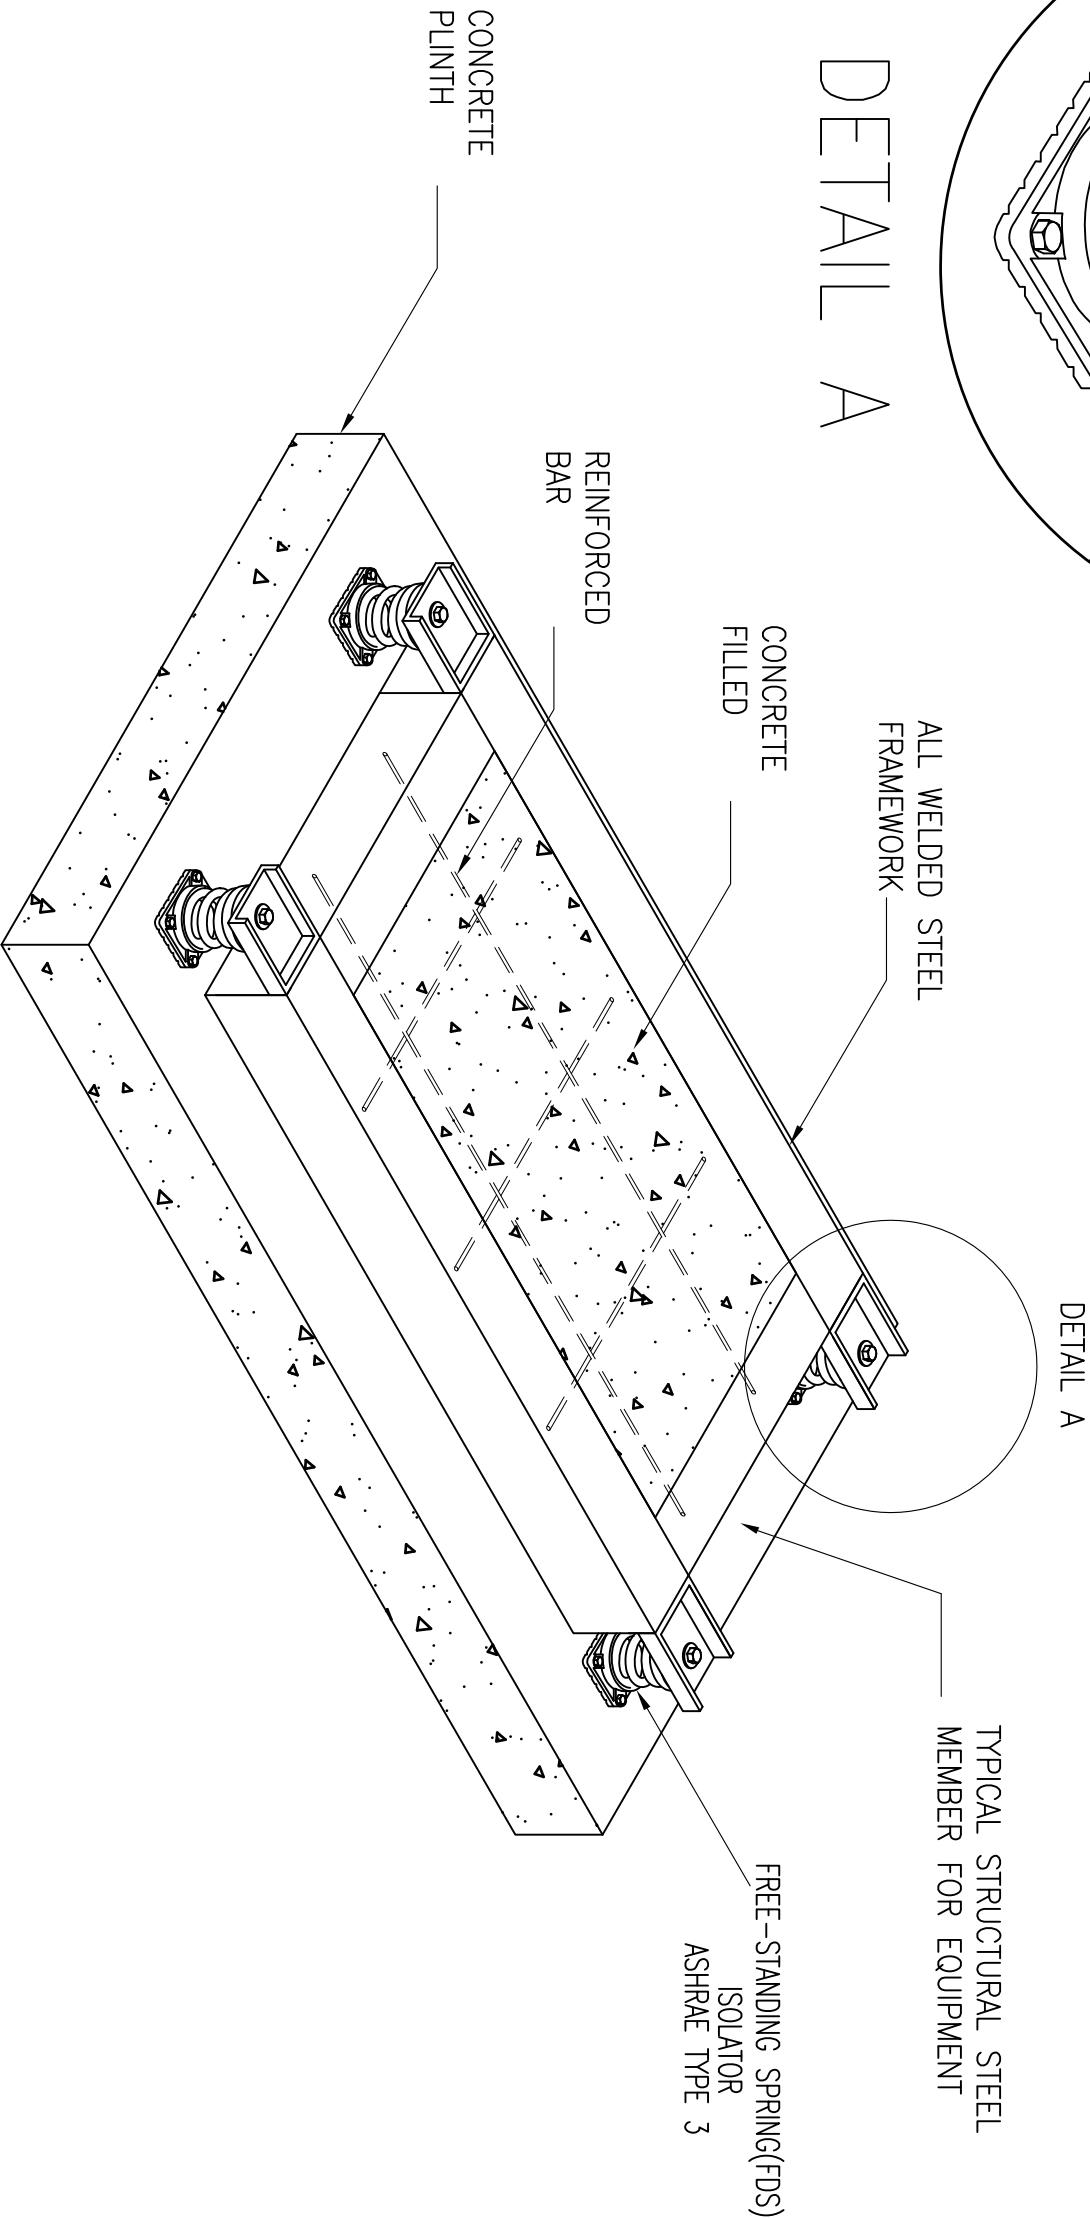

NOTE:



JASA KEPADA RAKYAT
CAWANGAN KEJURUTERAAN MEKANIKAL
Ibu Pejabat JKR Malaysia

AIR CONDITIONING SYSTEM

PUMP AND MOTOR BASE

DATE 2017 SCALE N.T.S


DRAWING NUMBER

CKMSTD/AC/PLANT/REV2017/09


PUMP AND MOTOR BASE

Inertia Block – Operation Weight Minima 1 :1.2


PIPE

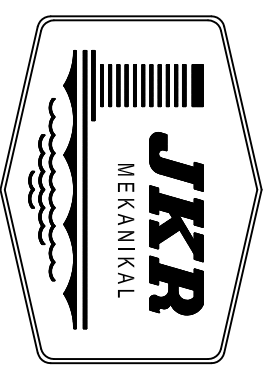

JASA KEPADA RAKYAT

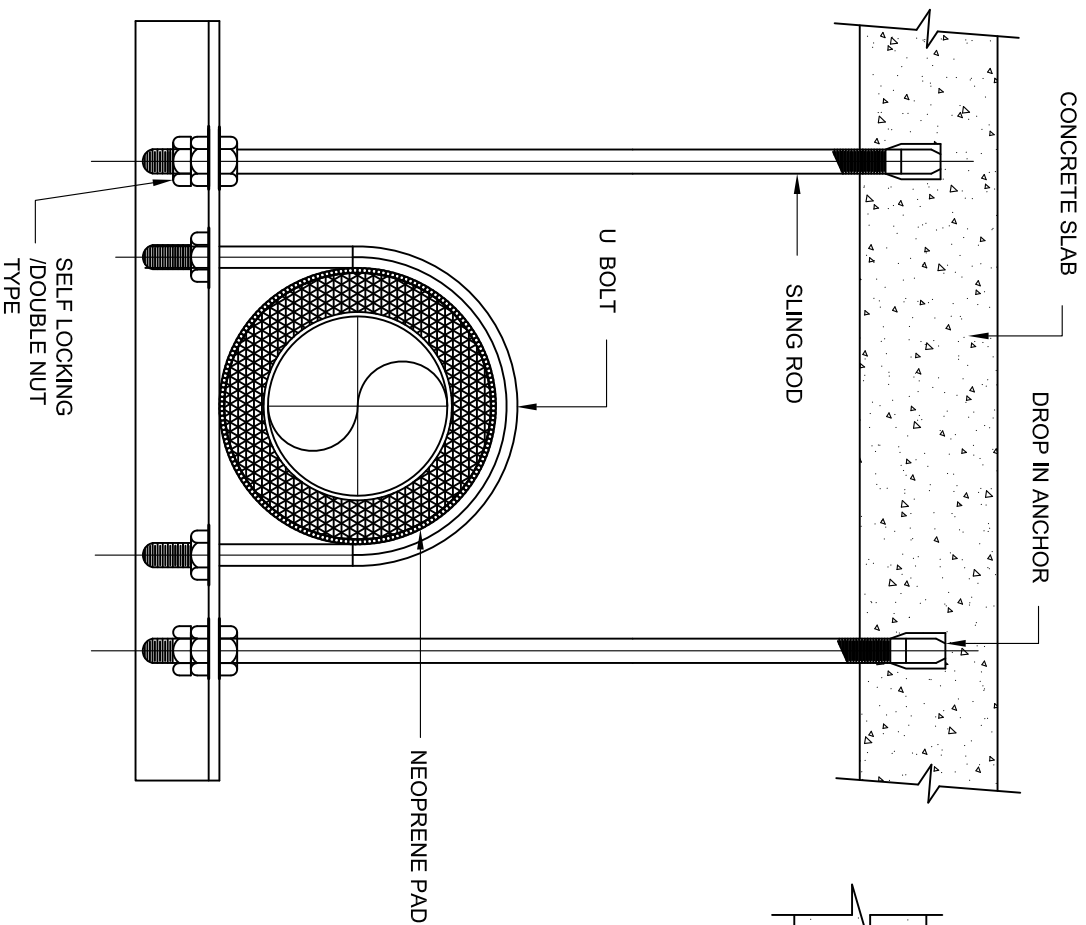

TYPICAL PIPE HANGER
(SINGLE PIPE)

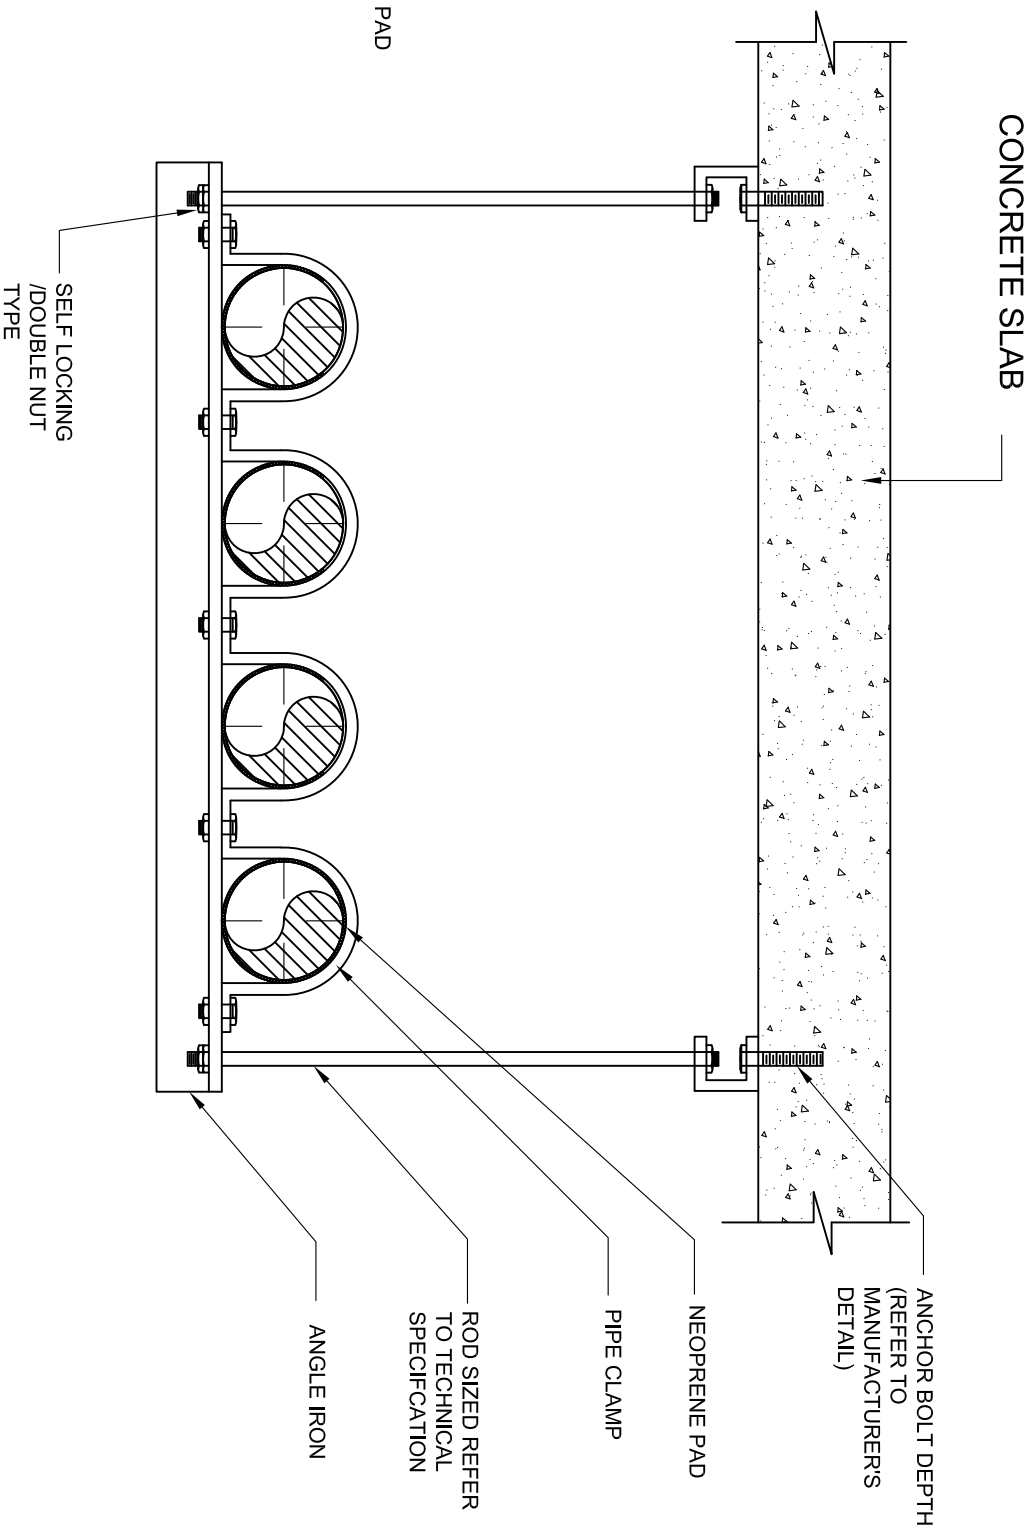

TYPICAL PIPE HANGER
(MORE THAN ONE PIPE)

PIPE HANGERS FOR INSULATED PIPE OUTSIDE MECHANICAL ROOM

NOTE:



JASA KEPADA RAKYAT
CAWANGAN KEJURUTERAAN MEKANIKAL
Ibu Pejabat JKR Malaysia

AIR CONDITIONING SYSTEM

PIPE HANGERS FOR INSULATED PIPE
(OUTSIDE MECHANICAL ROOM)

DATE


2017

SCALE


N.T.S

DRAWING NUMBER

CKM/STD/AC/PIPE/REV/2017/01

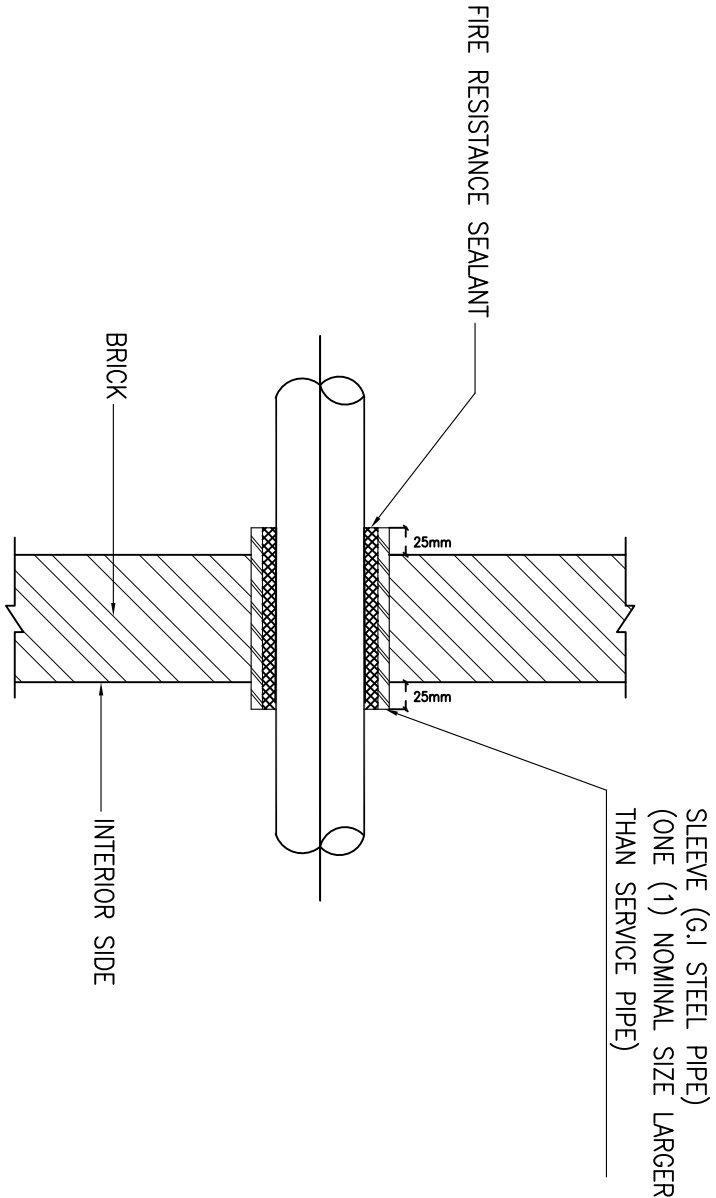


PIPE SLEEVE FOR PIPE THROUGH WALL

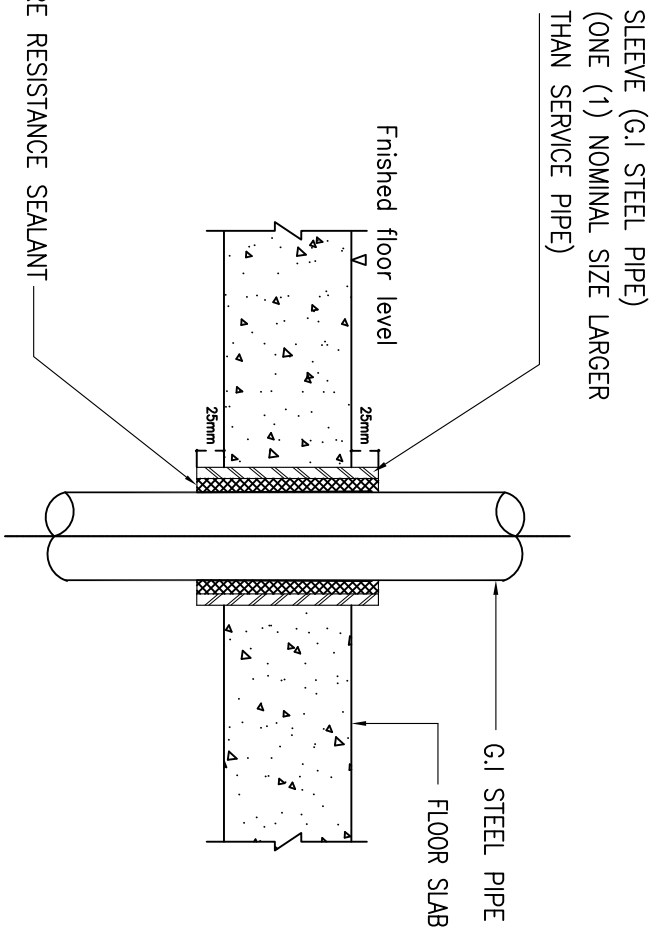


- Notes:
1. Normal floor—the sleeves shall end 25mm above finished floor level.
 2. Wet floor—the sleeves shall end 50mm above finished floor level.

PIPE SLEEVE FOR PIPE THROUGH FLOOR

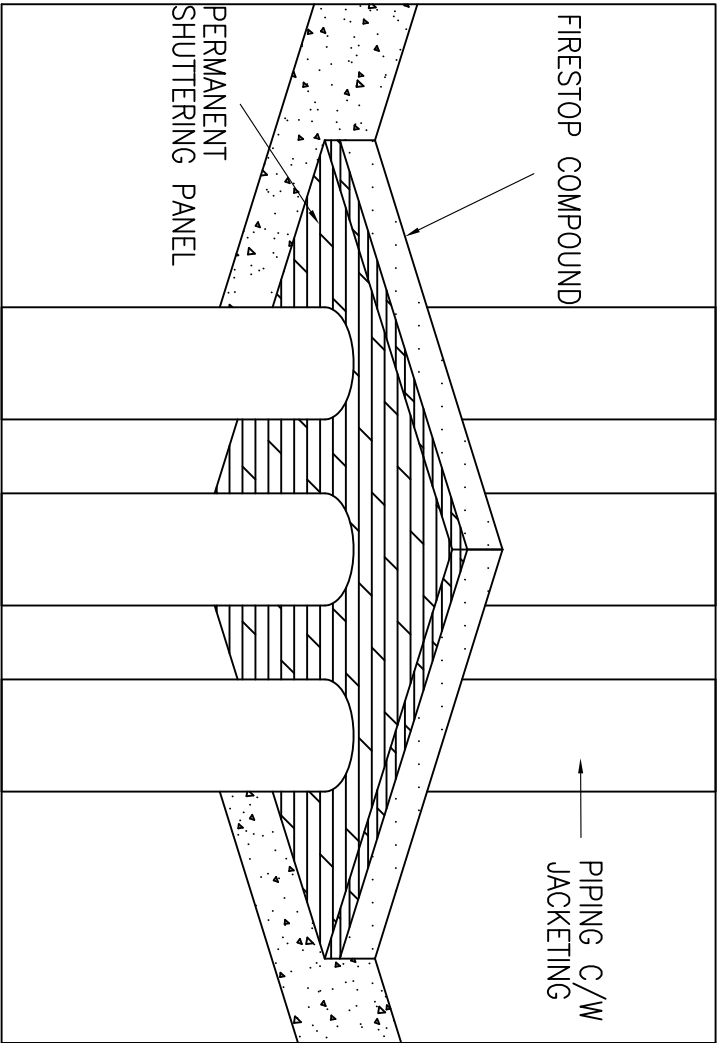

PIPE THROUGH FLOOR WITHOUT SLEEVE

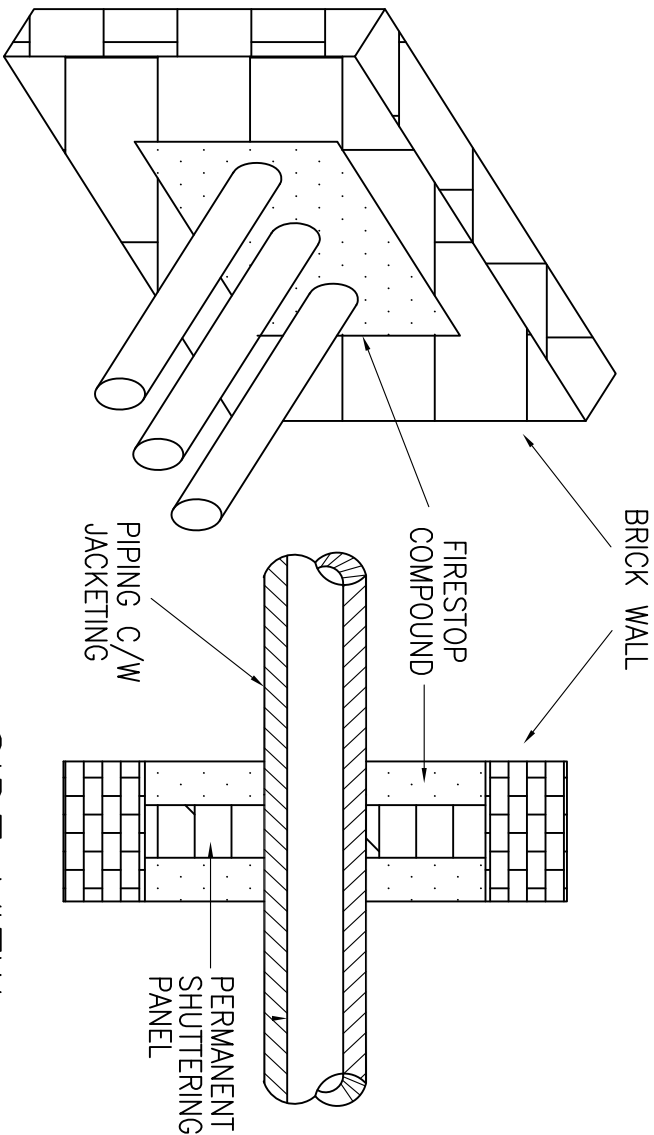

ISOMETRIC VIEW


SIDE VIEW

PIPE THROUGH WALL WITHOUT SLEEVE

NOTE:

 JASA KEPADA RAKYAT CAWANGAN KEJURUTERAAN MEKANIKAL Ibu Pejabat JKR Malaysia AIR CONDITIONING SYSTEM	
DETAIL OF PIPES THROUGH WALLS AND FLOORS	
DATE	SCALE
2017	N.T.S
DRAWING NUMBER	
CKM/STD/JAC/P/PE/REV/2017/10	


NOTE:

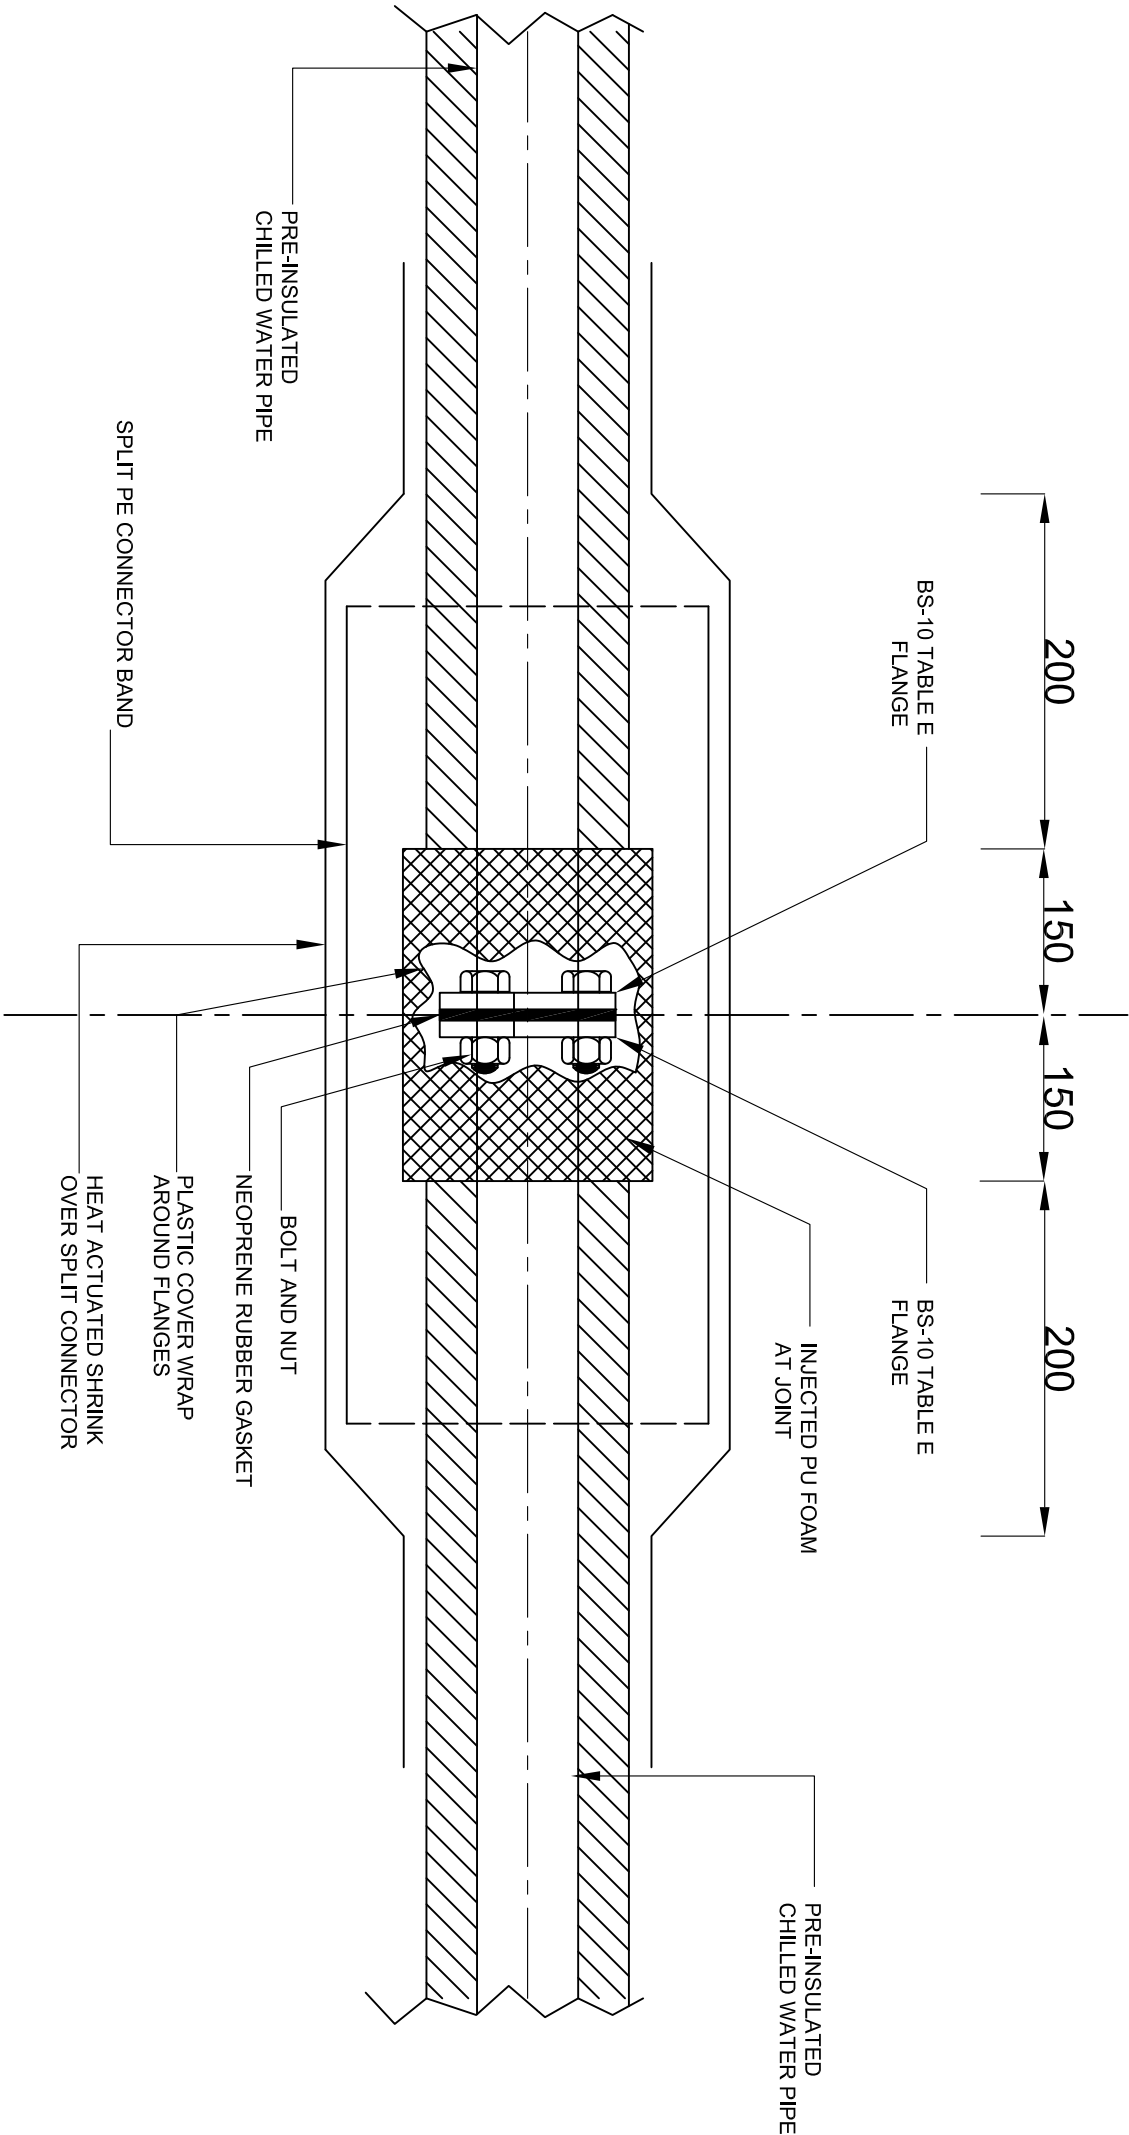

DETAIL OF JOINT FOR CHILLED WATER PIPE AT INTERFACING LINE

 JKR MEKANIKAL JASA KEPADA RAKYAT CAWANGAN KEJURUTERAAN MEKANIKAL Ibu Pejabat JKR Malaysia	
AIR CONDITIONING SYSTEM	
DETAIL OF JOINT FOR CHILLED WATER PIPE AT INTERFACING LINE	
DATE	SCALE
2017	N.T.S
DRAWING NUMBER	
CKM/STD/AC/PIPE/REV/2017/11	

NOTE:

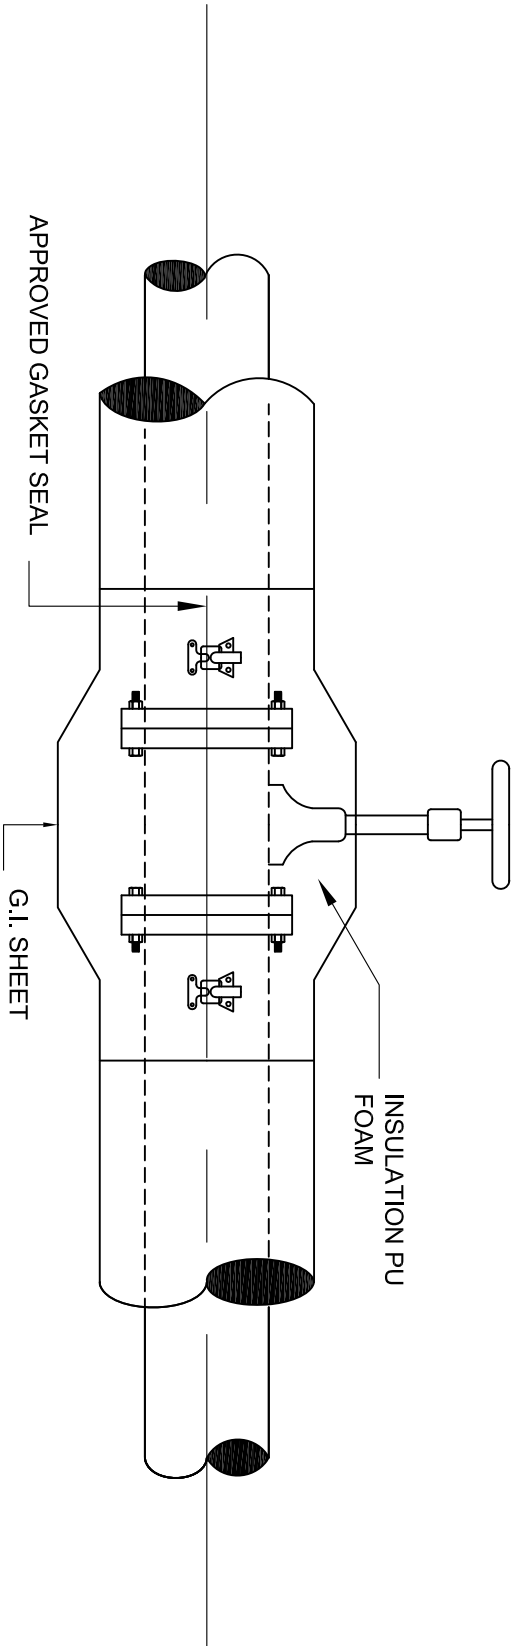


NOTE:


- 1. APPLICABLE FOR ALL CHILLED WATER VALVES, CONTROL VALVES, STRAINERS, BY PASS VALVES ETC.

TYPICAL CHILLED WATER VALVE INSULATION DETAILS

 JASA KEPADA RAKYAT CAWANGAN KEJURUTERAAN MEKANIKAL Ibu Pejabat JKR Malaysia		
AIR CONDITIONING SYSTEM		
TYPICAL CHILLED WATER VALVE INSULATION DETAILS		
DATE	SCALE	N.T.S
2017		
DRAWING NUMBER		
CKM/STD/AC/PIPE/REV2017/12		

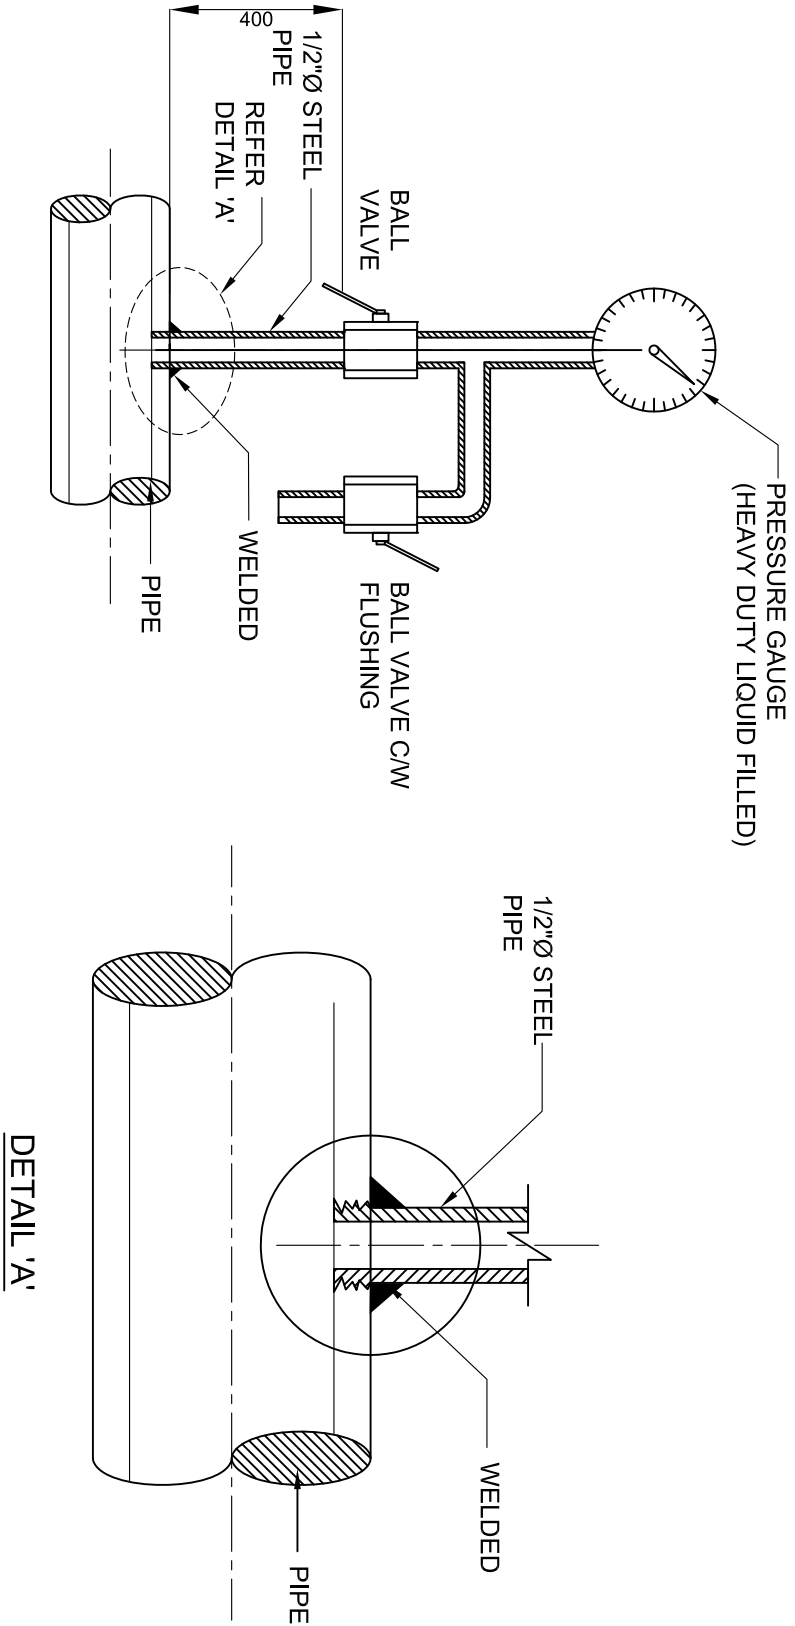

PRESSURE GAUGE ATTACHMENT DETAIL

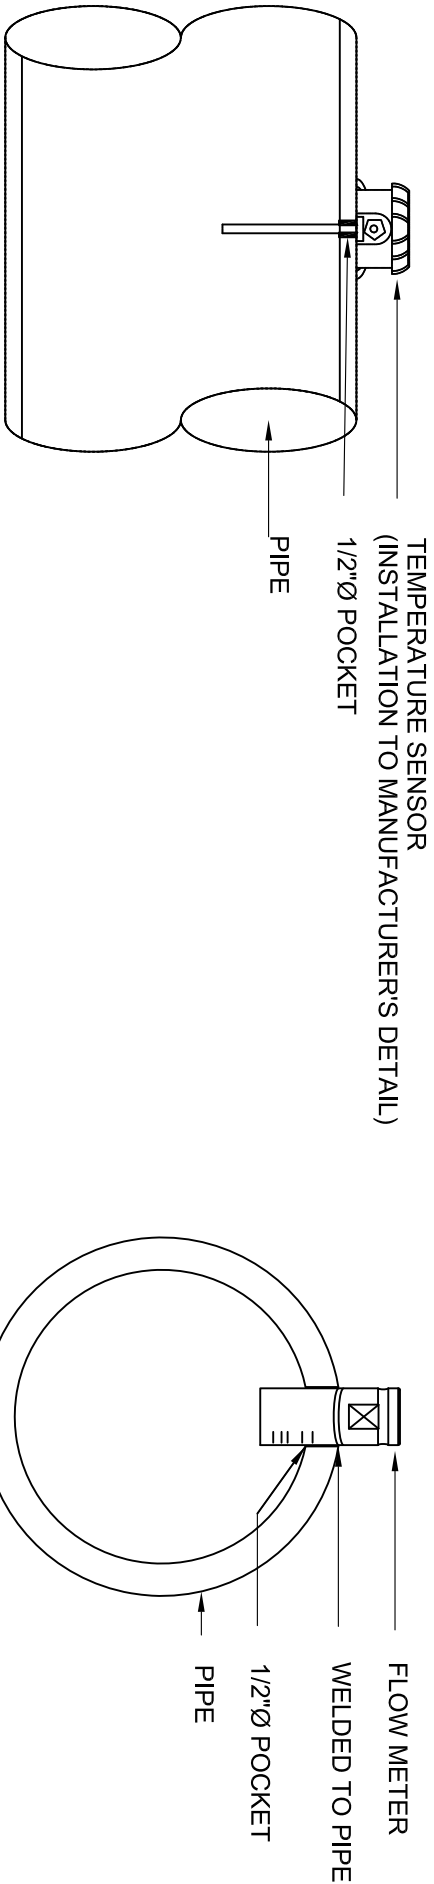

TEMPERATURE SENSOR INSTALLATION


FLOW METER INSTALLATION

NOTE:




JASA KEPADA RAKYAT
CAWANGAN KEJURUTERAAN MEKANIKAL
Ibu Pejabat JKR Malaysia


AIR CONDITIONING SYSTEM	
DETAIL OF CHILLED WATER PIPE FITTING INSTALLATION	
DATE	SCALE
2017	N.T.S
DRAWING NUMBER	
CKM/STD/AC/PIPE/REV/2017/13	

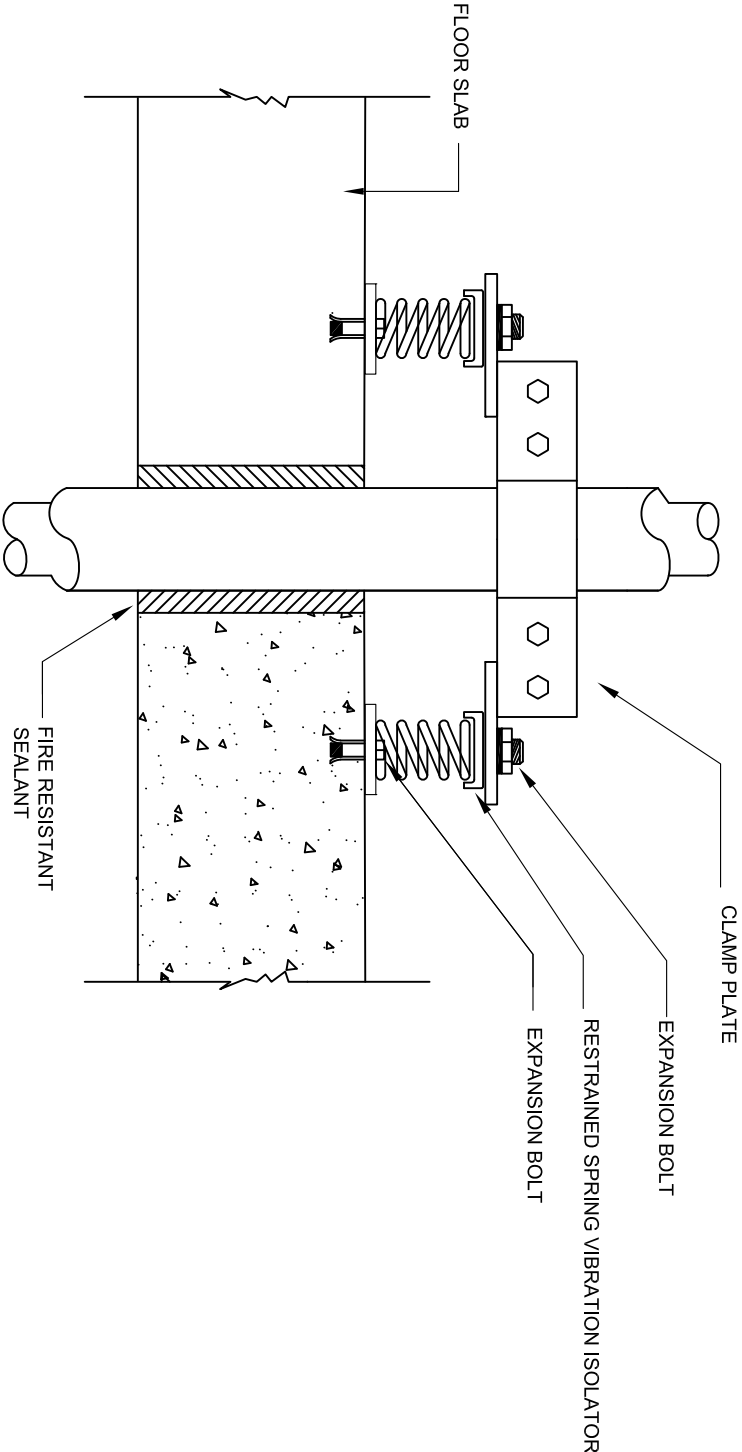


TYPICAL FIRST VERTICAL PIPE RISER THROUGH FLOOR SLAB
MOUNTING DETAILS

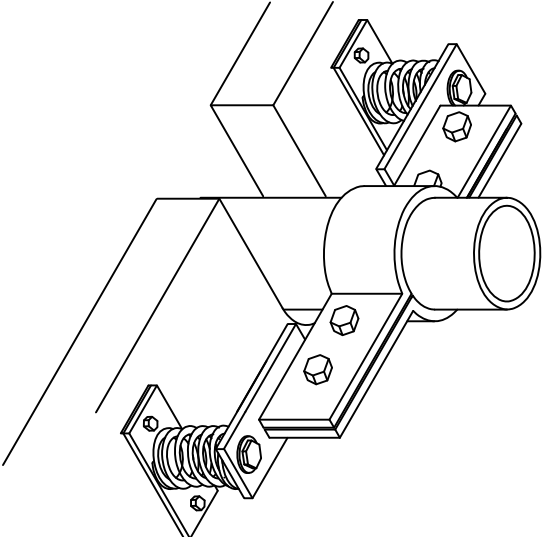

ISOMETRIC VIEW

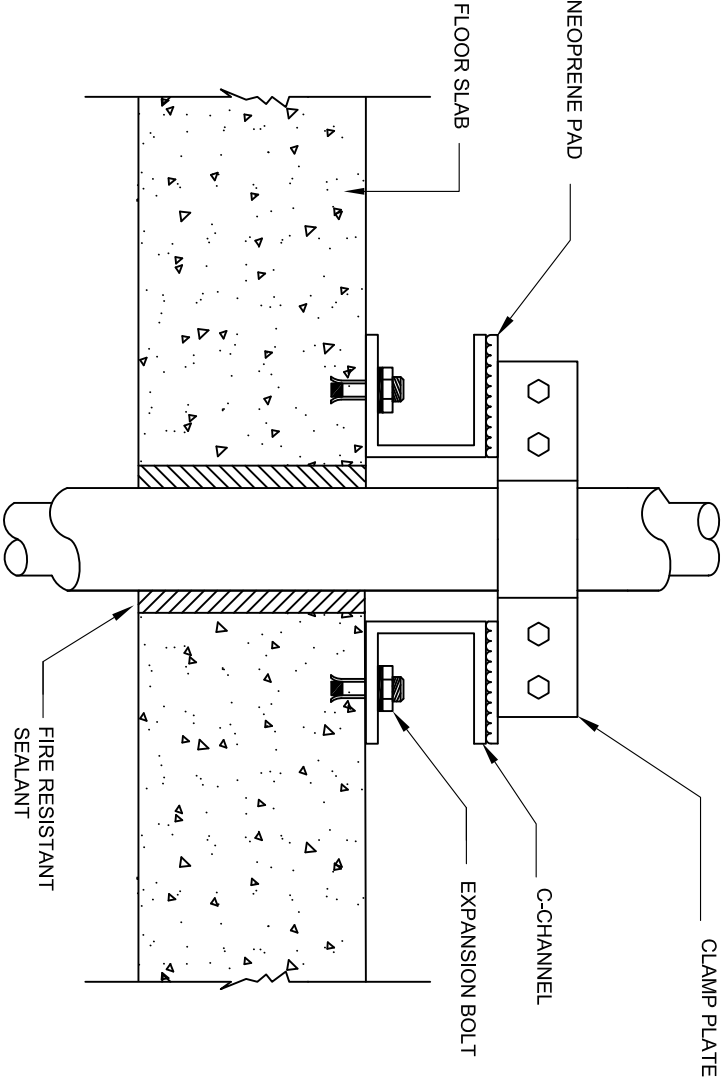

TYPICAL REMAINING VERTICAL PIPE RISER THROUGH FLOOR SLAB
MOUNTING DETAILS

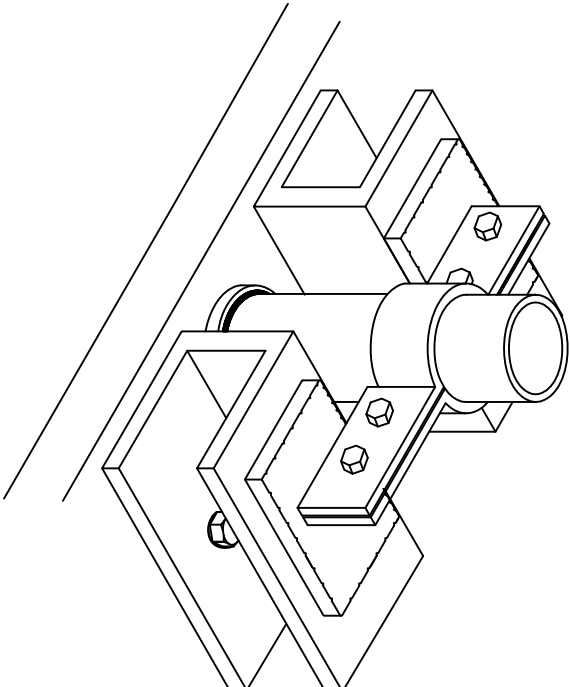

ISOMETRIC VIEW

NOTE:



JASA KEPADA RAKYAT
CAWANGAN KEJURUTERAAN MEKANIKAL
Ibu Pejabat JKR Malaysia

AIR CONDITIONING SYSTEM

PIPE RISER THROUGH FLOOR
SLAB MOUNTING DETAILS

DATE

2017


SCALE

N.T.S


DRAWING NUMBER

CKM/STD/ACP/PIPE/REV2017/14


NOTE:

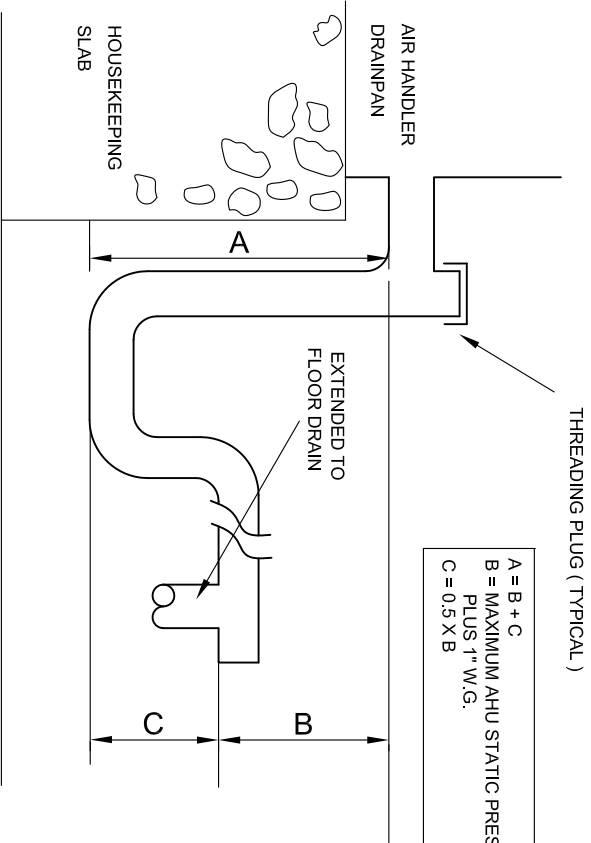

DRAIN TRAP FOR COIL SUBJECTED
TO NEGATIVE PRESSURE

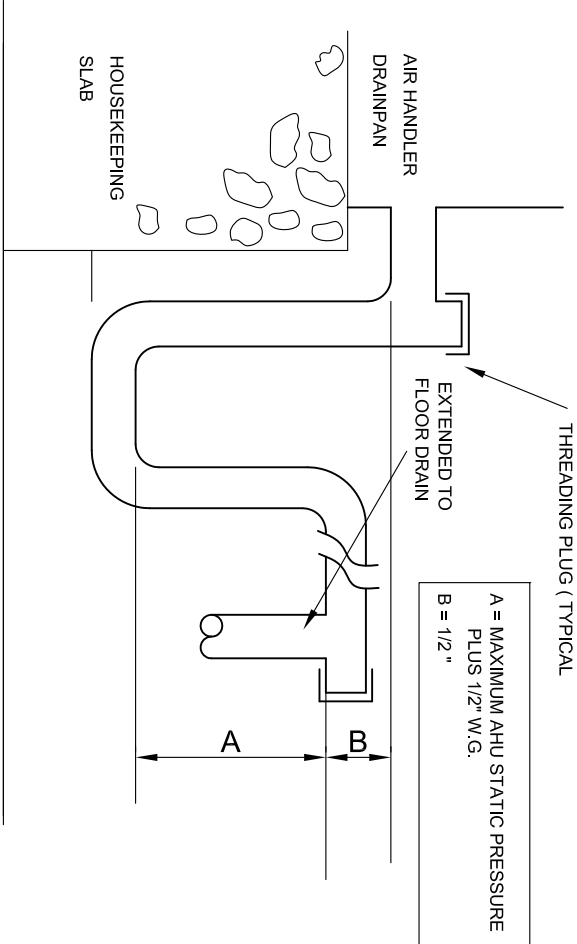

DRAIN TRAP FOR COIL SUBJECTED
TO POSITIVE PRESSURE

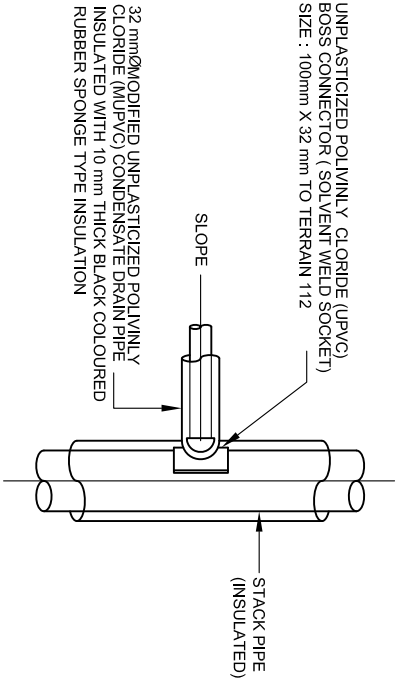

TYPICAL DETAIL OF A/C CONDENSATE DRAIN
PIPE CONNECTED TO UPVC STACK PIPE.



JASA KEPADA RAKYAT
CAWANGAN KEJURUTERAAN MEKANIKAL
Ibu Pejabat JKR Malaysia


AIR CONDITIONING SYSTEM

CONDENSATE DRAIN DETAIL

DATE 2017 SCALE N.T.S

DRAWING NUMBER CKM/STD/AC/P/PE/REV2017/15

NOTE:

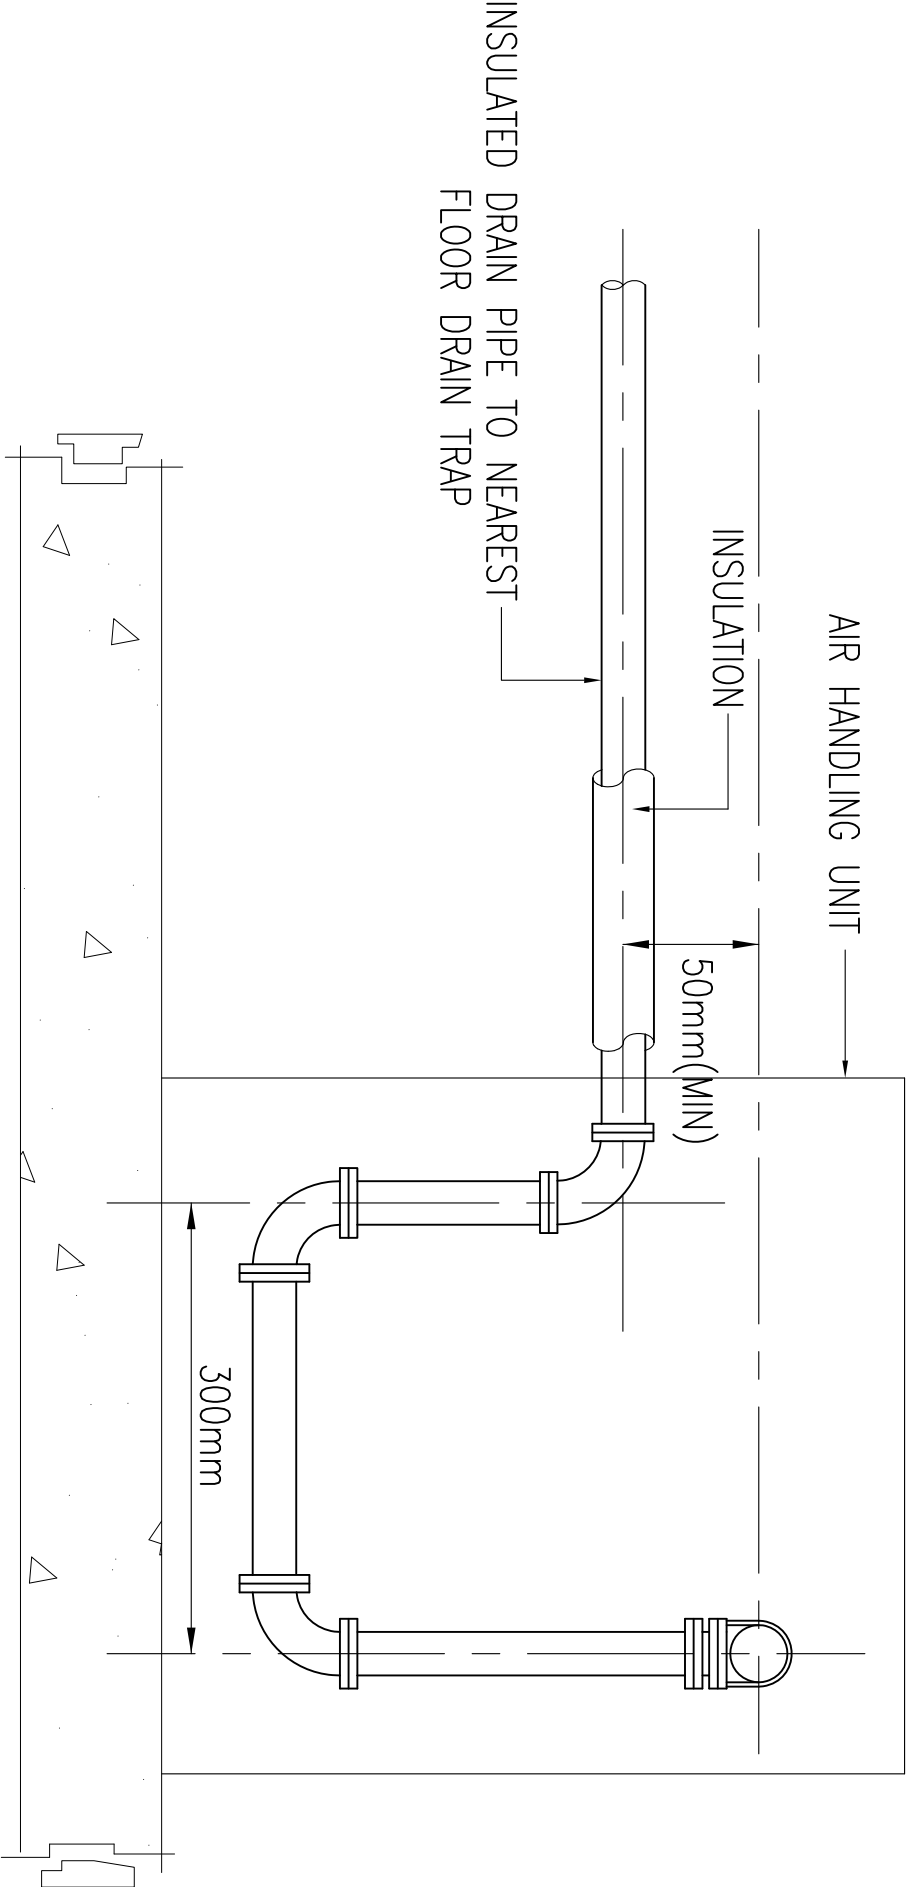

AHU/FCU CAPACITY (kW)	SIZE OF DRAIN PIPE (MM)
LESS 7 kW	19
7 TO 35	25
36 TO 106	32
107 TO 176	48
177 TO 616	50

CONDENSATE DRAIN DETAIL




JASA KEPADA RAKYAT
CAWANGAN KEJURUTERAAN MEKANIKAL
Ibu Pejabat JKR Malaysia

AIR CONDITIONING SYSTEM


CONDENSATE DRAIN DETAIL

DATE	SCALE
2017	N.T.S
DRAWING NUMBER	
CKM/STD/AC/P/PE/REV2017/16	


NOTE:

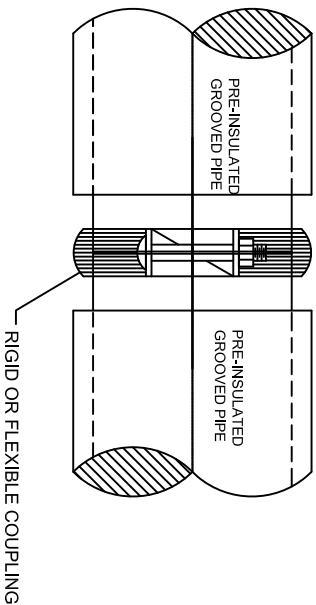


TYPICAL 65 mm TO 300 mm
CHW PIPE TO PIPE
CONNECTION

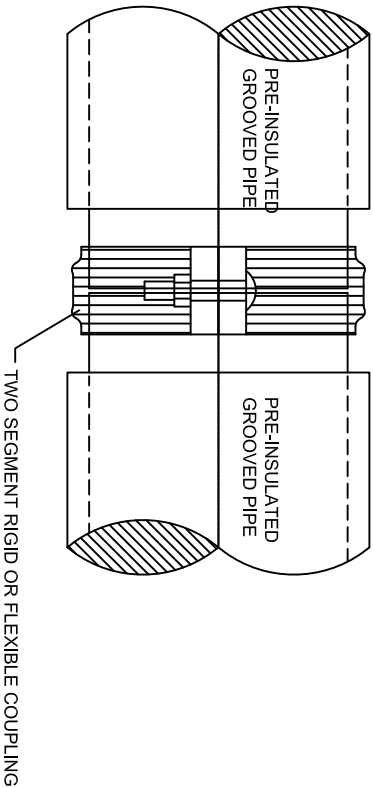



TYPICAL 350 mm AND ABOVE
CHW PIPE TO PIPE
CONNECTION

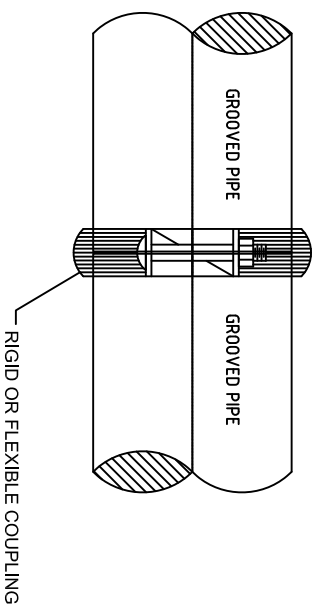


TYPICAL 65 mm TO 300 mm
CW PIPE TO PIPE
CONNECTION

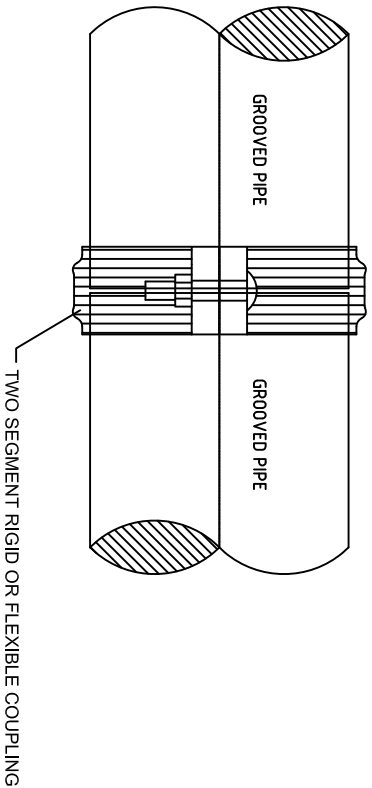

TYPICAL 350 mm AND ABOVE
CW PIPE TO PIPE
CONNECTION

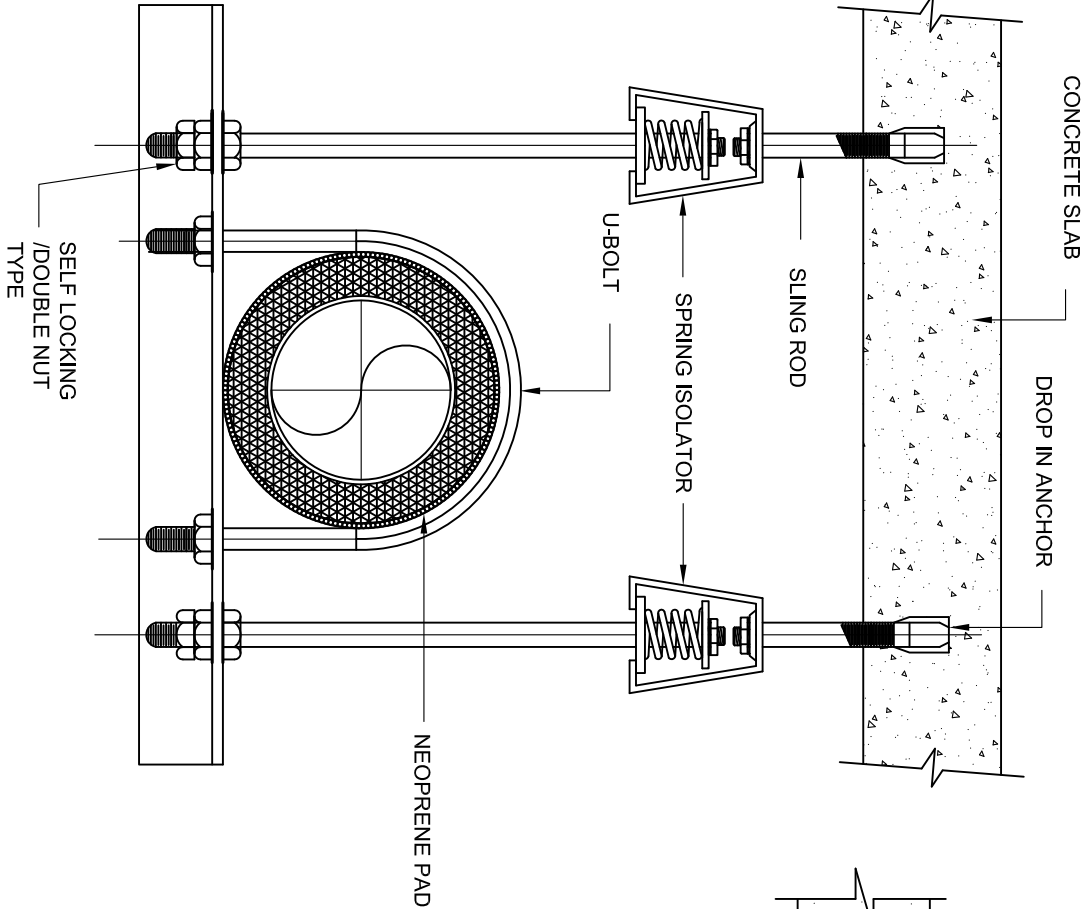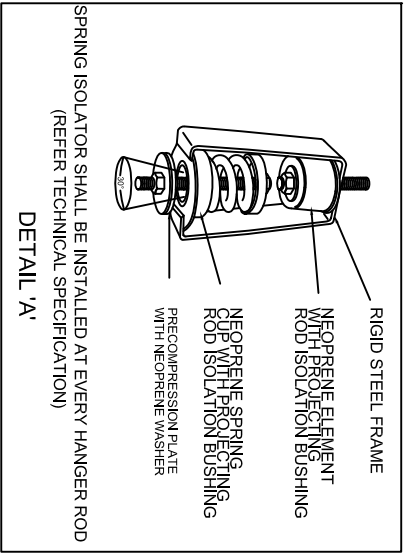

TYPICAL PIPE HANGER
(SINGLE PIPE)

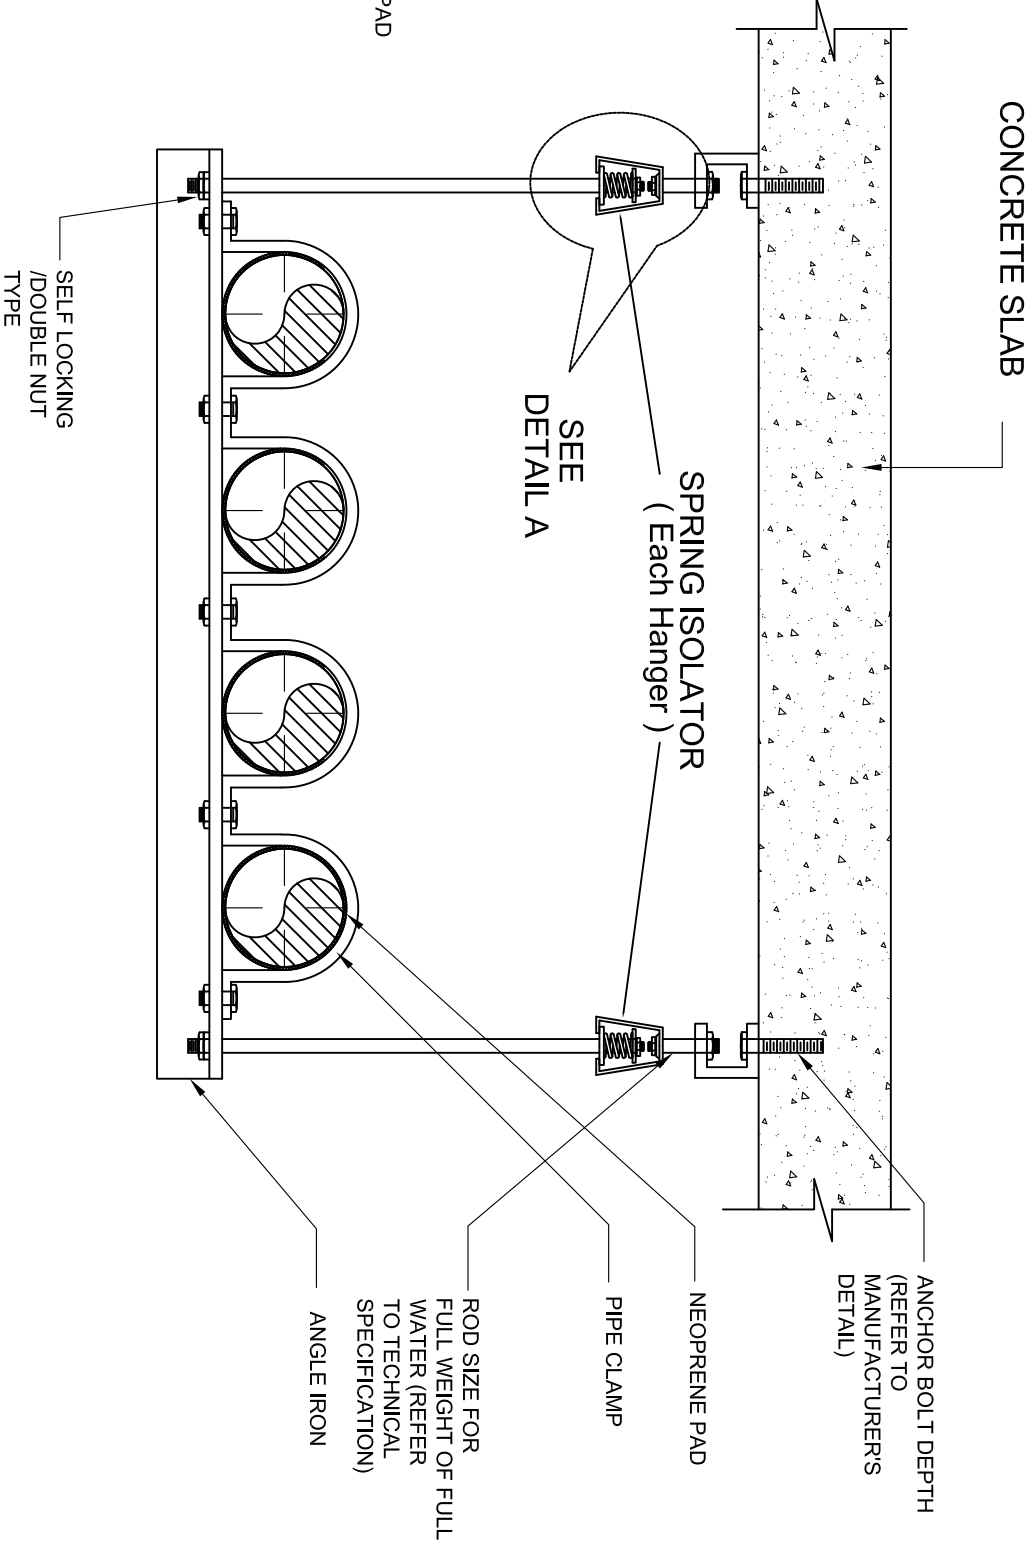

TYPICAL PIPE HANGER
(MORE THAN ONE PIPE)


PIPE HANGERS FOR INSULATED PIPE
INSIDE MECHANICAL ROOM

NOTE:



JASA KEPADA RAKYAT
CAWANGAN KEJURUTERAAN MEKANIKAL
Ibu Pejabat JKR Malaysia

AIR CONDITIONING SYSTEM	
PIPE HANGERS FOR INSULATED PIPE (INSIDE MECHANICAL ROOM)	
DATE	SCALE
2017	N1:5
DRAWING NUMBER	
CKM/STD/AC/PIPE/REV2017/02	

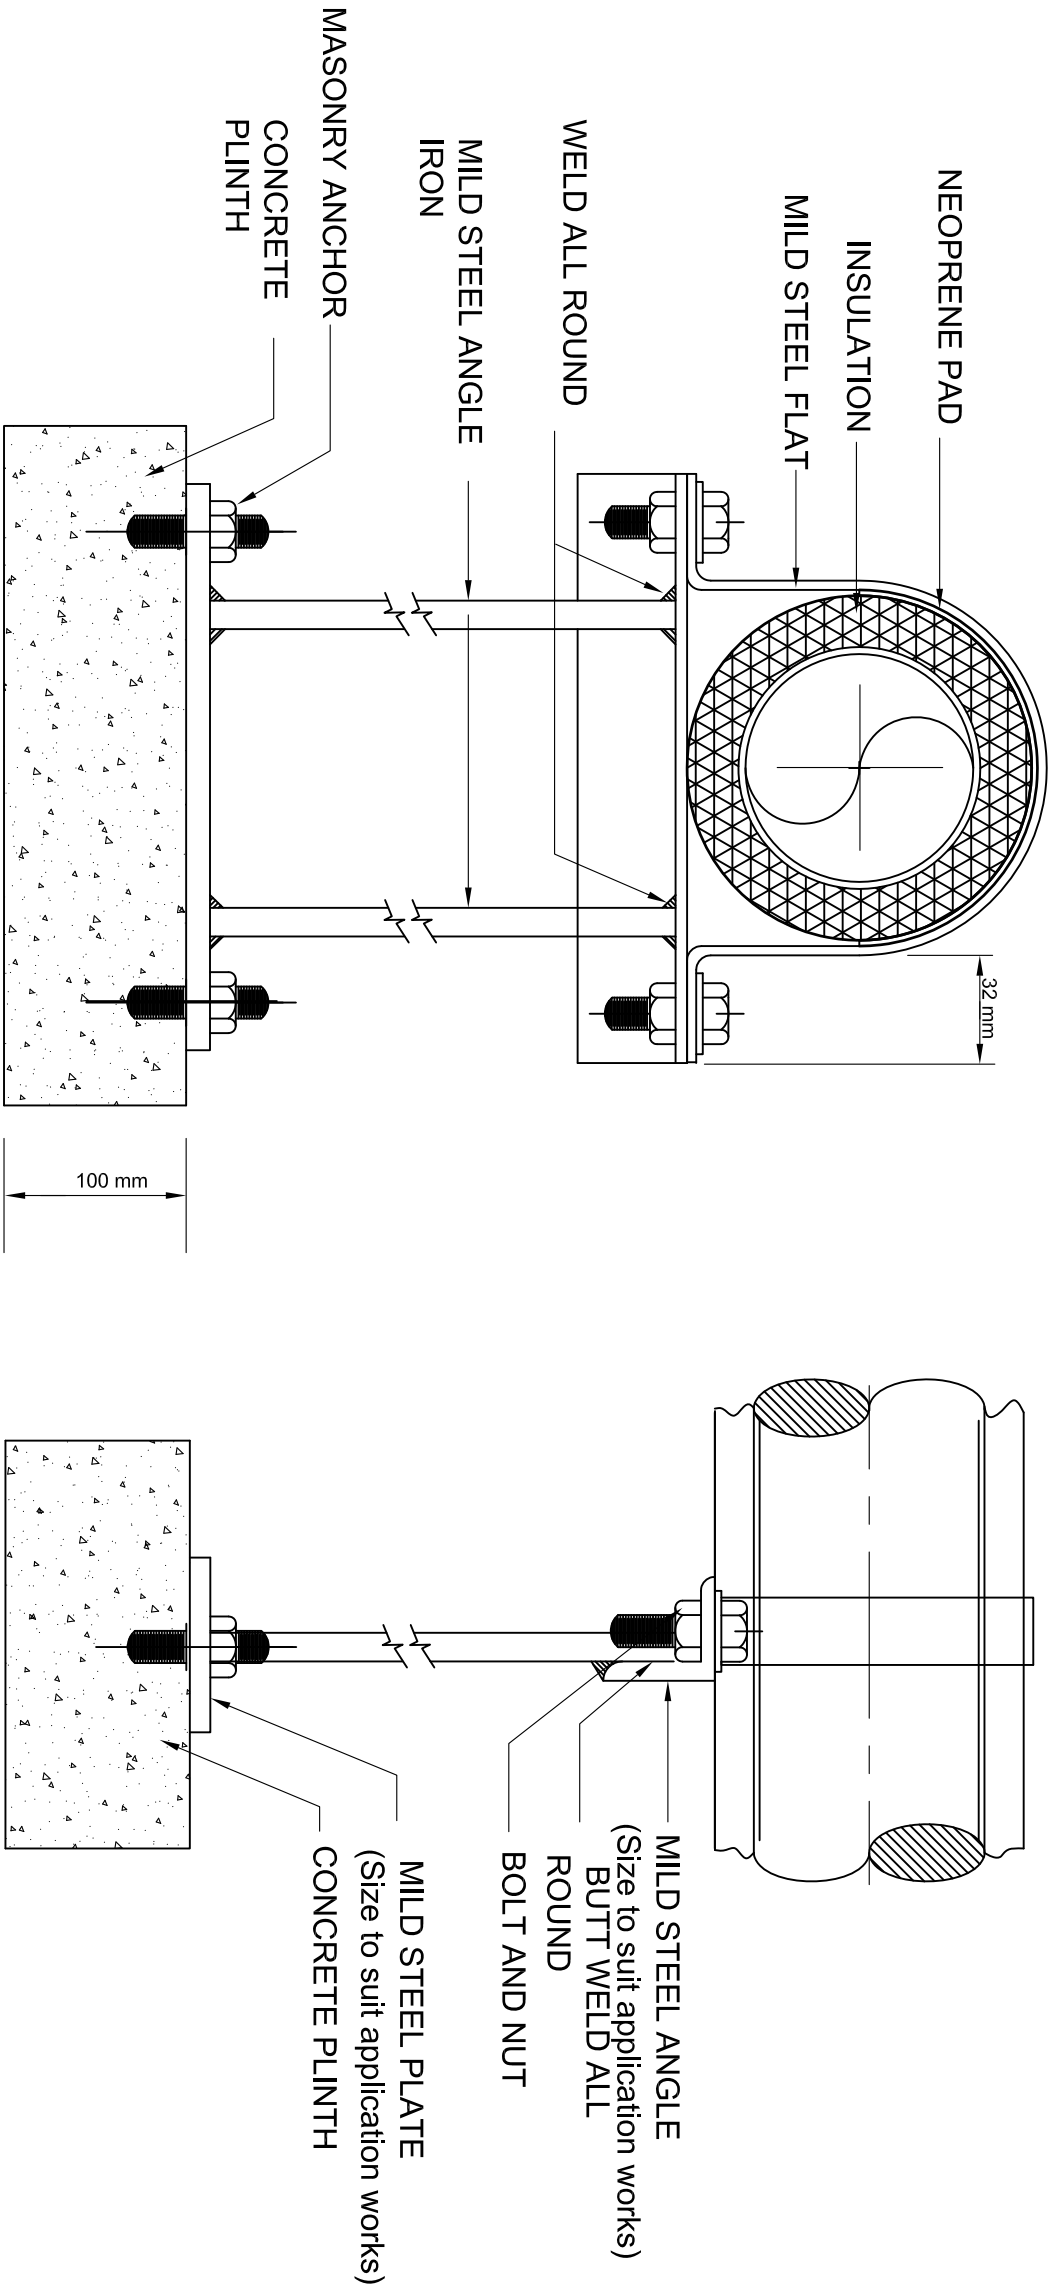

NOTE:



JASA KEPADA RAKYAT
CAWANGAN KEJURUTERAAN MEKANIKAL
Ibu Pejabat JKR Malaysia

AIR CONDITIONING SYSTEM

FLOOR MOUNTED PIPE SUPPORT
(OUTSIDE MECHANICAL ROOM)

DATE

2017


SCALE

N.T.S

DRAWING NUMBER

CKM/STD/AC/PIPE/REV/2017/03

NOTE:

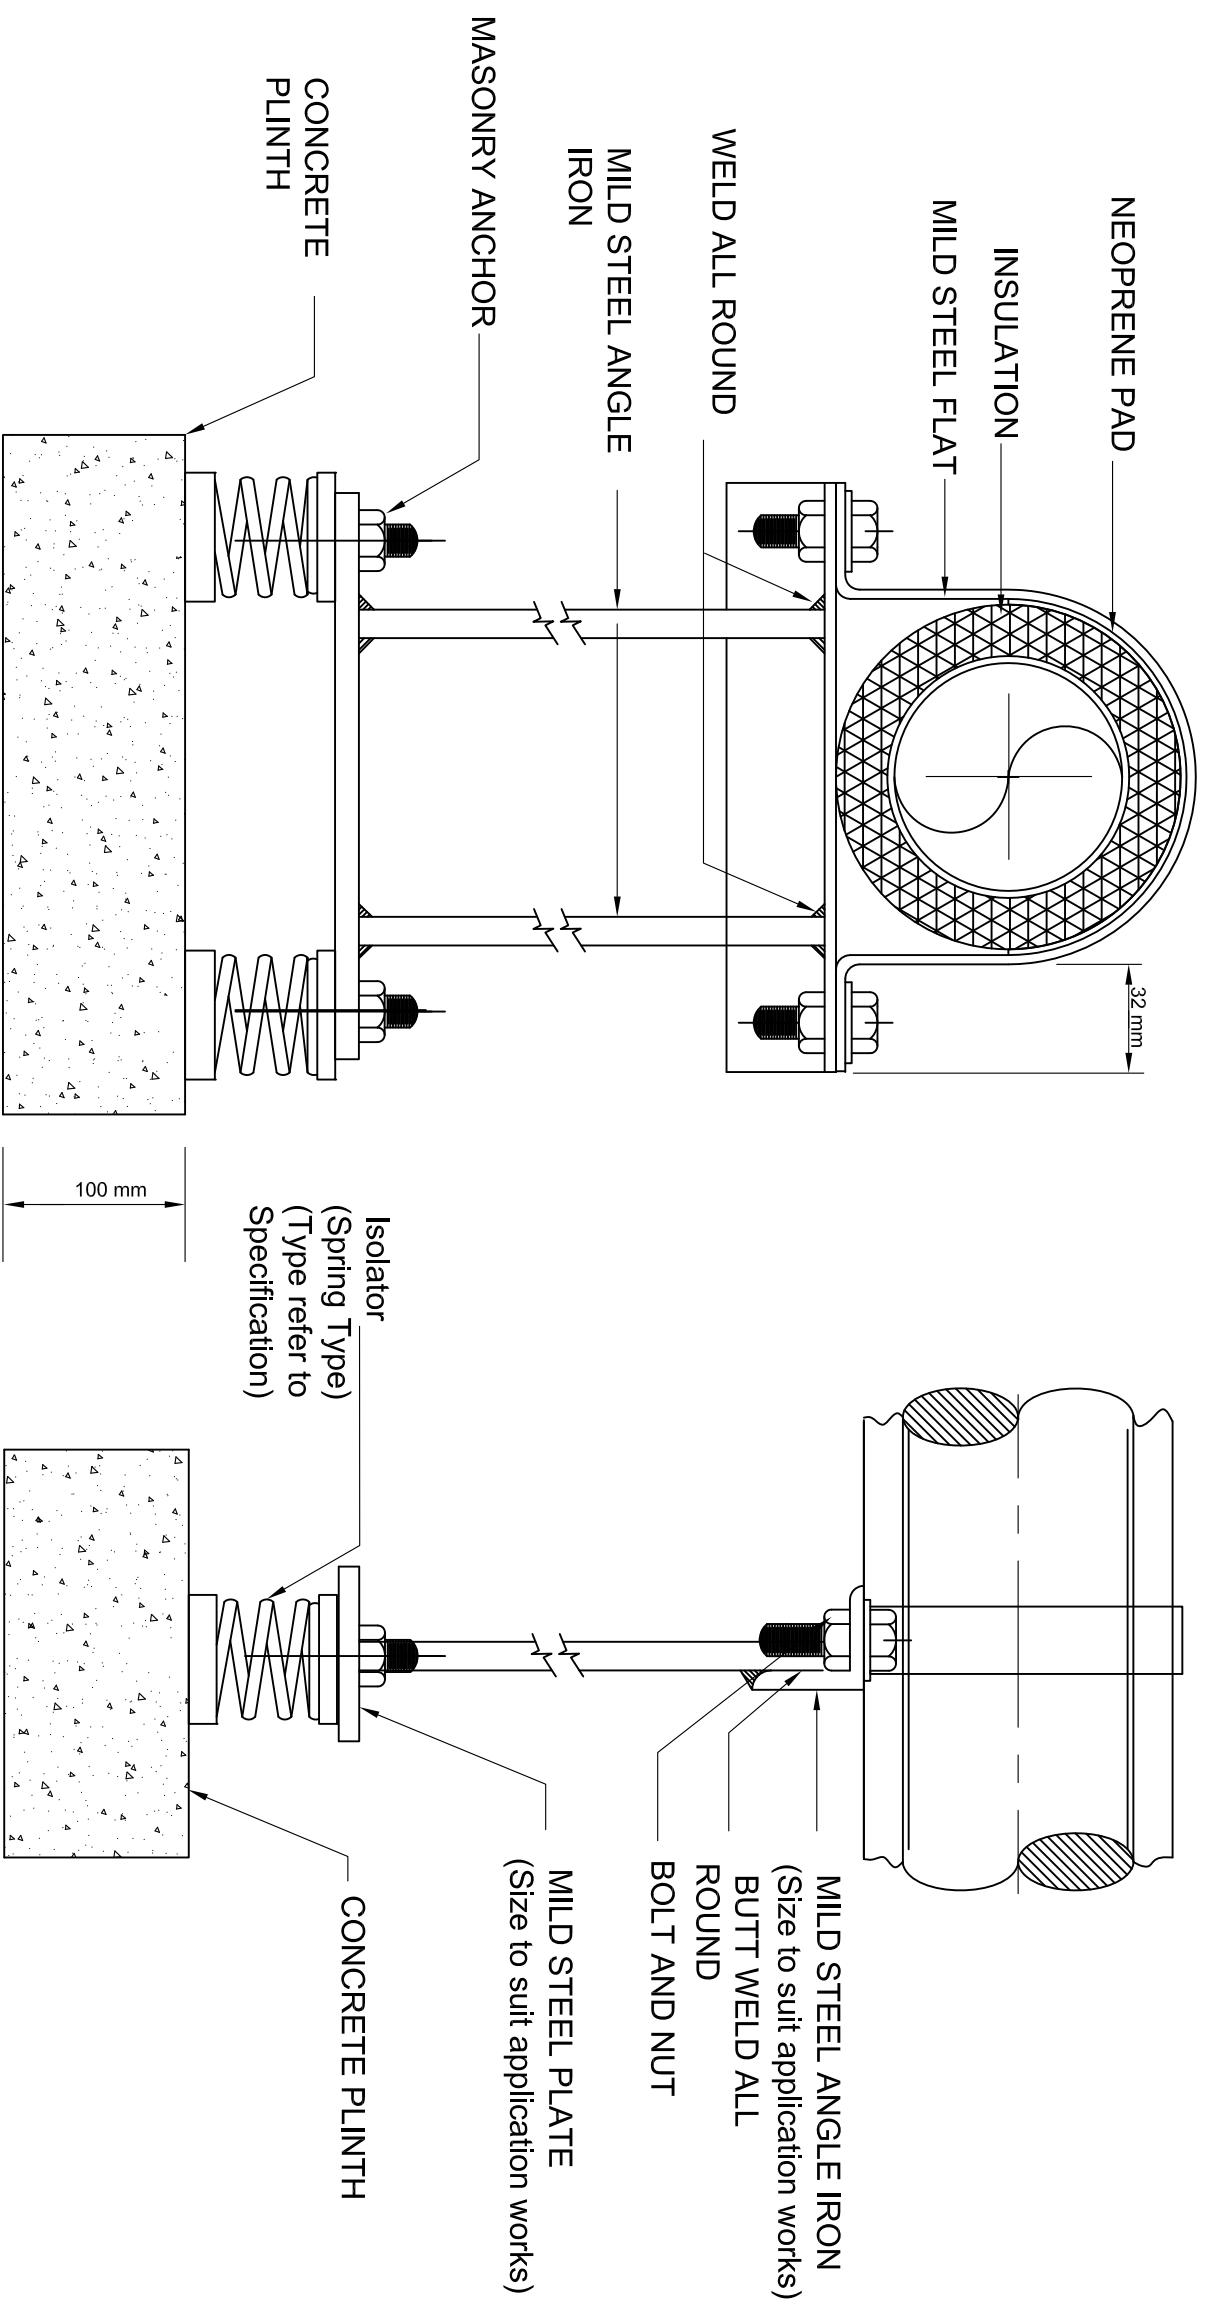

**FLOOR MOUNTED PIPE SUPPORT
(INSIDE MECHANICAL ROOM)**

AIR CONDITIONING SYSTEM

FLOOR MOUNTED PIPE SUPPORT (INSIDE MECHANICAL ROOM)

DATE _____

2017

SCALE


DRAWING NUMBER

CKM/STD/AC/PIPE/REV2017/04



JASA KEPADA RAKYAT

CAWANGAN KEJURUTERAAN MEKANIKAL
Ibu Pejabat JKR Malaysia

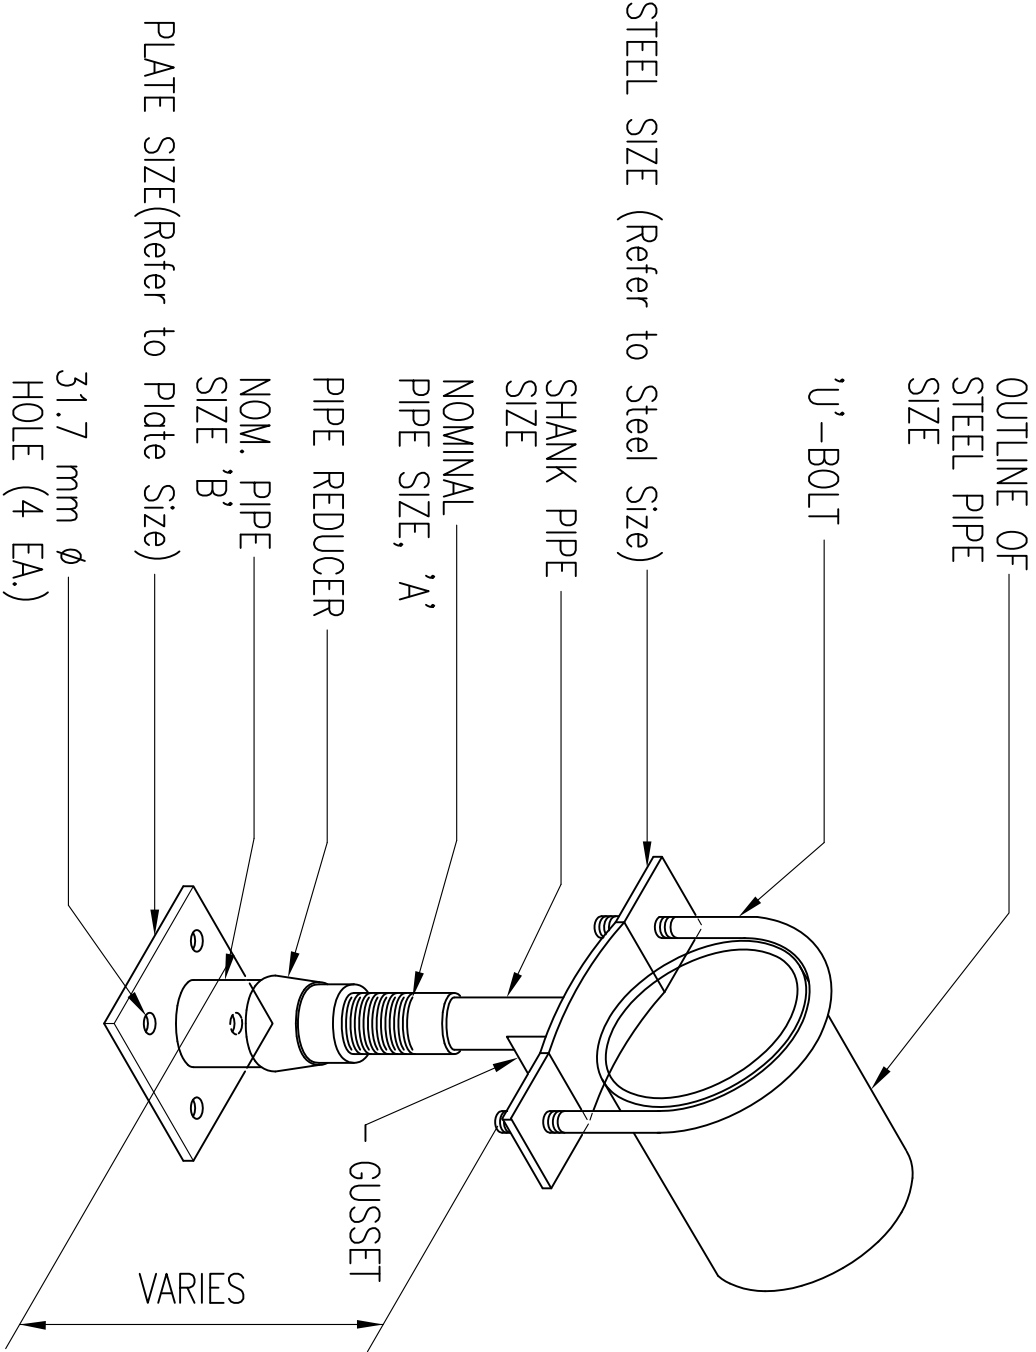

NOTE :

1. MATERIAL – STEEL PIPE / MALLEABLE IRON

PIPE SUPPORT SCHEDULE (mm)						
STL. PIPE SIZE	' A '	' B '	STEEL SIZE	' U ' BOLT	PLATE SIZE	SHANK PIPE SIZE
100 (4")	65	80	9.5x88.9	15	9.5x203 x 203.2	60.3
150 (6")	65	80	12.7x88.9	16	- D0 -	60.3
200 (8")	65	80	12.7x88.9	16	- D0 -	60.3
250 (10")	65	80	12.7x88.9	20	- D0 -	60.3
300 (12")	65	80	12.7x88.9	22	- D0 -	60.3

PIPE SADDLE WITH 'U'-BOLT

NOTE:



JASA KEPADA RAKYAT
CAWANGAN KEJURUTERAAN MEKANIKAL
Ibu Pejabat JKR Malaysia

AIR CONDITIONING SYSTEM



PIPE SADDLE WITH 'U' - BOLT

DATE 2017 SCALE N.T.S

DRAWING NUMBER



CKM/STD/AC/P/PE/REV2017/05

NOTE:

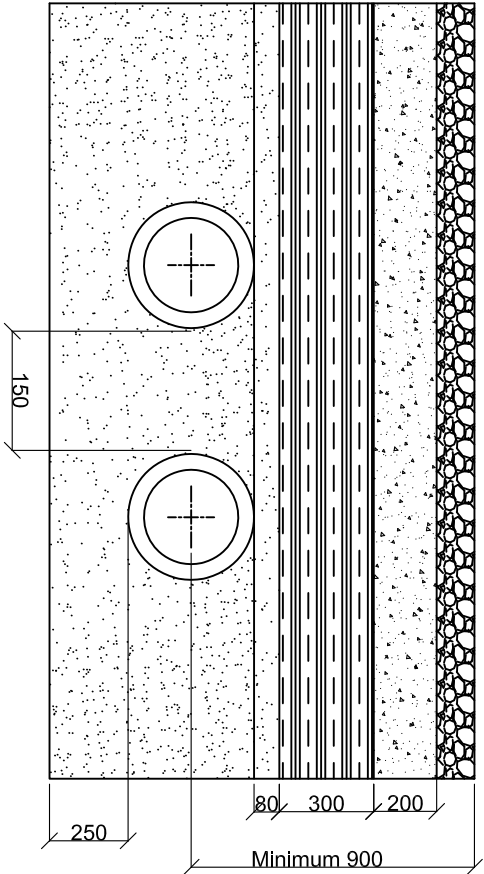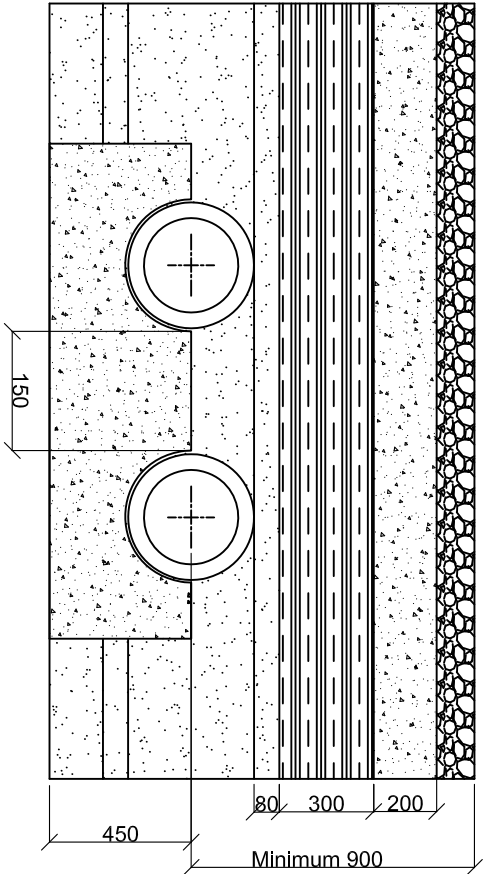

CROSS SECTION OF UNDERGROUND PIPES

PIPES BURIED UNDER THE ROAD

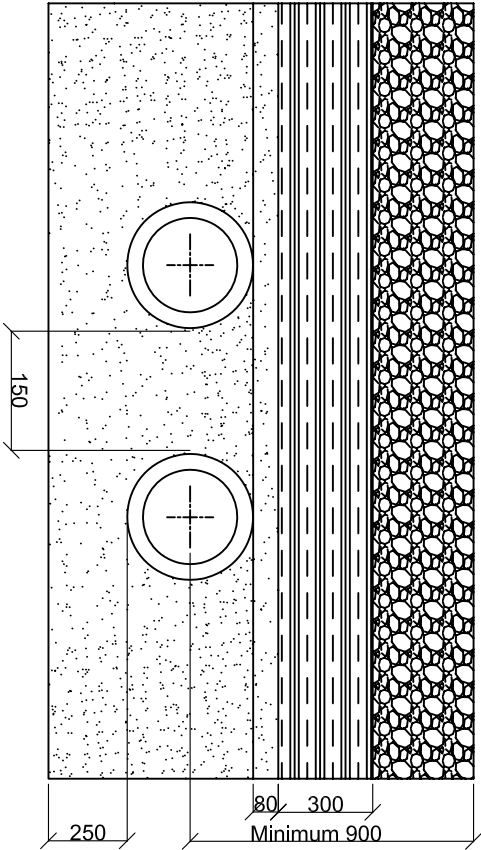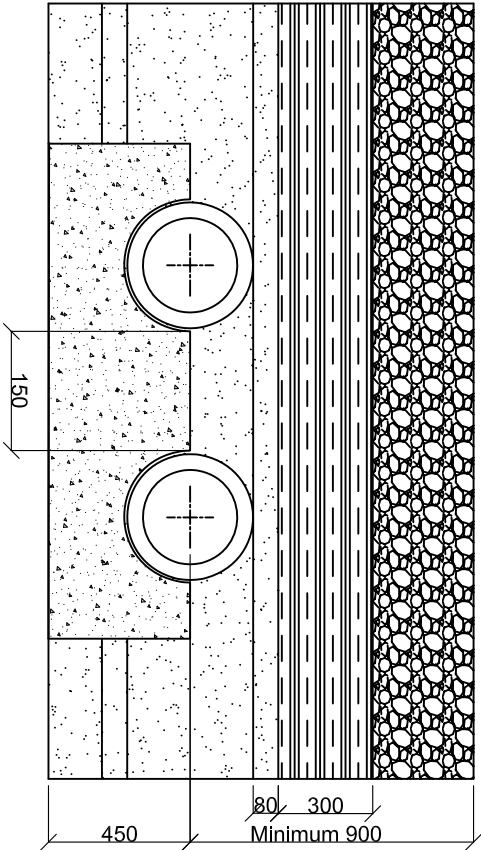

CROSS SECTION OF UNDERGROUND PIPES

PIPES BURIED UNDERGROUND (OTHER THAN UNDER THE ROAD)

LEGEND	
	AVAILABLE MATERIAL
	ROCK-FREE BACKFILL
	SAND BACKFILL
	CONCRETE

NOTE:



DETAIL OF UNDERGROUND PIPE BRACKET



AIR CONDITIONING SYSTEM


UNDERGROUND PIPE INSULATION
JOINT AND SUPPORT

DATE	SCALE
2017	N.T.S


DRAWING NUMBER

CMM/STD/AC/PIPE/REV/2017/07

NOTE:

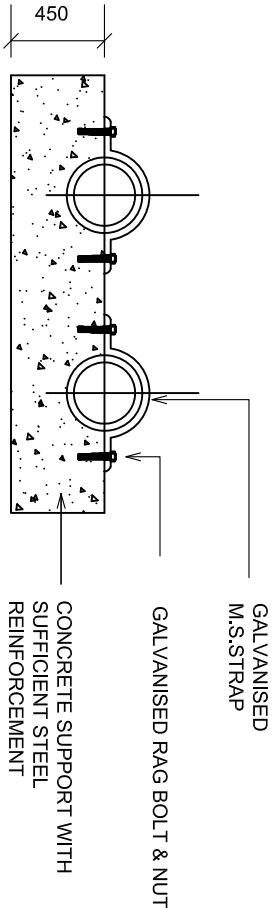

END VIEW

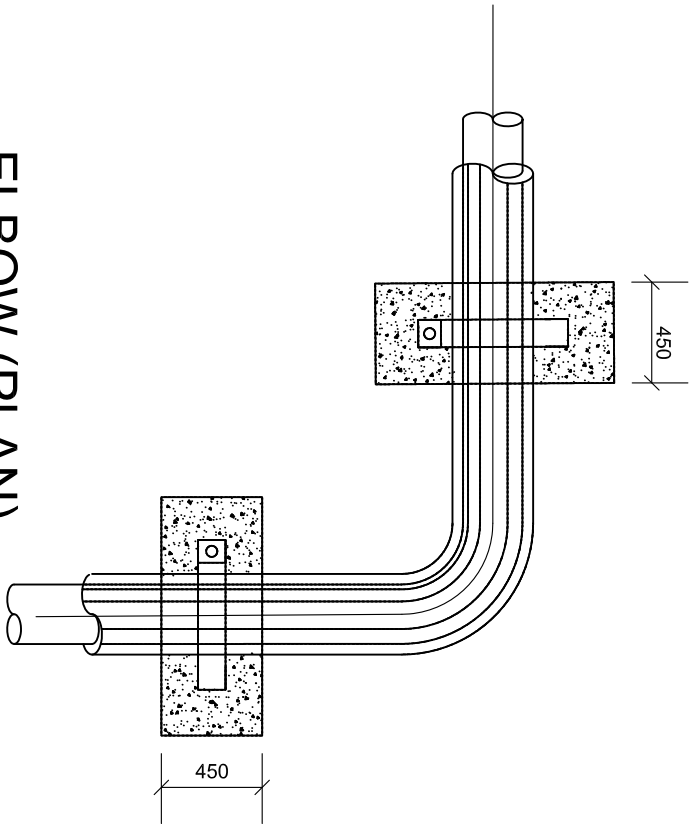

ELBOW (PLAN)

DETAIL DRAWING PRE-INSULATED PIPE BURIED UNDERGROUND





JASA KEPADA RAKYAT
CAWANGAN KEJURUTERAAN MEKANIKAL
Ibu Pejabat JKR Malaysia

AIR CONDITIONING SYSTEM

DETAIL DRAWING PRE-INSULATION PIPE
BURIED UNDERGROUND


DATE 2017 SCALE N.T.S

DRAWING NUMBER
CKM/STD/AC/PIPE/REV2017/08

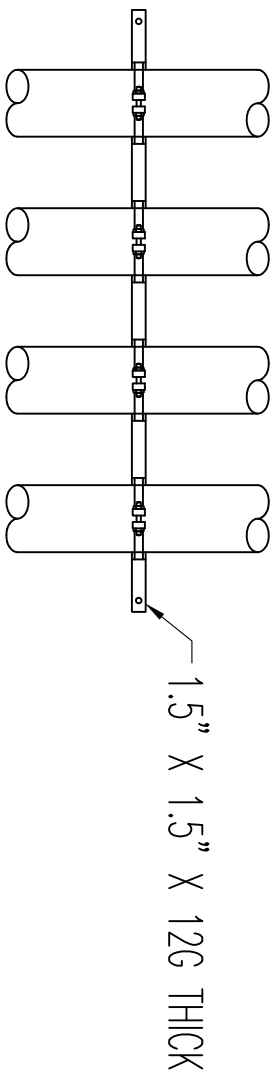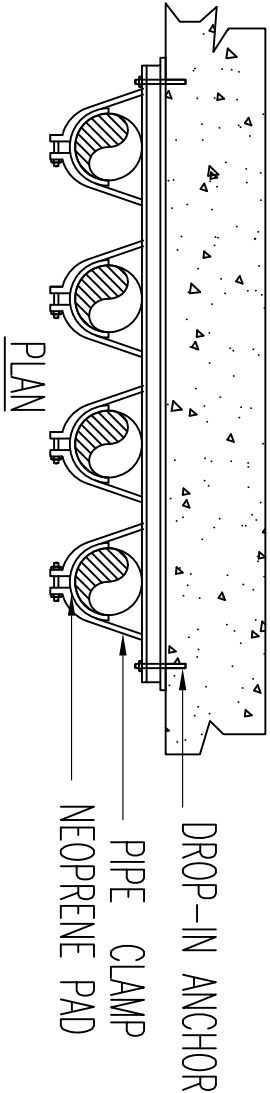

PIPE SIZE (MM)	ANCHOR SIZE (MM)
20	10
25	10
32	10
40	10
50	13
60	13
75	13
90	13
100	13
130	13
150	13


RISER PIPES BRACKET FOR HORIZONTAL PIPES

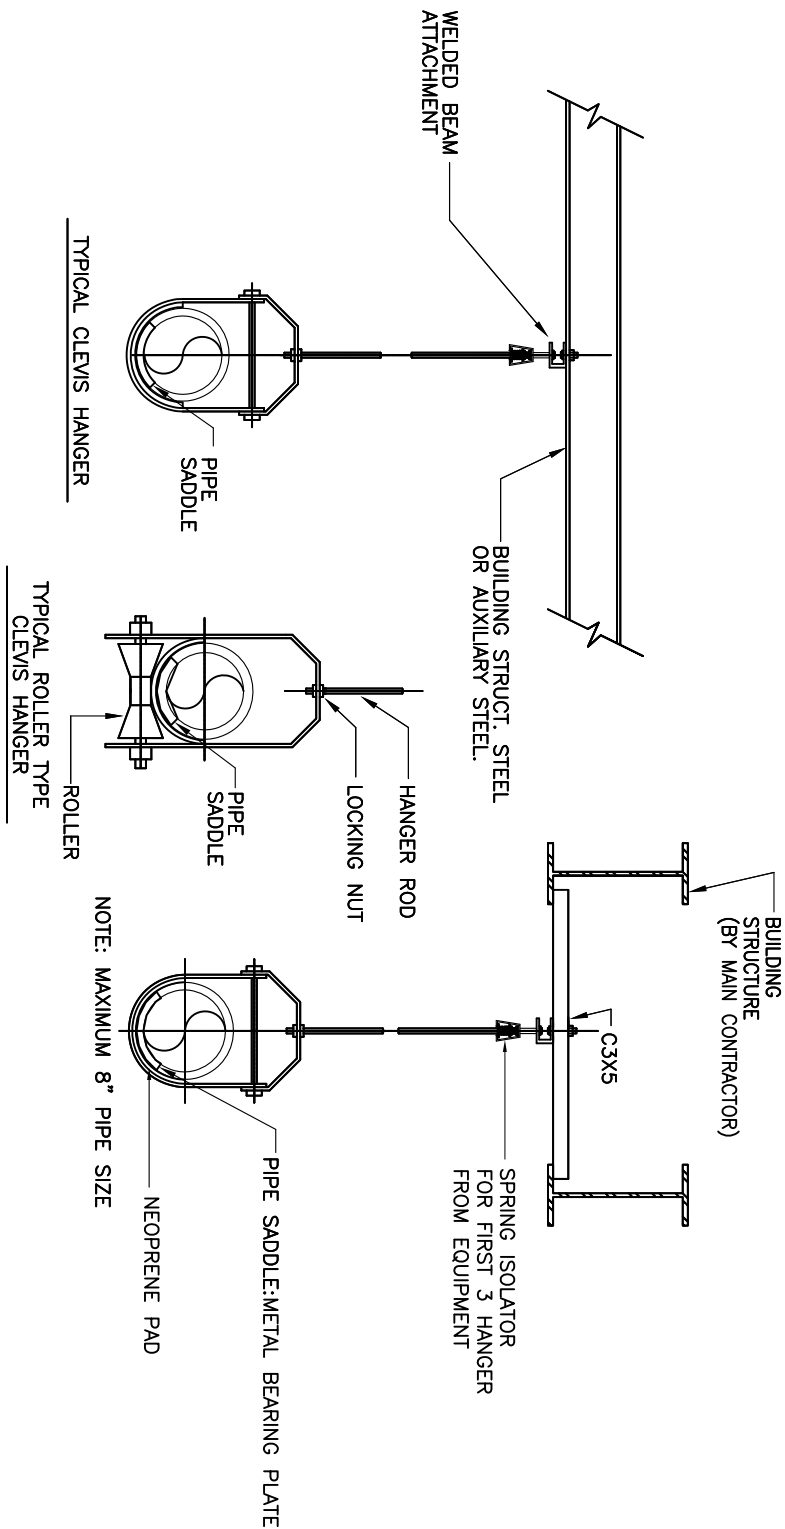





DETAIL - PIPE HANGER TYPES

NOTE:

AIR HANDLING UNIT

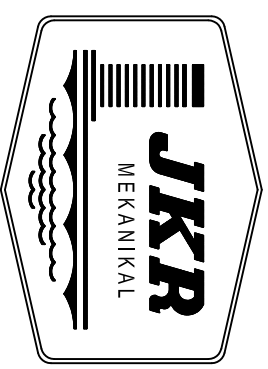


JASA KEPADA RAKYAT

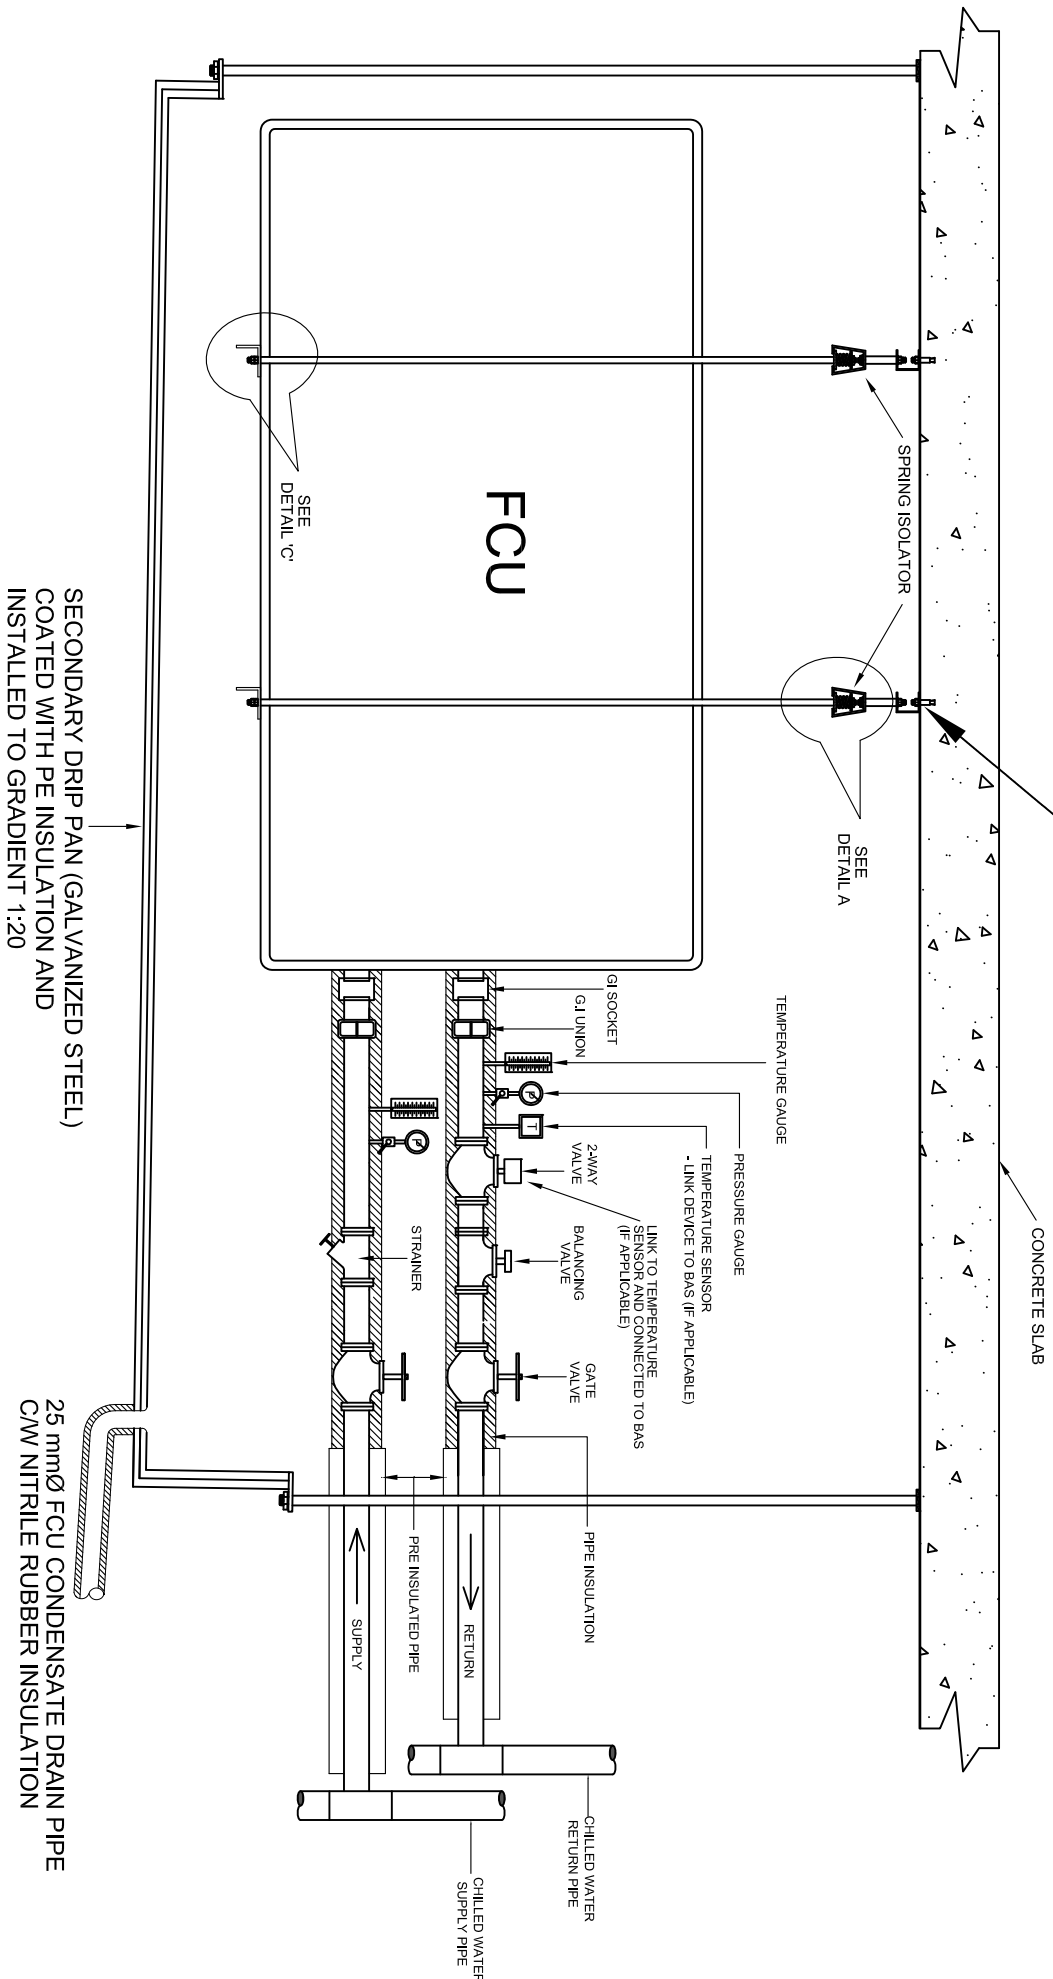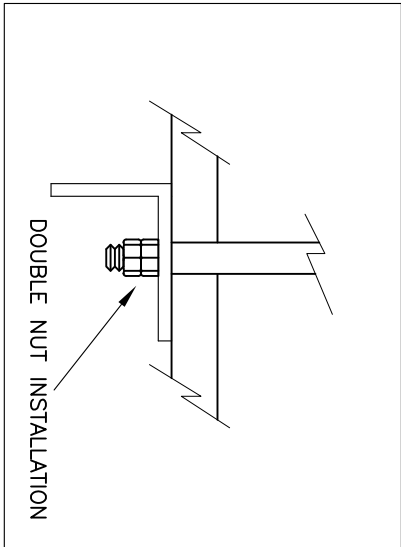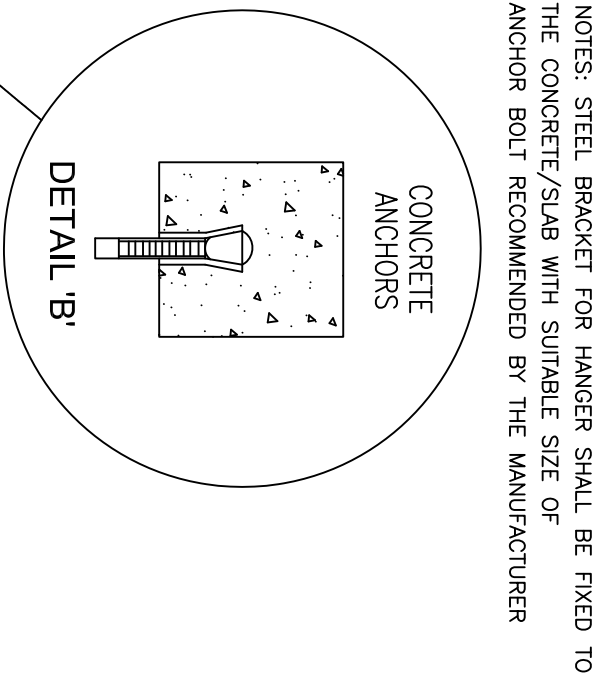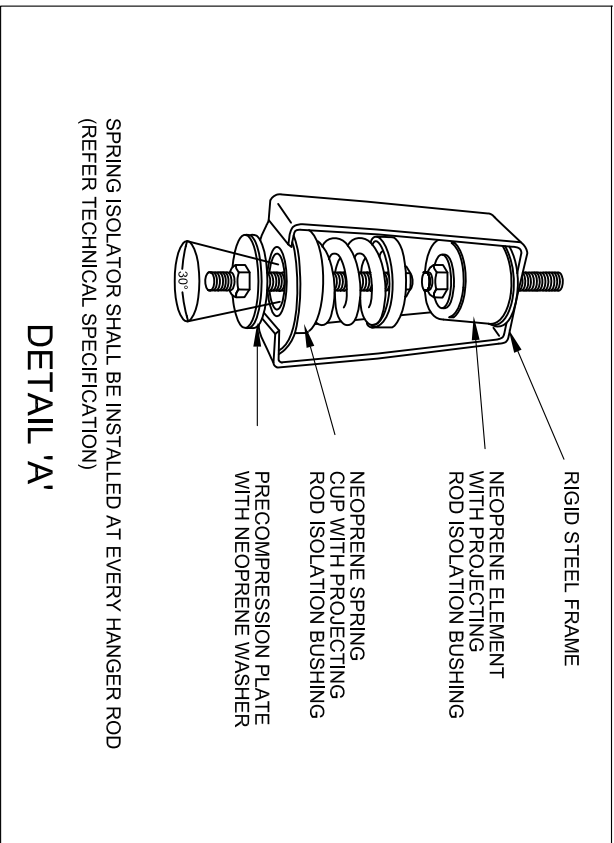

TYPICAL FAN COIL UNIT (FCU) PIPING CONNECTION USING 2-WAY VALVE

NOTE:

PETUNJUK

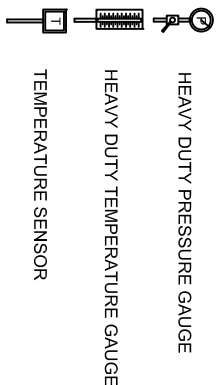

JASA KEPADA RAKYAT

CAWANGAN KEJURUTERAAN MEKANIKAL
Ibu Pejabat JKR Malaysia

AIR CONDITIONING SYSTEM

TYPICAL FCU CONNECTION USING 2-WAY VALVE

DATE

2017

SCALE

N.T.S

DRAWING NUMBER

CKMSTD/AC/AHU/REV2017/01

NOTE:



Ibu Pejabat JKR Malaysia

AIR CONDITIONING SYSTEM

DETAILS OF CONDENSATE DRAIN

DATE	SCALE
------	-------

Q. No.	Answer
7	N.T.S

DRAWING NUMBER


CKM/STD/AC/AHU/REV2017/10

NOTE:

PETUNJUK


-  HEAVY DUTY PRESSURE GAUGE
-  HEAVY DUTY TEMPERATURE GAUGE
-  TEMPERATURE SENSOR

NOTES: STEEL BRACKET FOR HANGER SHALL BE FIXED TO THE CONCRETE/SLAB WITH SUITABLE SIZE OF ANCHOR BOLT RECOMMENDED BY THE MANUFACTURER

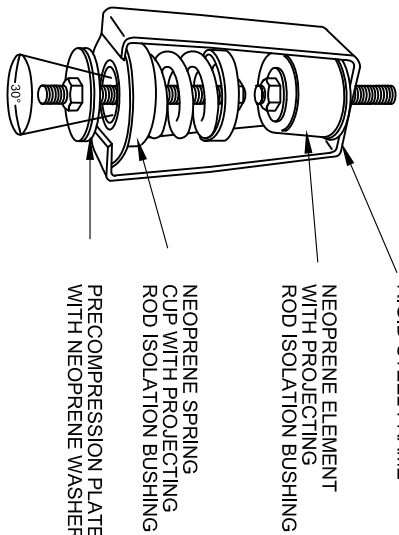


SPRING ISOLATOR SHALL BE INSTALLED AT EVERY HANGER ROD (REFER TECHNICAL SPECIFICATION)

DETAIL 'A'

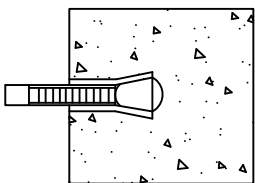


DETAIL 'B'

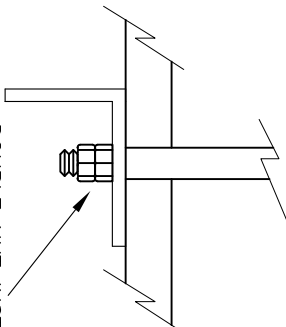

DOUBLE NUT INSTALLATION

DETAIL 'C'

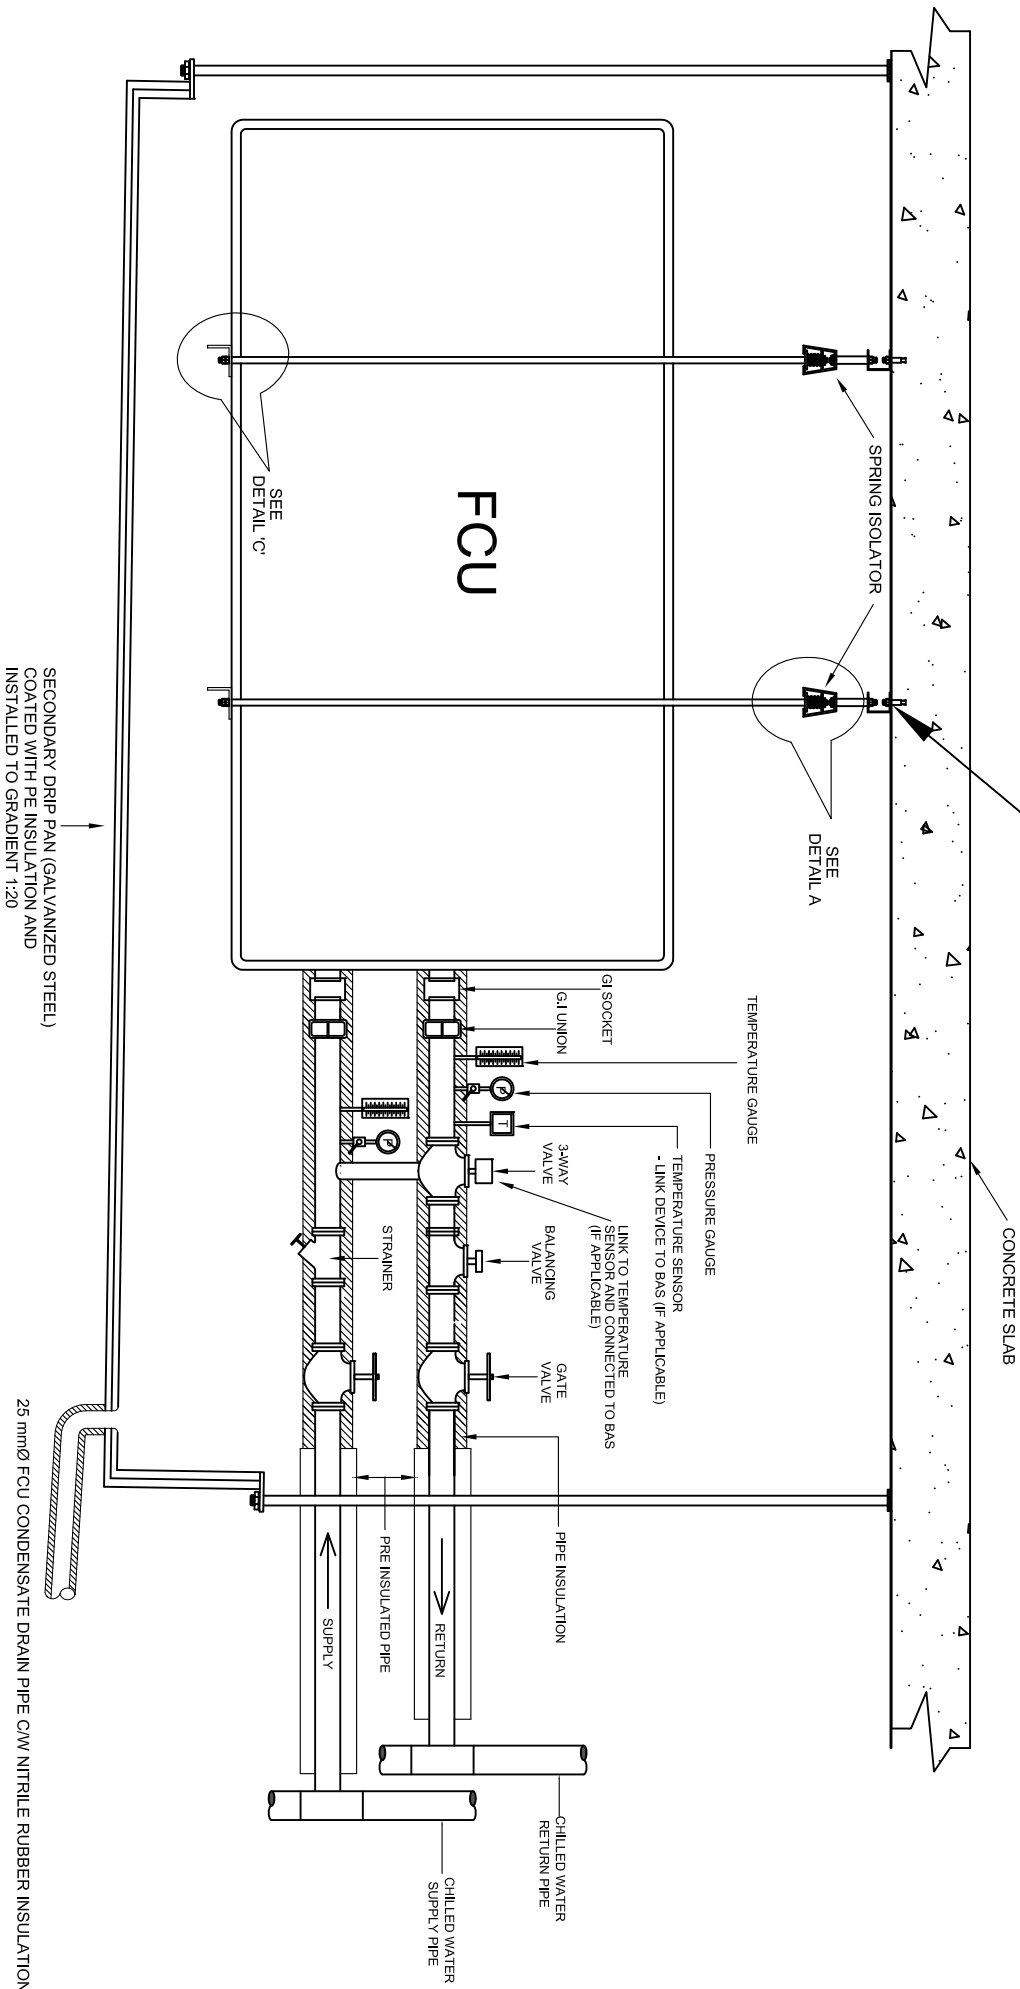

TYPICAL CONNECTION USING 3-WAY VALVE FOR FAN COIL UNIT(FCU) IN EVERY BRANCH



JASA KEPADA RAKYAT

CAWANGAN KEJURUTERAAN MEKANIKAL
Ibu Pejabat JKR Malaysia


AIR CONDITIONING SYSTEM

TYPICAL FCU CONNECTION USING 3-WAY VALVE

DATE 2017 SCALE N.T.S


DRAWING NUMBER CKMSTD/AC/AHU/REV2017/02

NOTE:
COOLING COIL SHALL BE SIZED WITH THE FACE
MAXIMUM VELOCITY OF 550 FPM.

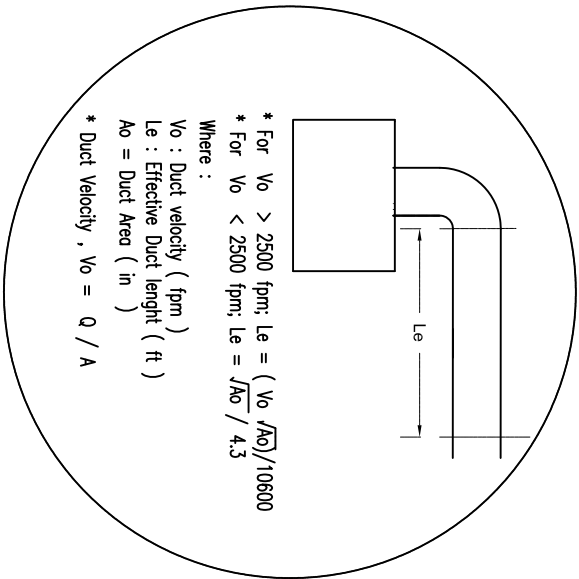

NOTE :
THE LENGTH OF INTERNAL INSULATION SHALL BE
TAKEN AS 5 METER FROM THE FAN OUTLET OR 1 METER
BEYOND THE FIRST BEND, WHICHEVER IS THE LONGEST

ALL AHU & FCU SHALL HAVE MINIMUM STRAIGHT DUCT LENGTH OF
OF 2½ TIMES DUCT DIAMETER OR LONGEST SIDE FOR RECTANGULAR DUCT
AFTER THE FAN OUTLET BEFORE ANY BEND.

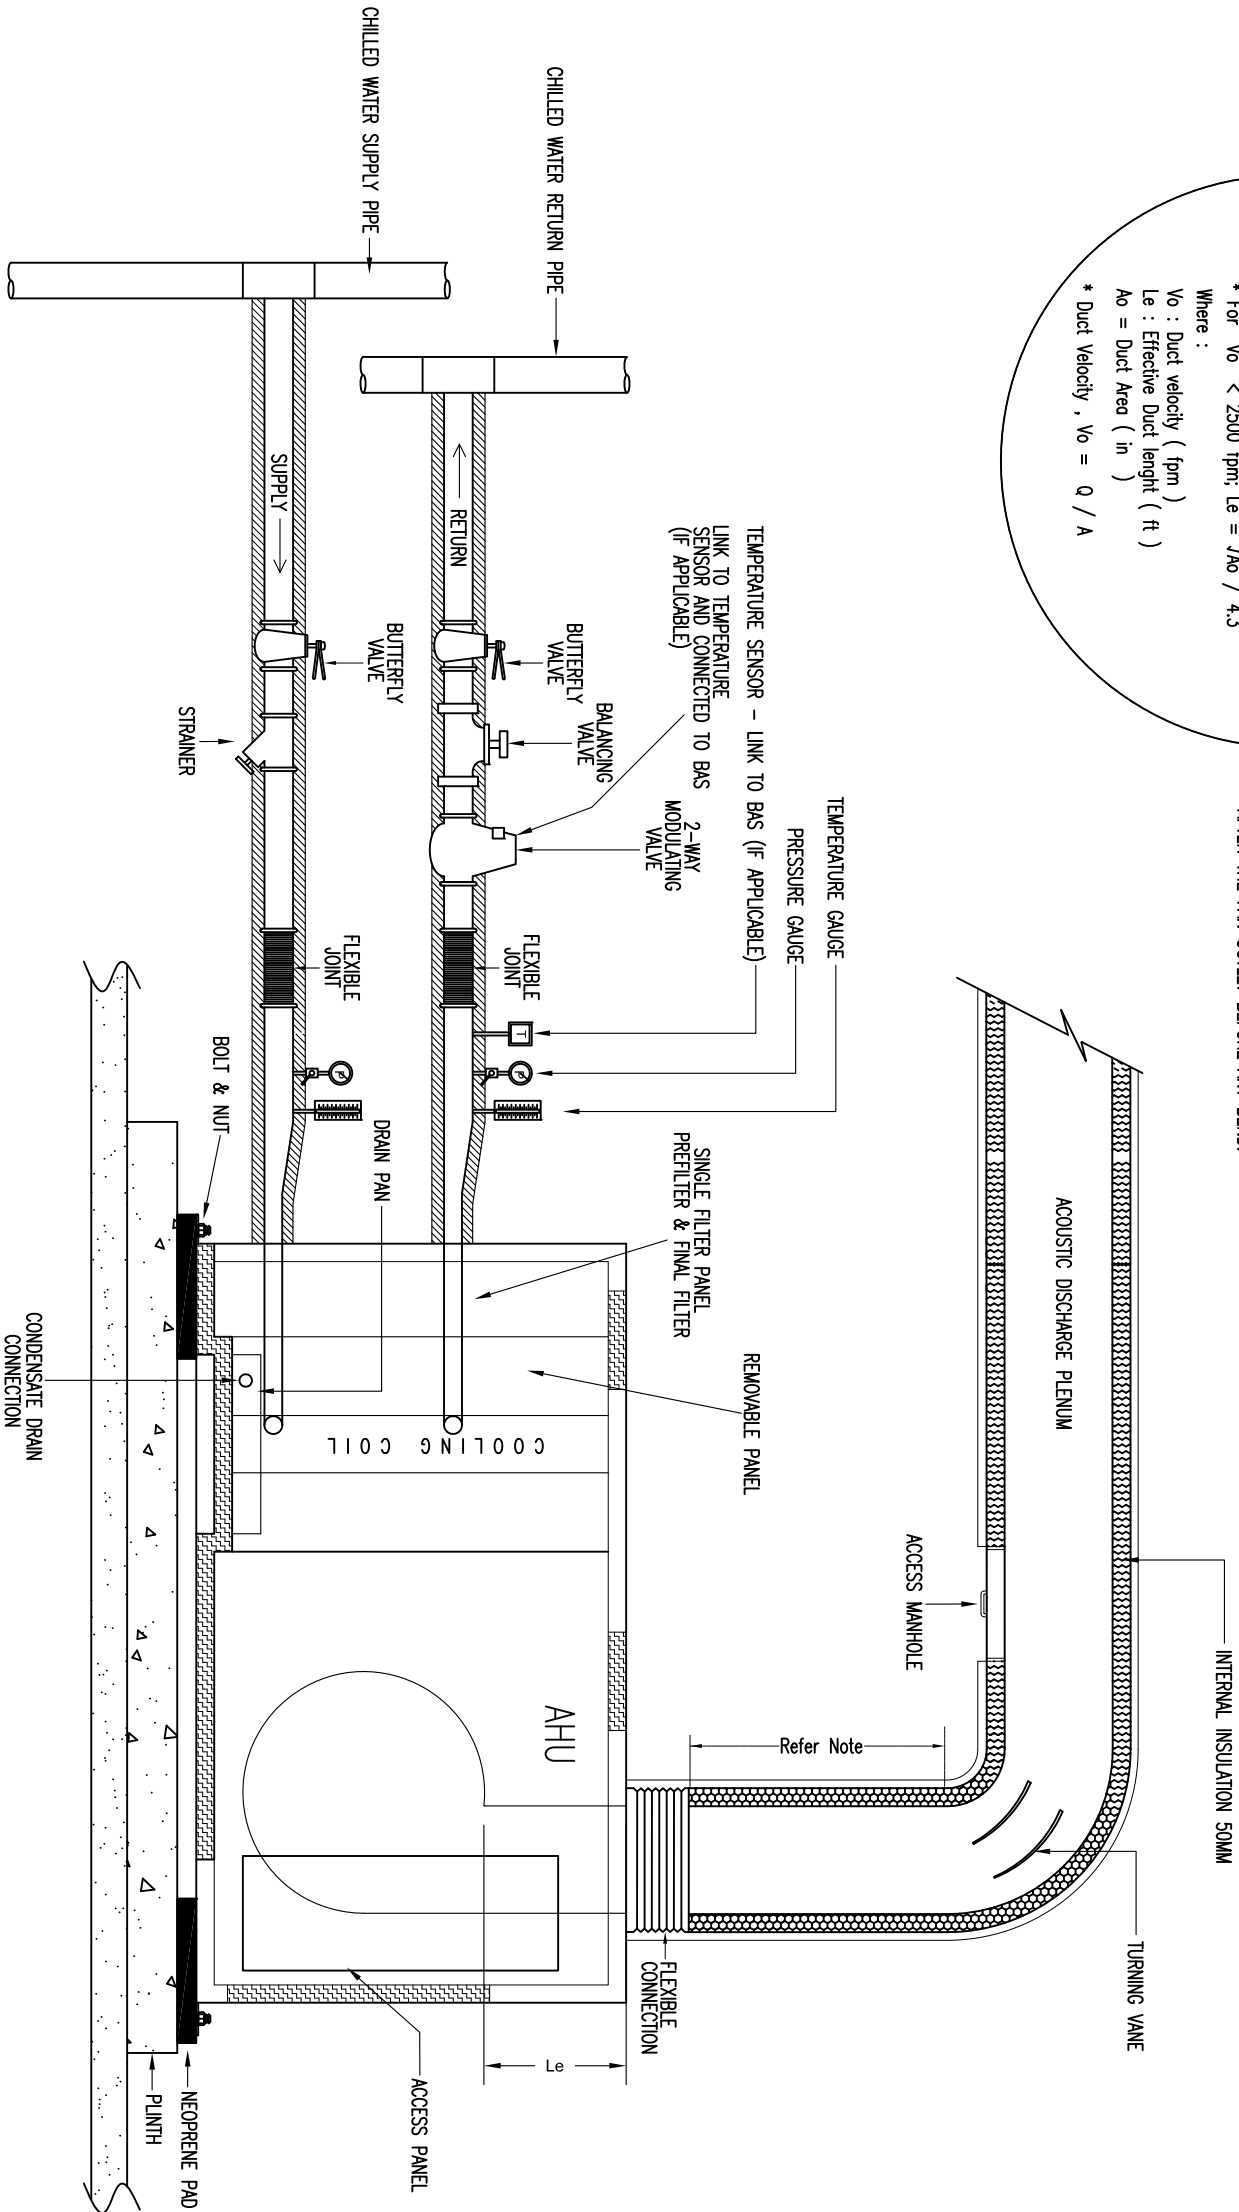

NOTE:

PETUNJUK

- HEAVY DUTY PRESSURE GAUGE
- HEAVY DUTY TEMPERATURE GAUGE
- TEMPERATURE SENSOR



JASA KEPADA RAKYAT
CAWANGAN KEJURUTERAAN MEKANIKAL
Ibu Pejabat JKR Malaysia

AIR CONDITIONING SYSTEM

TYPICAL AHU CONNECTION USING 2 WAY VALVE

DATE

2017


SCALE

N.T.S

DRAWING NUMBER

CKM/STD/AC/AHU/REV2017/03


NOTE:
COOLING COIL SHALL BE SIZED WITH THE FACE
MAXIMUM VELOCITY OF 550 FPM.

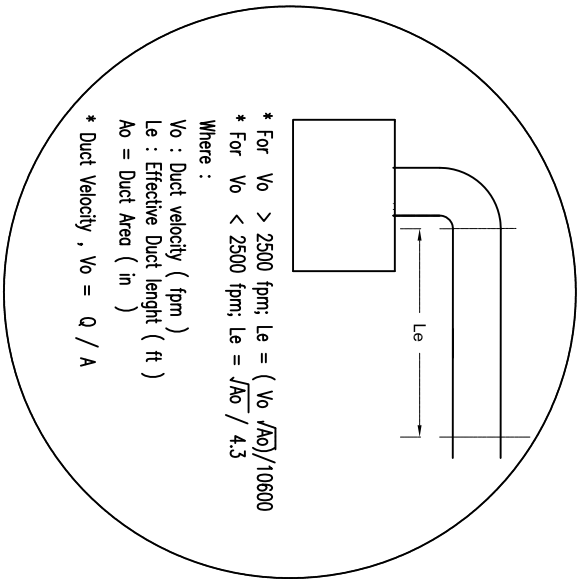

* For $V_o > 2500$ fpm; $Le = (V_o / \sqrt{A_o}) / 10600$
* For $V_o < 2500$ fpm; $Le = \sqrt{A_o} / 4.3$
Where :
 V_o : Duct velocity (fpm)
 Le : Effective Duct length (ft)
 A_o = Duct Area (in)
* Duct Velocity , $V_o = Q / A$

NOTE :
THE LENGTH OF INTERNAL INSULATION SHALL BE
TAKEN AS 5 METER FROM THE FAN OUTLET OR 1 METER
BEYOND THE FIRST BEND, WHICHEVER IS THE LONGEST

ALL AHU & FCU SHALL HAVE MINIMUM STRAIGHT DUCT LENGTH OF
OF 2½ TIMES DUCT DIAMETER OR LONGEST SIDE FOR RECTANGULAR DUCT
AFTER THE FAN OUTLET BEFORE ANY BEND.

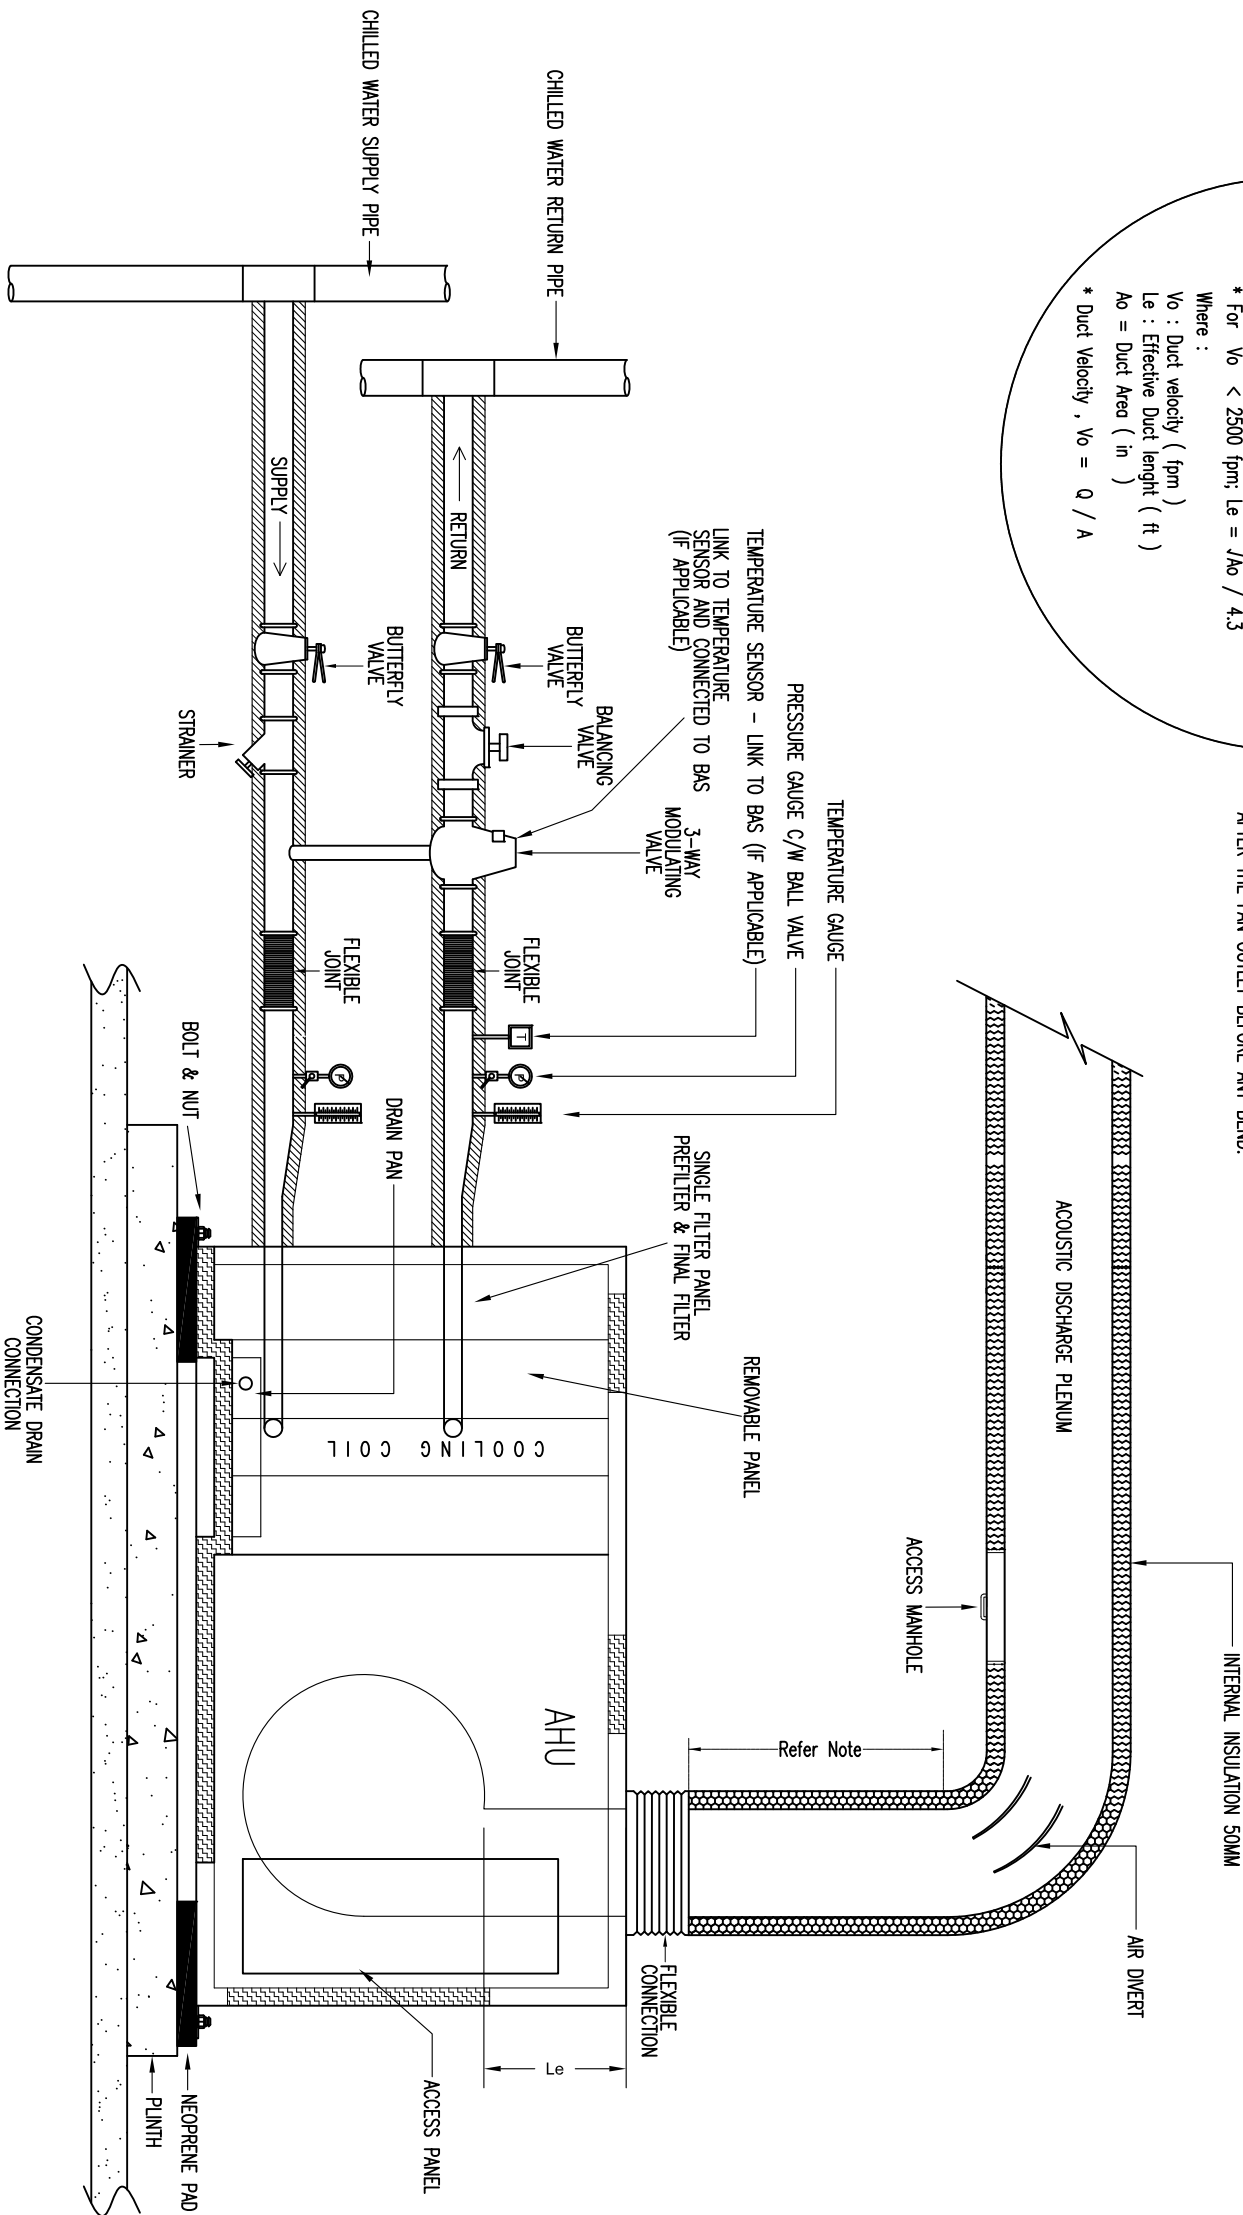

TYPICAL AHU PIPING CONNECTION USING 3-WAY VALVE

NOTE:

PETUNJUK

- HEAVY DUTY PRESSURE GAUGE
- HEAVY DUTY TEMPERATURE GAUGE
- TEMPERATURE SENSOR



JASA KEPADA RAKYAT
CAWANGAN KEJURUTERAAN MEKANIKAL
Ibu Pejabat JKR Malaysia


AIR CONDITIONING SYSTEM

TYPICAL AHU CONNECTION USING 3 WAY VALVE

DATE 2017 SCALE N.T.S


DRAWING NUMBER

CKM/STD/AC/AHU/REV2017/04

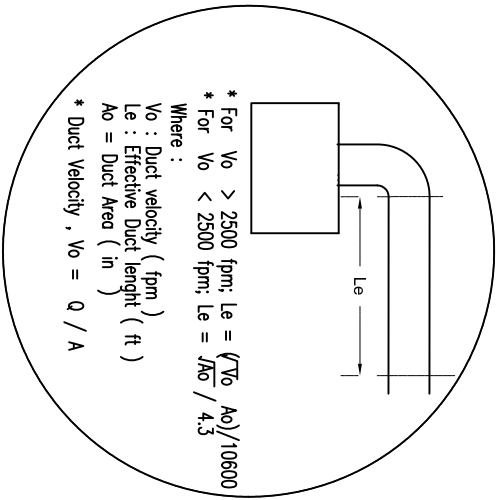

NOTE
THE LENGTH OF INTERNAL INSULATION SHALL BE
TAKEN AS 5 METER FROM THE FAN OUTLET OR 1 METER
BEYOND THE FIRST BEND, WHICHEVER IS THE LONGEST

ALL AHU & FCU SHALL HAVE MINIMUM STRAIGHT DUCT LENGTH OF
OF 2½ TIMES DUCT DIAMETER OR LONGEST SIDE FOR RECTANGULAR DUCT
AFTER THE FAN OUTLET BEFORE ANY BEND.

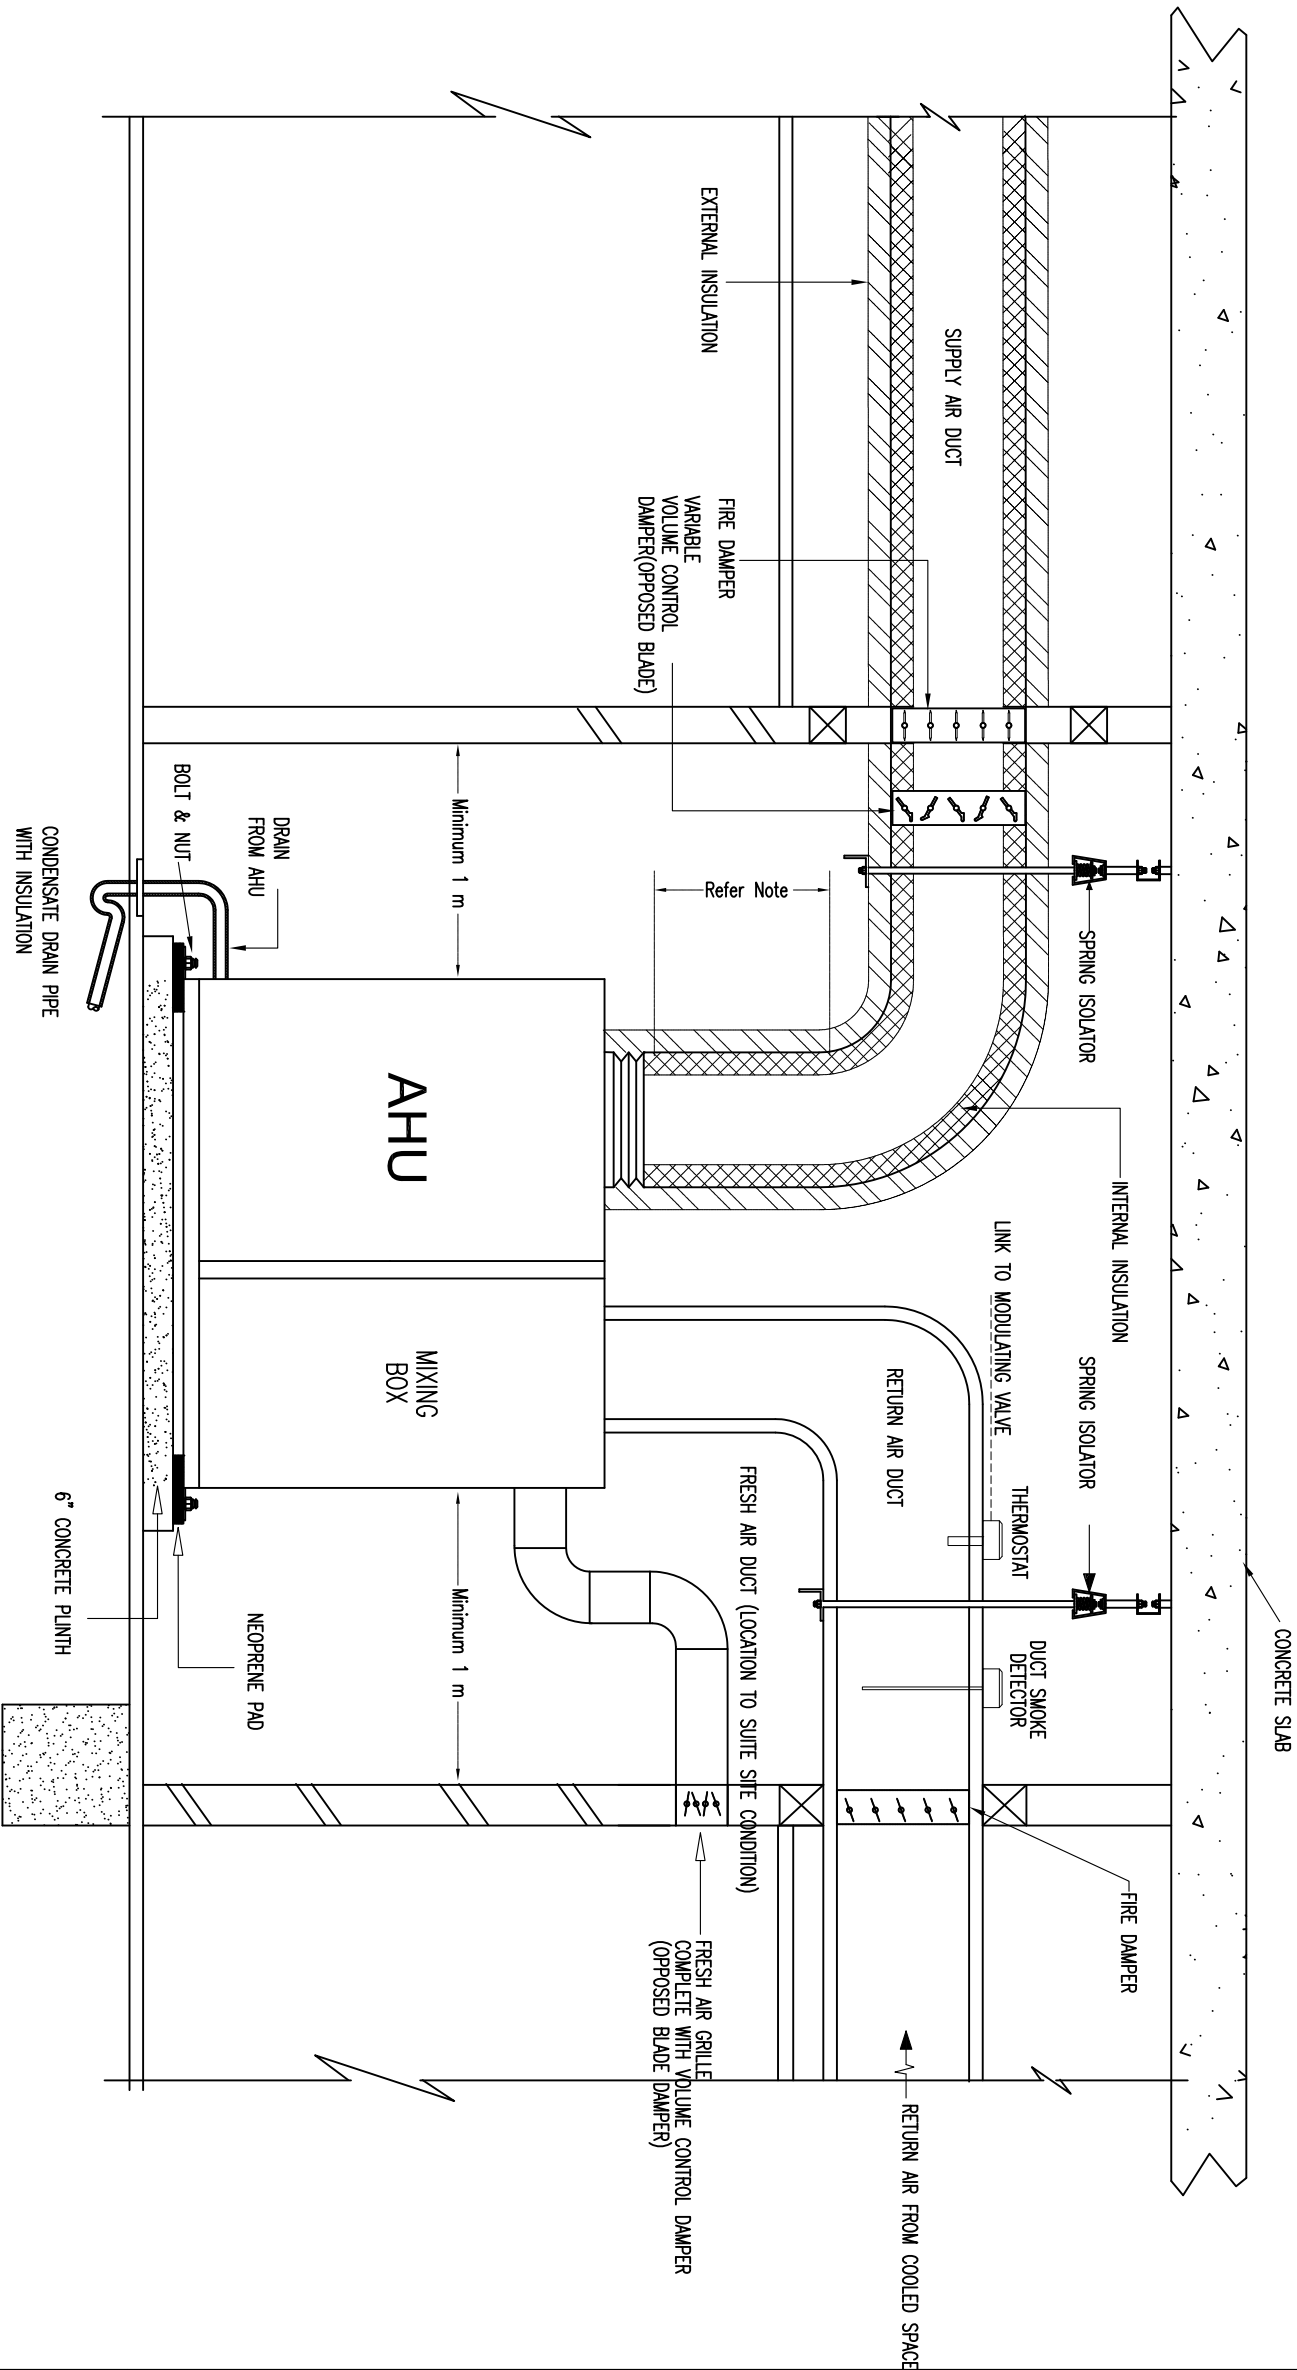

NOTE:

THE LENGTH OF INTERNAL INSULATION SHALL BE



JASA KEPADA RAKYAT
CAWANGAN KEJURUTERAAN MEKANIKAL
Ibu Pejabat JKR Malaysia

AIR CONDITIONING SYSTEM

TYPICAL AHU INSTALLATION WITH MIXING BOX

DATE

2017


SCALE

N.T.S

DRAWING NUMBER


CKM/STD/AC/AHU/REV2017/05

TYPICAL AHU INSTALLATION WITH MIXING BOX

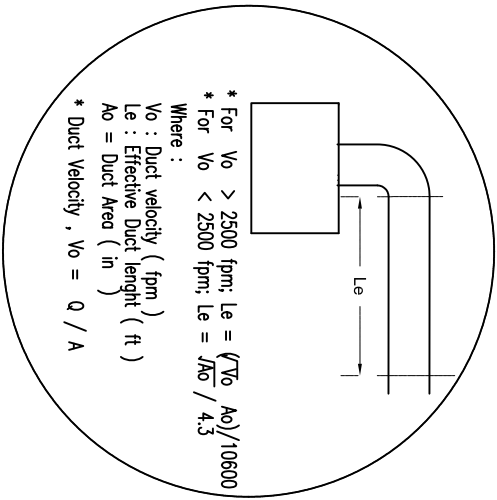

NOTE
THE LENGTH OF INTERNAL INSULATION SHALL BE
TAKEN AS 5 METER FROM THE FAN OUTLET OR 1 METER
BEYOND THE FIRST BEND, WHICHEVER IS THE LONGEST

ALL AHU & FCU SHALL HAVE MINIMUM STRAIGHT DUCT LENGTH OF
OF 2½ TIMES DUCT DIAMETER OR LONGEST SIDE FOR RECTANGULAR DUCT
AFTER THE FAN OUTLET BEFORE ANY BEND.

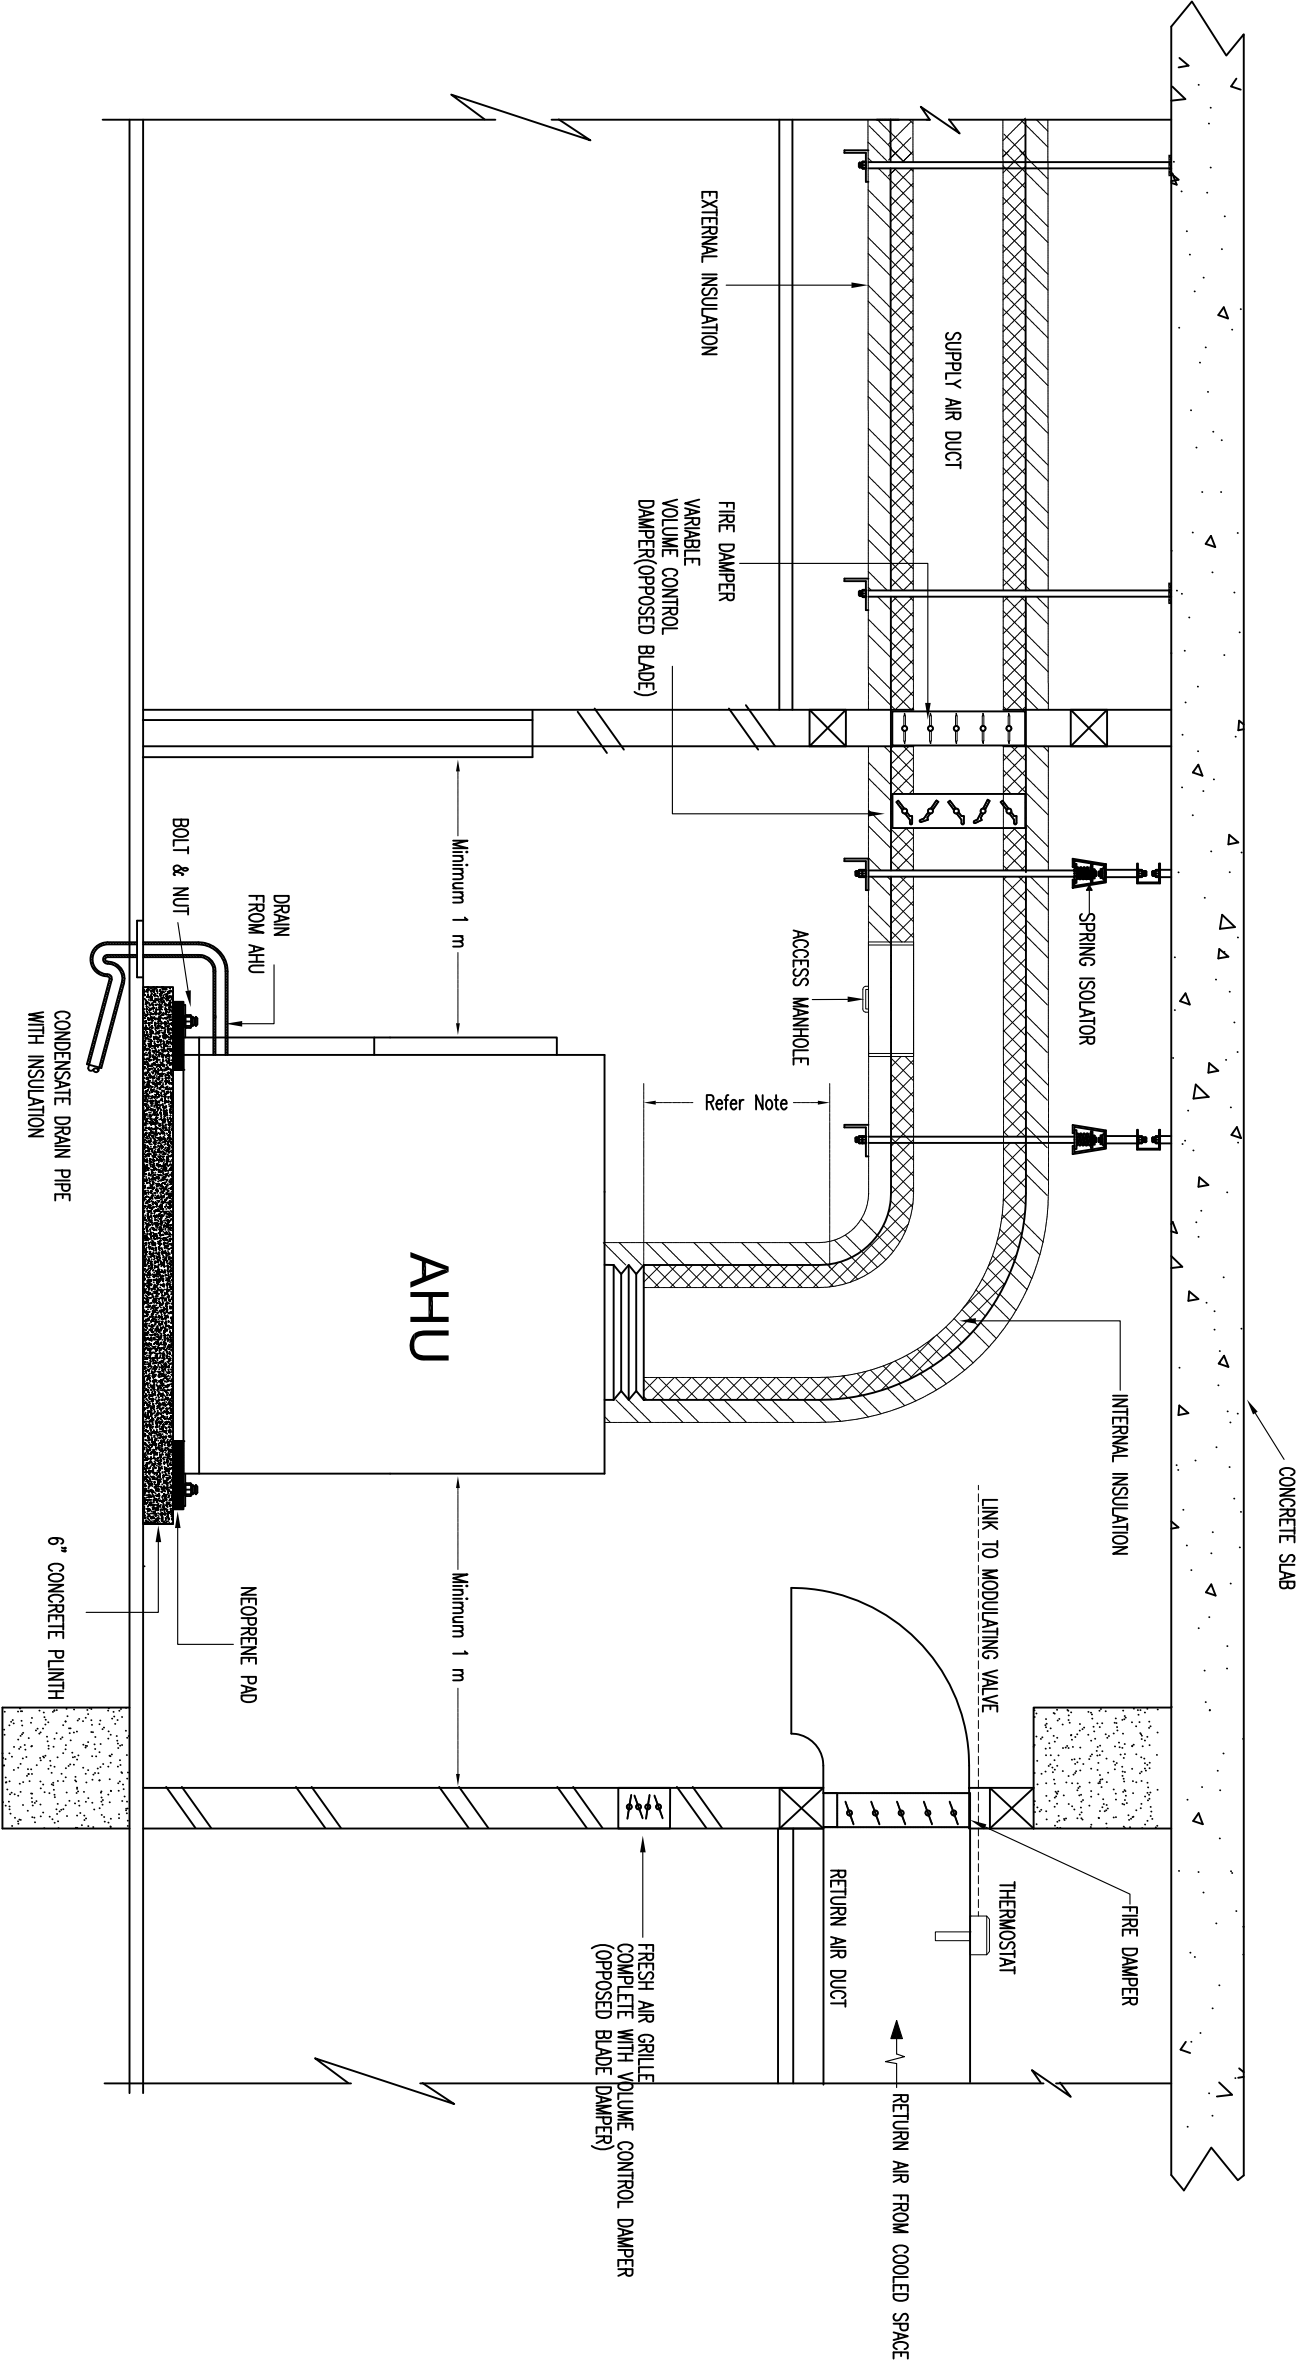

TYPICAL AHU INSTALLATION WITHOUT MIXING BOX

NOTE:




JASA KEPADA RAKYAT
CAWANGAN KEJURUTERAAN MEKANIKAL
Ibu Pejabat JKR Malaysia

AIR CONDITIONING SYSTEM


TYPICAL AHU INSTALLATION WITHOUT MIXING BOX

DATE	2017	SCALE	N.T.S
DRAWING NUMBER	CKMSTD/AC/AHU/REV2017/06		

NOTE:

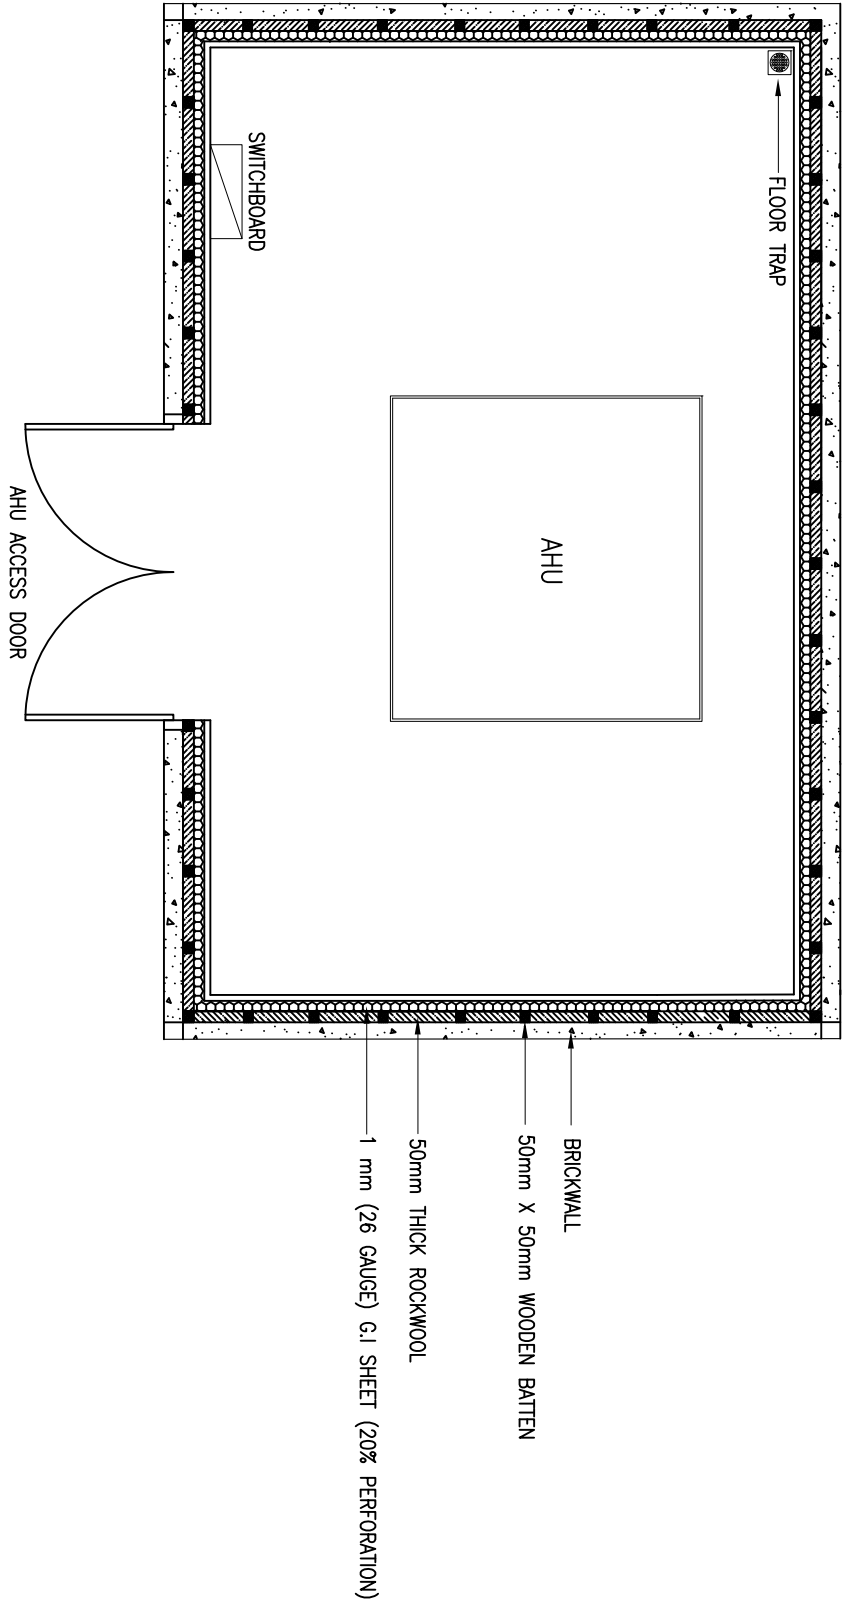

PLAN VIEW

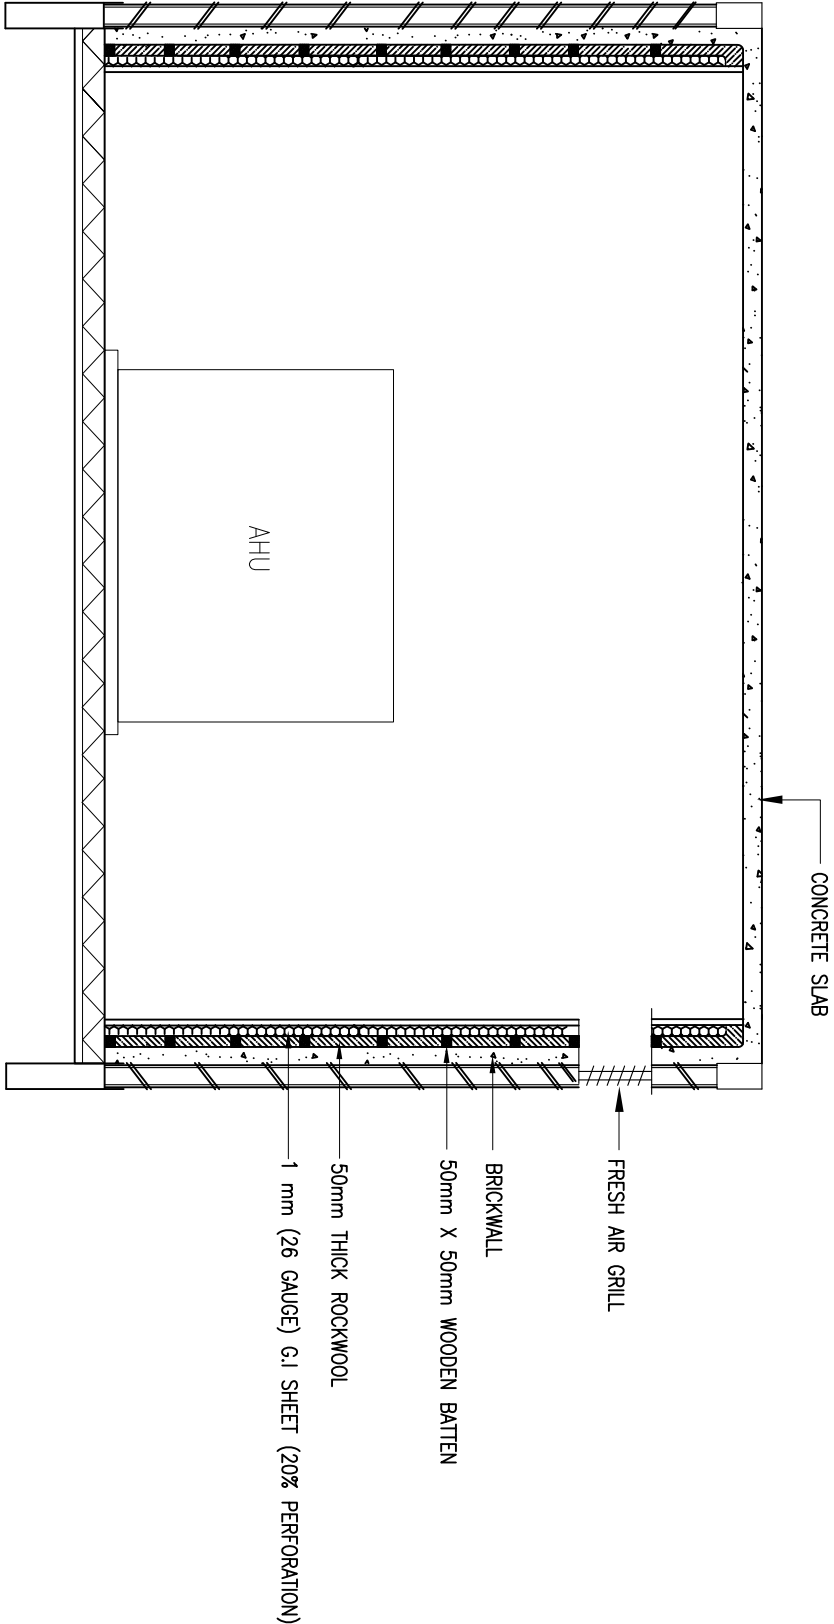

SECTION VIEW

AIR CONDITIONING SYSTEM	
DETAIL OF AHU ROOM INSULATION	
DATE	SCALE
2017	N.T.S
DRAWING NUMBER	
CKM/STD/AC/AHU/REV2017/07	




JKR
MEKANIKAL


JASA KEPADA RAKYAT

CAWANGAN KEJURUTERAAN MEKANIKAL

Ibu Pejabat JKR Malaysia

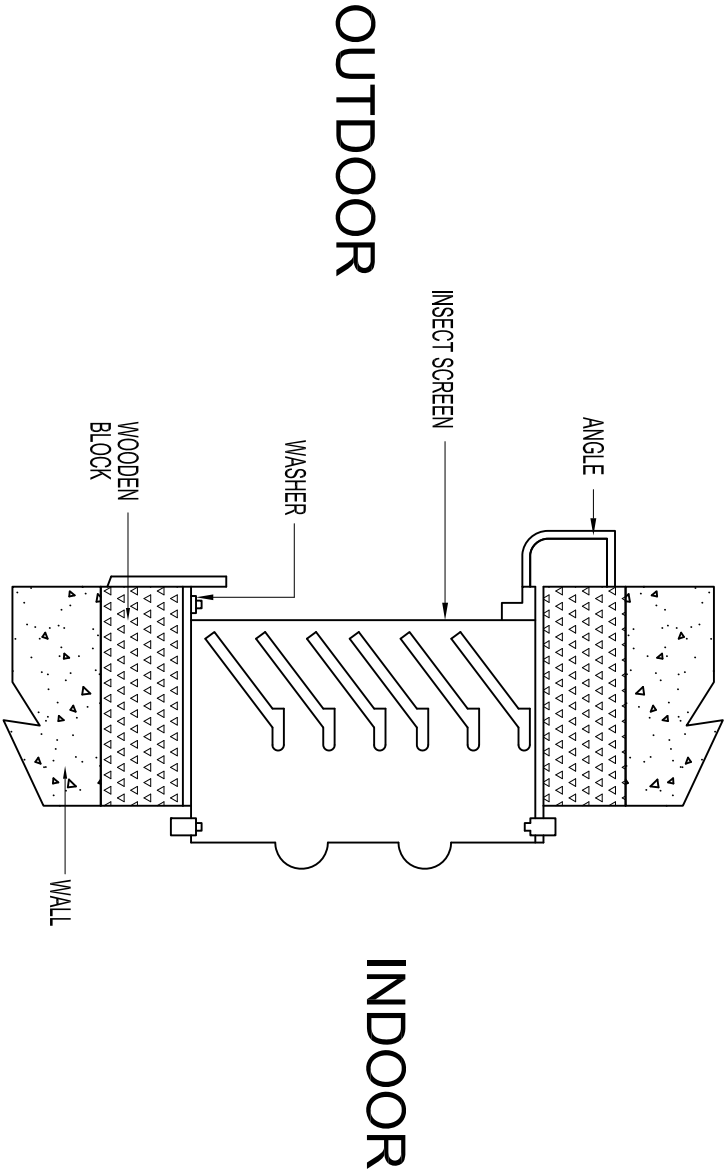

FRESH AIR INTAKE GRILL

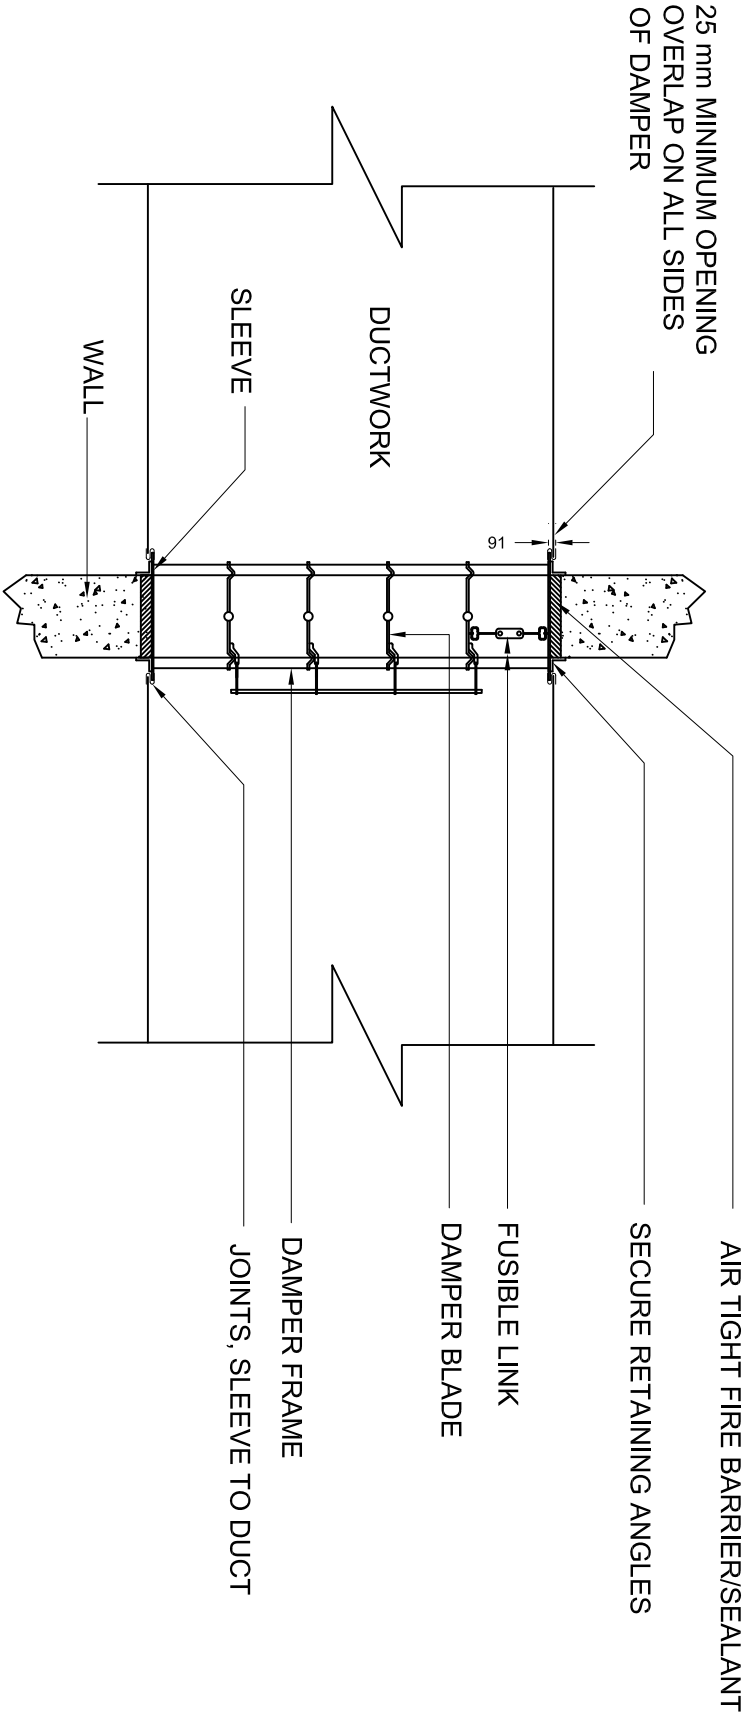

FIRE DAMPER INSTALLATION DETAIL

NOTE:

AIR CONDITIONING SYSTEM

FIRE DAMPER INSTALLATION DETAIL

DATE	2017	SCALE	N.T.S
DRAWING NUMBER			

CKM/STD/AC/AHU/REV2017/08




JASA KEPADA RAKYAT

CAWANGAN KEJURUTERAAN MEKANIKAL

Ibu Pejabat JKR Malaysia

NOTE:

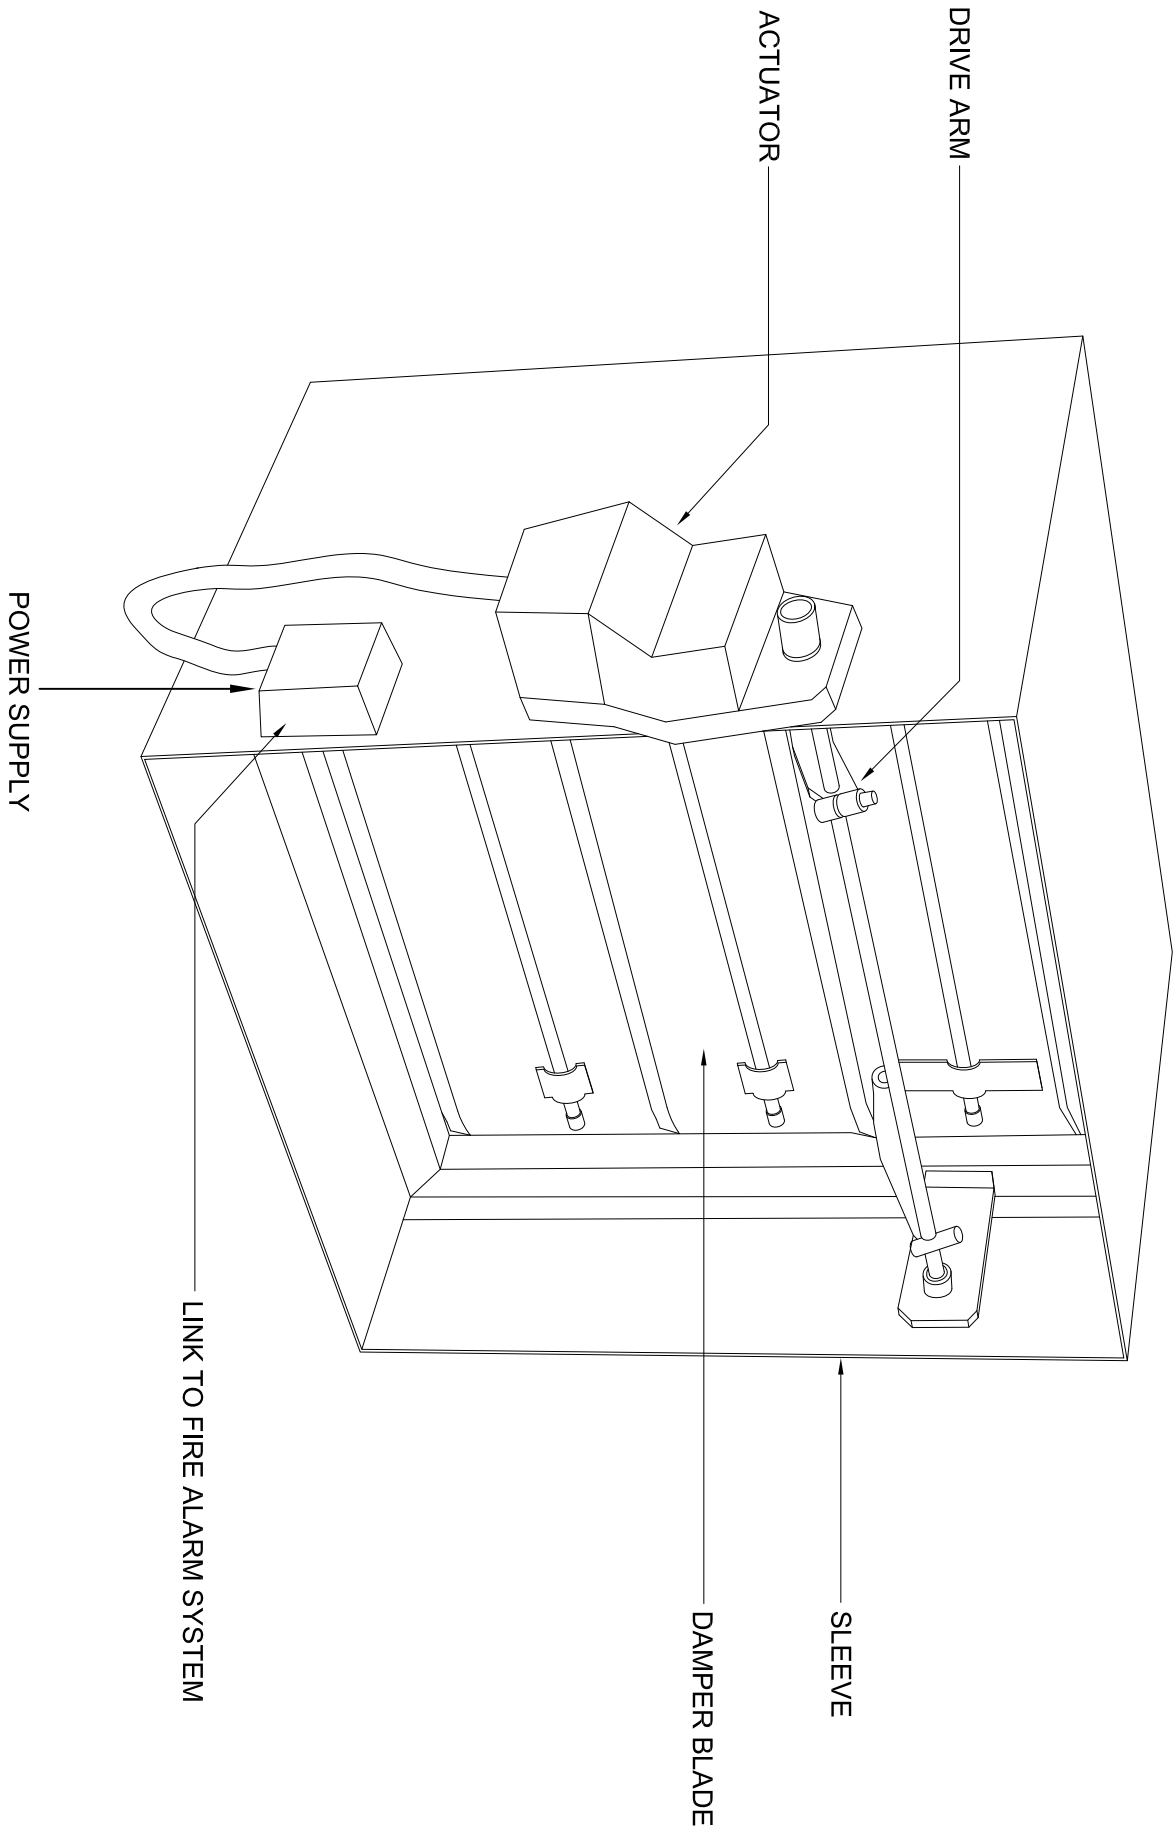

JASA KEPADA RAKYAT
CAWANGAN KEJURUTERAAN MEKANIKAL
Ibu Pejabat JKR Malaysia


AIR CONDITIONING SYSTEM

MOTORISED FIRE DAMPER DETAIL

DATE 2017 SCALE N.T.S


DRAWING NUMBER CKMSTD/AC/AH/REV2017/09

DUCTING

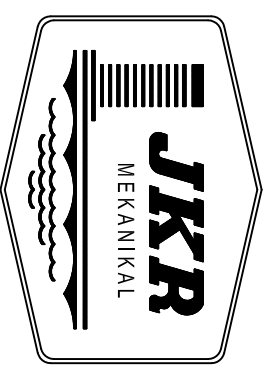


JASA KEPADA RAKYAT

NOTE:

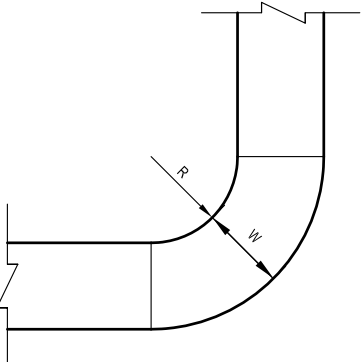


(R) – GREATER THAN OR EQUAL TO (W)
TYPE 1 – RADIUSUSED BEND

TYPE 1 RADIUSUSED BEND

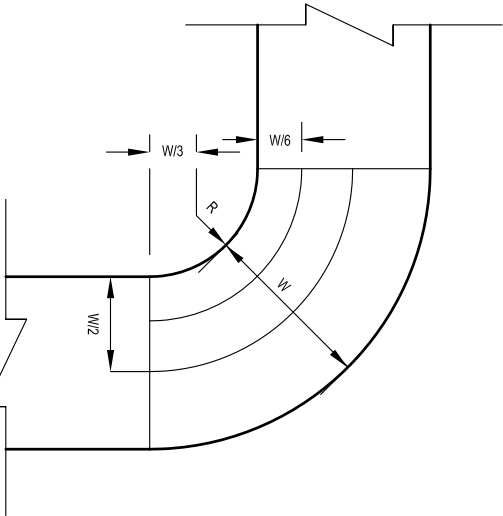


(R) – PREFERABLY W/4 BUT NOT LESS THAN 3"

TYPE 2 RADIUSUSED BEND

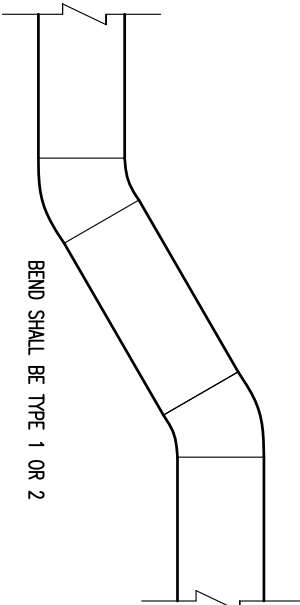


BEND SHALL BE TYPE 1 OR 2

OFFSET DUCT

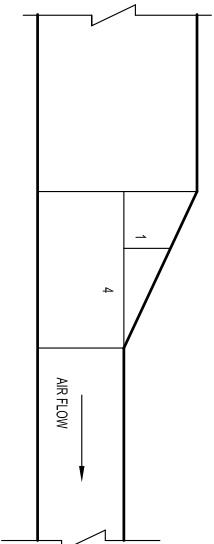

SLOPE OF ANY SIDE SHALL NOT EXCEED 1:4

CONVERGING SECTION (SUPPLY DUCT)

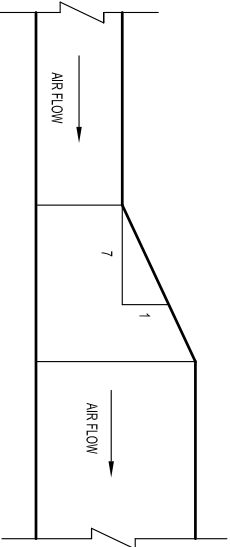

SLOPE OF ANY SIDE SHALL NOT EXCEED 1:7

DIVERGING SECTION (RETURN DUCT)




JASA KEPADA RAKYAT

CAWANGAN KEJURUTERAAN MEKANIKAL
Ibu Pejabat JKR Malaysia

AIR CONDITIONING SYSTEM
DUCT CONSTRUCTION DETAIL

DATE	SCALE	NT'S
2017		
DRAWING NUMBER		
CKM/STD/AC/DUCT/REV2017/01		

NOTE:

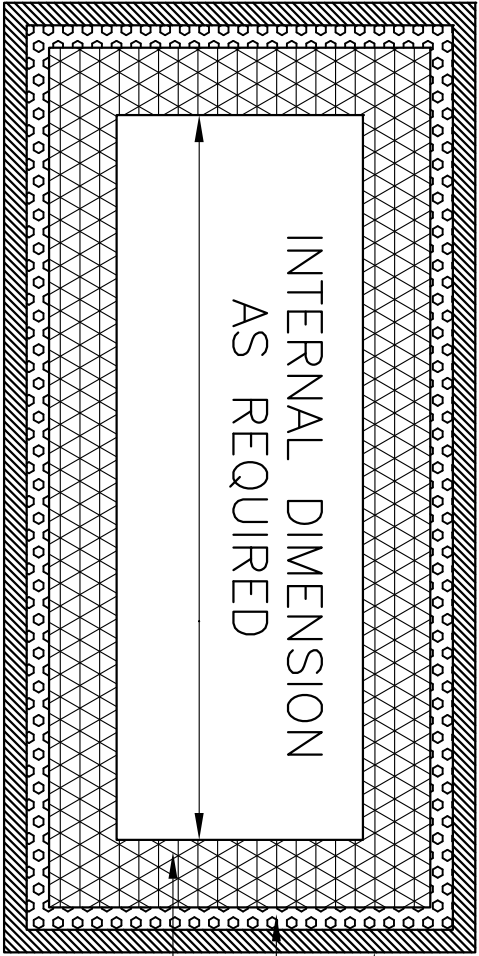

G.I SHEET TO SPECIFICATION

ADHESIVE

OPEN CELL POLYURETHANE (PU) FOAM
THICKNESS: NOT LESS THAN 25mm
THERMAL CONDUCTIVITY: NOT MORE THAN 0.02W/mk
DENSITY: LESS THAN 40 kg/m³

INTERNAL DUCT INSULATION WITH POLYURETHANE (PU)



JASA KEPADA RAKYAT

CAWANGAN KEJURUTERAAN MEKANIKAL
Ibu Pejabat JKR Malaysia

AIR CONDITIONING SYSTEM
INTERNAL DUCT INSULATION
WITH POLYURETHANE (PU)

DATE	SCALE	N.T.S
2017		
DRAWING NUMBER		
CKM/STD/AC/DUCT/REV/2017/11		

NOTE:




FIRE RESISTANT DOUBLE SIDED
REINFORCED ALUMINIUM FOIL

G.I SHEET TO SPECIFICATION

FIBREGLASS
THICKNESS: NOT LESS THAN 25 mm
DENSITY: LESS THAN 32 kg/m³
THERMAL CONDUCTIVITY
: NOT MORE THAN 0.0332w/mk
ADHESIVE

MOLTEN BITUMEN

EXTERNAL DUCT INSULATION WITH FIBREGLASS

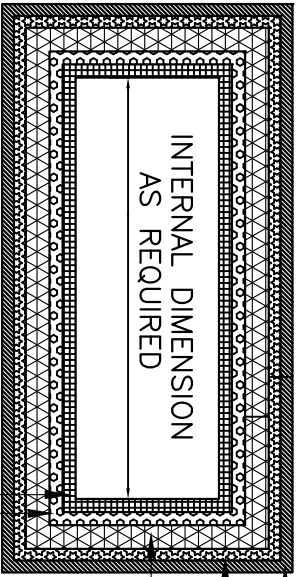

G.I SHEET TO SPECIFICATION

MOLTEN BITUMEN

FIBREGLASS
THICKNESS: NOT LESS THAN 50 mm
DENSITY: LESS THAN 32 kg/m³
THERMAL CONDUCTIVITY
: NOT MORE THAN 0.0332w/mk

ADHESIVE

PERFORATED LIGHT GAUGE SHEET METAL

INTERNAL DUCT INSULATION WITH FIBREGLASS



FIRE RESISTANT DOUBLE SIDED
REINFORCED ALUMINIUM FOIL

G.I SHEET TO SPECIFICATION

FIBREGLASS
THICKNESS: NOT LESS THAN 50 mm
DENSITY: LESS THAN 32 kg/m³
THERMAL CONDUCTIVITY
: NOT MORE THAN 0.0332w/mk
ADHESIVE

MOLTEN BITUMEN

EXTERNAL DUCT INSULATION WITH FIBREGLASS

FOR DUCT INSTALLED IMMEDIATELY
BELOW ROOF OR IN ANY VERTICAL SHAFT



FIRE RESISTANT DOUBLE SIDED
REINFORCED ALUMINIUM FOIL

G.I SHEET TO SPECIFICATION

FIBREGLASS
THICKNESS: NOT LESS THAN 50 mm
DENSITY: LESS THAN 32 kg/m³
THERMAL CONDUCTIVITY
: NOT MORE THAN 0.0332w/mk
ADHESIVE
METAL CLADDING

MOLTEN BITUMEN


EXTERNAL DUCT INSULATION WITH FIBREGLASS

FOR DUCT INSTALLED INSIDE AHU ROOM OR
EXPOSED TO WEATHER OR ALL DUCTWORKS
FOR SERVING 24 HRS ROOMS.


TYPICAL DUCT INSULATION WITH FIBREGLASS MATERIAL

CAWANGAN KEJURUTERAAN MEKANIKAL Ibu Pejabat JKR Malaysia		
JKR MEKANIKAL JASA KEPADA RAKYAT		
AIR CONDITIONING SYSTEM TYPICAL DUCT INSULATION WITH FIBREGLASS MATERIAL		
DATE 2017	SCALE N.T.S	
DRAWING NUMBER CKM/STD/AC/DUCT/REV/2017/12		

NOTE:


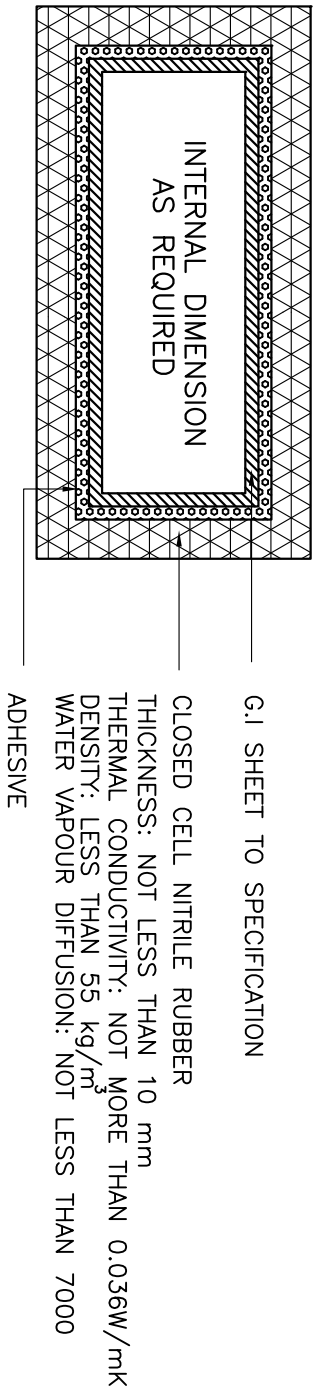


EXTERNAL DUCT INSULATION WITH NITRILE RUBBER

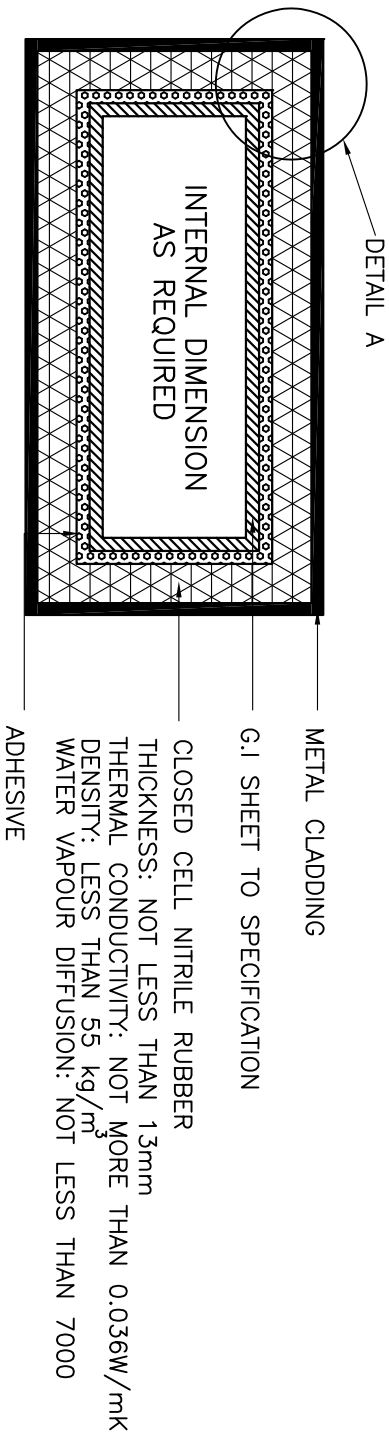

EXTERNAL DUCT INSULATION WITH NITRILE RUBBER
FOR DUCT INSTALLED INSIDE AHU ROOM OR
EXPOSED TO WEATHER OR ALL DUCTWORKS
FOR SERVING 24 HRS ROOMS.

DETAIL A

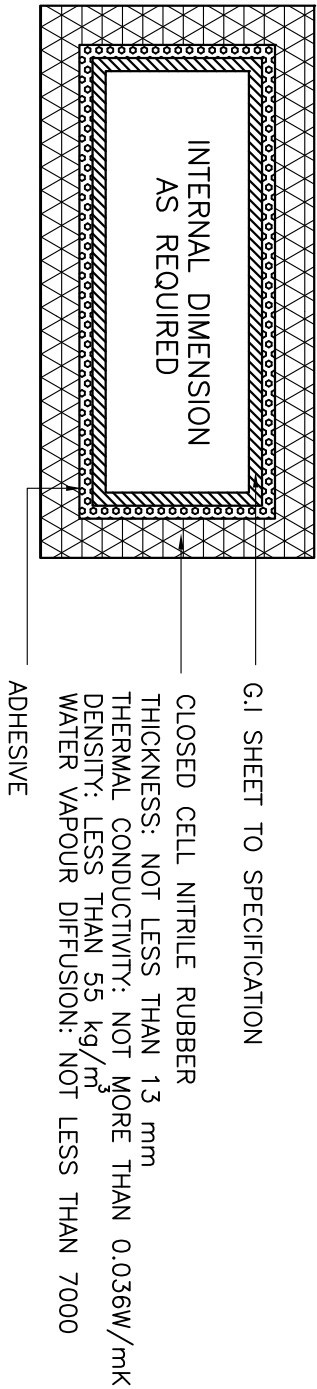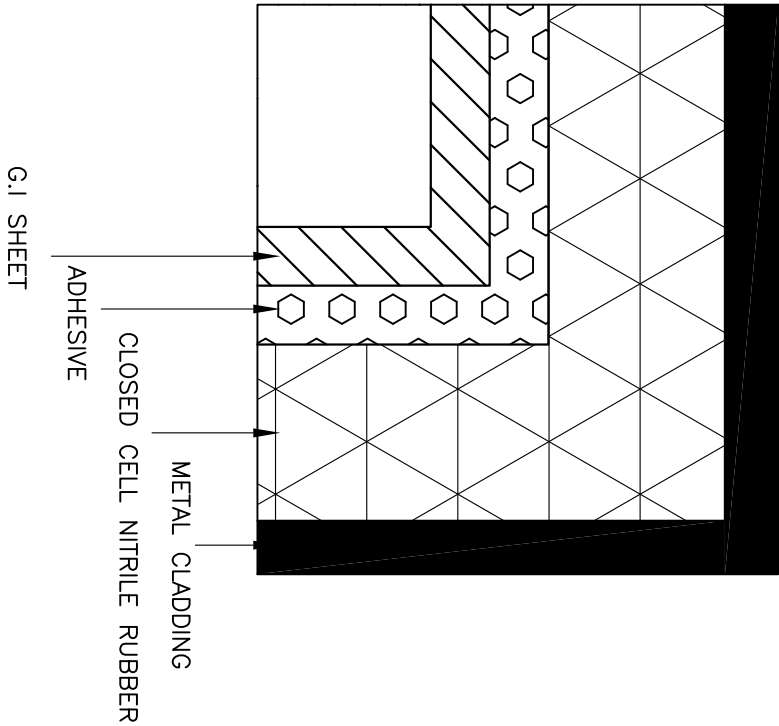

EXTERNAL DUCT INSULATION WITH NITRILE RUBBER
FOR DUCT INSTALLED IMMEDIATELY
BELOW ROOF OR IN ANY VERTICAL SHAFT

TYPICAL DUCT INSULATION WITH CLOSED CELL NITRILE RUBBER MATERIAL

AIR CONDITIONING SYSTEM	
TYPICAL DUCT INSULATION WITH CLOSED CELL CELL NITRILE RUBBER MATERIAL	
DATE	SCALE
2017	N.T.S
DRAWING NUMBER	
CKM/STD/AC/DUCT/REV/2017/13	



JASA KEPADA RAKYAT

CAWANGAN KEJURUTERAAN MEKANIKAL
Ibu Pejabat JKR Malaysia

NOTE:



G.I SHEET TO SPECIFICATION

POLYETHELYNE P.E

THICKNESS: NOT LESS THAN 12mm

THERMAL CONDUCTIVITY: NOT MORE THAN 0.036w/mk

DENSITY: LESS THAN 33 kg/m³

EXTERNAL DUCT INSULATION WITH POLYETHYLENE (PE)



METAL CLADDING

G.I SHEET TO SPECIFICATION

POLYETHYLENE (PE)

THICKNESS: NOT LESS THAN 20mm

THERMAL CONDUCTIVITY: NOT MORE THAN 0.036w/mk

DENSITY: LESS THAN 33 kg/m³

ADHESIVE

EXTERNAL DUCT INSULATION WITH POLYETHYLENE (PE)

FOR DUCT INSTALLED INSIDE AHU ROOM OR

EXPOSED TO WEATHER OR ALL DUCTWORKS

FOR SERVING 24 HRS ROOMS.



G.I SHEET TO SPECIFICATION

POLYETHYLENE (PE)

THICKNESS: NOT LESS THAN 20mm

THERMAL CONDUCTIVITY: NOT MORE THAN 0.036w/mk

DENSITY: LESS THAN 33 kg/m³

ADHESIVE

EXTERNAL DUCT INSULATION WITH POLYETHYLENE (PE)

FOR DUCT INSTALLED IMMEDIATELY


BELOW ROOF OR IN ANY VERTICAL SHAFT

TYPICAL DUCT INSULATION WITH POLYETHYLENE (PE) MATERIAL

NOTE : POLYETHYLENE (PE) SHALL NOT BE APPLY FOR INTERNAL DUCT INSULATION.



NOTE:

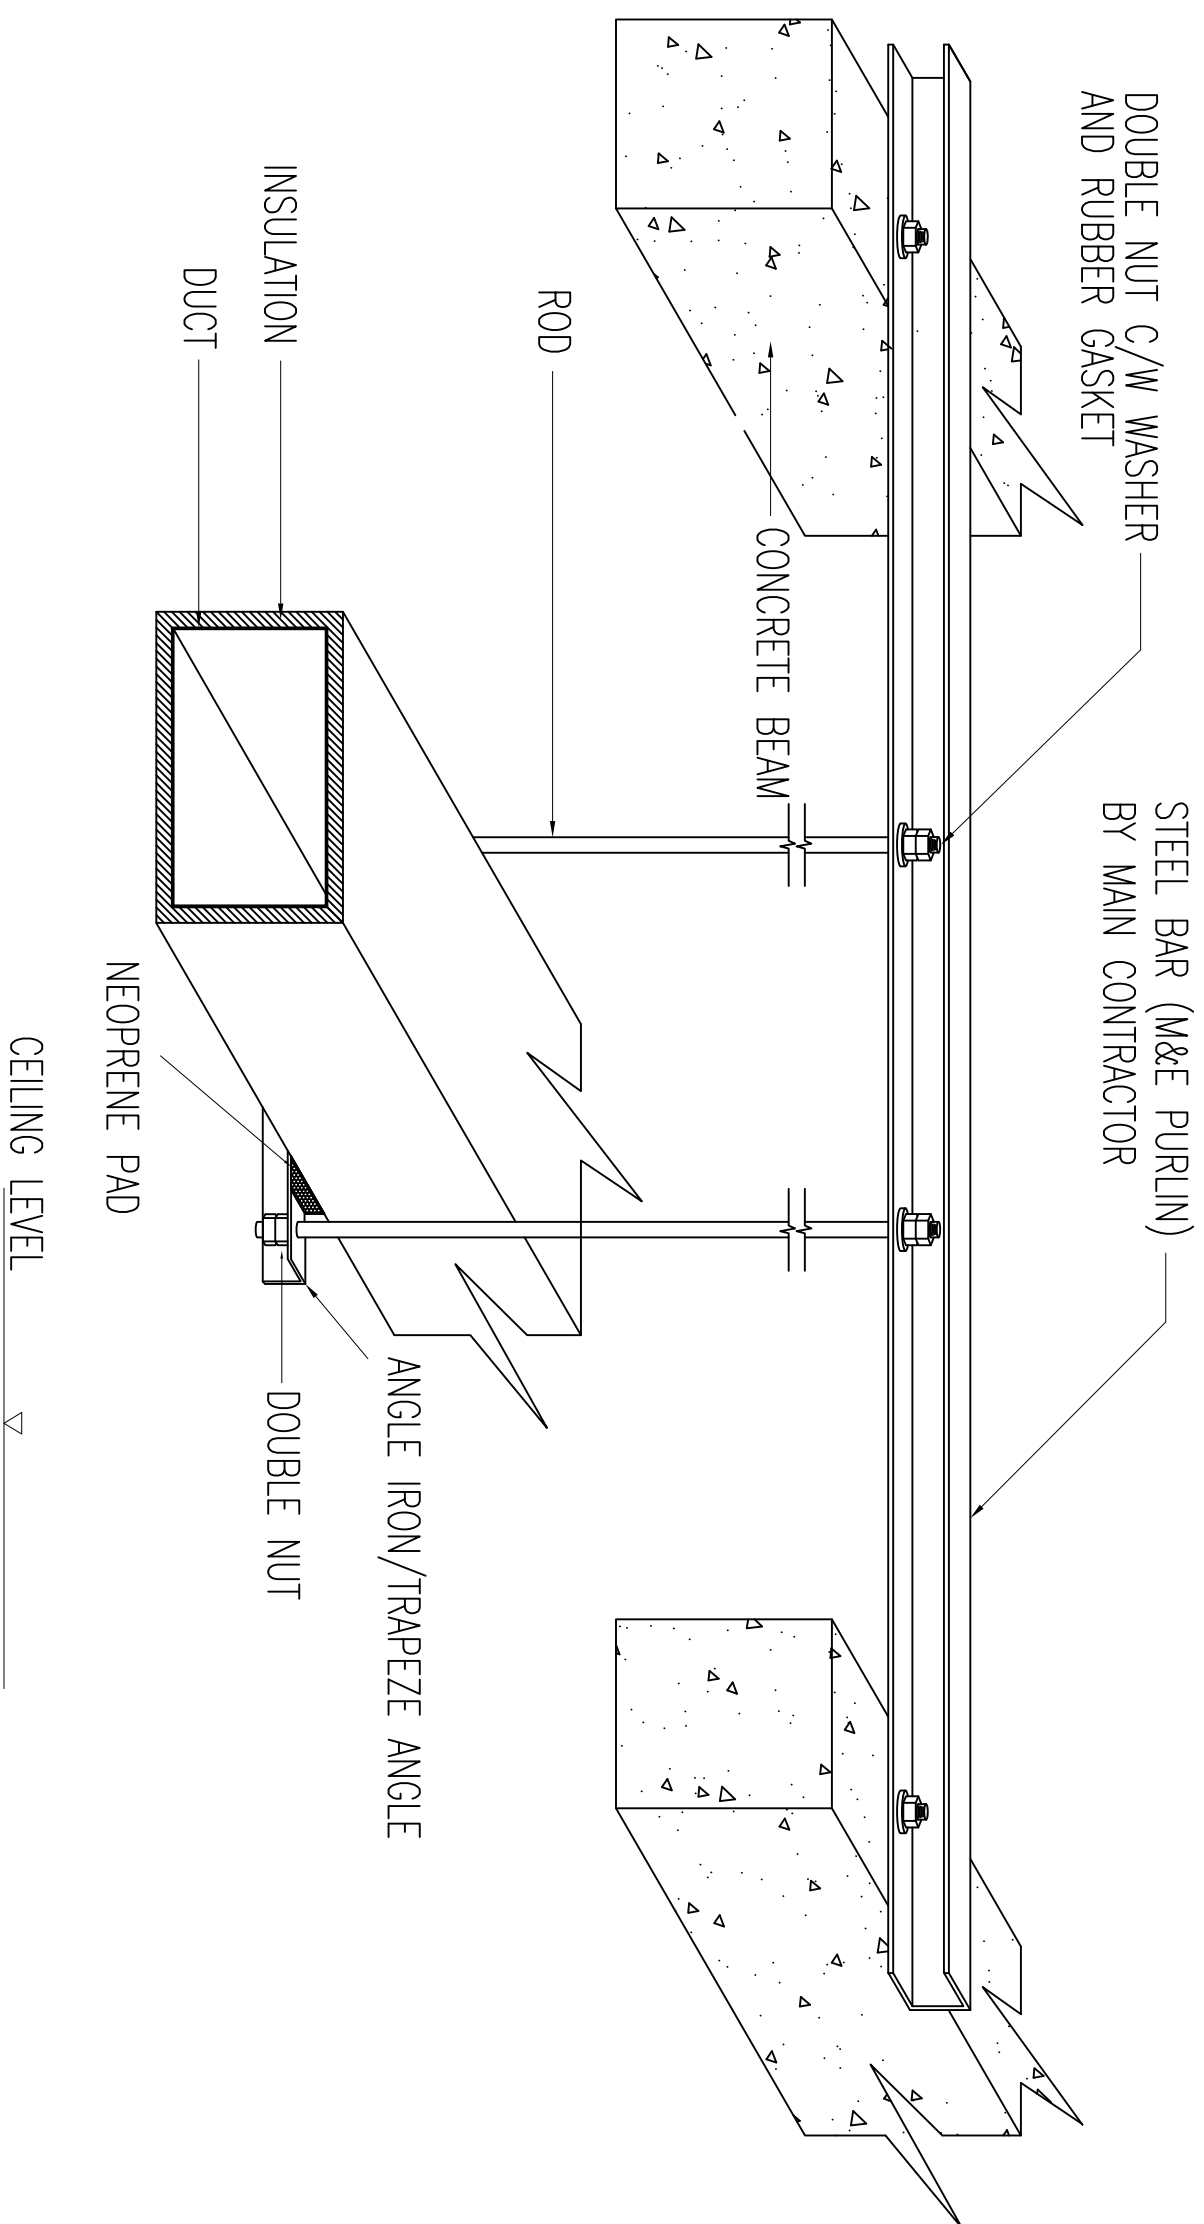

TYPICAL DUCT SUPPORT AND HANGER (UNDER THE ROOF)

AIR CONDITIONING SYSTEM

DUCT SUPPORT DETAIL (UNDER THE ROOF)

DATE	SCALE
------	-------

2017

SCALE

N.T.S

DRAWING NUMBER



CKM/STD/AC/DUCT/REV2017/17




JASA KEPADA RAKYAT

CAWANGAN KEJURUTERAAN MEKANIKAL
Ibu Pejabat JKR Malaysia

Ibu Pejabat JKR Malaysia

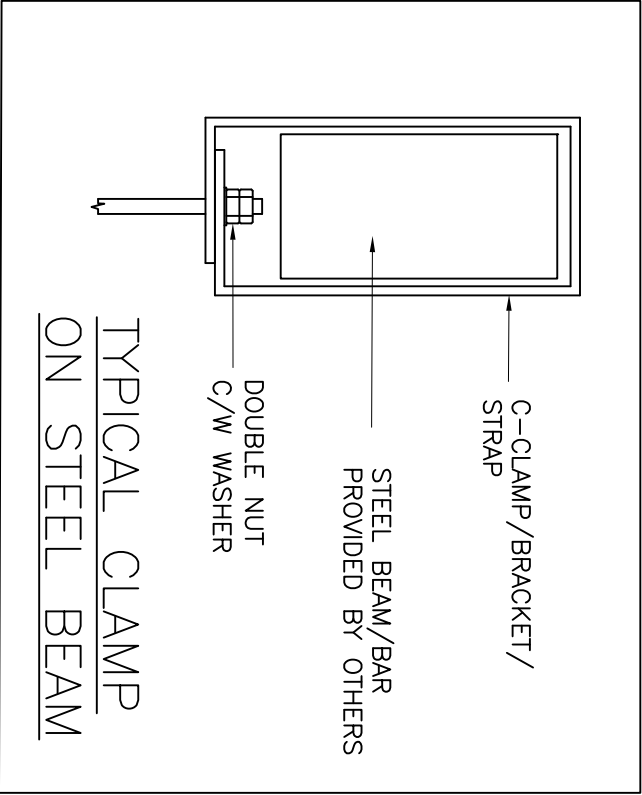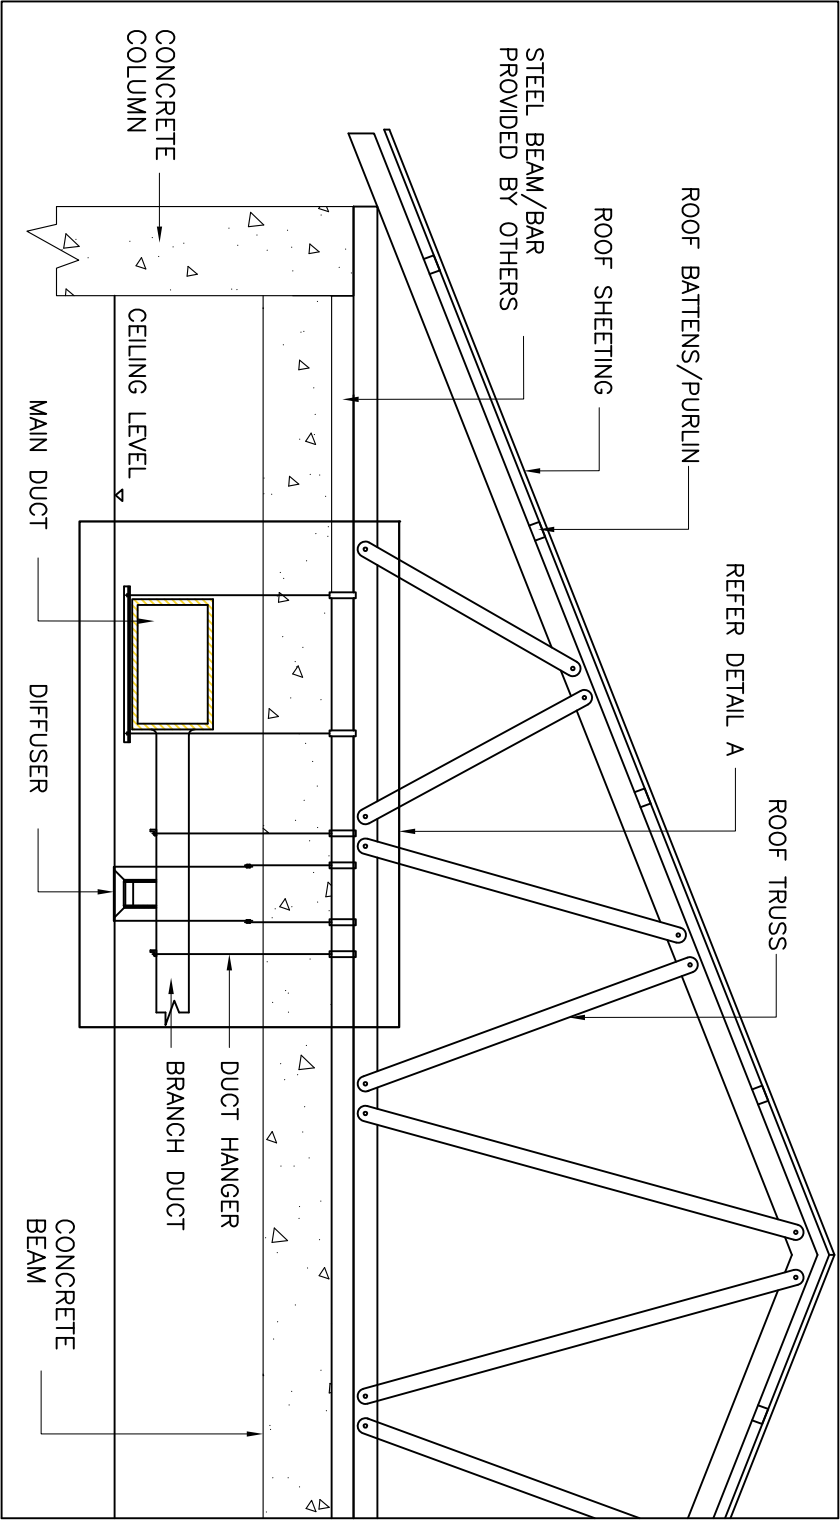

**TYPICAL DUCT/ DIFFUSER SUPPORT
AND HANGER (UNDER THE ROOF)**

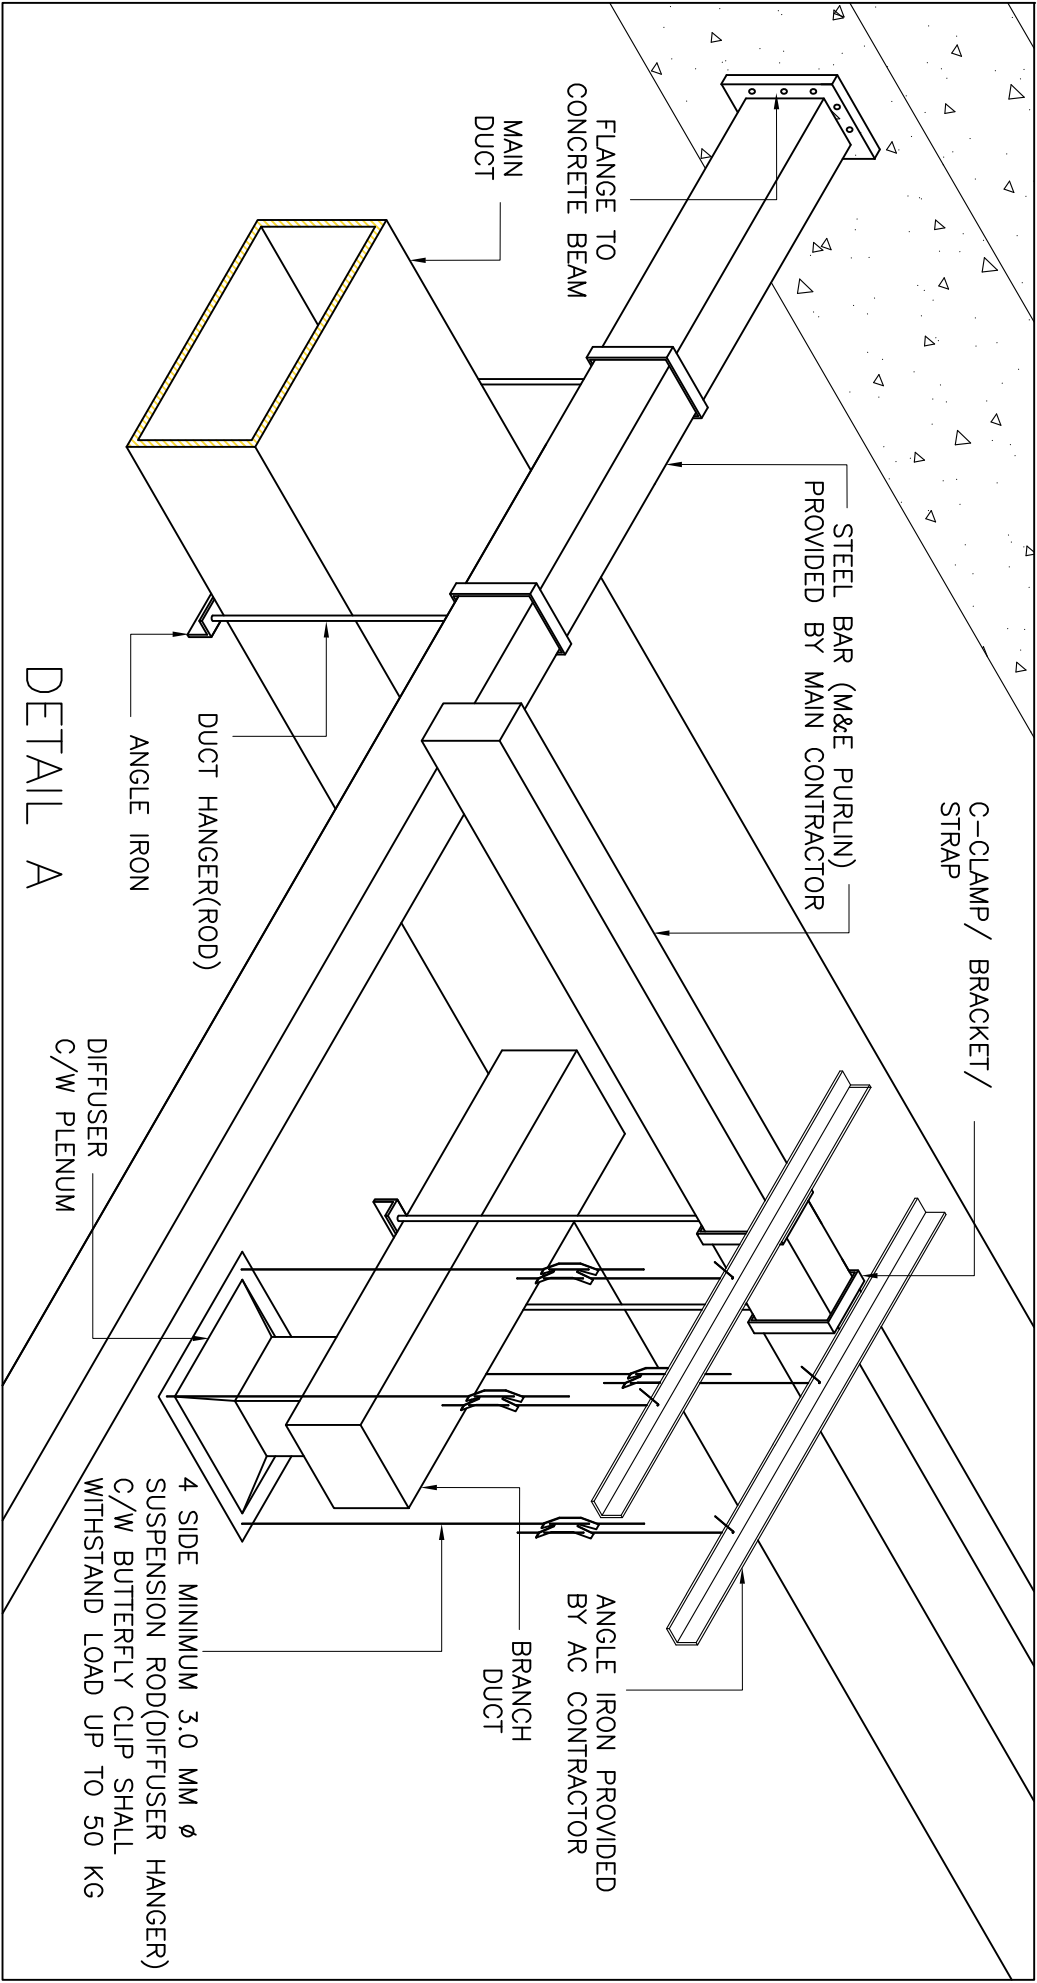


DETAIL A

NOTE:


 JKR MEKANIKAL JASA KEPADA RAKYAT CAWANGAN KEJURUTERAAN MEKANIKAL Ibu Pejabat JKR Malaysia		
AIR CONDITIONING SYSTEM		
TYPICAL DUCT/ DIFFUSER SUPPORT AND HANGER (UNDER THE ROOF)		
DATE	SCALE	
2017	N.T.S	
DRAWING NUMBER	CKM/STD/AC/DUCT/REV/2017/18	

NOTE:

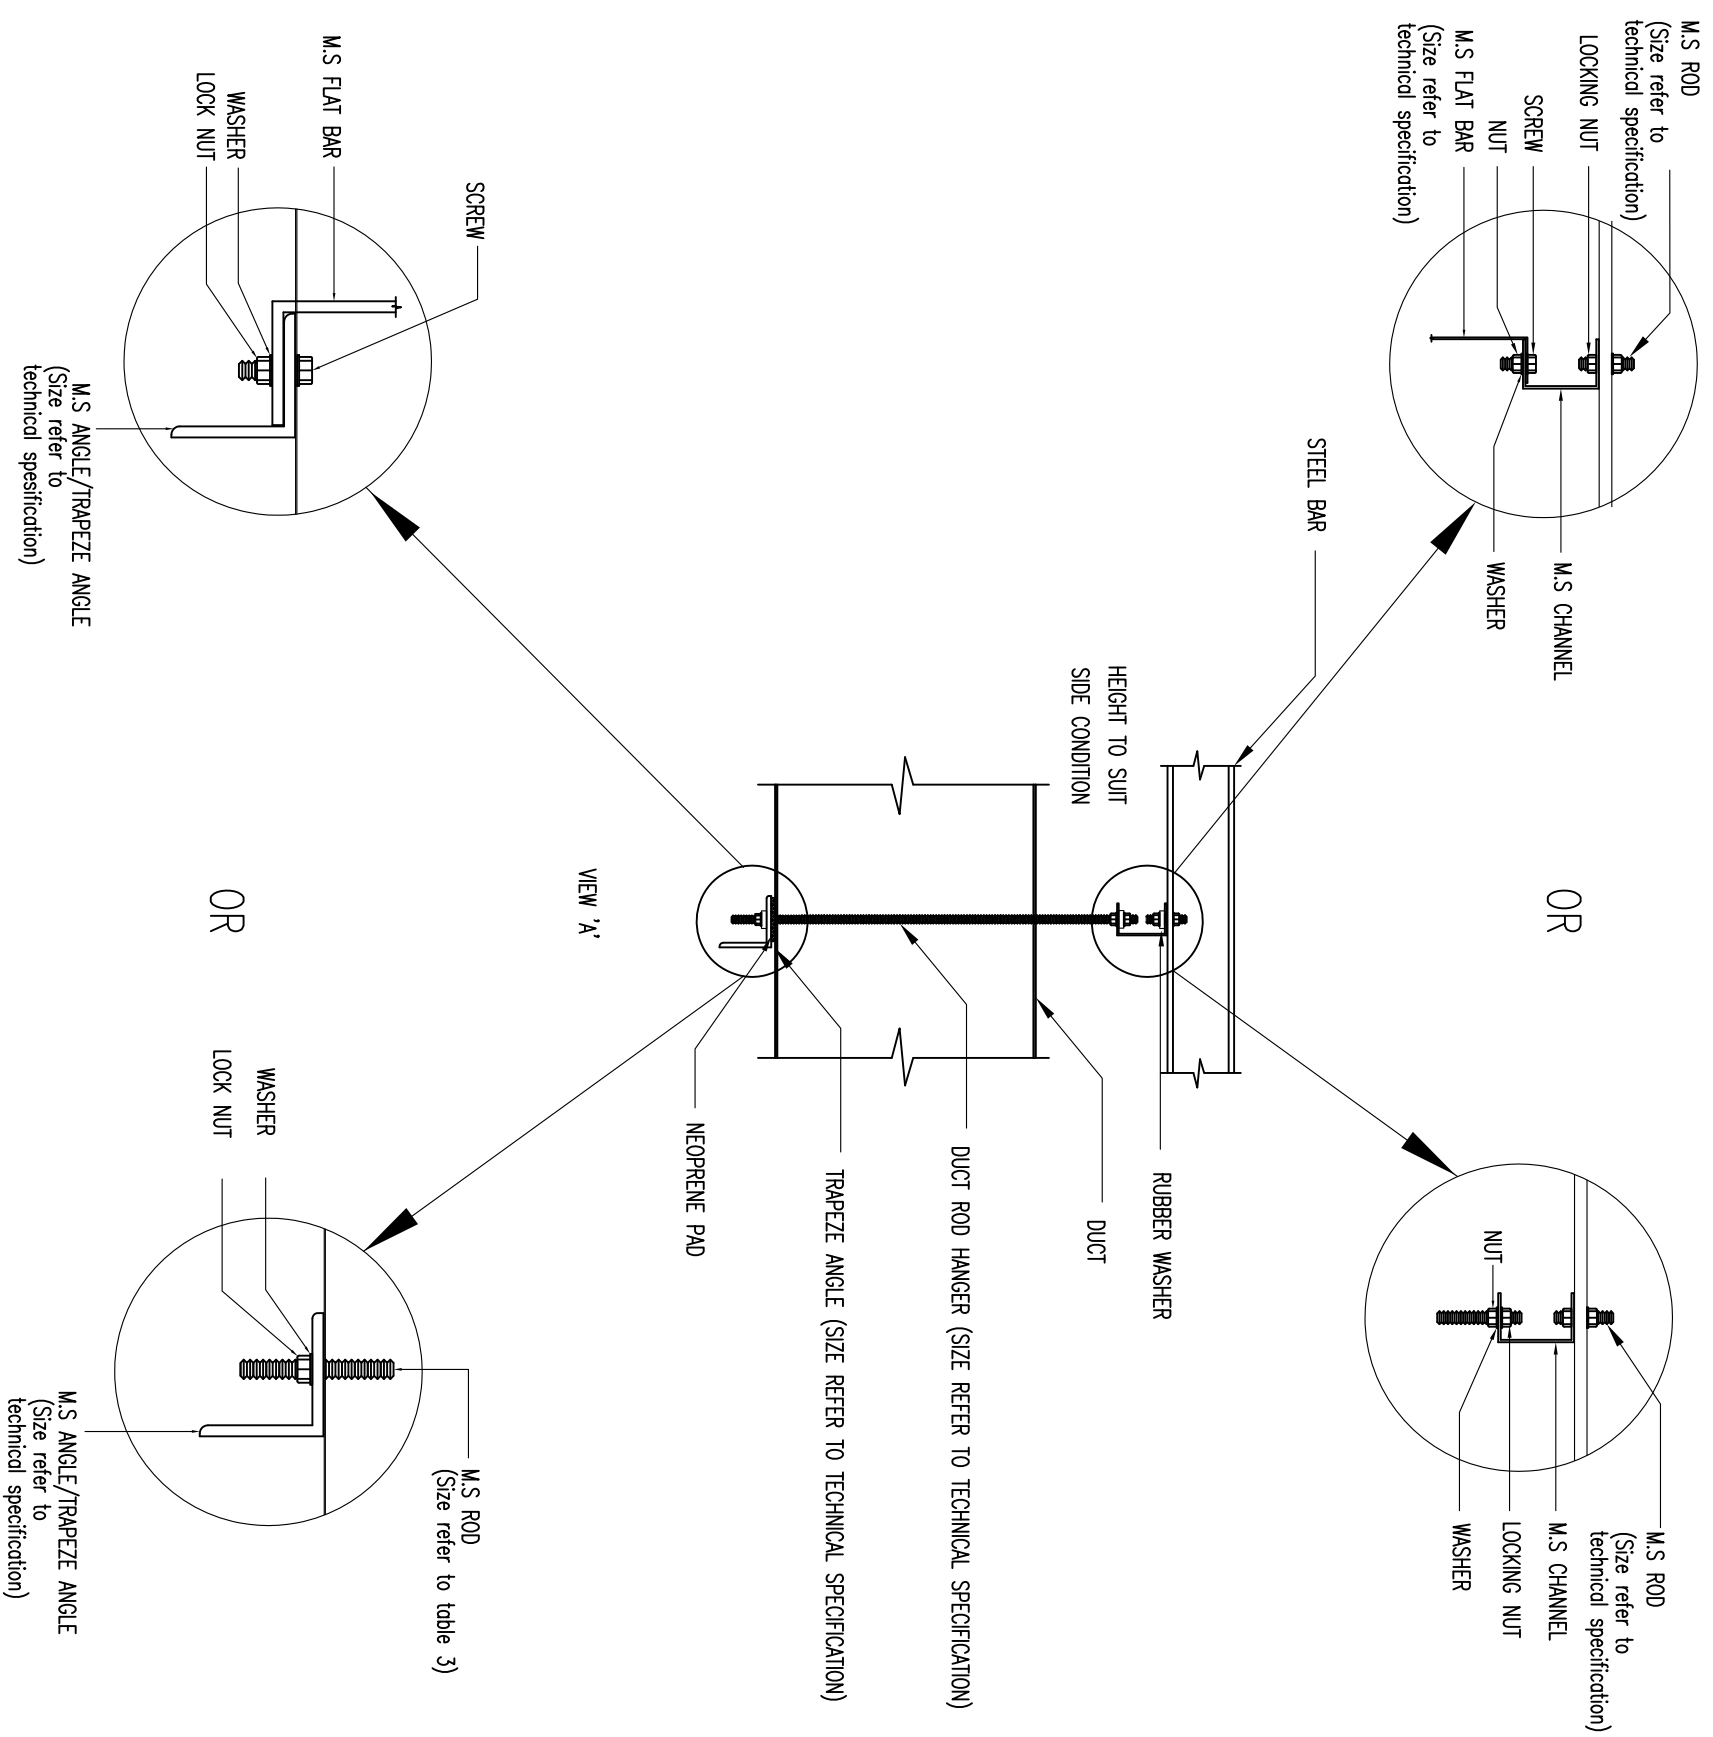

DUCT SUPPORT AND BRACKET DETAIL

NOTE:

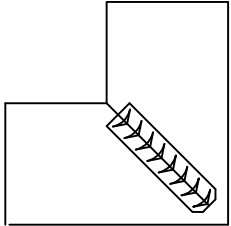


SQUARE ELBOW

FIGURE 1


NOTE:

NUMBER AND CONSTRUCTION OF VANES
SHALL FOLLOW SMACNA, HVAC DUCT CONTRUCTION

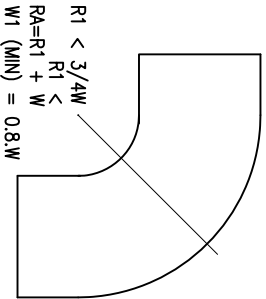

UNVANE ELBOW

FIGURE 2

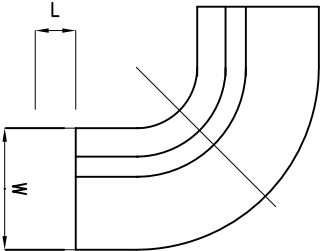

SHORT RADIUS ELBOW

FIGURE 3

VANES	R1 min.	R1 max.
ONE	1/2 W	3/4 W
TWO	1/4 W	1/2 W

$Ra = R1 + W$
 $L = W/3$
 $W1 (MIN.) = 0.8W$

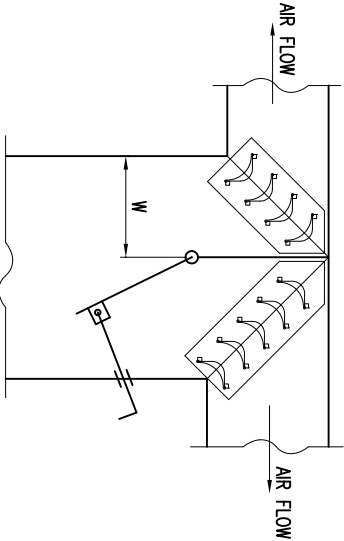


FIGURE 4

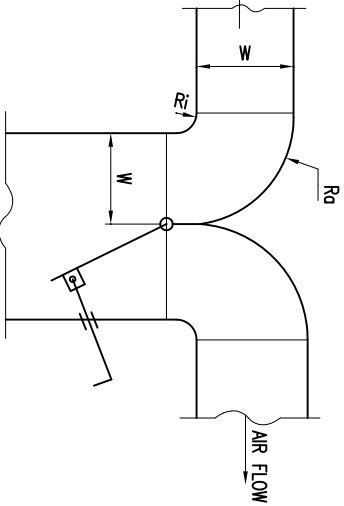


FIGURE 5

TEES AND TAKE-OFFS

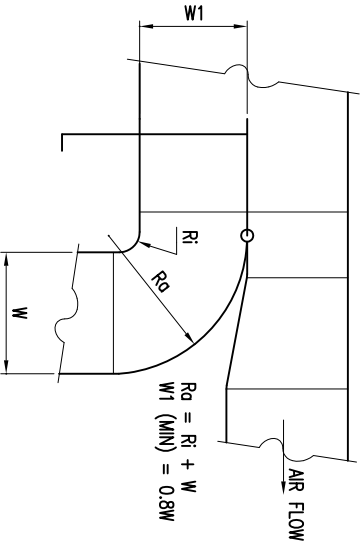


FIGURE 6

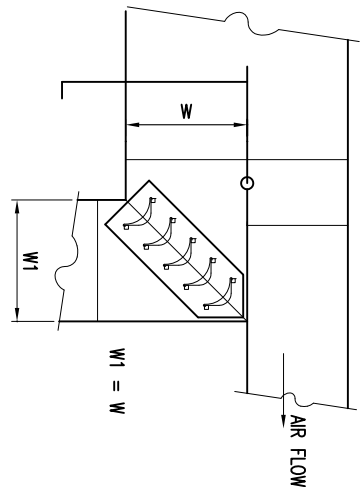


FIGURE 7

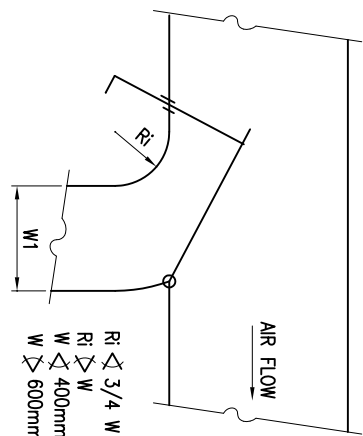


FIGURE 8



JASA KEPADA RAKYAT

CAWANGAN KEJURUTERAAN MEKANIKAL
Ibu Pejabat JKR Malaysia

AIR CONDITIONING SYSTEM


DUCT CONSTRUCTION DETAIL

DATE	SCALE	NT'S
2017		
DRAWING NUMBER	CKM/STD/AC/DUCT/REV2017/02	

This technical diagram illustrates the installation of a fan coil unit (FCU) within a ceiling structure. The unit is shown as a rectangular box with a fan coil unit label. Air flow is indicated by arrows: "SUPPLY AIR" enters the unit from the bottom, and "RETURN AIR" exits from the top. The unit is connected to a "FLEXIBLE CONNECTION (REFER DETAIL A)" on the right side. Water connections are shown on the left side, with "CHILLED WATER SUPPLY" and "CHILLED WATER RETURN" lines. A "CONDENSATE DRAIN" line is also shown, leading from the unit to a drain. A "HANGER ROD (MOUNTED TO CEILING)" is shown supporting the unit. A "FLEXIBLE PORTION" is indicated on the right side of the unit.

 JASA KEPADA RAKYAT CAWANGAN KEJURUTERAAN MEKANIKAL Ibu Pejabat JKR Malaysia	
AIR CONDITIONING SYSTEM DUCT CONNECTION DETAIL FOR FAN COIL UNIT (FCU)	
DATE	SCALE
2017	N.T.S
DRAWING NUMBER	
CKM/STD/AC/DUCT/REV/2017/120	

NOTE:

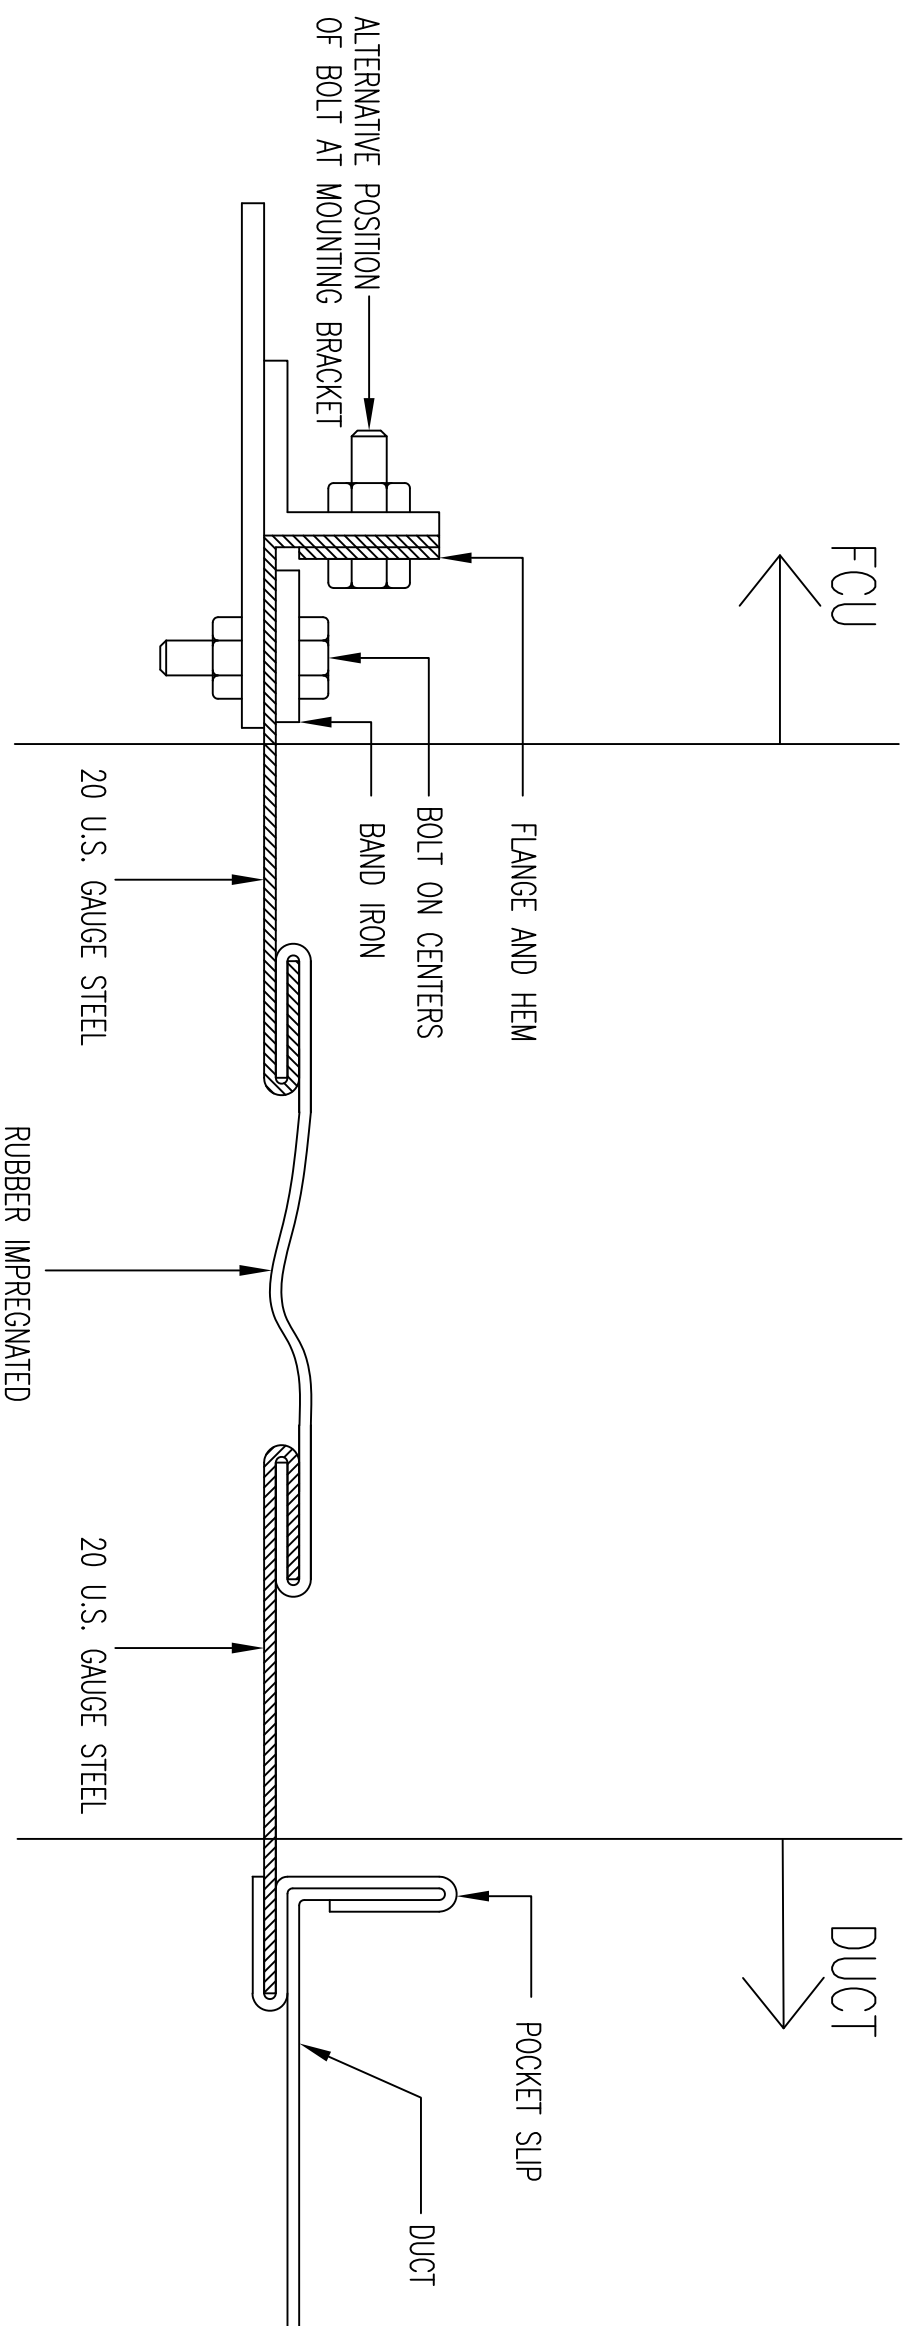

DETAIL A - FLEXIBLE CONNECTION FOR RECTANGULAR (FAN OUTLET/INLET)



JASA KEPADA RAKYAT

CAWANGAN KEJURUTERAAN MEKANIKAL
Ibu Pejabat JKR Malaysia

**AIR CONDITIONING SYSTEM
FLEXIBLE CONNECTION FOR
RECTANGULAR (FAN OUTLET/INLET)**

DATE	SCALE
------	-------


2017	2016	N.T.S

SCALE



N.T.S

DRAWING NUMBER

CKM/STD/AC/DUCT/REV2017/21

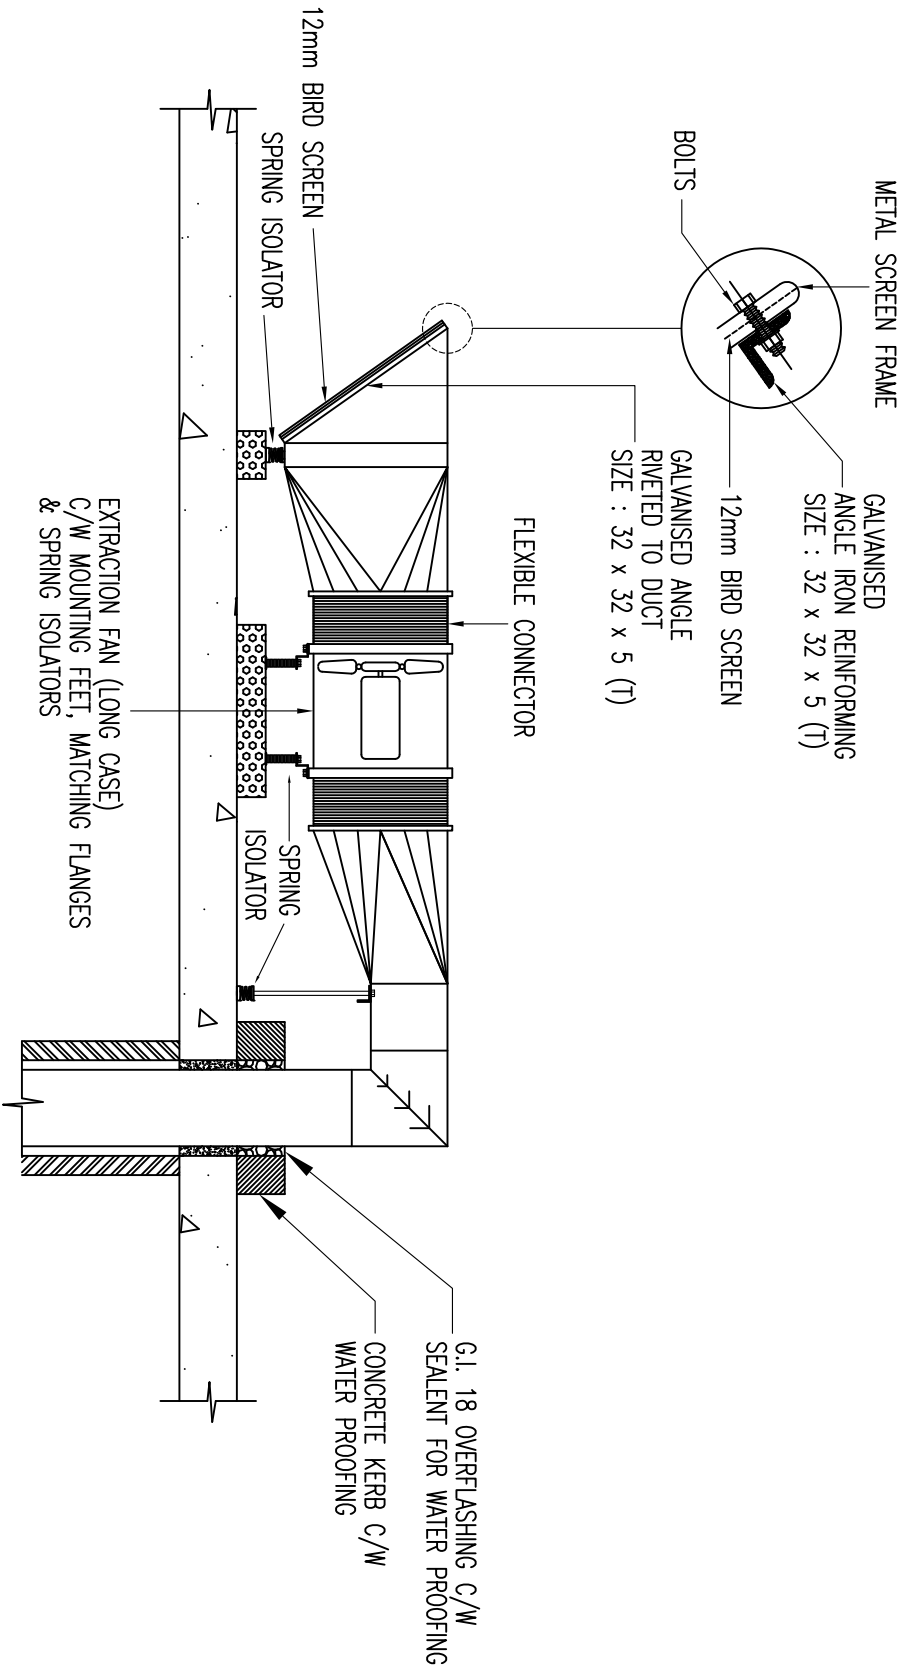

ROOF MOUNTED EXTRACTION FAN DETAILS

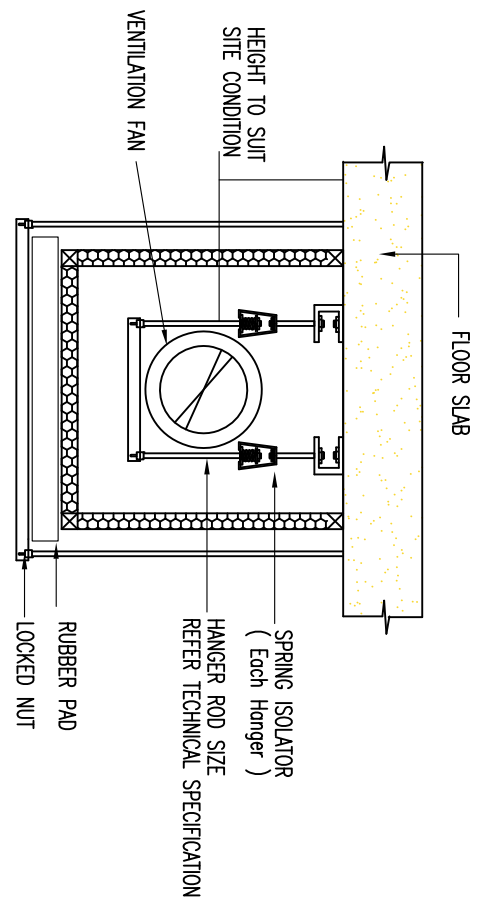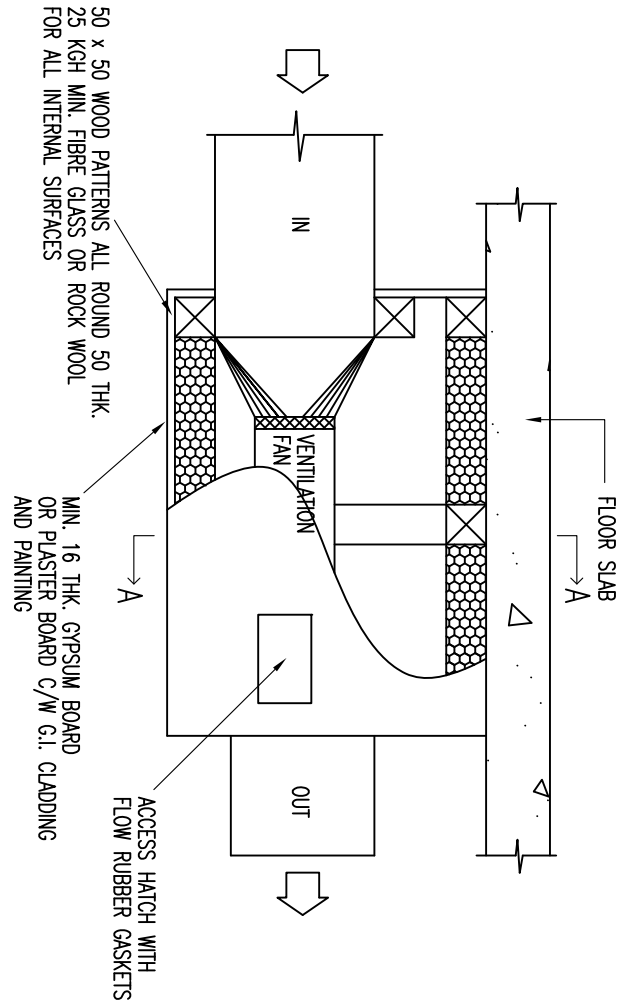


SECTION A-A

NOTE:
1. CLEARANCE MIN. 150mm ALL ROUND THE FAN
2. ALL JOINTS AND JUNCTIONS TO BE CAULKED AIR TIGHT



VENTILATION FAN – NOISE CONTROL DETAIL INSTALLATION

NOTE:

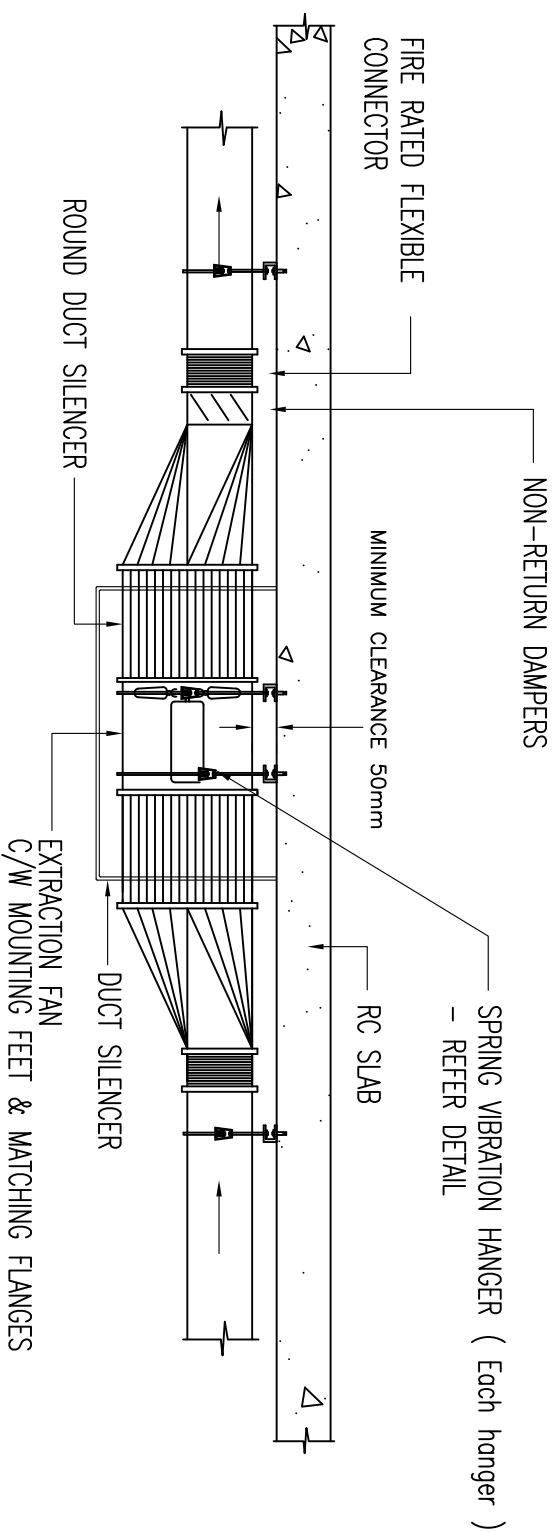

VENTILATION SUPPLY & EXHAUST FAN

DETAILS WITH DUCT SILENCERS

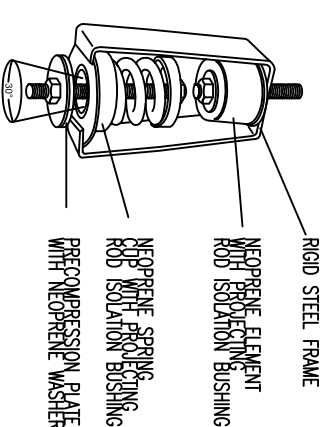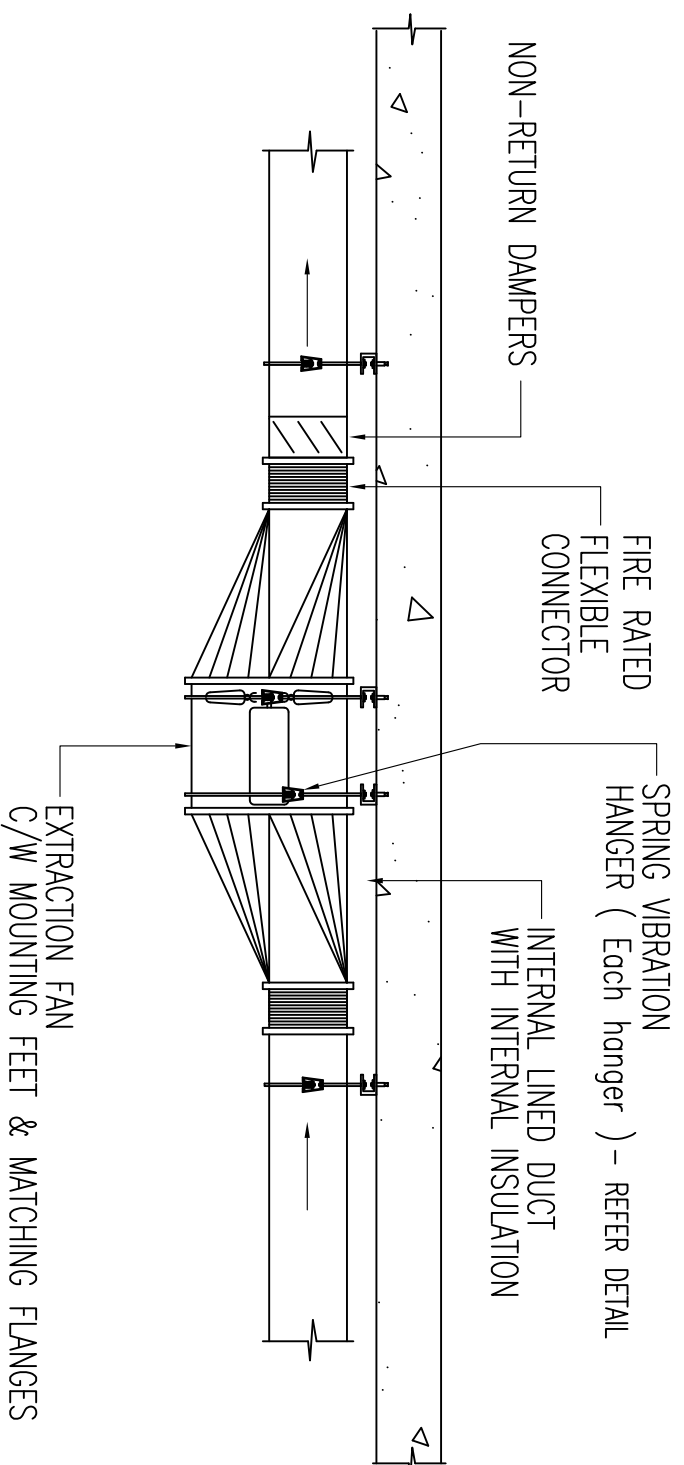

DETAIL SPRING

AIR CONDITIONING SYSTEM

DETAIL OF VENTILATION SYSTEM INSTALLATION

DATE	SCALE
2017	N.T.S


DRAWING NUMBER

CKM/STD/AC/DUCT/REV2017/23




JASA KEPADA RAKYAT


CAWANGAN KEJURUTERAAN MEKANIKAL
Ibu Pejabat JKR Malaysia

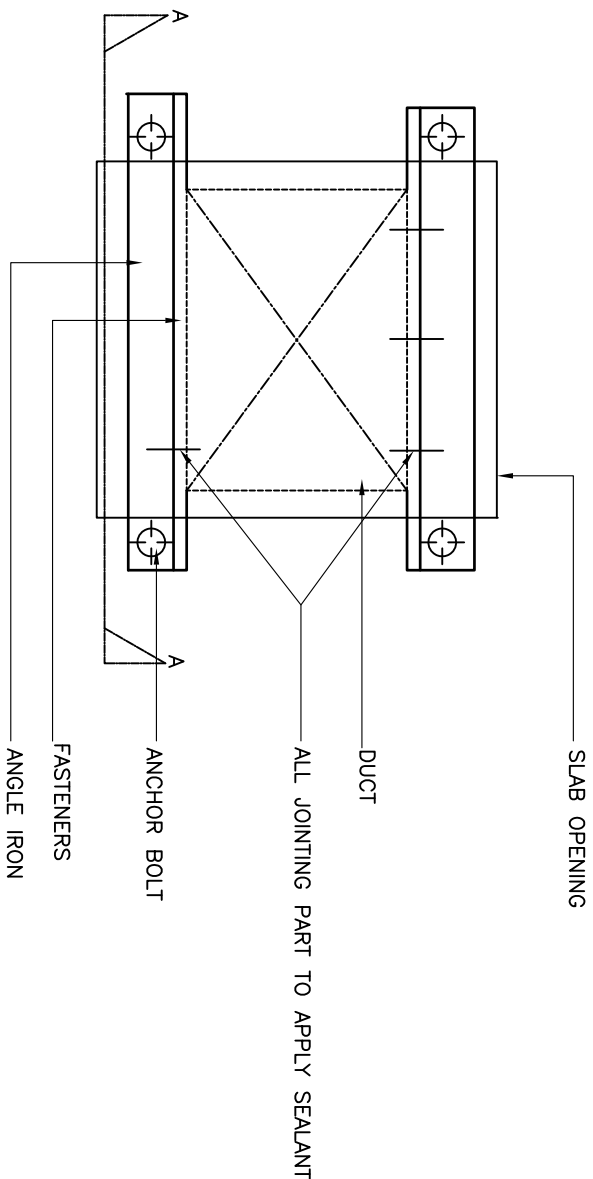

PLAN

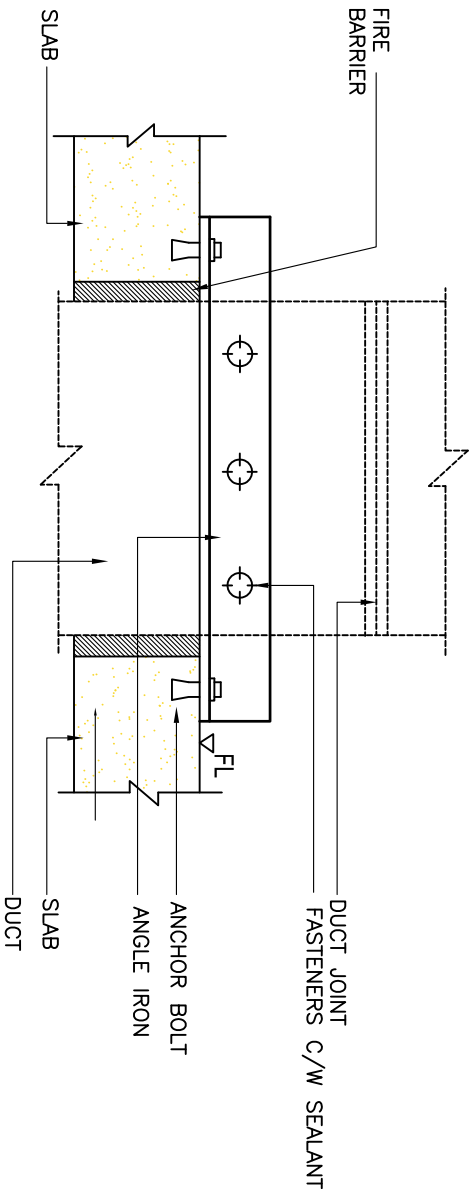

SECTION A-A

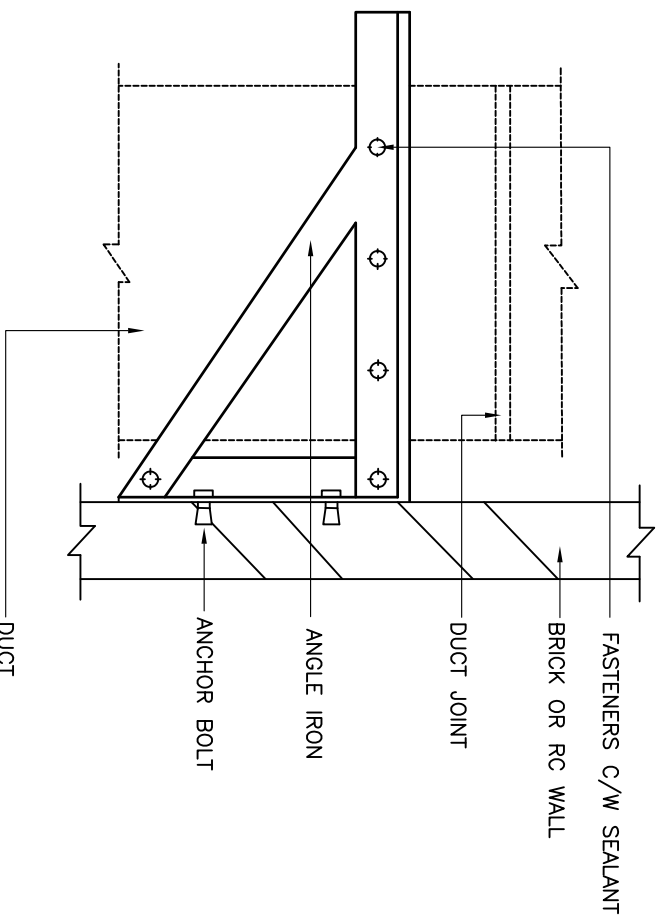


DUCT SUPPORT FOR DUCT RISER

ANCHORING INTO R.C WALL OR BRICK WALL


NOTE:

NOTE:

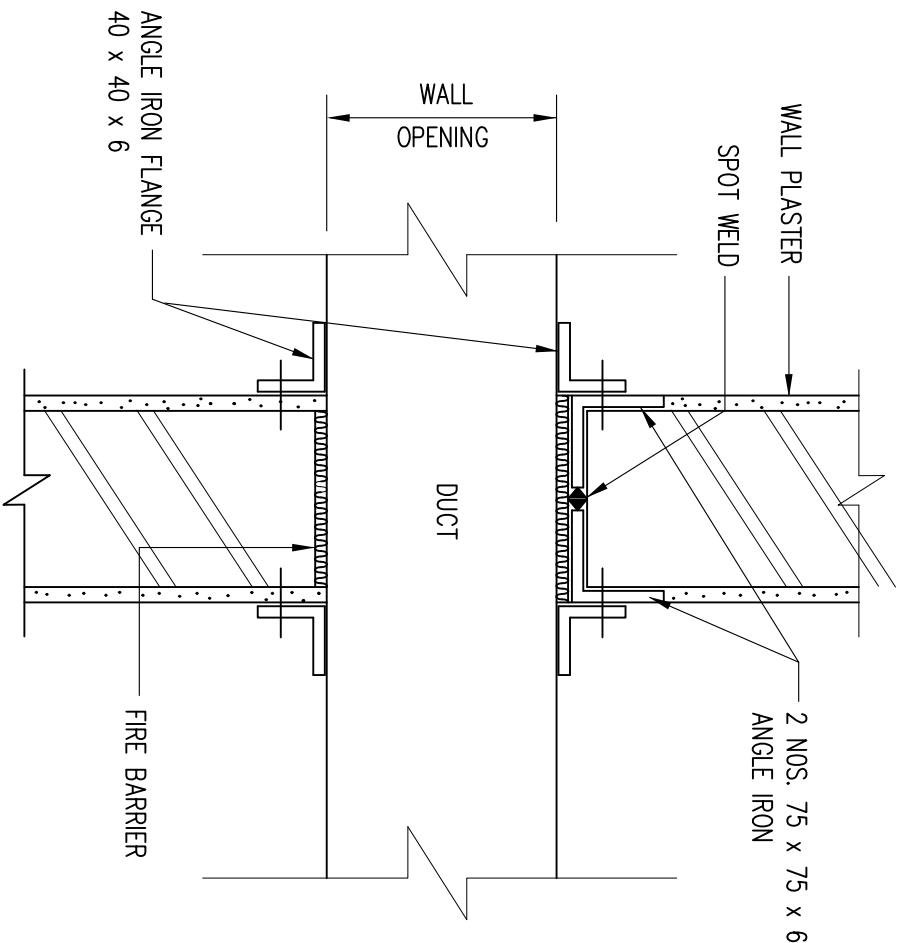

SECTION

A

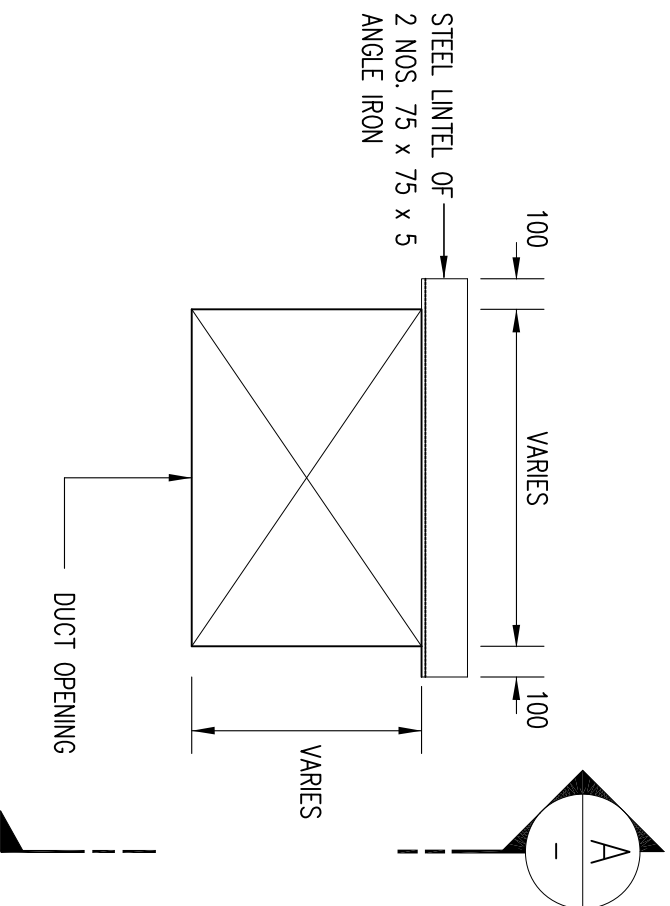


ELEVATION

STANDARD DETAIL OF DUCT FIRE BARRIER

THROUGH FLOOR SLAB & FIRE COMPARTMENT WALL

JKR MEKANIKA JASA KEPADA RAKYAT CAWANGAN KEJURUTERAAN MEKANIKA Ibu Pejabat JKR Malaysia	
AIR CONDITIONING SYSTEM	
DUCT PENETRATION DETAIL	
DATE	SCALE
2017	N.T.S
DRAWING NUMBER	
CKM/STD/AC/DUCT/REV2017/25	

NOTE:

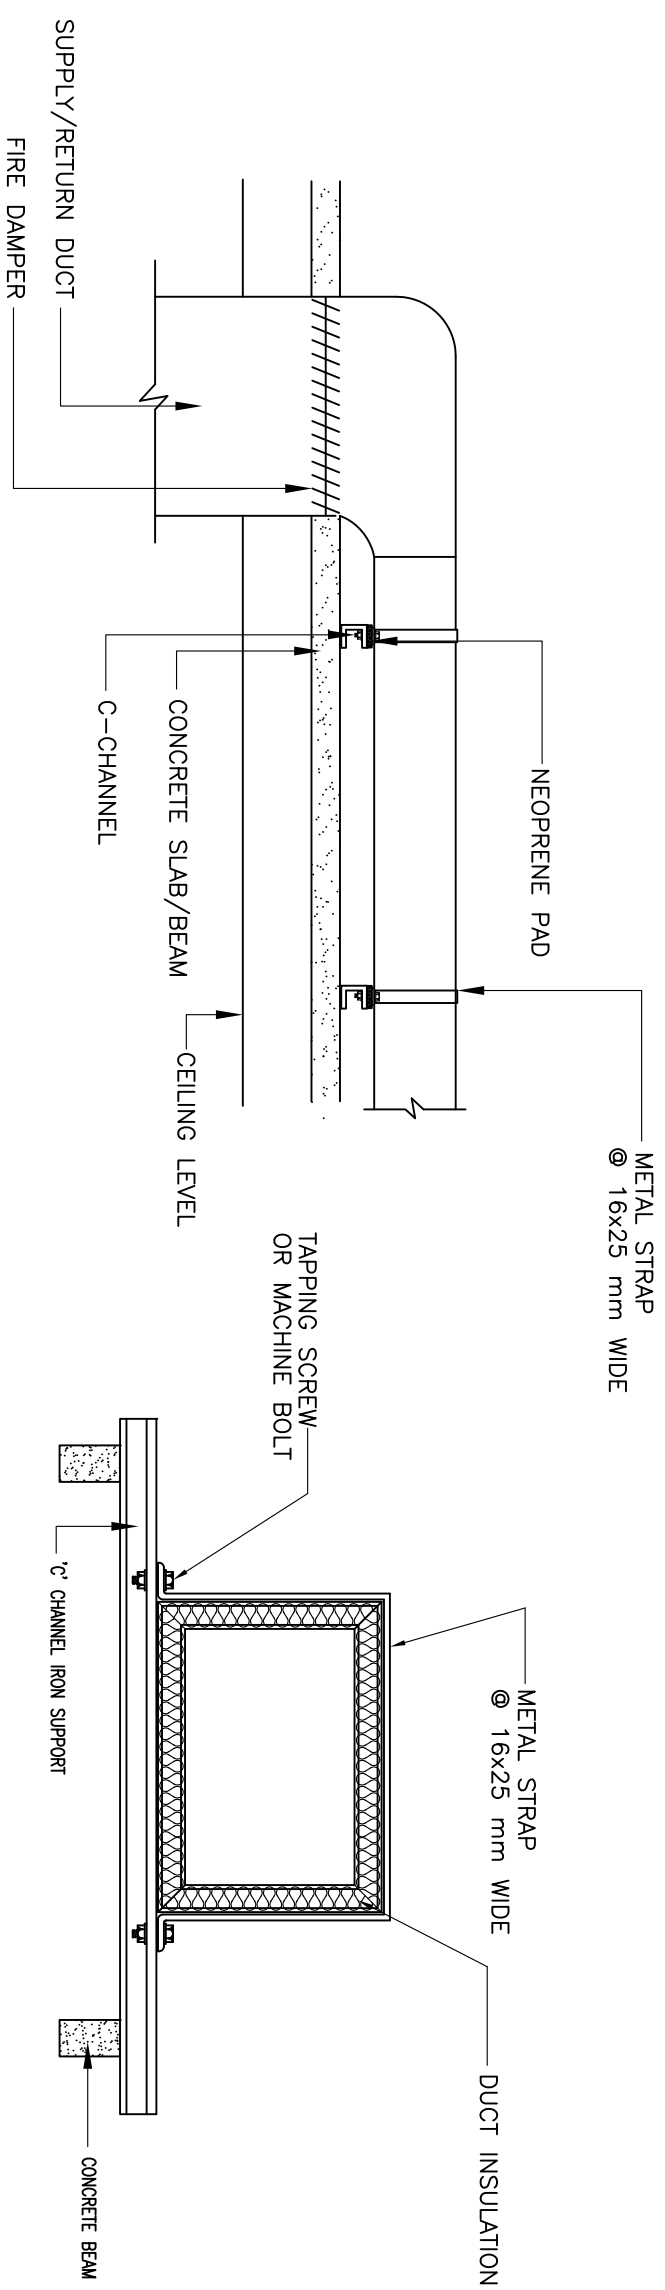


NOTE:
POSITION OF 'C' CHANNELS TO SUPPORT THE DUCTS
SHALL BE DETERMINED AT SITE

DUCT SUPPORT AND BRACKET DETAIL

	
JASA KEPADA RAKYAT	
CAWANGAN KEJUTERAAN MEKANIKAL	
Ibu Pejabat JKR Malaysia	
AIR CONDITIONING SYSTEM	
DUCT SUPPORT AND BRACKET DETAIL	
DATE	SCALE
2017	N.T.S
DRAWING NUMBER	
CM/MTD/AC/DUCT/REV/2017/7/26	

NOTE:

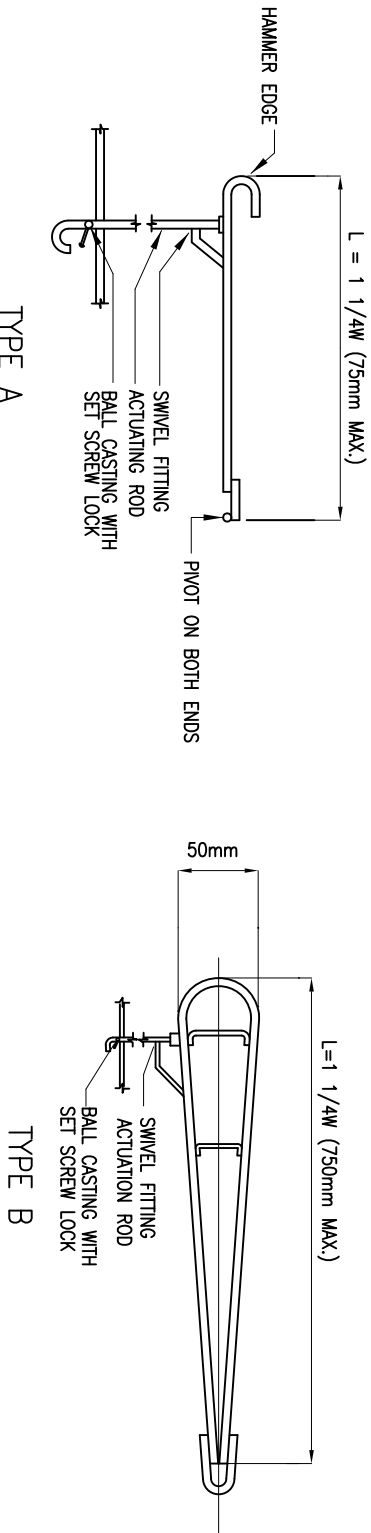

TYPE A

TYPE B

SPLITTER DAMPERS

SPLITTER DAMPERS
INSTALLATION OF SPLITTER
DAMPER

SCHEDULE OF SPLITTER DAMPER

DUCT WIDTH (W)	DUCT HEIGHT 0 – 600 MM					DUCT HEIGHT 601 – 1500 MM					DUCT HEIGHT ABOVE 1500 MM				
	SPLITTER TYPE	SIZE OF HINGE	NO. OF HINGES	SIZE OF ADJUST ROD	NO. OF RODS	SPLITTER TYPE	SIZE OF HINGES	NO. OF HINGES	SIZE OF ADJUST ROD	NO. OF RODS	SPLITTER TYPE	SIZE OF HINGES	NO. OF HINGES	SIZE OF ADJUST ROD	NO. OF RODS
SPLITTER DAMPERS FOR BRANCH TAKE OFFS															
UP TO 400 MM	TYPE A	50 MM HINGE	2	5 MM	1	TYPE B	HINGE ROD 5 MMØ	CONT.	5 MM	2	TYPE B	HINGE ROD 5 MM	CONT.	8 MMØ	3
451 MM TO 700 MM	TYPE B	HINGE ROD 15 MMØ	CONT.	5 MM	1	TYPE A	HINGE ROD 20 MMØ	CONT.	5 MM	2	TYPE B	HINGE ROD 20 MM	CONT.	8 MMØ	3
SPLITTER DAMPERS FOR TEES AND SIMILAR															
UP TO 450 MM	TYPE A	50 MM HINGE	2	5 MM	1	TYPE B	HINGE ROD 15 MMØ	CONT.	5 MMØ	2	TYPE B	HINGE ROD 20 MMØ	CONT.	8 MMØ	3
451 MM TO 700 MM	TYPE B	HINGE ROD 15 MMØ	CONT.	5 MM	1	TYPE A	HINGE ROD 20 MMØ	CONT.	5 MMØ	2	TYPE B	HINGE ROD 25 MMØ	CONT.	8 MMØ	3

SPLITTER DAMPER DETAIL

JKR

MEKANIKAL

JASA KEPADA RAKYAT

CAWANGAN KEJURUTERAAN MEKANIKAL
Ibu Pejabat JKR Malaysia


AIR CONDITIONING SYSTEM

SPLITTER DAMPER DETAIL


DATE2017SCALEN.T.S

DRAWING NUMBERCKM/STD/AC/DUCT/REV/2017/27


NOTE:

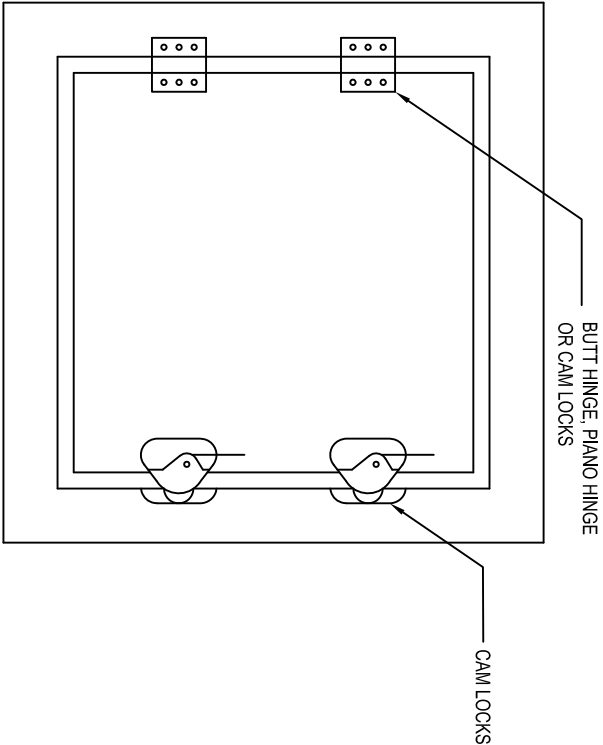


ACCESS DOOR

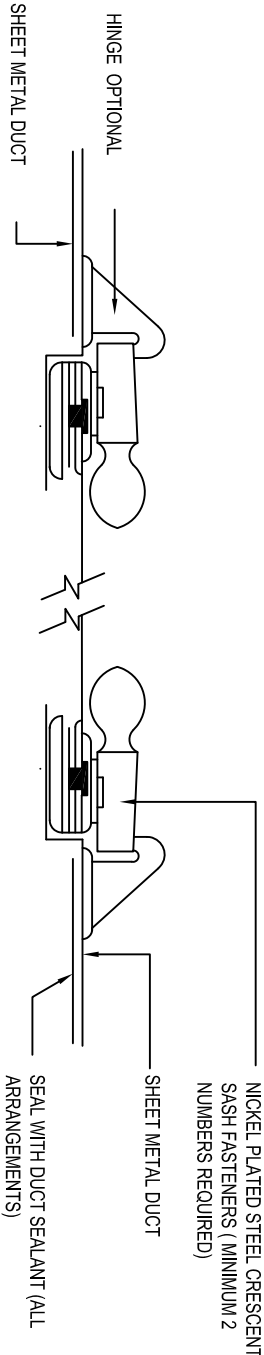

STANDARD DUCTWORK

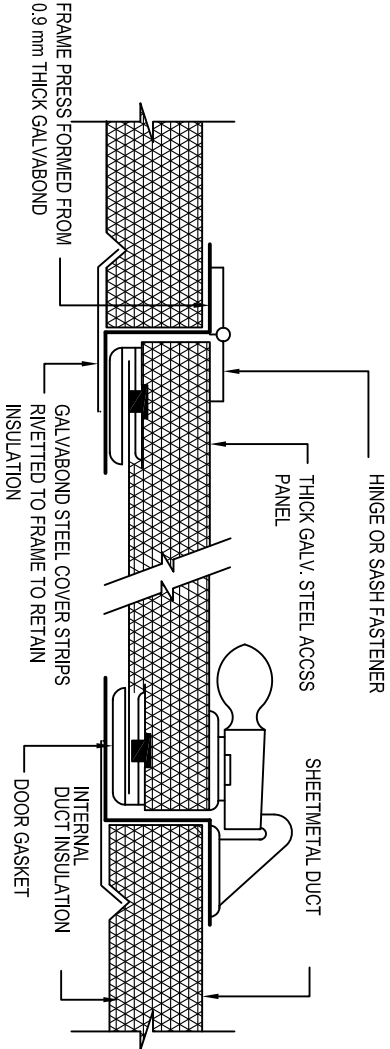

INTERNALLY INSULATED DUCTWORK


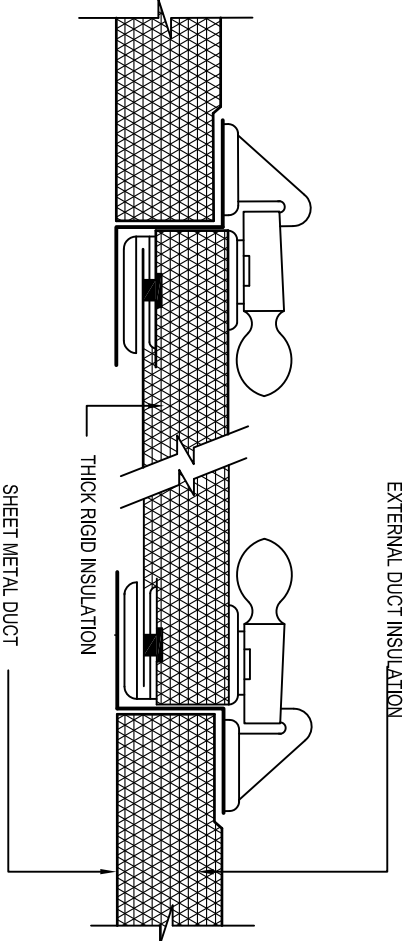


EXTERNALLY INSULATED DUCTWORK

- NOTES: 1) ACCESS OPENING SIZE SHALL BE MINIMUM OF 600 mm X 450 mm
- 2) FOR SMALLER DUCT WIDTH,DIMENSION MAY BE TO REDUCE THE WIDTH OR DEPTH OF DUCT



DUCTWORK ACCESS PANELS

NOTE:

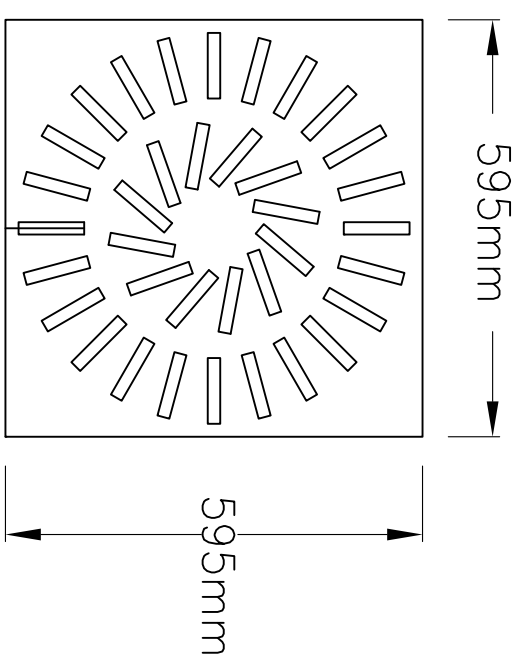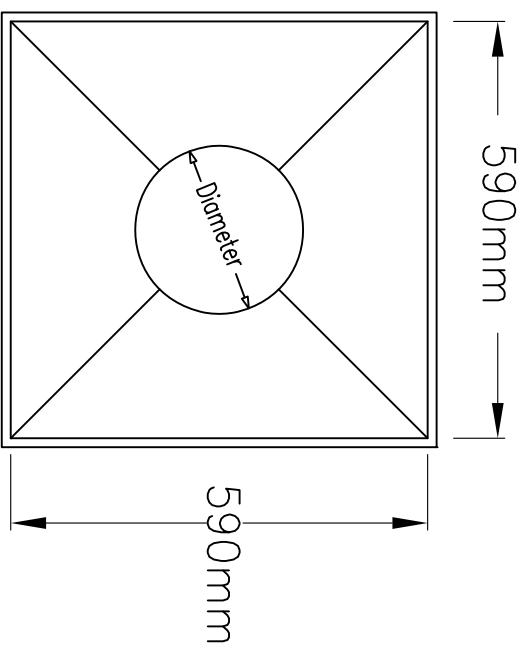

TOP VIEW

BOTTOM VIEW

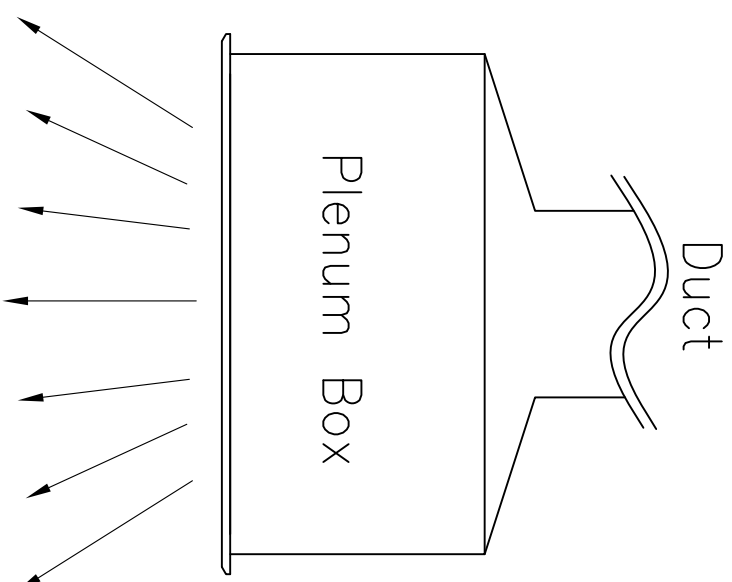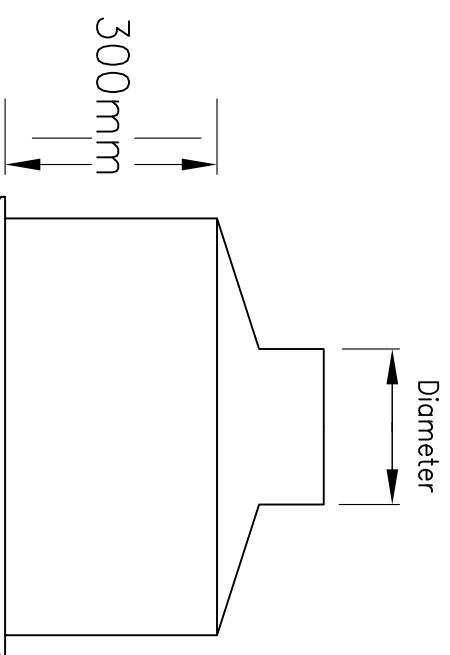

SIDE VIEW

SQUARE SWIRL DIFFUSER DETAIL

 JASA KEPADA RAKYAT CAWANGAN KEJURUTERAAN MEKANIKAL Ibu Pejabat JKR Malaysia		AIR CONDITIONING SYSTEM SQUARE SWIRL DIFFUSER DETAIL
DATE	2017	SCALE
DRAWING NUMBER		N.T.S
CKM/STD/AC/DUCT/REV/2017/129		

NOTE:

SCHEDULE OF APPROVED DUCT ELEMENTS						
DUCT WIDTH	ELBOWS		TEES		TAKE – OFFS	
	APPROVED TYPES	REF. FIG.NO.	APPROVED TYPES	REF. FIG.NO.	APPROVED TYPES	REF. FIG.NO.
UP TO 180mm	UNVANE ELBOWS (R1 < 3/4 W)	2	CORNER RADIUS R1 < 3/4 W (UNVANED)	5	CORNER RADIUS R1 < (3/4 W (UNVANED)	6
					RADIUSSED CORNER	6
181mm TO 400mm	UNVANE ELBOWS (R1 < 3/4 W)	2	CORNER RADIUS R1 < 3/4 W (UNVANED)	5	RADIUSSED CORNER	8
	SINGLE VANED ELBOWS (R1 < 1/2W)	3	CORNER RADIUS R1 < 1/2 W (SINGLE VANED)	5	CORNER RADIUS R1 < (1/2 W (UN VANED)	6
	SQUARE ELBOWS WITH TYPE 'B' VANES	1	SQUARE CORNER WITH TYPE 'B' VANES	4	CORNER RADIUS R1 < 1/2 W (SINGLE VANED)	6
					SQUARE CORNER WITH TYPE 'B' VANES	7
401mm TO 600mm	UNVANE ELBOWS (R1 < 3/4 W)	2	CORNER RADIUS R1 < 3/4 W (UNVANED)	5	RADIUSSED CORNER	8
	SINGLE VANED ELBOWS (R1 < 1/2W)	3	CORNER RADIUS R1 < 1/2 W (SINGLE VANED)	5	CORNER RADIUS R1 < (3/4 W (UNVANED)	6
	SQUARE ELBOWS WITH TYPE 'B' VANES	1	SQUARE CORNER WITH TYPE 'B' VANES	4	CORNER RADIUS R1 < (1/2 W (SINGLE VANED)	6
					SQUARE CORNER WITH TYPE 'B' VANES	6
ABOVE 600mm	DOUBLE VANED ELBOWS (R1 < 1/4W)	3	CORNER RADIUS R1 < 1/4W (DOUBLE VANED)	5	CORNER RADIUS R1 < (1/4 W (SINGLE VANED)	8
	SQUARE ELBOWS WITH TYPE 'A' VANES	1	SQUARE CORNER WITH TYPE 'A' VANES	4	SQUARE CORNER WITH TYPE 'A' VANES	7

NOTES :
1. THE TYPE DUCT ELEMENT TO BE PROVIDED SHALL BE IN ACCORDANCE WITH THE ABOVE UNLESS OTHERWISE APPROVED OR DIRECTED.
2. WHERE ALTERNATIVE ARE SCHEDULE EQUAL CONSIDERATIONS WILL BE TO ALL TYPE.

DUCT CONSTRUCTION DETAIL



JASA KEPADA RAKYAT

CAWANGAN KEJURUTERAAN MEKANIKAL

Ibu Pejabat JKR Malaysia

AIR CONDITIONING SYSTEM

DUCT CONSTRUCTION DETAIL

DATE


2017

SCALE


N.T.S

DRAWING NUMBER


CKM/STD/AC/DUCT/REV/2017/03

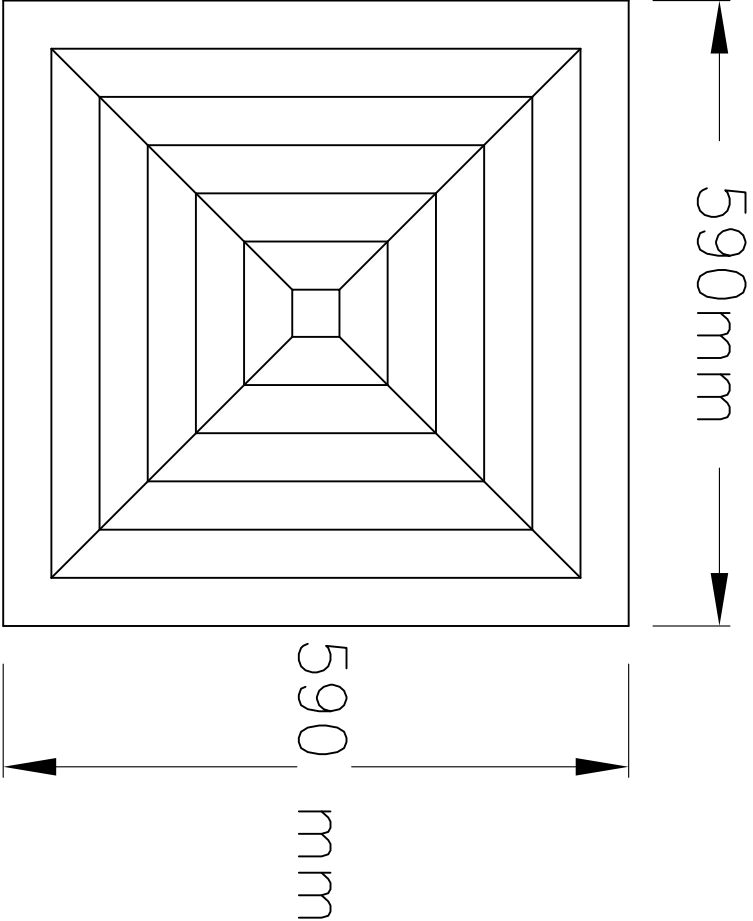



TOP VIEW

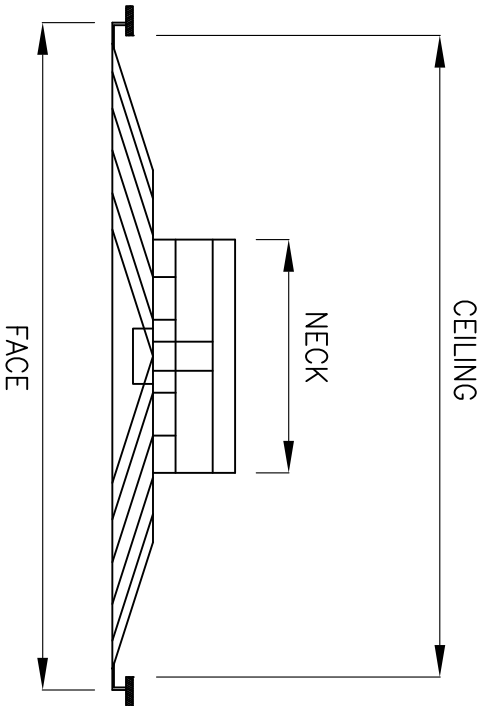

SIDE VIEW

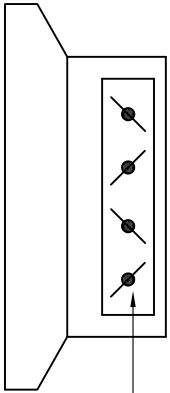

VOLUME CONTROL
DAMPER

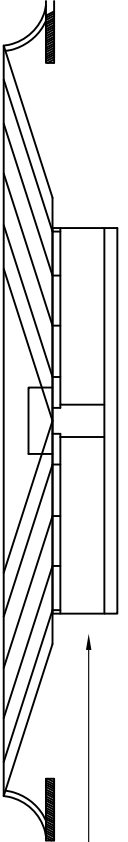 


AIR
DIFFUSER

EXPLODED VIEW

NOTE:


 JASA KEPADA RAKYAT CAWANGAN KEJURUTERAAN MEKANIKAL Ibu Pejabat JKR Malaysia	
AIR CONDITIONING SYSTEM	
SQUARE DIFFUSER DETAIL	
DATE	SCALE
2017	N.T.S
DRAWING NUMBER	
CKM/STD/AC/DUCT/REV/2017/30	

NOTE:

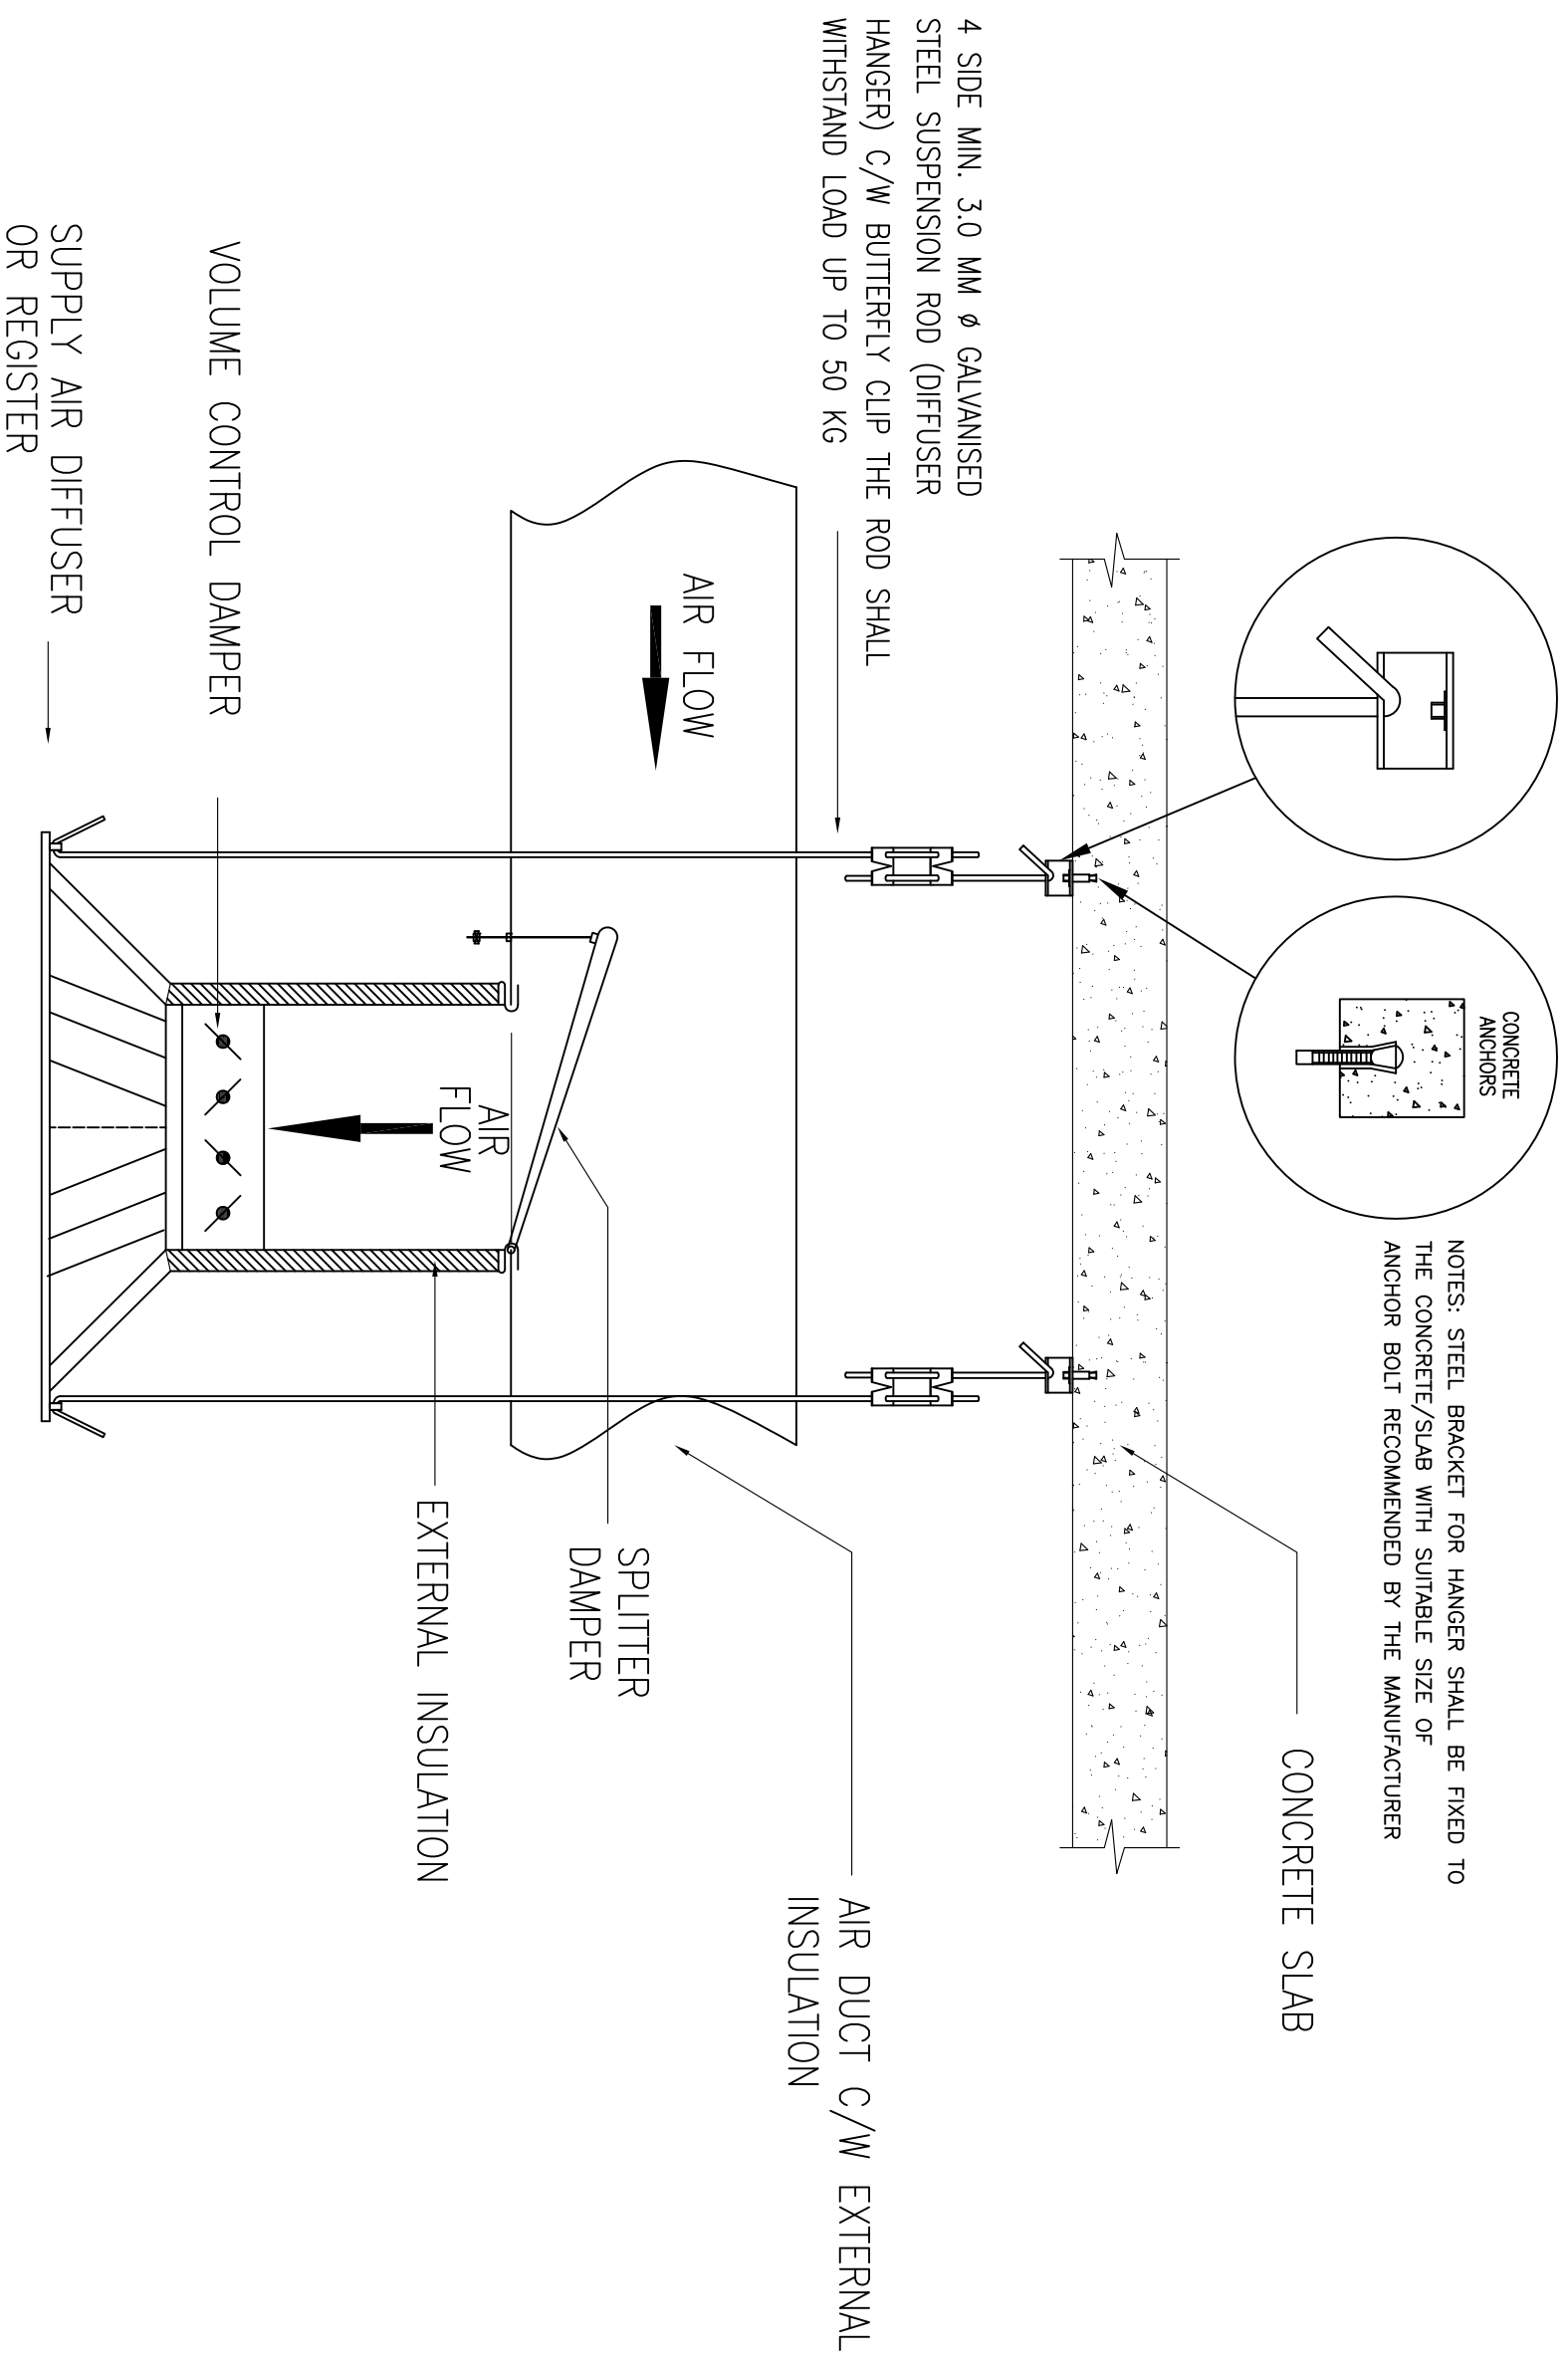

TYPICAL DETAIL OF SQUARE DIFFUSER CONNECTION


NOTE:

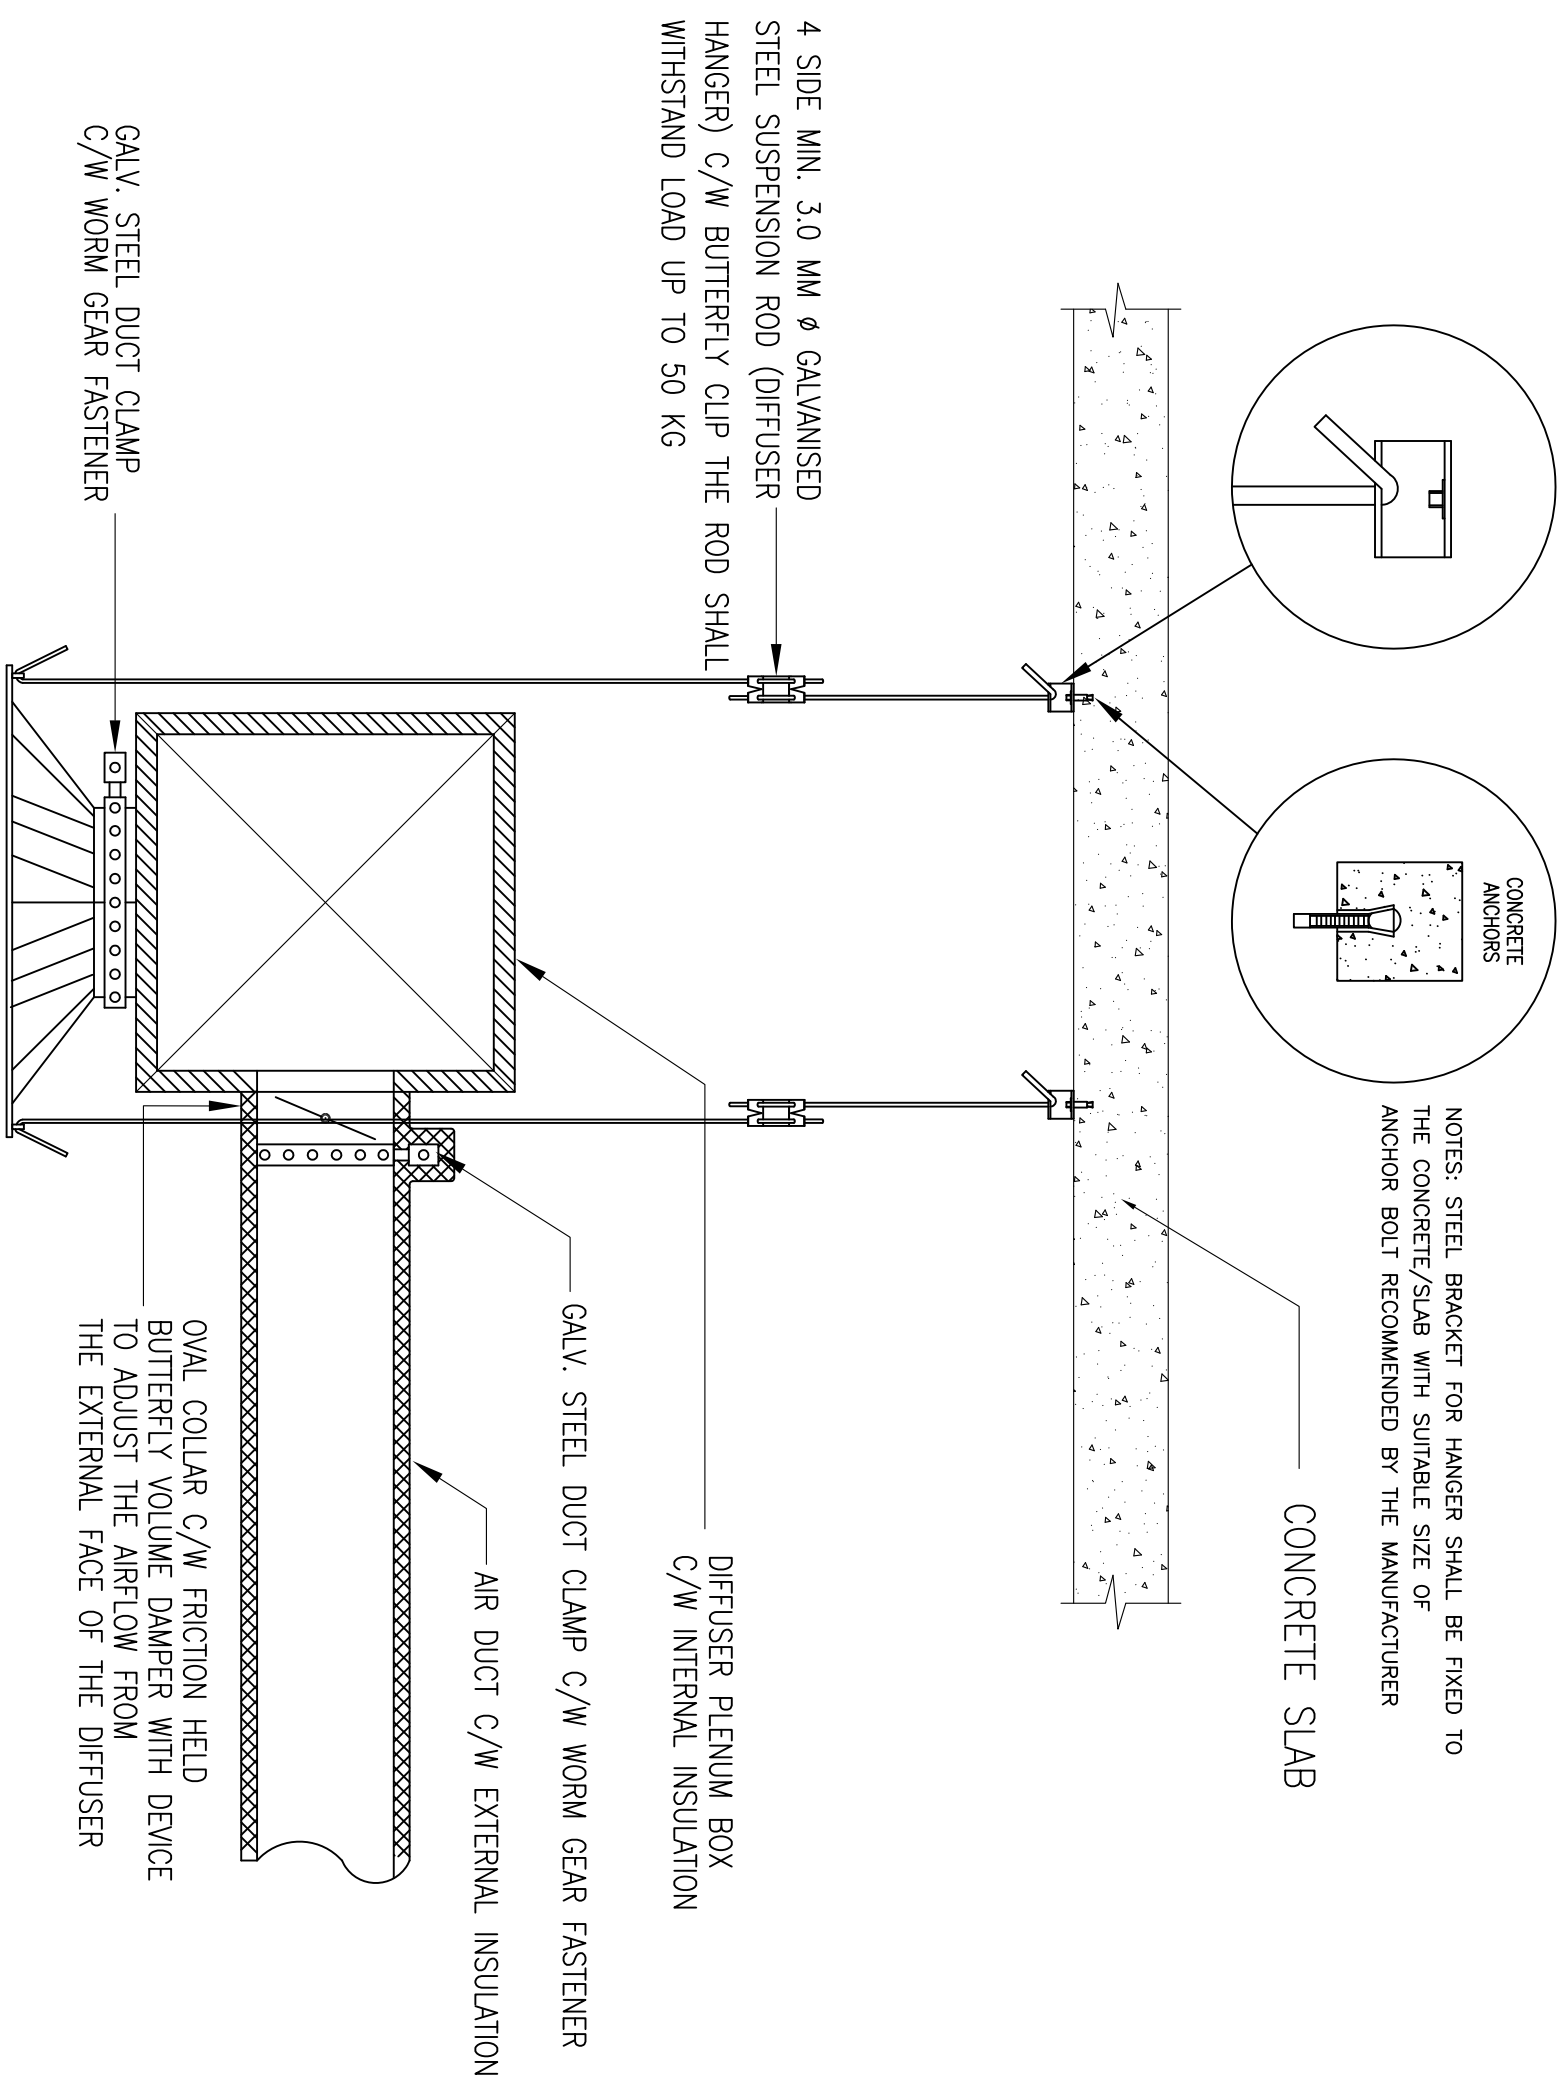

TYPICAL DETAIL OF SQUARE DIFFUSER CONNECTION WITH PLENUM BOX

AIR CONDITIONING SYSTEM	
TYPICAL DETAIL OF SQUARE DIFFUSER CONNECTION WITH PLENUM BOX	
DATE	2017
SCALE	N.T.S
DRAWING NUMBER	
CKM/STD/AC/DUCT/REV/2017/32	

STEEL BAR (M&E PURLIN)
- BY MAIN CONTRACTOR

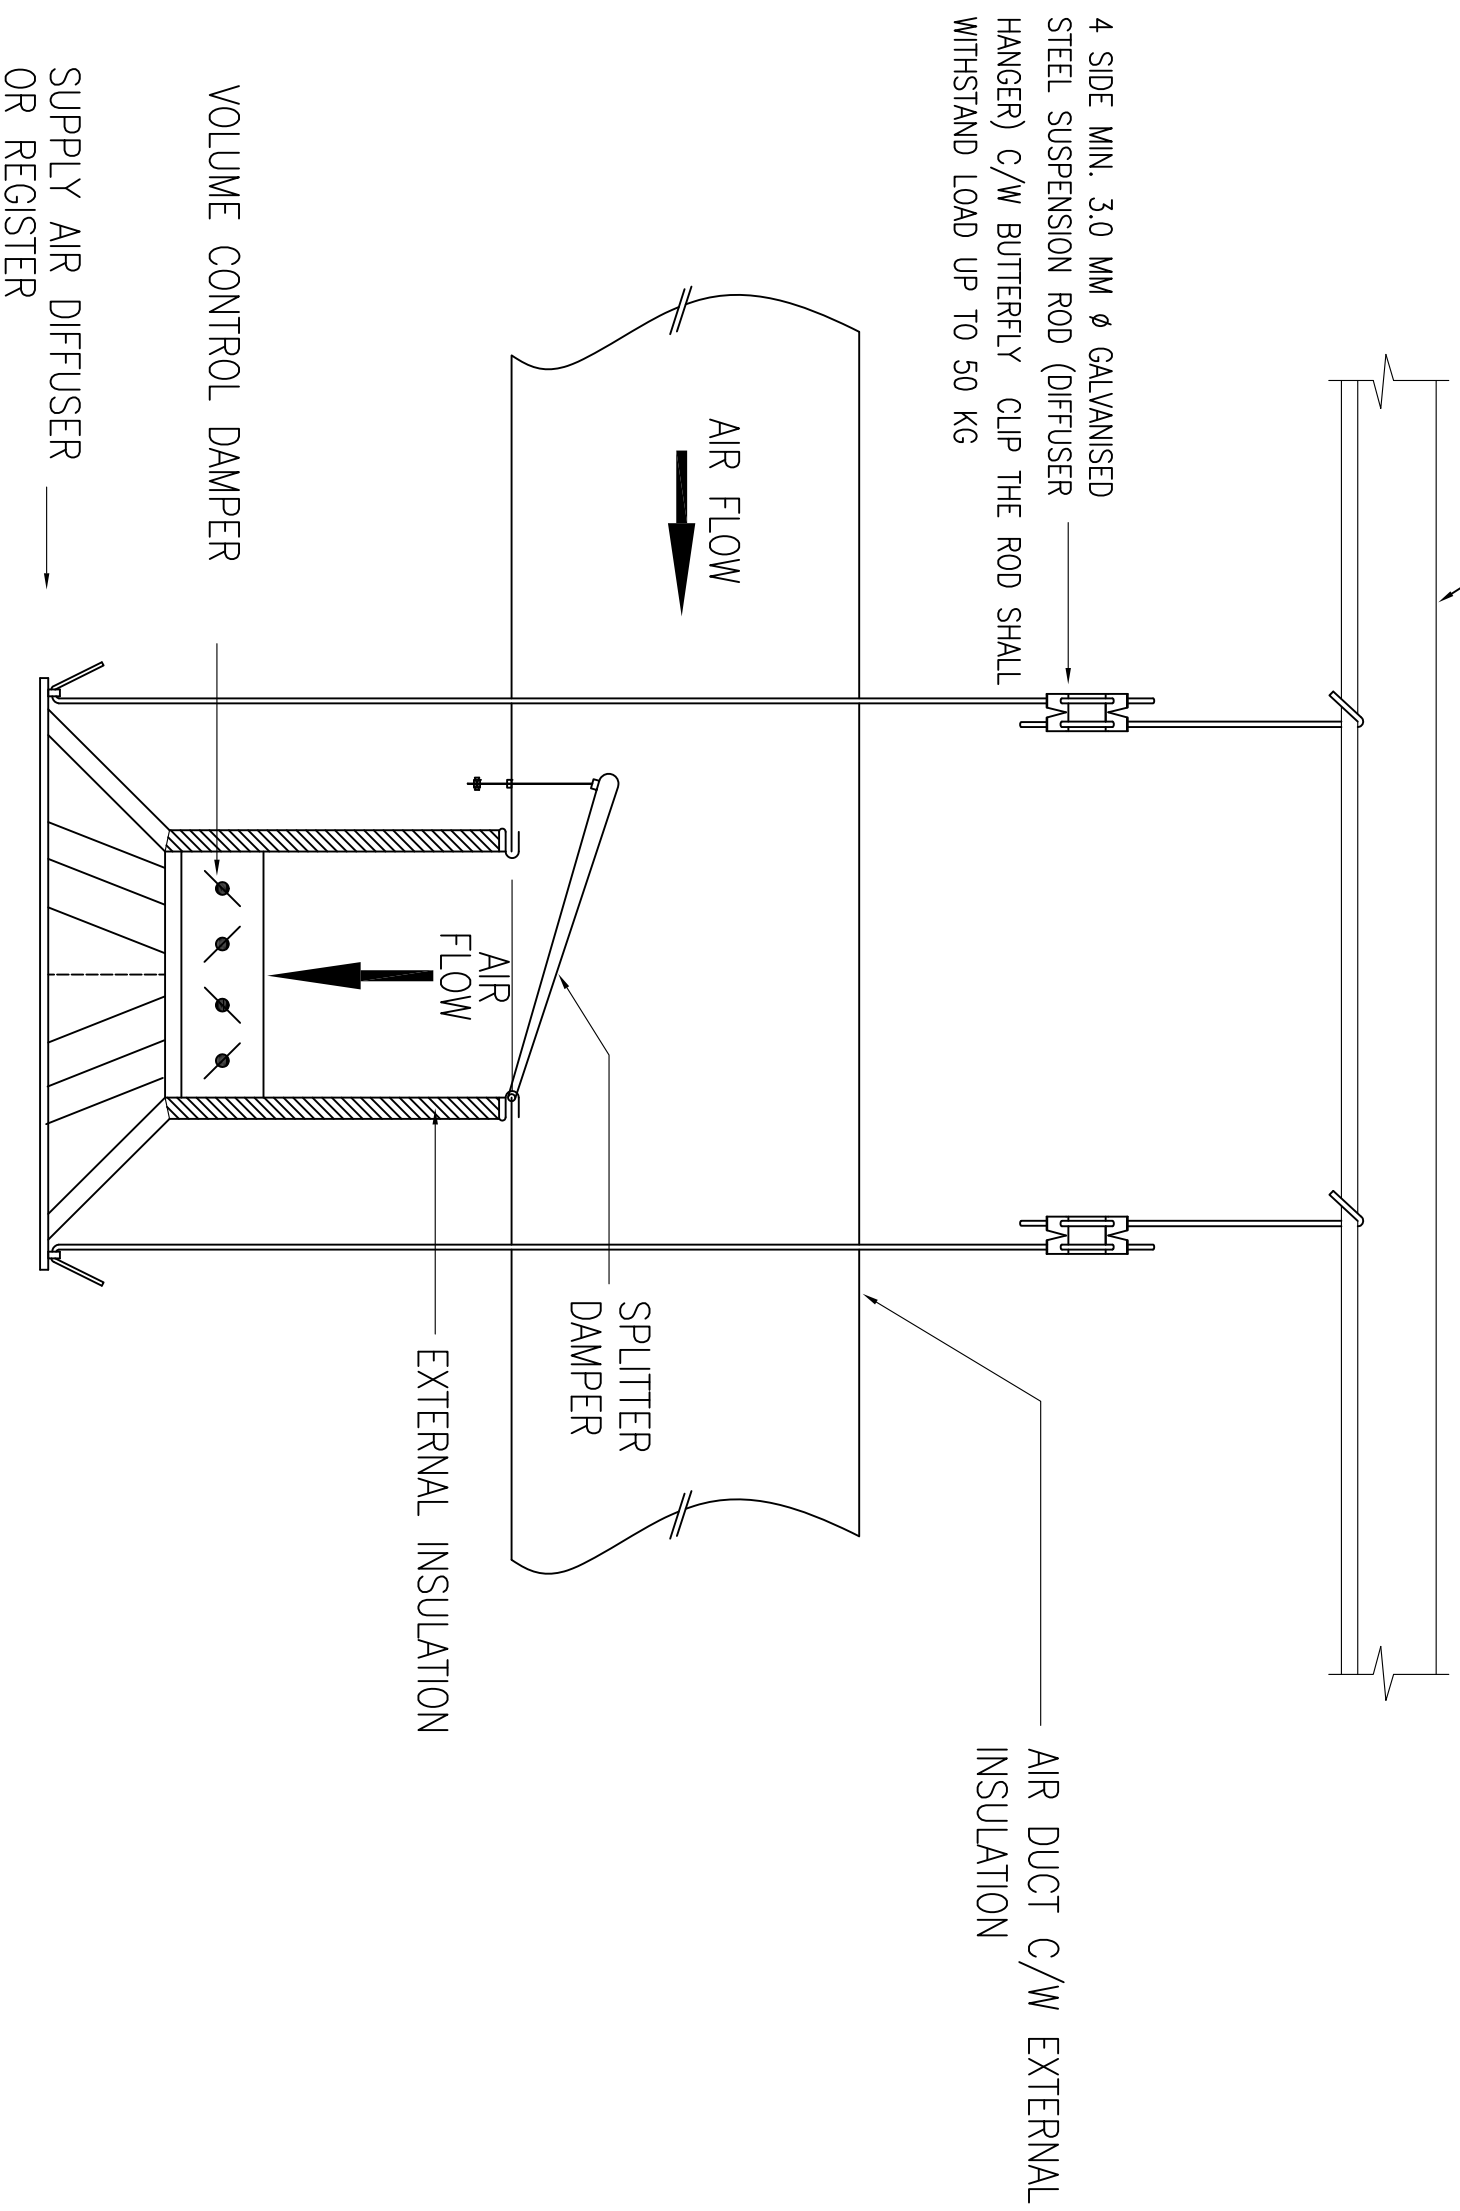

TYPICAL DETAIL OF SQUARE DIFFUSER CONNECTION
(UNDER THE ROOF)

NOTE



JASA KEPADA RAKYAT

CAWANGAN KEJURUTERAAN MEKANIKAL
Ibu Pejabat JKR Malaysia

AIR CONDITIONING SYSTEM


TYPICAL DETAIL OF SQUARE DIFFUSER CONNECTION

2017

N.T.S

DRAWING NUMBER

CKM/STD/AC/DUCT/REV2017/33

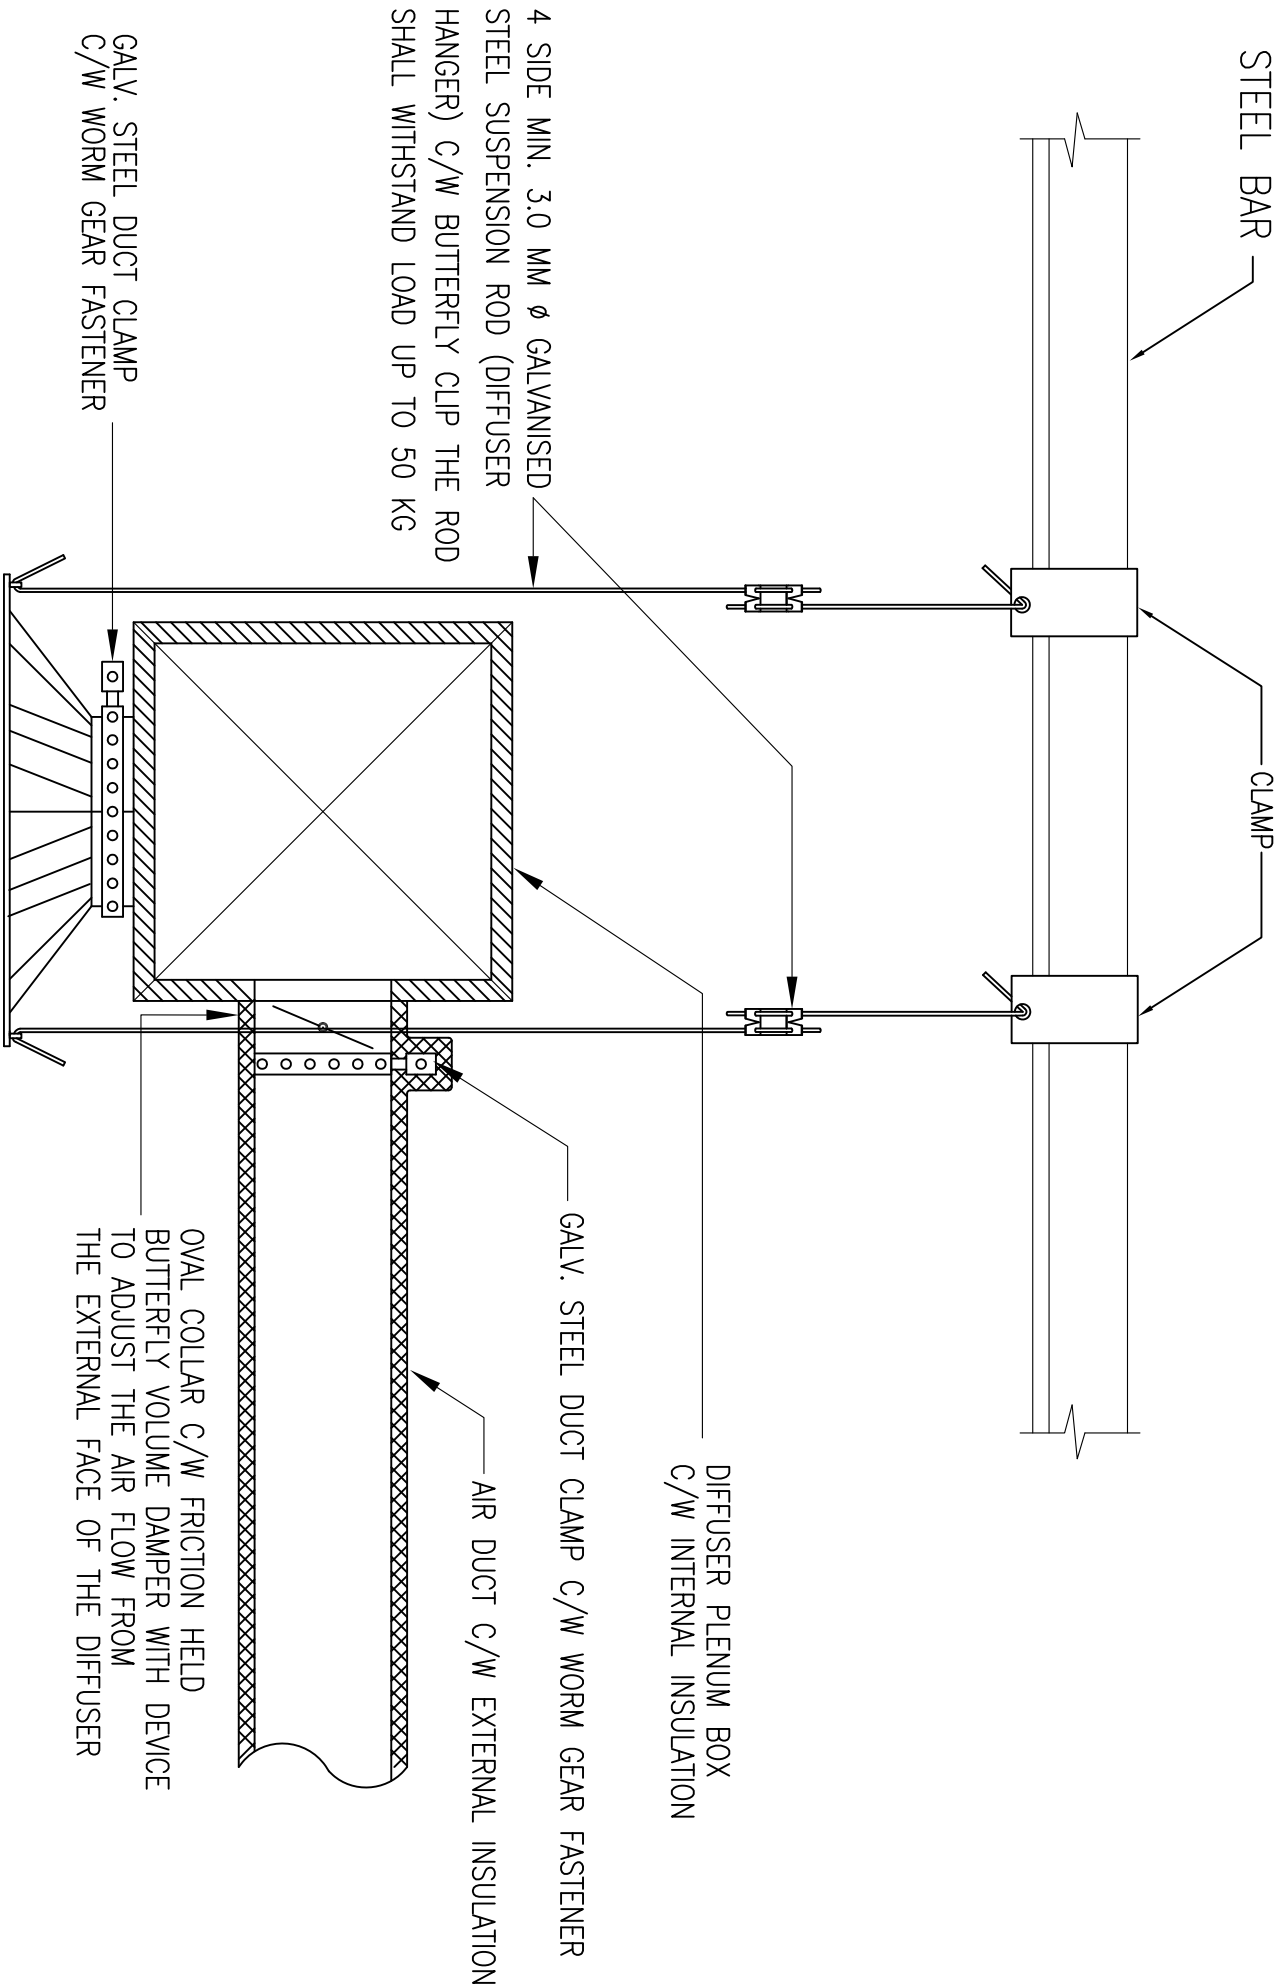

TYPICAL DETAIL OF SQUARE DIFFUSER CONNECTION WITH PLENNUM BOX
(UNDER THE ROOF)

NOTE:




CAWANGAN KEJURUTERAAN MEKANIKAL
Ibu Pejabat JKR Malaysia

AIR CONDITIONING SYSTEM

TYPICAL DETAIL OF SQUARE DIFFUSER
CONNECTION WITH PLENNUM BOX

DATE	2017	SCALE	N.T.S
DRAWING NUMBER	CKMSTD/AC/DUCT/REV/2017/34		

NOTE:

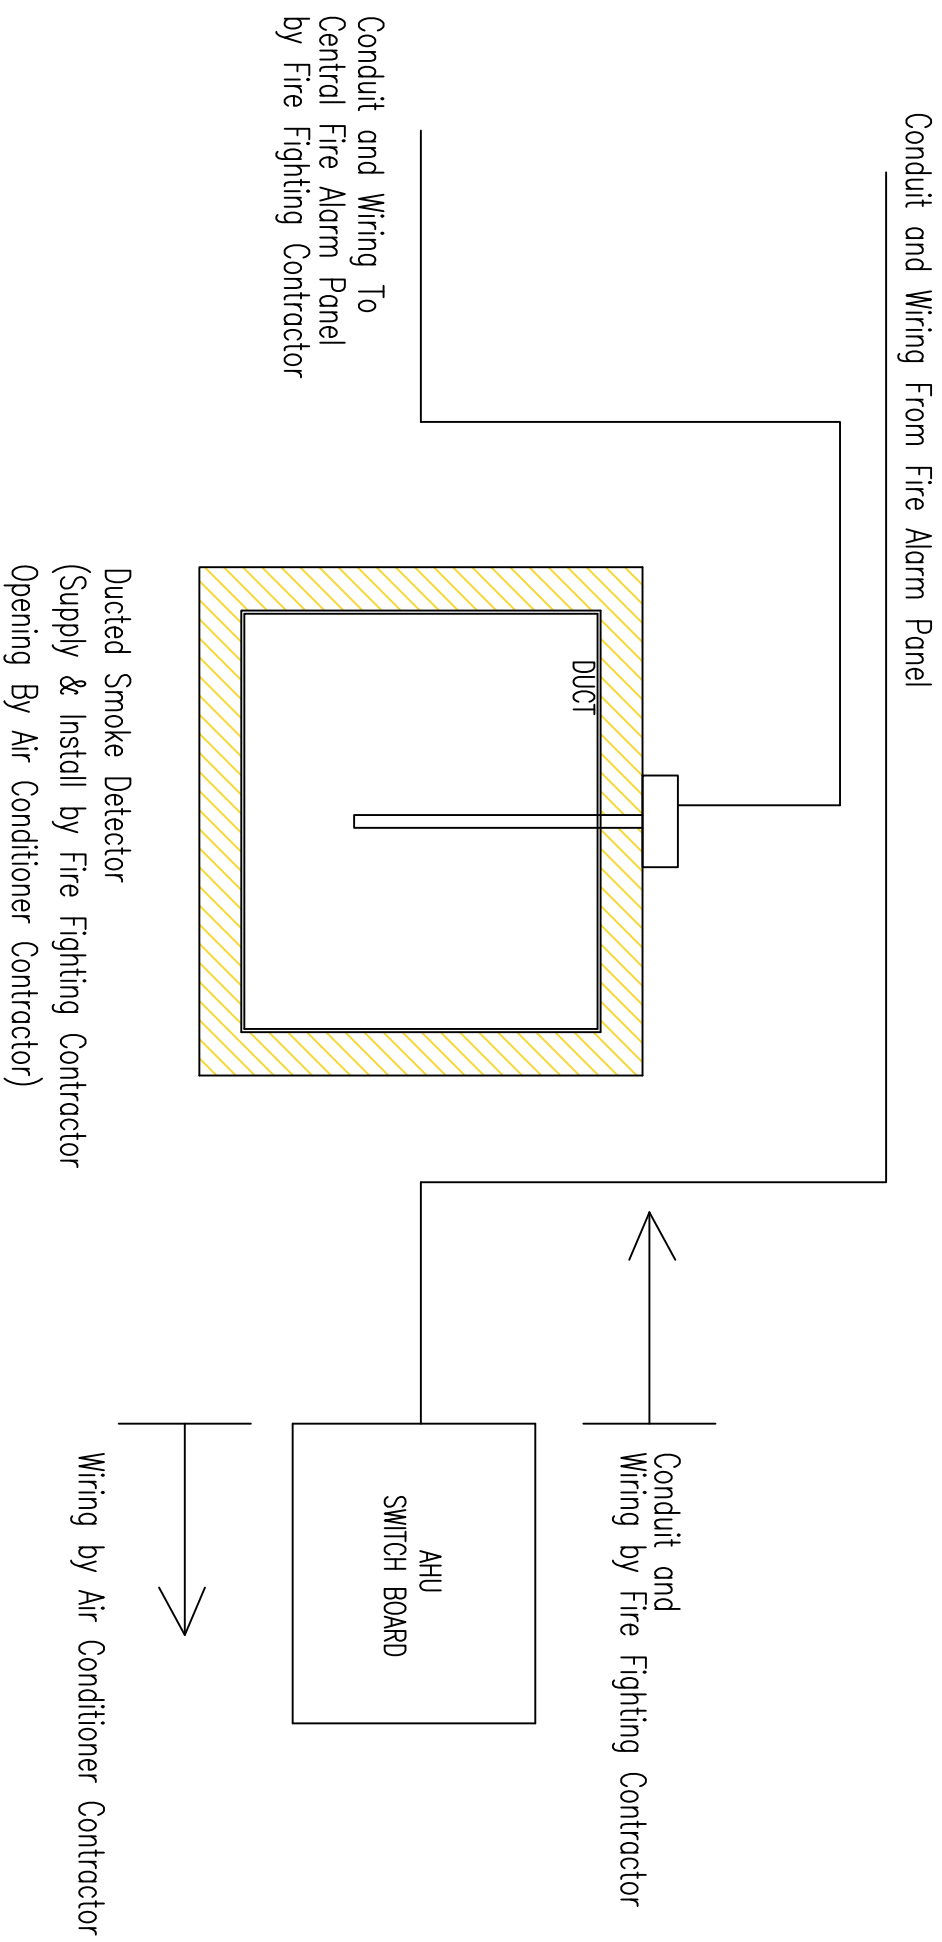

NOTES: DUCT SMOKE DETECTOR MOUNTING SHALL BE PROVIDED INSIDE THE RETURN DUCT ADJACENT TO DUCT ACCESS DOOR

INSTALLATION OF SMOKE DETECTOR INSIDE AIR CONDITIONER DUCTING



CAWANGAN KEJURUTERAAN MEKANIKAL
Ibu Pejabat JKR Malaysia

AIR CONDITIONING SYSTEM

INSTALLATION OF SMOKE DETECTOR INSIDE DUCTING

DAI E

2017


SCALE

.T.S


DRAWING NUMBER

CKM/STD/AC/DUCT/REV2017/35

NOTE:



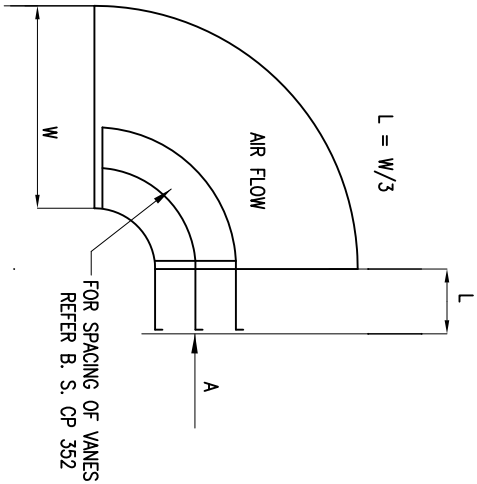


VANES FOR SHORT RADIUS ELBOWS

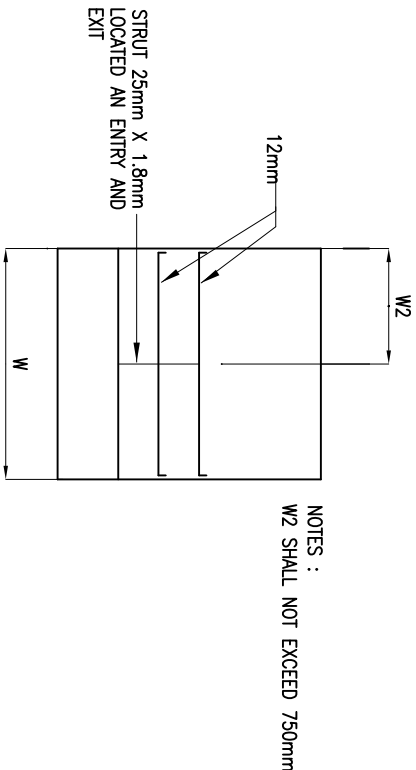

VIEW ON ARROWS 'A'

VANES FOR SHORT RADIUS ELBOWS

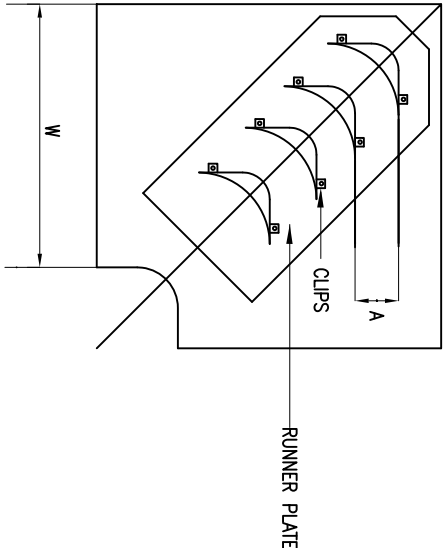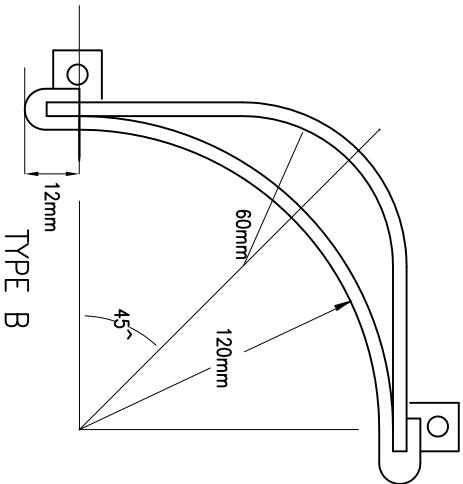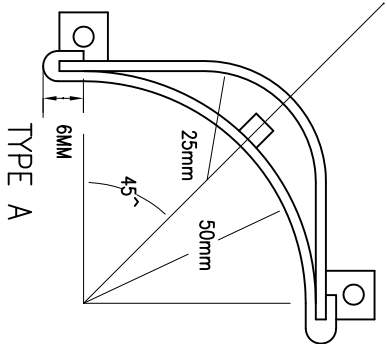

VANES FOR SQUARE ELBOWS (IF APPLICABLE)

SCHEDULES OF VANES					
ELBOWS WIDTH 'W'	VANES TYPE	VANE CONSTRUCTION		RUNNER PLATE CONSTRUCTION	
		PLATE THICKNESS (MM)	MAX. DISTANCE BETWEEN RUNNER PLATES (MM)	PLATE THICKNESS (MM)	PLATE WIDTH (MM)
600mm	TYPE B	0.6	600mm	0.6	115
ABOVE 600mm	TYPE A	0.8	900mm	0.8	200




JASA KEPADA RAKYAT
CAWANGAN KEJURUTERAAN MEKANIKAL
Ibu Pejabat JKR Malaysia

AIR CONDITIONING SYSTEM


VANES

NOTE:

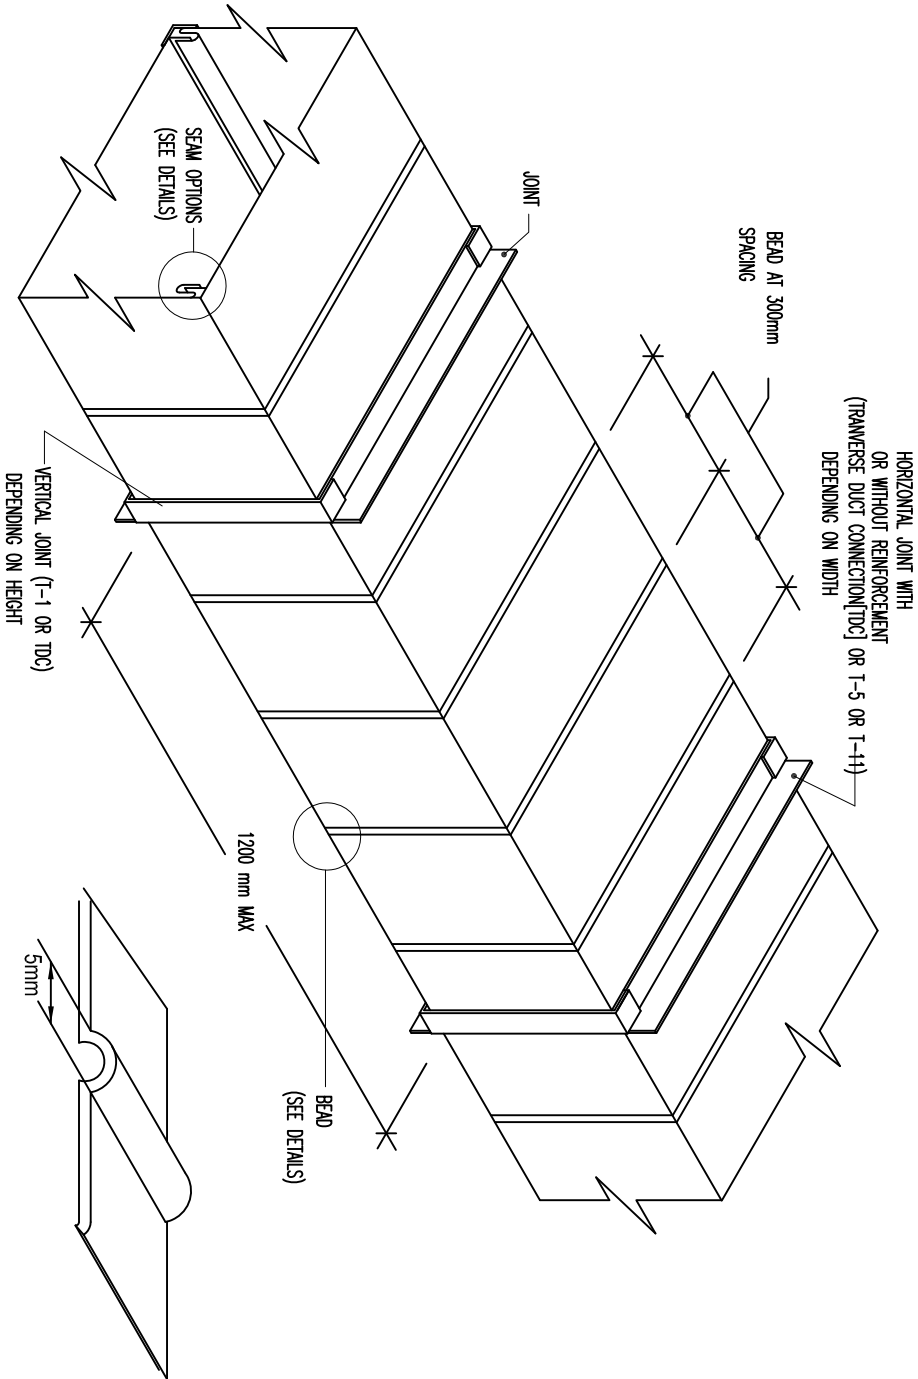


GENERAL LAYOUT OF DUCT CONSTRUCTION

(NOTES: SIZE OF DUCT SHALL REFER TO TECHNICAL SPECS)

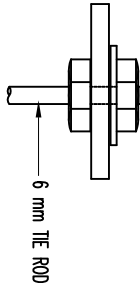

DETAIL 'A'
TIE ROD WITH INTERNAL AND EXTERNAL NUTS

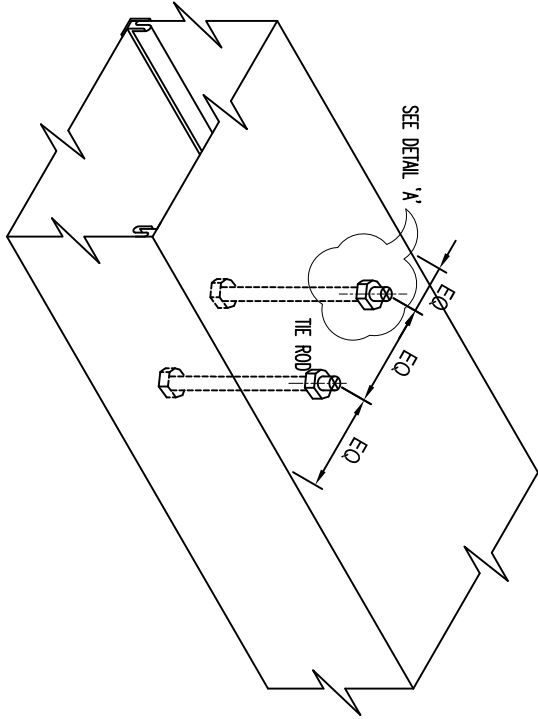

DETAIL FOR TIE ROD

(NOTES: SIZE OF DUCT SHALL REFER TO TECHNICAL SPECS)



JASA KEPADA RAKYAT


CAWANGAN KEJURUTERAAN MEKANIKAL
Ibu Pejabat JKR Malaysia

AIR CONDITIONING SYSTEM

GENERAL LAYOUT OF DUCT CONSTRUCTION

DATE	SCALE	N.T.S
2017		
DRAWING NUMBER		
CKM/STD/AC/DUCT/REV2017/05		


NOTE:

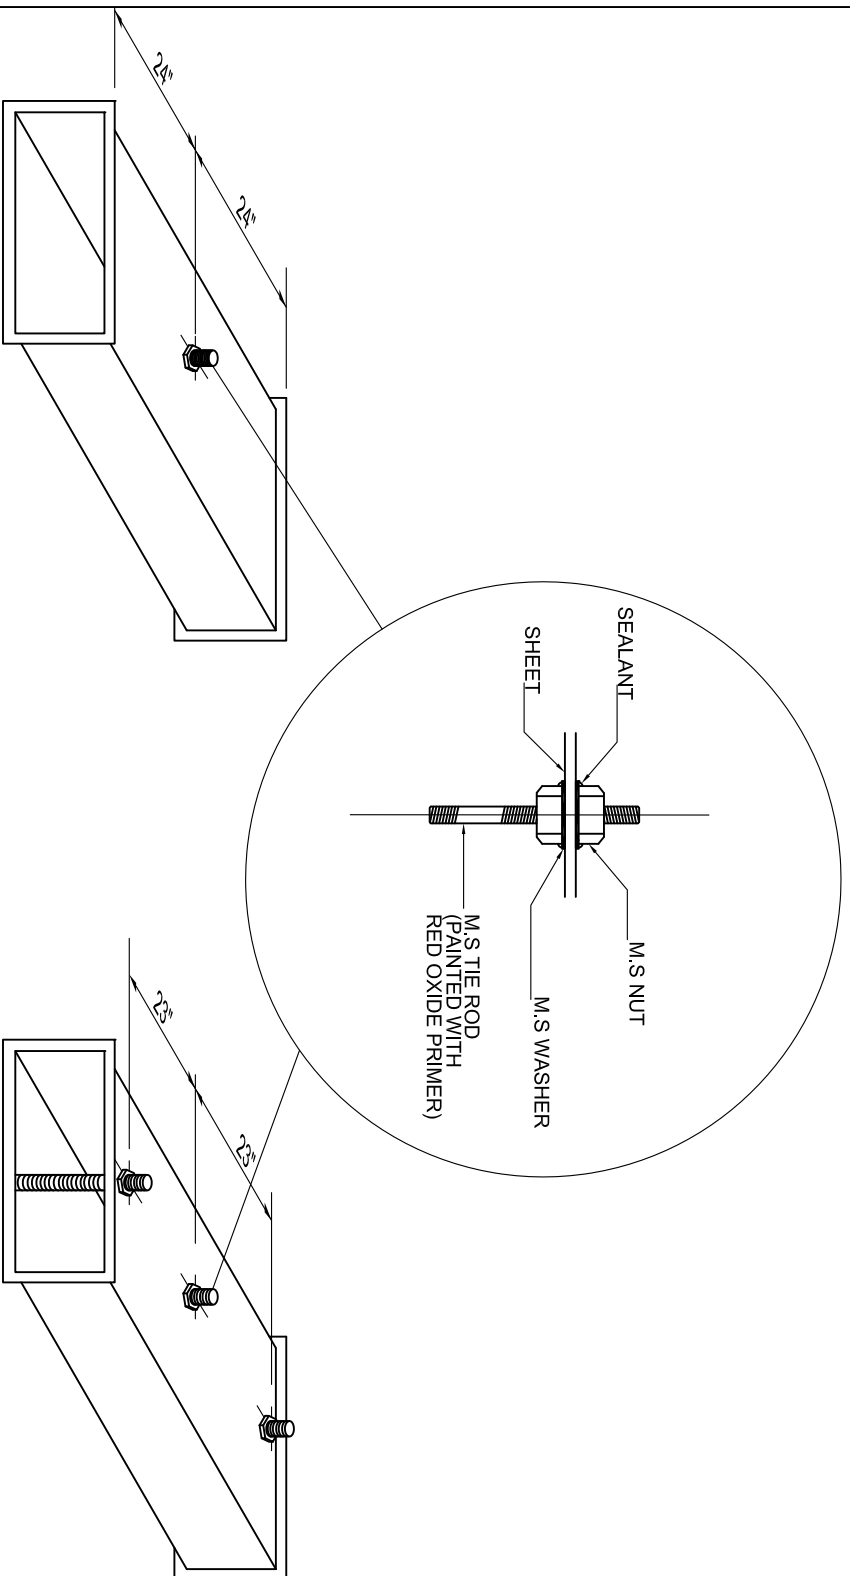


THE ROD CENTER (TRC) REQUIRES A TIE ROD IN THE EXACT CENTER OF THE DUCT SECTION

THE ROD CENTER/TIE ROD FLANGE (TRC/TRF)
THE TIE RODS AT THE FLANGES SHOULD BE LOCATED
1" FROM THE TDF FLANGES, WITH APPROPRIATE
SPACING ACROSS THE WIDTH OF THE DUCT.
THE ROD AT THE CENTER SHOULD BE LOCATED
AT THE CENTER OF THE DUCT IN LINE WITH THE
FLANGE TIE RODS.


THE ROD REINFORCEMENT

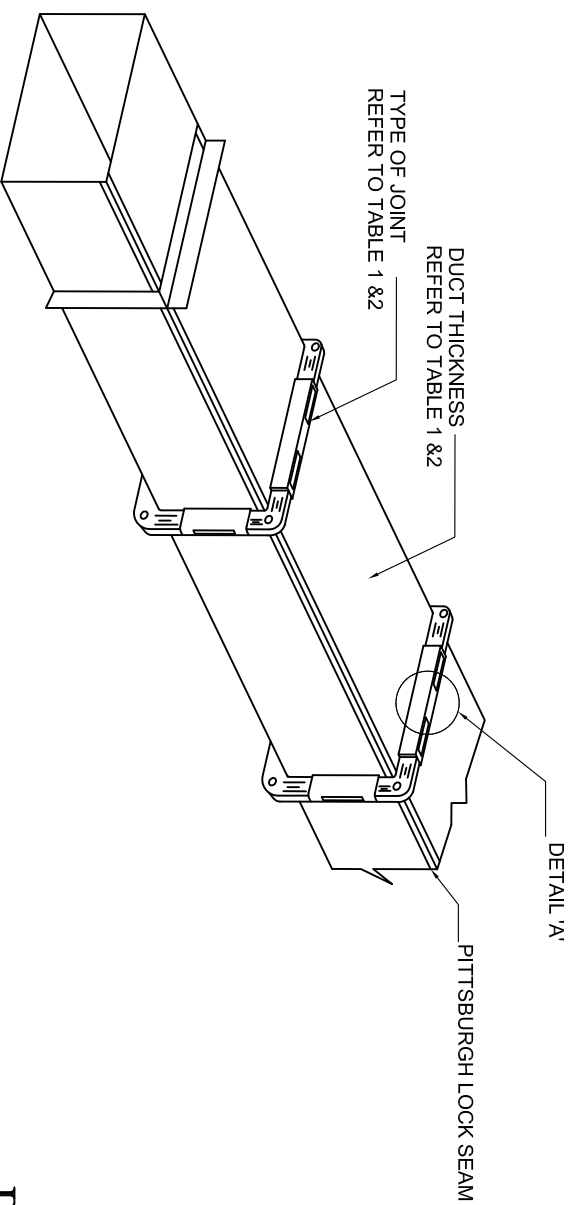

TRANSVERSE DUCT FLANGE
DUCT ISOMETRIC VIEW

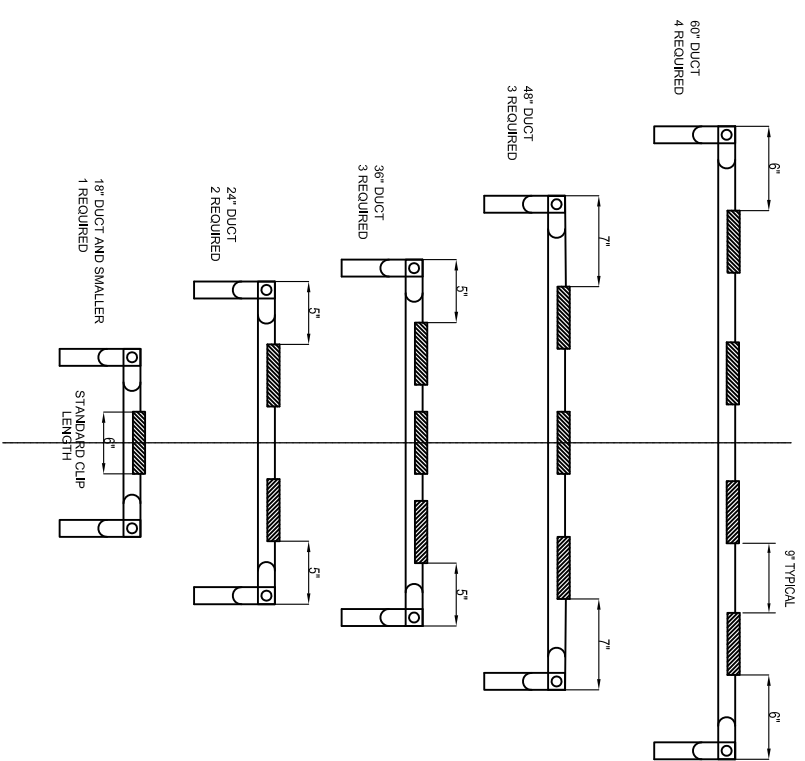

RECOMMENDED CLIP SPACING FOR TRANSVERSE DUCT FLANGE CONNECTION

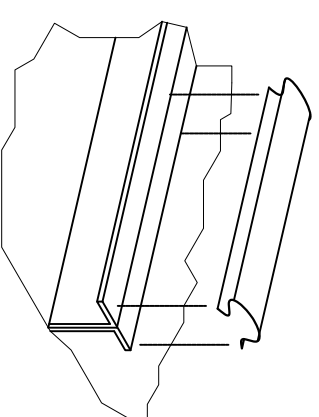

DETAIL 'A' TRANSVERSE DUCT FLANGE


		
JASA KEPADA RAKYAT		
CAWANGAN KEJURUTERAAN MEKANIKAL		
Ibu Pejabat JKR Malaysia		
AIR CONDITIONING SYSTEM		
DUCT SUPPORT AND BRACKET DETAIL		
DATE	2017	SCALE
		N.T.S
DRAWING NUMBER		

CKM/STD/AC/DUCT/REV/2017/06


		
JASA KEPADA RAKYAT		
CAWANGAN KEJURUTERAAN MEKANIKAL		
Ibu Pejabat JKR Malaysia		
AIR CONDITIONING SYSTEM		
DUCT SUPPORT AND BRACKET DETAIL		
DATE	2017	SCALE
		N.T.S
DRAWING NUMBER		

CKM/STD/AC/DUCT/REV/2017/06


NOTE:

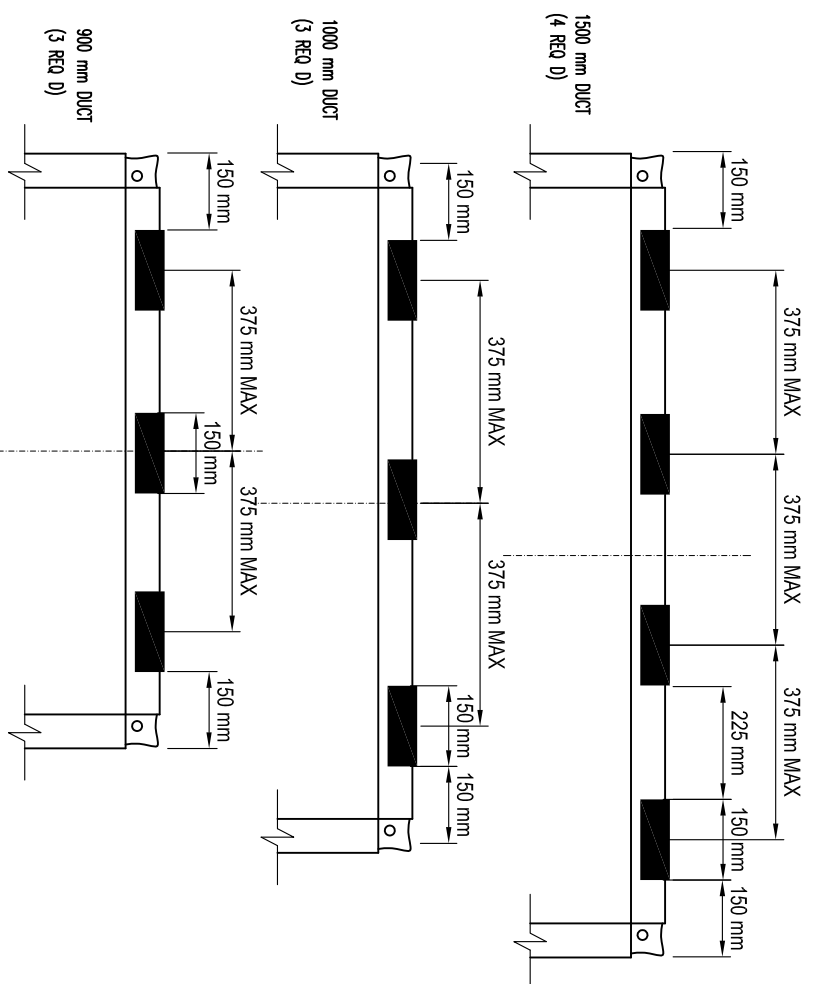


2(a)-CLIP SPACING

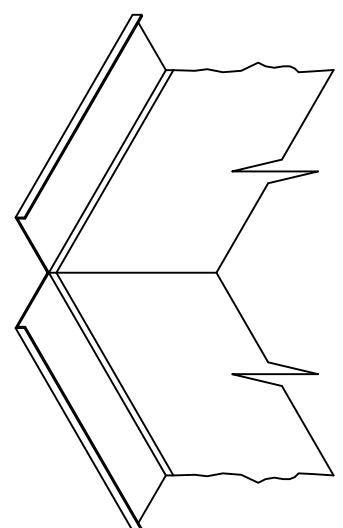


2(c)-T-24 FORMED FLANGE

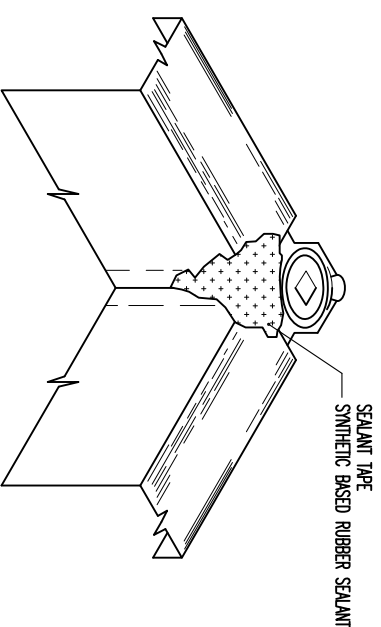

2(d)-INSIDE CORNER

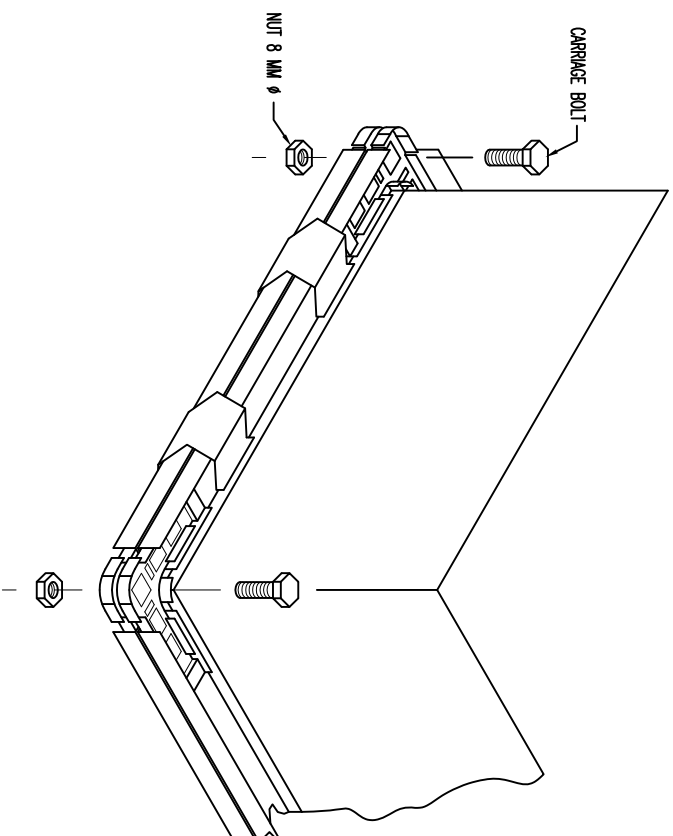

2(b)-REINFORCEMENT OPTION

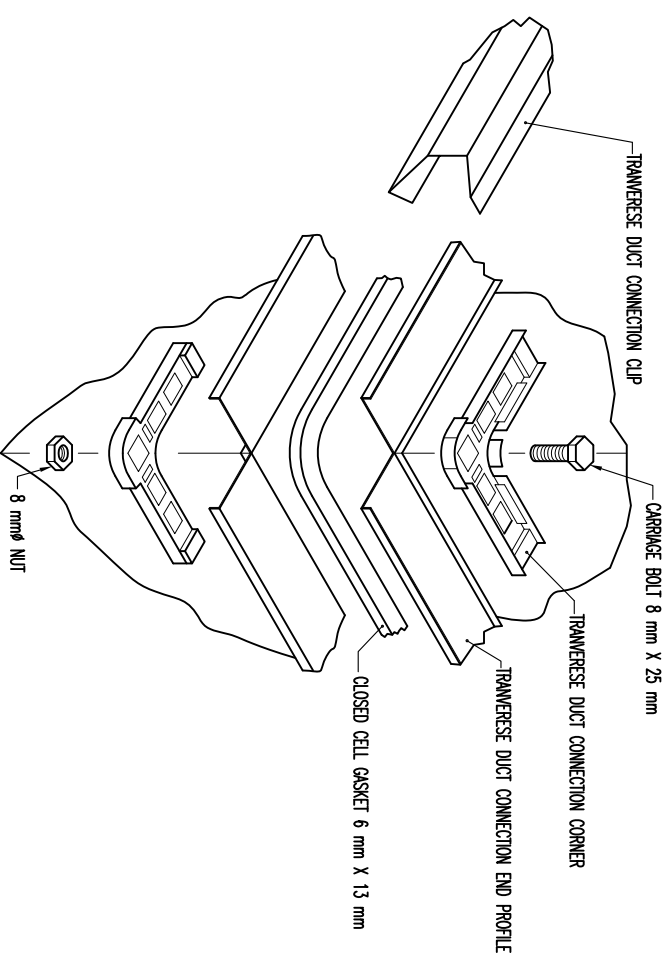


2(e)-CORNER ASSEMBLY

TDC JOINT & REINFORCEMENT


DATE	SCALE
2017	N.T.S
DRAWING NUMBER	
CKM/STD/AC/DUCT/REV/2017/07	

NOTE:

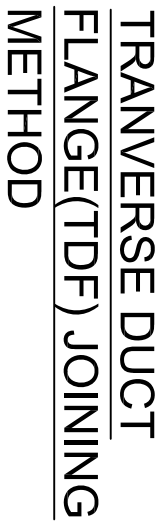


 JASA KEPADA RAKYAT CAWANGAN KEJURUTERAAN MEKANIKAL Ibu Pejabat JKR Malaysia	
AIR CONDITIONING SYSTEM DUCT JOINT DETAIL	
DATE	SCALE
2017	N.T.S
DRAWING NUMBER	
CKM/STD/AC/DUCT/REV/2017/08	

NOTE:

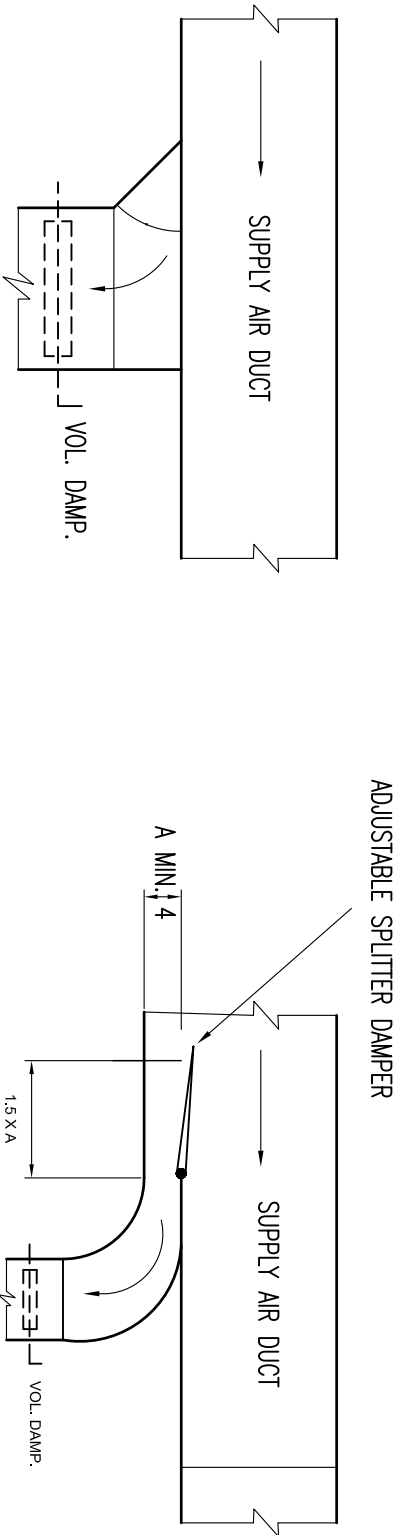


**SMALL BRANCH DUCT TAKE-OFF FROM MAIN DUCT WITH
VELOCITIES TO 1800 FPM (9m/s).**

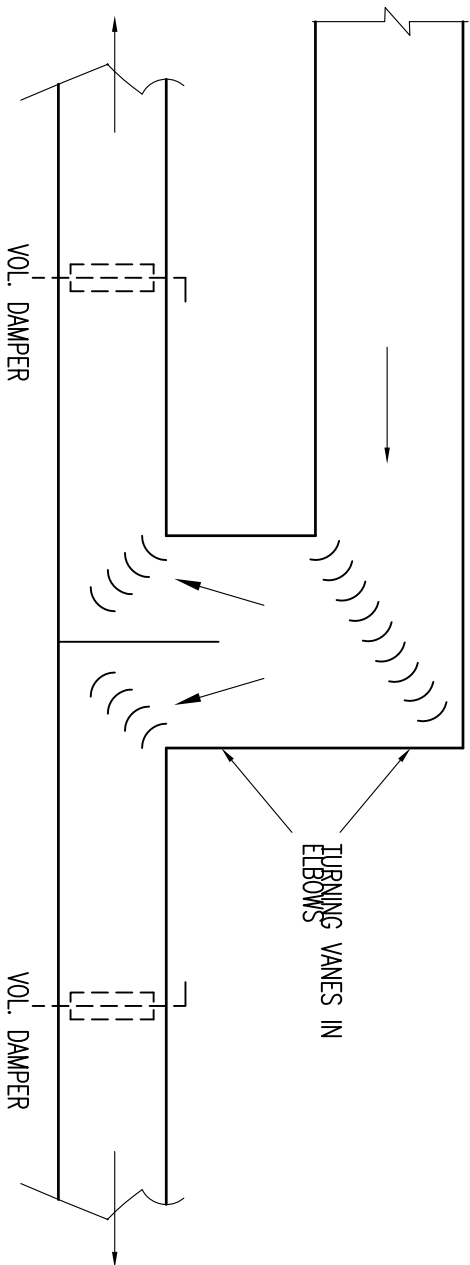


**PREFERRED MAIN DUCT ELBOWS AND DIVIDED FLOW FITTING TO
BRANCH DUCTS**

AIR COOLED SPLIT UNIT

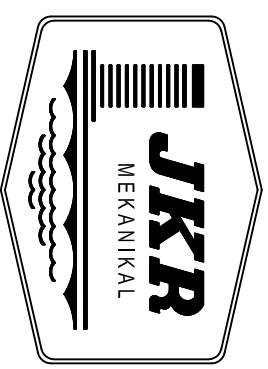






JASA KEPADA RAKYAT

NOTE:

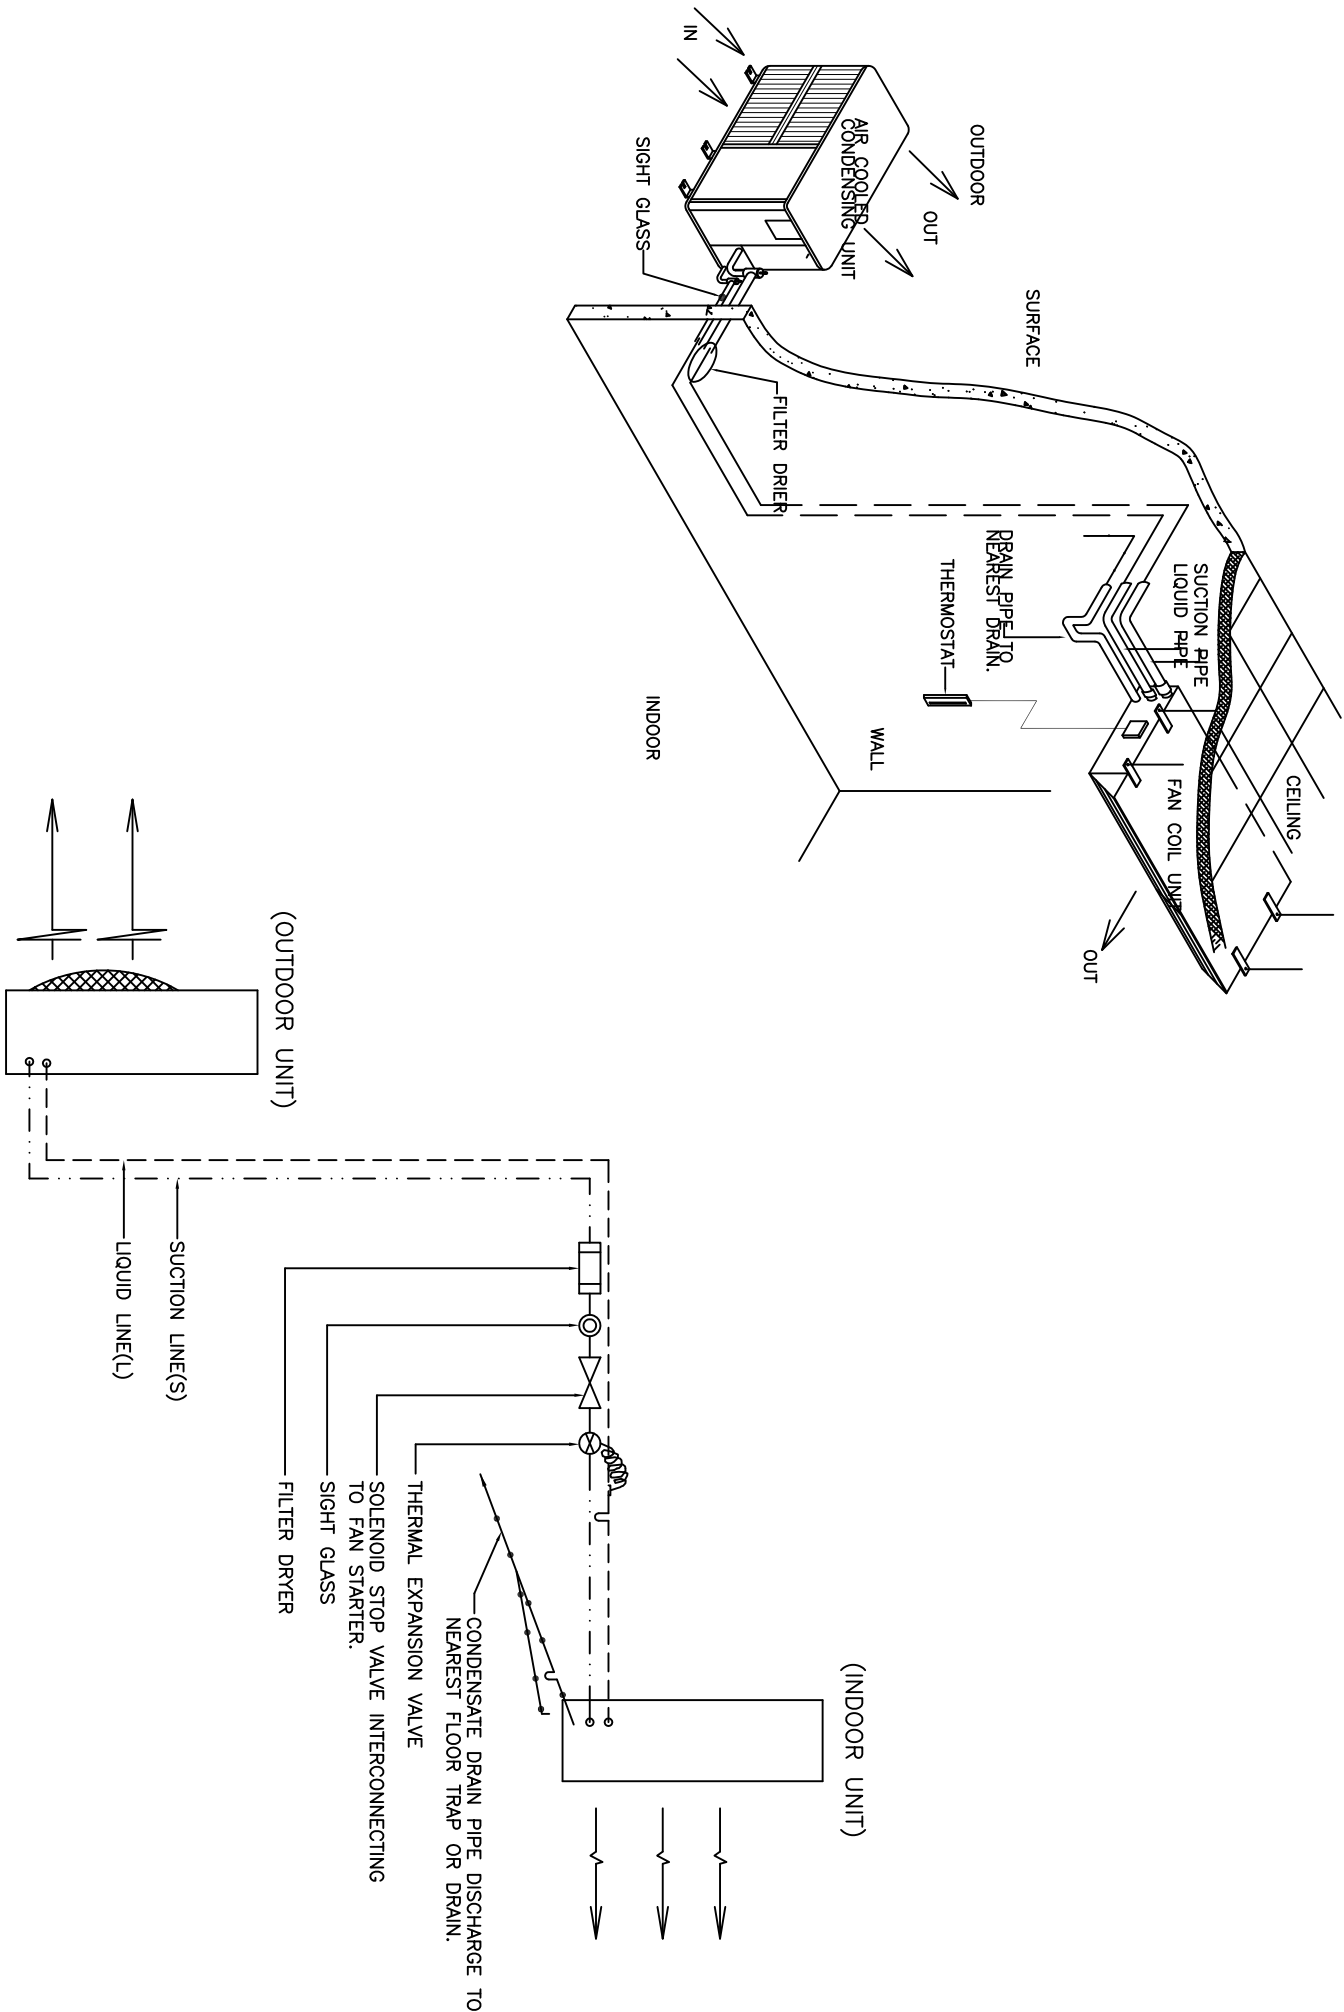

REFRIGERANT PIPING SCHEMATIC AND CONTROL DIAGRAM.

NOTE:

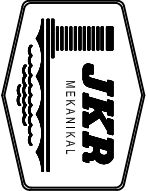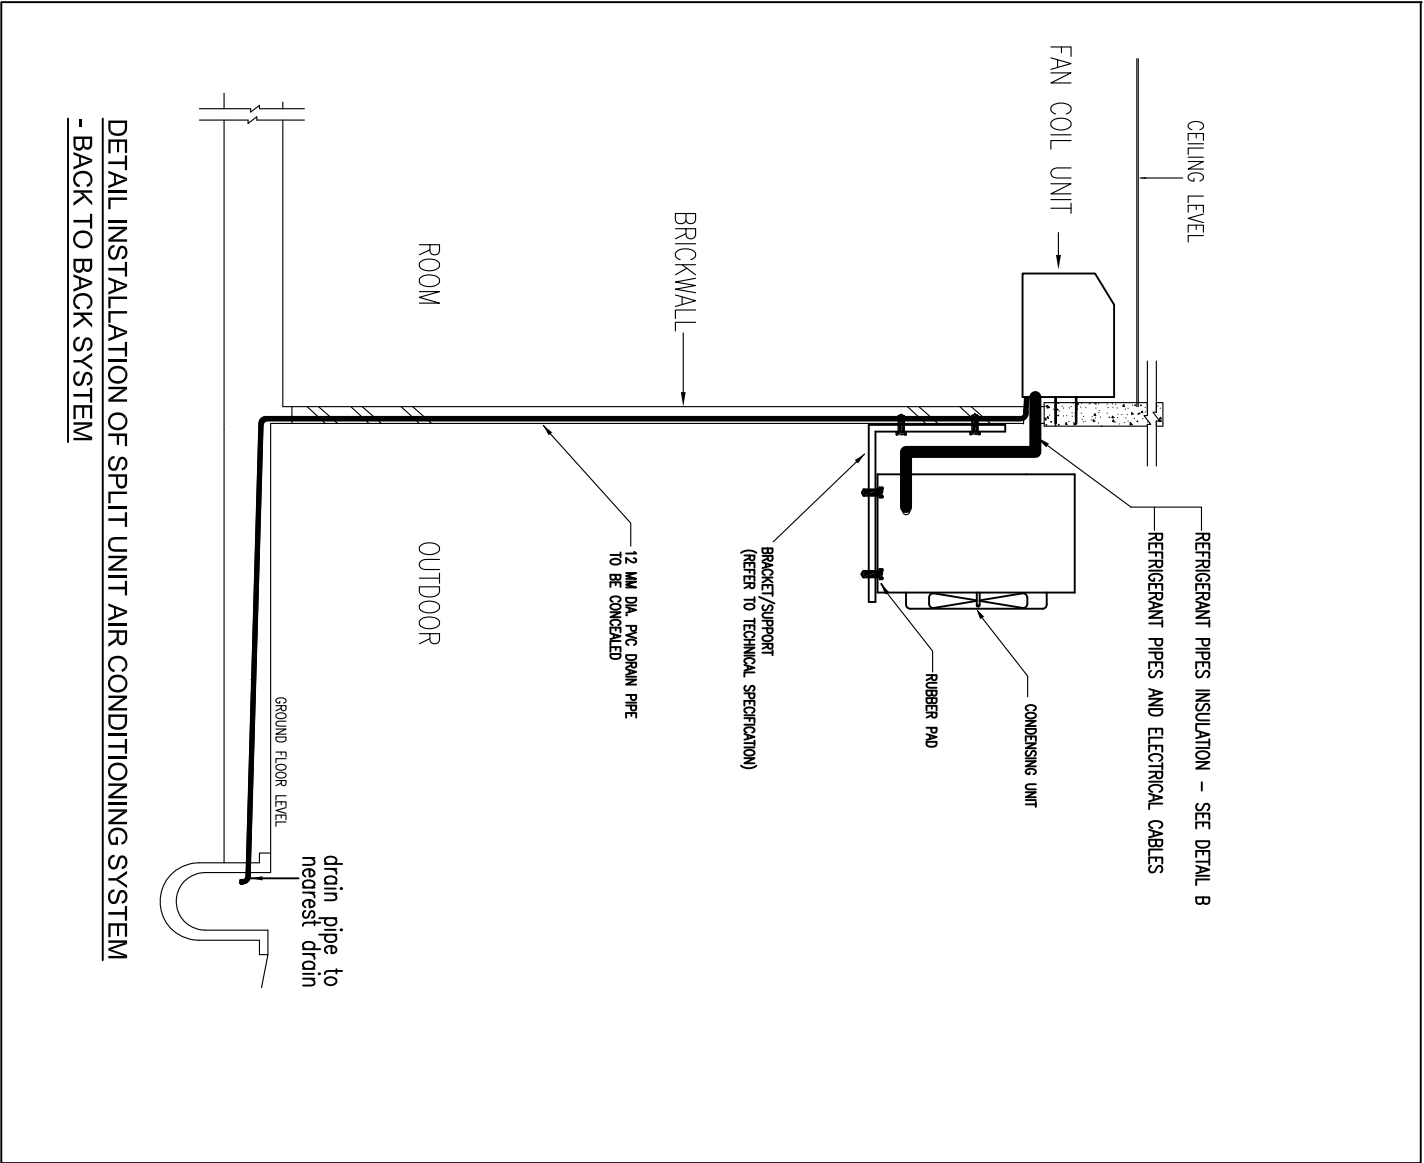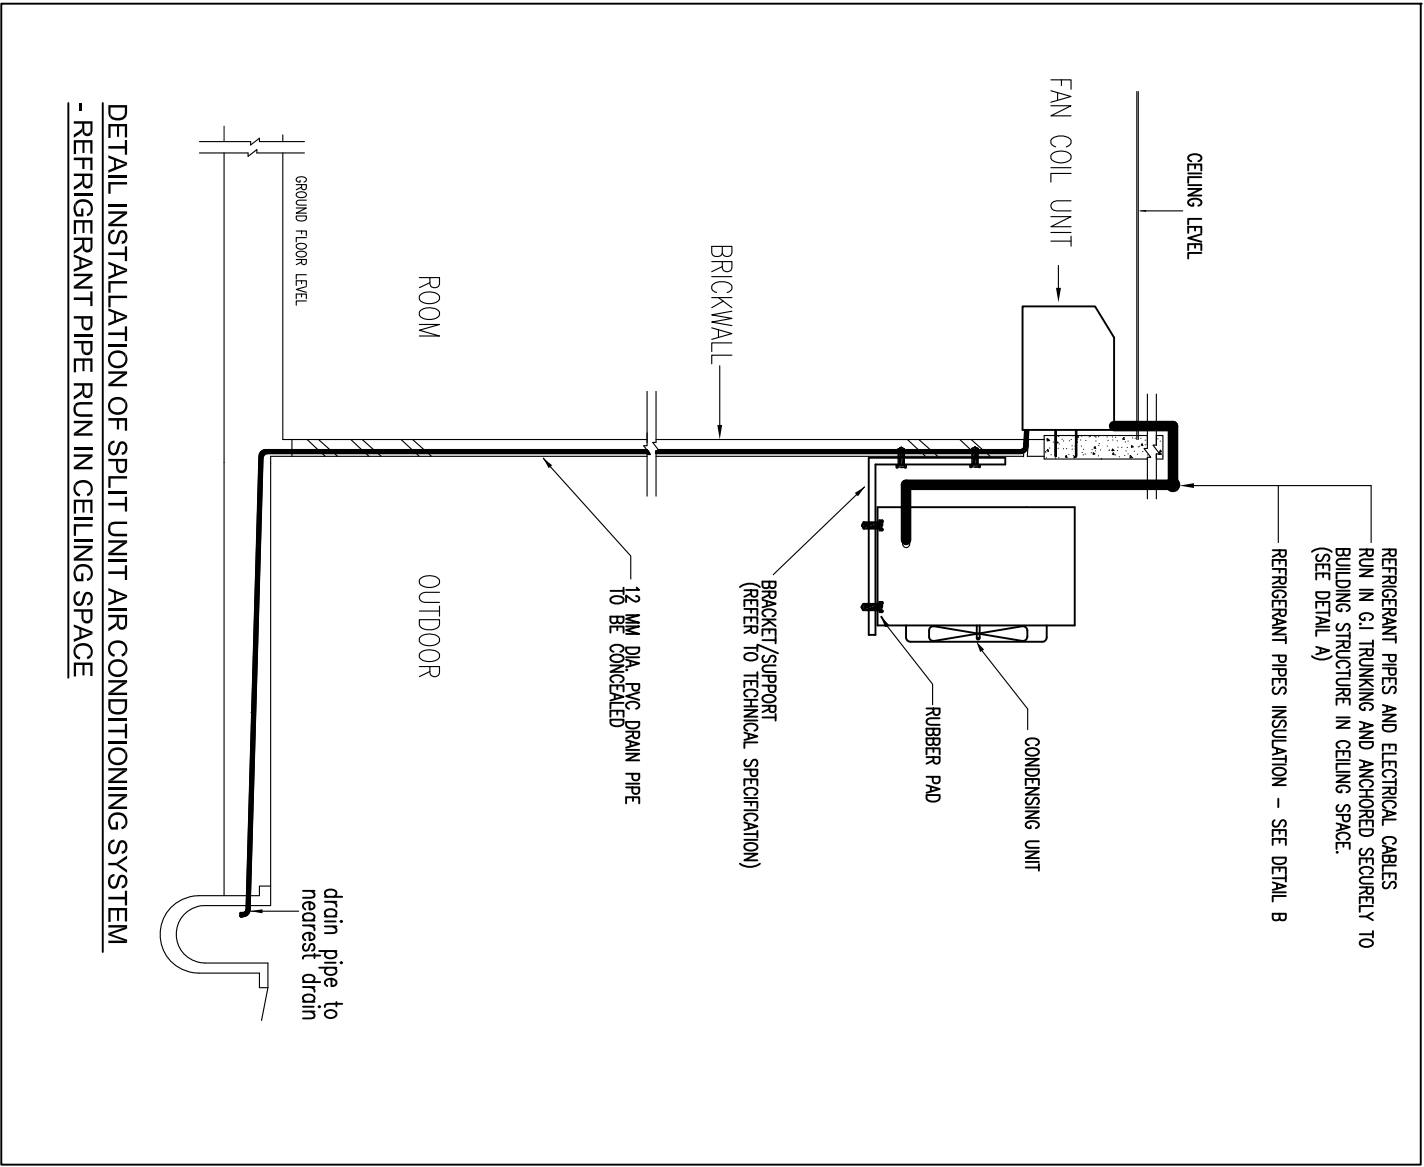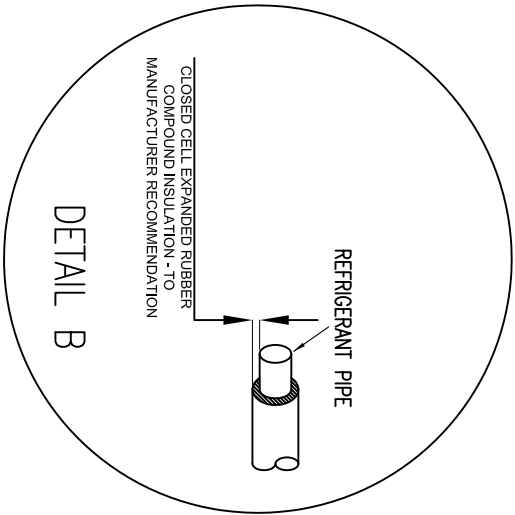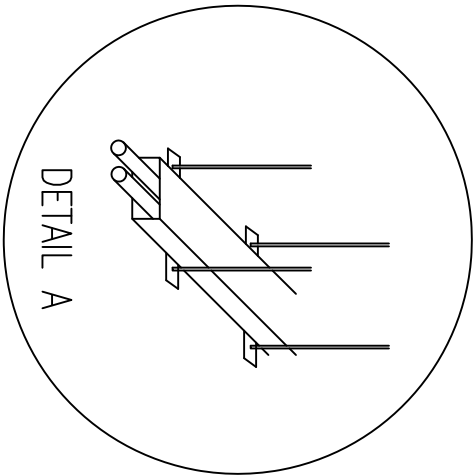

JASA KEPADA RAKYAT
CAWANGAN KEJURUTERAAN MEKANIKAL
Ibu Pejabat JKR Malaysia

AIR CONDITIONING SYSTEM




INSTALLATION OF SPLIT UNIT

DATE 2017 SCALE N.T.S

DRAWING NUMBER

CKM/STD/AC/SPLIT UNIT/REV2017/02

NOTE:

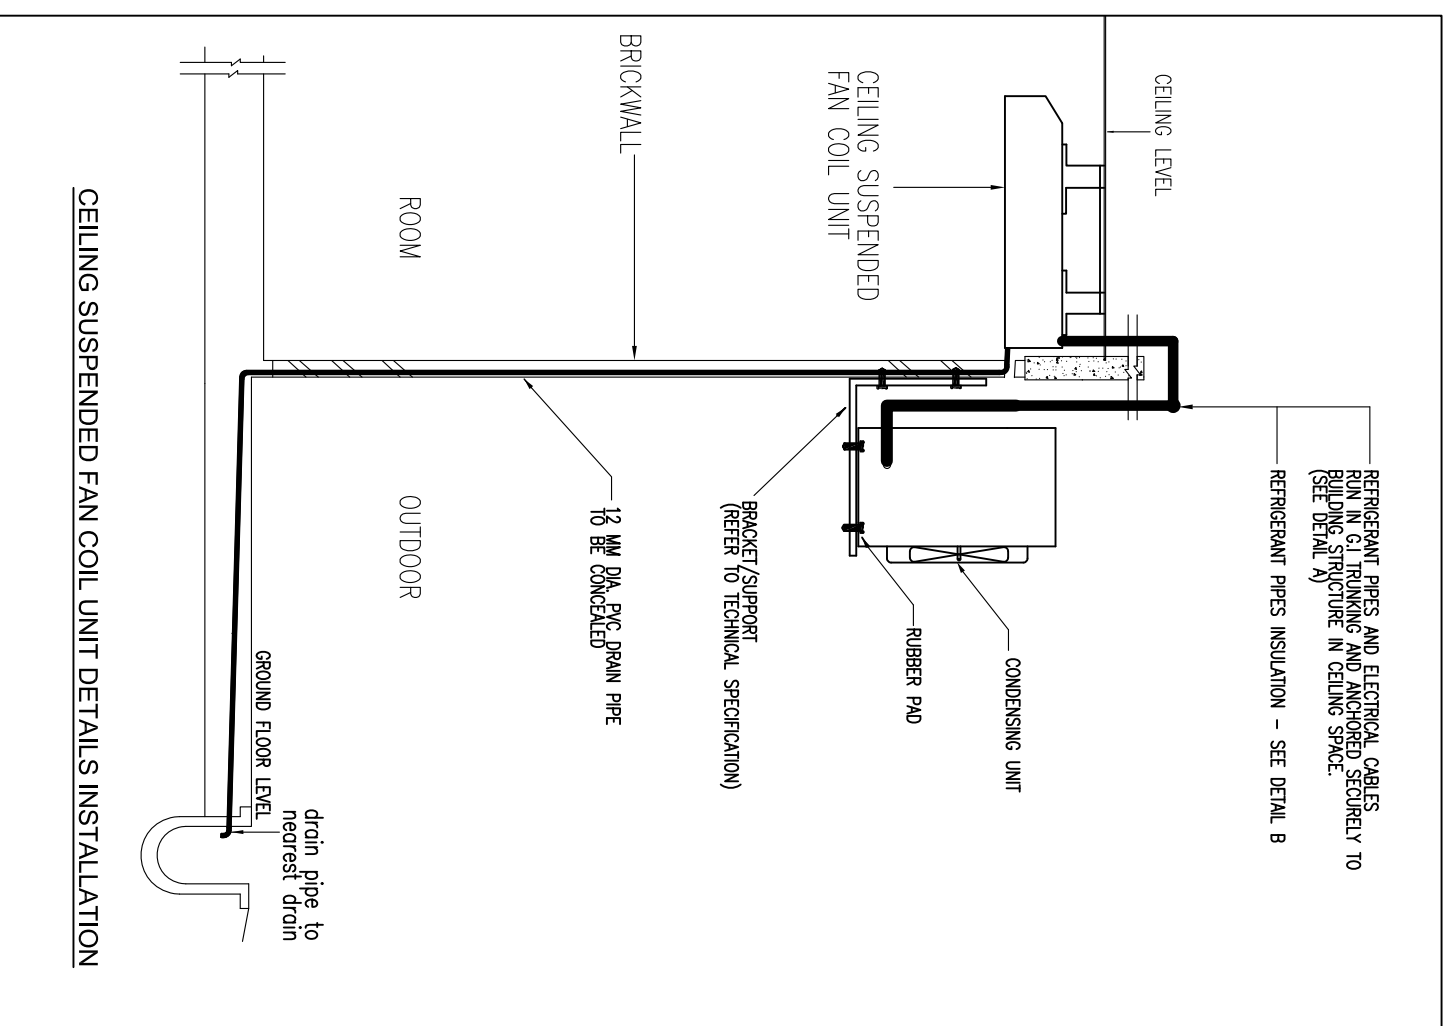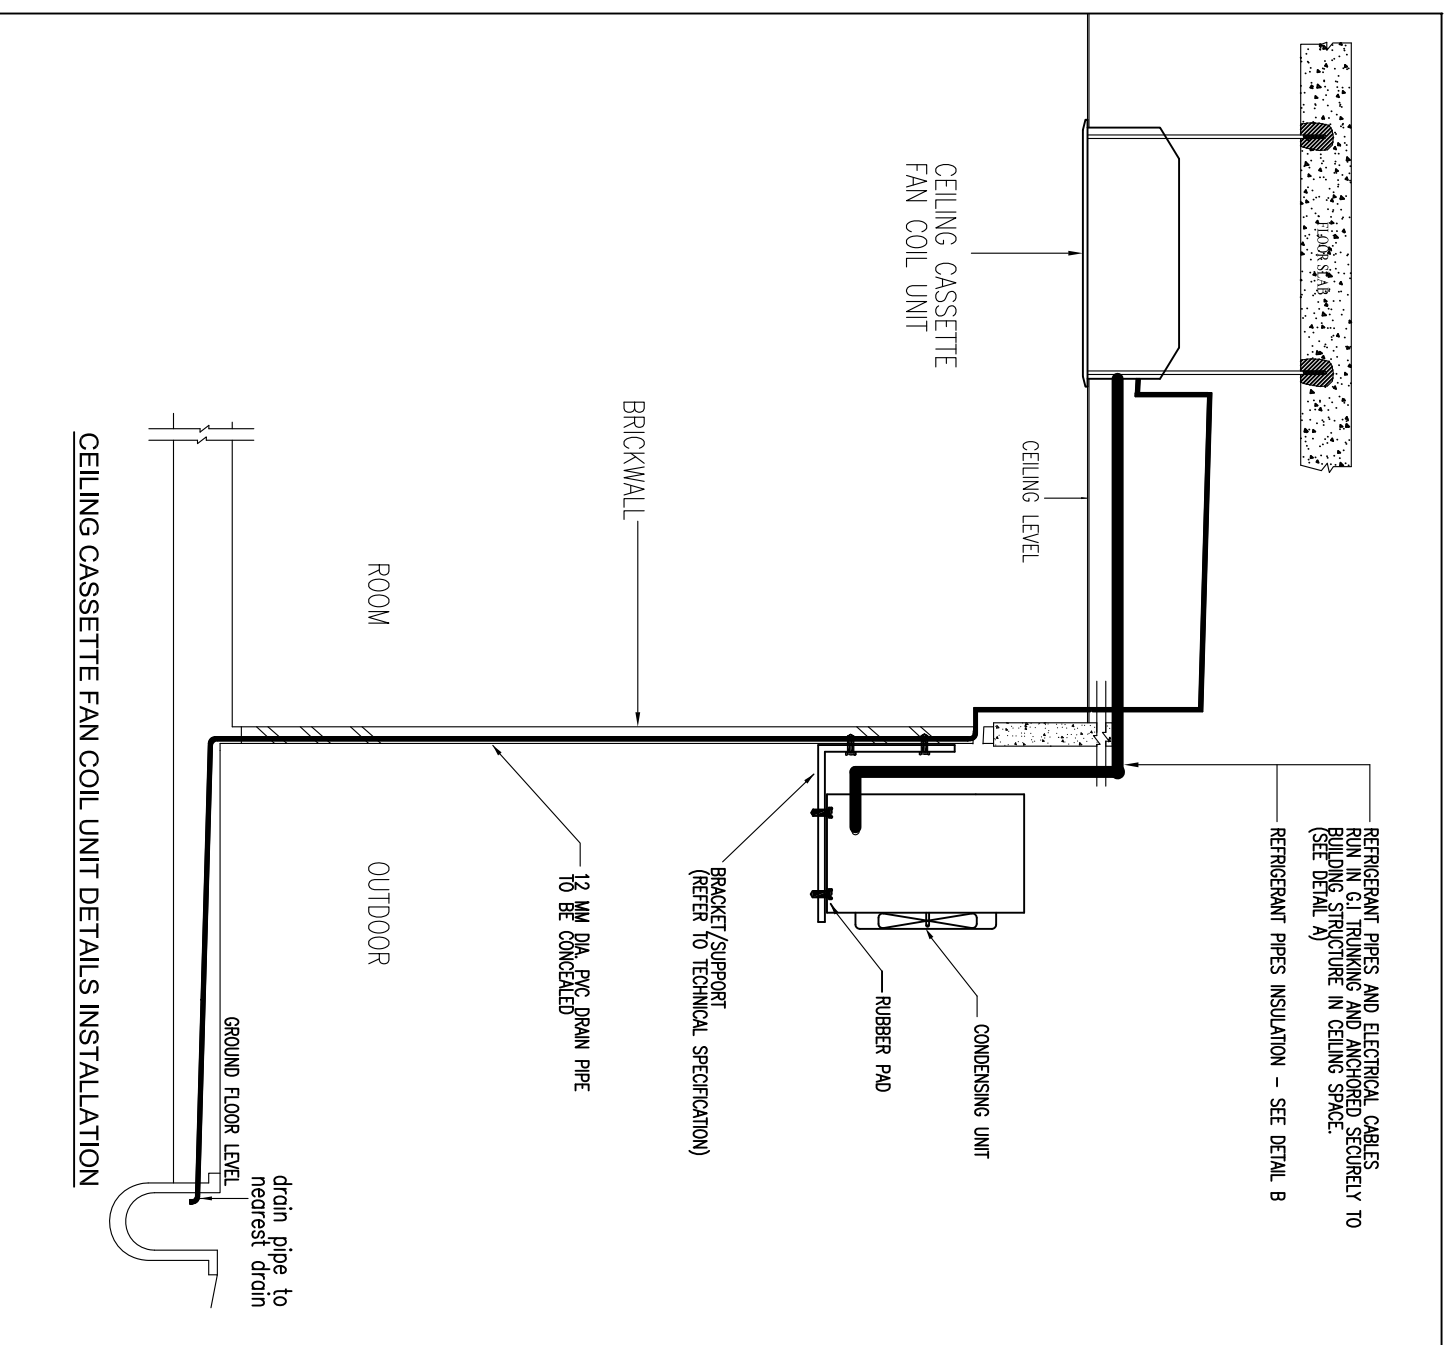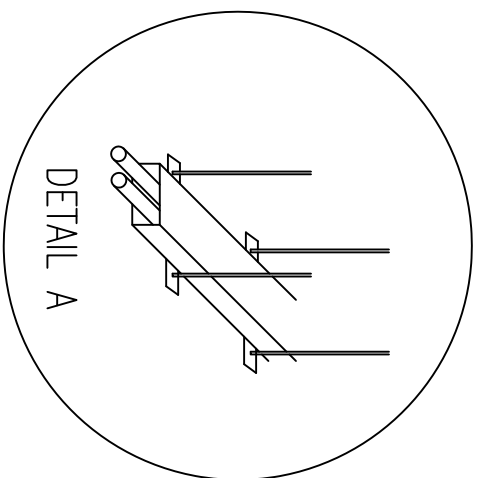

CAWANGAN KEJURUTERAAN MEKANIKAL
Ibu Pejabat JKR Malaysia



JASA KEPADA RAKYAT

AIR CONDITIONING SYSTEM

INSTALLATION OF SPLIT UNIT

DATE	SCALE
2017	N.T.S





2017	N.T.S
------	-------

SCALE	N.T.S
-------	-------

DRAWING NUMBER

CKM/STD/AC/SPLIT UNIT/REV2017/03

NOTE:

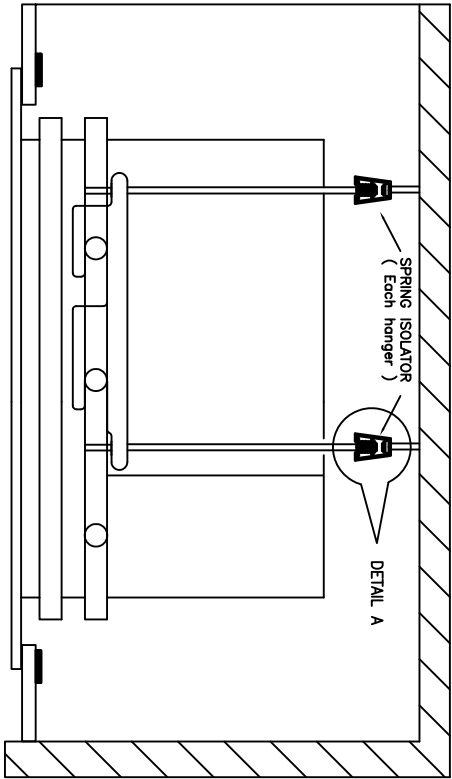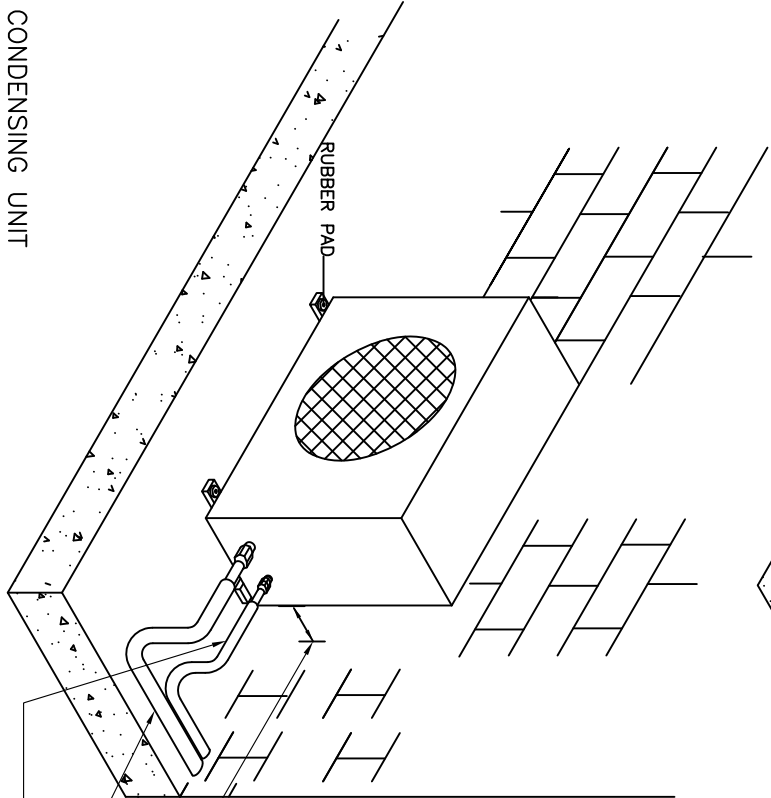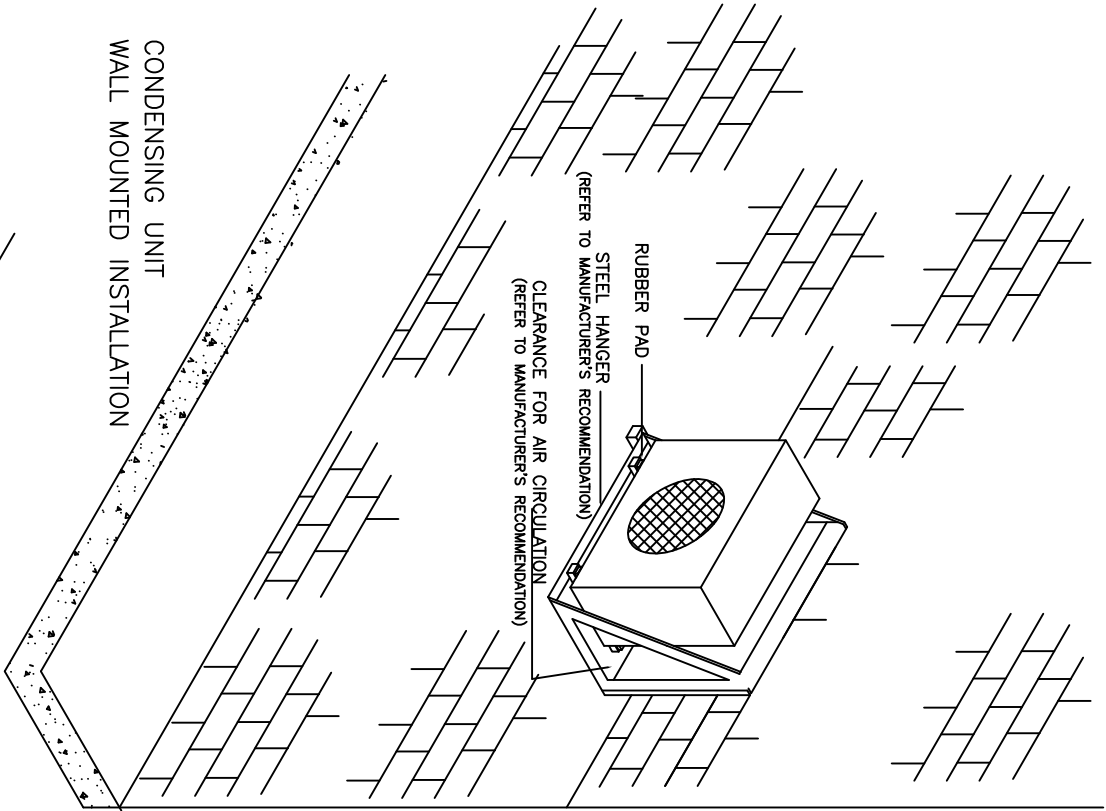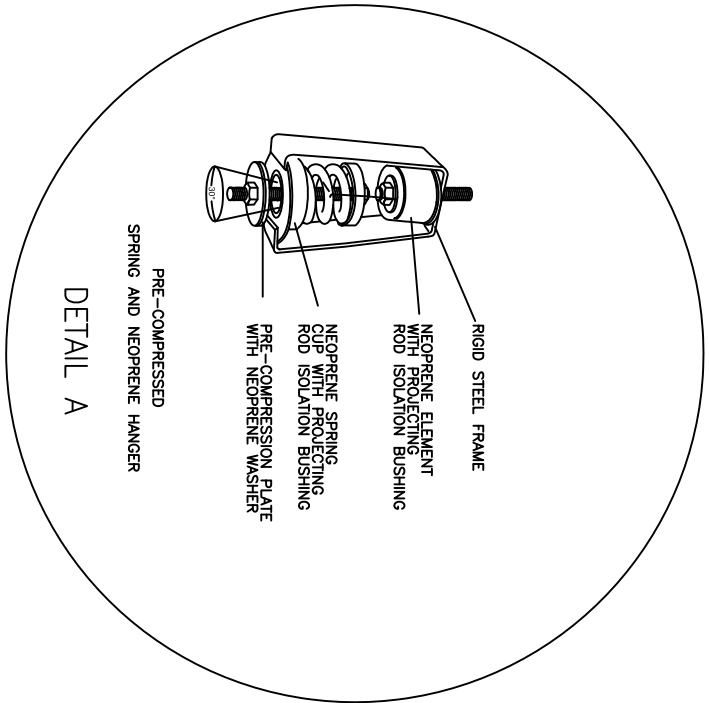

CLEARANCE FOR AIR CIRCULATION
(REFER TO MANUFACTURER RECOMMENDATION)

LIQUID SIDE – COPPER PIPE
C/W INSULATION

SUCTION SIDE – COPPER PIPE
C/W INSULATION





CAWANGAN KEJURUTERAAN MEKANIKAL
Ibu Pejabat JKR Malaysia

AIR CONDITIONING SYSTEM
INSTALLATION OF SPLIT UNIT

DATE	SCALE	NT:5
2017		
DRAWING NUMBER		
CKM/STD/AC/SPLIT UNIT/REV2017/04		



NOTE:

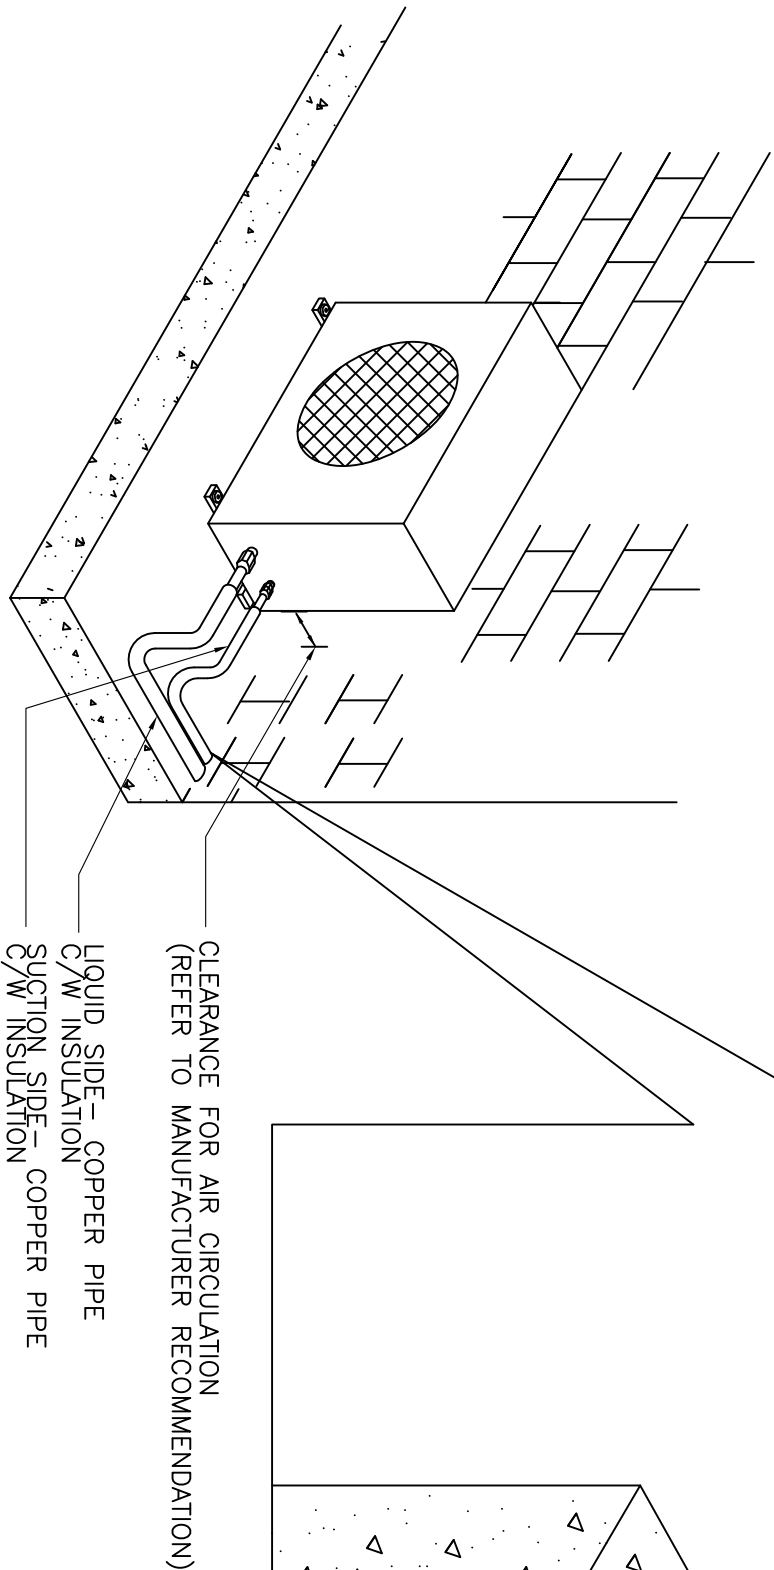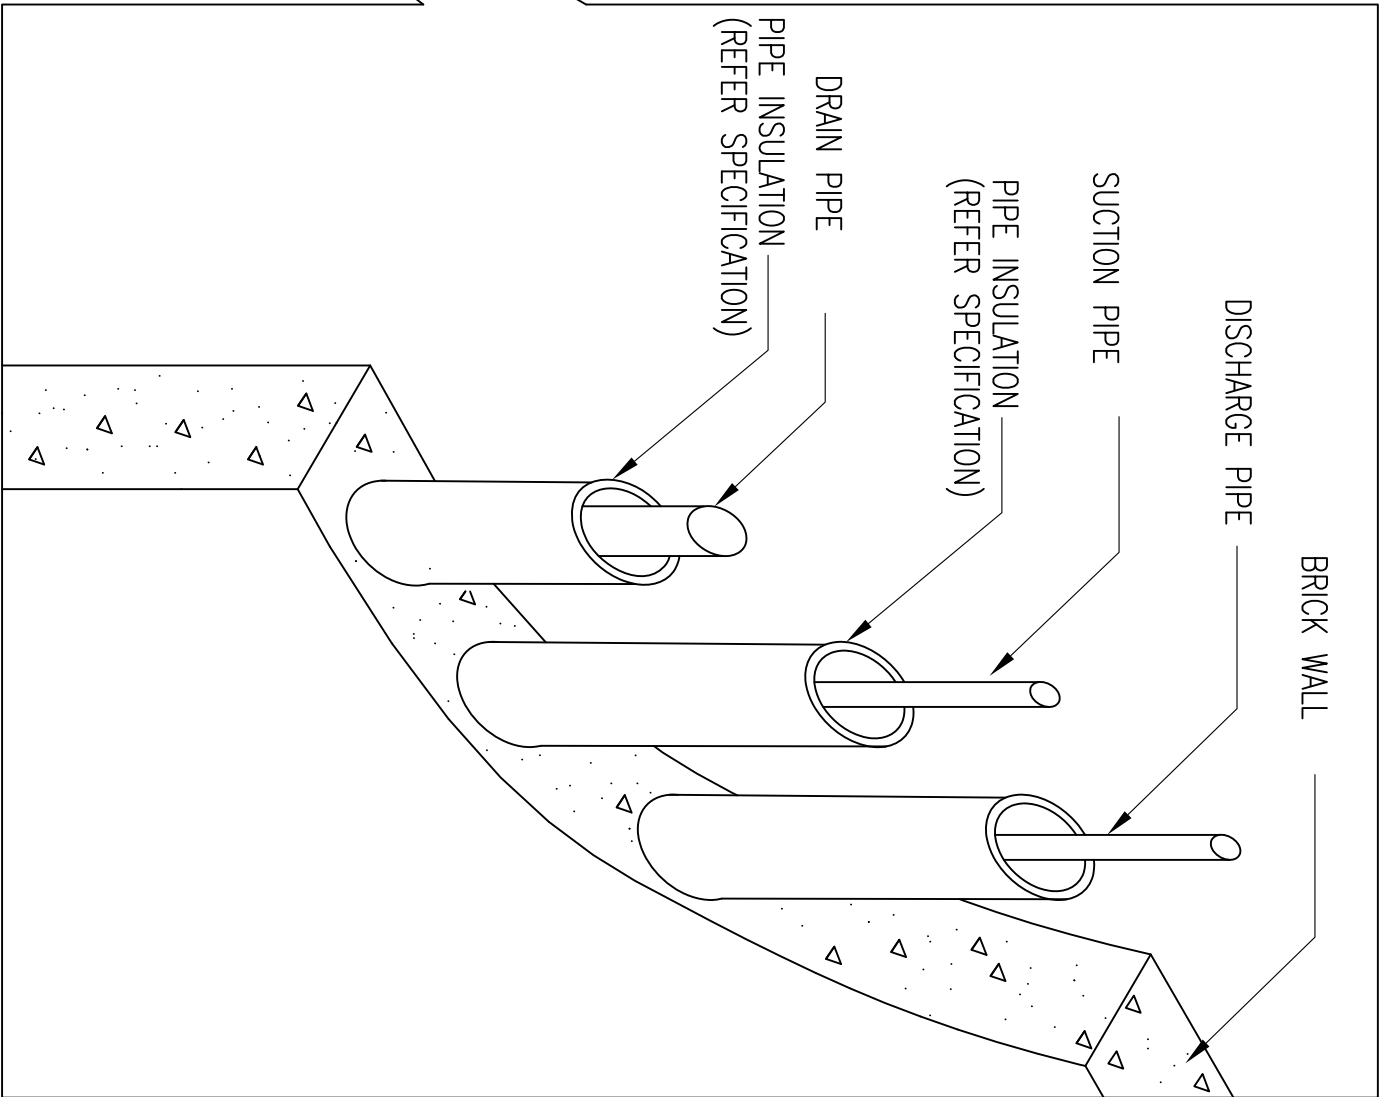

REFRIGERANT PIPE INSTALLATION CONCEALED IN BRICK WALL

 JASA KEPADA RAKYAT CAWANGAN KEJURUTERAAN MEKANIKAL Ibu Pejabat JKR Malaysia	
AIR CONDITIONING SYSTEM	
REFRIGERANT PIPE INSTALLATION CONCEALED IN BRICK WALL	
DATE	SCALE
2017	NT:S
DRAWING NUMBER	
CKM/STD/JAC/SPLIT UNIT/REV2017/05	

NOTE:

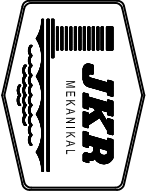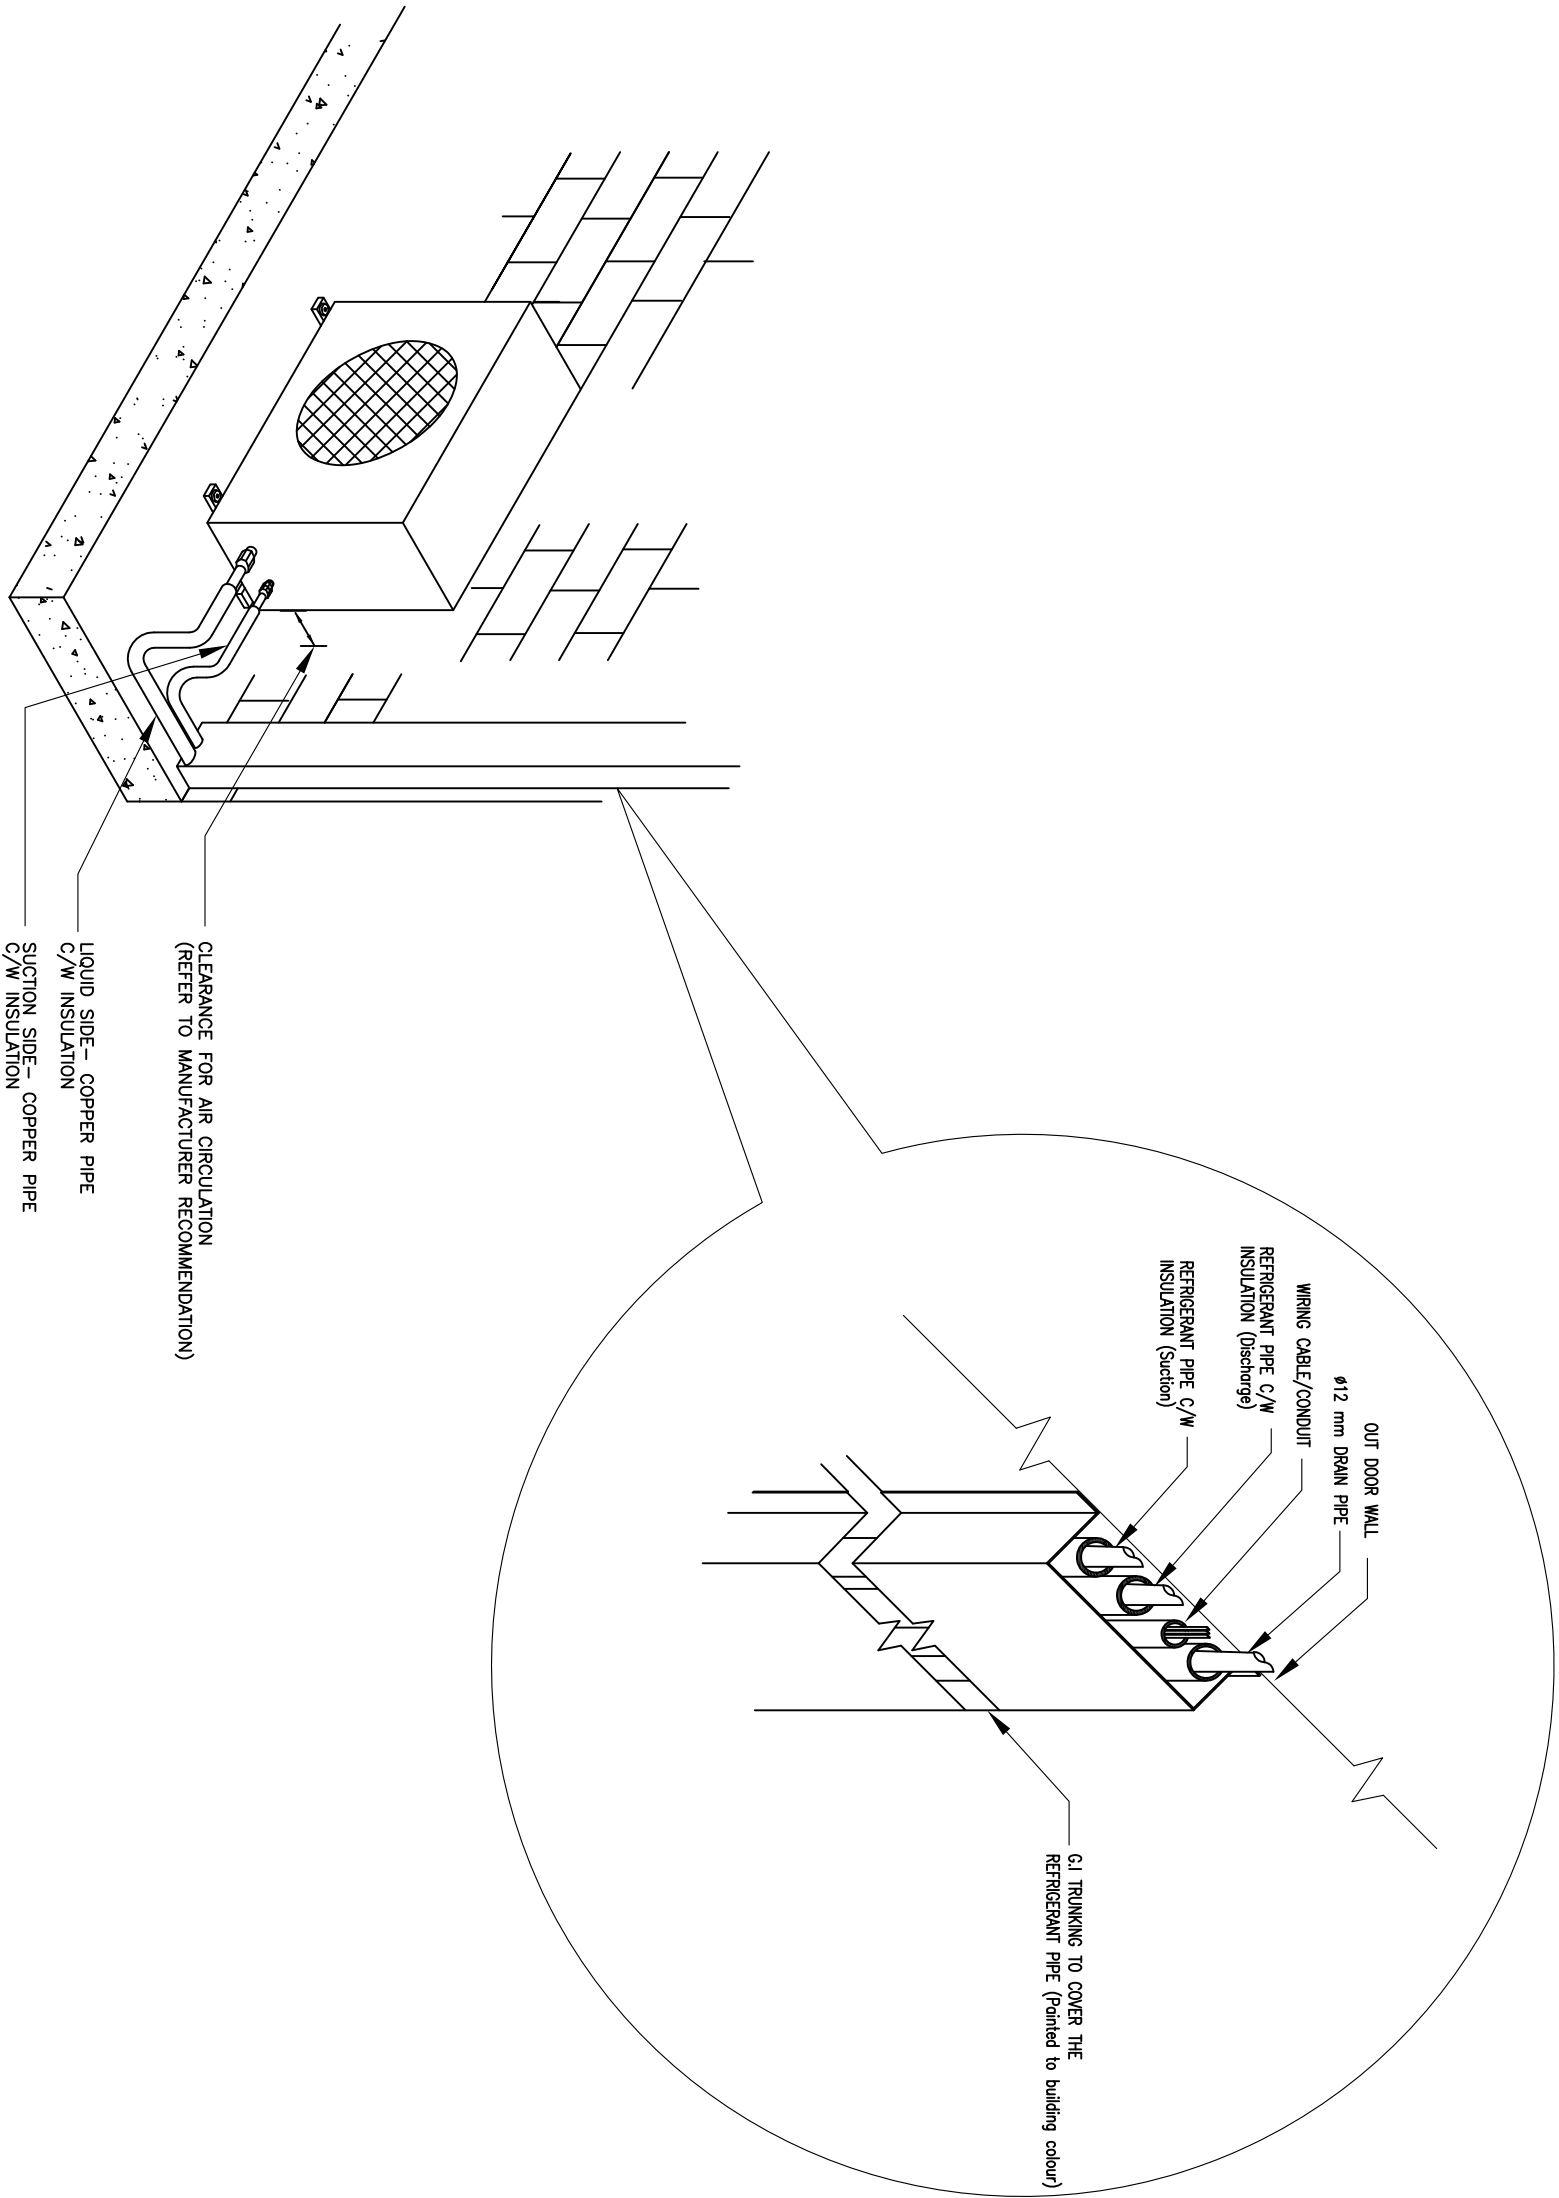

JASA KEPADA RAKYAT



CAWANGAN KEJURUTERAAN MEKANIKAL
Ibu Pejabat JKR Malaysia

AIR CONDITIONING SYSTEM
REFRIGERANT PIPE INSTALLATION
USING GI TRUNKING

DATE	SCALE	NT:S
2017		
DRAWING NUMBER		
CKM/STD/AC/SPLIT UNIT/REV2017/06		

REFRIGERANT PIPE INSTALLATION USING GI TRUNKING

NOTE:

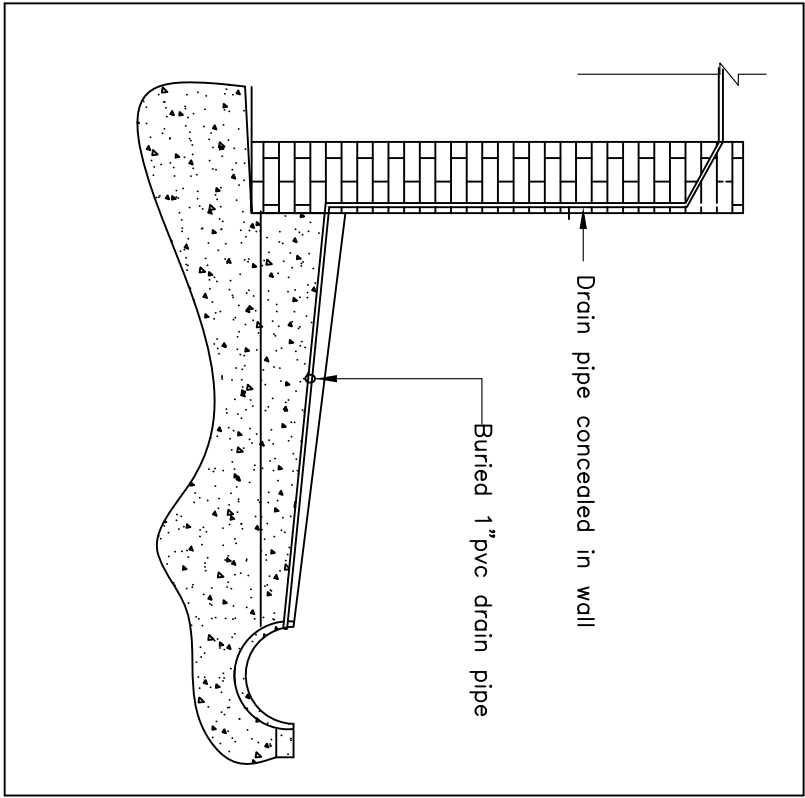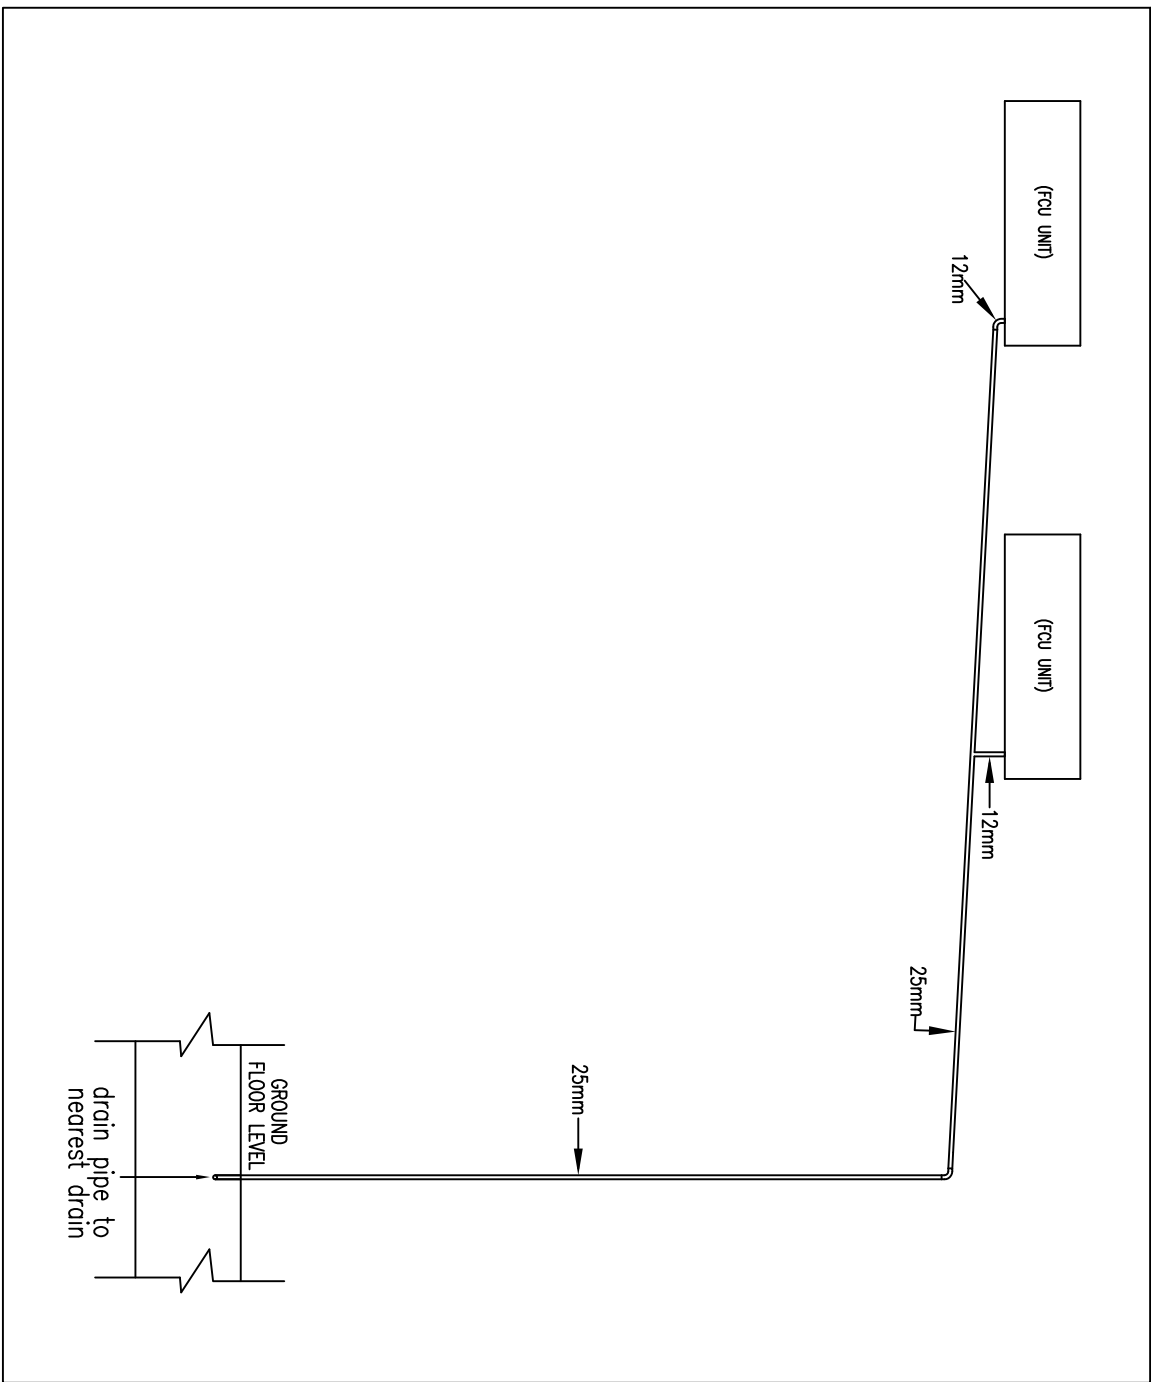

INSTALLATION OF CENTRALISED DRAIN PIPE.

AIR CONDITIONING SYSTEM INSTALLATION OF CENTRALISED DRAIN PIPE


DATE _____

2017

SCALE
N.T.S

DRAWING NUMBER

CKM/STD/AC/SPLIT UNIT/REV2017/07

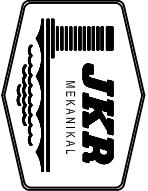


JASA KEPADA RAKYAT

CAWANGAN KEJURUTERAAN MEKANIKAL
Ibu Pejabat JKR Malaysia

STANDARD MECHANICAL DESIGN DETAIL DRAWING FOR MECHANICAL SYSTEMS IN BUILDINGS

SECTION II : FIRE FIGHTING SYSTEM


CAWANGAN KEJURUTERAAN MEKANIKAL
IBU PEJABAT JKR MALAYSIA
KUALA LUMPUR

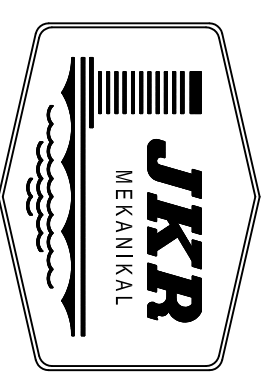

JASA KEPADA RAKYAT

2017


FIRE FIGHTING SYSTEM

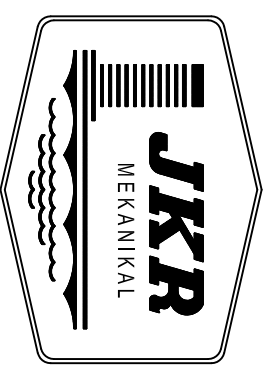

JASA KEPADA RAKYAT

LIST OF DRAWINGS

NO.	DRAWING TITLE	DRAWING NUMBER
	LIST OF DRAWINGS	CKM/STD/FF/REV2017/INDEX
A WATER TANK SYSTEM		
1	DETAIL OF HOSE REEL TANK INSTALLATION	CKM/STD/FF/WATER TANK/REV2017/01
2	DETAIL OF SPRINKLER AND WET RISER TANK INSTALLATION	CKM/STD/FF/WATER TANK/REV2017/02
3	DETAIL OF LEVEL INDICATOR INSTALLATION	CKM/STD/FF/WATER TANK/REV2017/03
4	DETAIL OF ELECTRODE INSTALLATION FOR FIRE FIGHTING TANK	CKM/STD/FF/WATER TANK/REV2017/04
5	DETAIL OF SPRINKLER AND WET RISER PUMP	CKM/STD/FF/WATER TANK/REV2017/05
B WATER PUMP SYSTEM		
1	DETAIL OF SPRINKLER, WET RISER & PRESSURE HYDRANT PUMP (DIESEL ENGINE DRIVEN)	CKM/STD/FF/PUMP/REV2017/01
2	DETAIL OF HOSE REEL PUMP (DIESEL ENGINE DRIVEN)	CKM/STD/FF/PUMP/REV2017/02
3	DETAIL OF SPRINKLER, WET RISER & PRESSURE HYDRANT PUMP (ELECTRIC DRIVEN – GENSET)	CKM/STD/FF/PUMP/REV2017/03
4	DETAIL OF HOSE REEL PUMP(ELECTRIC DRIVEN – GENSET)	CKM/STD/FF/PUMP/REV2017/04
5	DETAIL OF DIESEL ENGINE INSTALLATION	CKM/STD/FF/PUMP/REV2017/05
6	TYPICAL VALVE ARRANGEMENT FOR END SUCTION PUMP	CKM/STD/FF/PUMP/REV2017/06
7	TYPICAL VALVE ARRANGEMENT FOR VERTICAL IN – LINE PUMP	CKM/STD/FF/PUMP/REV2017/07
8	DETAIL OF PUMP AND MOTOR INERTIA BLOCK FOR SPRINKLER AND WET RISER	CKM/STD/FF/PUMP/REV2017/08
9	DETAIL OF PLINTH AND INERTIA BLOCK FOR PUMP INSTALLATION FOR SPRINKLER AND WET RISER	CKM/STD/FF/PUMP/REV2017/09
C PIPE SYSTEM		
1	TYPICAL ARRANGEMENT PIPE IN RISER	CKM/STD/FF/PIPE/REV2017/01
2	TYPICAL BRACKET FOR VERTICAL PIPES AT WALL	CKM/STD/FF/PIPE/REV2017/02
3	TYPICAL TYPES OF HANGERS	CKM/STD/FF/PIPE/REV2017/03
4	DETAILS OF PIPE HANGERS	CKM/STD/FF/PIPE/REV2017/04
5	TYPICAL PIPE HANGERS (PLANT ROOM) SPRINKLER AND WET RISER	CKM/STD/FF/PIPE/REV2017/05
6	DETAIL OF UNDERGROUND PIPING INSTALLATION	CKM/STD/FF/PIPE/REV2017/06
7	PIPE MECHANICAL JOINT COUPLING FOR SPRINKLER, WET RISER AND DRY RISER	CKM/STD/FF/PIPE/REV2017/07
8	DETAIL OF PIPES THROUGH WALLS AND FLOORS	CKM/STD/FF/PIPE/REV2017/08
9	TYPICAL VERTICAL PIPE RISER THROUGH FLOOR SLAB MOUNTING FOR SPRINKLER AND WET RISER	CKM/STD/FF/PIPE/REV2017/09
D SPRINKLER SYSTEM		
1	DETAIL SPRINKLER CONTROL VALVE	CKM/STD/FF/SPRINKLER/REV2017/01
2	TYPICAL TYPES OF SPRINKLER AND INSTALLATION	CKM/STD/FF/SPRINKLER/REV2017/02
3	TYPICAL FLOW SWITCH AND BUTTERFLY VALVE INSTALLATION (SPRINKLER)	CKM/STD/FF/SPRINKLER/REV2017/03
E DRY & WET RISER		
1	TYPICAL SIDE ELEVATION OF LANDING VALVE (DRY OR WET RISER)	CKM/STD/FF/DRY & WET RISER/REV2017/01
2	TYPICAL TYPES OF BREECHING INLET	CKM/STD/FF/DRY & WET RISER/REV2017/02
3	TYPICAL BREECHING INLET CABINET	CKM/STD/FF/DRY & WET RISER/REV2017/03
F HOSE REEL SYSTEM		
1	DETAIL OF HOSE REEL CABINET	CKM/STD/FF/HOSE REEL/REV2017/01
2	DETAIL OF HOSE REEL INSTALLATION	CKM/STD/FF/HOSE REEL/REV2017/02
G EXTINGUISHER		
1	DETAIL OF PORTABLE FIRE EXTINGUISHER INSTALLATION	CKM/STD/FF/EXTINGUISHER/REV2017/01

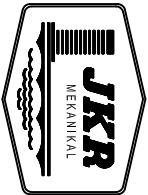

JASA KEPADA RAKYAT

CAWANGAN KEJURUTERAAN MEKANIKAL

Ibu Pejabat JKR Malaysia

FIRE FIGHTING SYSTEM

DRAWING INDEX


DATE	SCALE
2017	NTS

DRAWING NUMBER

CKM.BPKSTD/FF/2011/INDEX01

LIST OF DRAWINGS

NO.	DRAWING TITLE	DRAWING NUMBER
H	SWITCHBOARD	
1	TYPICAL CIRCUIT DIAGRAM FOR PUMP SWITCHBOARD	CKM/STD/FF/SWITCHBOARD/REV2017/01
2	TYPICAL PUMP SWITCHBOARD FOR HOSE REEL, SPRINKLER & WET RISER SYSTEM	CKM/STD/FF/SWITCHBOARD/REV2017/02
3	TYPICAL SWITCHBOARD TYPES FOR FIRE SUPPRESSION SYSTEM	CKM/STD/FF/SWITCHBOARD/REV2017/03
4	SISTEM PENGAWASAN KEBAKARAN AUTOMATIK (SPKA)	CKM/STD/FF/SWITCHBOARD/REV2017/04
I	FIRE ALARM SYSTEM	
1	DETAIL OF SMOKE OR HEAT DETECTOR INSTALATION	CKM/STD/FF/FIRE ALARM/REV2017/01
2	DETAIL OF ALARM BELL AND BREAK GLASS INSTALLATION	CKM/STD/FF/FIRE ALARM/REV2017/02
3	TYPICAL ADDRESSABLE FIRE ALARM PANEL	CKM/STD/FF/FIRE ALARM/REV2017/03
4	TYPICAL SCHEMATIC DIAGRAM FOR ADDRESSABLE FIRE ALARM SYSTEM	CKM/STD/FF/FIRE ALARM/REV2017/04
5	TYPICAL CONVENTIONAL FIRE ALARM PANEL	CKM/STD/FF/FIRE ALARM/REV2017/05
J	FIRE CURTAIN	
1	DETAIL OF FIRE CURTAIN	CKM/STD/FF/FIRE CURTAIN/REV2017/01
K	WET CHEMICAL	
1	TYPICAL OF WET CHEMICAL SYSTEM	CKM/STD/FF/WET CHEMICAL/REV2017/01
L	FIRE SUPPRESSION	
1	TYPICAL OF FIRE SUPPRESSION SYSTEM	CKM/STD/FF/FIRE SUPPRESSION/REV2017/01
M	PRESSURIZATION SYSTEM	
1	TYPICAL OF PRESSURIZATION SYSTEM(LOBBY)	CKM/STD/FF/PRESSURIZATION/REV2017/01
2	TYPICAL OF PRESSURIZATION SYSTEM(STAIRCASE)	CKM/STD/FF/PRESSURIZATION/REV2017/02
3	TYPES OF FAN INSTALLATION	CKM/STD/FF/PRESSURIZATION/REV2017/03
4	TYPES OF FAN INSTALLATION	CKM/STD/FF/PRESSURIZATION/REV2017/04
5	TYPICAL TYPE OF DUCT INSTALLATION	CKM/STD/FF/PRESSURIZATION/REV2017/05
6	TYPICAL TYPE OF DUCT INSTALLATION	CKM/STD/FF/PRESSURIZATION/REV2017/06
N	SMOKE SPILL SYSTEM	
1	TYPICAL OF SMOKE SPILL SYSTEM	CKM/STD/FF/SMOKE SPILL/REV2017/01
2	TYPICAL TYPE OF FAN INSTALLATION	CKM/STD/FF/SMOKE SPILL/REV2017/02
3	TYPES TYPES OF FAN INSTALLATION	CKM/STD/FF/SMOKE SPILL/REV2017/03
4	TYPICAL TYPES OF DUCT INSTALLATION	CKM/STD/FF/SMOKE SPILL/REV2017/04
5	TYPICAL TYPES OF DUCT INSTALLATION	CKM/STD/FF/SMOKE SPILL/REV2017/05
6	TYPICAL TYPES OF DUCT INSTALLATION	CKM/STD/FF/SMOKE SPILL/REV2017/06

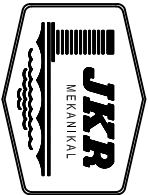




JASA KEPADA RAKYAT

CAWANGAN KEJURUTERAAN MEKANIKAL
Ibu Pejabat JKR Malaysia

FIRE FIGHTING SYSTEM

DRAWING INDEX

DATE 2017	SCALE NTS
DRAWING NUMBER CKM.BPKSTD/FF/2011/INDEX02	

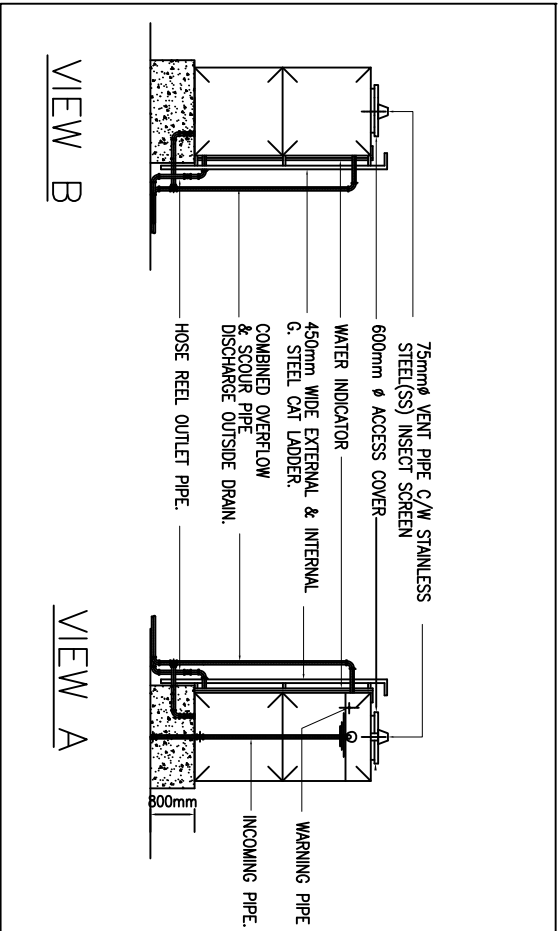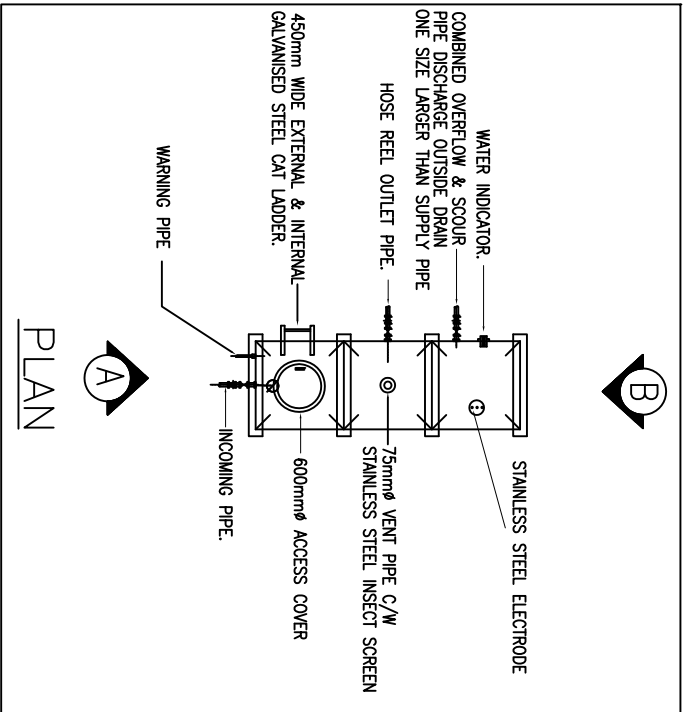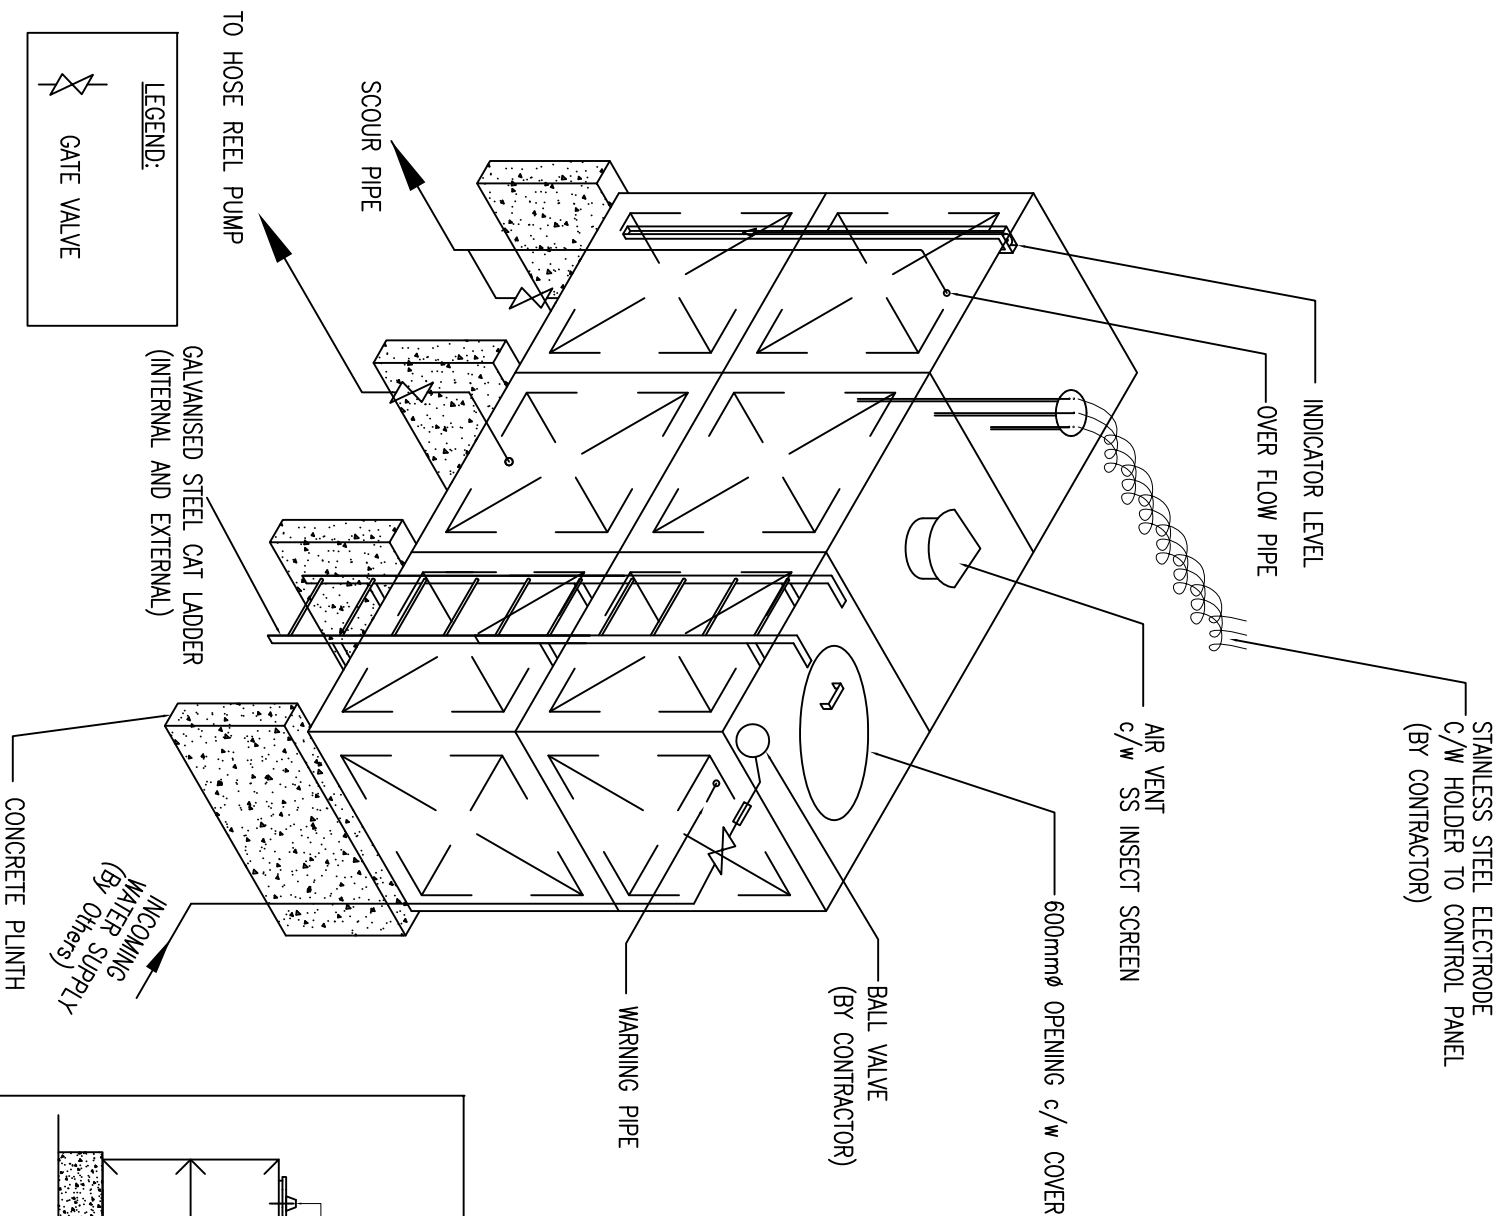

NOTE:
PLEASE REFER TO THE SCHEMATIC FOR THE EXACT TANK SIZE

DETAIL OF HOSE REEL TANK INSTALLATION




JASA KEPADA RAKYAT

CAWANGAN KEJURUTERAAN MEKANIKAL
Ibu Pejabat JKR Malaysia


FIRE FIGHTING SYSTEM

DETAIL OF HOSE REEL TANK INSTALLATION


DATE	2017	SCALE	NTS
DRAWING NUMBER	CKM/STD/FF/WATER TANK/REV2017/01		

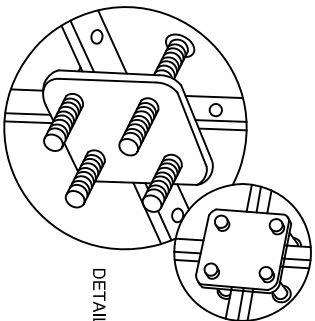


DETAIL OF 'A'

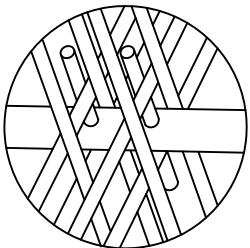


DETAIL OF 'B'

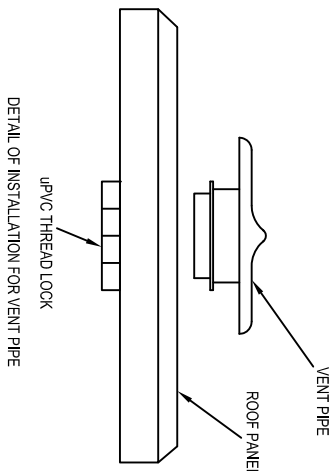


DETAIL OF INSTALLATION FOR VENT PIPE

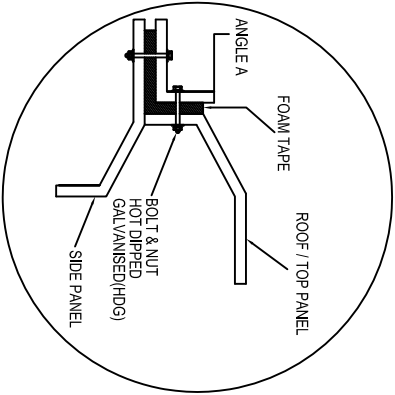


DETAIL OF 'D':
DETAIL OF INSTALLATION FOR ROOF PANEL

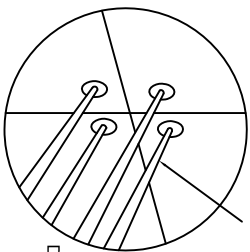


DETAIL OF 'C'

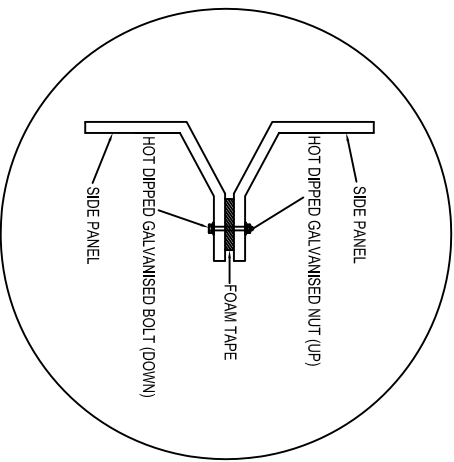

DETAIL OF 'E':
DETAIL OF INSTALLATION FOR SIDE PANEL

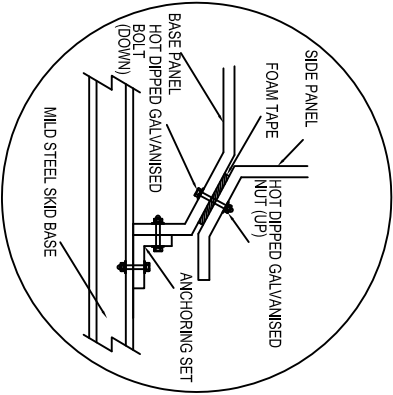

DETAIL OF 'F':
DETAIL OF INSTALLATION FOR BASE PANEL

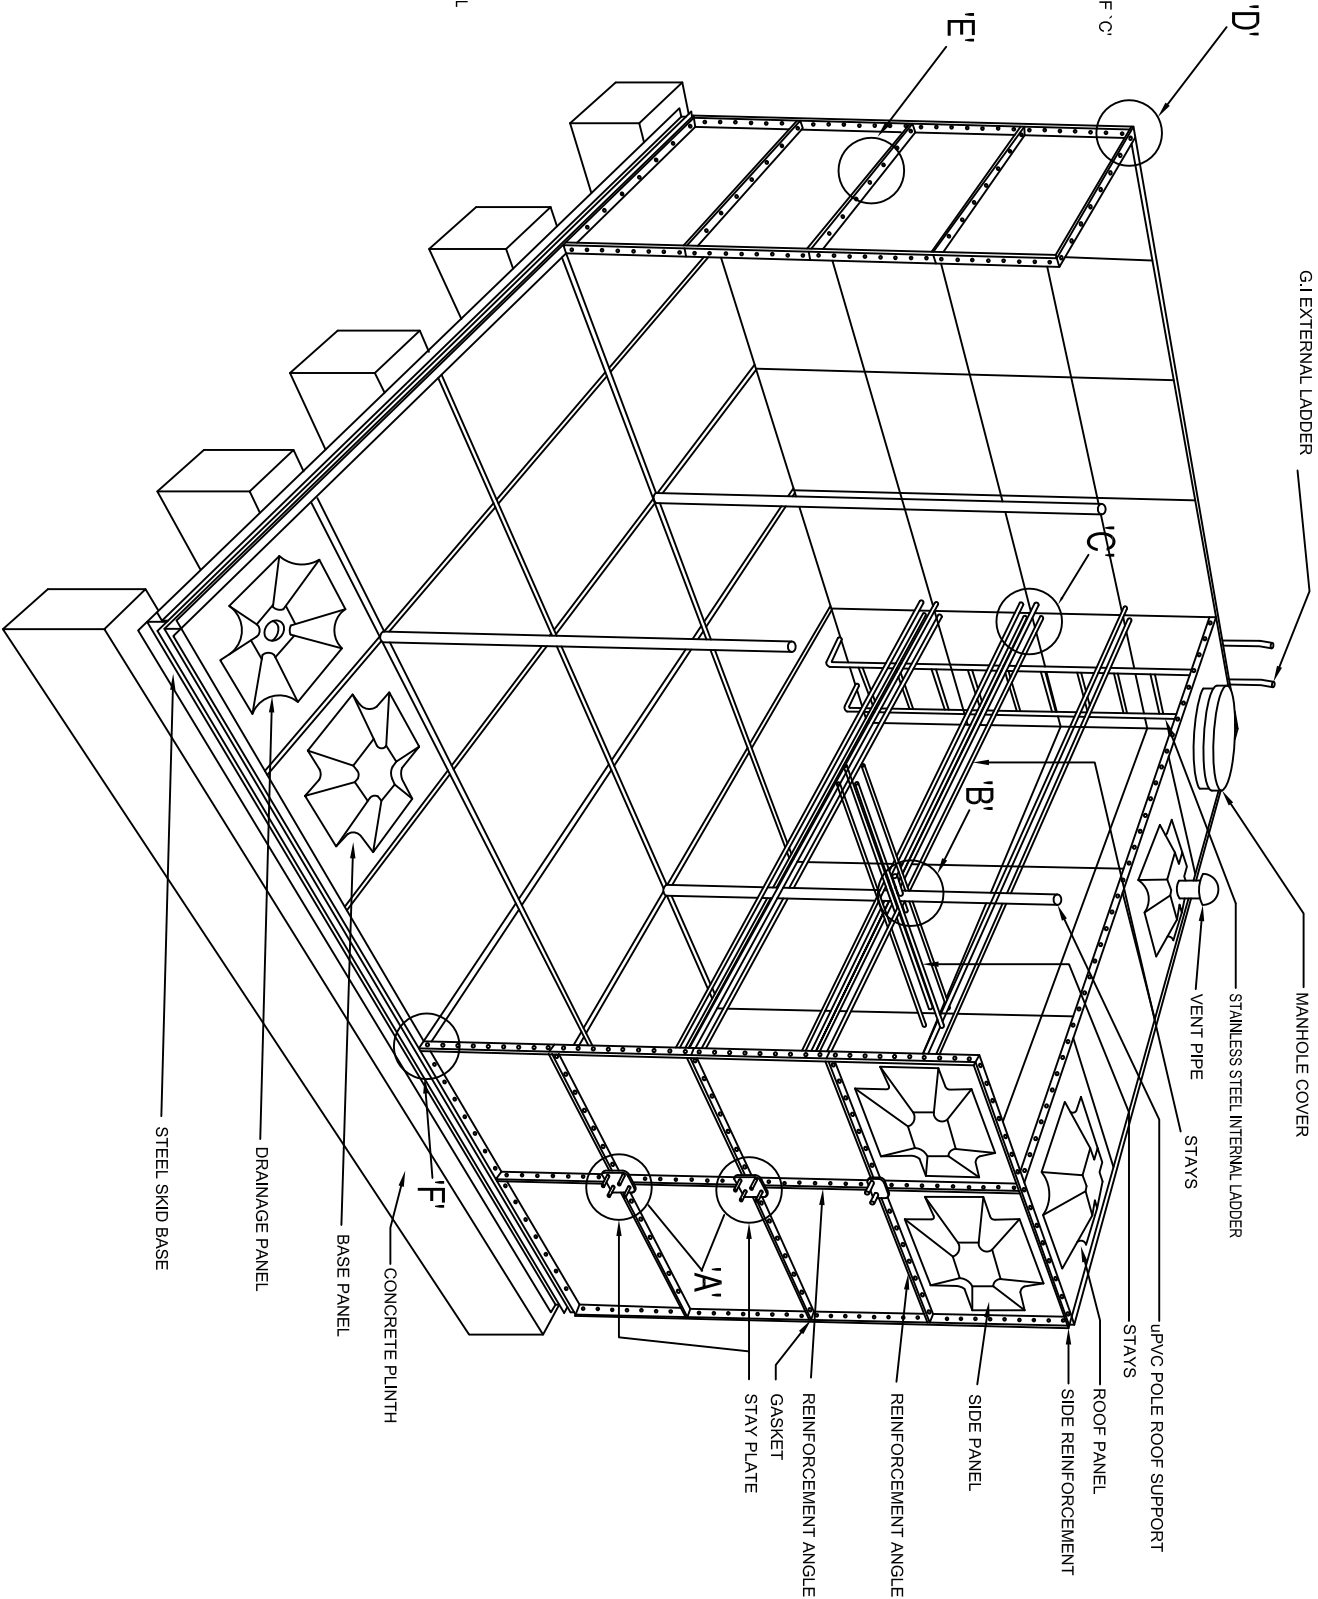

DETAIL OF FRP INTERNAL REINFORCEMENT SUPPORT & PANEL

SCALE : NTS




JASA KEPADA RAKYAT

CAWANGAN KEJURUTERAAN MEKANIKAL
Ibu Pejabat JKR Malaysia


FIRE FIGHTING SYSTEM
DETAIL OF FRP INTERNAL REINFORCEMENT
SUPPORT & PANEL

DATE	2017	SCALE	NTS
DRAWING NUMBER	CKM/STD/FF/WATER TANK/REV2017/02		

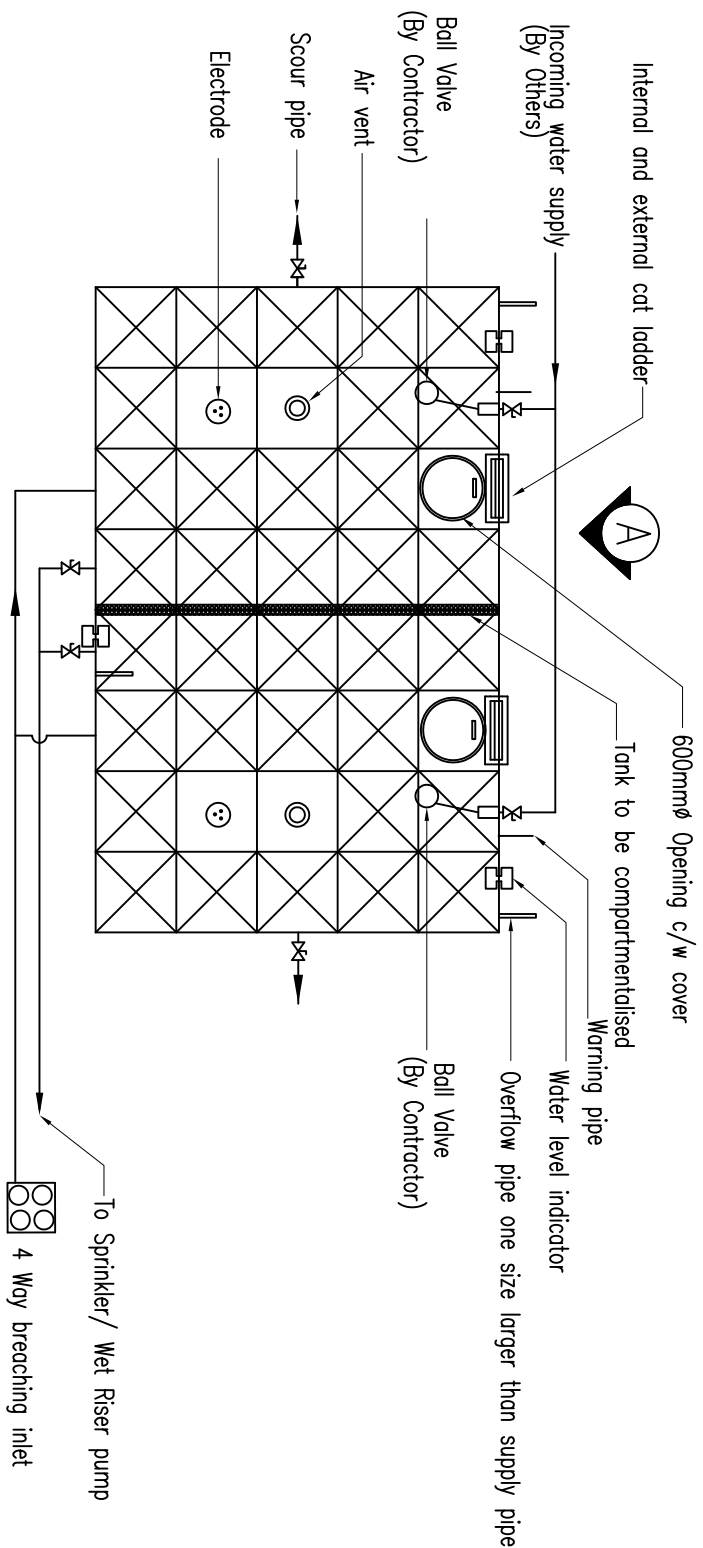

PLAN VIEW

NOTE:
REFER TO THE SCHEMATIC FOR THE EXACT TANK SIZE

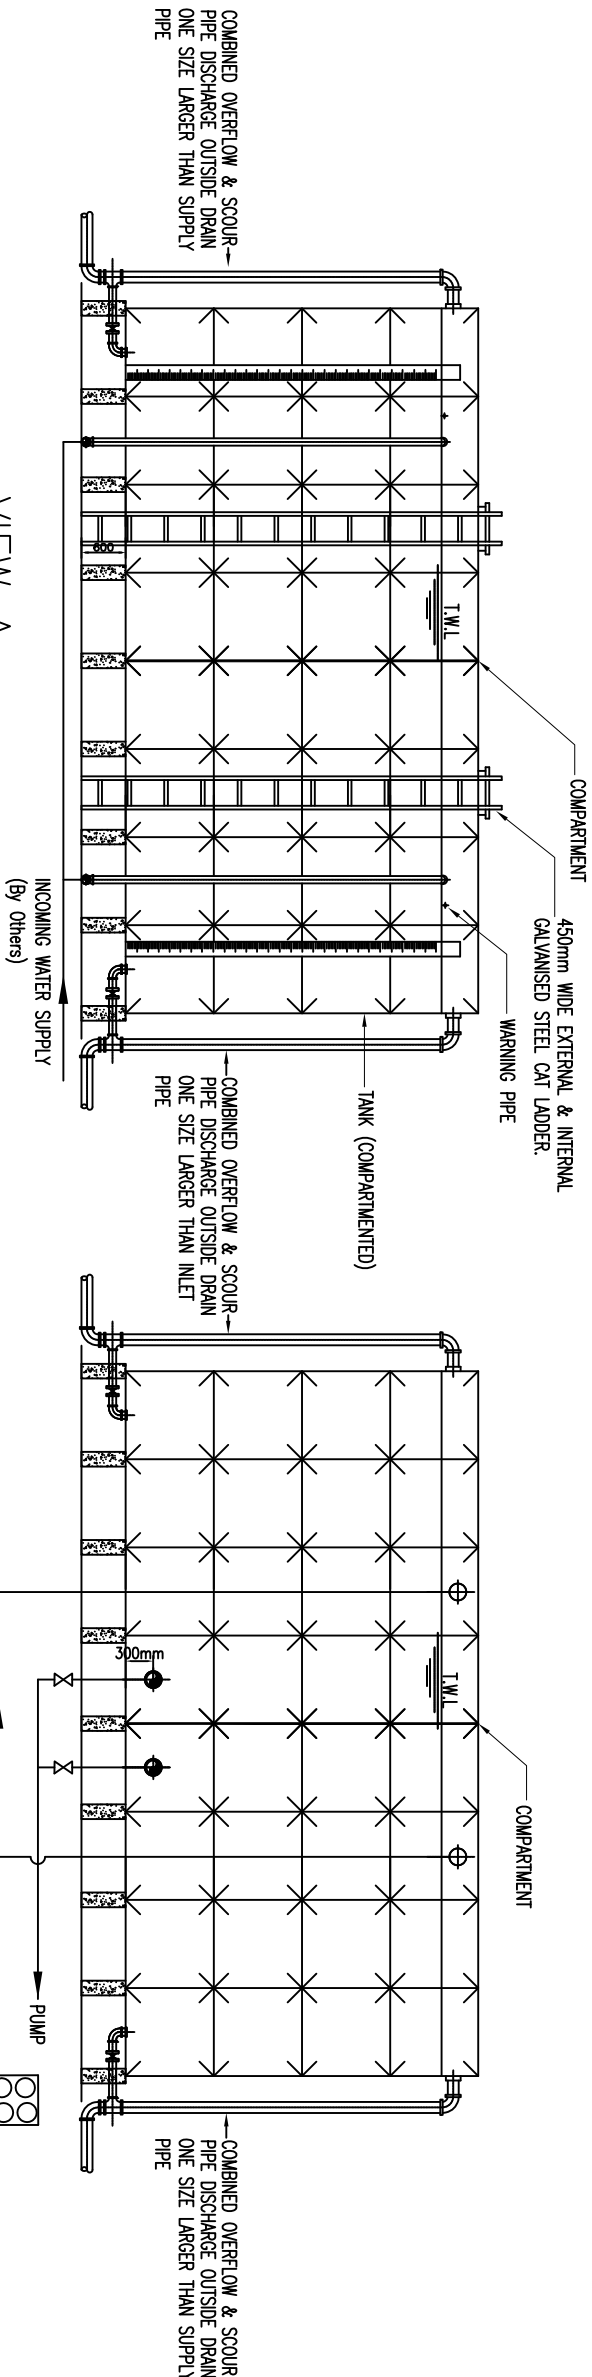

DETAIL OF SPRINKLER AND WET RISER TANK INSTALLATION




JASA KEPADA RAKYAT
CAWANGAN KEJURUTERAAN MEKANIKAL
Ibu Pejabat JKR Malaysia

FIRE FIGHTING SYSTEM

DETAIL OF SPRINKLER AND WET RISER TANK
INSTALLATION

DATE	2017	SCALE	NTS
DRAWING NUMBER	CKM/STD/FF/WATER TANKREV2017/03		

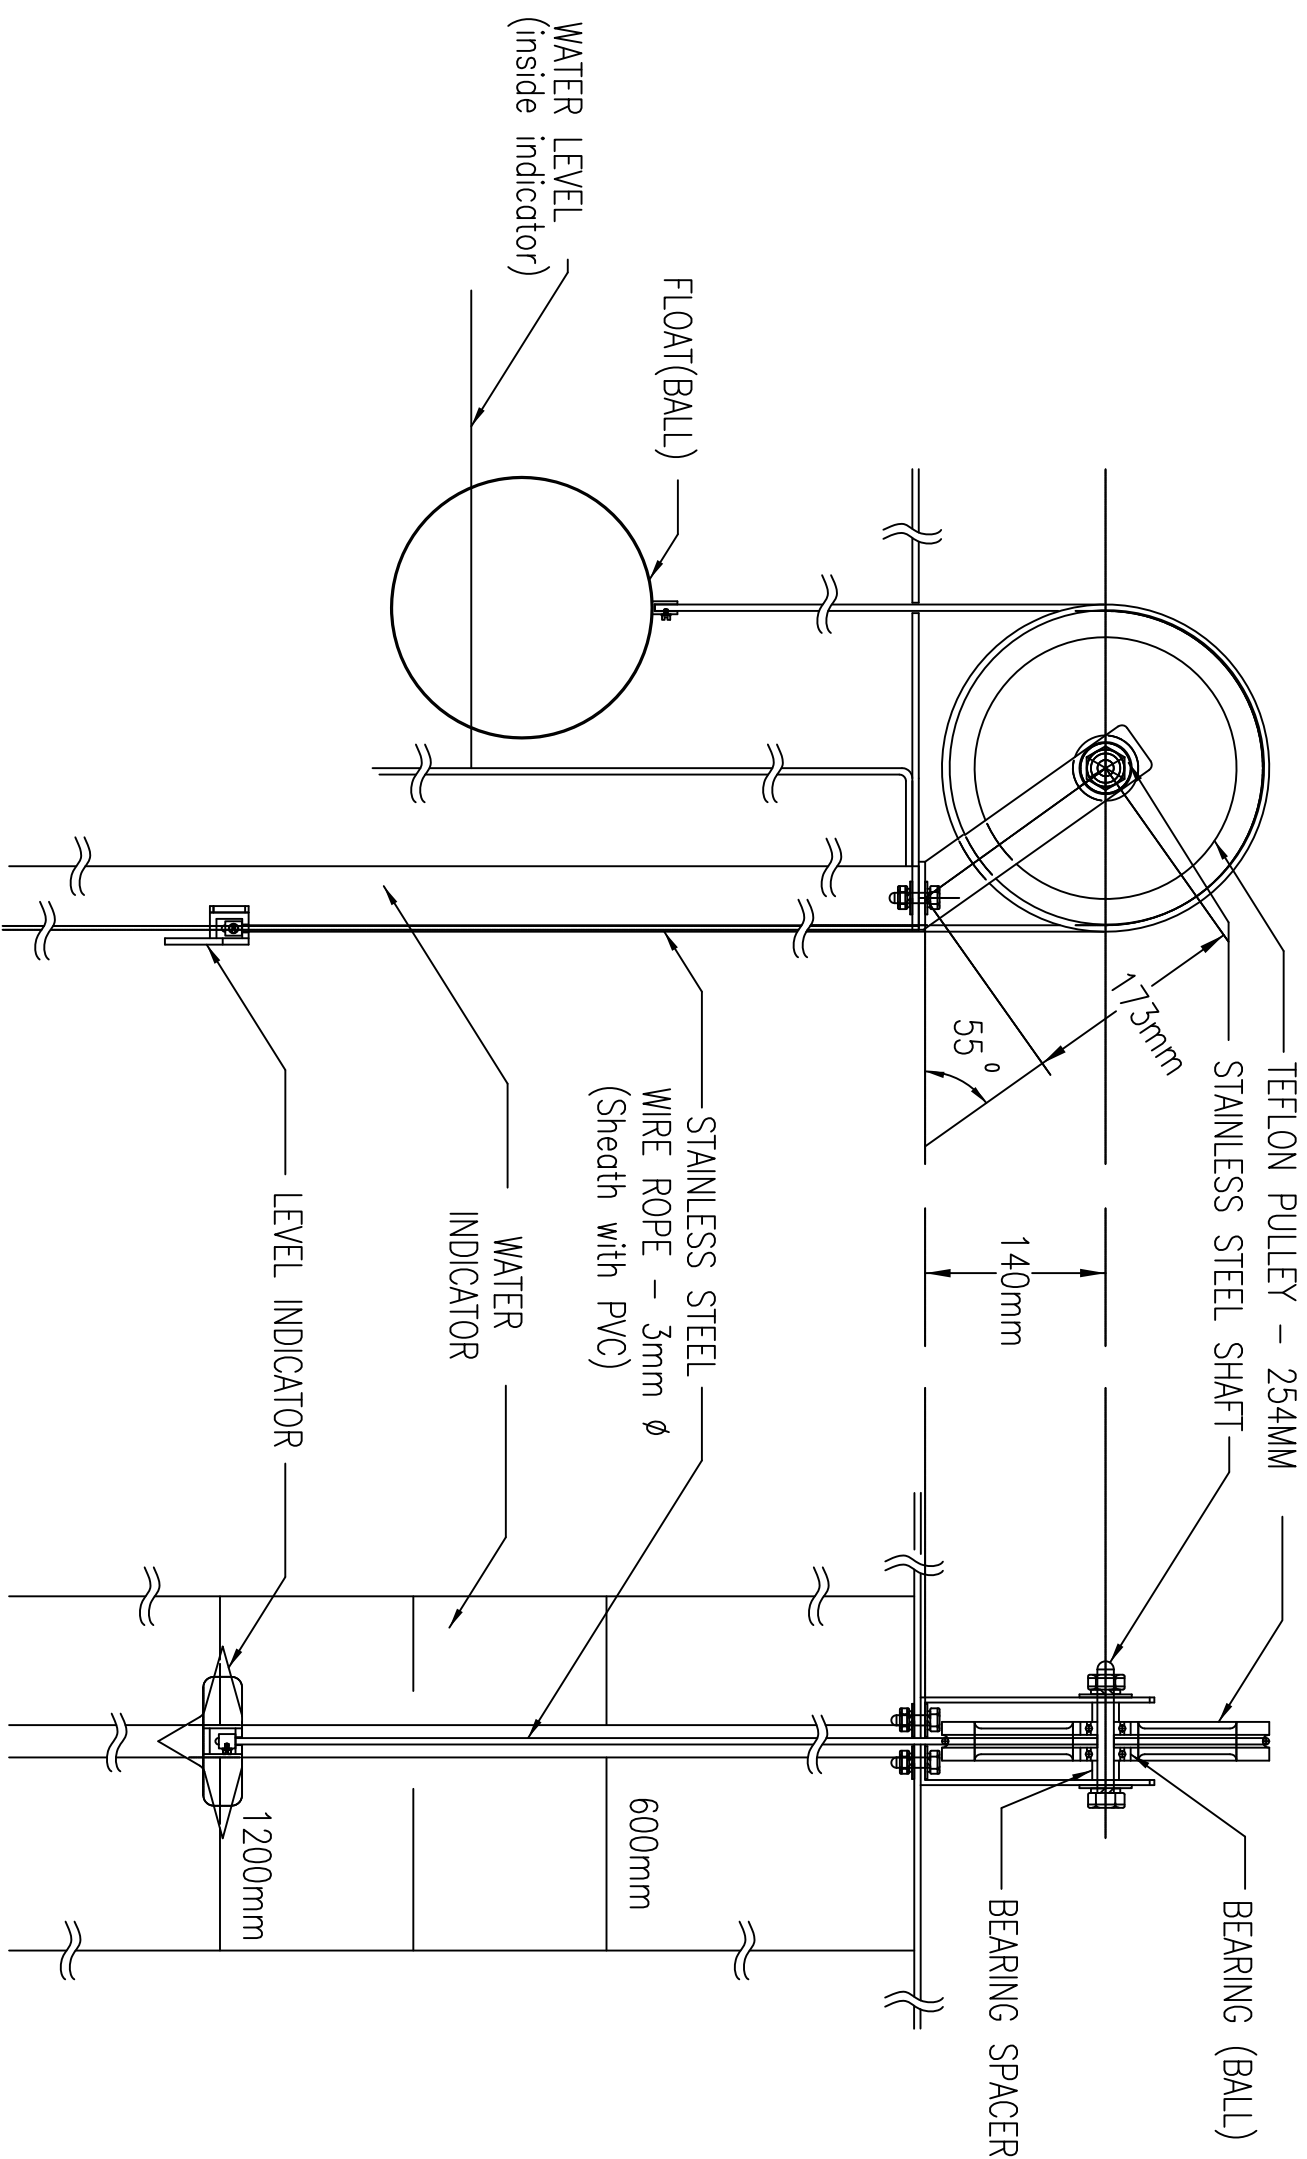

DETAIL OF LEVEL INDICATOR INSTALLATION




JASA KEPADA RAKYAT

CAWANGAN KEJURUTERAAN MEKANIKAL
Ibu Pejabat JKR Malaysia


FIRE FIGHTING SYSTEM

DETAIL OF LEVEL INDICATOR INSTALLATION

DATE	2017	SCALE	NTS
DRAWING NUMBER	CKM/STD/FF/WATER TANK/REV2017/04		

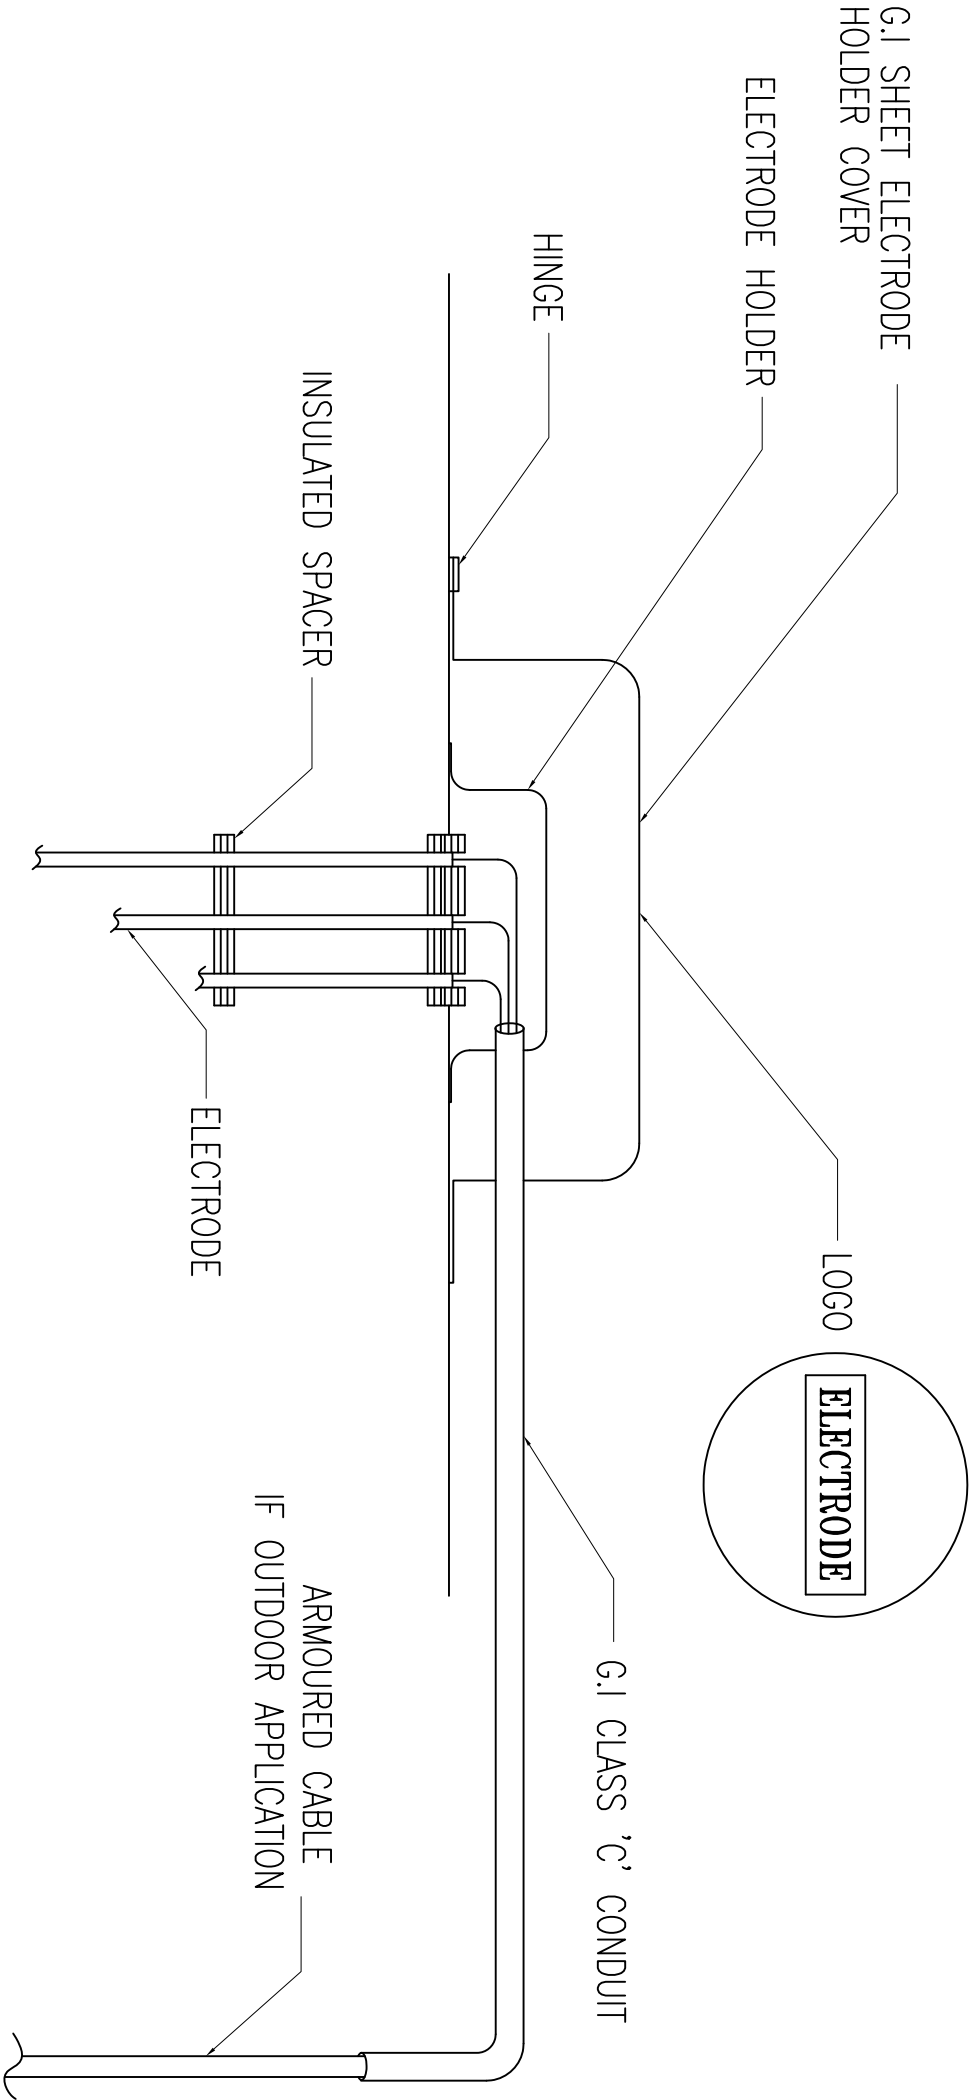

DETAIL OF ELECTRODE INSTALLATION FOR FIRE FIGHTING TANK

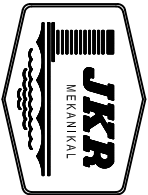





JASA KEPADA RAKYAT

CAWANGAN KEJURUTERAAN MEKANIKAL
Ibu Pejabat JKR Malaysia

FIRE FIGHTING SYSTEM

DETAIL OF ELECTRODE INSTALLATION FOR
FIRE FIGHTING TANK





DATE	SCALE
2017	NTS
DRAWING NUMBER	
CKM/STD/FF/WATER TANK/REV2017/05	

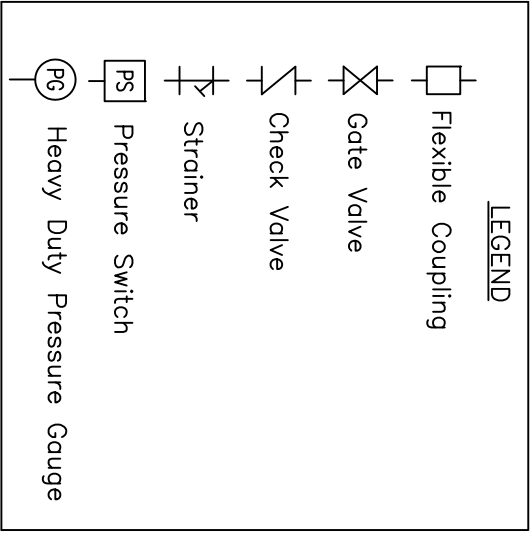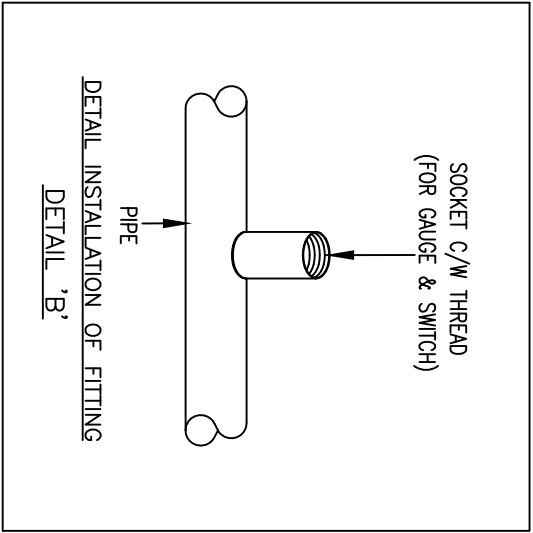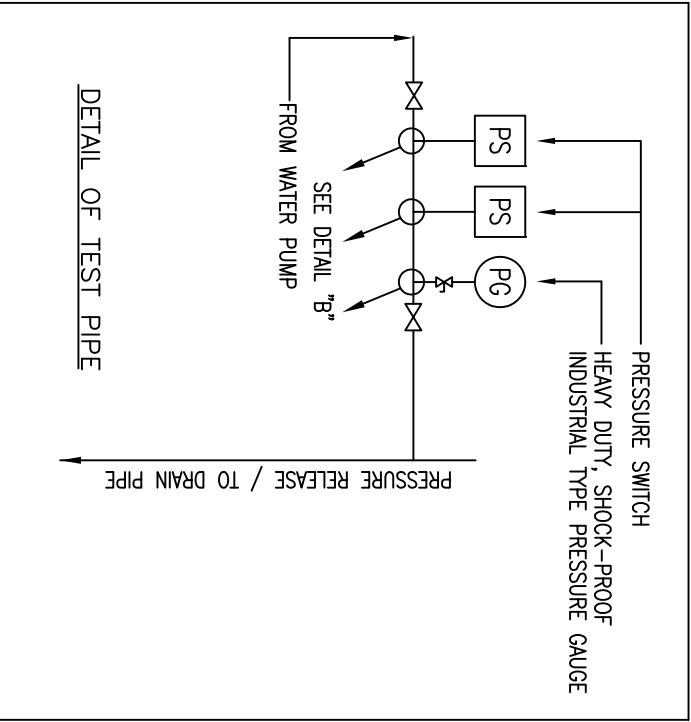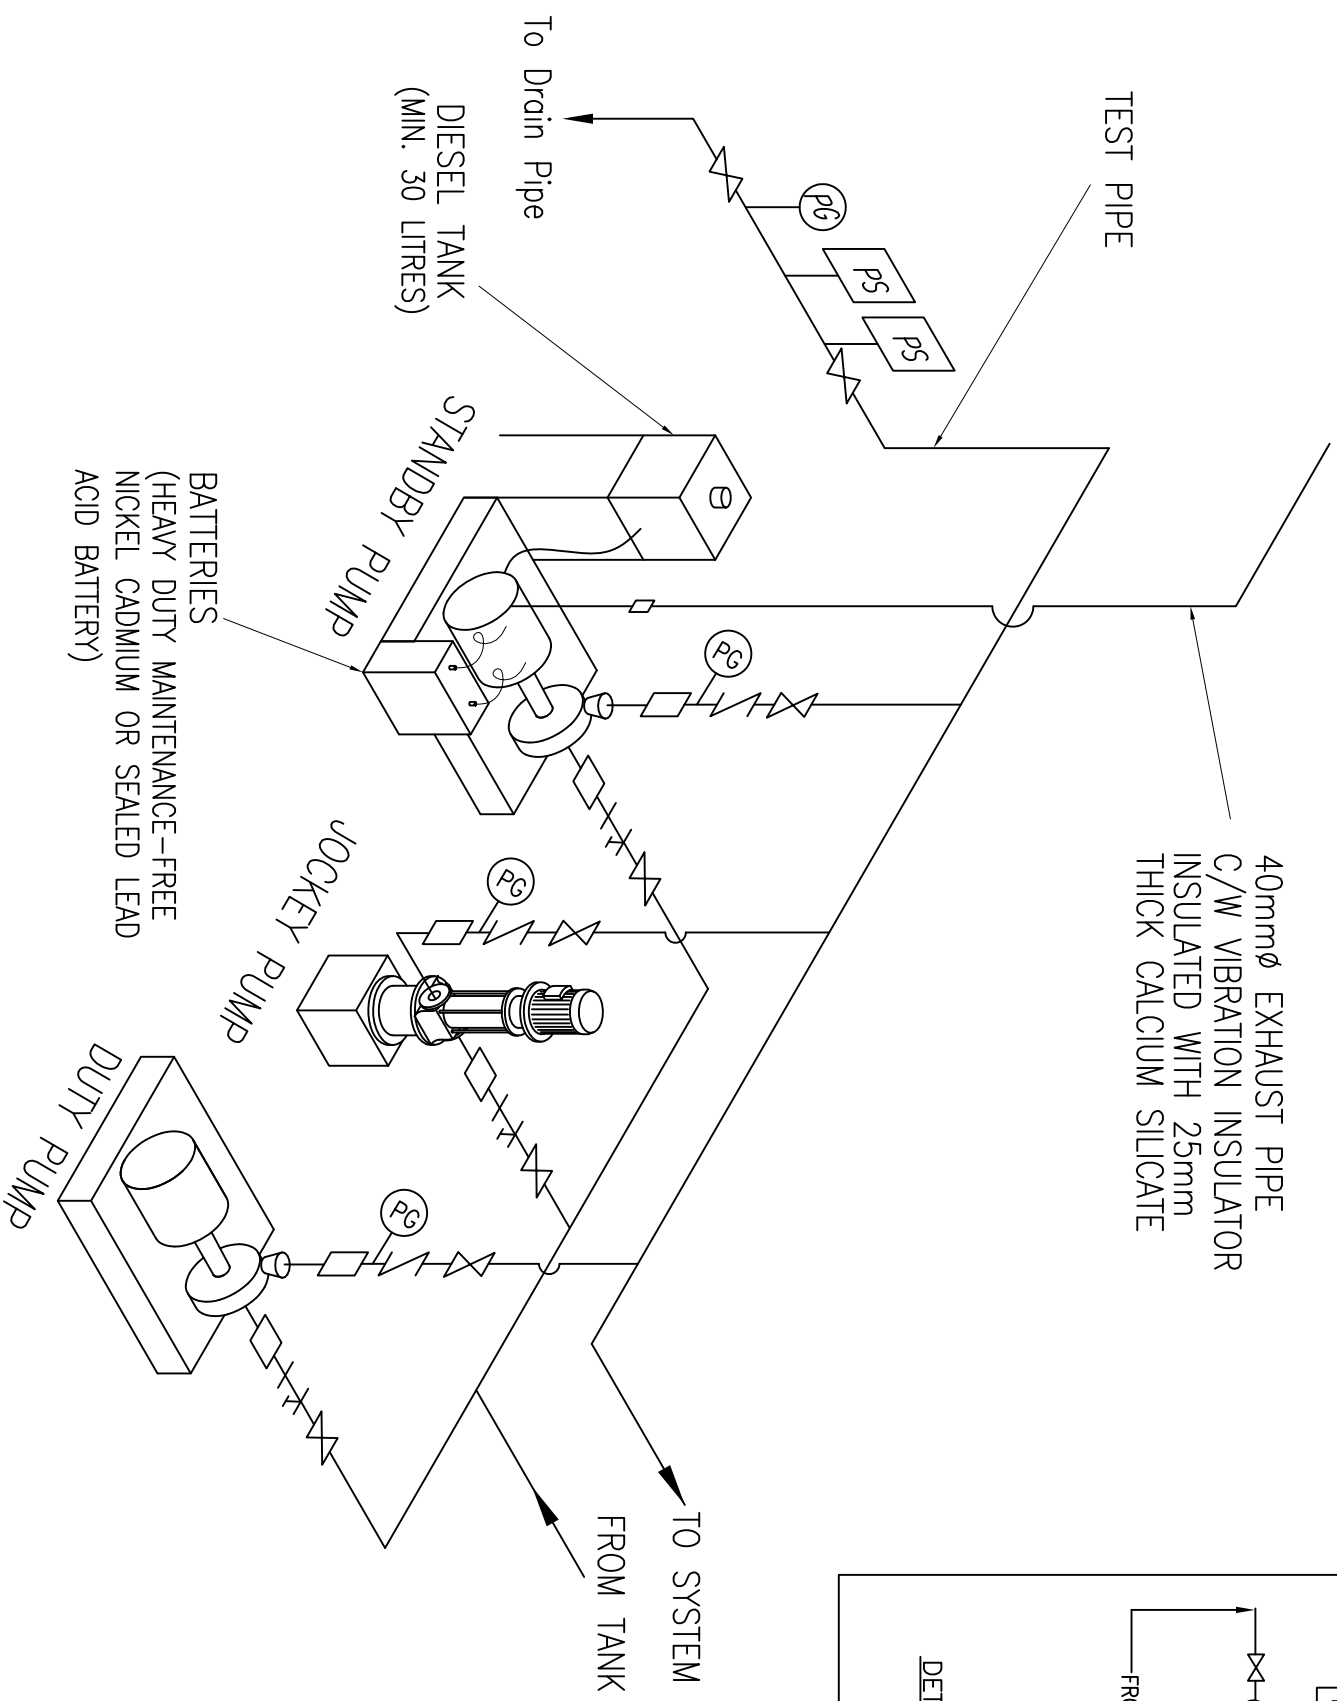

CAWANGAN KEJURUTERAAN MEKANIKAL
Ibu Pejabat JKR Malaysia

FIRE FIGHTING SYSTEM

DETAIL OF SPRINKLER / WET RISER PUMP
/ PRESSURISED HYDRANT
(DIESEL ENGINE DRIVEN)

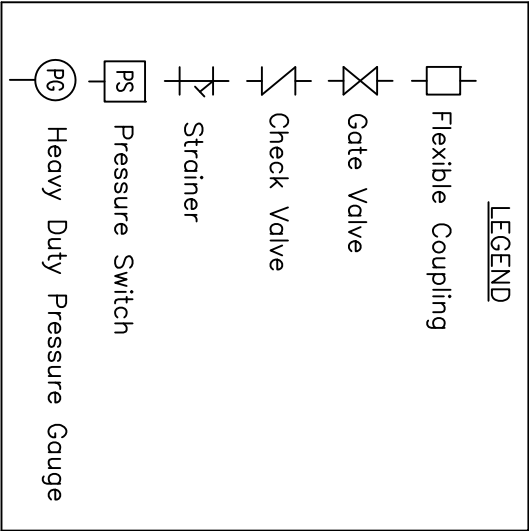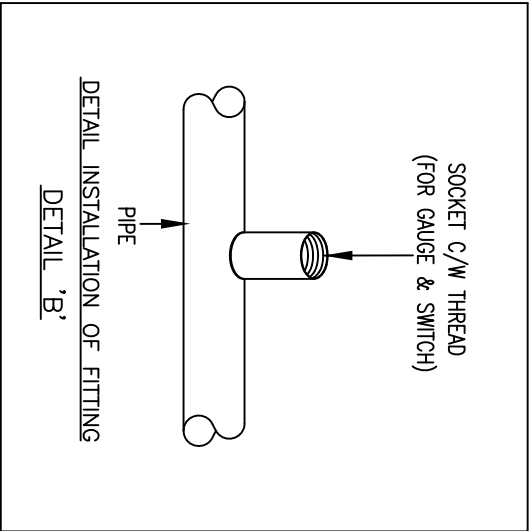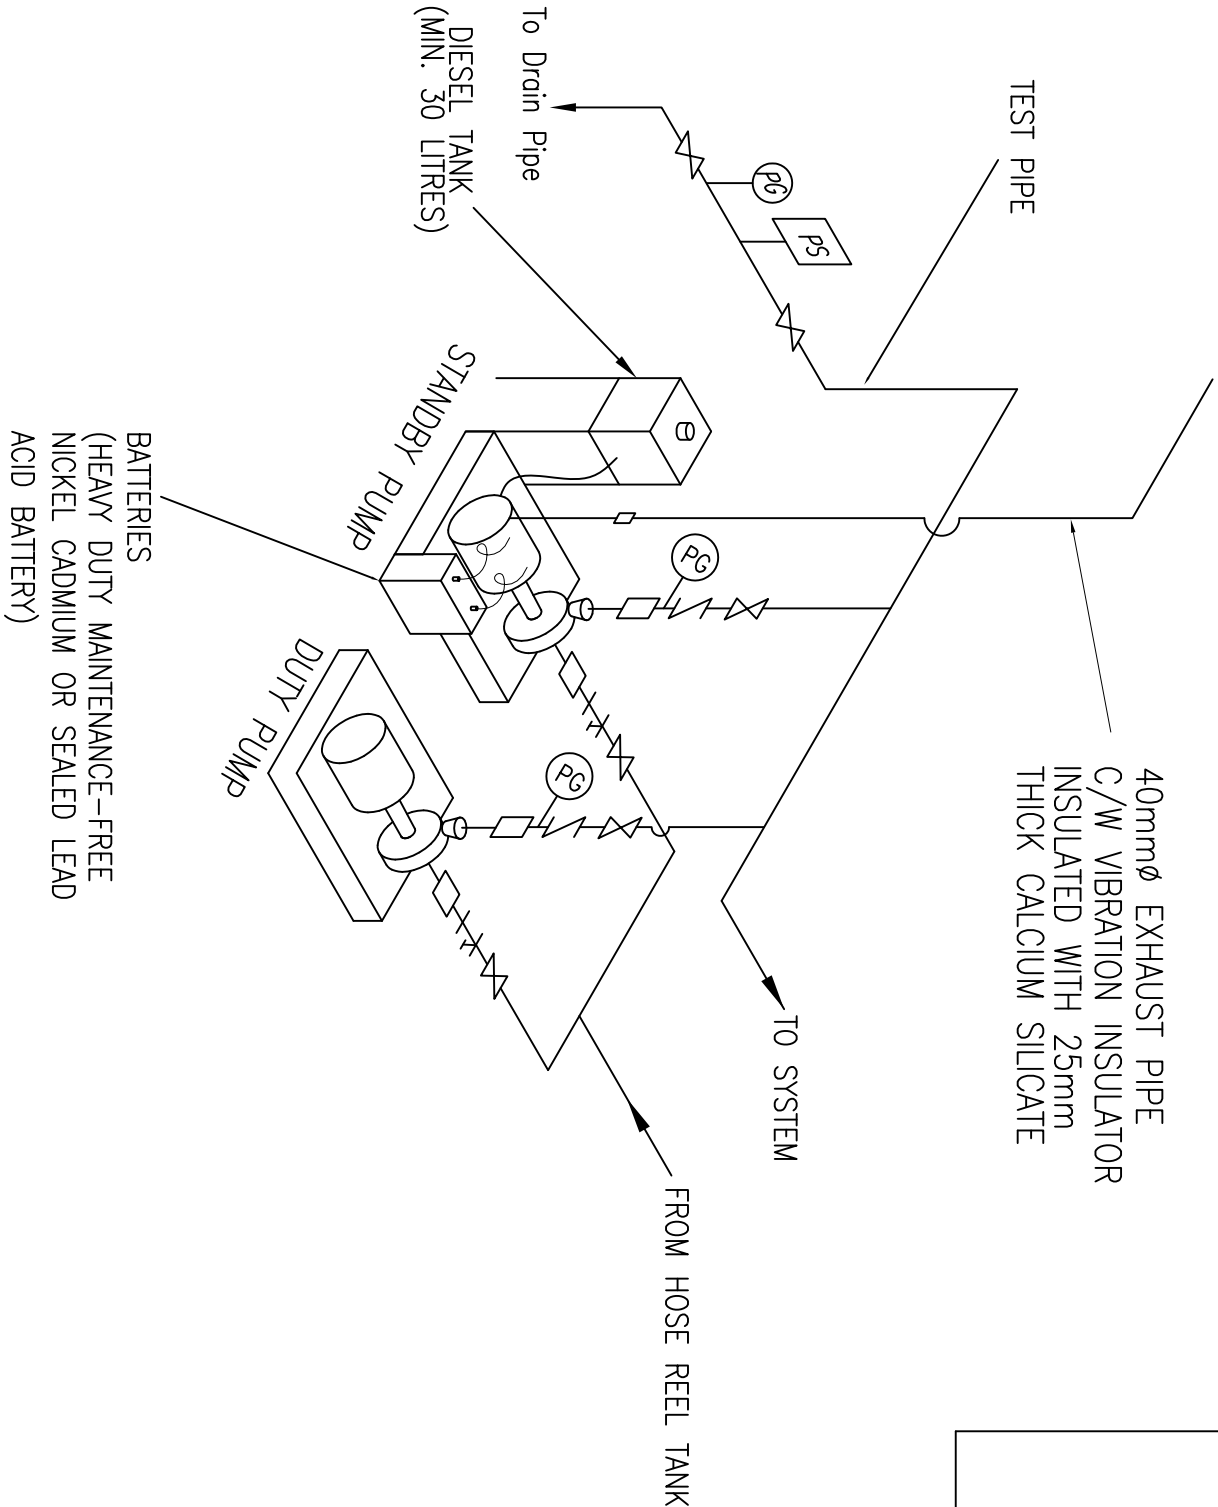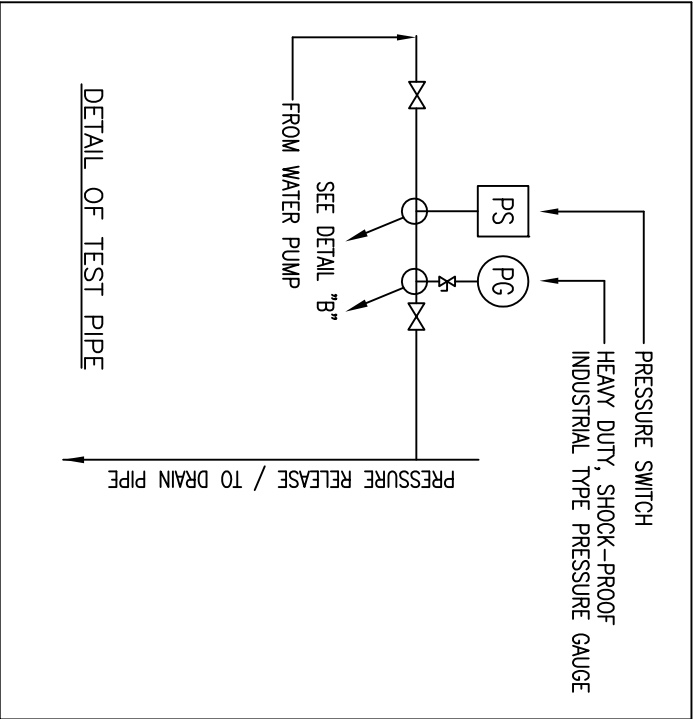

DETAIL OF HOSE REEL PUMP







JASA KEPADA RAKYAT

CAWANGAN KEJURUTERAAN MEKANIKAL
Ibu Pejabat JKR Malaysia

FIRE FIGHTING SYSTEM

DETAIL OF HOSE REEL PUMP
(DIESEL ENGINE DRIVEN)





DATE	2017	SCALE	NTS
DRAWING NUMBER	CKM/STD/FF/PUMP/REV/2017/02		

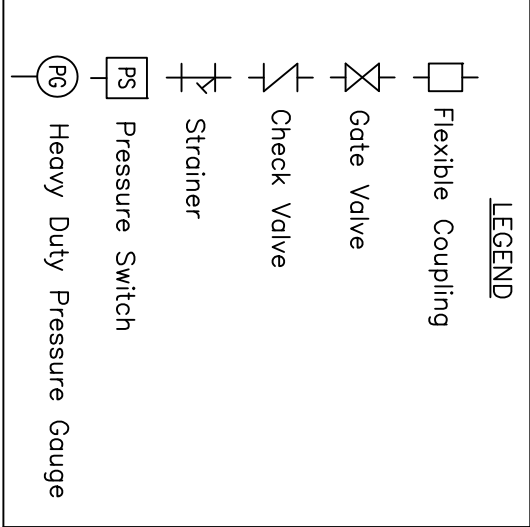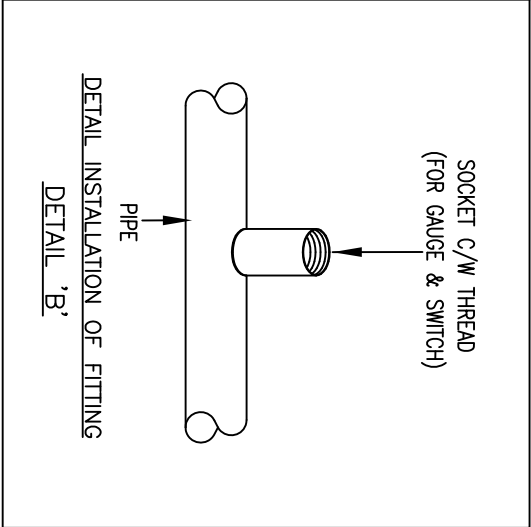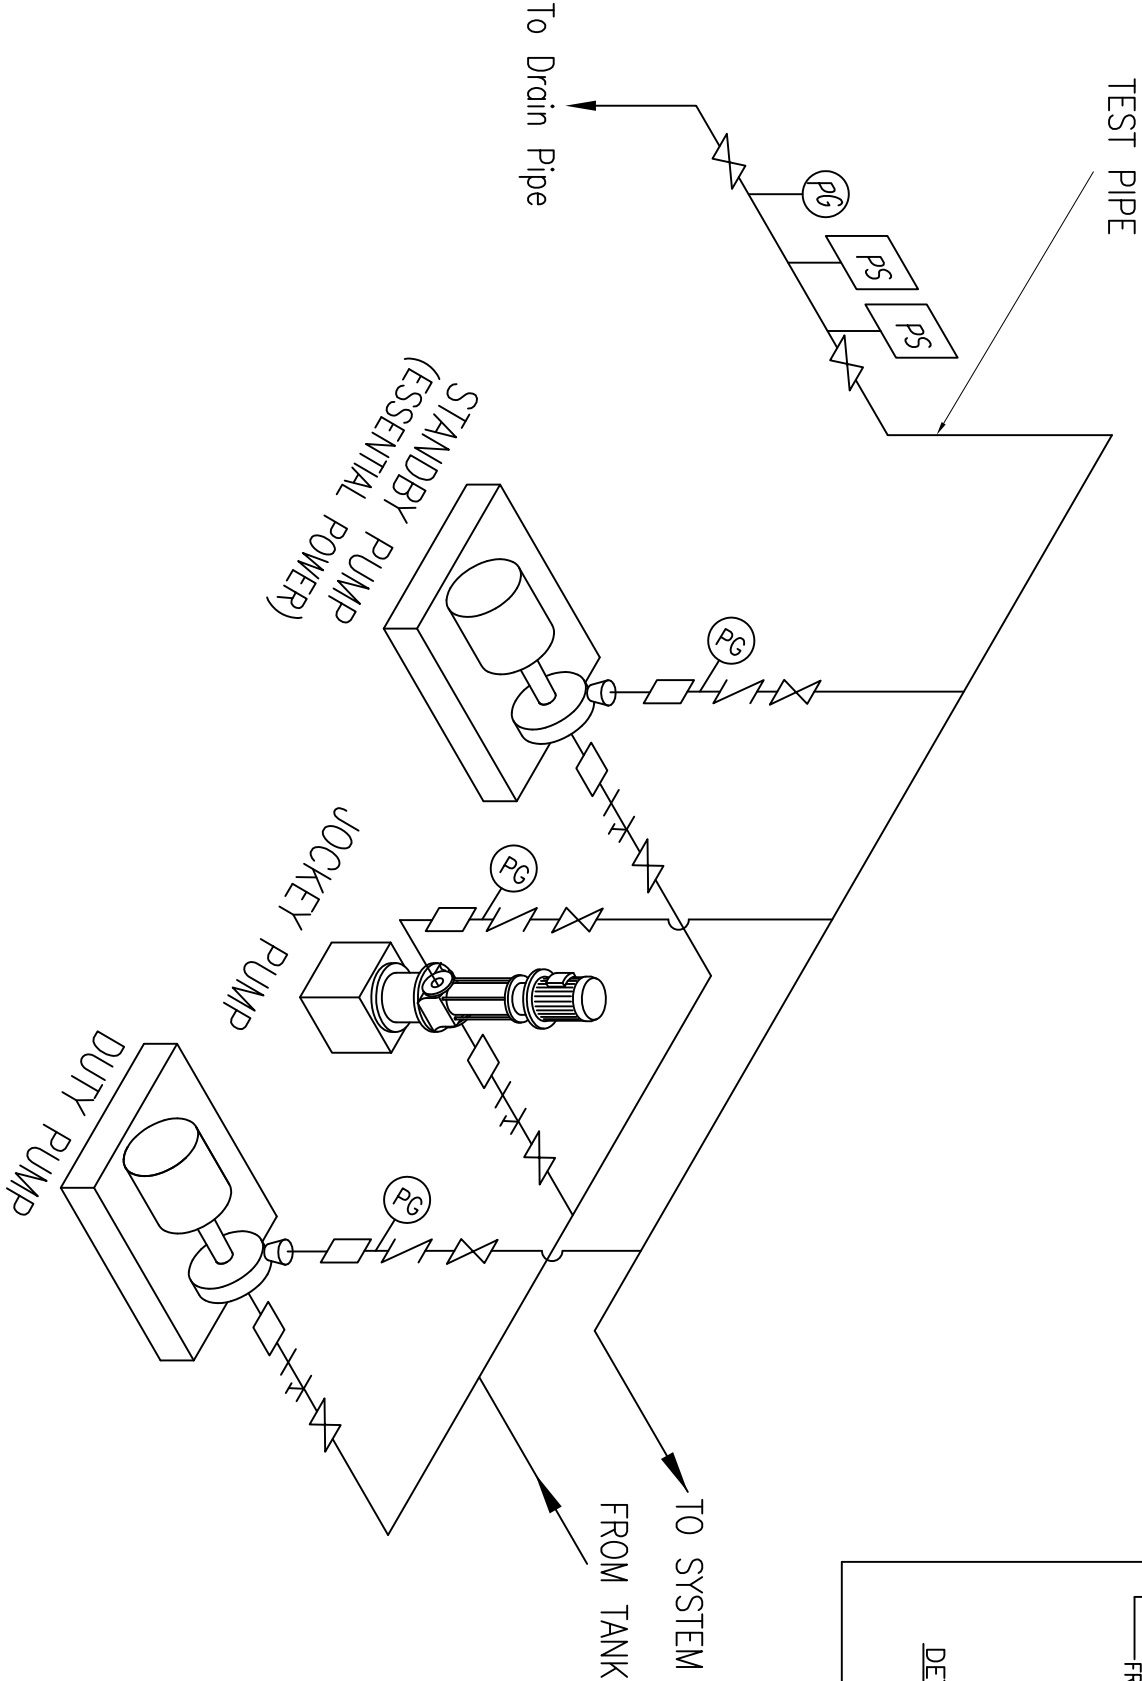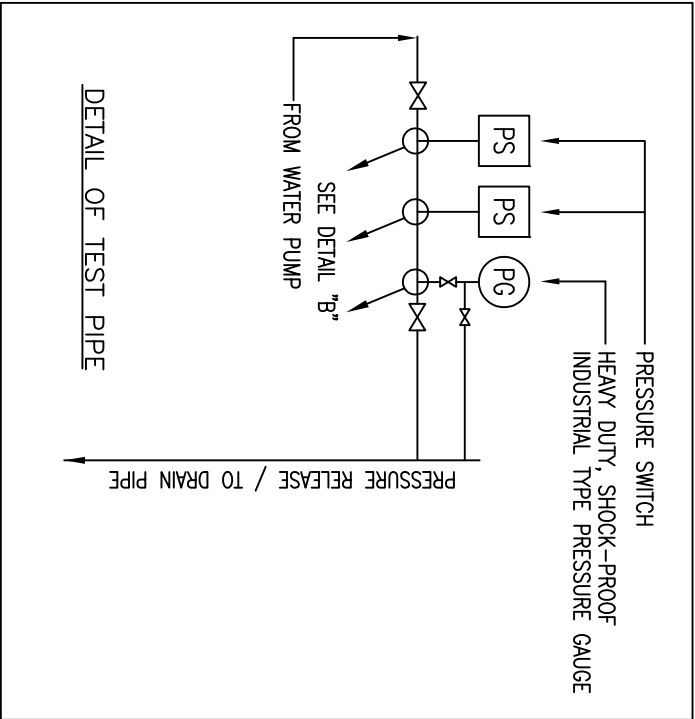

JASA KEPADA RAKYAT
CAWANGAN KEJURUTERAAN MEKANIKAL
Ibu Pejabat JKR Malaysia

FIRE FIGHTING SYSTEM
DETAIL OF SPRINKLER / WET RISER PUMP
/ PRESSURISED HYDRANT
(ELECTRIC DRIVEN - GENSET)

DATE 2017 SCALE NTS
DRAWING NUMBER CKM/STD/FF/PUMP/REV/2017/03

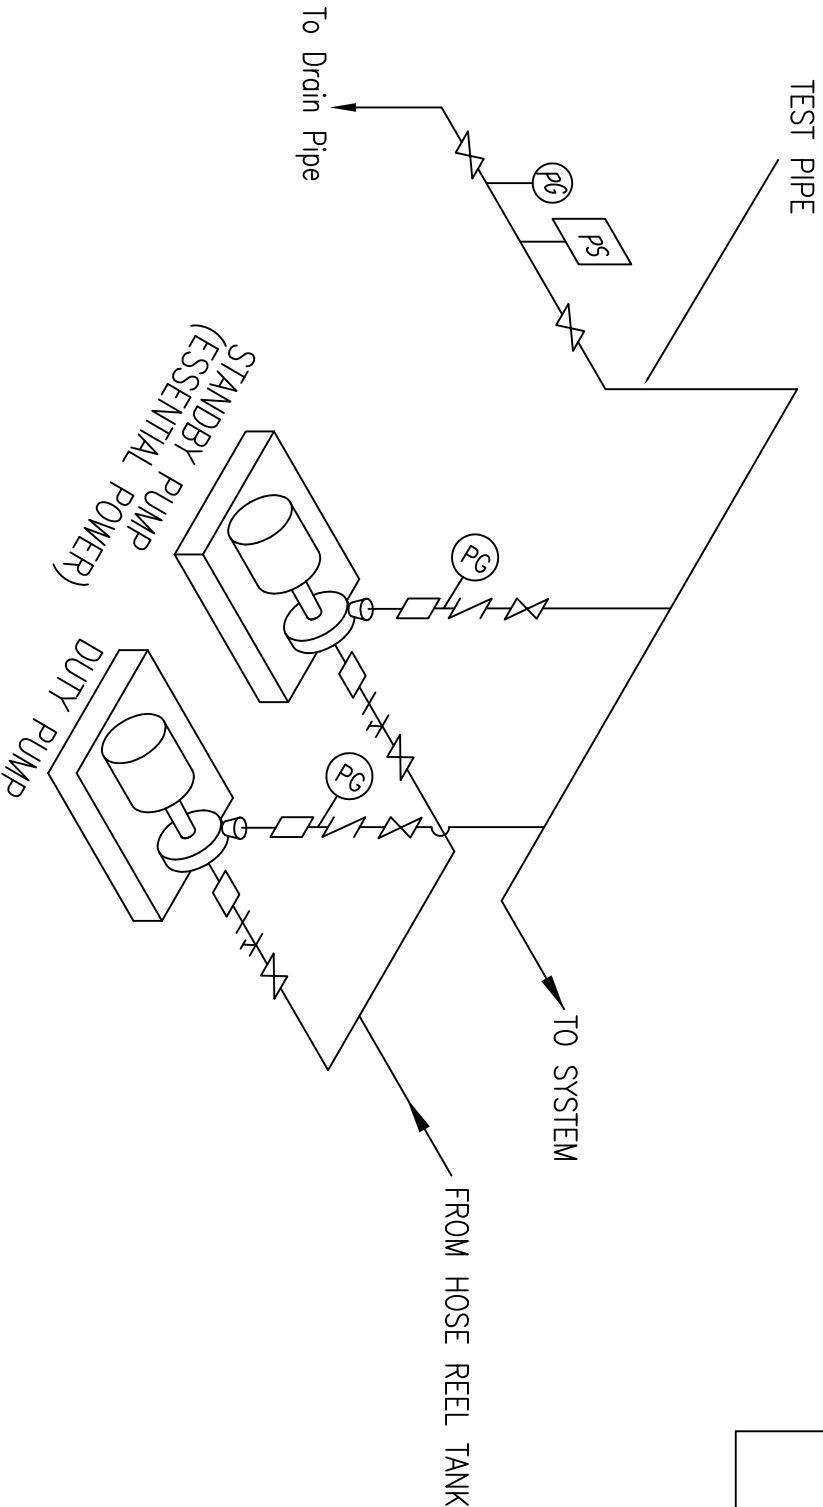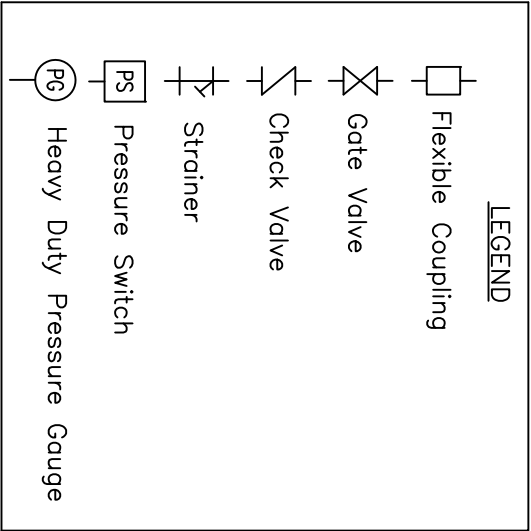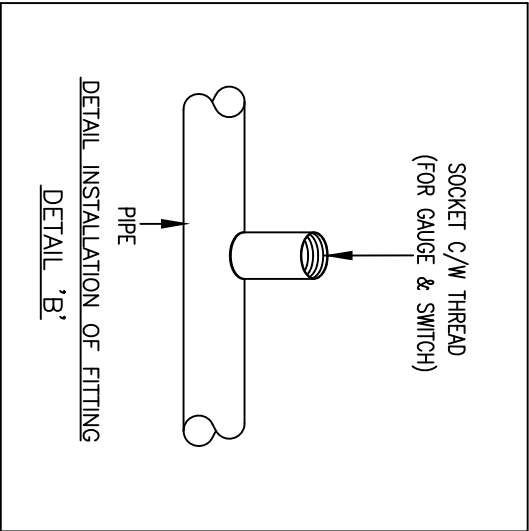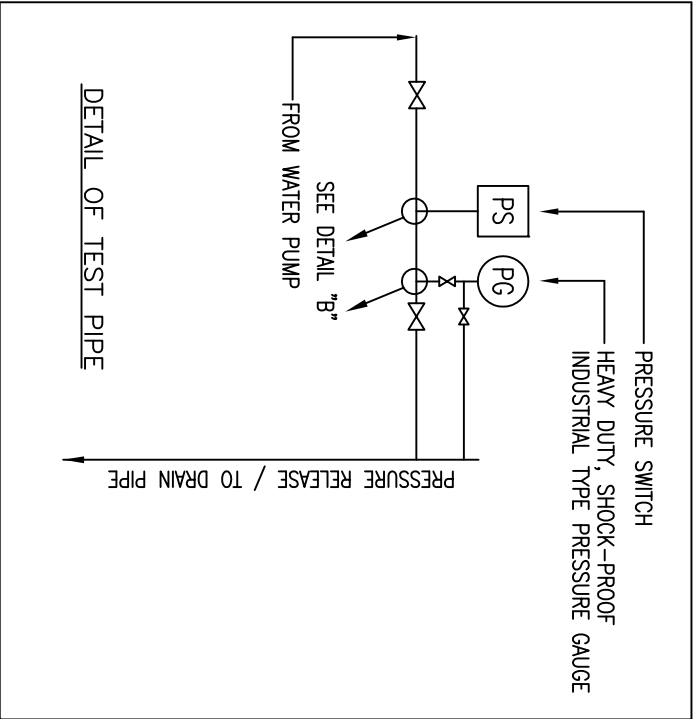

DETAIL OF HOSE REEL PUMP




JASA KEPADA RAKYAT

CAWANGAN KEJURUTERAAN MEKANIKAL
Ibu Pejabat JKR Malaysia



FIRE FIGHTING SYSTEM

DETAIL OF HOSE REEL PUMP
(ELECTRIC DRIVEN - GENSET)

DATE	2017	SCALE	NTS
DRAWING NUMBER	CKM/STD/FF/PUMP/REV/2017/04		

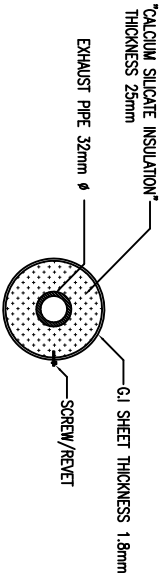

CROSS SECTION OF DIESEL ENGINE EXHAUST PIPE

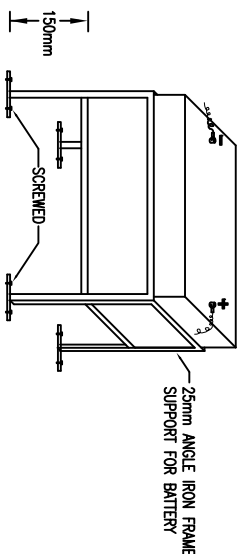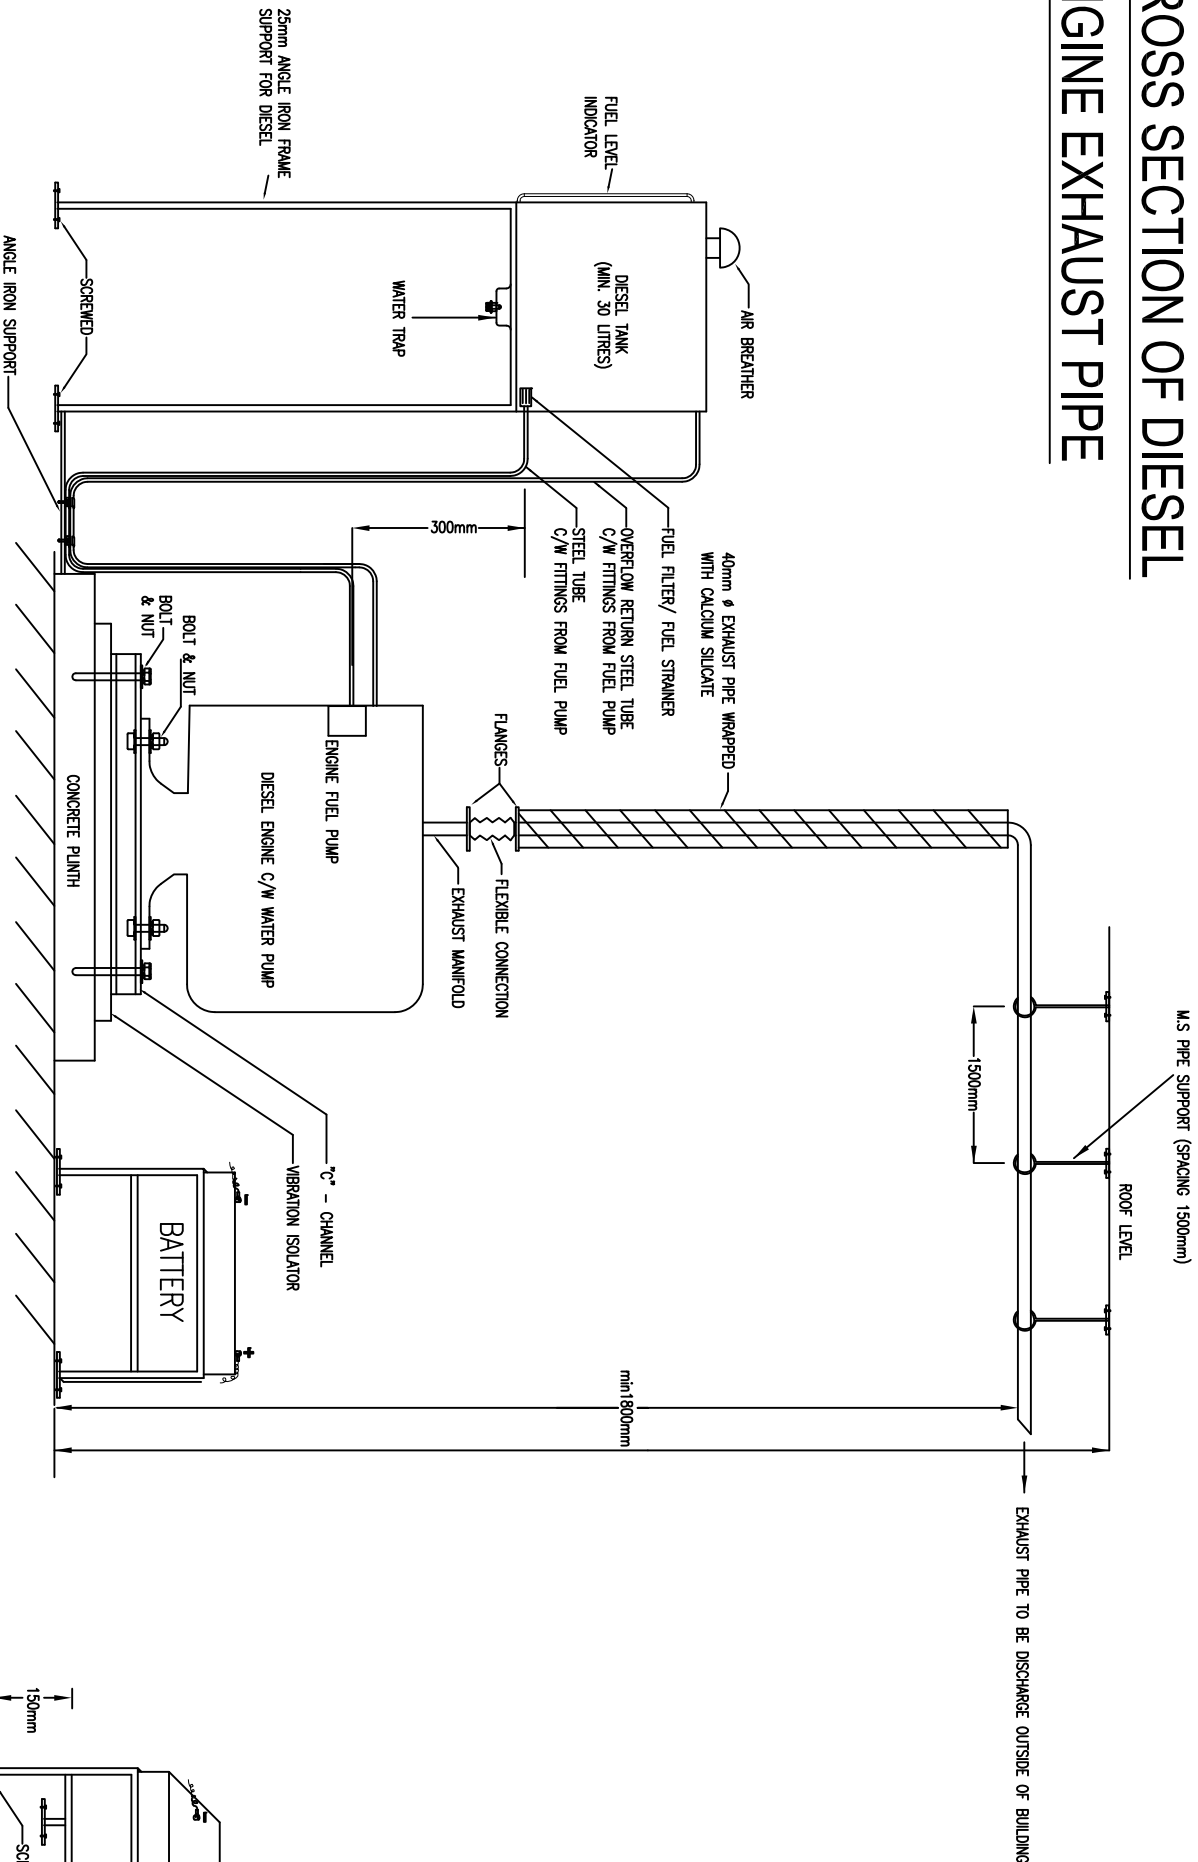

DETAIL OF DIESEL ENGINE EXHAUST PIPE INSULATION

BATTERY FOR DIESEL ENGINE INSTALLATION



JASA KEPADA RAKYAT

CAWANGAN KEJURUTERAAN MEKANIKAL

Ibu Pejabat JKR Malaysia


FIRE FIGHTING SYSTEM

DETAIL OF DIESEL ENGINE INSTALLATION

DATE 2017 SCALE NTS

DRAWING NUMBER

CKM/STD/FPUMP/REV/2017/05

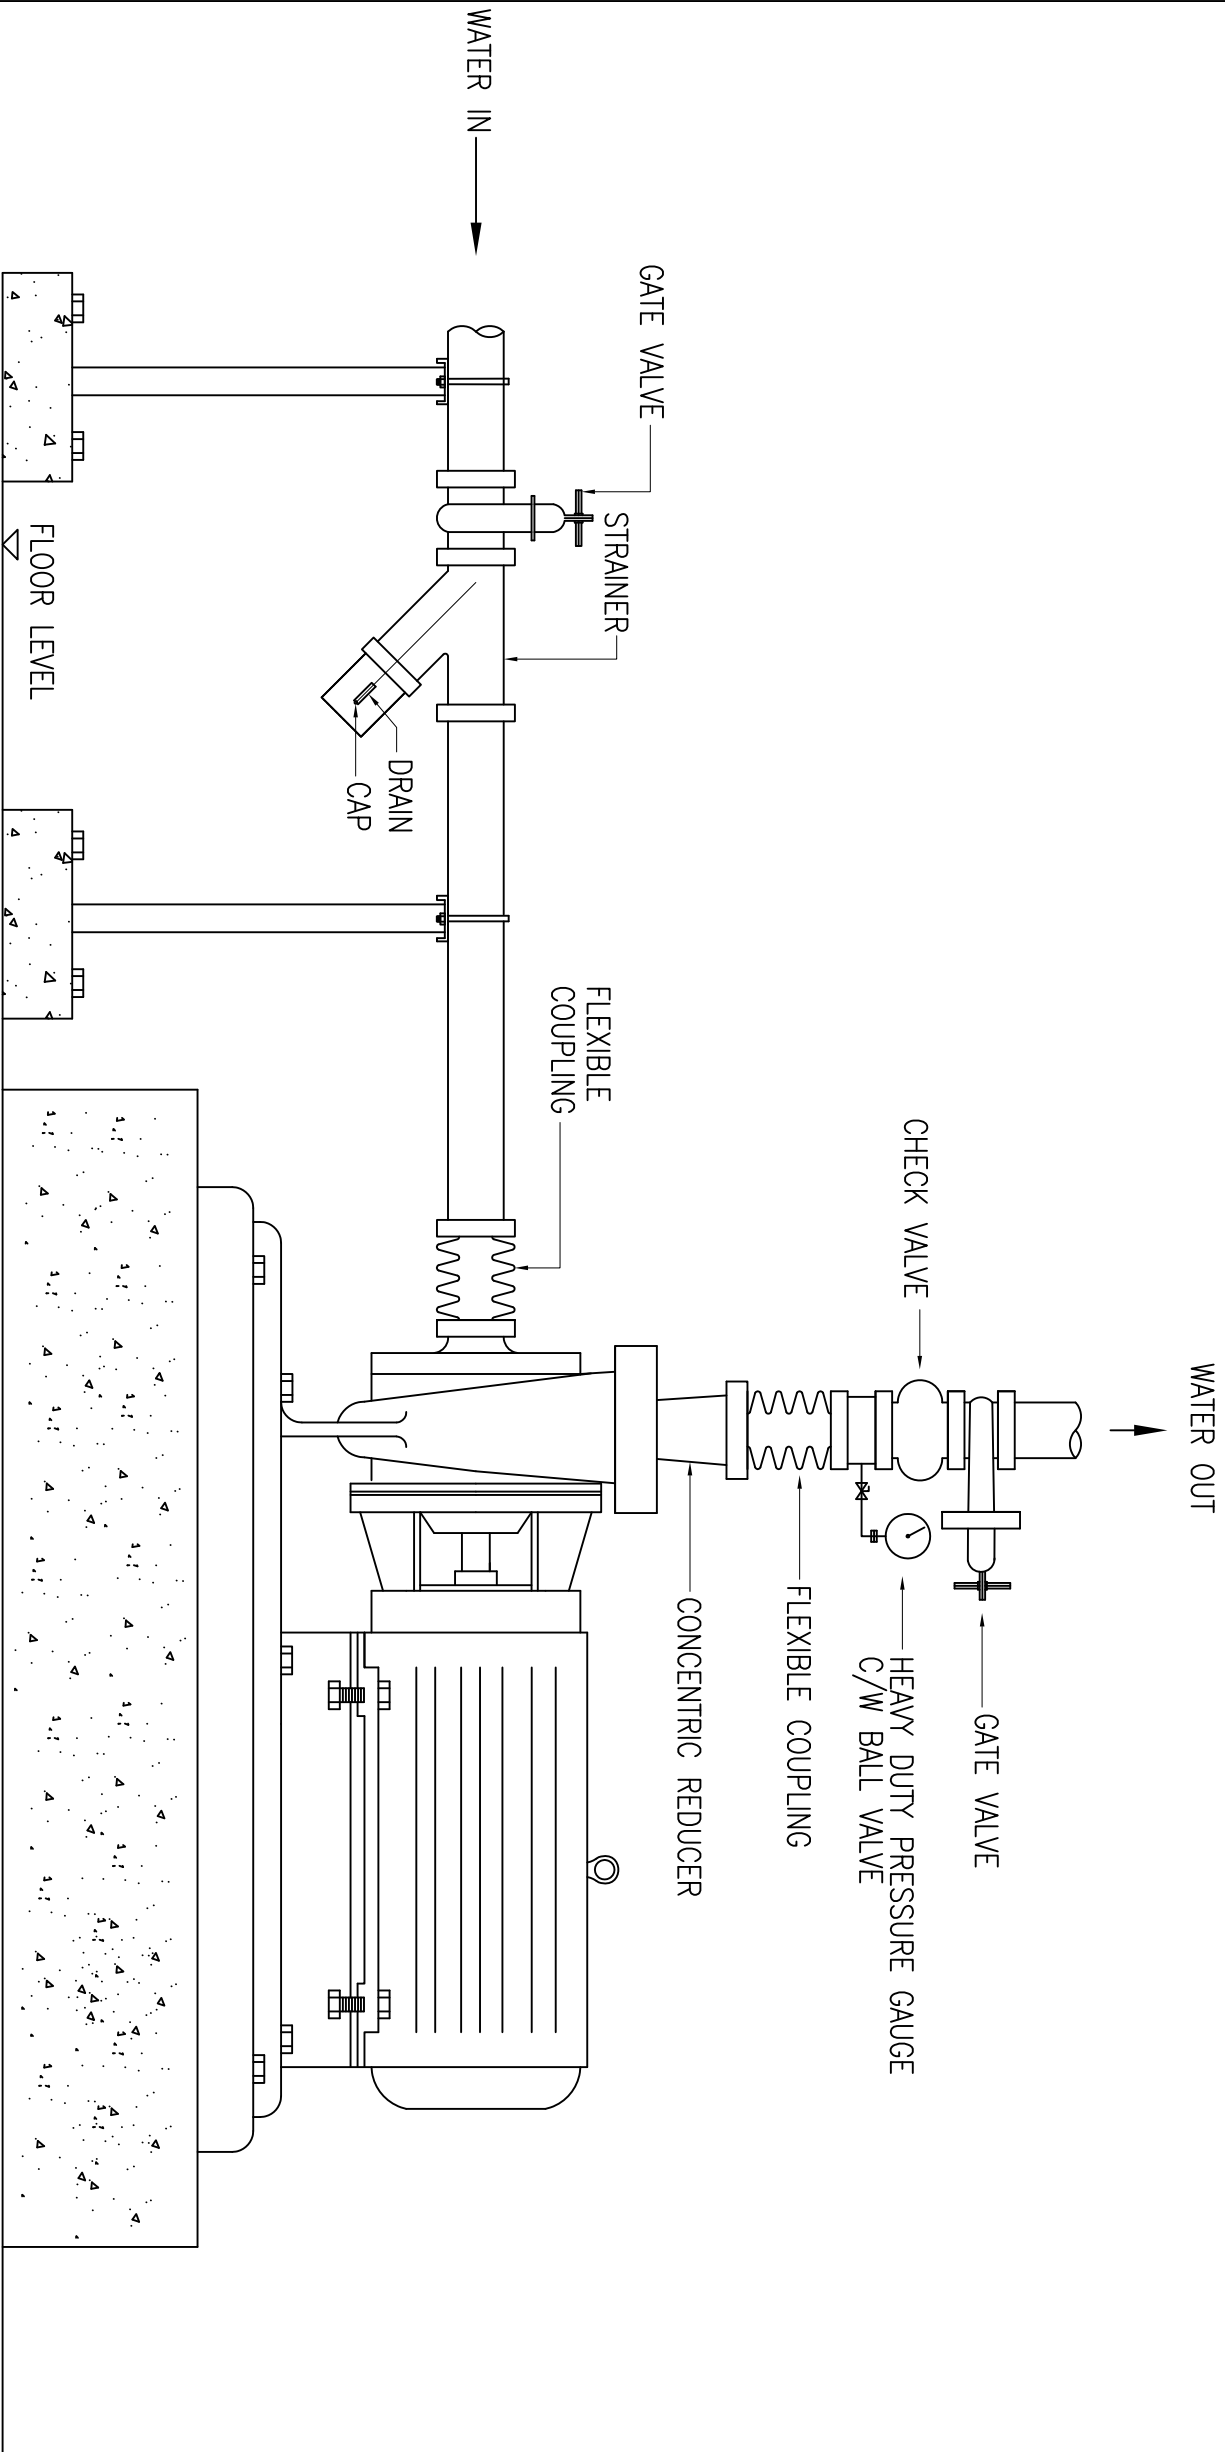

TYPICAL VALVES ARRANGEMENT FOR END SUCTION PUMP




JASA KEPADA RAKYAT

CAWANGAN KEJURUTERAAN MEKANIKAL
Ibu Pejabat JKR Malaysia

FIRE FIGHTING SYSTEM

TYPICAL VALVE ARRANGEMENT FOR
END SUCTION PUMP

DATE	SCALE
2017	NTS
DRAWING NUMBER	
CKM/STD/FF/PUMP/REV/2017/06	

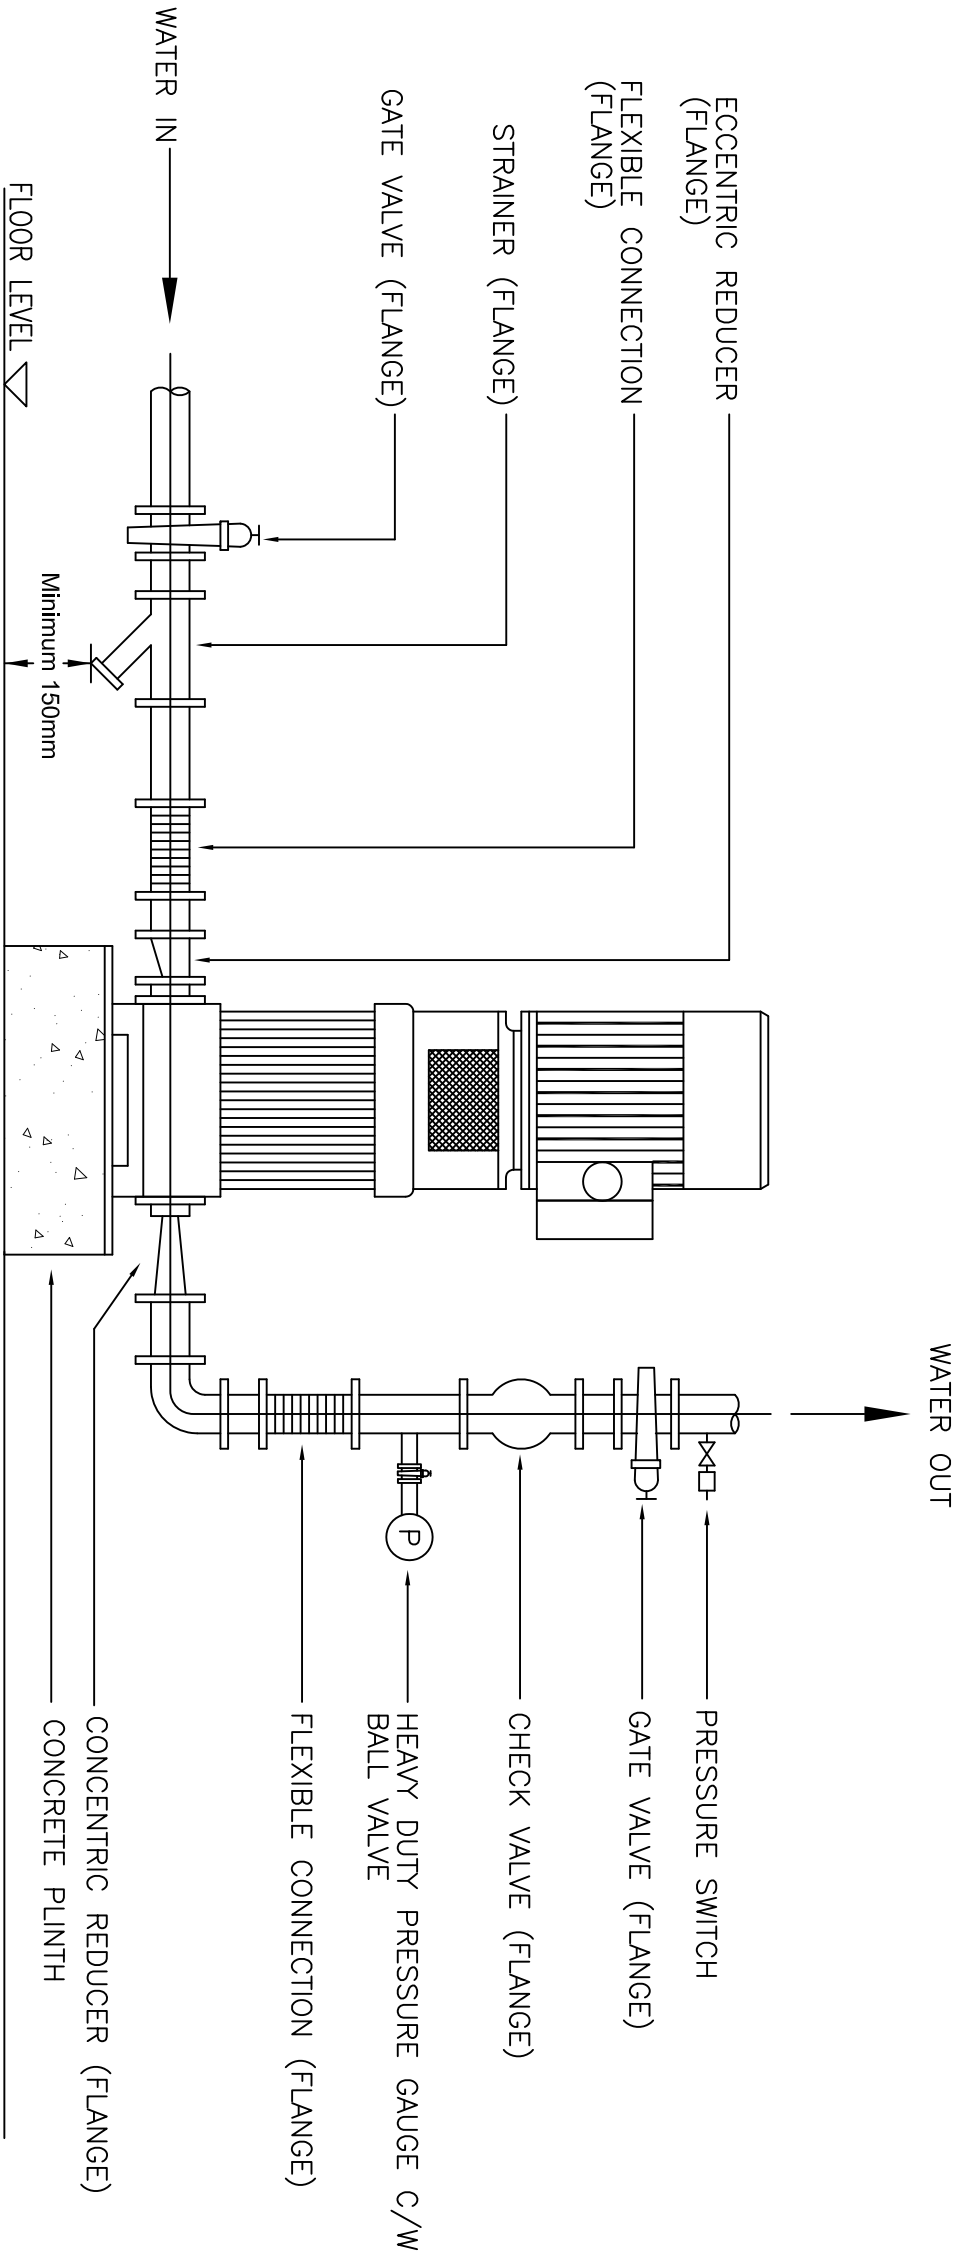

TYPICAL VALVES ARRANGEMENT FOR VERTICAL IN - LINE PUMP




JASA KEPADA RAKYAT

CAWANGAN KEJURUTERAAN MEKANIKAL
Ibu Pejabat JKR Malaysia

FIRE FIGHTING SYSTEM

TYPICAL VALVE ARRANGEMENT FOR
VERTICAL IN-LINE PUMP

DATE	2017	SCALE	NTS
DRAWING NUMBER			
CKM/STD/FPUMP/REV/2017/07			

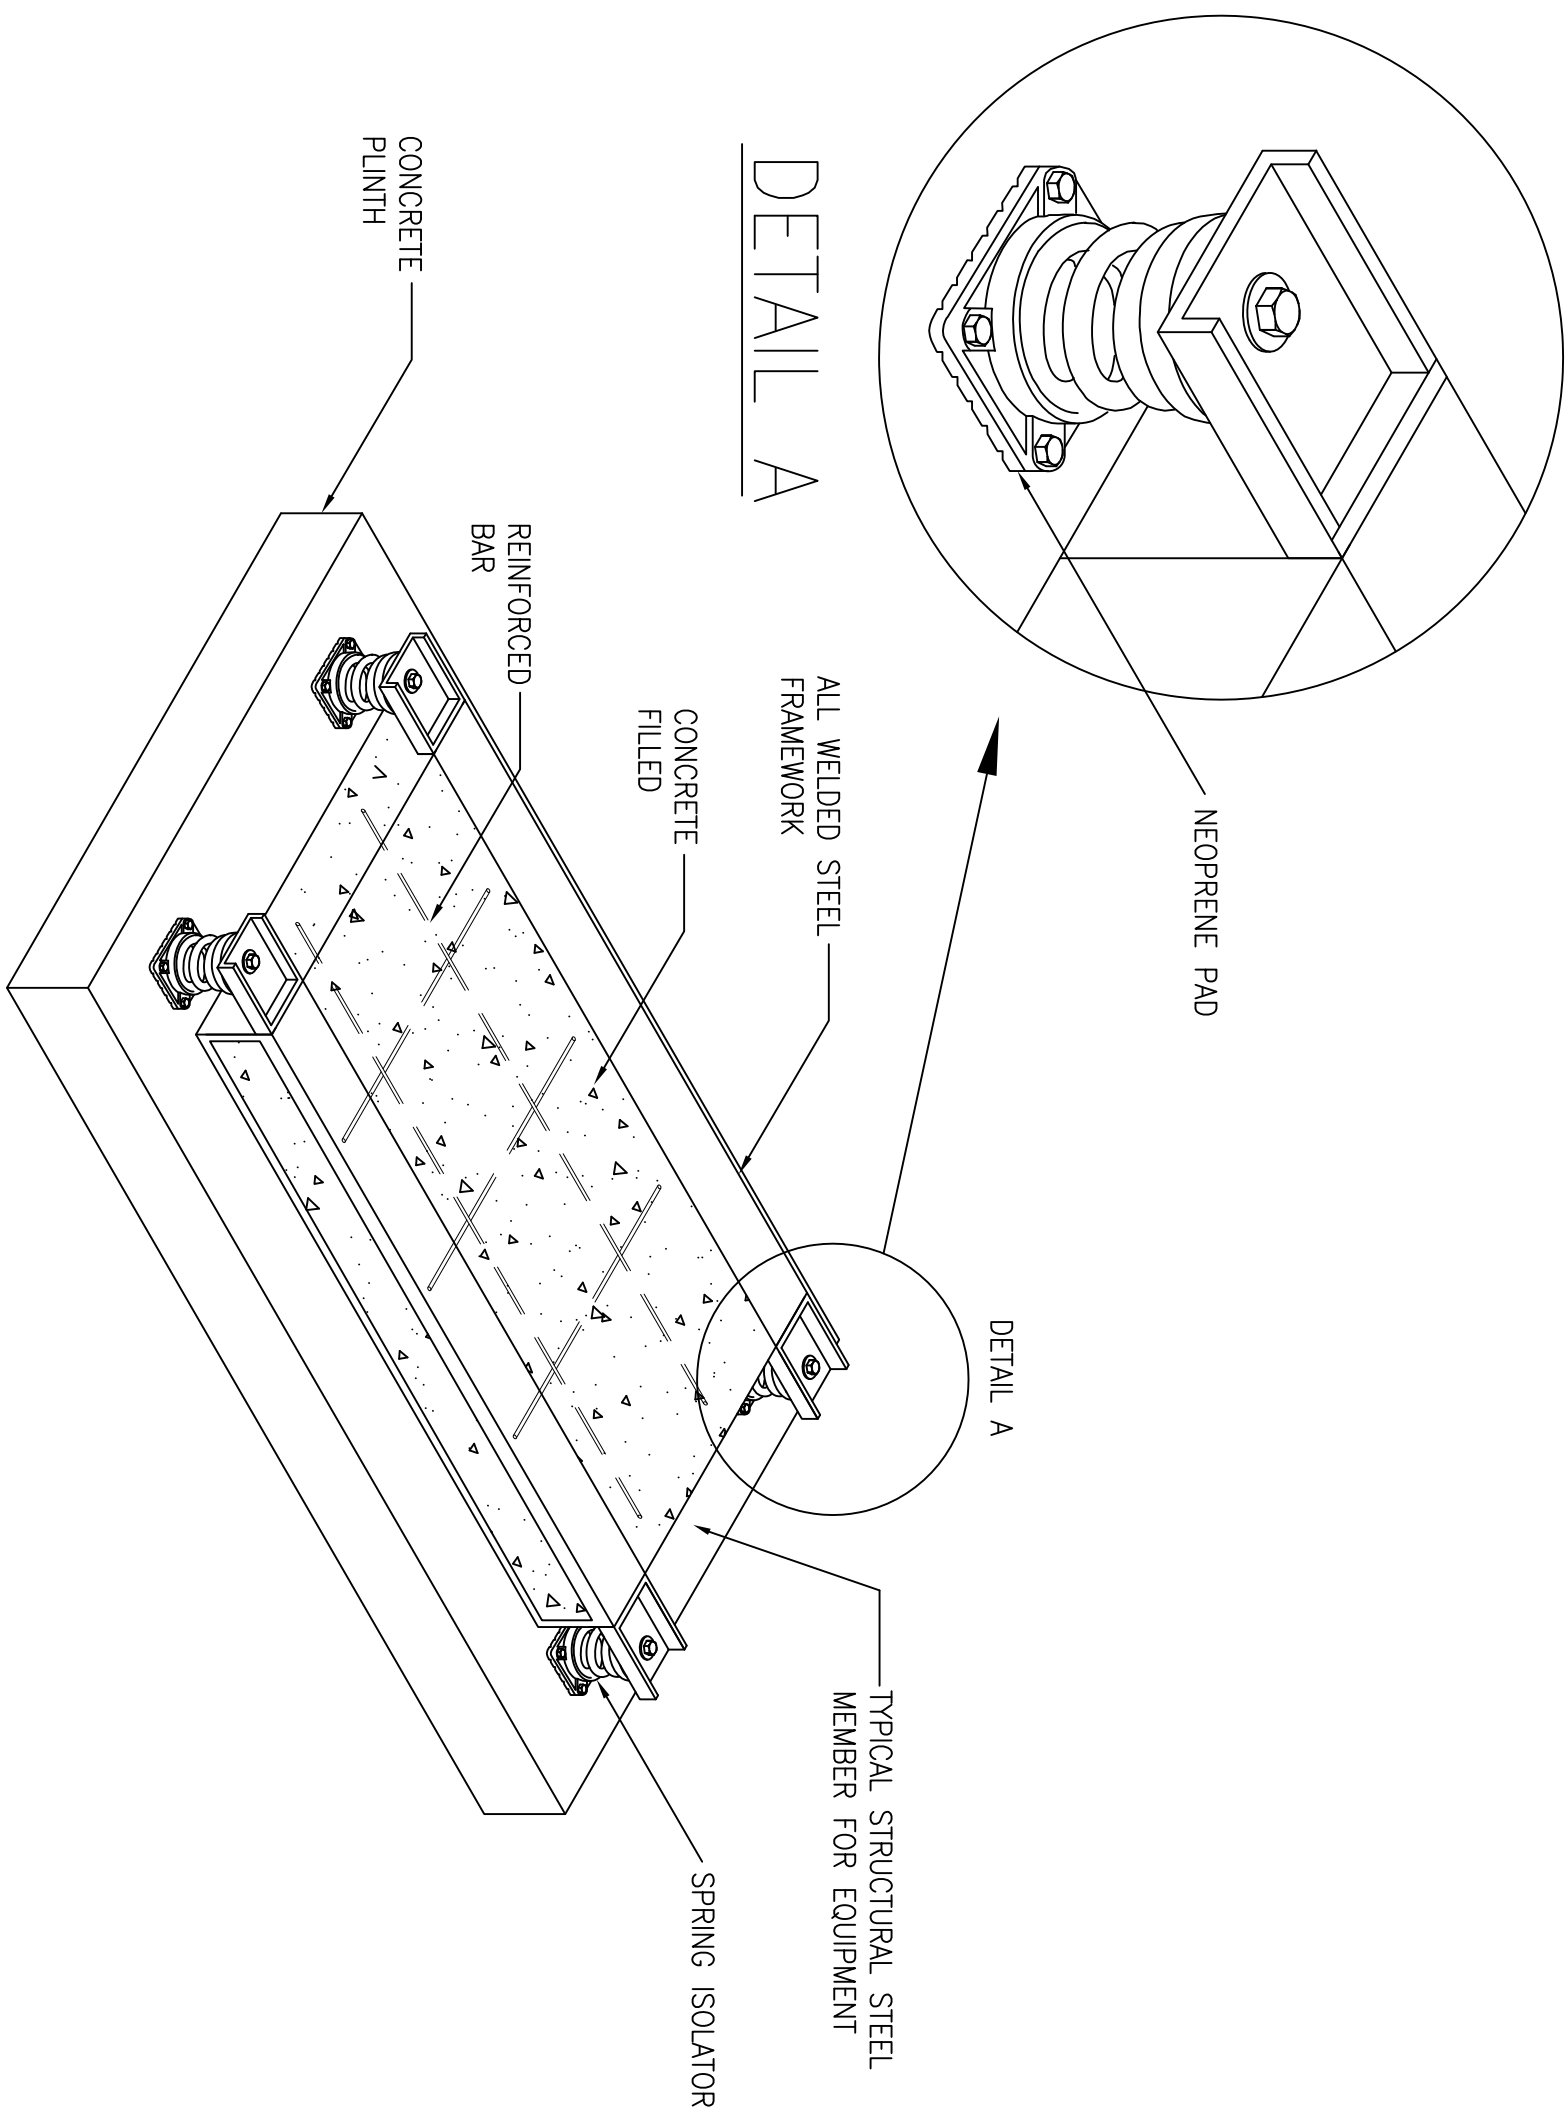

DETAIL OF PUMP AND MOTOR INERTIA BLOCK FOR SPRINKLER AND WET RISER



JASA KEPADA RAKYAT


CAWANGAN KEJURUTERAAN MEKANIKAL
Ibu Pejabat JKR Malaysia

FIRE FIGHTING SYSTEM

DETAIL OF PUMP AND MOTOR INERTIA BLOCK
FOR SPRINKLER AND WET RISER

DATE	SCALE
2017	NTS
DRAWING NUMBER	
CKM/STD/FP/UMP/REV/2017/08	

- NOTES:
- 1) INERTIA BLOCK SIZING, SPRING SELECTIONS AND INSTALLATION SHALL BE MAKE IN ACCORDANCE WITH THE SPECIFICATIONS AND SCHEDULE OF INSTALLATION EQUIPMENT.
 - 2) INERTIA BLOCK SHALL BE SIZED (IN PLAN) TO SUPPORT THE WEIGHT OF PUMP AND PIPEWORK UP TO AND INCLUDING THE PIPE ELBOWS.

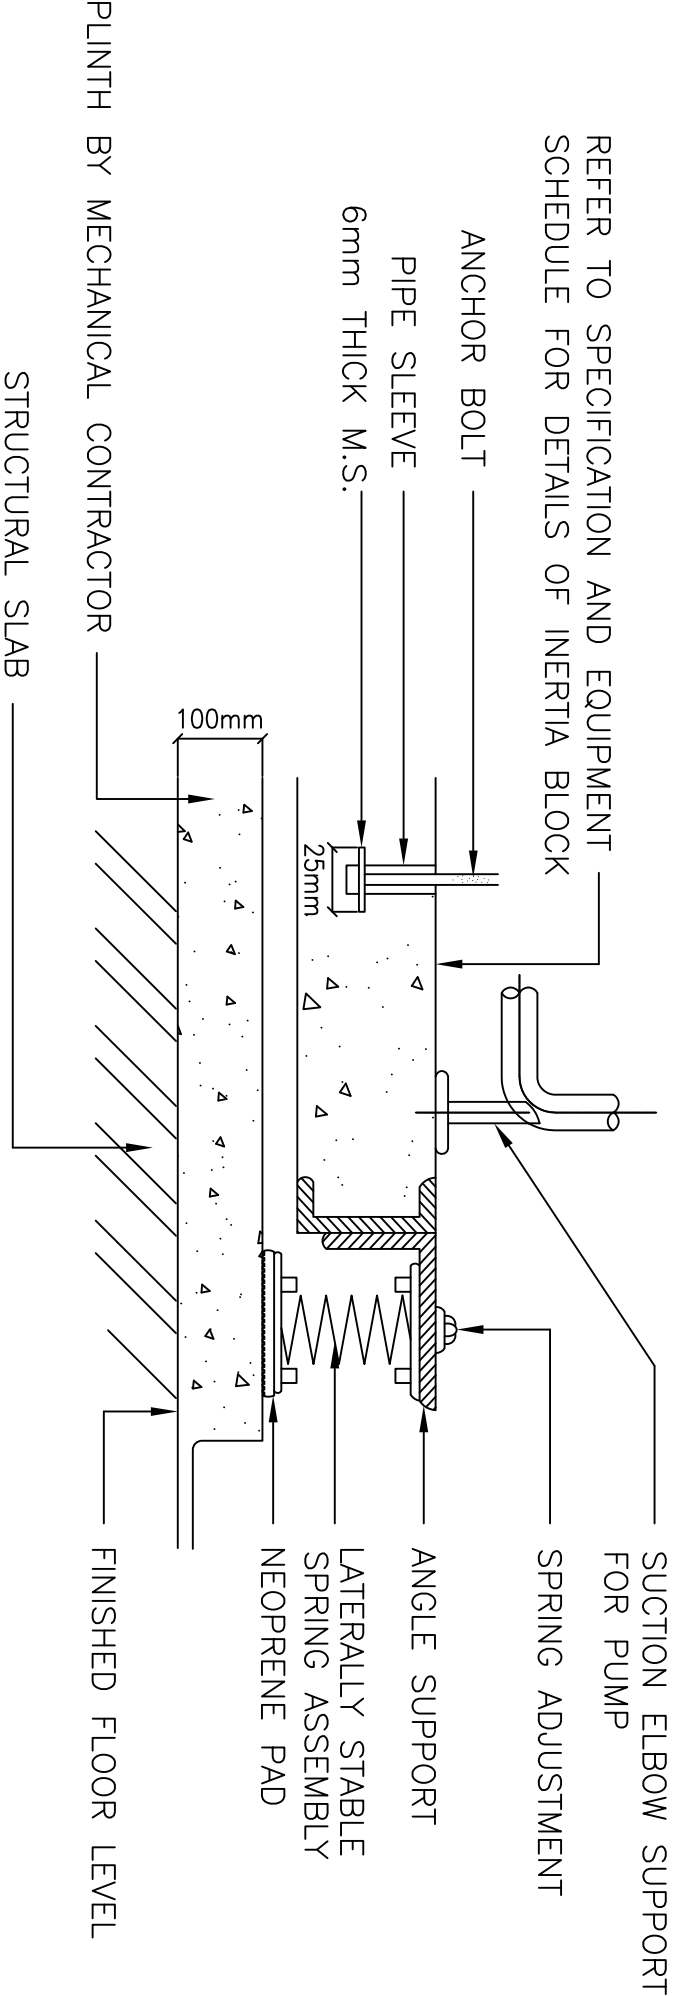

DETAIL OF PLINTH AND INERTIA BLOCK ANTI-VIBRATION MOUNTING FOR PUMP INSTALLATION FOR SPRINKLER AND WET RISER




JASA KEPADA RAKYAT

CAWANGAN KEJURUTERAAN MEKANIKAL
Ibu Pejabat JKR Malaysia

FIRE FIGHTING SYSTEM


DETAIL OF PLINTH AND INERTIA BLOCK FOR PUMP
INSTALLATION FOR SPRINKLER AND WET RISER

DATE	SCALE
2017	NTS
DRAWING NUMBER	
CKM/STD/FF/PUMP/REV/2017/09	

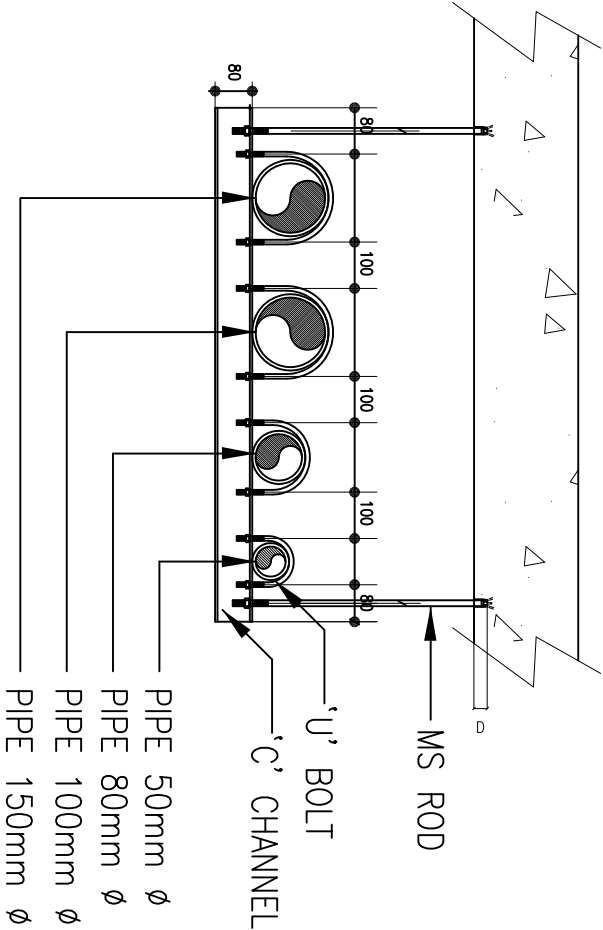


ANCHORING					
PIPE SIZES (Diameter)	ROD SIZE	ANCHOR SIZE	HOLE DIAMETER	ANCHOR LENGTH	HOLE DEPTH (D)
20mm - 40mm	6 mm	10 mm	10 mm	25 mm	25 mm
50mm - 150mm	9 mm	13 mm	13 mm	40 mm	40 mm

TYPICAL PIPE ARRANGEMENT AND SUPPORT

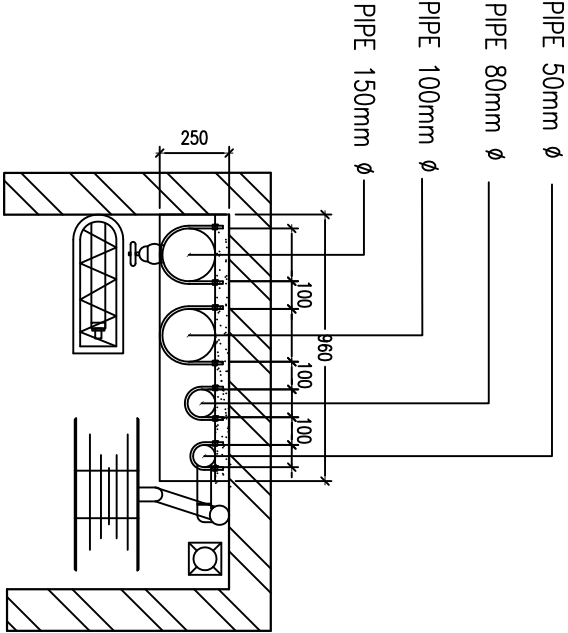

PLAN VIEW

TYPICAL ARRANGEMENT PIPE IN RISER FOR FIRE FIGTHING SYSTEM

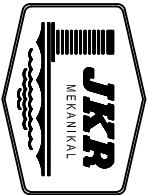


CAWANGAN KEJURUTERAAN MEKANIKAL
Ibu Pejabat JKR Malaysia


FIRE FIGHTING SYSTEM

TYPICAL ARRANGEMENT PIPE IN RISER


DATE	2017	SCALE	NTS
DRAWING NUMBER			
CKM/STD/FF/PIPE/REV/2017/01			

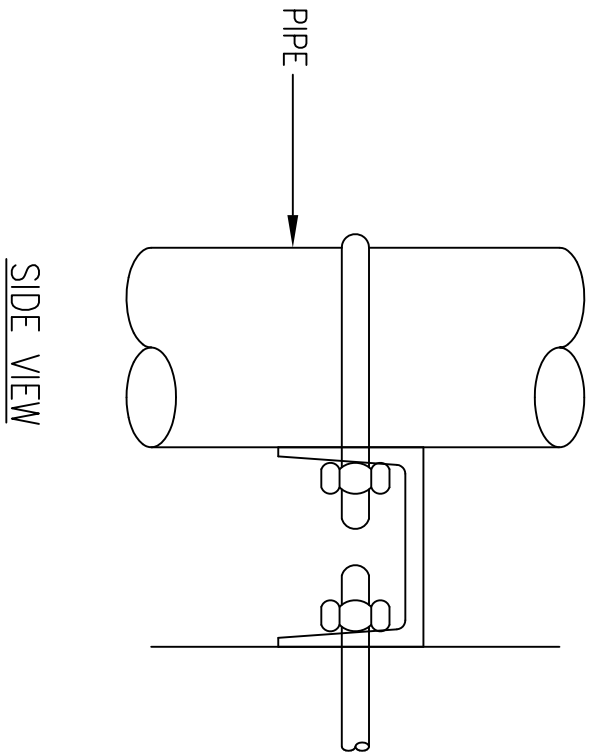

FRONT VIEW

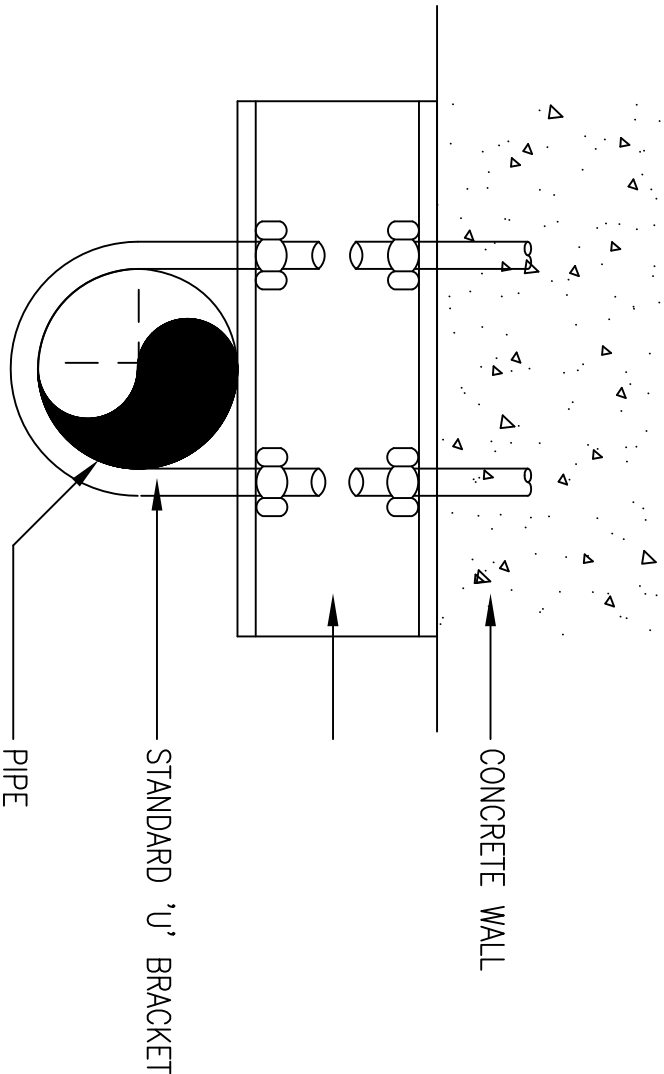

TYPICAL BRACKETS FOR VERTICAL PIPES AT WALL

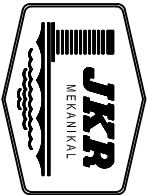


CAWANGAN KEJURUTERAAN MEKANIKAL
Ibu Pejabat JKR Malaysia


FIRE FIGHTING SYSTEM

TYPICAL BRACKETS FOR VERTICAL PIPES AT WALL


DATE	2017	SCALE	NTS
DRAWING NUMBER			
CKM/STD/FF/PIPE/REV/2017/02			

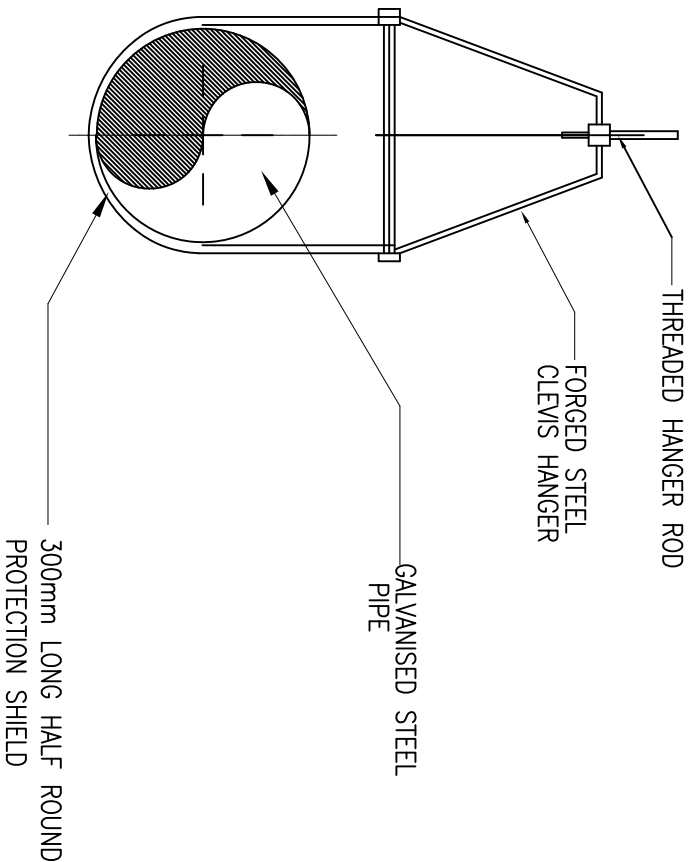

PIPE HANGER (SINGLE PIPES) –CLEVIS TYPE
PIPE SIZE 125mm & ABOVE

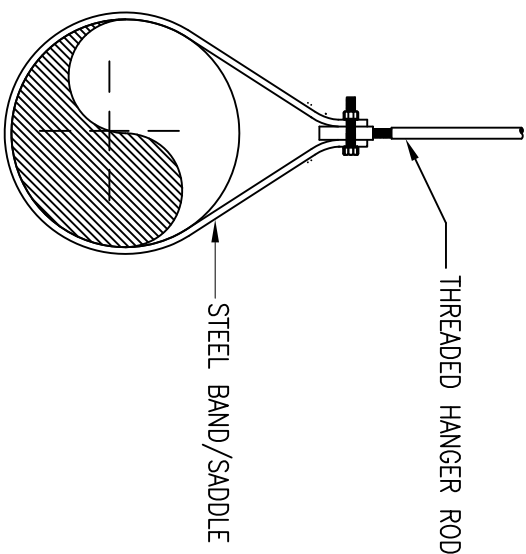

PIPE HANGER (SINGLE PIPE) – BAND TYPE
PIPE SIZE 100mm & BELOW

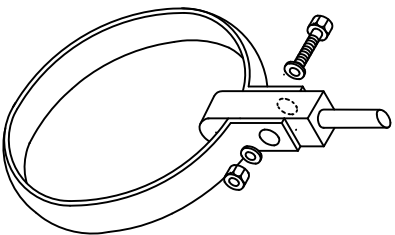

DETAIL TYPES OF PIPE HANGER




JASA KEPADA RAKYAT

CAWANGAN KEJURUTERAAN MEKANIKAL
Ibu Pejabat JKR Malaysia


FIRE FIGHTING SYSTEM

DETAIL TYPES OF PIPE HANGER

DATE	2017	SCALE	NTS
DRAWING NUMBER	CKM/STD/FF/PIPE/REV/2017/03		

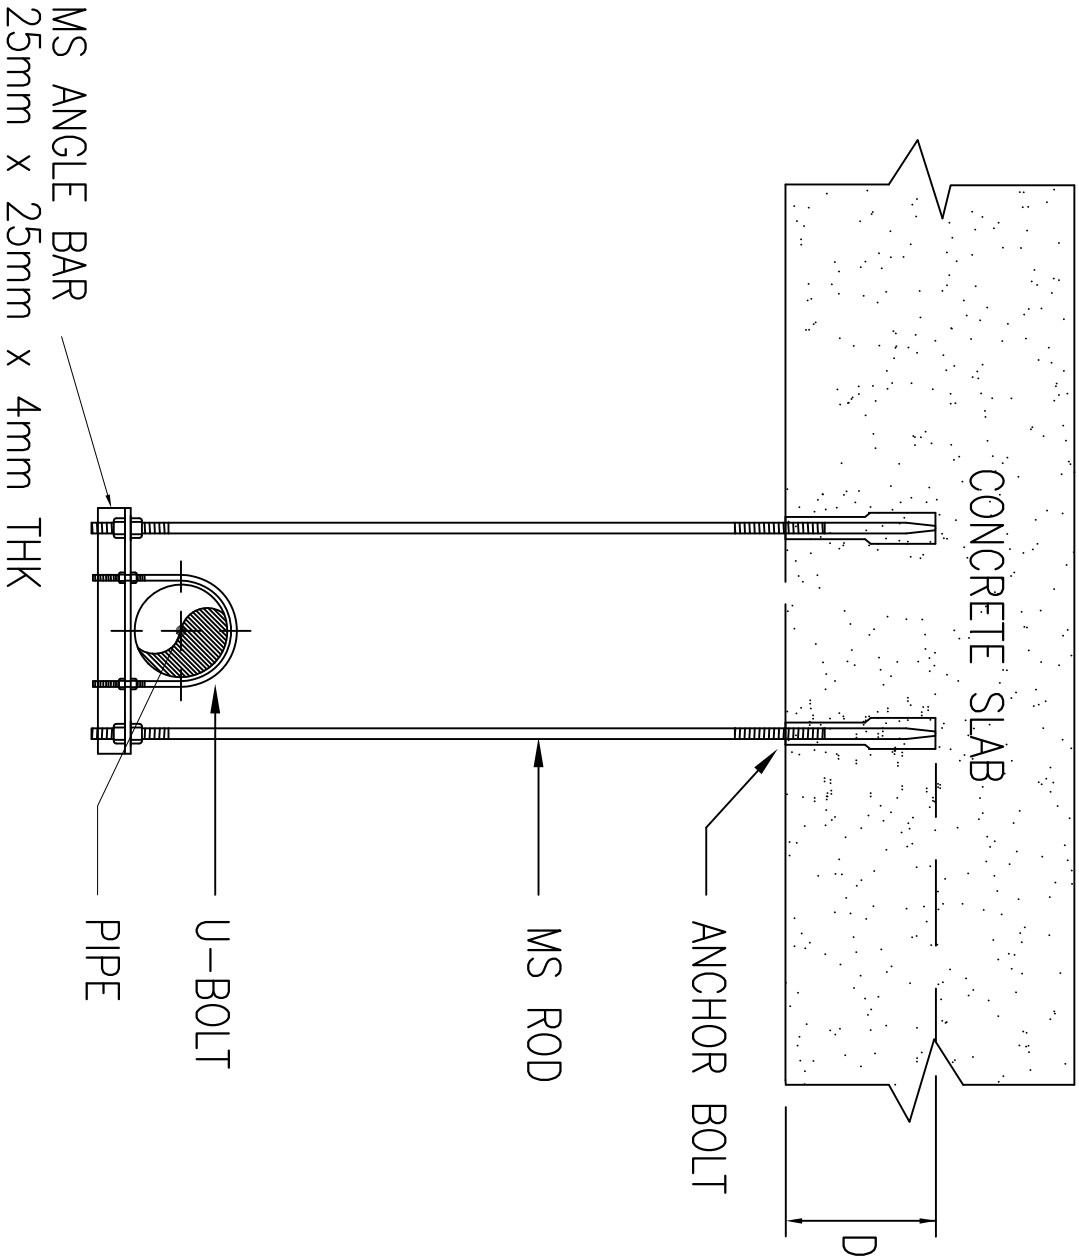

PIPE SIZES (Diameter)	ANCHOR & ROD SIZE	HOLE DIAMETER	HOLE DEPTH (D)
25mm - 50mm	6 mm	8 mm	25 mm
65mm - 150mm	9 mm	12 mm	40 mm

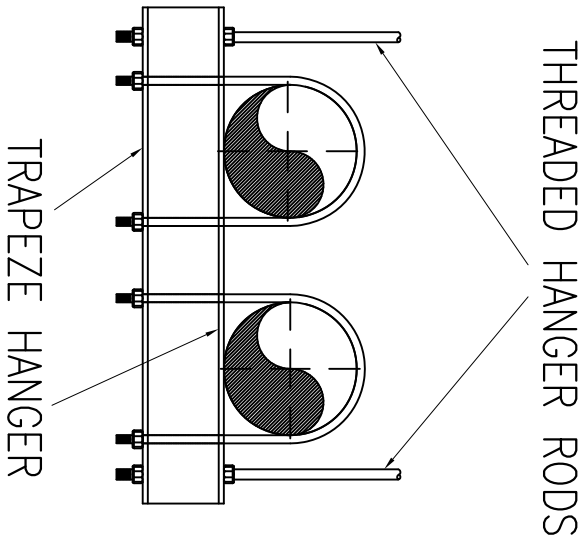

DETAIL OF PIPE HANGERS




JASA KEPADA RAKYAT

CAWANGAN KEJURUTERAAN MEKANIKAL
Ibu Pejabat JKR Malaysia

FIRE FIGHTING SYSTEM


DETAIL OF PIPE HANGERS

DATE	2017	SCALE	NTS
DRAWING NUMBER	CKM/STD/FF/PIPE/REV/2017/04		

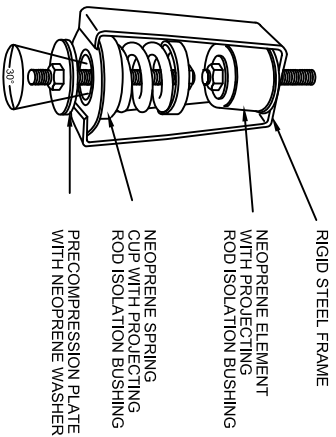


SPRING ISOLATOR SHALL BE INSTALLED AT FIRST THREE HANGER ROD
(REFER TECHNICAL SPECIFICATION)

DETAIL 'A'

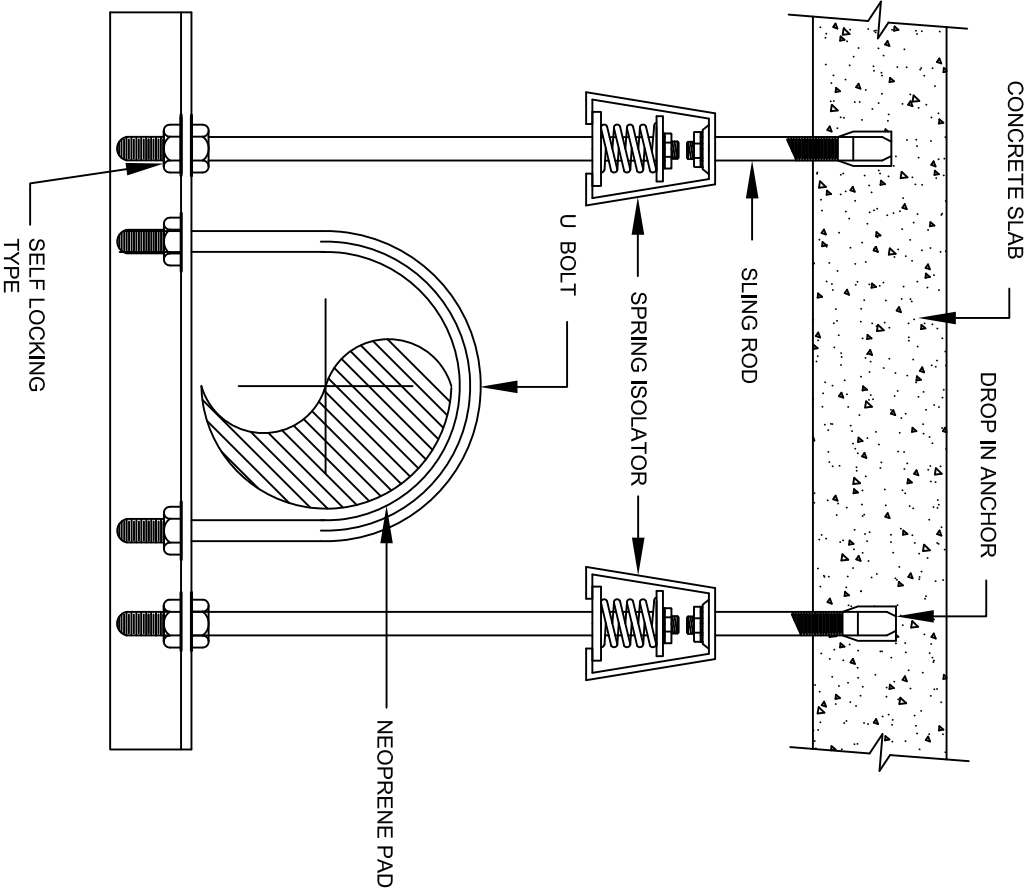


TYPICAL PIPE HANGER
(SINGLE PIPE)

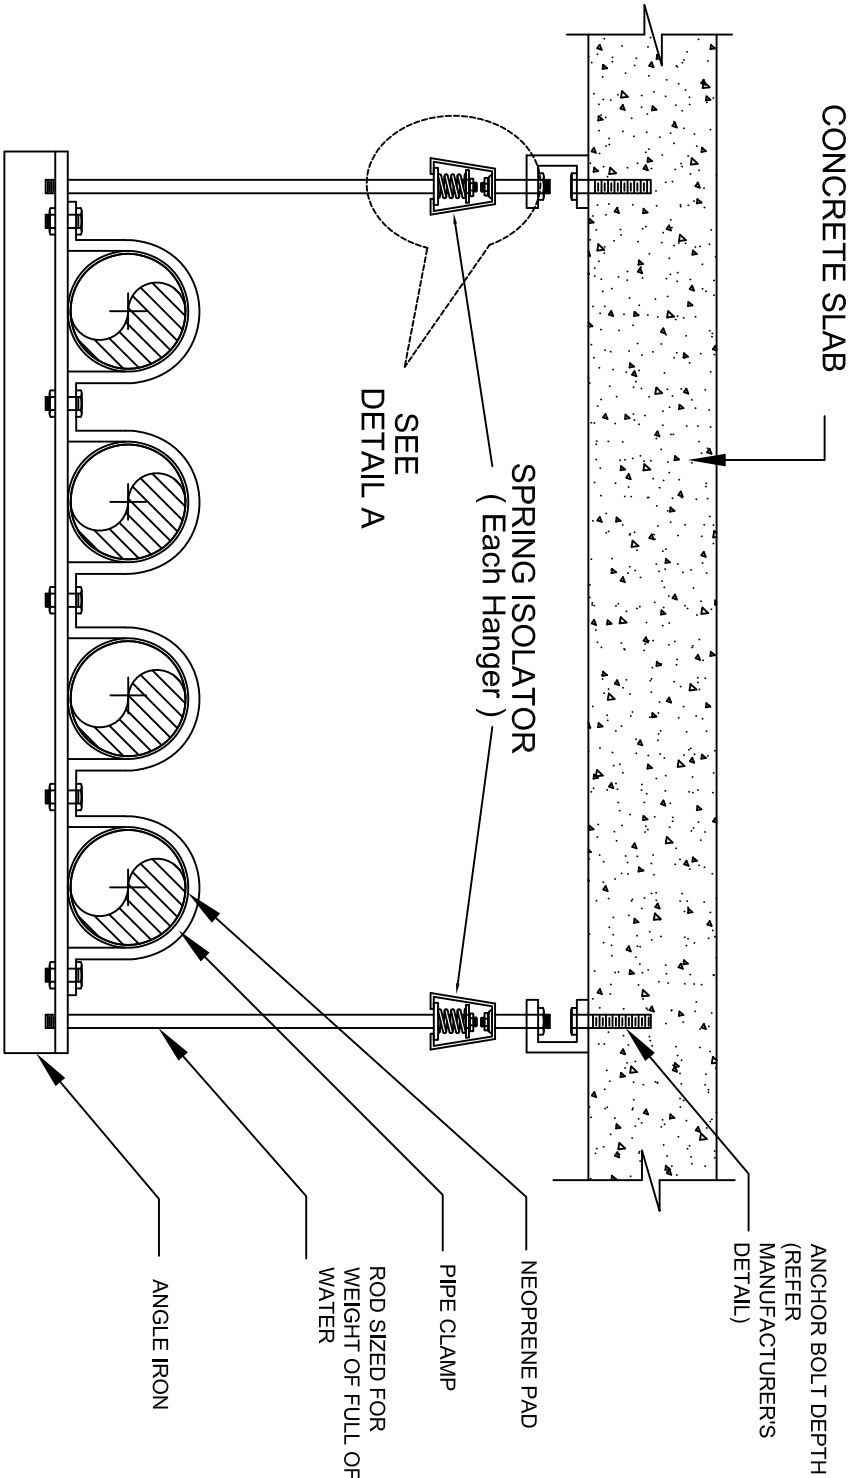

TYPICAL PIPE HANGER
(MORE THAN ONE PIPE)

TYPICAL PIPE HANGER FOR SPRINKLER AND WET RISER AT PLANT ROOM

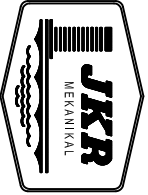


JASA KEPADA RAKYAT

CAWANGAN KEJURUTERAAN MEKANIKAL
Ibu Pejabat JKR Malaysia


FIRE FIGHTING SYSTEM

TYPICAL PIPE HANGERS (PLANT ROOM)
SPRINKLER AND WET RISER

DATE	2017	SCALE	NTS
DRAWING NUMBER	CKM/STD/FF/PIPE/REV/2017/05		

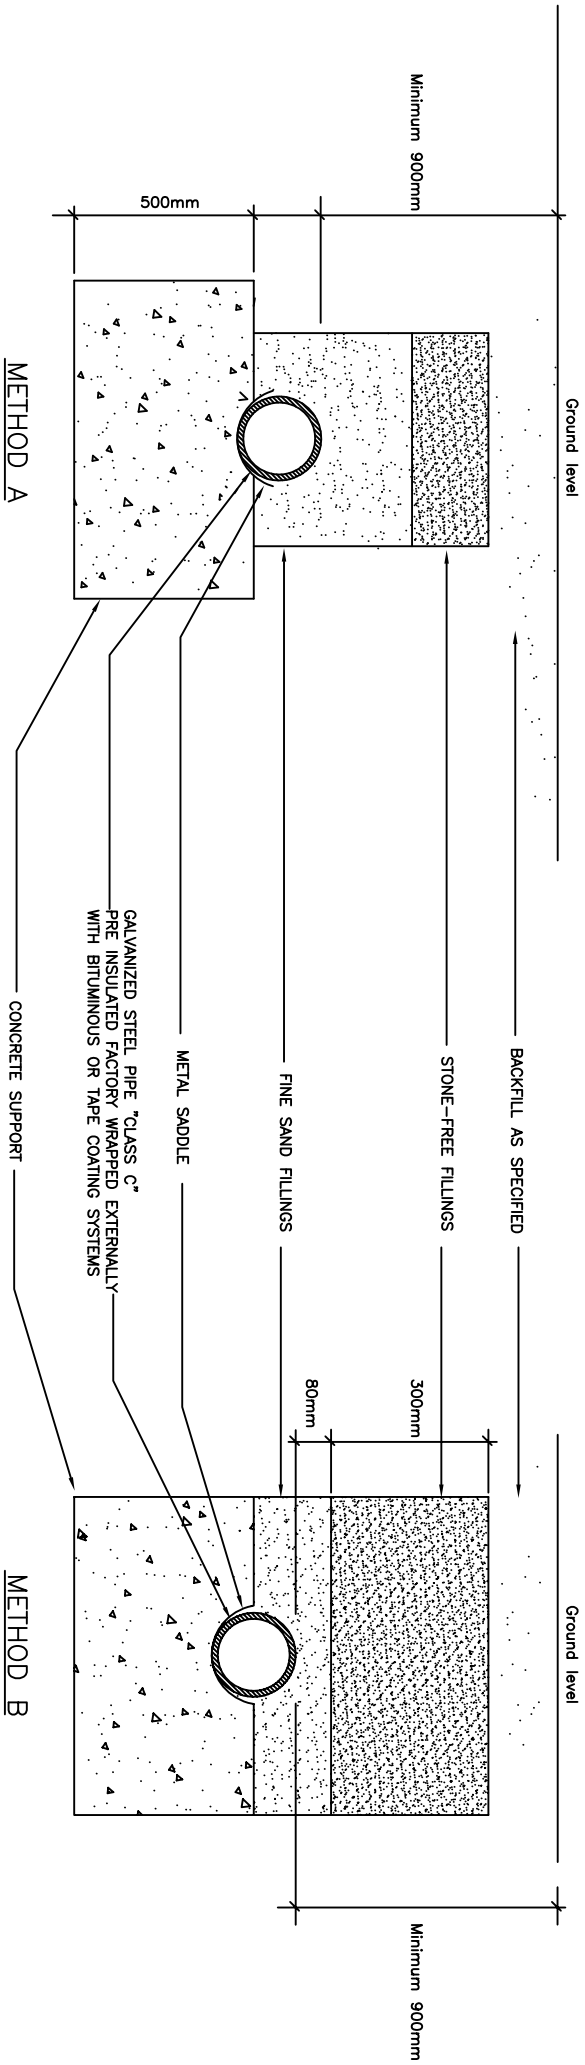

CROSS-SECTION

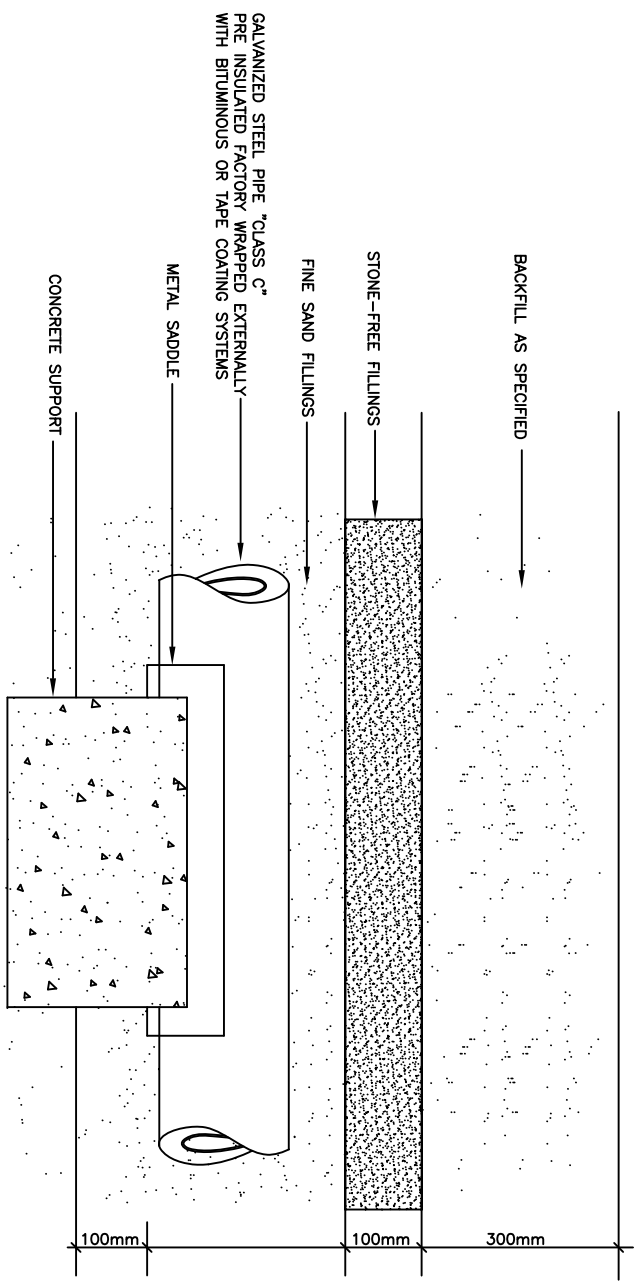

LONGITUDINAL

DETAIL OF UNDERGROUND PIPING INSTALLATION




JASA KEPADA RAKYAT
CAWANGAN KEJURUTERAAN MEKANIKAL
Ibu Pejabat JKR Malaysia


FIRE FIGHTING SYSTEM

DETAIL OF UNDERGROUND PIPING INSTALLATION

DATE	2017	SCALE	NTS
DRAWING NUMBER	CKM/STD/FF/PIPE/REV/2017/06		

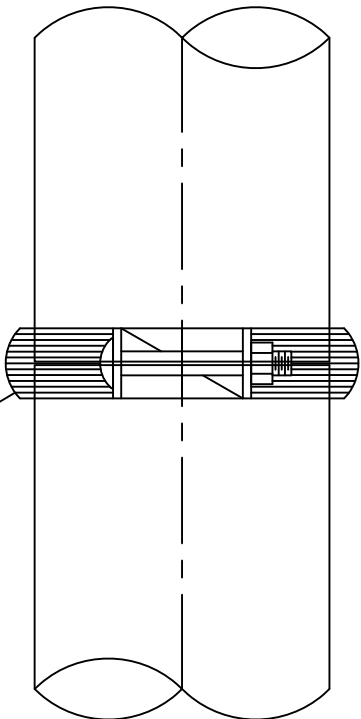


Pipe Jointing for 65 mm Diameter and Above

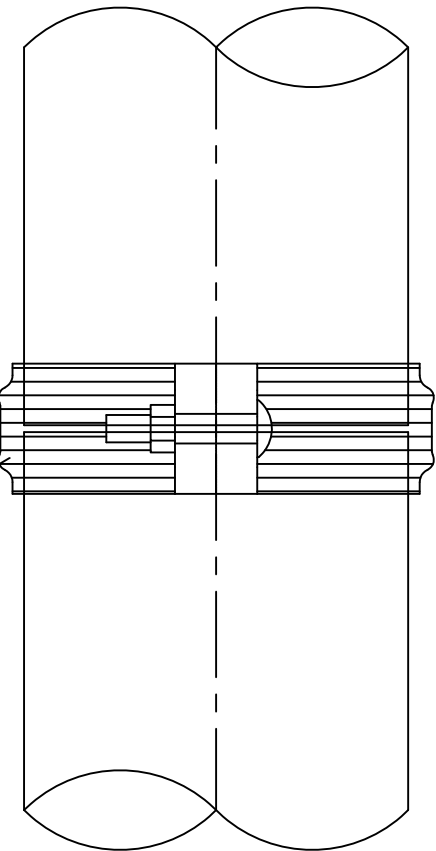

Pipe Jointing for 65 mm Diameter and Above

DETAIL PIPE MECHANICAL JOINT COUPLING FOR SPRINKLER, WET RISER
AND DRY RISER

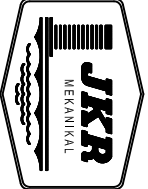

JASA KEPADA RAKYAT


CAWANGAN KEJURUTERAAN MEKANIKAL
Ibu Pejabat JKR Malaysia

FIRE FIGHTING SYSTEM


PIPE MECHANICAL JOINT COUPLING FOR
SPRINKLER, WET RISER AND DRY RISER

DATE	SCALE
2017	NTS

DRAWING NUMBER
CKMSTD/FF/PIPE/REV2017/07

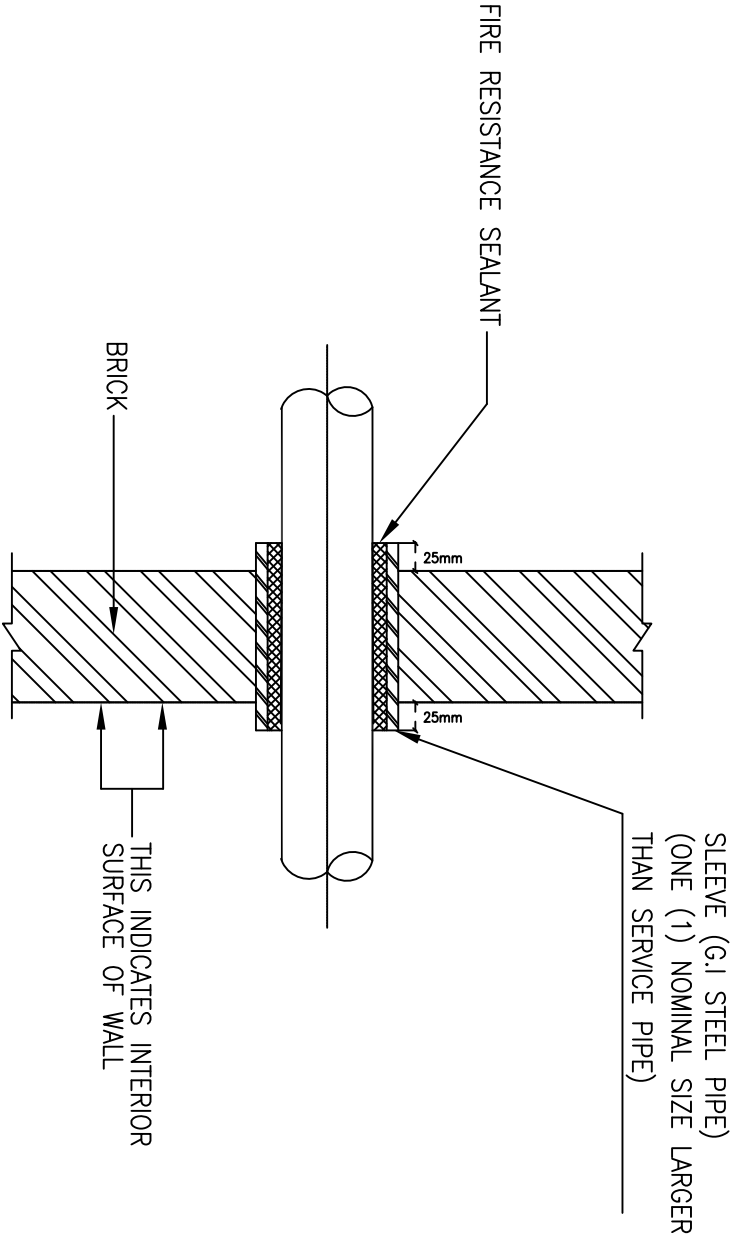


PIPE SLEEVE FOR PIPE THROUGH WALL

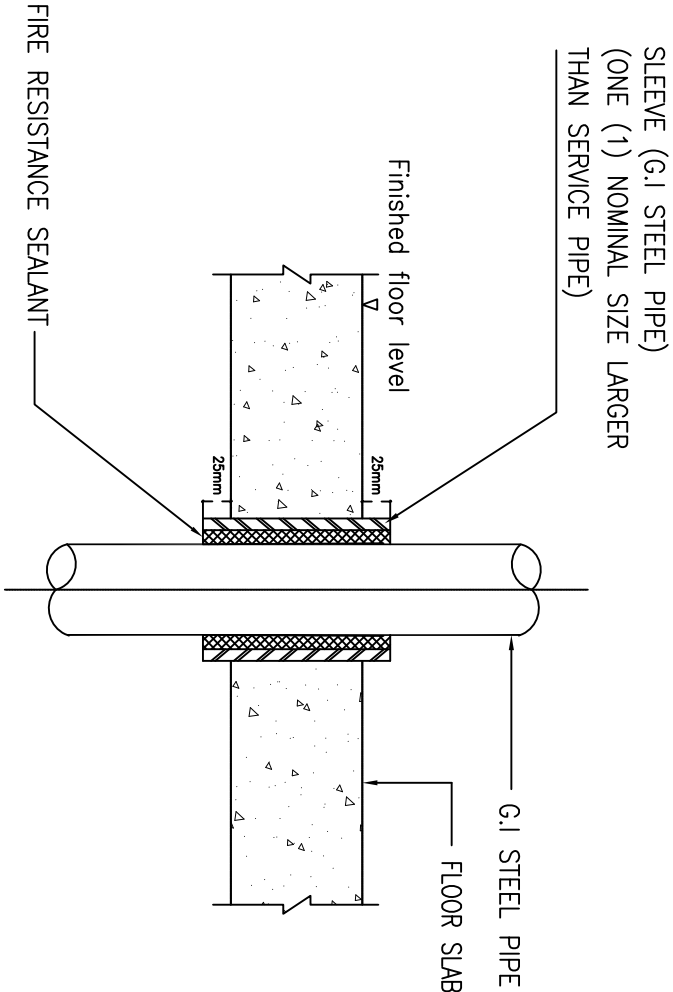


Notes:

1. Normal floor—the sleeves shall end 25mm above finished floor level.
2. Wet floor—the sleeves shall end 50mm above finished floor level.

PIPE SLEEVE FOR PIPE THROUGH FLOOR

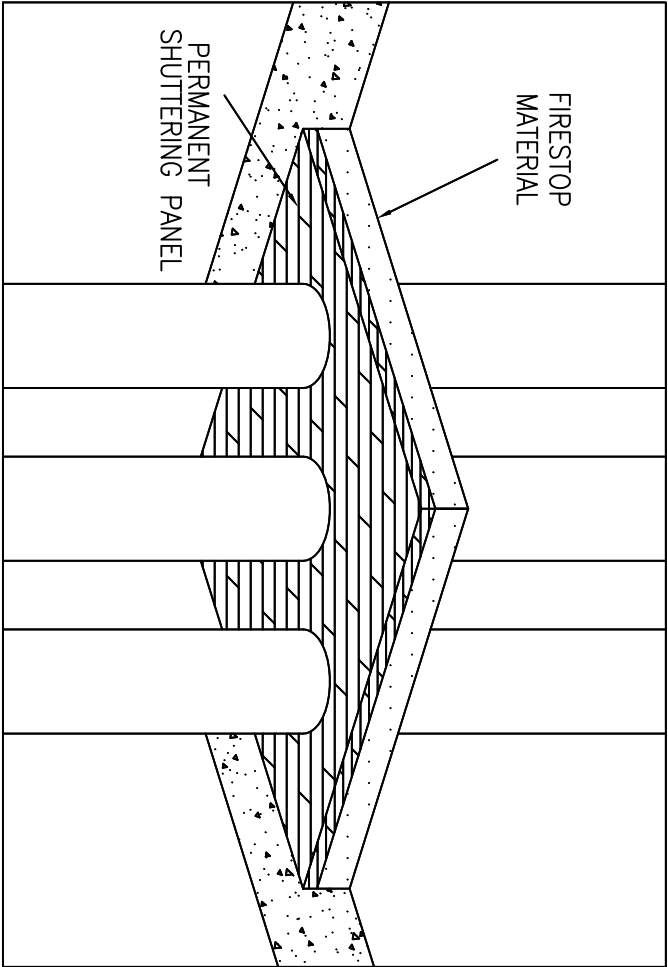


PIPE THROUGH FLOOR WITHOUT SLEEVE

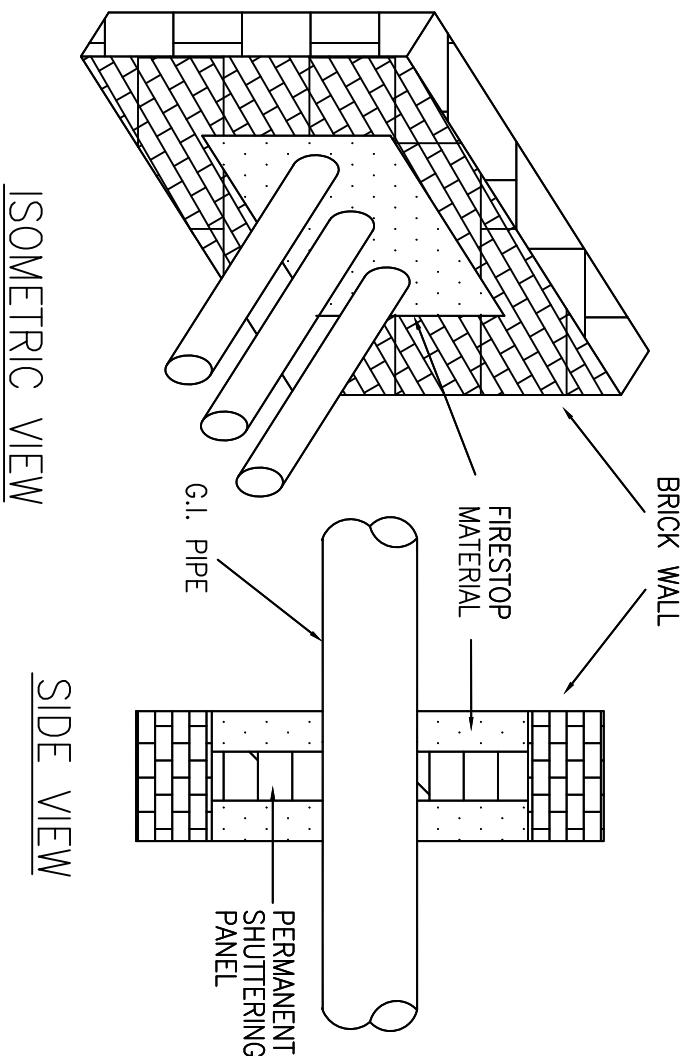

ISOMETRIC VIEW

SIDE VIEW

PIPE THROUGH WALL WITHOUT SLEEVE

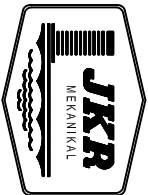


JASA KEPADA RAKYAT

CAWANGAN KEJURUTERAAN MEKANIKAL
Ibu Pejabat JKR Malaysia


FIRE FIGHTING SYSTEM

DETAIL OF PIPES THROUGH WALLS AND FLOORS

DATE	2017	SCALE	NTS
DRAWING NUMBER	CKMSTD/FF/PIPE/REV2017/08		

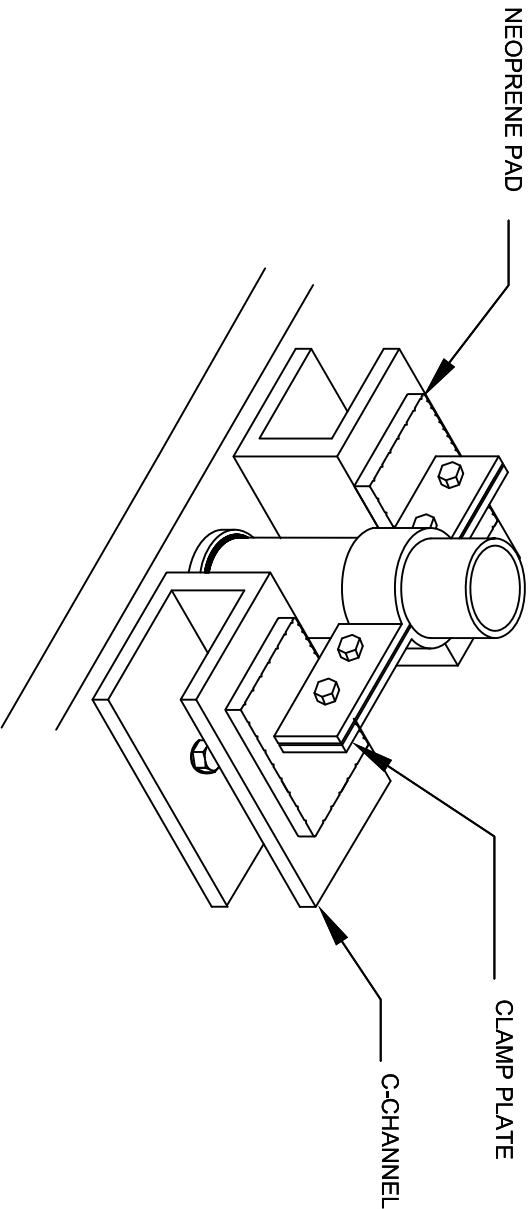

ISOMETRIC VIEW

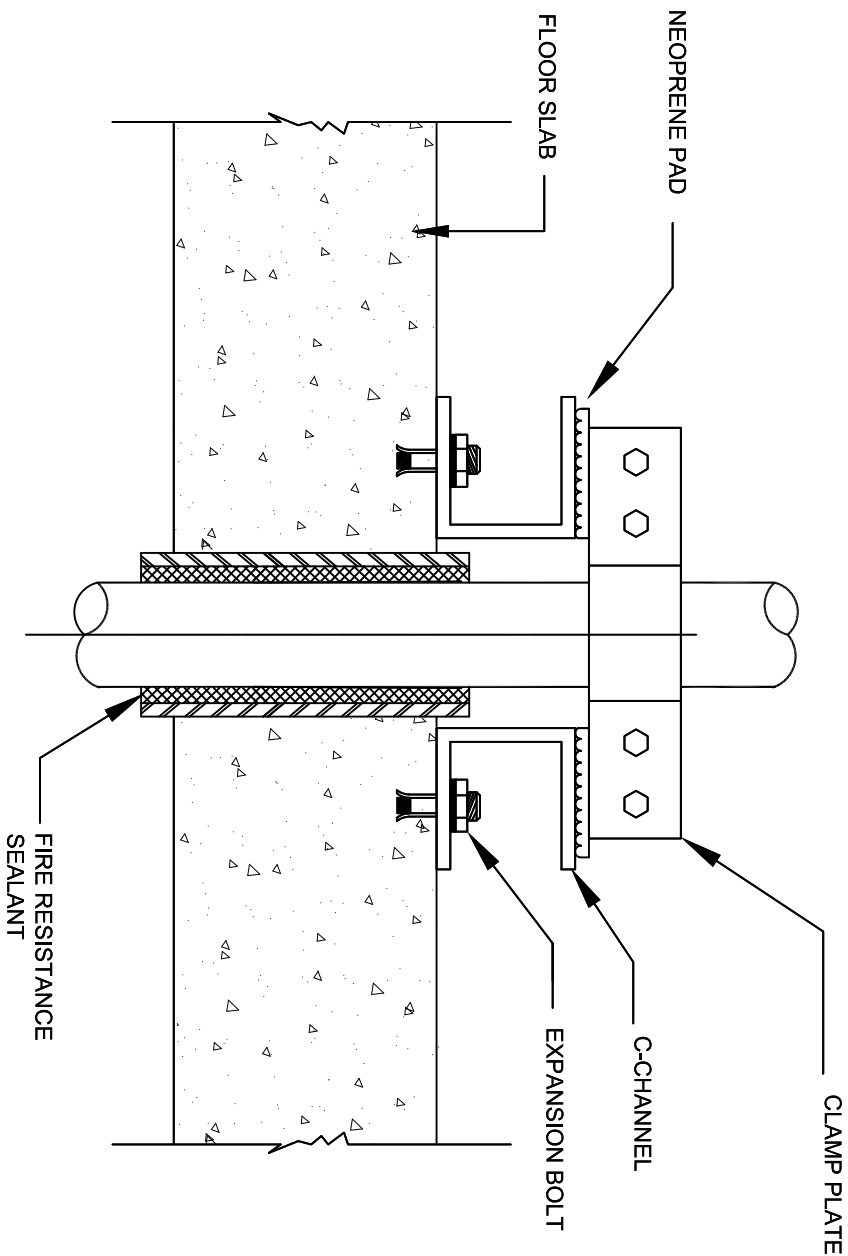

TYPICAL VERTICAL PIPE RISER THROUGH FLOOR SLAB MOUNTING
FOR SPRINKLER AND WET RISER




JASA KEPADA RAKYAT

CAWANGAN KEJURUTERAAN MEKANIKAL
Ibu Pejabat JKR Malaysia

FIRE FIGHTING SYSTEM

TYPICAL VERTICAL PIPE RISER THROUGH
FLOOR SLAB MOUNTING FOR SPRINKLER
AND WET RISER

DATE	SCALE
2017	NTS
DRAWING NUMBER	
CKM/STD/FF/PIPE/REV2017/09	

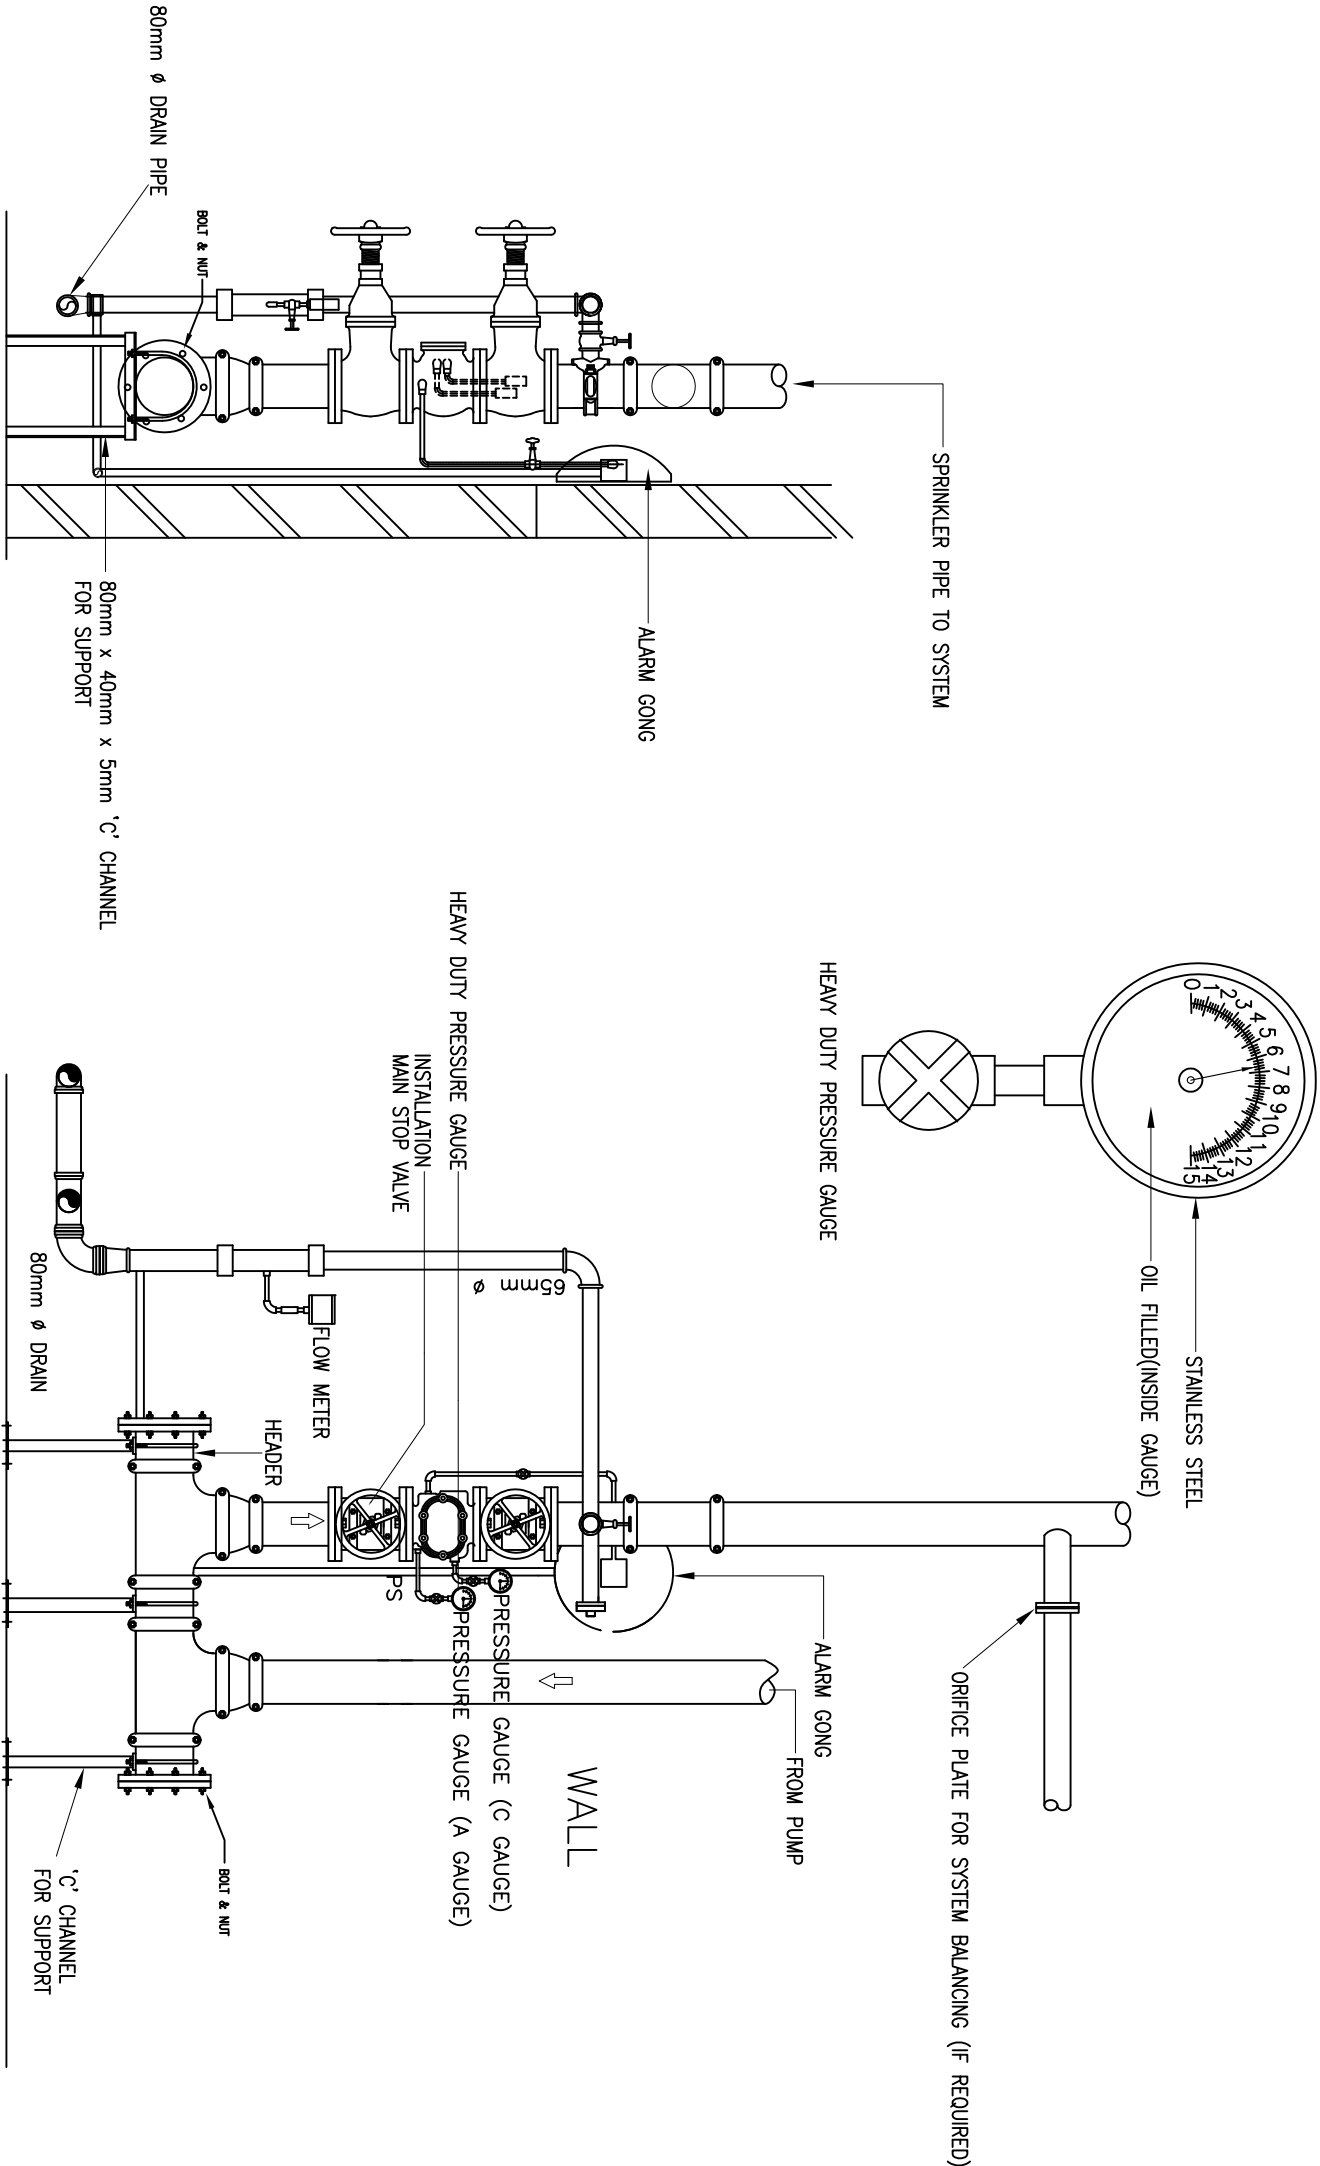

SIDE VIEW

FRONT VIEW

DETAIL SPRINKLER CONTROL VALVE




JASA KEPADA RAKYAT

CAWANGAN KEJURUTERAAN MEKANIKAL
Ibu Pejabat JKR Malaysia


FIRE FIGHTING SYSTEM

DETAIL SPRINKLER CONTROL VALVE


DATE	SCALE
2017	NTS
DRAWING NUMBER	
CKM/STD/FF/SPRINKLER/REV2017/01	

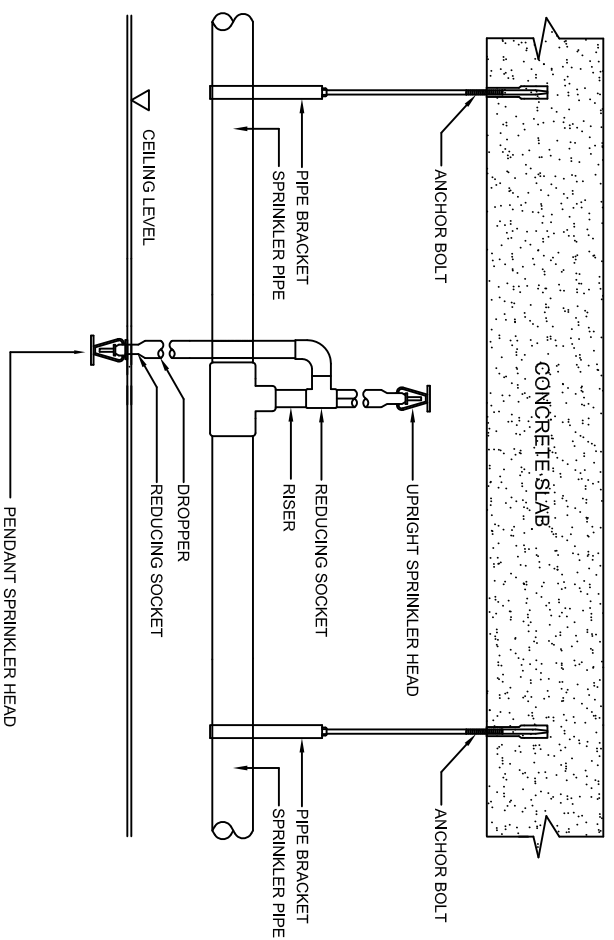


PENDANT AND UPRIGHT SPRINKLER INSTALLATION

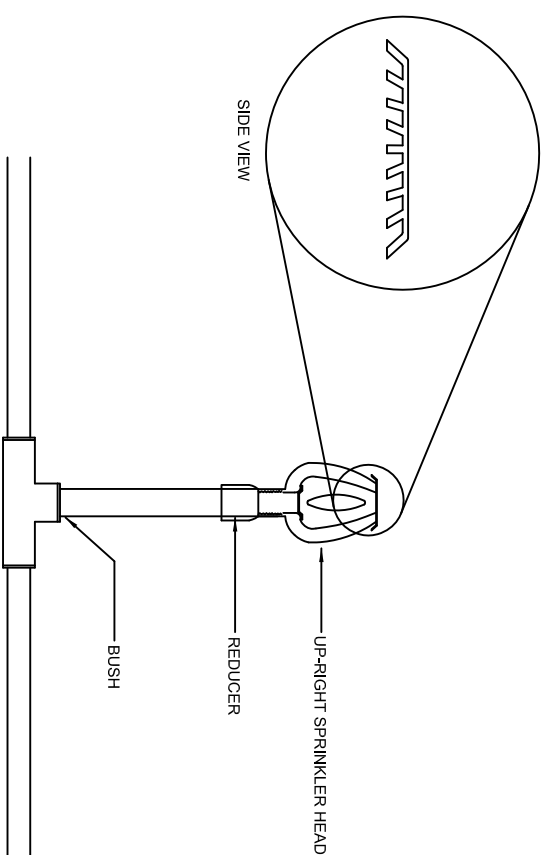

UPRIGHT SPRINKLER HEAD

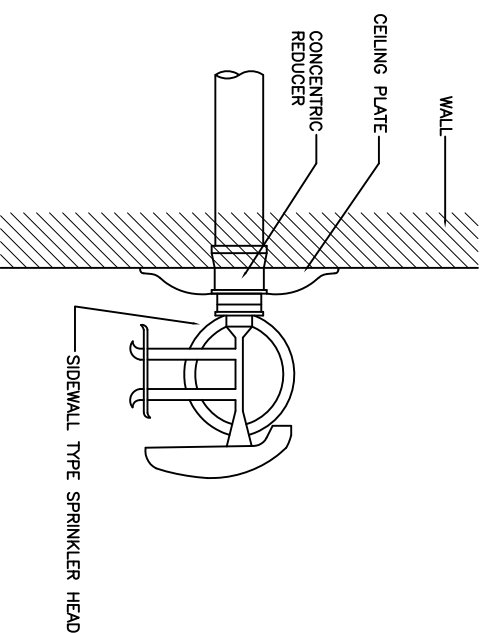


SIDEWALL TYPE SPRINKLER

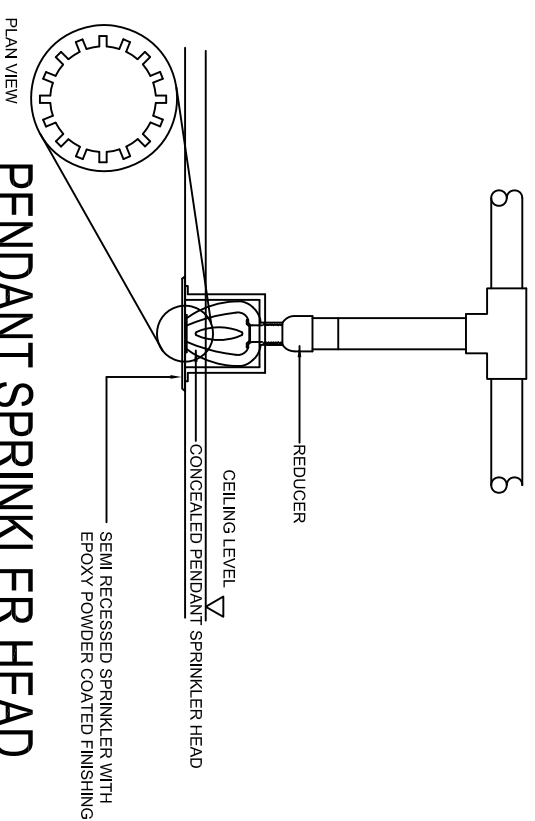


PENDANT SPRINKLER HEAD

DATE 2017 DRAWING NUMBER		SCALE NTS
TYPICAL TYPES OF SPRINKLER AND INSTALLATION		
FIRE FIGHTING SYSTEM		
CAWANGAN KEJURUTERAAN MEKANIKAL Ibu Pejabat JKR Malaysia		
JASA KEPADA RAKYAT 		

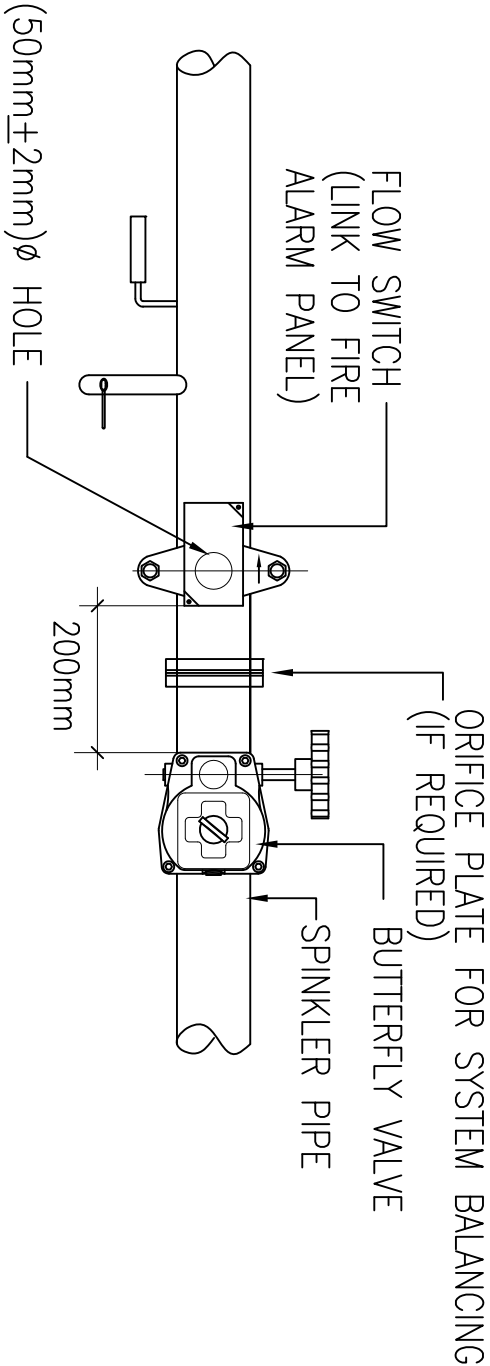

PLAN VIEW

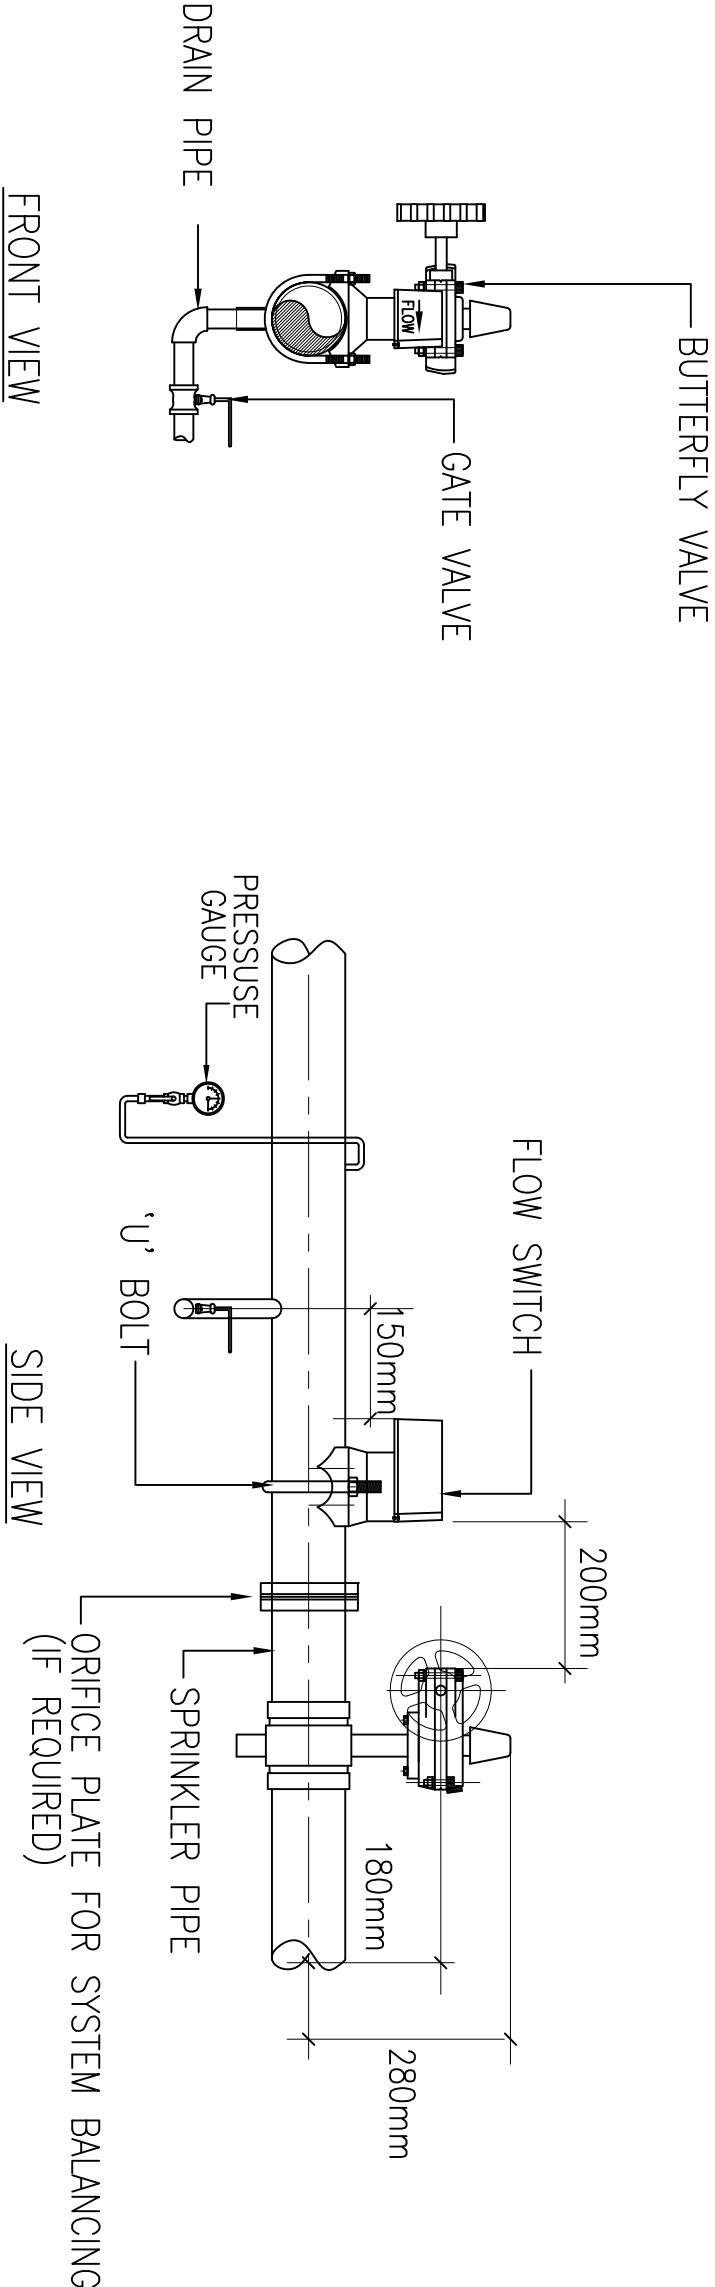

TYPICAL FLOW SWITCH & BUTTERFLY VALVE INSTALLATION (SPRINKLER)





JASA KEPADA RAKYAT

CAWANGAN KEJURUTERAAN MEKANIKAL
Ibu Pejabat JKR Malaysia

FIRE FIGHTING SYSTEM

TYPICAL FLOW SWITCH AND BUTTERFLY VALVE
INSTALLATION (SPRINKLER)

DATE	SCALE
2017	NTS
DRAWING NUMBER	
CKM/STD/FF/SPRINKLER/REV2017/03	

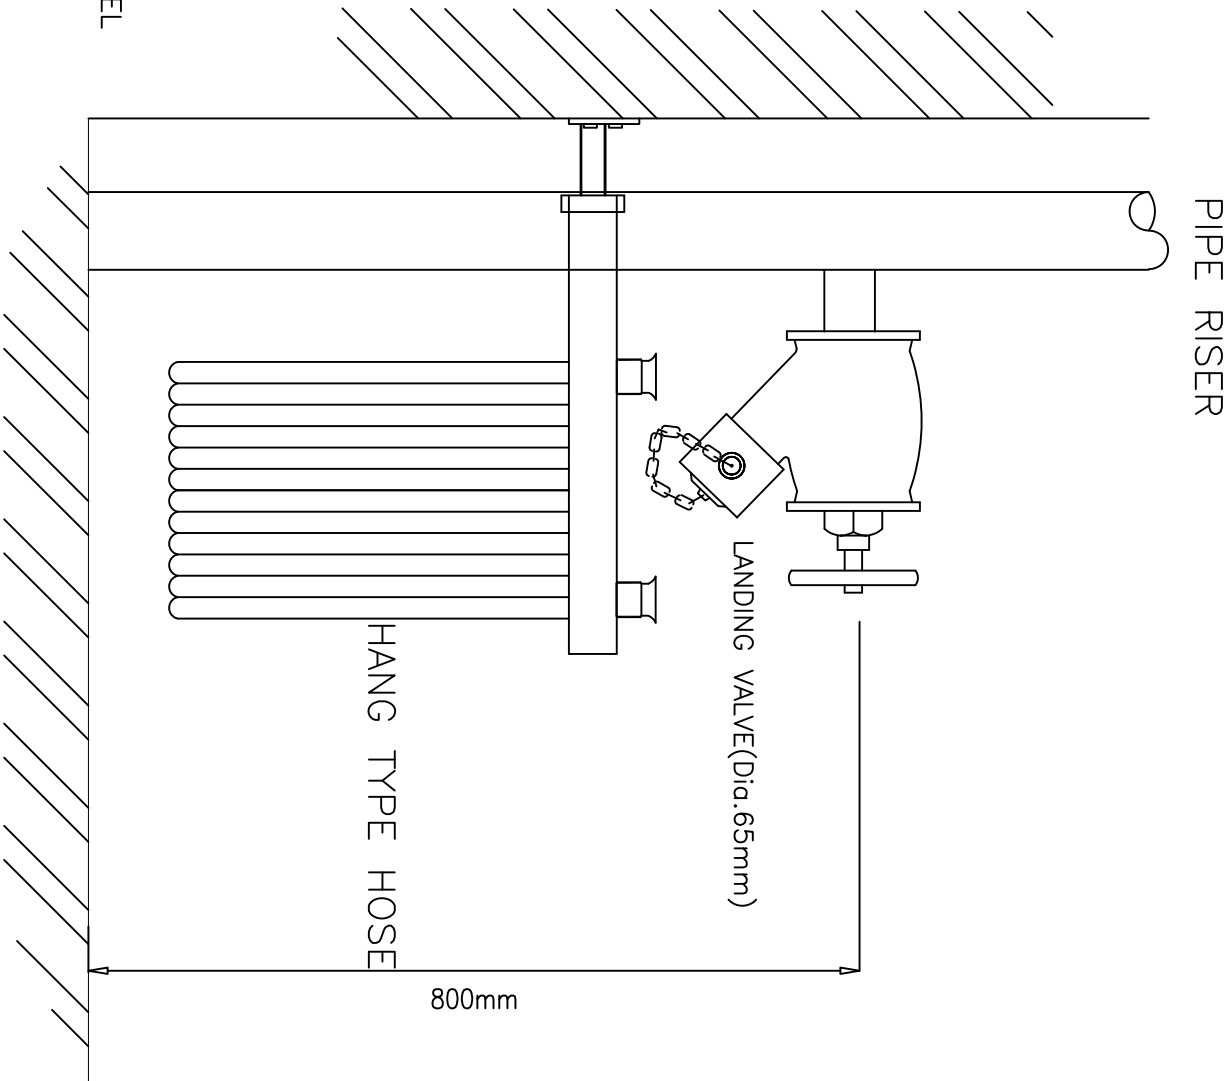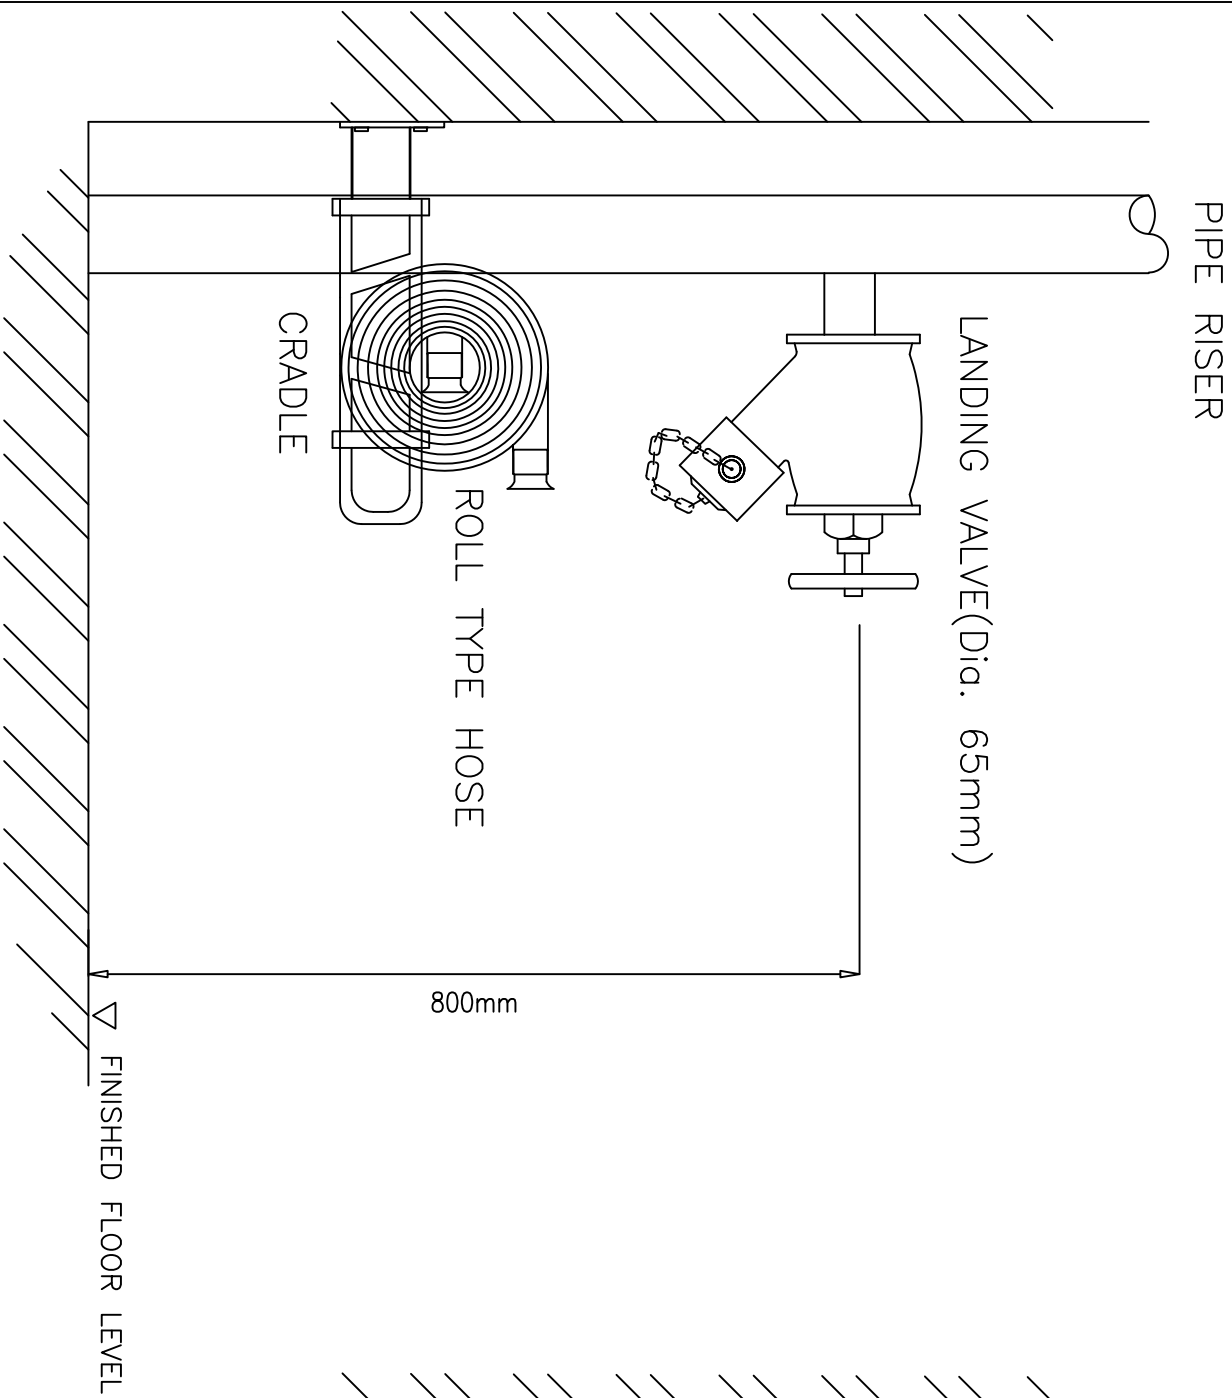

TYPICAL SIDE ELEVATION OF LANDING VALVE (DRY OR WET RISER)




JASA KEPADA RAKYAT
CAWANGAN KEJURUTERAAN MEKANIKAL
Ibu Pejabat JKR Malaysia


FIRE FIGHTING SYSTEM

TYPICAL SIDE ELEVATION OF LANDING VALVE
(DRY OR WET RISER)


DATE	SCALE
2017	NTS
DRAWING NUMBER	
CKM/STD/FF/DRY & WET RISER/REV2017/01	

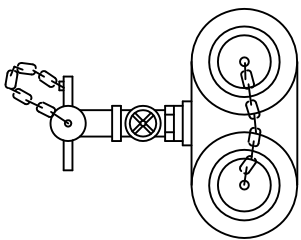


FRONT VIEW 2-WAY

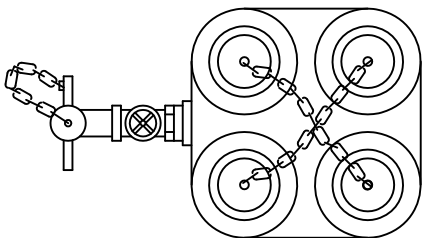


FRONT VIEW 4-WAY

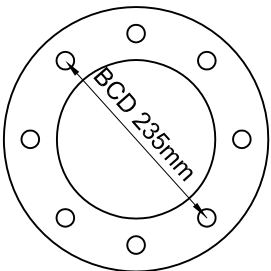


FLANGE

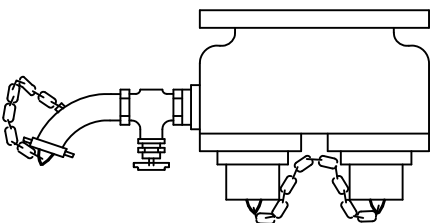

SIDE VIEW

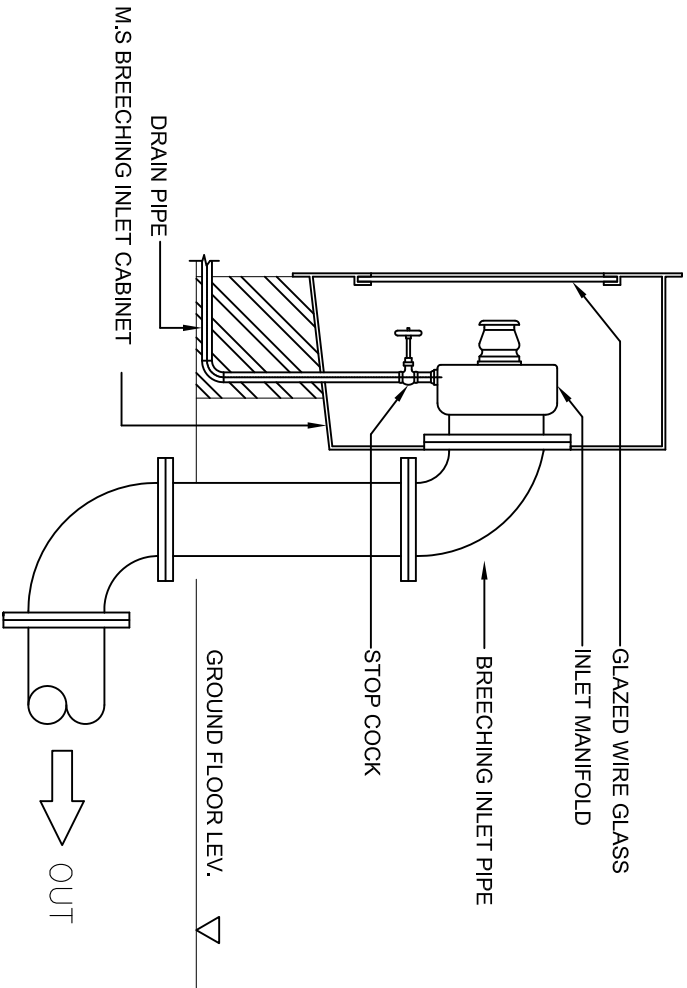

SIDE VIEW – 2 WAY

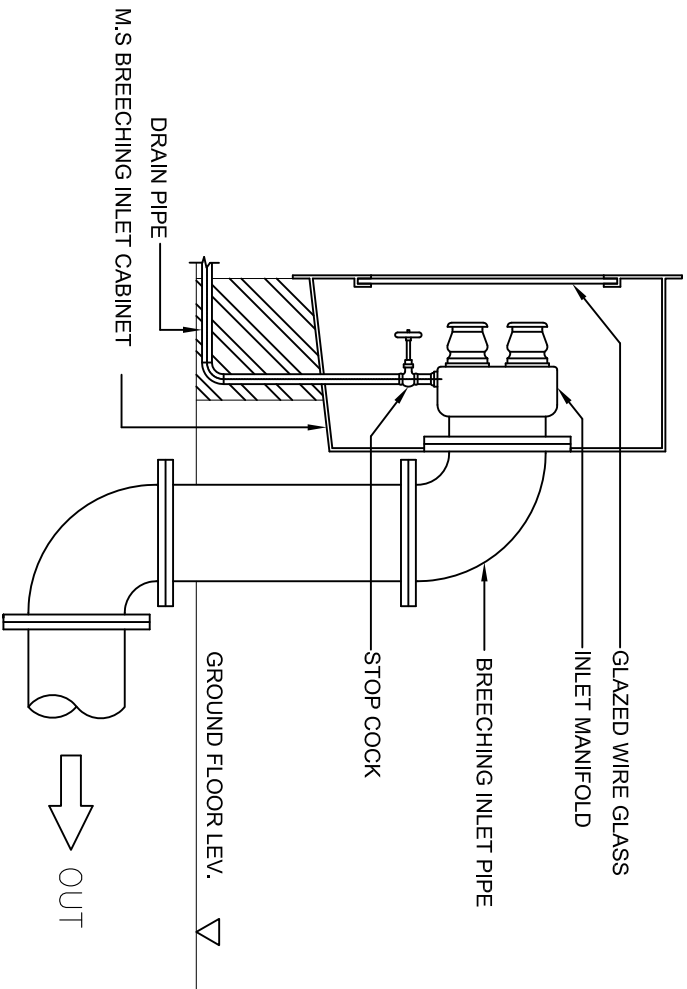

SIDE VIEW – 4 WAY

TYPICAL 4-WAY / 2-WAY BREECHING INLET




CAWANGAN KEJURUTERAAN MEKANIKAL
Ibu Pejabat JKR Malaysia

FIRE FIGHTING SYSTEM

TYPICAL TYPES OF BREECHING INLET

DATE	SCALE
2017	NTS
DRAWING NUMBER	
CKM/ST/FF/DRY & WET RISER/REV/2017/02	

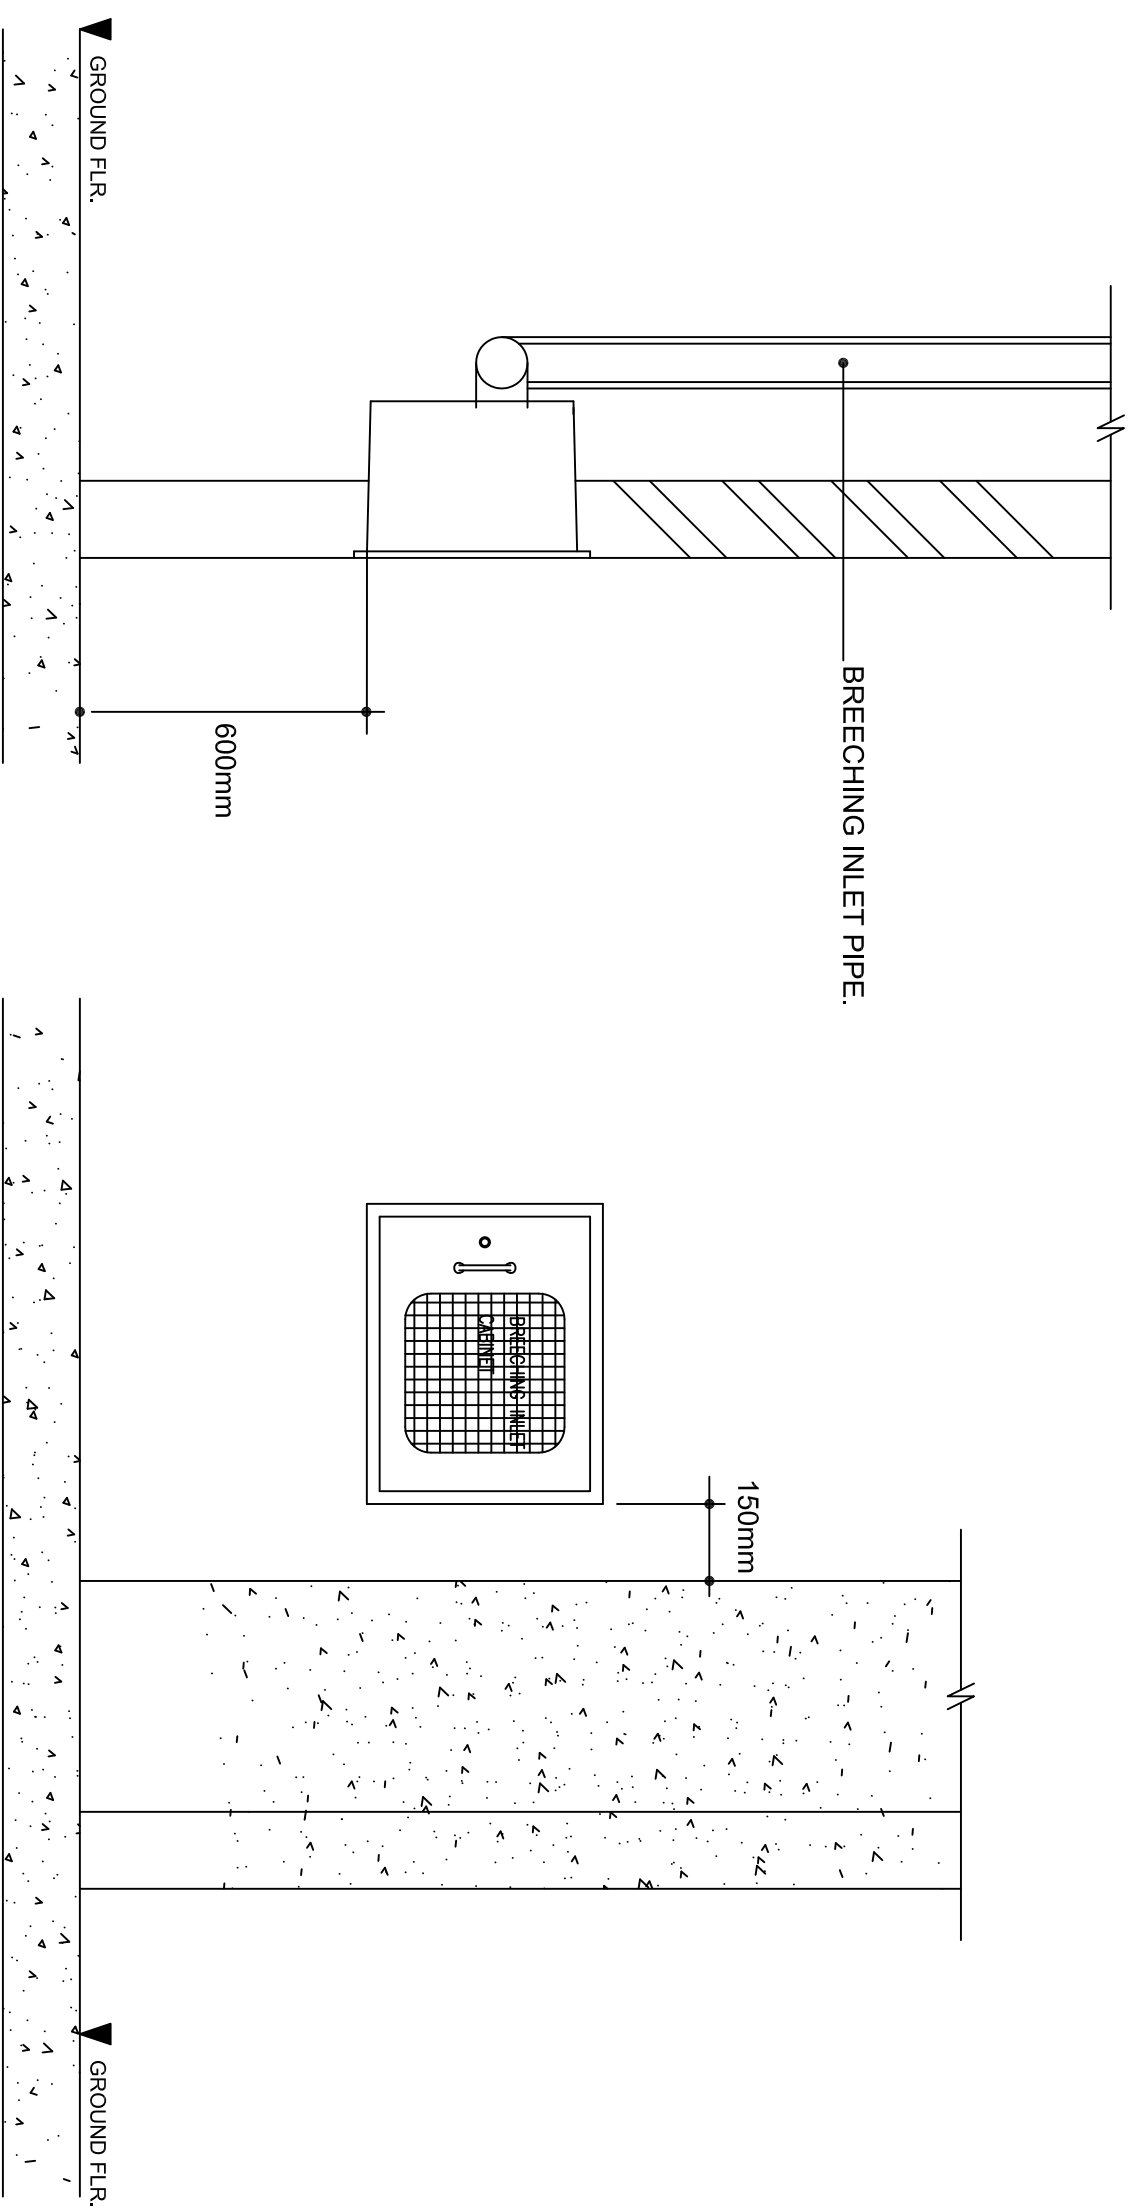

TYPICAL BREECHING INLET CABINET





JASA KEPADA RAKYAT
CAWANGAN KEJURUTERAAN MEKANIKAL
Ibu Pejabat JKR Malaysia

FIRE FIGHTING SYSTEM

TYPICAL BREECHING INLET CABINET

DATE	2017	SCALE	NTS
DRAWING NUMBER			
CKMSTD/FF/DRY & WET RISER/REV/2017/03			

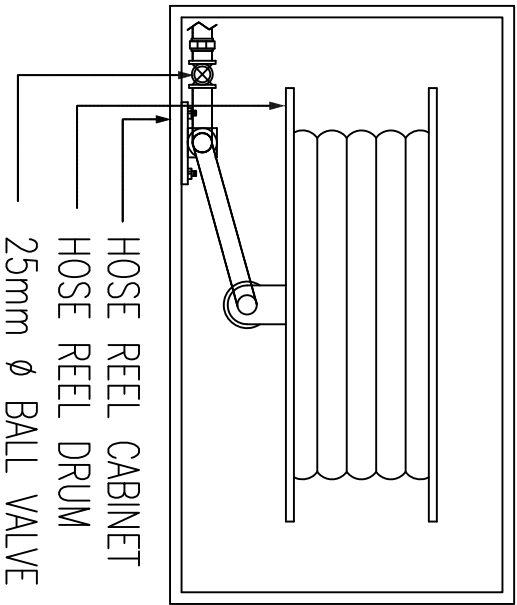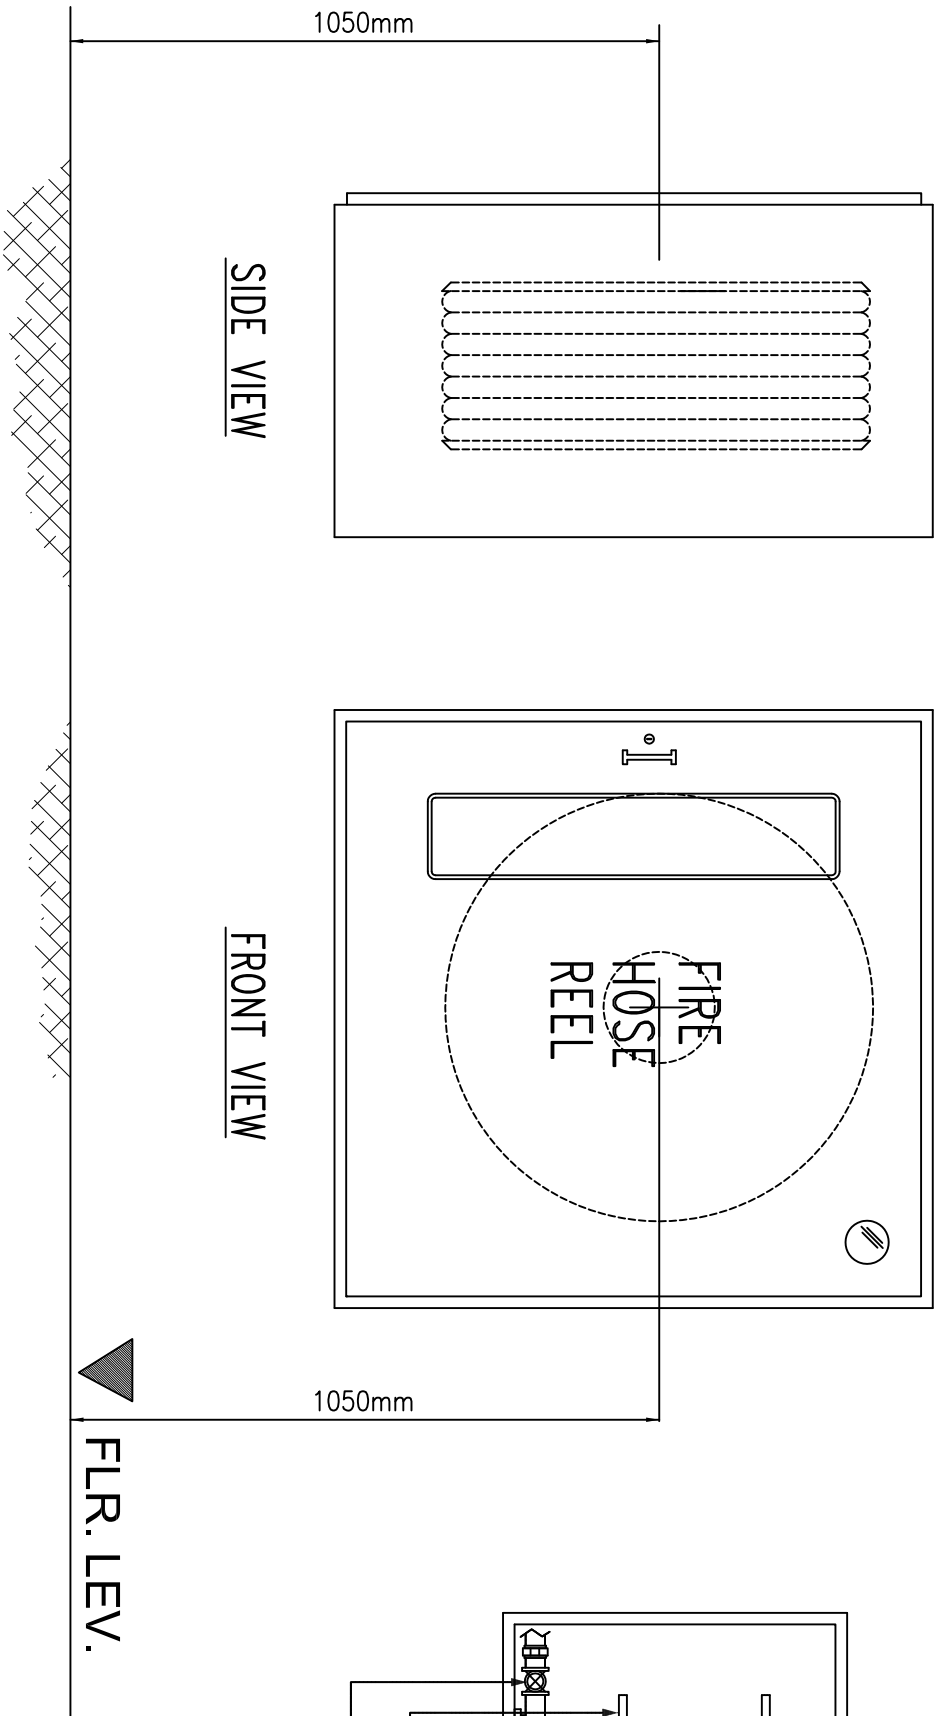

DETAIL OF HOSE REEL CABINET





JASA KEPADA RAKYAT
CAWANGAN KEJURUTERAAN MEKANIKAL
Ibu Pejabat JKR Malaysia

FIRE FIGHTING SYSTEM

DETAIL OF HOSE REEL CABINET

DATE	SCALE
2017	NTS
DRAWING NUMBER	
CKM/STD/FF/HOSE REEL/REV2017/01	

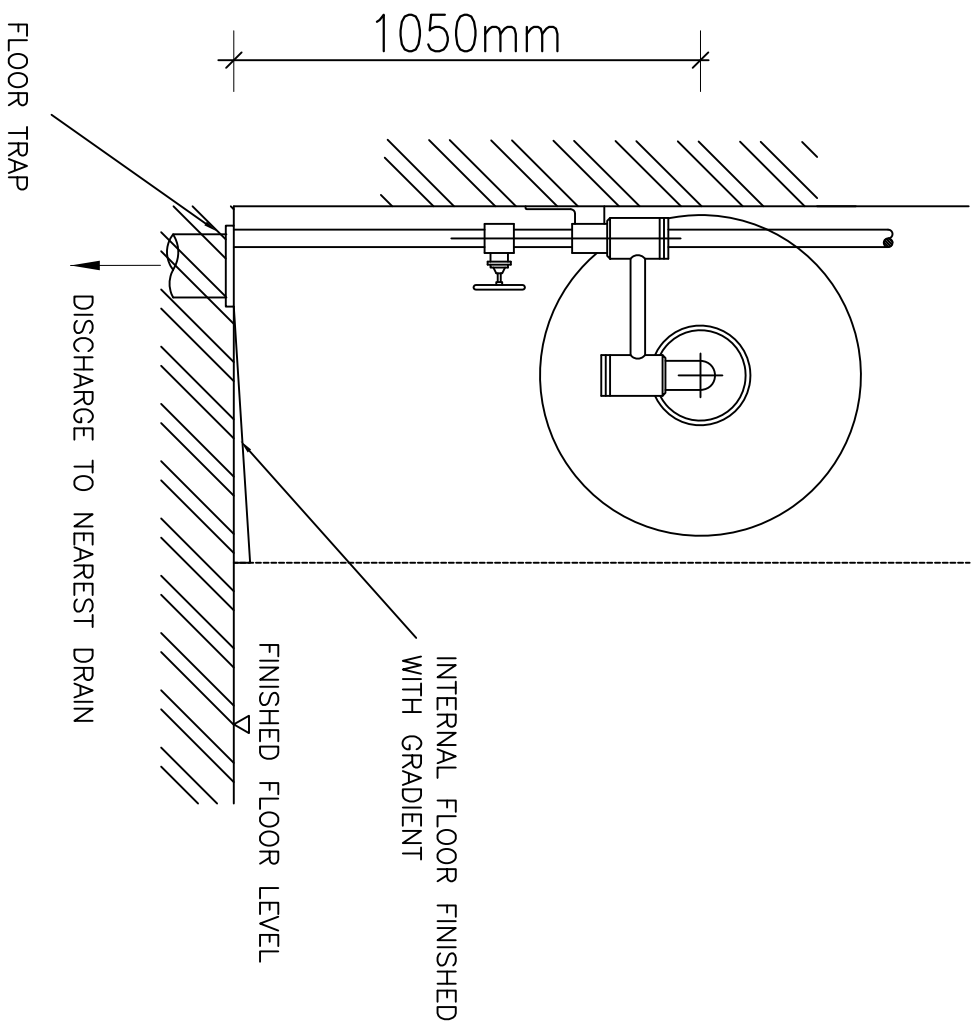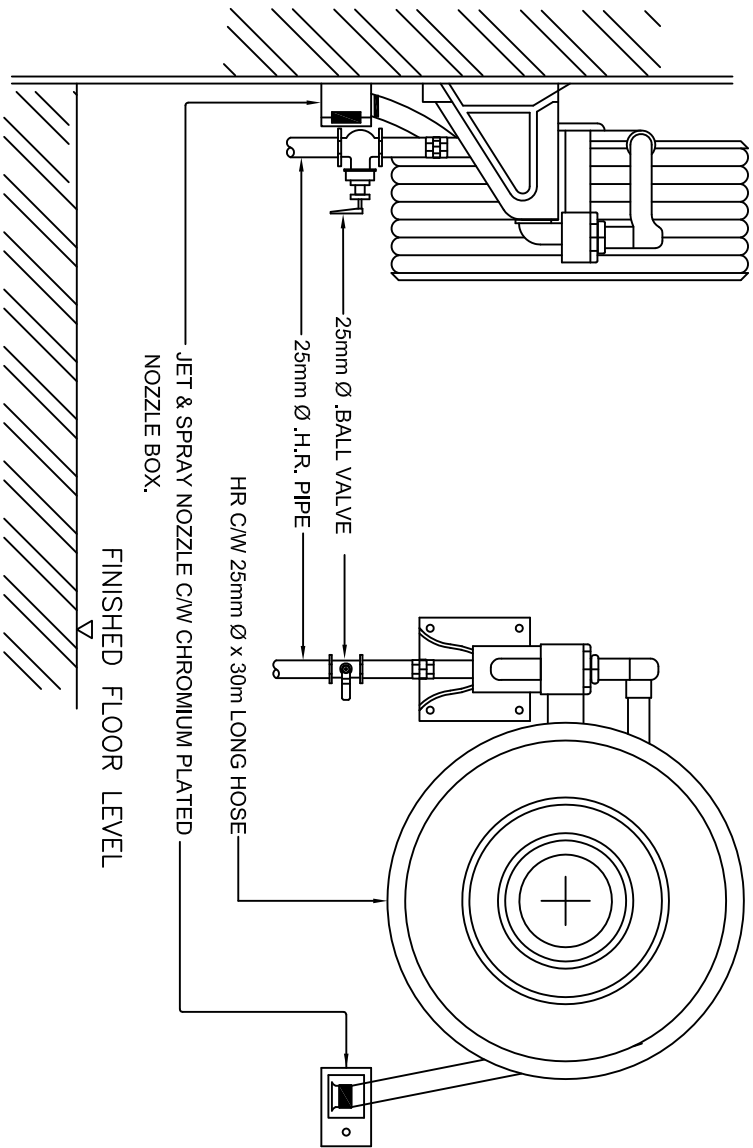

DETAIL OF HOSE REEL INSTALLATION




JASA KEPADA RAKYAT

CAWANGAN KEJURUTERAAN MEKANIKAL
Ibu Pejabat JKR Malaysia


FIRE FIGHTING SYSTEM

DETAIL OF HOSE REEL INSTALLATION

DATE	SCALE
2017	NTS
DRAWING NUMBER	
CKM/STD/FF/HOSE REEL/REV2017/02	

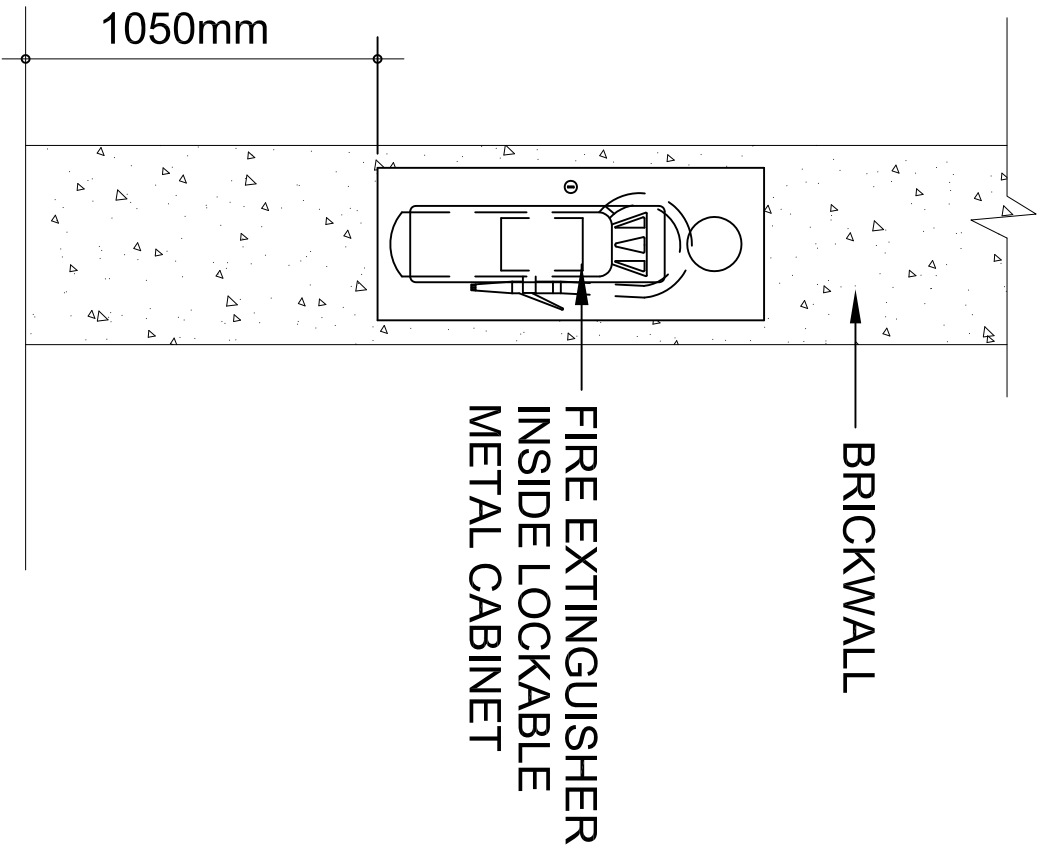

FRONT VIEW

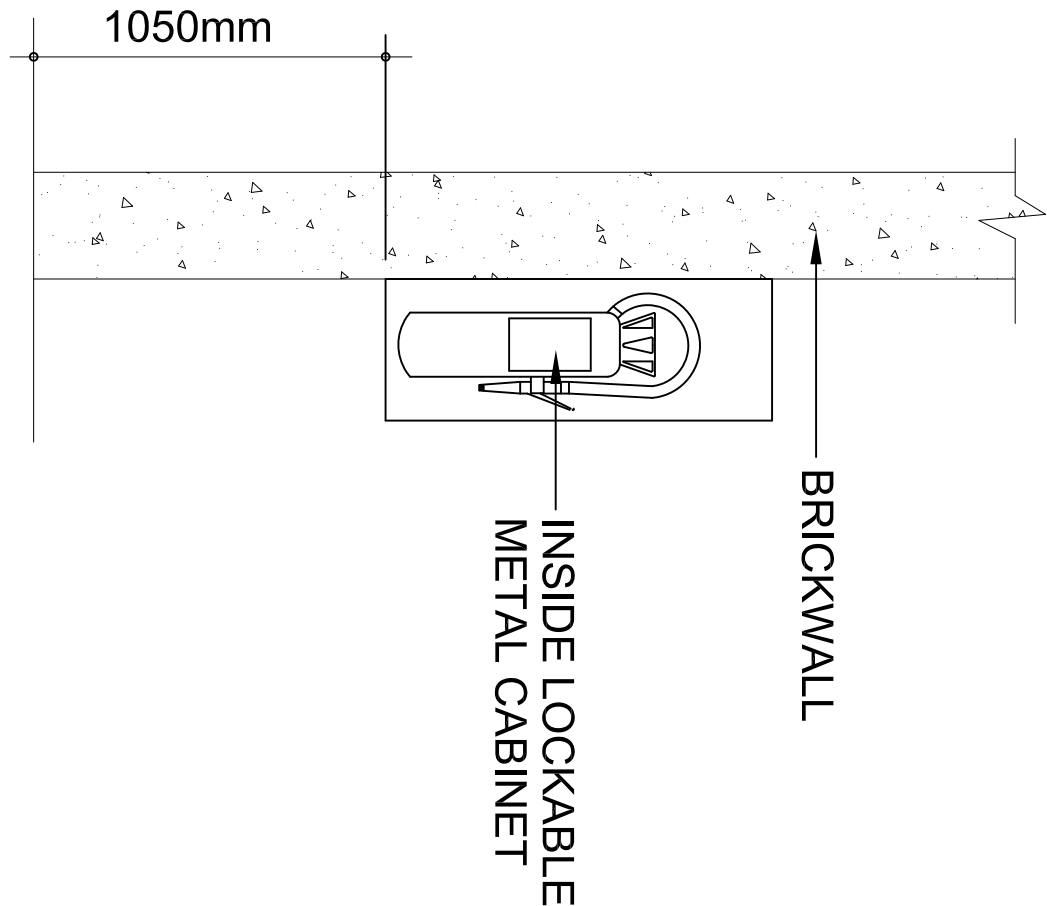

SIDE VIEW

DETAIL OF PORTABLE FIRE EXTINGUISHER INSTALLATION




JASA KEPADA RAKYAT
CAWANGAN KEJURUTERAAN MEKANIKAL
Ibu Pejabat JKR Malaysia


FIRE FIGHTING SYSTEM
DETAIL OF PORTABLE FIRE EXTINGUISHER
INSTALLATION

DATE	SCALE
2017	NTS
DRAWING NUMBER CKM/STD/FF/EXTINGUISHER/REV2017/01	

LEGEND	
TPN	Triple Pole & Neutral
ELCB	Earth Leakage Circuit Breaker
SPN	Single Pole & Neutral
SSB	Sub Switch Board
MCCB	Moulded Case Circuit Breaker
MCB	Miniature Circuit Breaker
CU	Cooper
AT	Auto Transformer
SD	Star Delta
DOL	Direct On Line
A	Ampere
V	Volt
R	Red
Y	Yellow
B	Blue

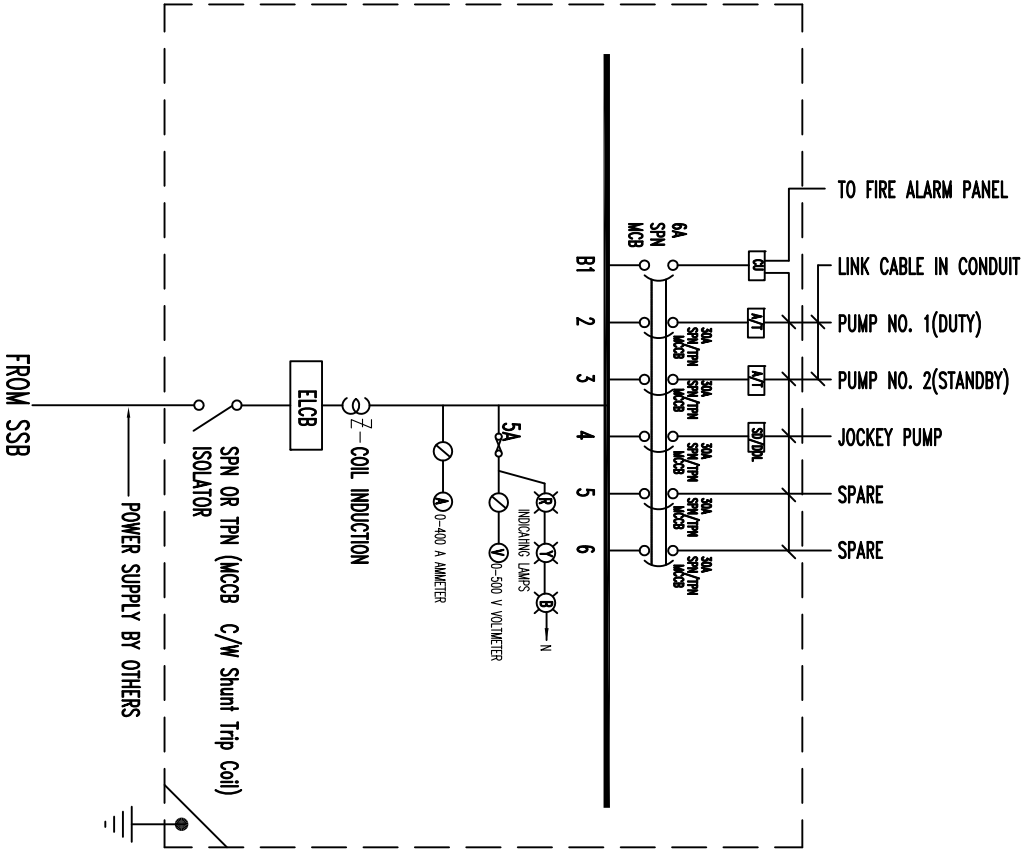

TYPICAL DIAGRAM
FOR SPRINKLER & WET RISER PUMP
SWITCHBOARD

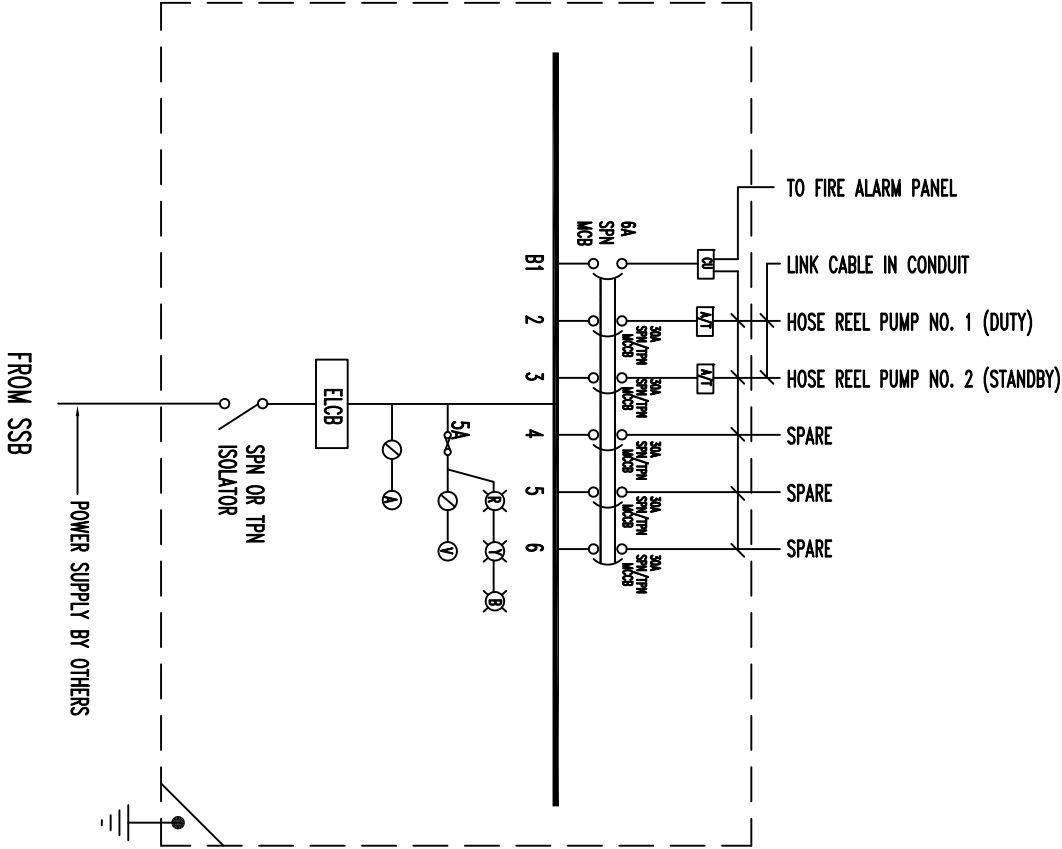


TYPICAL SINGLE LINE DIAGRAM
FOR HOSE REEL PUMP SWITCHBOARD




JASA KEPADA RAKYAT
CAWANGAN KEJURUTERAAN MEKANIKAL
Ibu Pejabat JKR Malaysia

FIRE FIGHTING SYSTEM
TYPICAL CIRCUIT DIAGRAM
FOR PUMP SWITCHBOARD


DATE	SCALE
2017	NIS
DRAWING NUMBER	
CKM/STD/FF/SWITCHBOARD/REV2017/01	

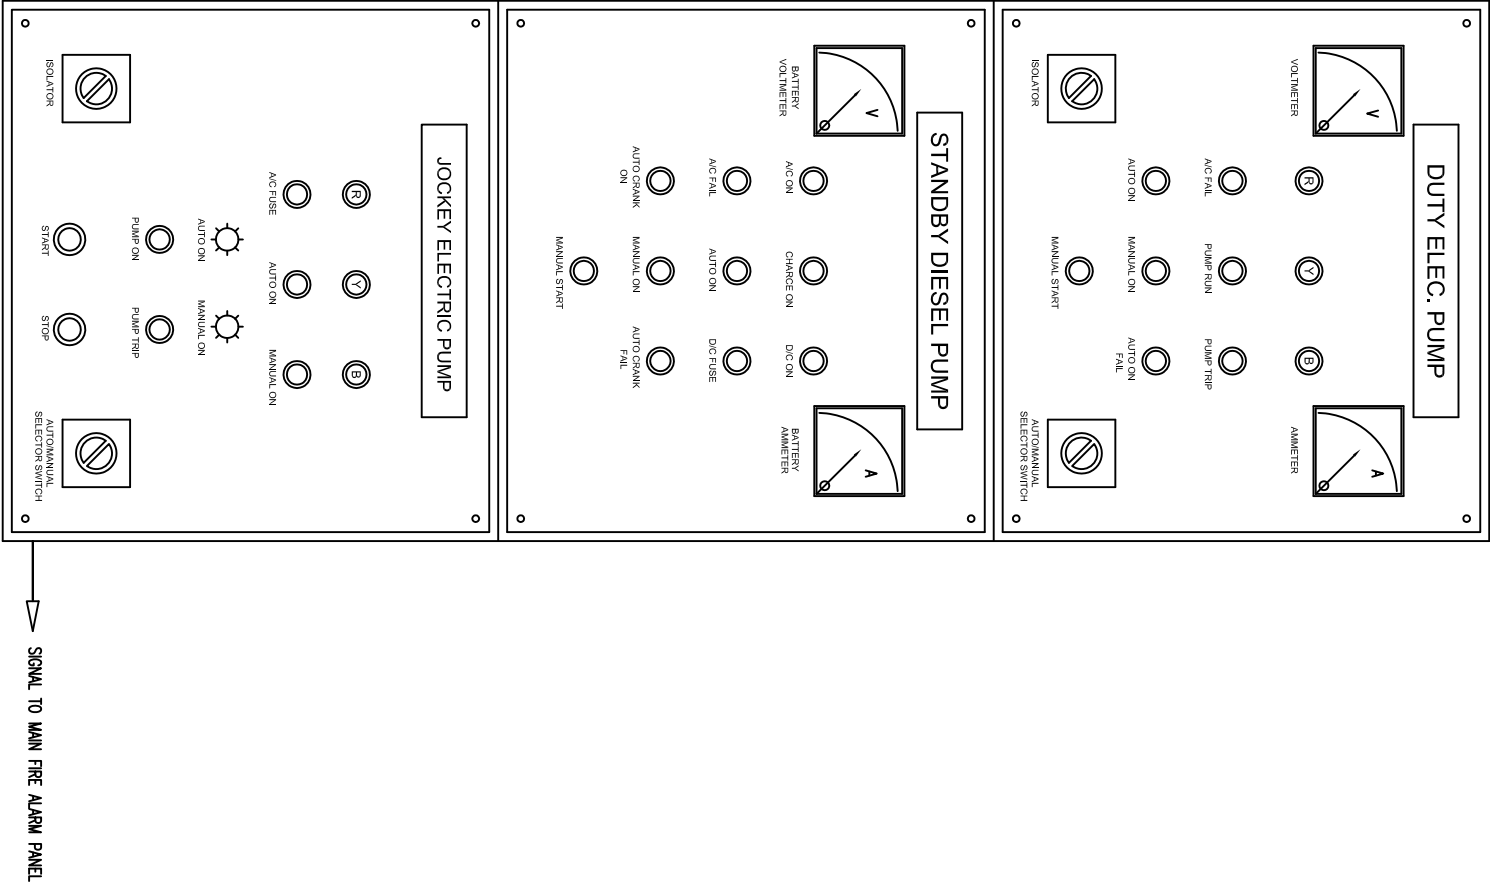


TYPICAL SPRINKLER AND WET RISER PUMP SWITCHBOARD

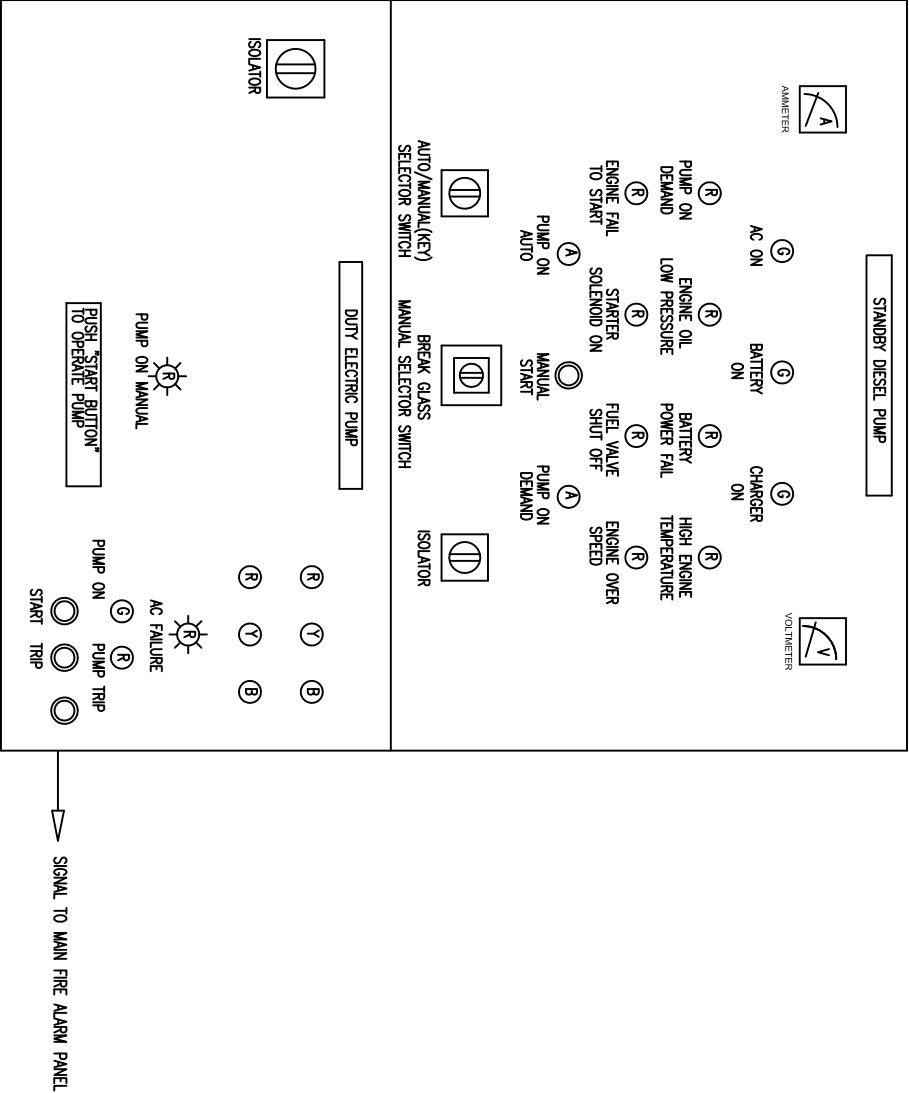

TYPICAL HOSE REEL STARTER PUMP SWITCHBOARD

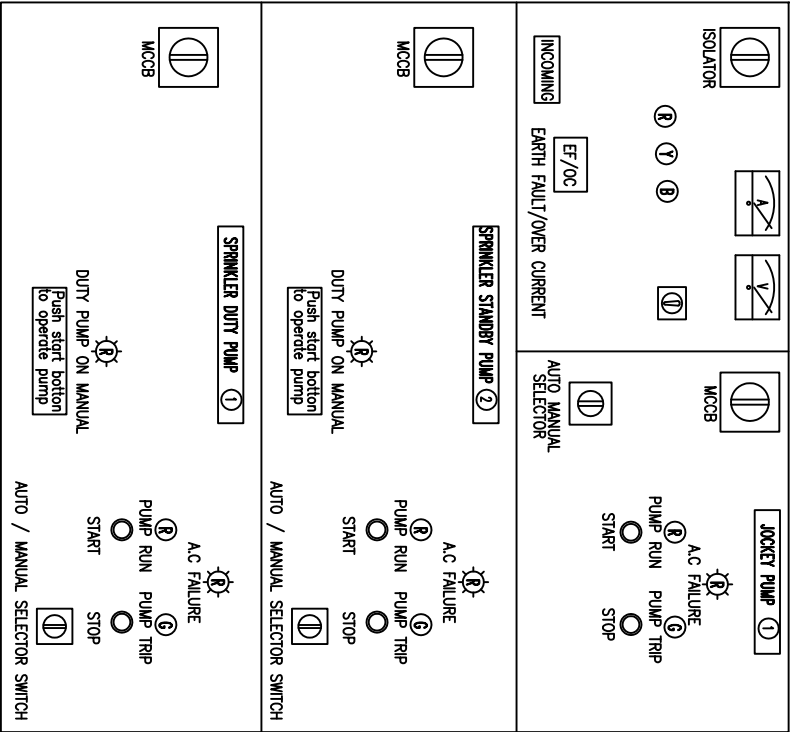

TYPICAL SPRINKLER AND WET RISER PUMP SWITCHBOARD

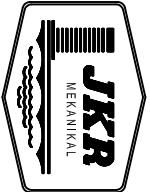

CAWANGAN KEJURUTERAAN MEKANIKAL
Ibu Pejabat JKR Malaysia

TYPICAL PUMP SWITCHBOARD FOR
HOSE REEL, SPRINKLER AND WET RISER

DATE 2017 SCALE NTS
DRAWING NUMBER CKM/STD/FF/SWITCHBOARD/REV2017/02

PERINGATAN!

JANGAN MASUK KE BILIK
INI BILA GAS DILEPASKAN

 
EMERGENCY INSTRUCTION SIGN

ARAHAN KECEMASAN


Bilik Ini Dikawal Oleh Alat Pengesan Haba.
Asap Dan Sistem Automatik Pencegah Kebakaran
Total Flooding Extinguishing System:

1. Dilarang Merokok Di dalam Bilik Ini.
2. Keluar Dengan SegeraDoripoda Bilik Ini Apabila
Lonceng Amaran Berbunyi.
3. Jangan Masuk Ke Bilik Ini Bila Gas Dilepaskan

ISOMETRIC DIAGRAM





 
TYPICAL FIRE SUPPRESSION SYSTEM SWITCHBOARD



Ibu Pejabat JKR Malaysia

FIRE FIGHTING SYSTEM

TYPICAL SWITCHBOARD TYPES FOR FIRE SUPPRESSION SYSTEM

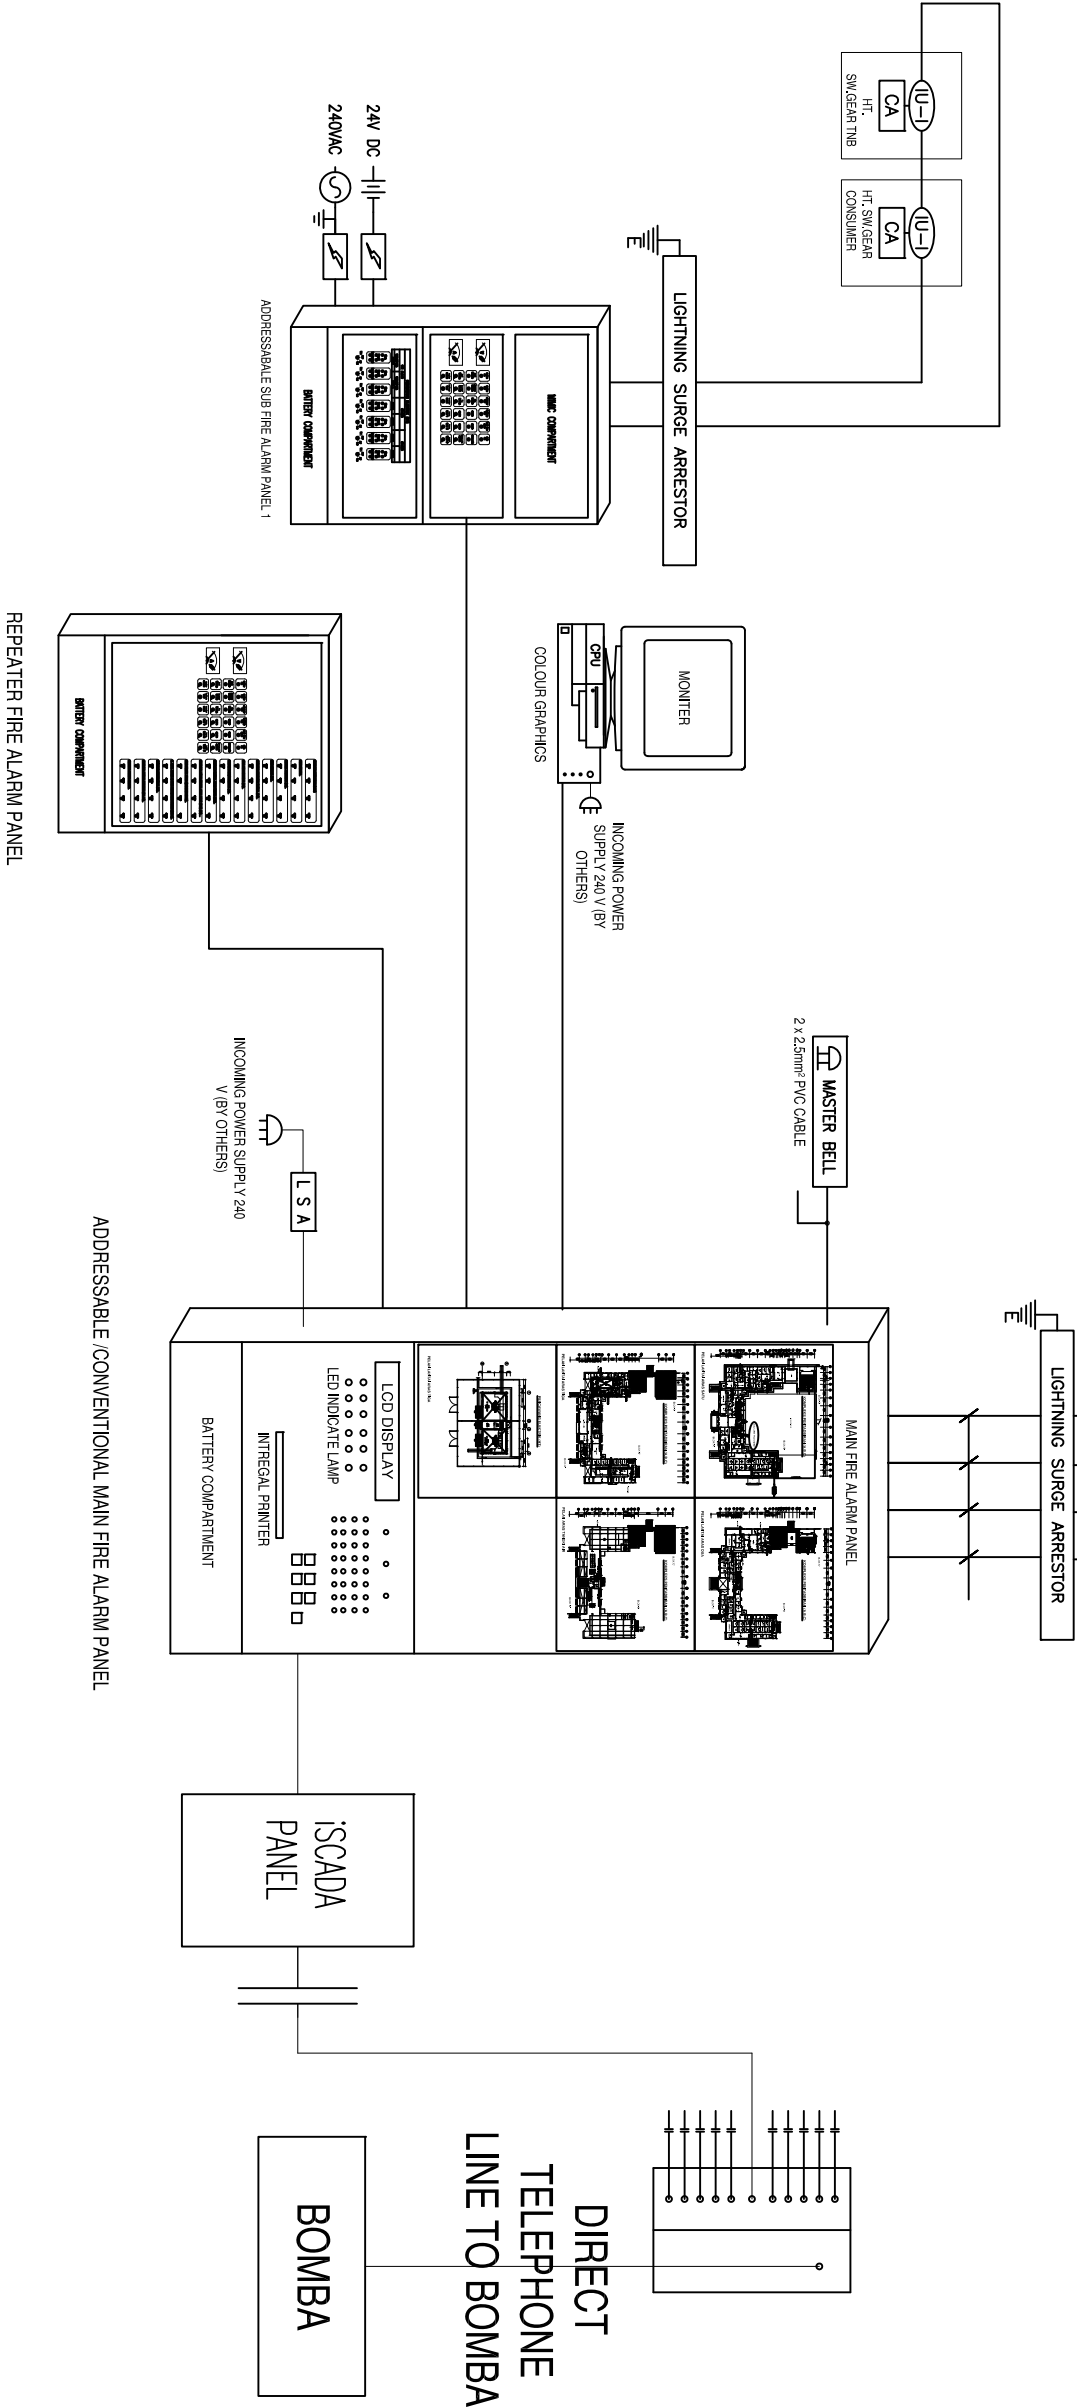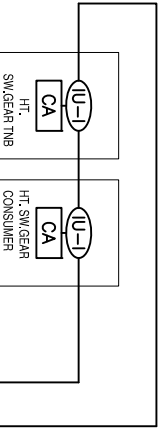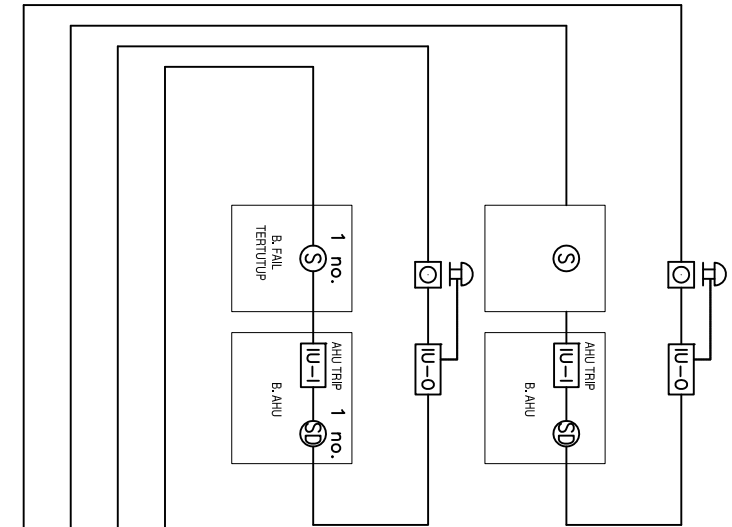

- LEGEND**
- SD - SMOKE DETECTOR
 - SD - DUCT SMOKE DETECTOR
 - H - HEAT DETECTOR
 - AB - ALARM BELL
 - BG - BREAK GLASS
 - CP - CONTROL PANEL
 - RP - REMOTE PROGRAMMABLE PROCESSING UNIT
 - IU - INTERFACING UNIT - INPUT
 - IU - INTERFACING UNIT - OUTPUT
 - LSA - LIGHTNING SURGE ARRESTOR
 - CA - CLEAN AGENT


TYPICAL CONNECTION TO SPKA




JASA KEPADA RAKYAT
CAWANGAN KEJURUTERAAN MEKANIKAL
Ibu Pejabat JKR Malaysia

SISTEM PENGAWASAN
KEBAKARAN AUTOMATIK (SPKA)

DATE	SCALE
2017	NTS
DRAWING NUMBER	
CKM/STD/FF/SWITCHBOARD/REV2017/04	

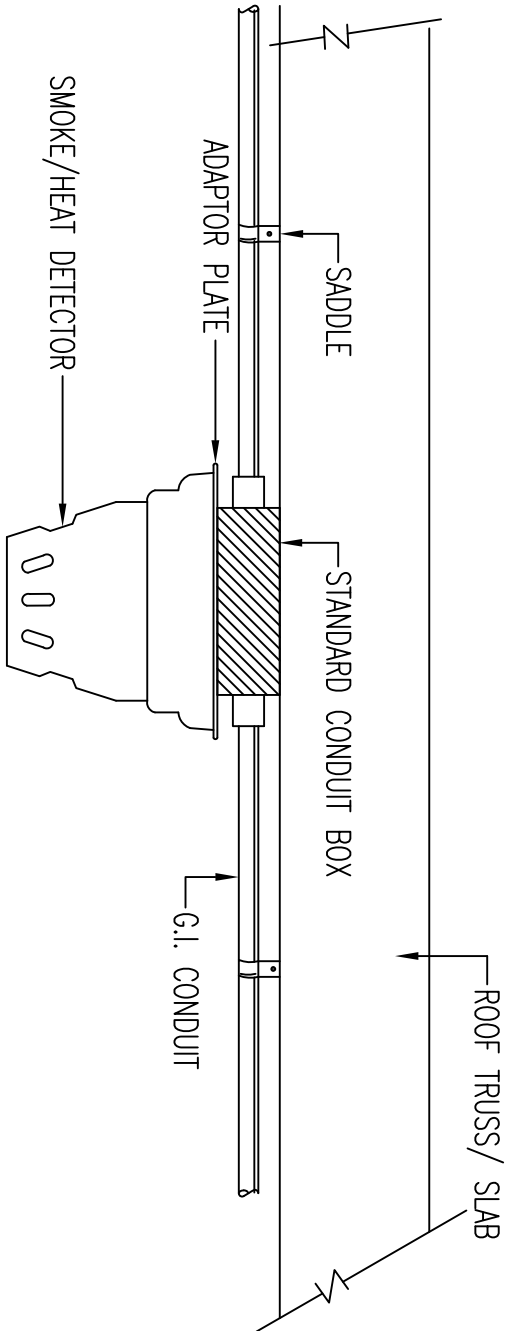

DETAIL OF SMOKE OR HEAT DETECTOR INSTALLATION ON ROOF TRUSS/ SLAB

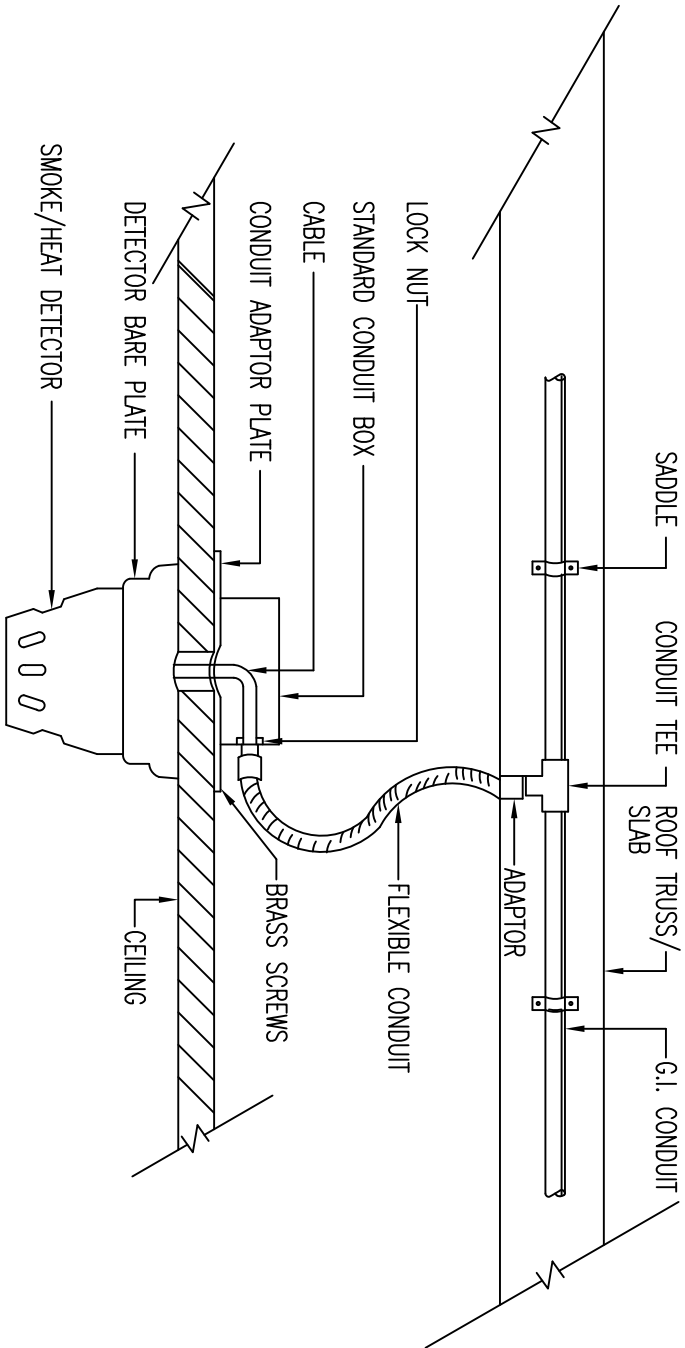

DETAIL OF SMOKE OR HEAT DETECTOR INSTALLATION ON CEILING



JASA KEPADA RAKYAT



CAWANGAN KEJURUTERAAN MEKANIKAL
Ibu Pejabat JKR Malaysia

FIRE FIGHTING SYSTEM

DETAIL OF SMOKE OR HEAT DETECTOR
INSTALLATION

DATE 2017 SCALE NTS

DRAWING NUMBER
CKM/STD/FF/FIRE ALARM/REV2017/01

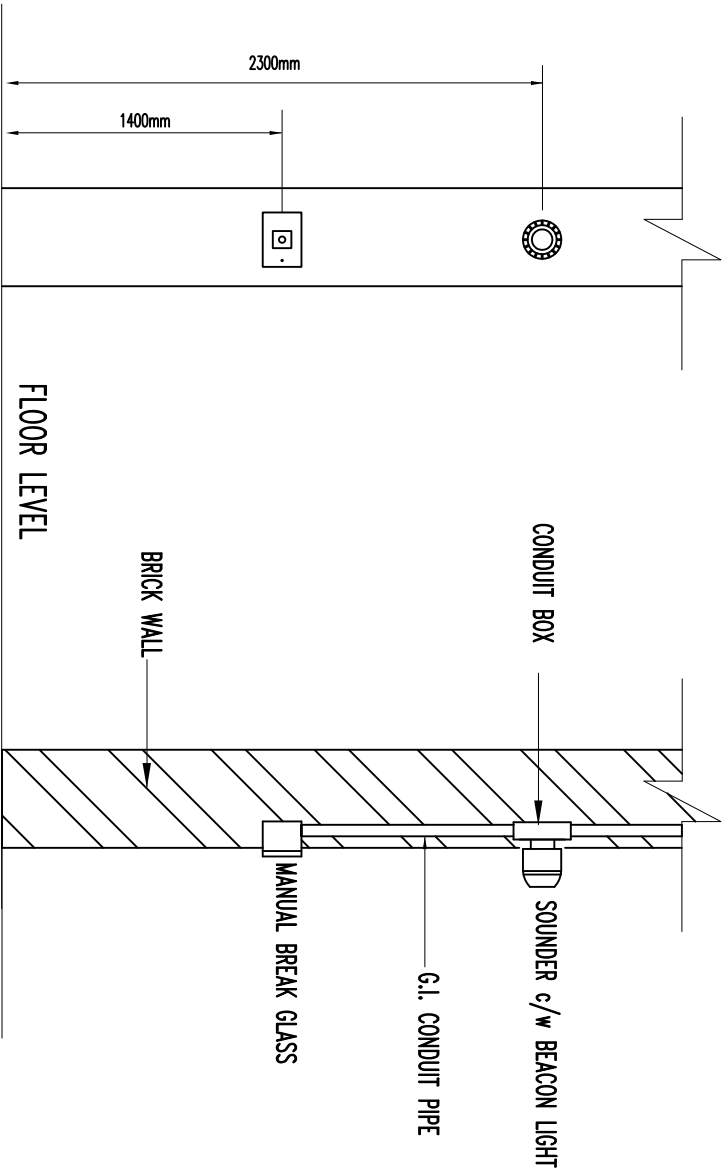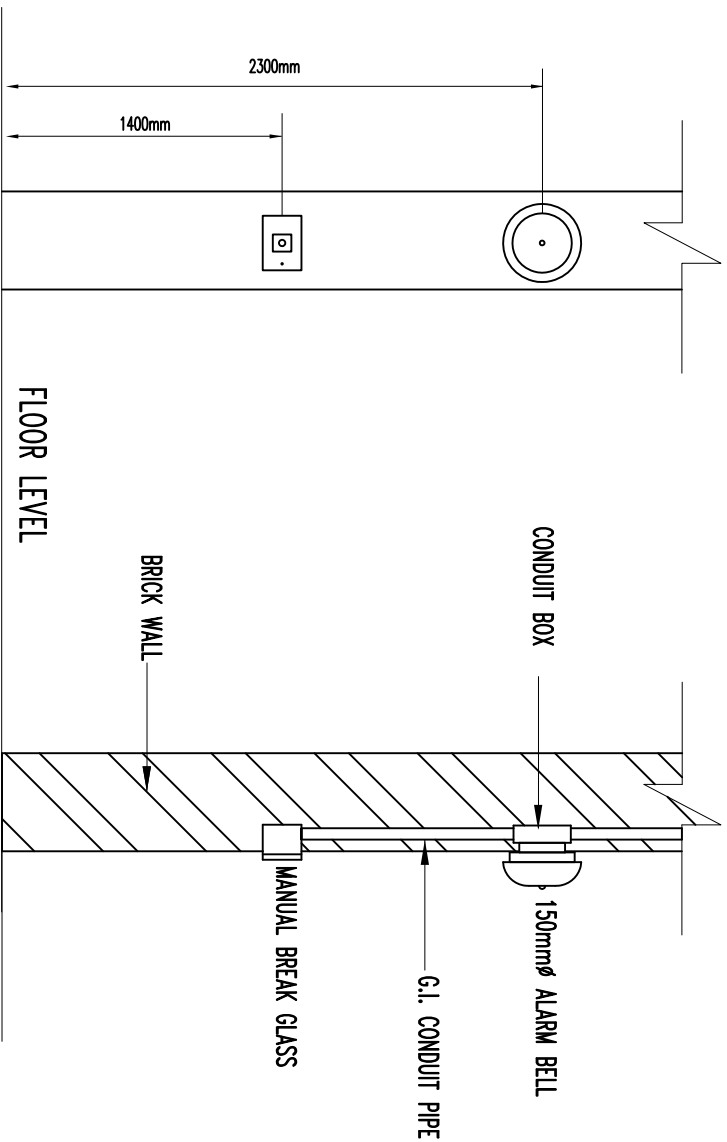

DETAIL OF ALARM BELL & BREAK GLASS POINT MOUNTING

DETAIL OF SOUNDER & BREAK GLASS POINT MOUNTING




JASA KEPADA RAKYAT
CAWANGAN KEJURUTERAAN MEKANIKAL
Ibu Pejabat JKR Malaysia

FIRE FIGHTING SYSTEM

DETAIL OF ALARM BELL AND BREAK GLASS
INSTALLATION

DATE	SCALE
2017	NTS
DRAWING NUMBER	
CKM/BPK/STD/FF/FIRE ALARM/REV2017/02	

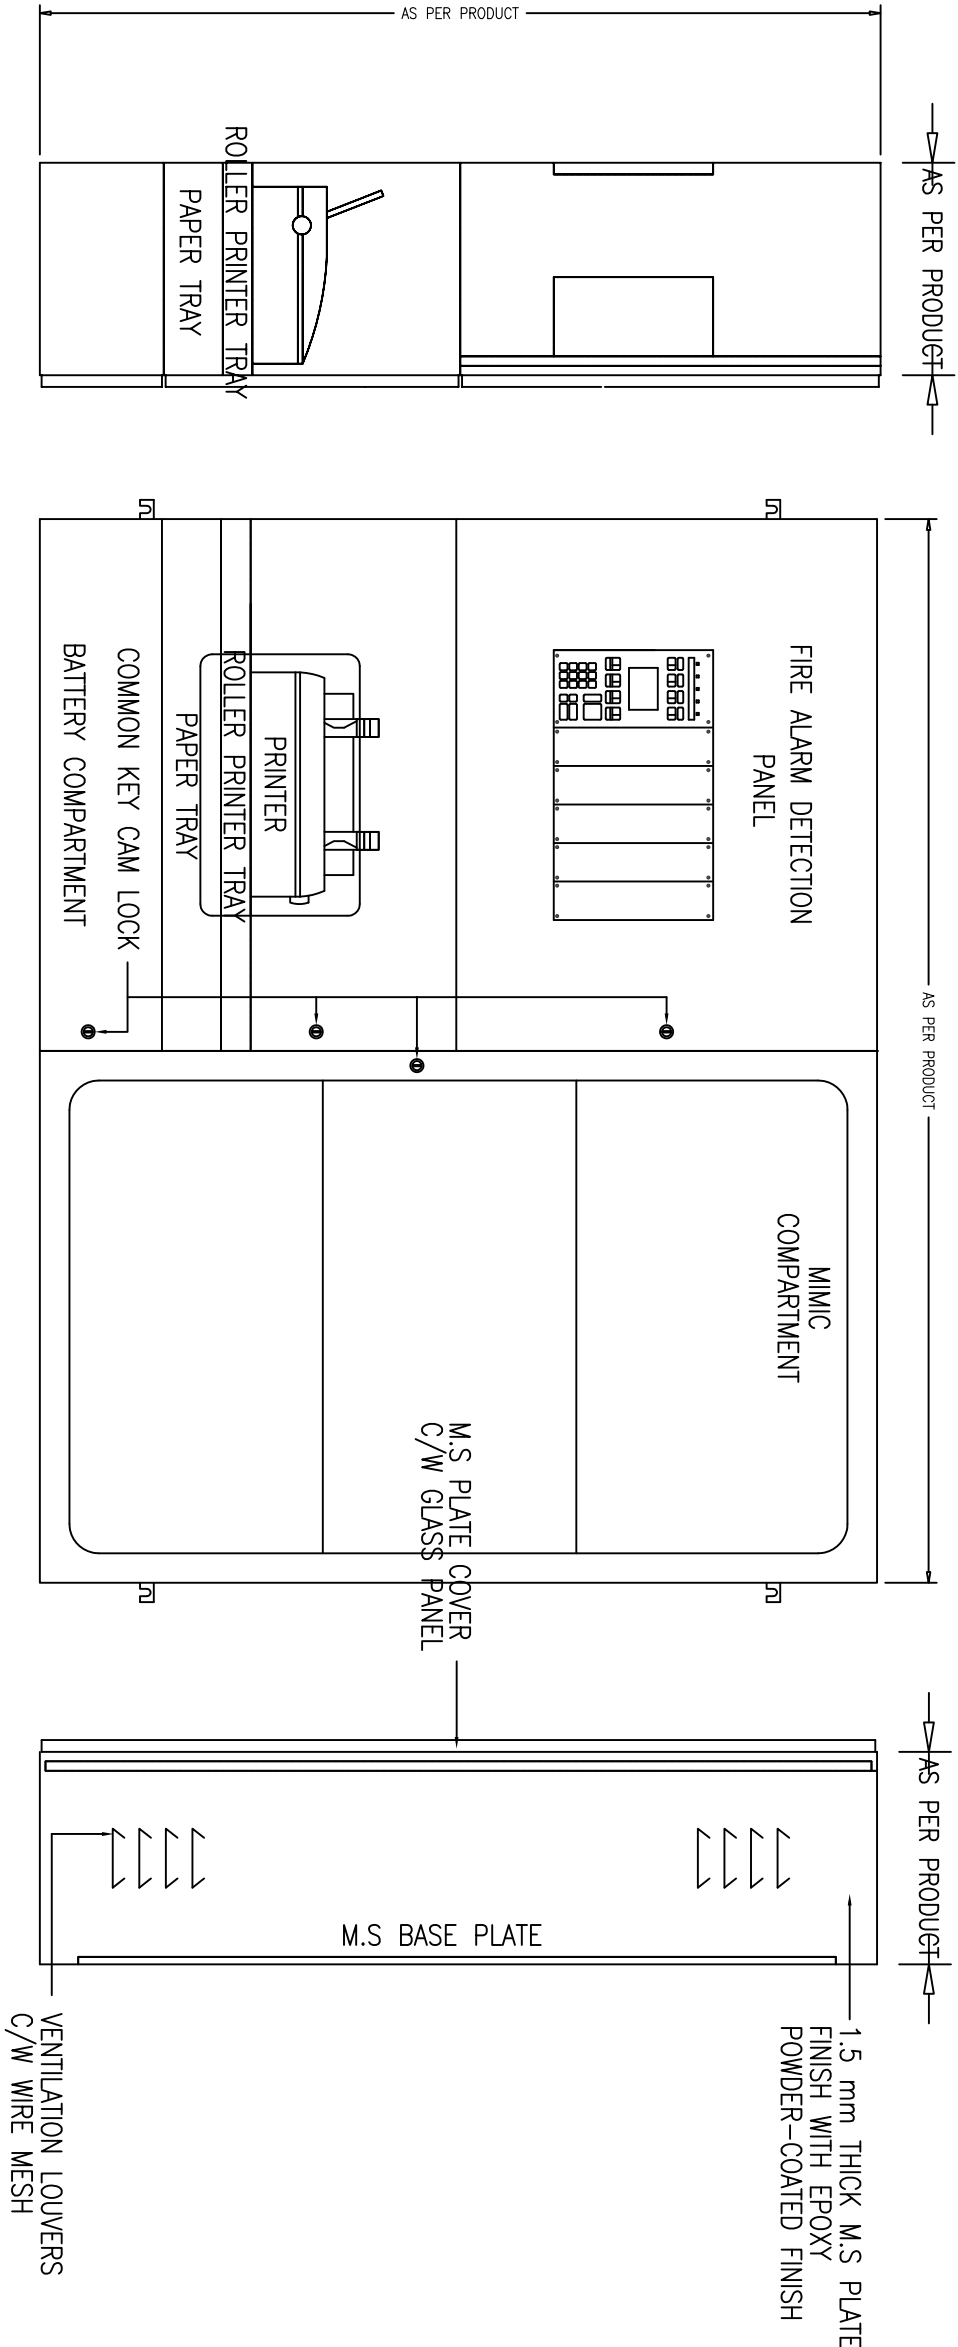

TYPICAL MAIN FIRE ALARM PANEL(ADDRESSABLE)




JASA KEPADA RAKYAT
CAWANGAN KEJURUTERAAN MEKANIKAL
Ibu Pejabat JKR Malaysia

FIRE FIGHTING SYSTEM

TYPICAL ADDRESSABLE FIRE ALARM PANEL

DATE	2017	SCALE	N.T.S
DRAWING NUMBER	CKM.BPK/STD/FF/FIRE ALARM/REV2017/03		

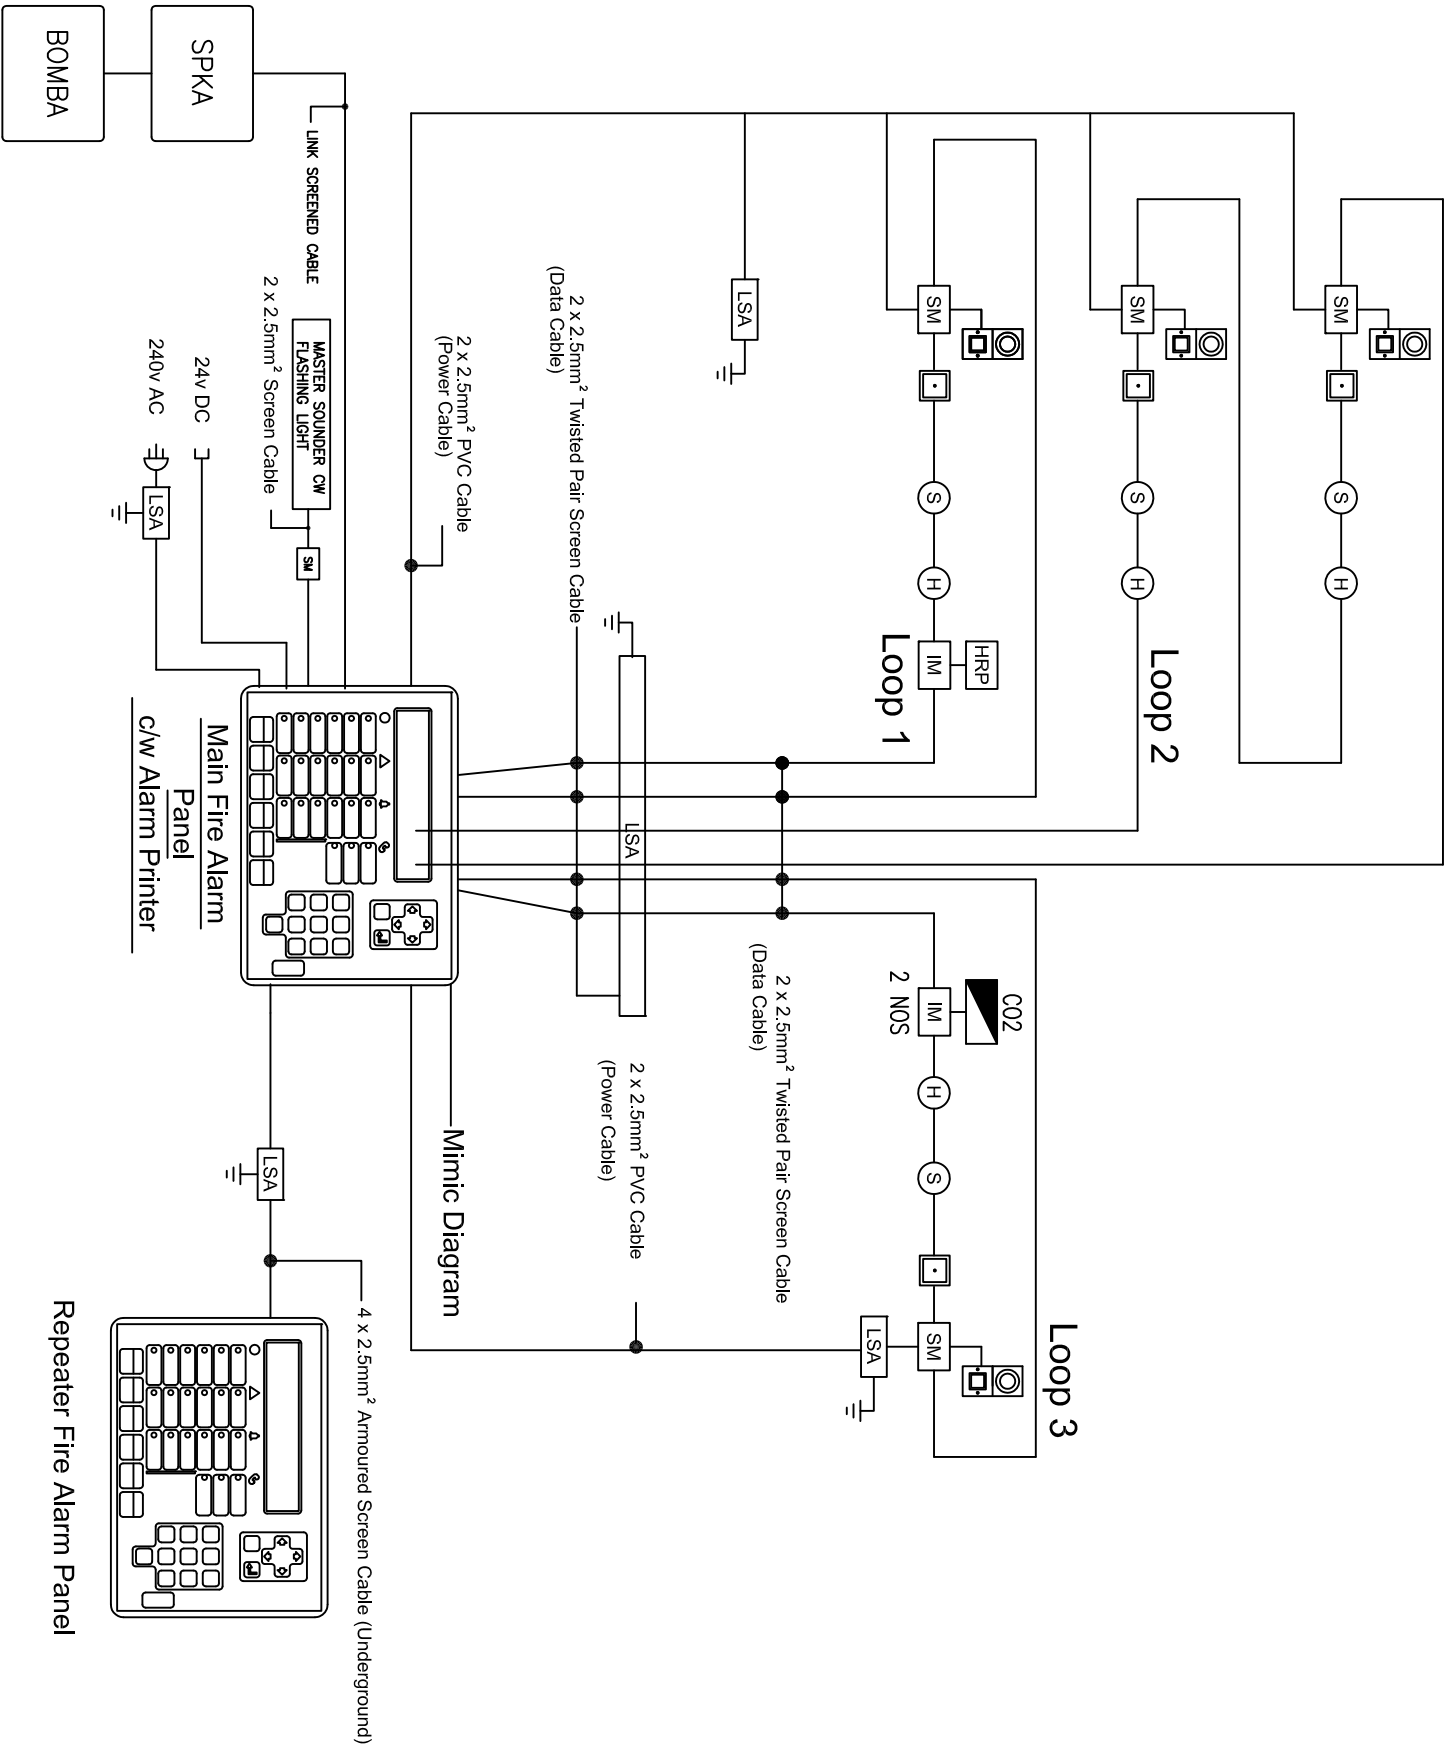

TYPICAL SCHEMATIC LINE DIAGRAM
OF ADDRESSABLE FIRE ALARM SYSTEM

- LEGEND**
- SM Addressable Sounder c/w
 - LSA Flashing Light Module
 - IM Lightning Surge Arrestor
 - SPKA Addressable Input Module
 - HRP Sistem Pengawasan Kebakaran Automatik
 - BG Hose Reel Pump
 - Break Glass
 - Smoke Detector
 - H Heat Detector
 - Sounder c/w Flashing Light
 - CO2 CO2 Panel




JASA KEPADA RAKYAT

CAWANGAN KEJURUTERAAN MEKANIKAL
Ibu Pejabat JKR Malaysia

FIRE FIGHTING SYSTEM

TYPICAL SCHEMATIC DIAGRAM FOR
ADDRESSABLE FIRE ALARM PANEL


DATE	SCALE
2017	NTS
DRAWING NUMBER	
CKM.BPK/STD/FF/FIRE ALARM/REV2017/04	

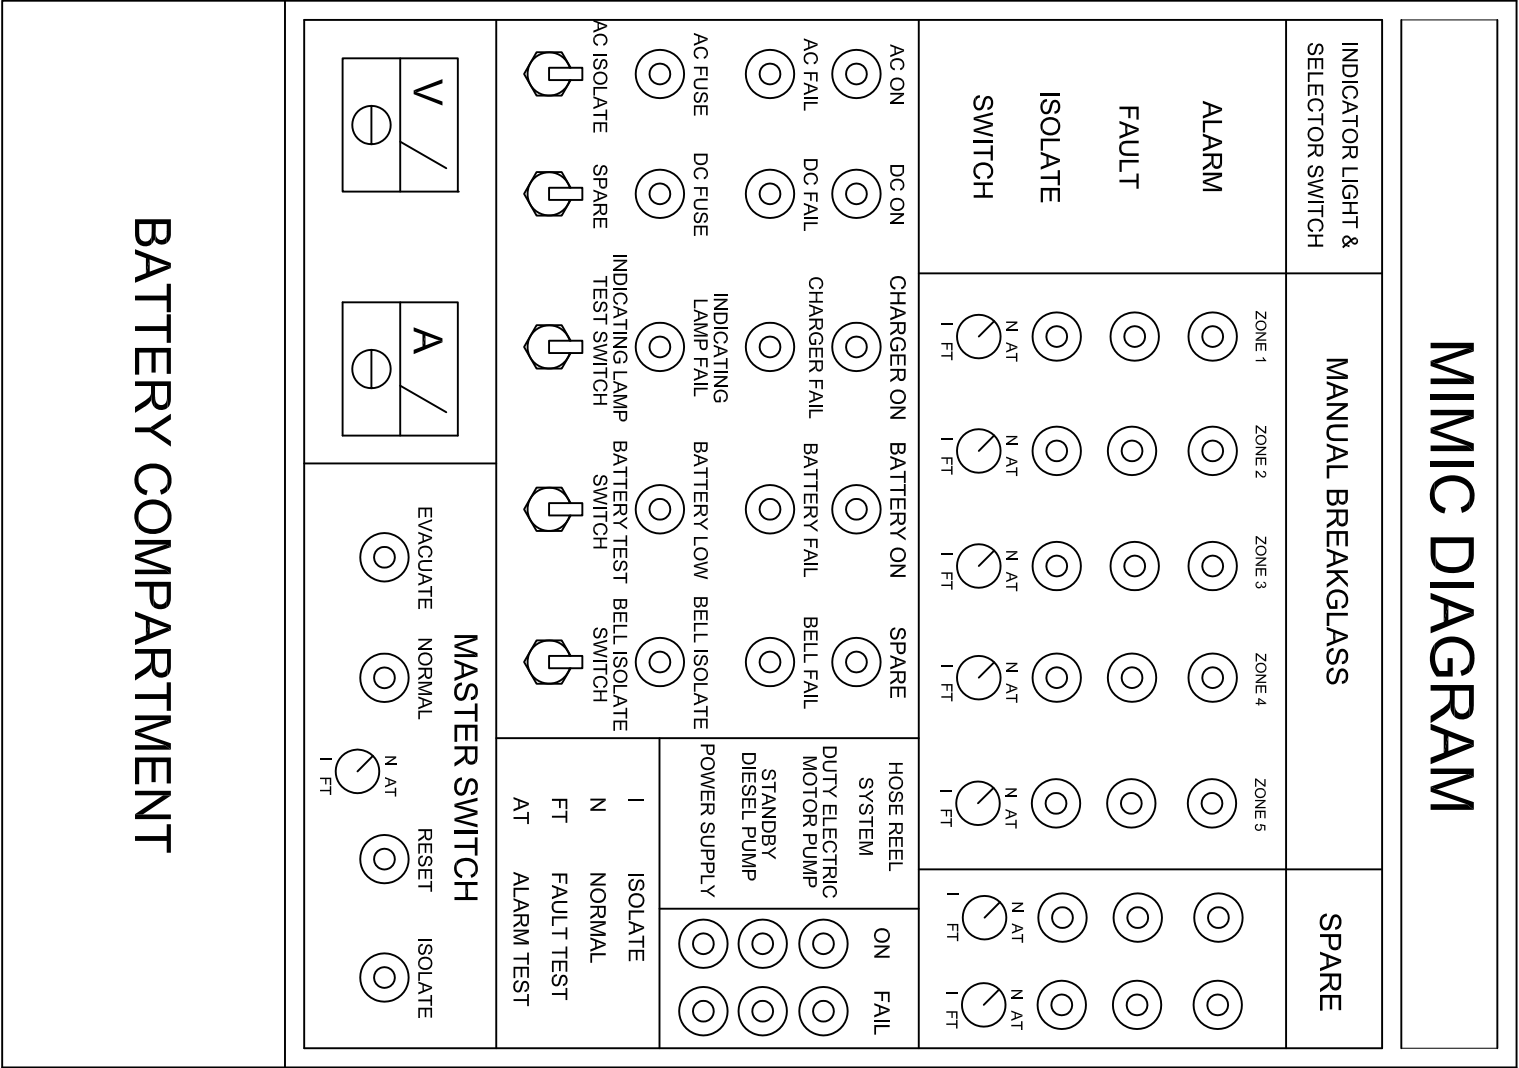

BATTERY COMPARTMENT

TYPICAL CONVENTIONAL FIRE ALARM PANEL

LOCENG PENGGERA UTAMA

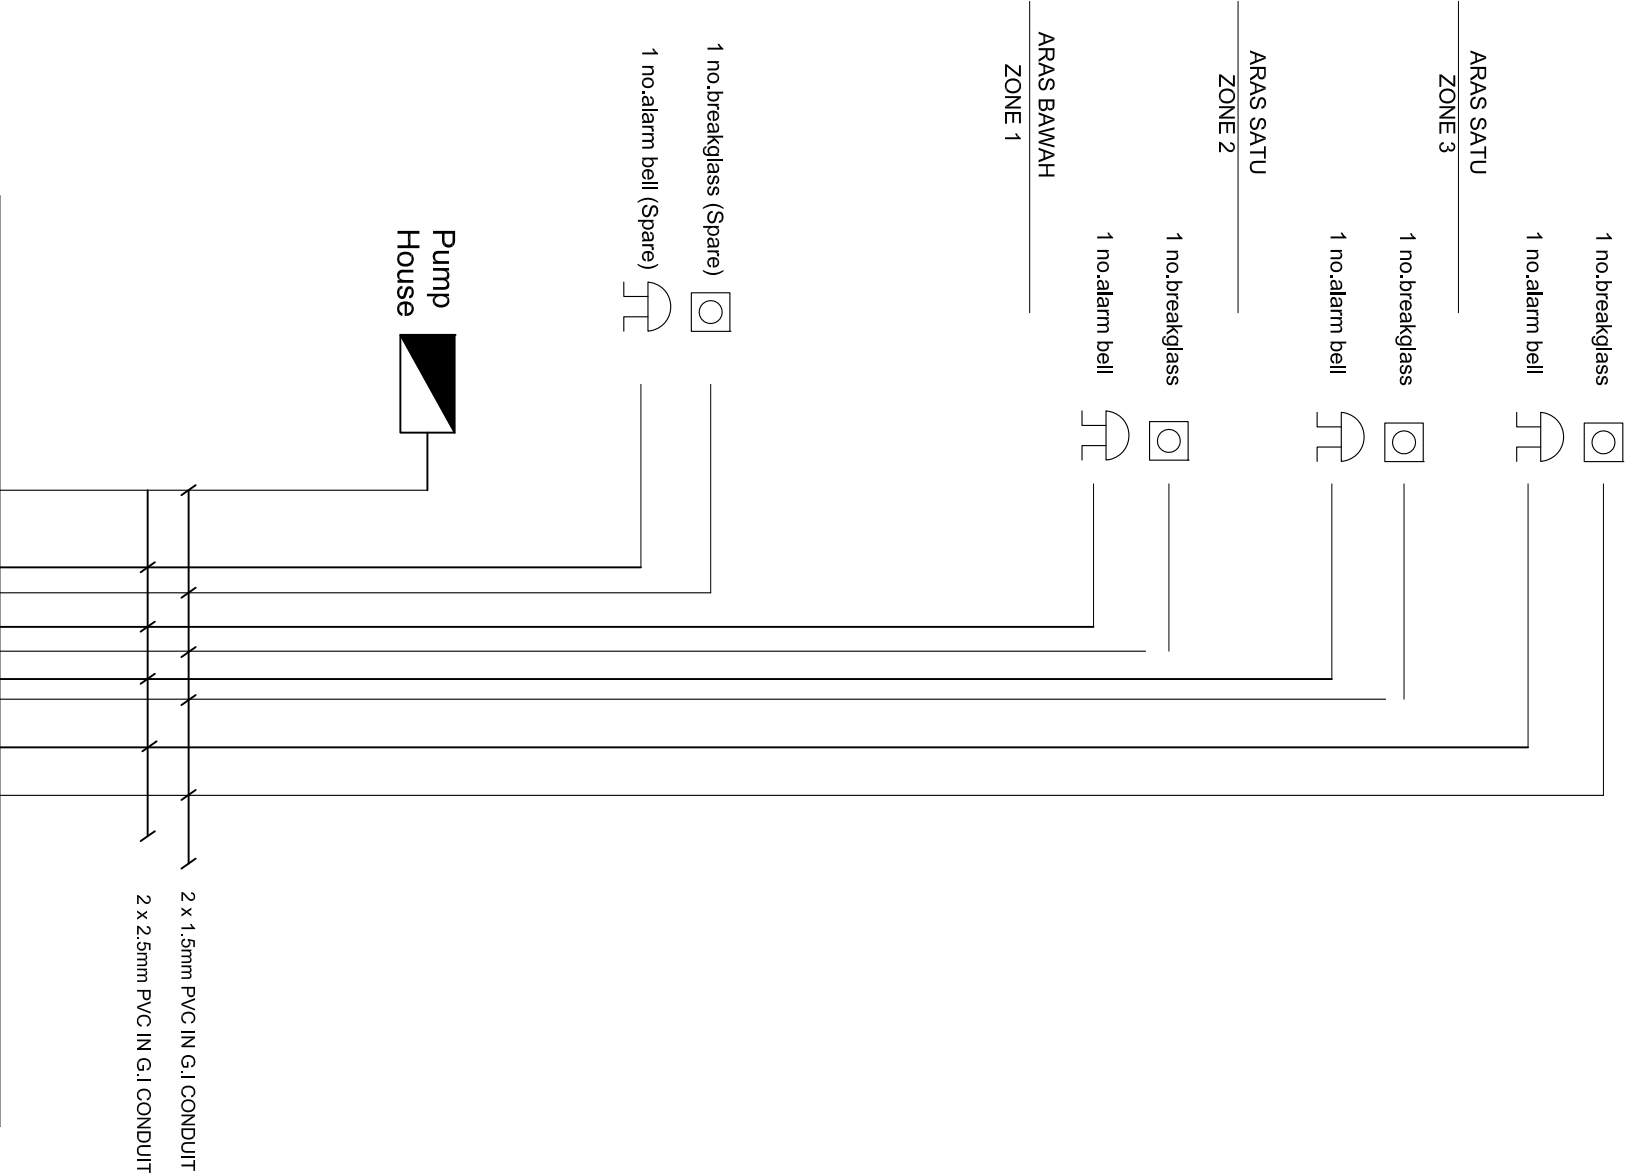

TYPICAL SCHEMATIC DIAGRAM FAP

- LEGEND
- SELECTOR SWITCH

SELECTOR SWITCH

INDICATING LIGHT

A

AMMETER

V

VOLTMETER


ALARM BELL

HEAT DETECTOR


BREAK GLASS

PUSH BUTTON


SWITCH BOARD

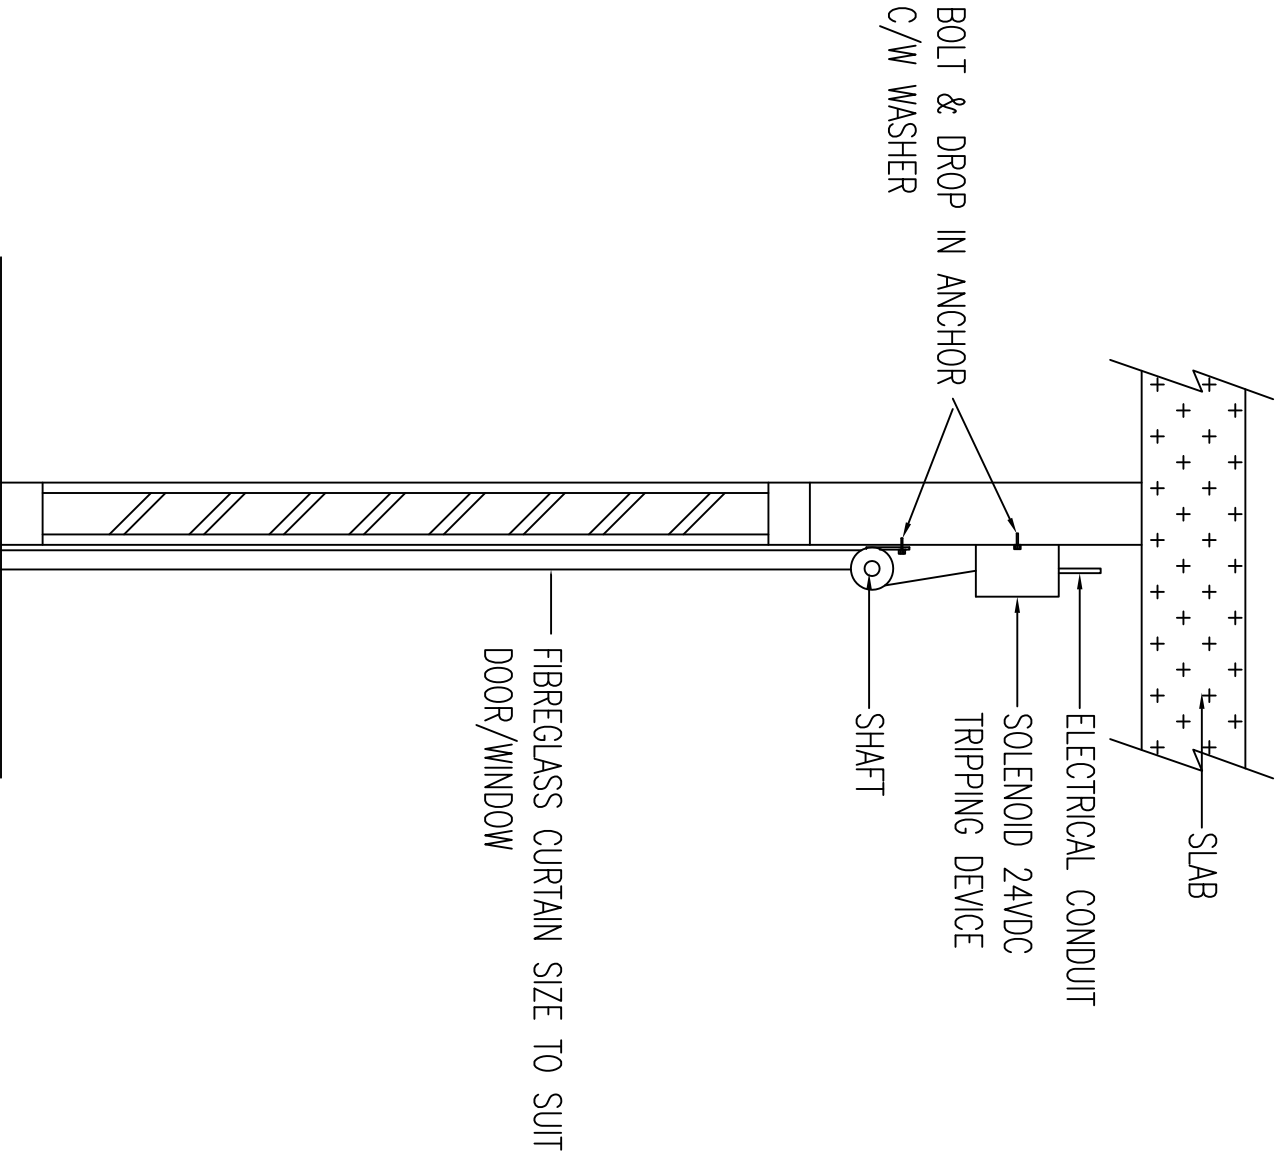

SIDE ELEVATION

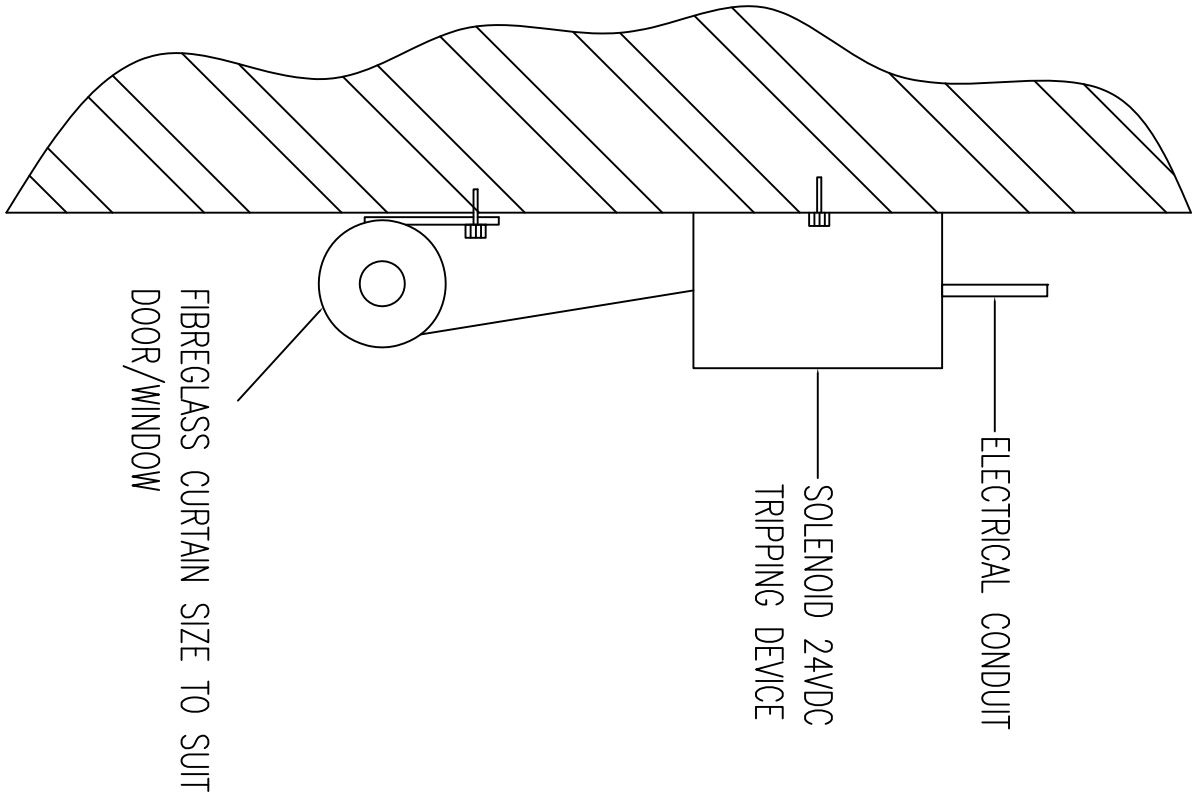

ASSEMBLY DRAWING

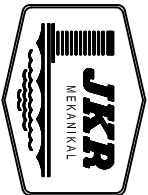


JASA KEPADA RAKYAT

CAWANGAN KEJURUTERAAN MEKANIKAL
Ibu Pejabat JKR Malaysia




FIRE FIGHTING SYSTEM

DETAIL OF FIRE CURTAIN

DATE	SCALE
2017	NTS
DRAWING NUMBER	
CKM/STD/FF/FIRE CURTAIN/REV/2017/01	

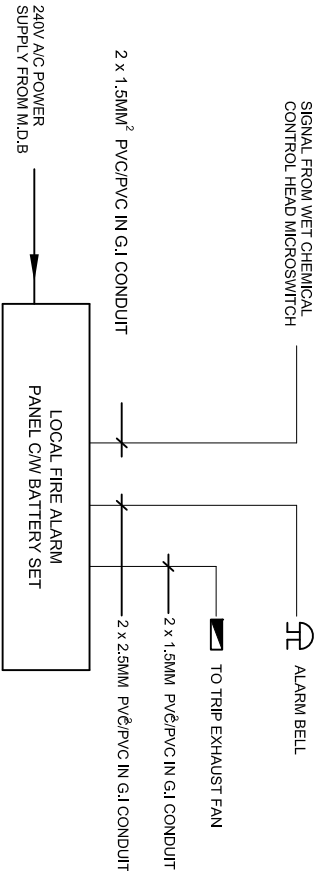

LINE DIAGRAM FOR WET CHEMICAL
CONTROL BOX AND FIRE ALARM PANEL

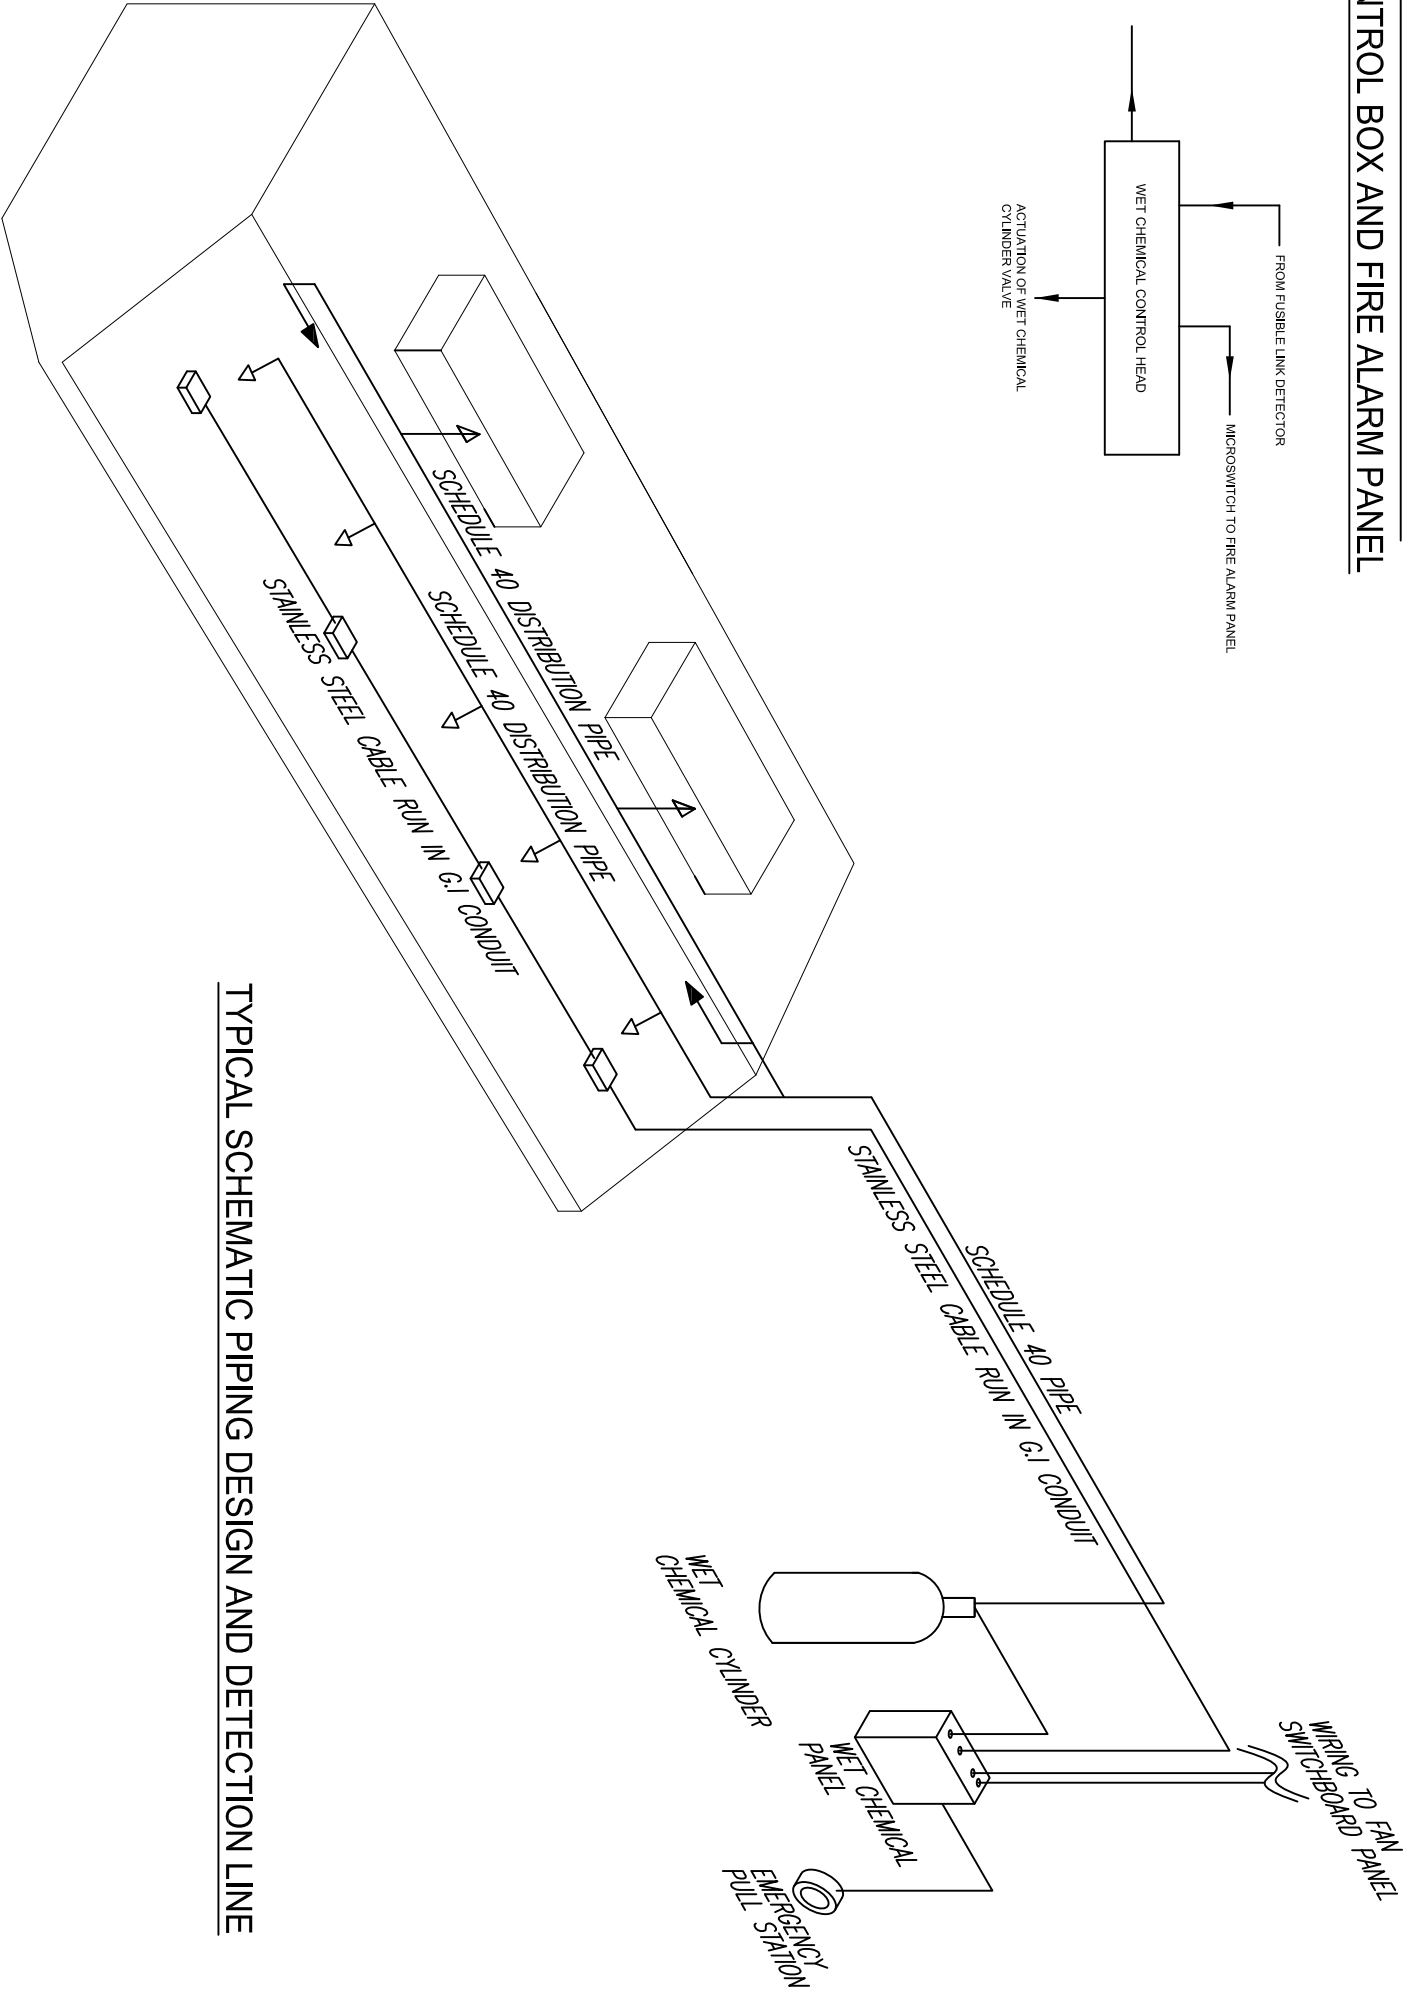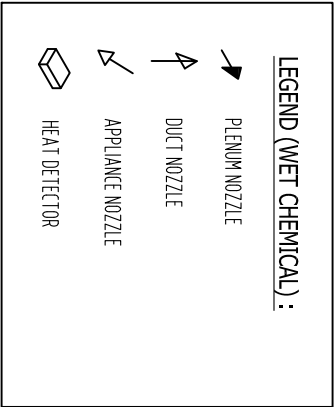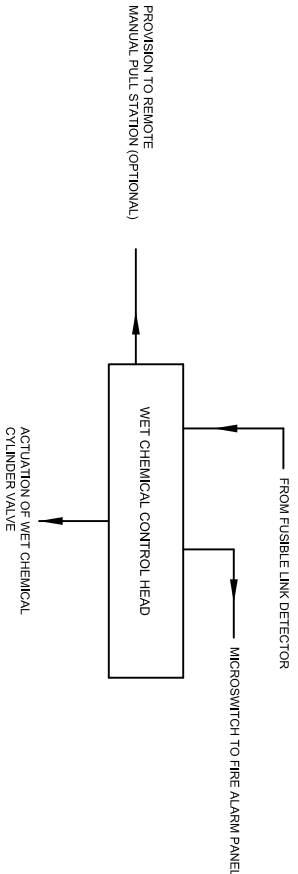

TYPICAL SCHEMATIC PIPING DESIGN AND DETECTION LINE




JASA KEPADA RAKYAT

CAWANGAN KEJURUTERAAN MEKANIKAL
Ibu Pejabat JKR Malaysia

FIRE FIGHTING SYSTEM


DETAIL OF WET CHEMICAL SYSTEM

DATE	SCALE
2017	NTS
DRAWING NUMBER	
CKM/STD/FF/WET CHEMICAL/REV2017/01	

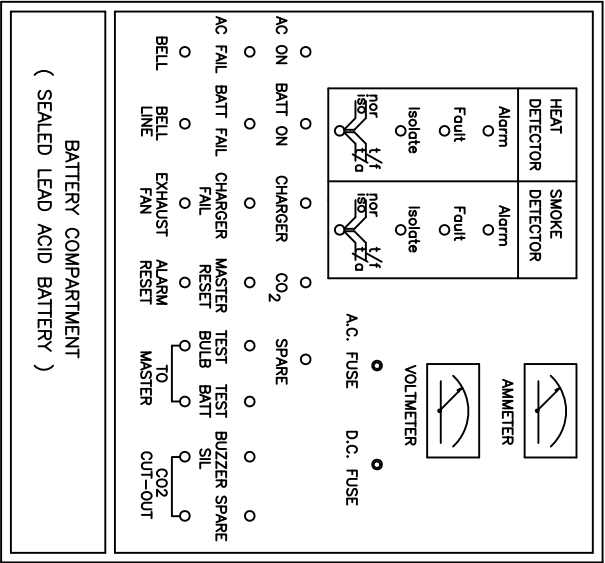


TYPICAL CONTROL PANEL DIAGRAM – 2 ZONE

- LEGEND FOR SYSTEM**
- ◻ ALARM BELL
 - ⊕ HEAT DETECTOR
 - Ⓢ SMOKE DETECTOR
 - ◼ MANUAL KEY SWITCH
 - ◼ INDICATING LIGHT
 - ◼ CO2 CONTROL PANEL (IP54)
 - ⊗ DISCHARGE NOZZLE
 - ⊗ EXHAUST FAN
 - ▬ FIRE CURTAIN
- FLUSH MOUNTED

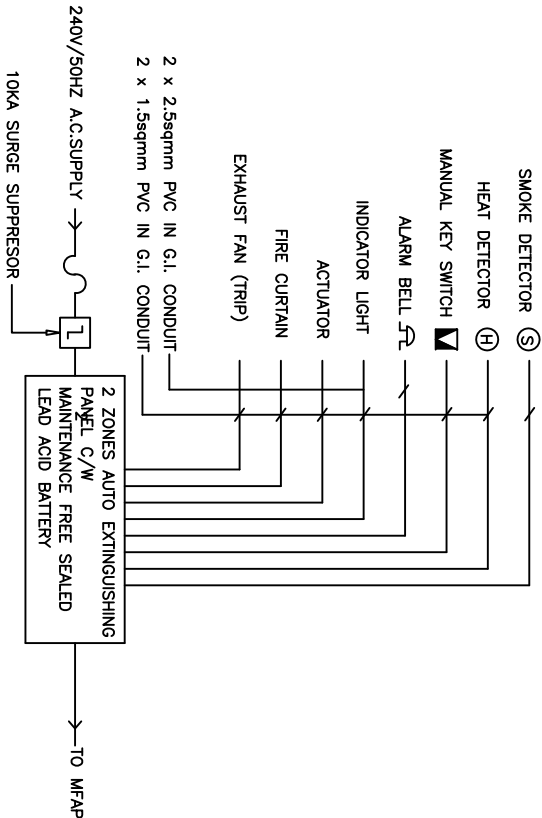

TYPICAL 2 ZONE AUTO EXTINGUISHING
FIRE SUPPRESSION SYSTEM

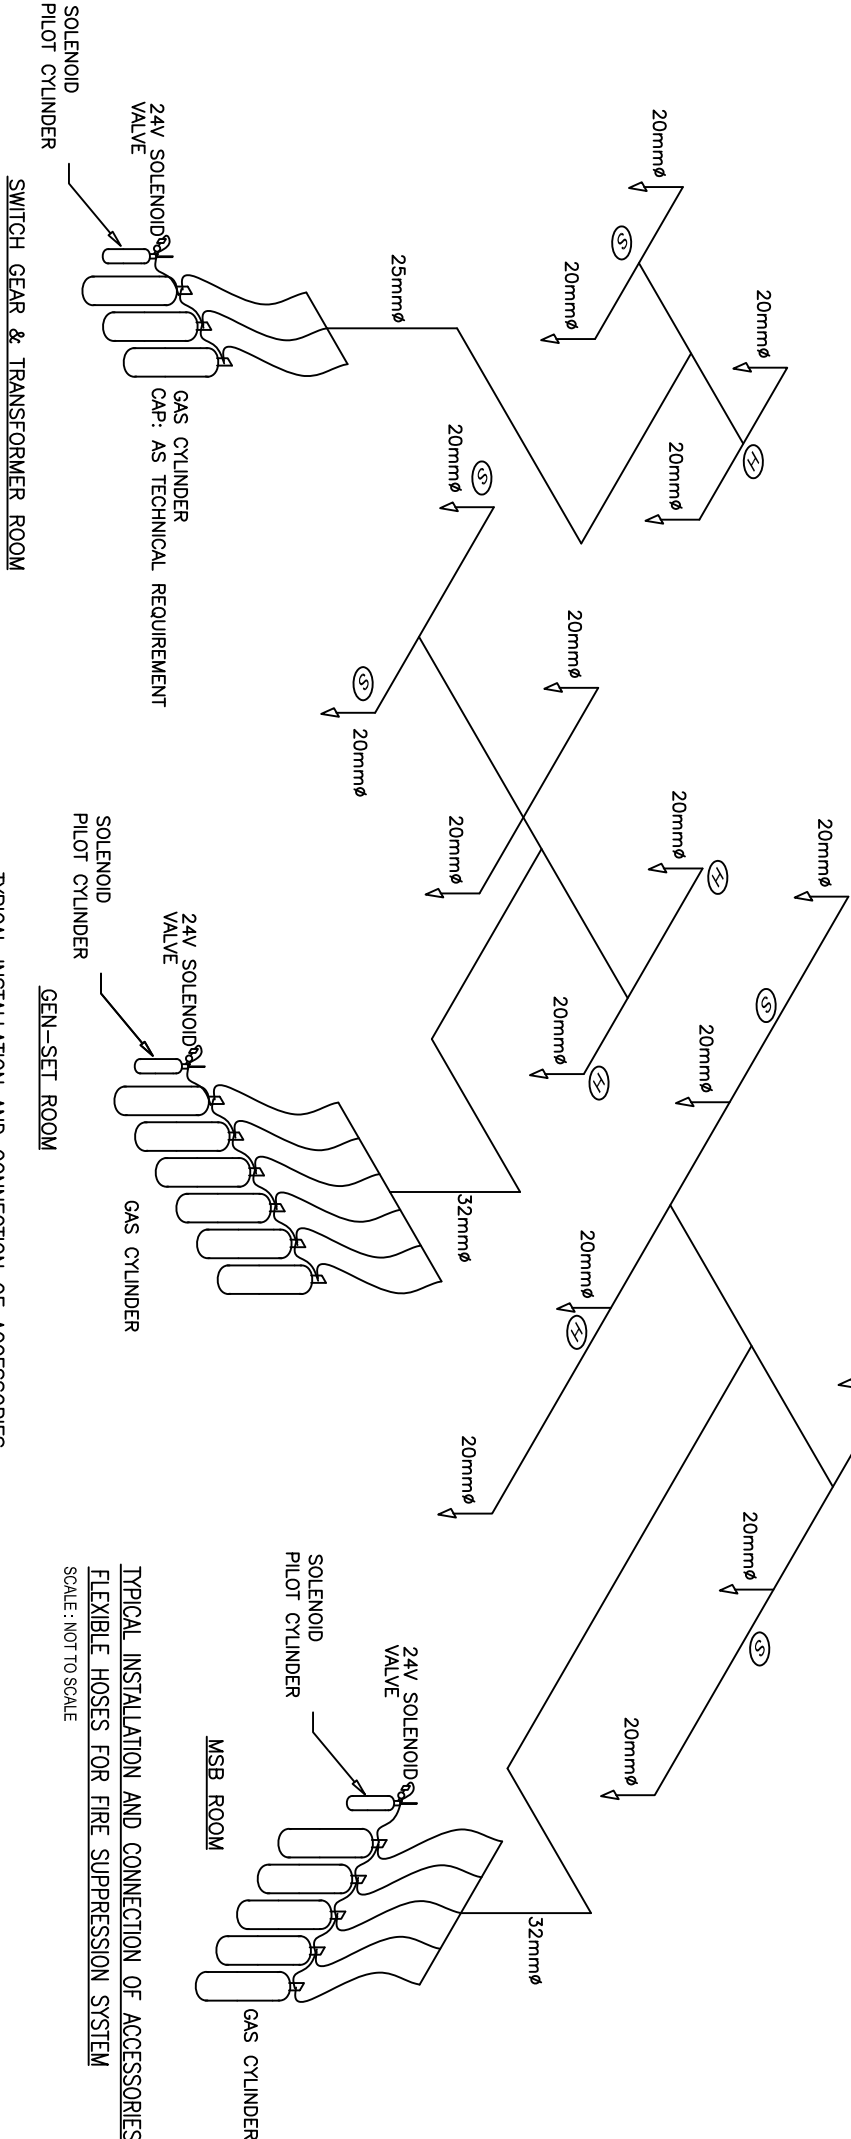


TYPICAL INSTALLATION AND CONNECTION OF ACCESSORIES
FLEXIBLE HOSES FOR FIRE SUPPRESSION SYSTEM

SCALE : NOT TO SCALE

TYPICAL INSTALLATION AND CONNECTION OF ACCESSORIES
FLEXIBLE HOSES FOR FIRE SUPPRESSION SYSTEM

SCALE : NOT TO SCALE

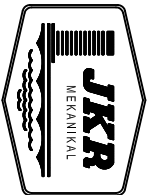

JASA KEPADA RAKYAT

CAWANGAN KEJURUTERAAN MEKANIKAL
Ibu Pejabat JKR Malaysia



FIRE FIGHTING SYSTEM

TYPICAL FIRE SUPPRESSION SYSTEM

NOTE :

CONTROL STRATEGY FOR LIFT LOBBY PRESSURISATION SYSTEM

- a) UPON RECEIPT OF A FIRE SIGNAL AT THE FAN CONTROL PANEL, THE PRESSURISATION FAN SHALL AUTOMATICALLY START.
 - b) A FIRE SIGNAL SHALL BE SENT TO OPEN THE MOTORISED DAMPER ON THE SUPPLY DUCT TO THE LIFT LOBBY FOR THE LEVEL ON FIRE, THE LEVEL IMMEDIATELY ABOVE AND BELOW. THE MOTORISED DAMPER THE LEVEL ON FIRE, THE LEVEL IMMEDIATELY ABOVE AND BELOW. THE MOTORISED DAMPER ON ALL OTHER LEVELS SHALL REMAIN CLOSED.
 - c) A DIFFERENTIAL SENSOR IN THE AIR SHAFT (INSTALLED AT 2/3 DISTANCE DOWN THE AIR SHAFT) SHALL SENSE THE TOTAL AIR DEMAND AND MODULATE A MOTORISED PRESSURE RELIEF DAMPER (PRD) LOCATED ON THE DUCT AT THE FAN DISCHARGE TO MAINTAIN THE REQUIRED AIR DEMAND.
 - d) A PRESSURE RELIEF DAMPER INSTALLED ON THE WALL BETWEEN THE LIFT LOBBY AND THE ADJACENT UNPRESSURISED SPACE AT EACH LIFT LOBBY SHALL BE SET TO MAINTAIN A DIFFERENTIAL PRESSURE OF 50 Pa BETWEEN THE LIFT LOBBY AND ADJCENT UNPRESSURISED SPACE.
- ALL PRESSURISATION SHALL BE LINKED TO A REMOTE START-STOP PANEL LOCATED AT THE FIRE CONTROL ROOM WHERE THE FAN CAN BE STARTED, STOPPED AND THE "RUN" & "TRIP" STATUS CAN BE MONITORED.

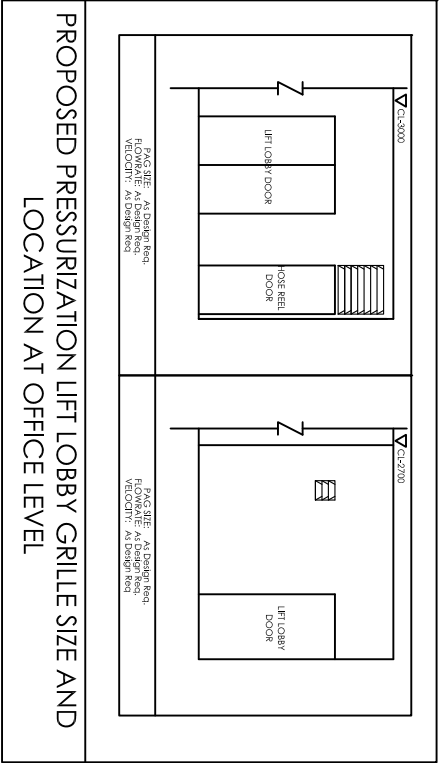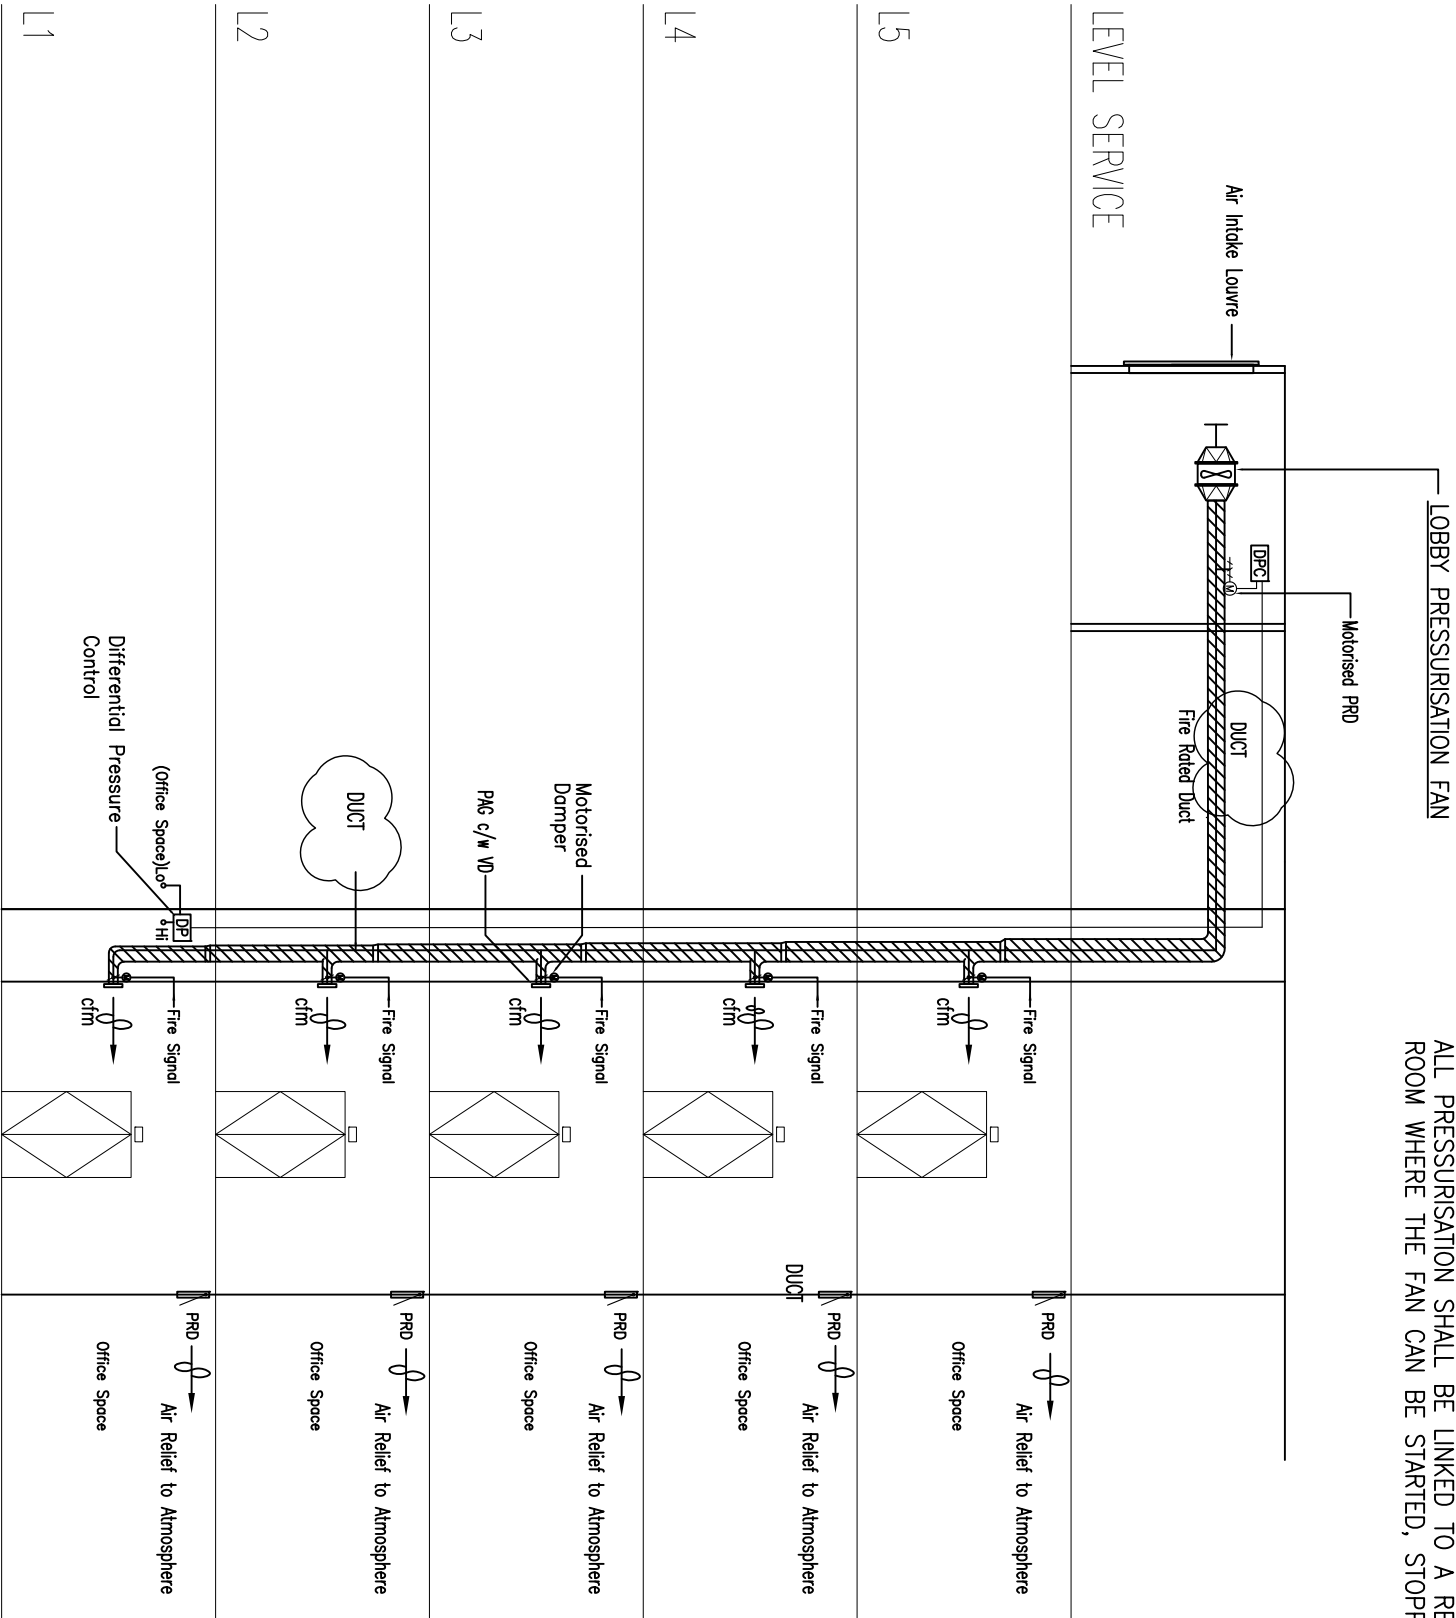

LEGEND :

- PRD (MOTORISED) PRESSURE RELIEF DAMPER (MOTORISED)
- PRD (COUNTER WEIGHT) PRESSURE RELIEF DAMPER (COUNTER WEIGHT)
- MOTORISED DAMPER
- DIFFERENTIAL PRESSURE SENSOR C/W COPPER TUBING
- DIFFERENTIAL PRESSURE CONTROLLER



CAWANGAN KEJURUTERAAN MEKANIKAL
Ibu Pejabat JKR Malaysia

FIRE FIGHTING SYSTEM

TYPICAL PRESSURIZATION SYSTEM(LOBBY)



TYPICAL SCHEMATIC LIFT LOBBY PRESSURIZATION SYSTEM

DATE	SCALE
2017	NTS
DRAWING NUMBER	
CKMSTD/FF/PRESSURIZATION/REV2017/01	

NOTE :

CONTROL STRATEGY FOR STAIRCASE PRESSURISATION SYSTEM

- a) UPON RECEIPT OF A FIRE SIGNAL AT THE FAN CONTROL PANEL, THE PRESSURISATION FAN SHALL AUTOMATICALLY START.
- b) A DIFFERENTIAL SENSOR (INSTALLED AT 2/3 DISTANCE DOWN THE STAIRCASE) SHALL MEASURE THE PRESSURE DIFFERENTIAL BETWEEN THE STAIRCASE AND THE ADJACENT UNPRESSURED SPACE.
- c) THE MEASURED PRESSURE DIFFERENTIAL SHALL BE USED TO MODULATE A MOTORISED PRESSURE RELIEF DAMPER (PRD) LOCATED ON THE DUCT AT THE FAN DISCHARGE TO MAINTAIN A PRESSURE DIFFERENTIAL OF 50Pa BETWEEN THE STAIRCASE AND THE ADJACENT UNPRESSURED SPACE.

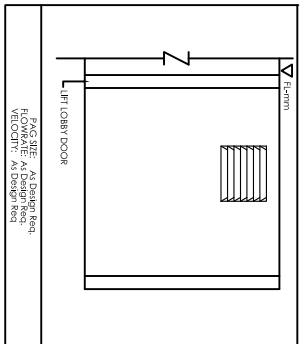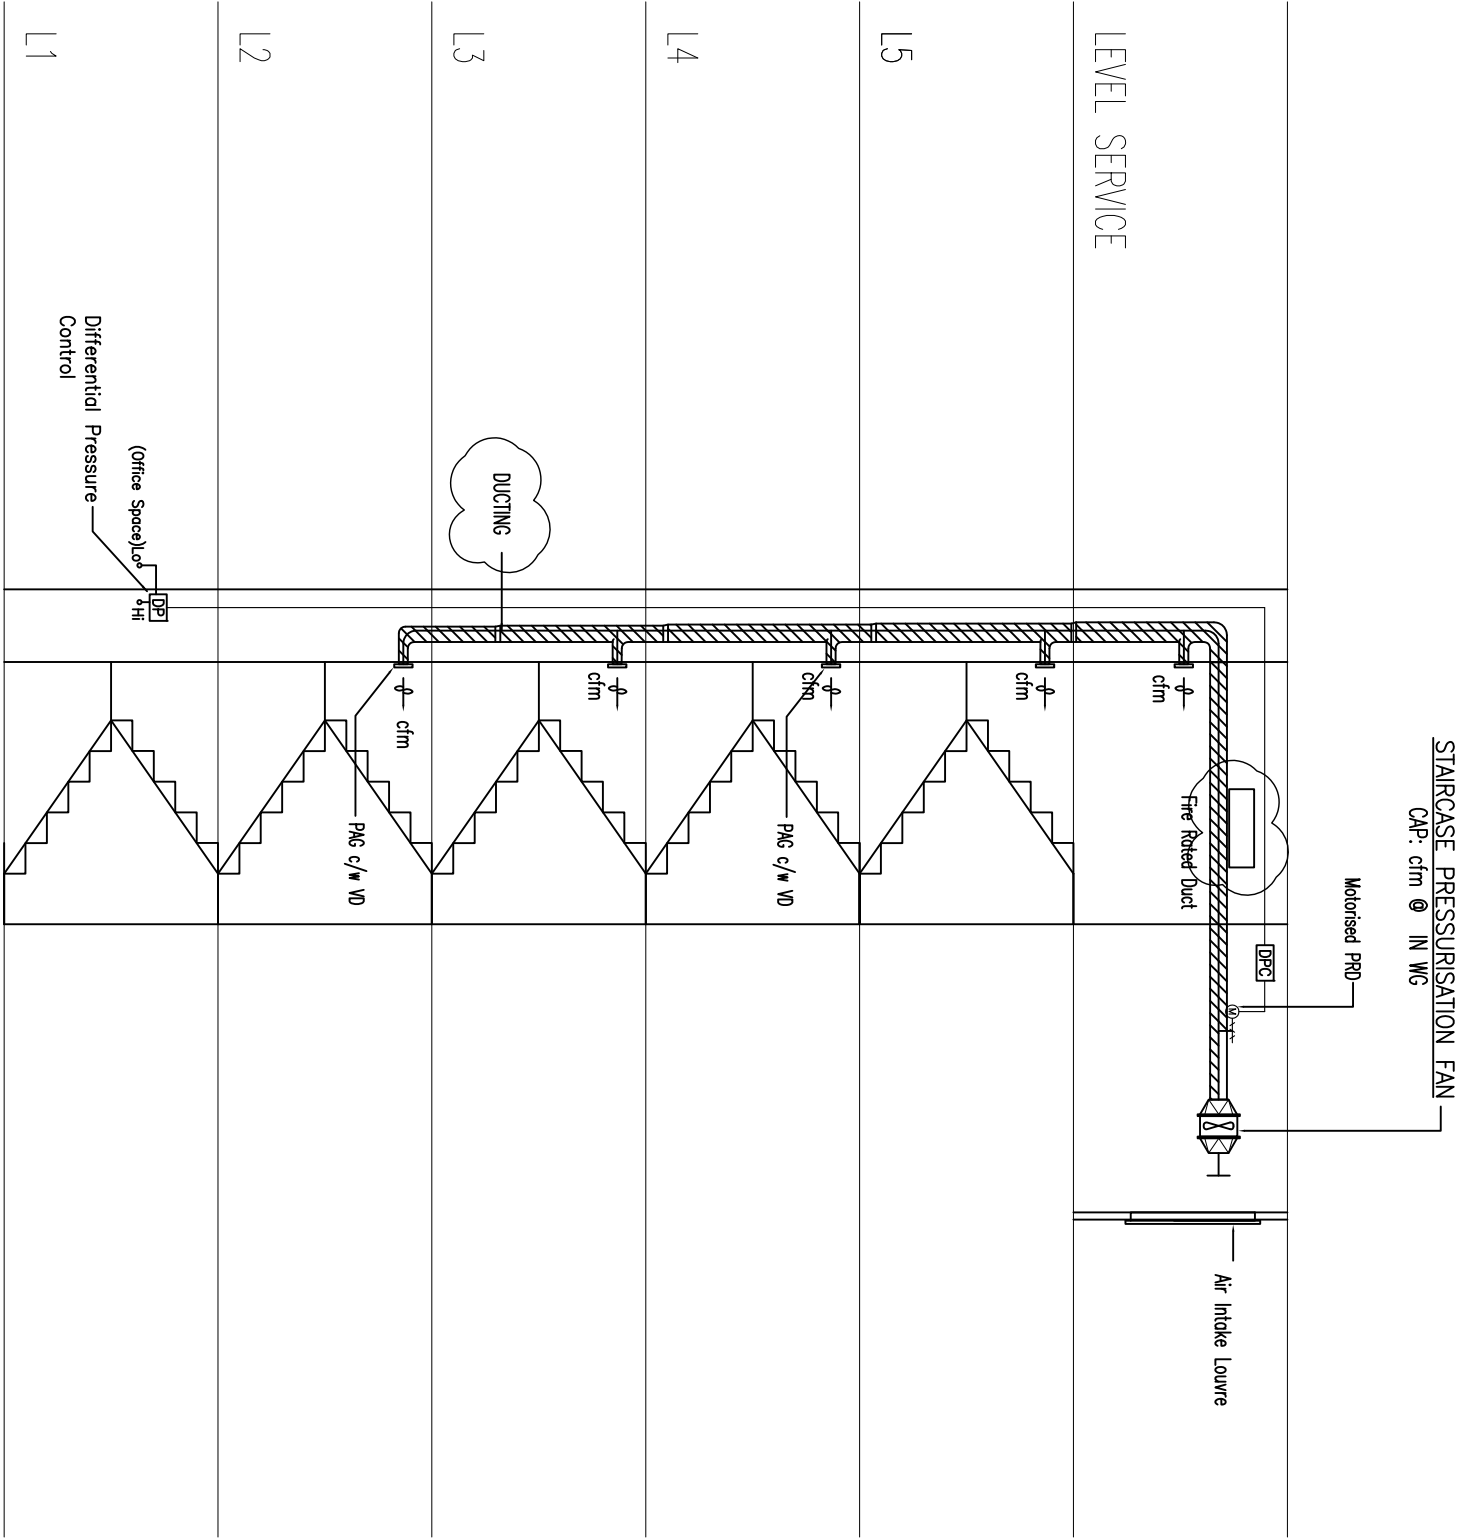

TYPICAL PRESSURIZATION
LIFT LOBBY GRILL SIZE
AND LOCATION AT STAIRCASE

LEGEND :

- ① PRD (MOTORISED)
- PRD PRESSURE RELIEF DAMPER (COUNTER WEIGHT)
- MOTORISED DAMPER
- DIFFERENTIAL PRESSURE SENSOR C/W COPPER TUBING
- DIFFERENTIAL PRESSURE CONTROLLER
- PAG c/w VD PRESSURE AIR GRILLE C/W VOLUME DAMPER



JASA KEPADA RAKYAT

CAWANGAN KEJURUTERAAN MEKANIKAL
Ibu Pejabat JKR Malaysia


FIRE FIGHTING SYSTEM

TYPICAL PRESSURISATION SYSTEM
(STAIRCASE)



DATE	SCALE
2017	NTS

DRAWING NUMBER
CKM/STD/FF/PRESURIZATION/REV2017/02



TYPICAL SCHEMATIC STAIRCASE PRESSURIZATION SYSTEM

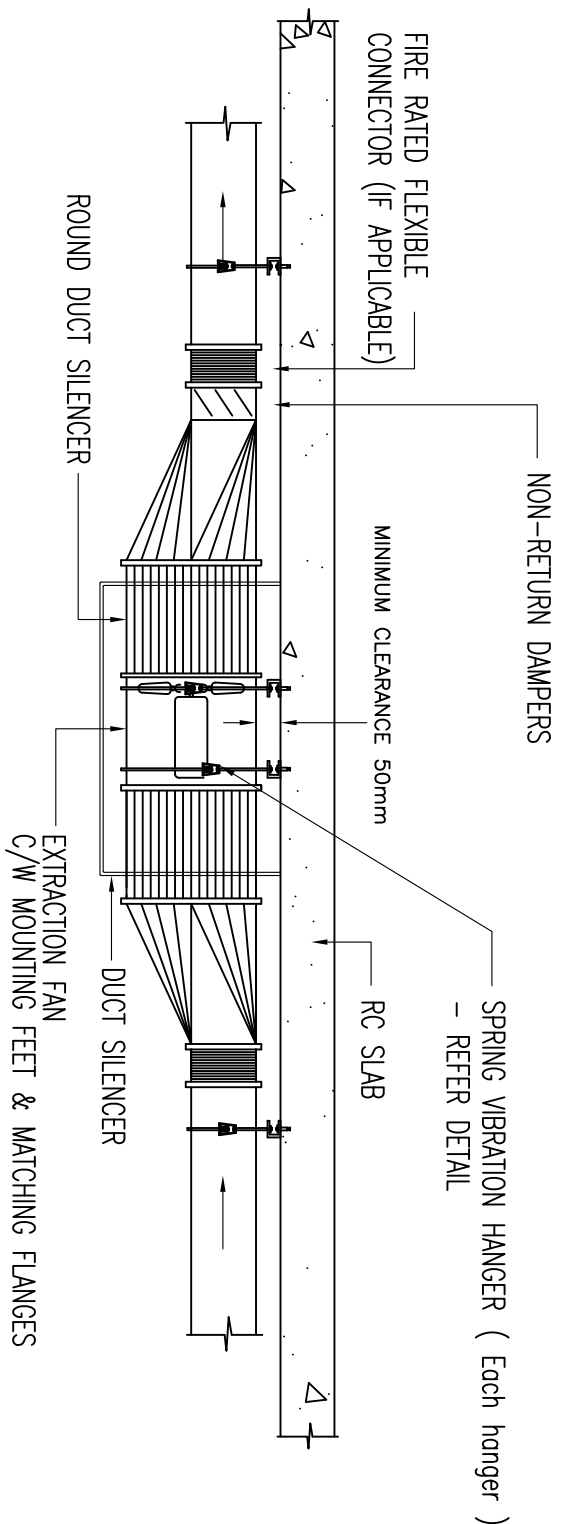

VENTILATION SUPPLY & EXHAUST FAN
DETAILS WITH DUCT SILENCERS

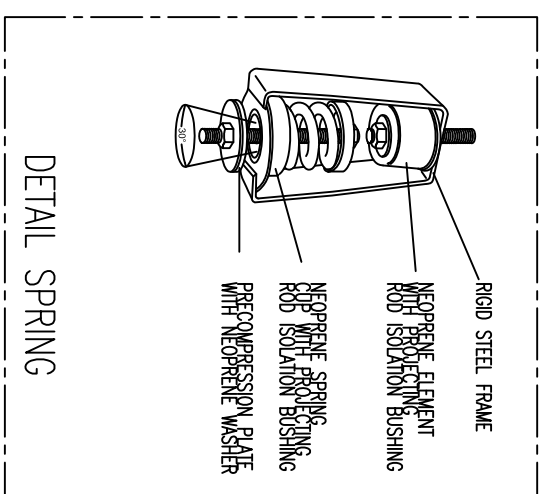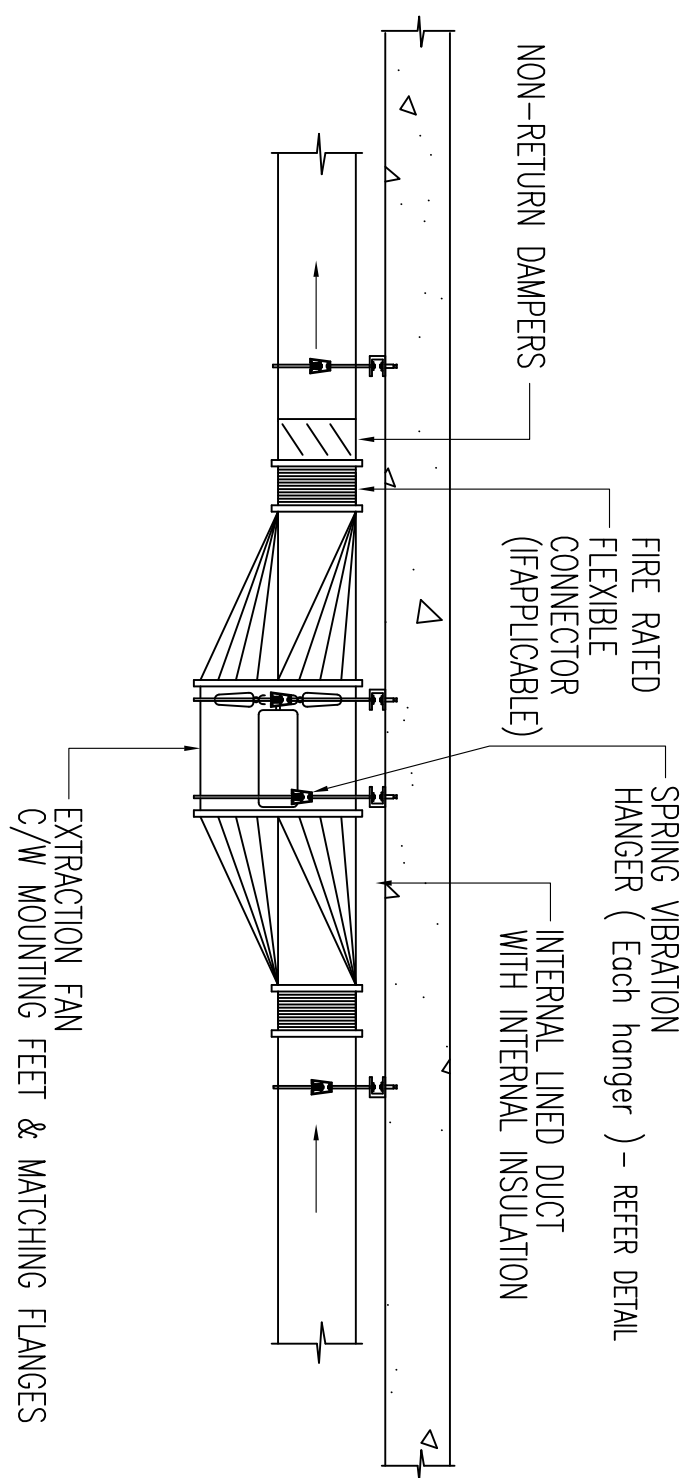

GENERAL VENTILATION FAN DETAILS

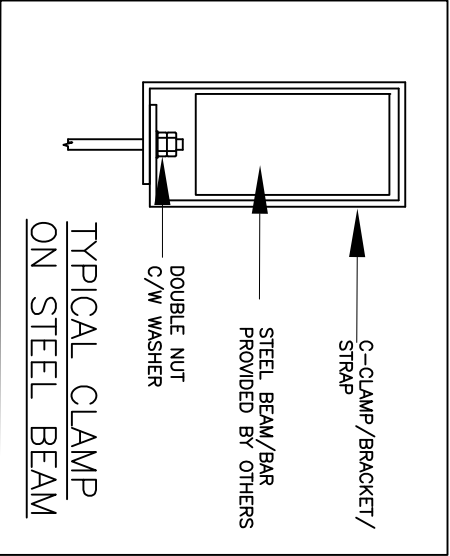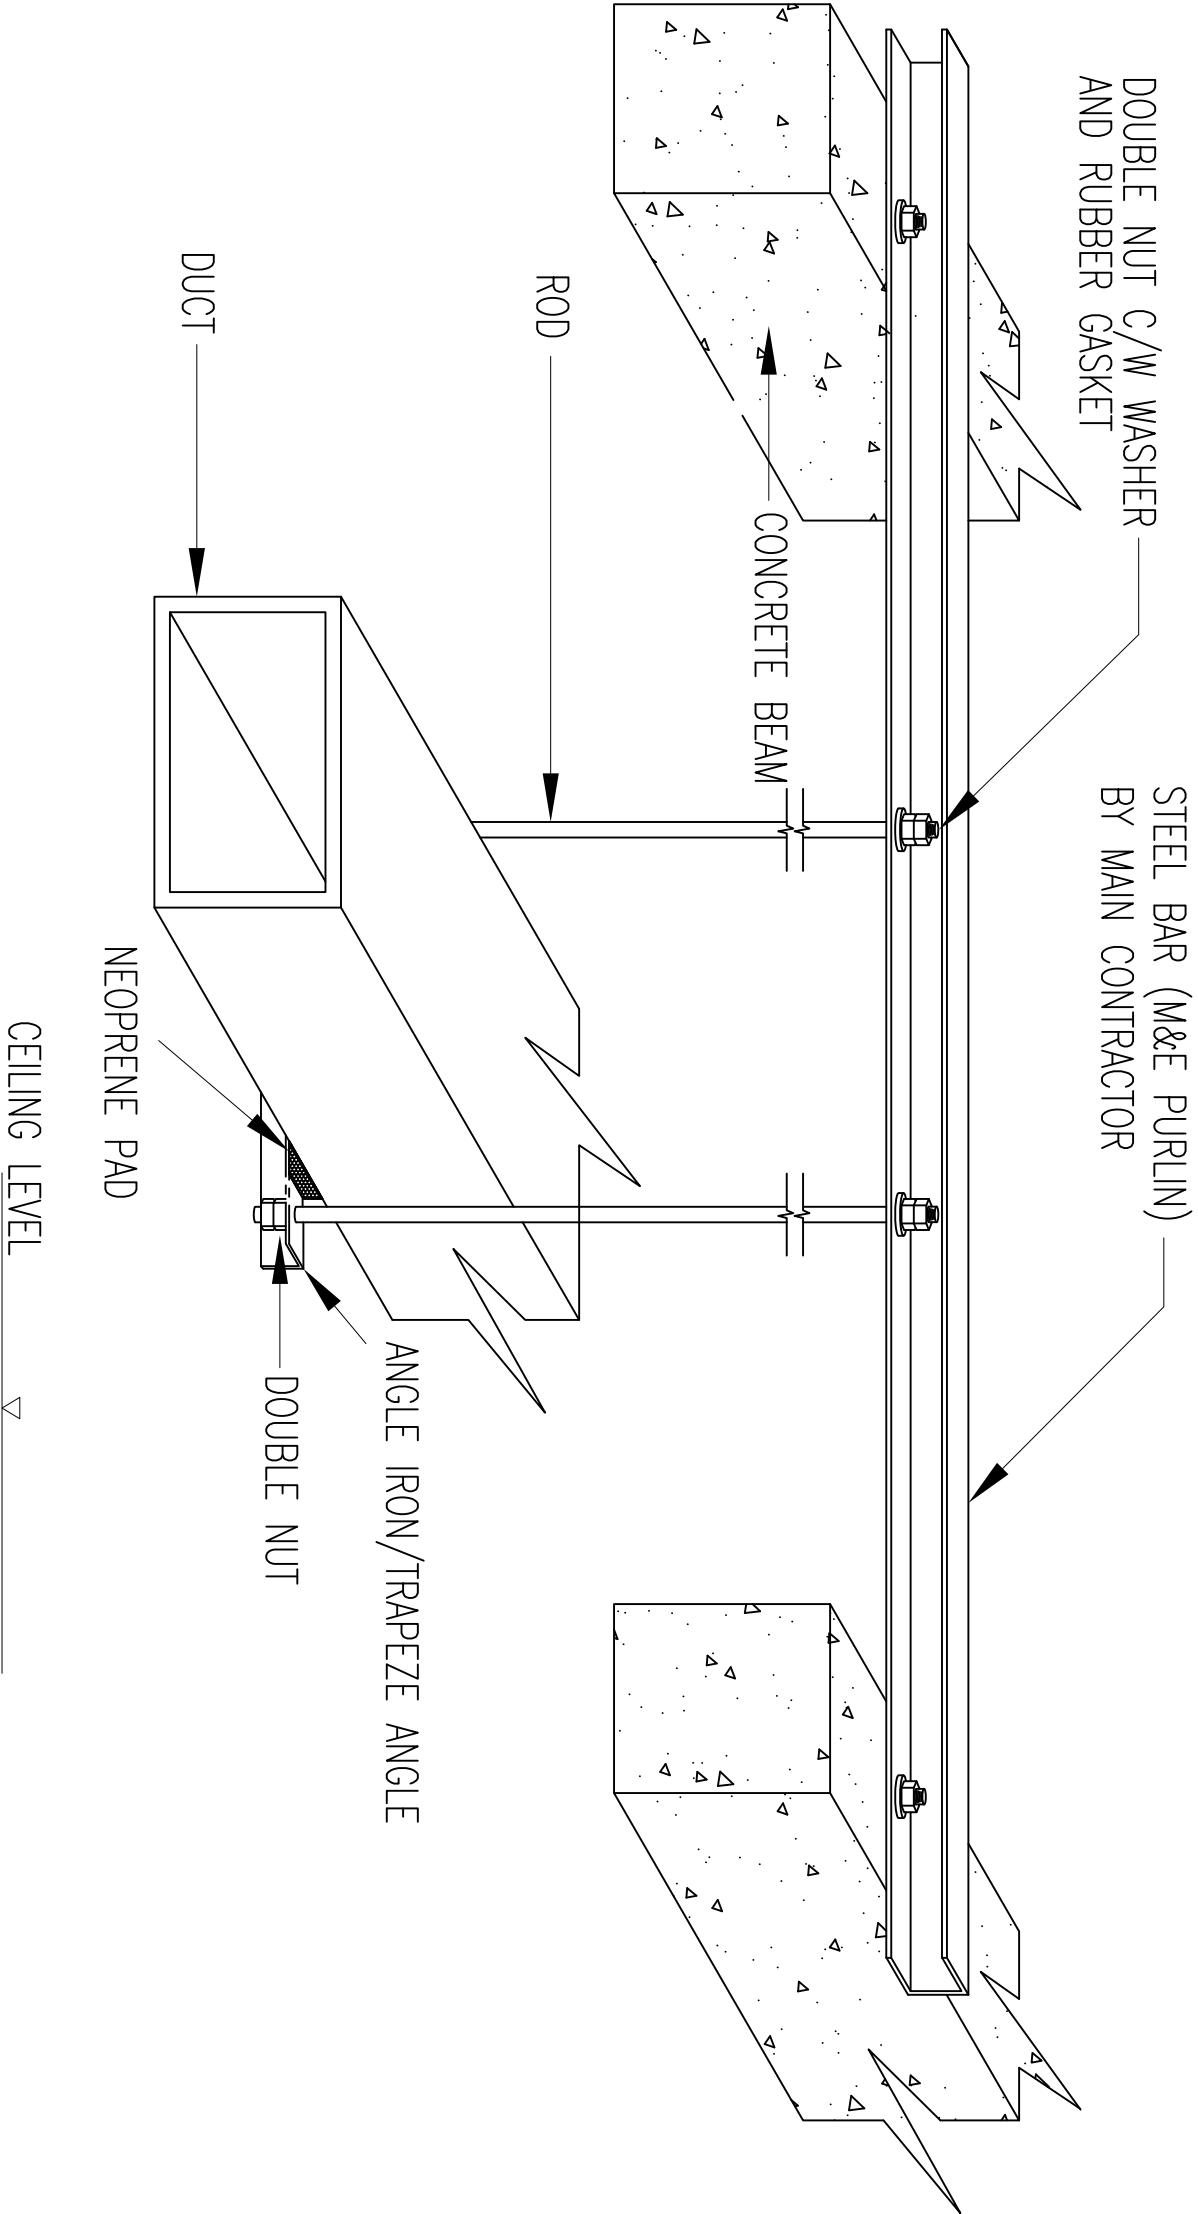

TYPICAL DUCT / DIFFUSER SUPPORT AND HANGER (UNDER THE ROOF)

TYPICAL DUCT SUPPORT AND HANGER (UNDER THE ROOF)






JASA KEPADA RAKYAT

CAWANGAN KEJURUTERAAN MEKANIKAL
Ibu Pejabat JKR Malaysia

FIRE FIGHTING SYSTEM

TYPICAL TYPE OF DUCT INSTALLATION

DATE	SCALE
2017	NTS
DRAWING NUMBER	
CKM/STD/FF/PRESURIZATION/REV2017/05	

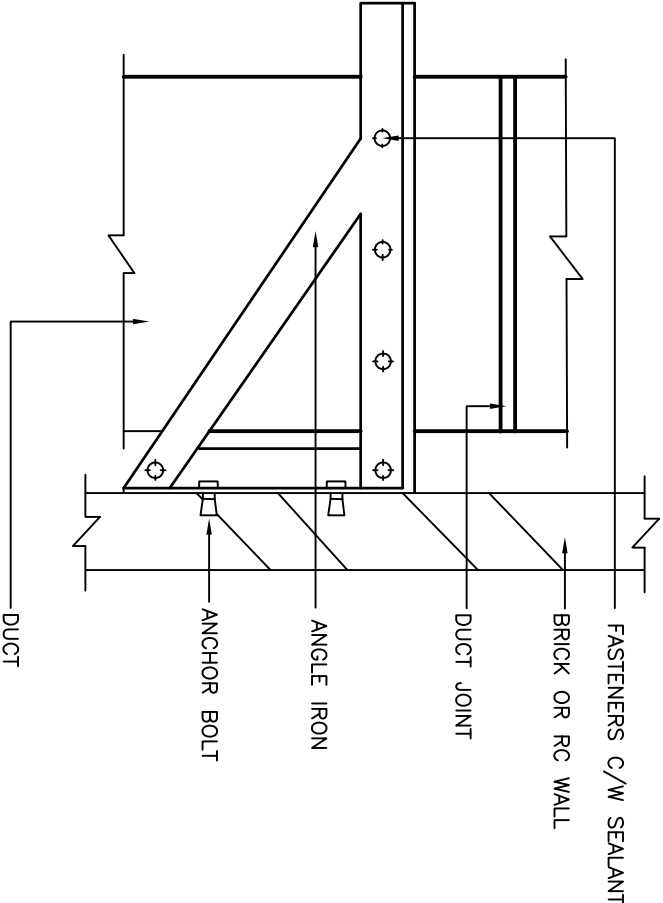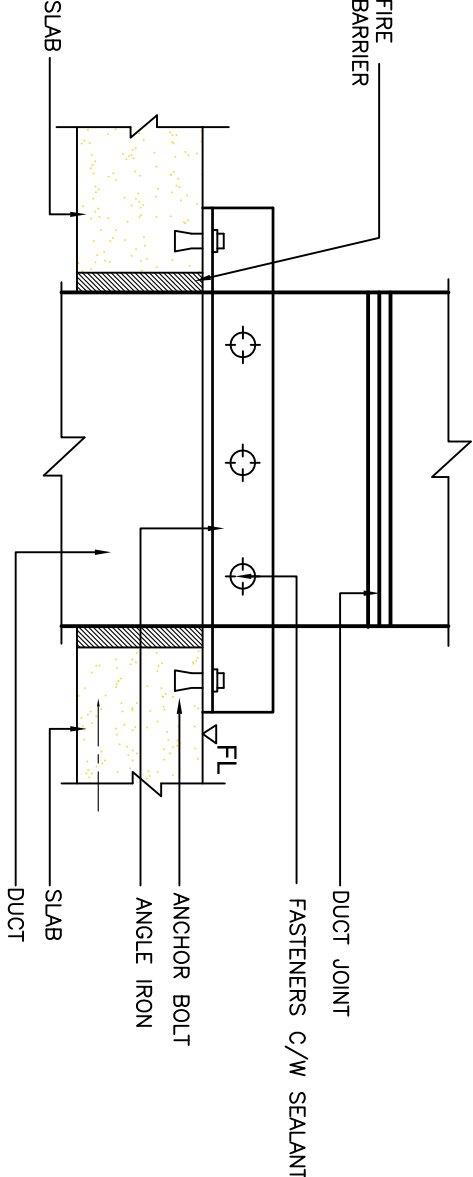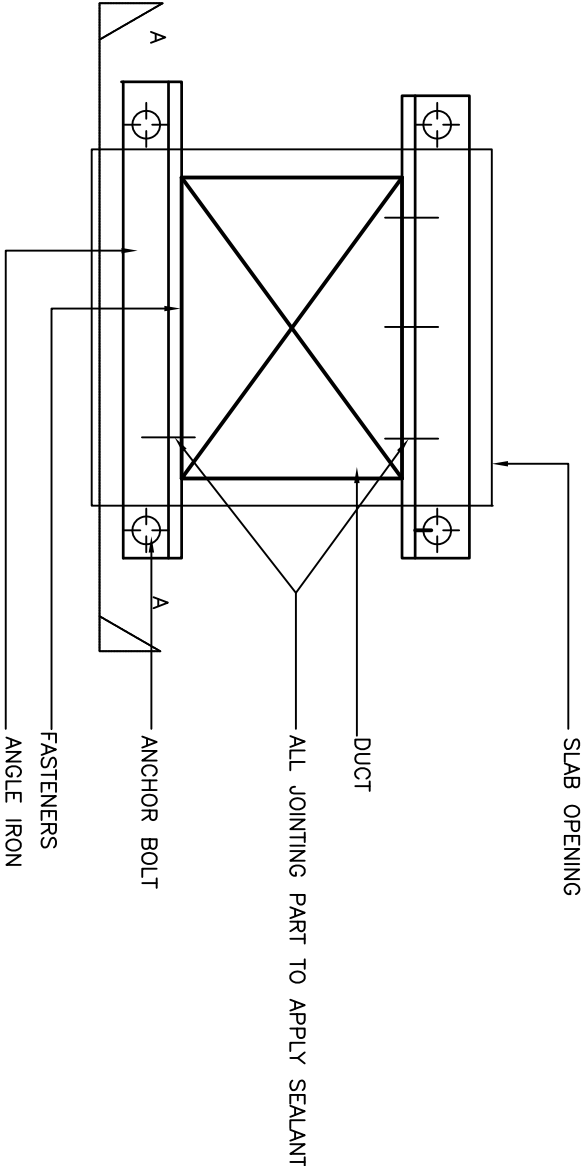

DUCT SUPPORT FOR DUCT RISER

ANCHORING INTO R.C WALL OR BRICKWALL




JASA KEPADA RAKYAT
CAWANGAN KEJURUTERAAN MEKANIKAL
Ibu Pejabat JKR Malaysia

FIRE FIGHTING SYSTEM

TYPICAL TYPE OF DUCT INSTALLATION

DATE	SCALE
2017	NTS
DRAWING NUMBER	
CKM/STD/FF/PRESURIZATION/REV2017/06	

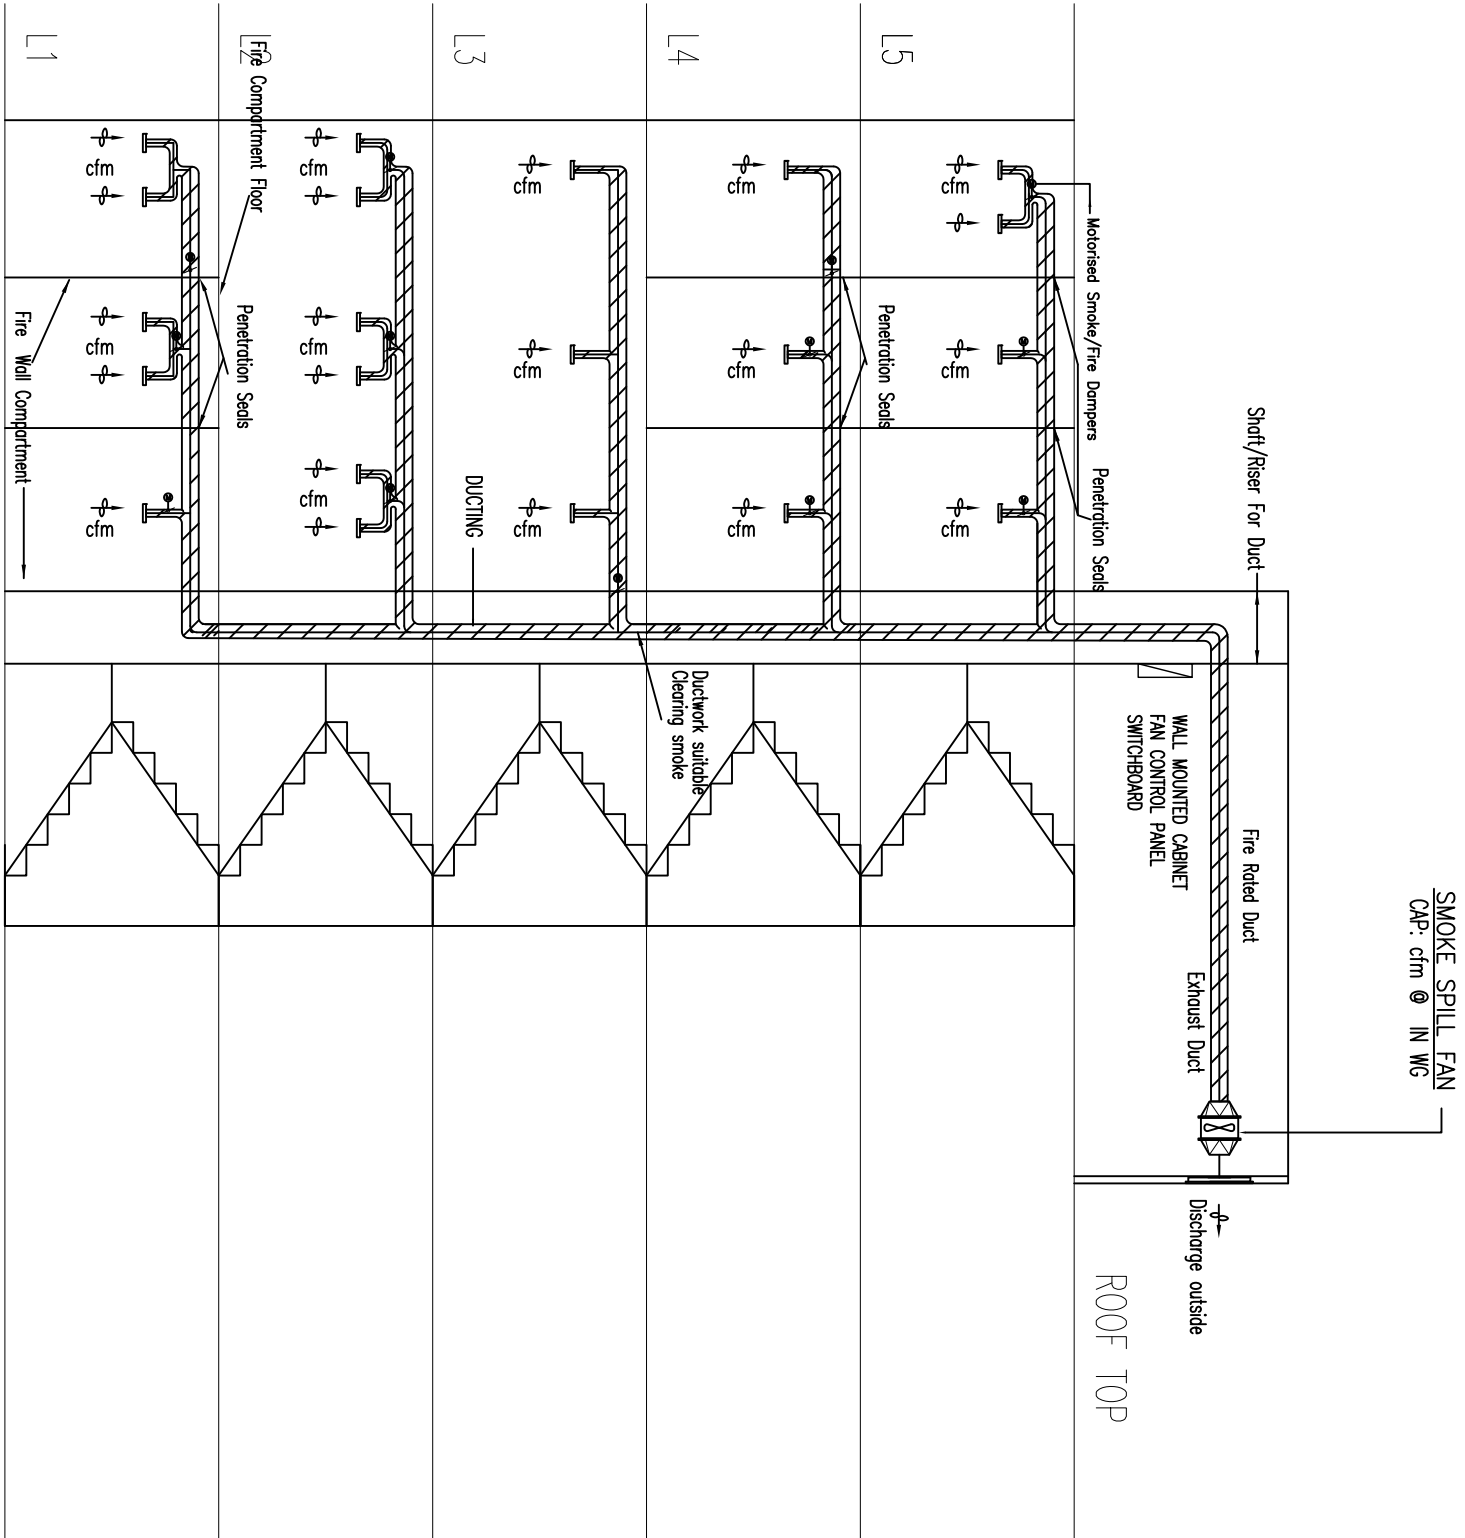

LEGEND :

 MOTORISED DAMPER




JASA KEPADA RAKYAT
CAWANGAN KEJURUTERAAN MEKANIKAL
Ibu Pejabat JKR Malaysia

FIRE FIGHTING SYSTEM



TYPICAL INSTALLATION
SMOKE SPILL SYSTEM

DATE	SCALE
2017	NTS
DRAWING NUMBER	
CKMSTD/FF/SMOKE SPILL/REV/2017/01	

TYPICAL INSTALLATION SMOKE SPILL SYSTEM

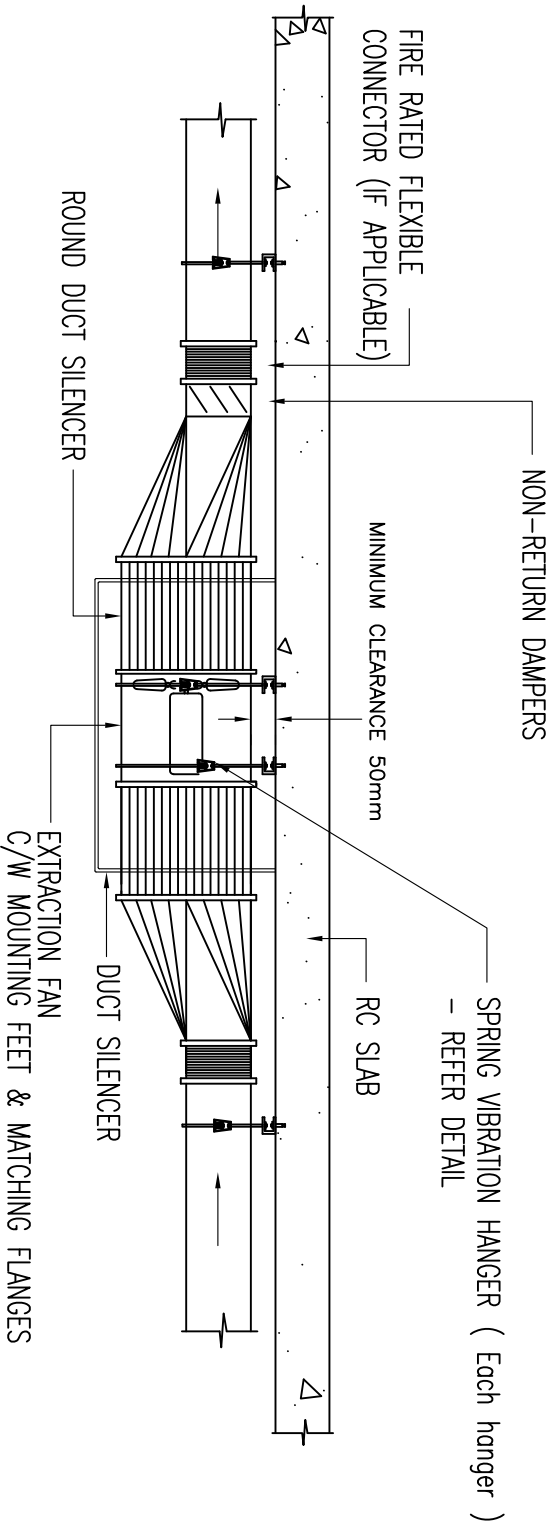

VENTILATION SUPPLY & EXHAUST FAN
DETAILS WITH DUCT SILENCERS

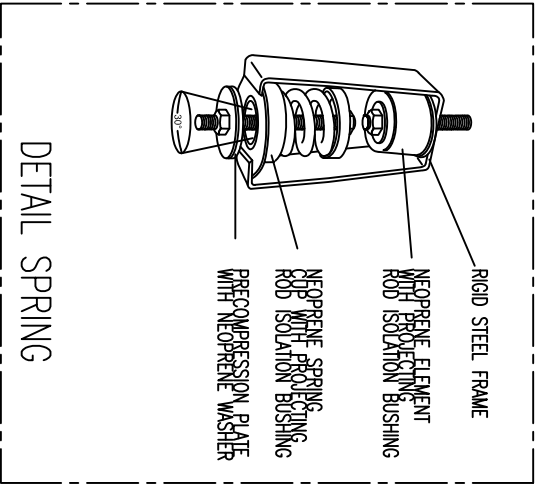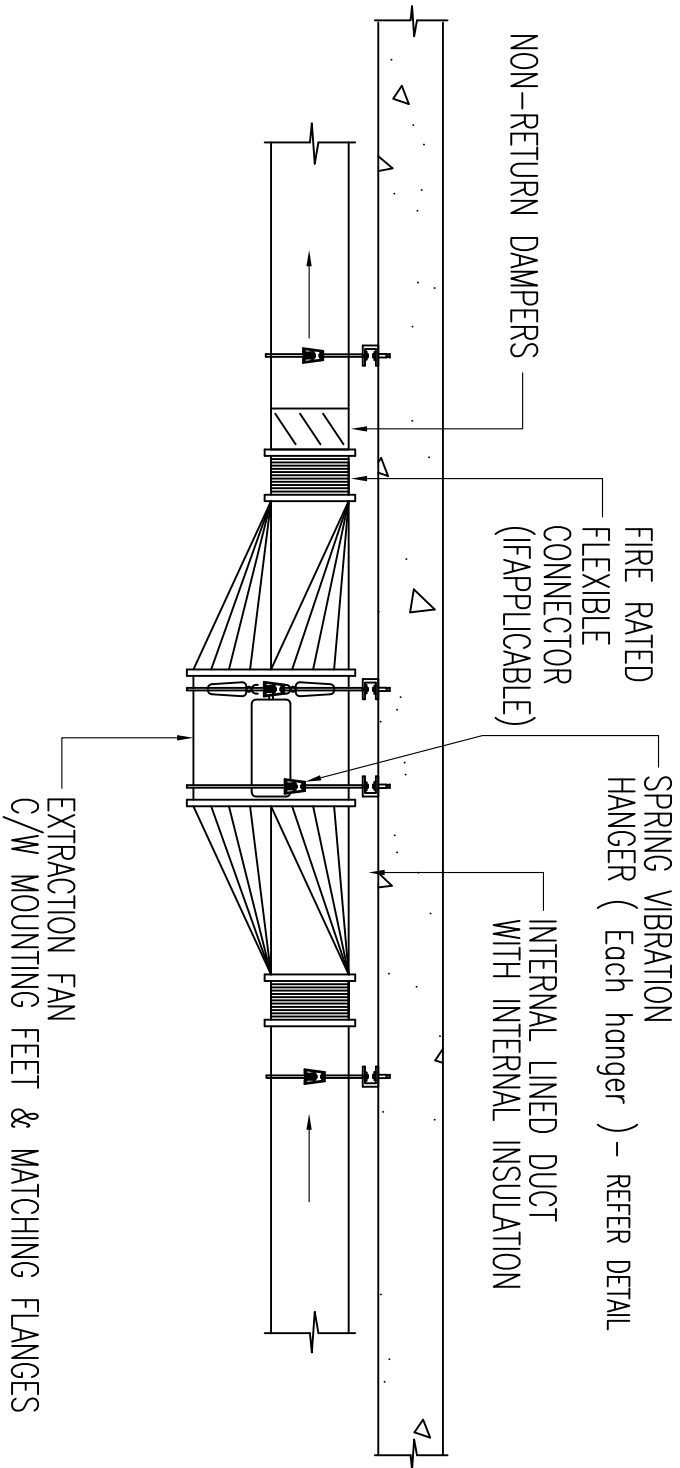


JASA KEPADA RAKYAT

CAWANGAN KEJURUTERAAN MEKANIKAL
Ibu Pejabat JKR Malaysia



FIRE FIGHTING SYSTEM

TYPICAL TYPE OF FAN INSTALLATION

DATE	SCALE
2017	NTS
DRAWING NUMBER	
CKM/STD/FF/SMOKE SPILL/REV2017/02	

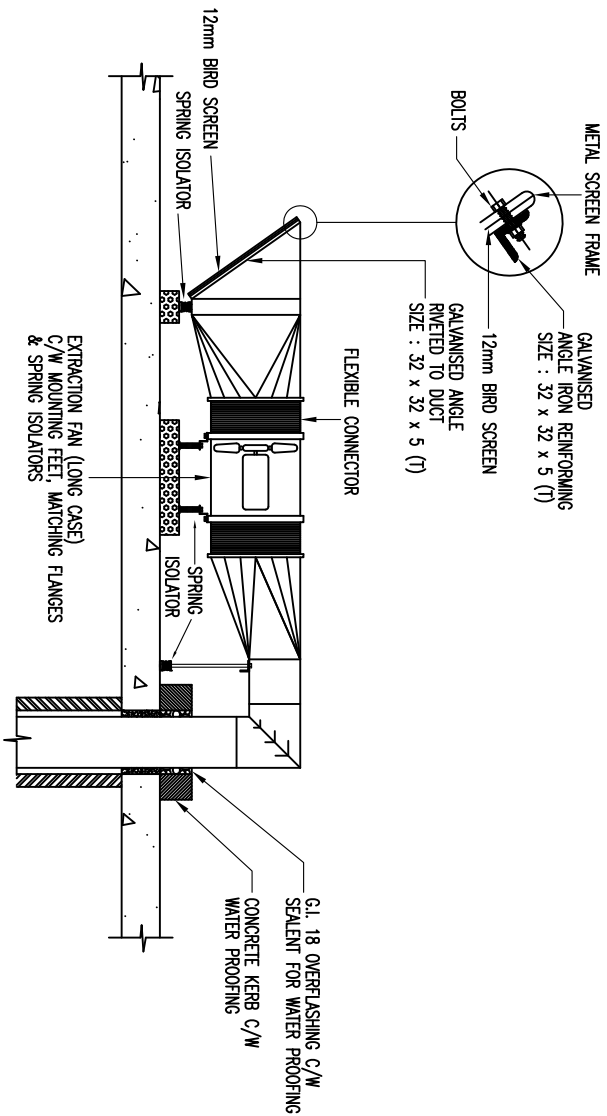

ROOF MOUNTED EXTRACTION FAN DETAILS

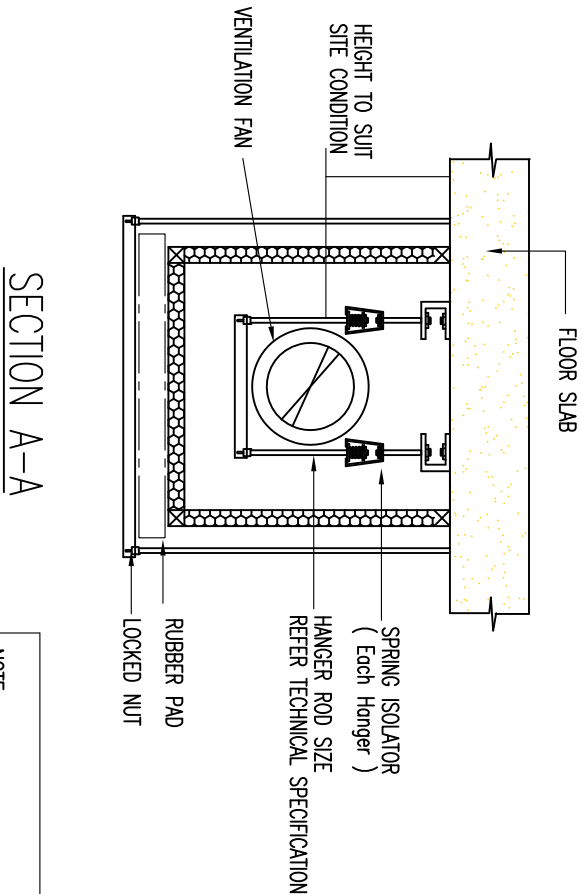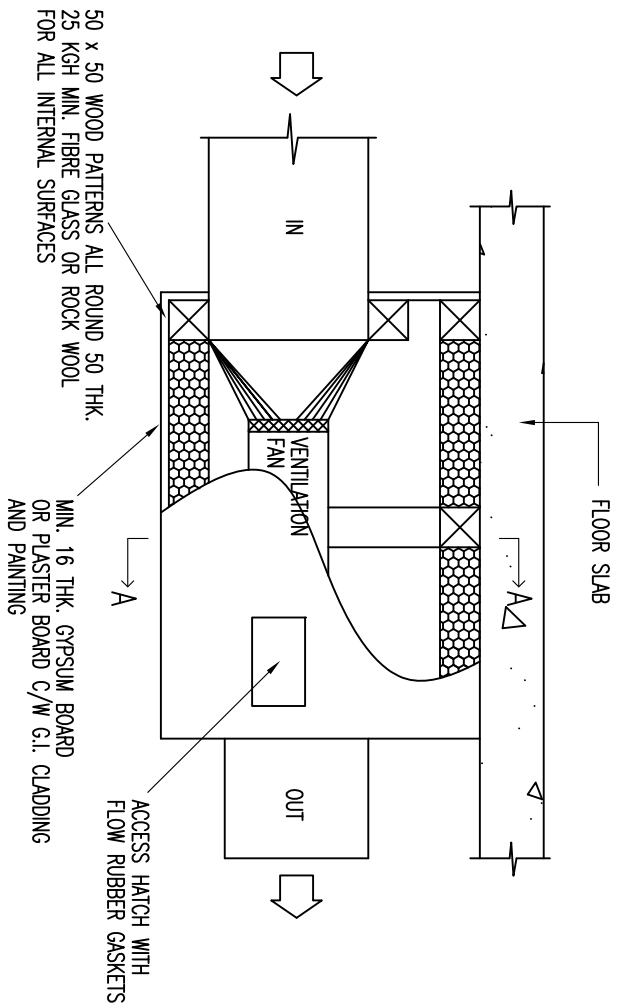

- NOTE:
1. CLEARANCE MIN. 150mm ALL ROUND THE FAN
 2. ALL JOINTS AND JUNCTIONS TO BE CAULKED AIR TIGHT

TYPICAL INSTALLATION VENTILATION FAN – NOISE CONTROL DETAIL INSTALLATION





JASA KEPADA RAKYAT

CAWANGAN KEJURUTERAAN MEKANIKAL
Ibu Pejabat JKR Malaysia

FIRE FIGHTING SYSTEM

TYPICAL TYPE OF FAN INSTALLATION

DATE 2017 SCALE NTS
DRAWING NUMBER CKM/STD/FF/SMOKE SPILL/REV2017/03

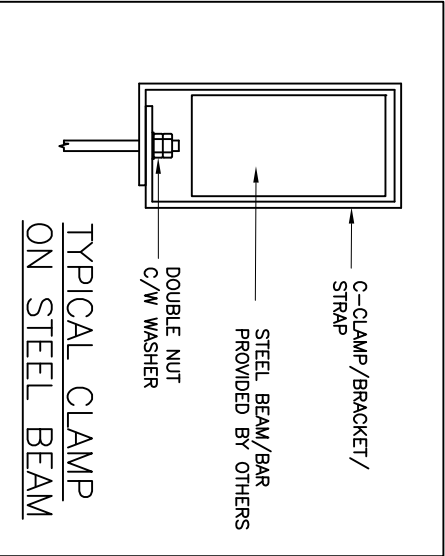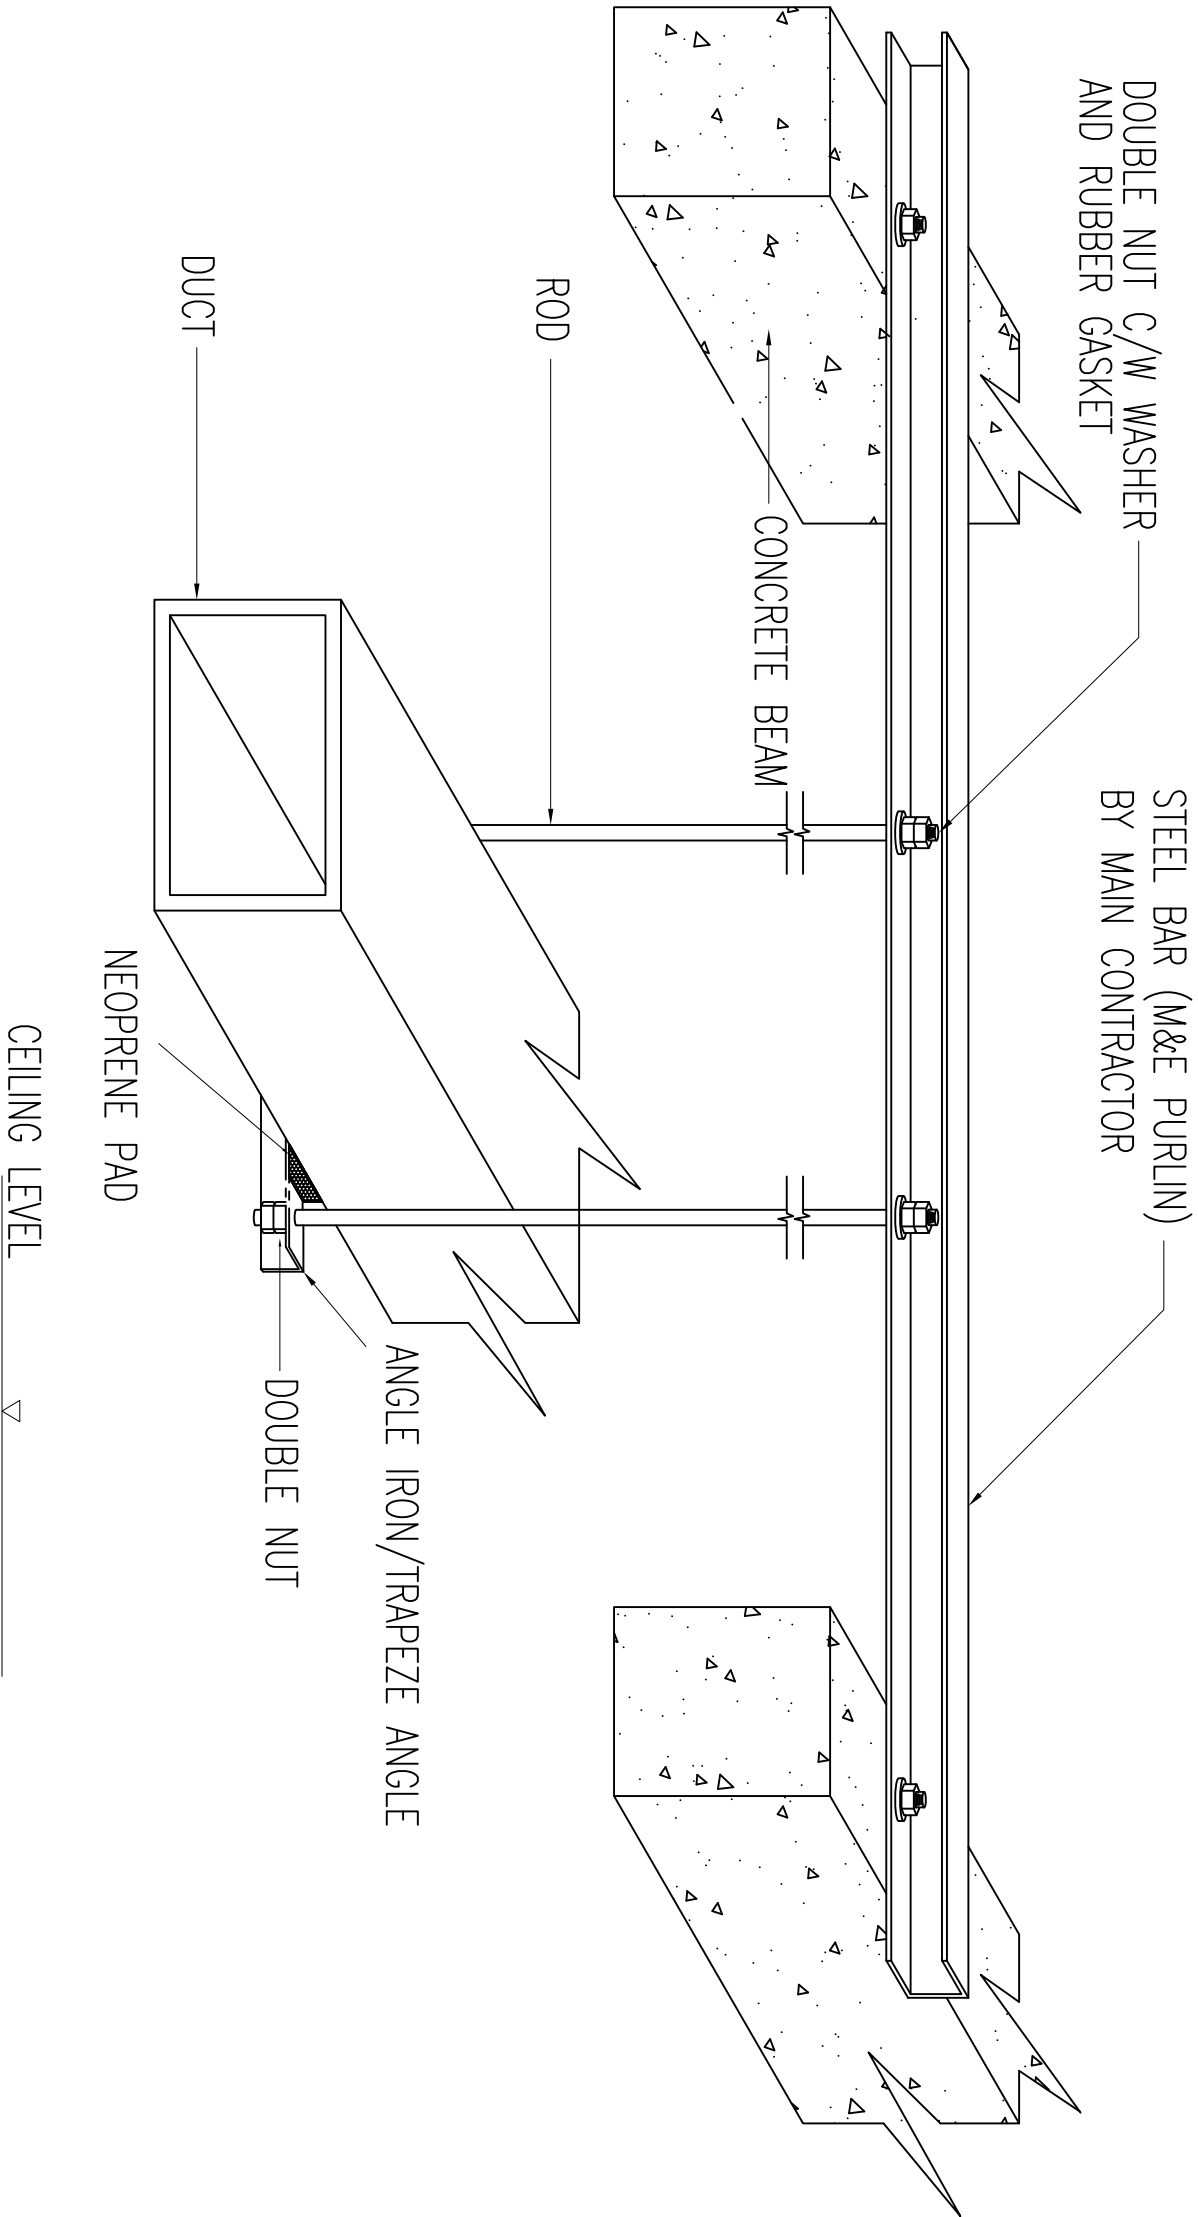

TYPICAL DUCT SUPPORT AND HANGER (UNDER THE ROOF)

TYPICAL DUCT / DIFFUSER SUPPORT
AND HANGER (UNDER THE ROOF)



JASA KEPADA RAKYAT



CAWANGAN KEJURUTERAAN MEKANIKAL
Ibu Pejabat JKR Malaysia

FIRE FIGHTING SYSTEM


TYPICAL TYPE OF DUCT INSTALLATION


DATE	2017	SCALE	NTS
DRAWING NUMBER	CKM/STD/FF/SMOKE SPILL/REV/2017/04		


NOTES: DUCT HANGERS SHALL BE FIXED TO THE CONCRETE/SLAB WITH SUITABLE SIZE OF ANCHOR BOLT RECOMMENDED BY THE MANUFACTURER

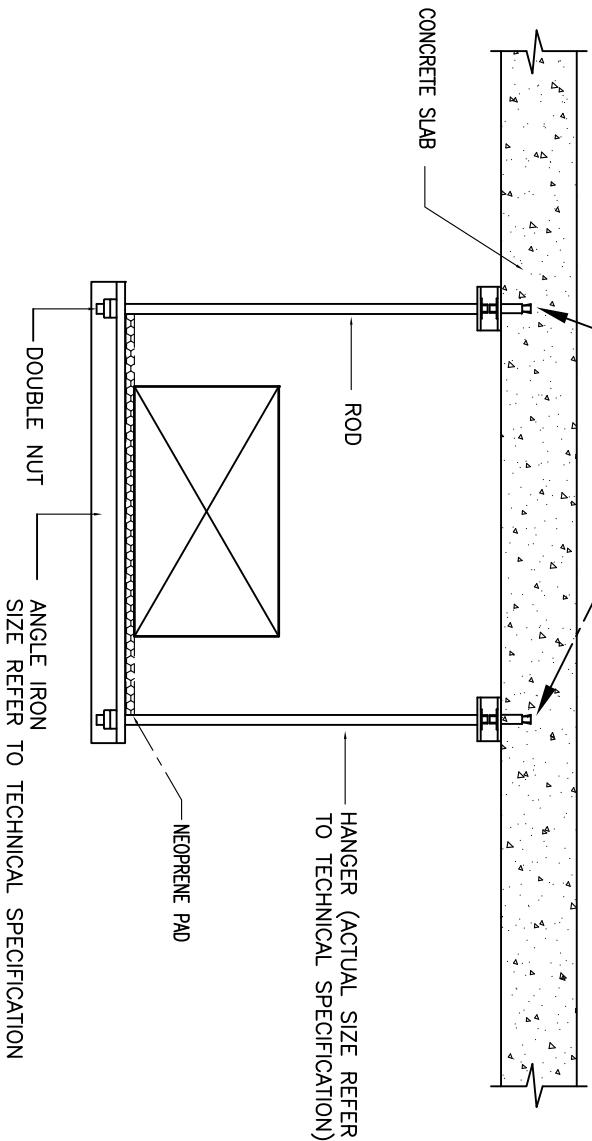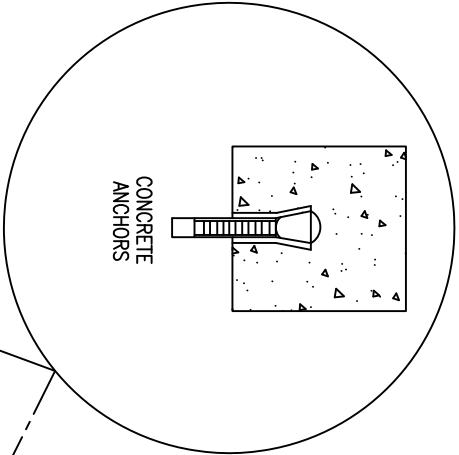

**TYPICAL DUCT
SUPPORT AND HANGER
(TRAPEZE ANGLE)**

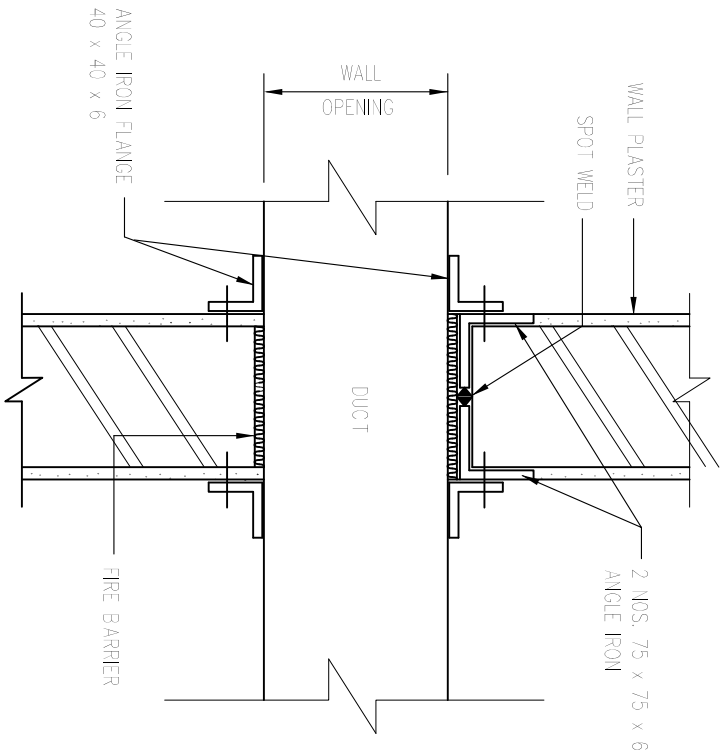


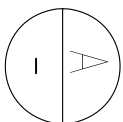SECTION 

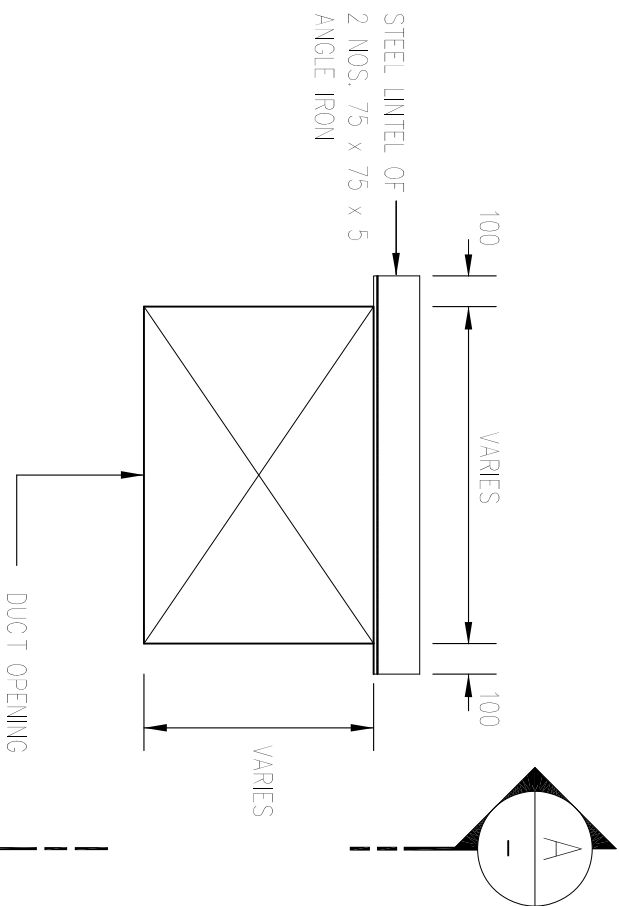

ELEVATION

STANDARD DETAIL OF DUCT FIRE BARRIER THOUGH FLOOR SLAB & FIRE COMPARTMENT WALL

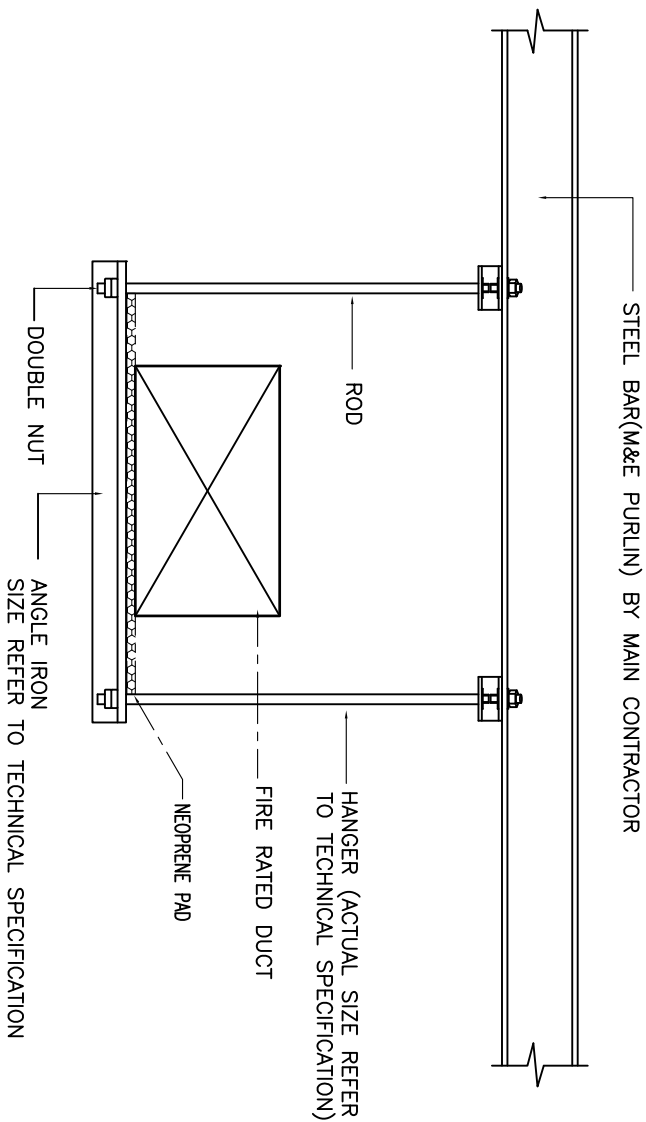

**TYPICAL DUCT SUPPORT
AND HANGER**






JASA KEPADA RAKYAT

CAWANGAN KEJURUTERAAN MEKANIKAL
Ibu Pejabat JKR Malaysia

FIRE FIGHTING SYSTEM

TYPICAL TYPE OF DUCT INSTALLATION

DATE	SCALE
2017	NTS
DRAWING NUMBER	
CKM/STD/FF/SMOKE SPILL/REV/2017/05	

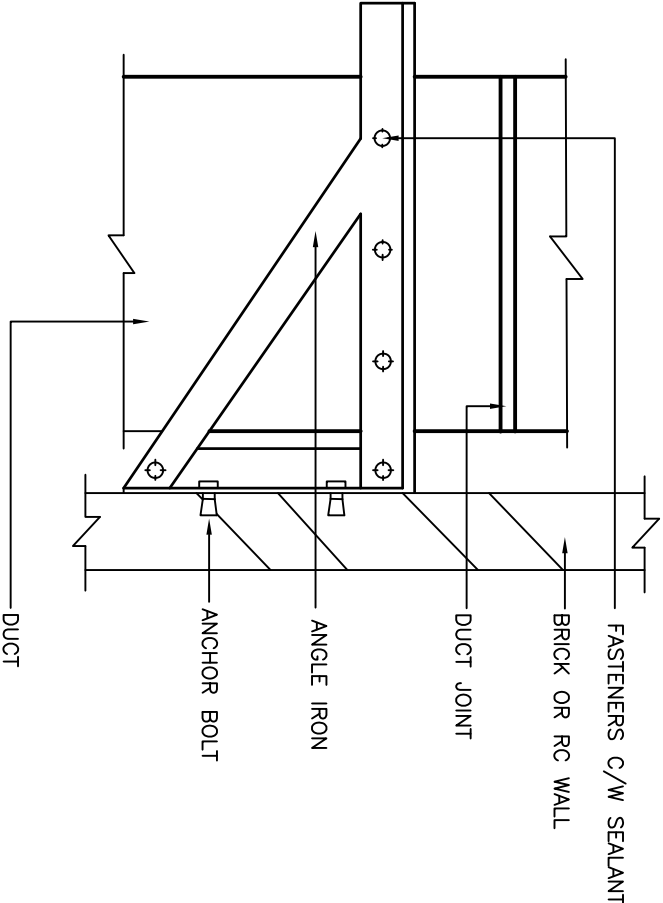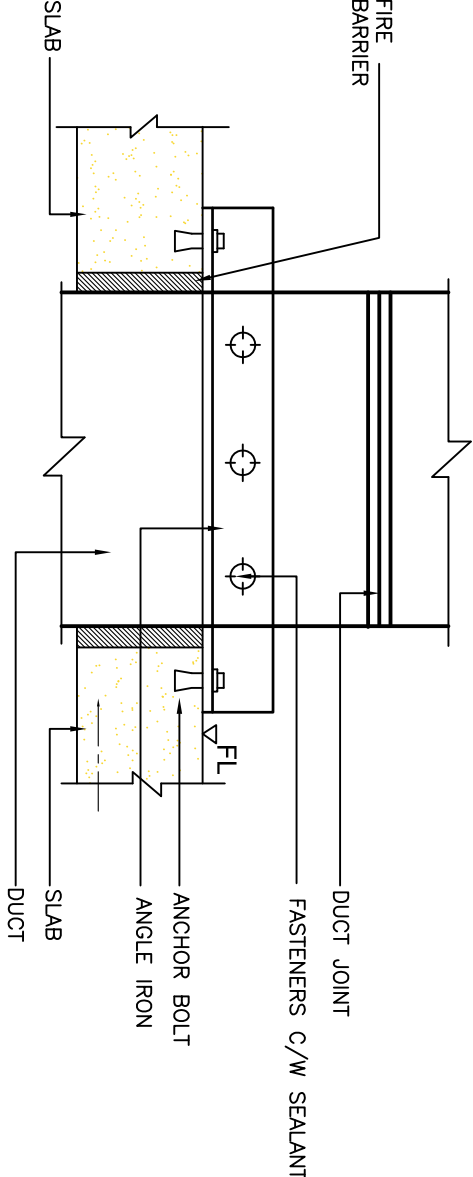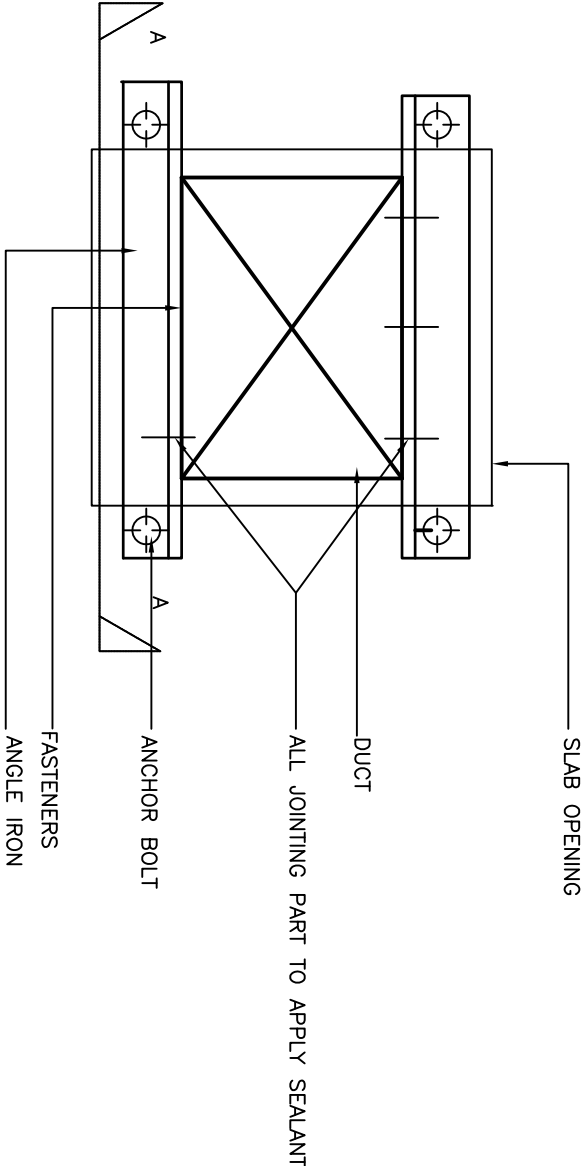

DUCT SUPPORT FOR DUCT RISER

ANCHORING INTO R.C WALL OR BRICKWALL



JASA KEPADA RAKYAT

CAWANGAN KEJURUTERAAN MEKANIKAL
Ibu Pejabat JKR Malaysia

FIRE FIGHTING SYSTEM

TYPICAL TYPE OF DUCT INSTALLATION

DATE	SCALE
2017	NTS
DRAWING NUMBER	
CKM/STD/FF/SMOKE SPILL/REV2017/06	

STANDARD MECHANICAL DESIGN DETAIL DRAWING FOR MECHANICAL SYSTEMS IN BUILDINGS

SECTION III : LIFT AND ESCALATOR SYSTEM

CAWANGAN KEJURUTERAAN MEKANIKAL
IBU PEJABAT JKR MALAYSIA
KUALA LUMPUR



JASA KEPADA RAKYAT

2017

NOTE:

- 1. This is a tender drawing and should not be taken as working drawing.
- 2. The standard details shown shall serve as guidelines only, contractor shall install and modify if necessary to suit the site condition and subject to S.O approval.

LIST OF DRAWINGS

NO.	DRAWING TITLE	DRAWING NUMBER
A	LIFT SYSTEM	
1	LIFT HOISTWAY INSTALLATION DETAIL	CKM/STD/LF/REV2017/01
2	MACHINE ROOM DETAIL	CKM/STD/LF/REV2017/02
3	LIFT CAR INTERNAL INSTALLATION DETAIL	CKM/STD/LF/REV2017/03
4	LIFT LOBBY INSTALLATION DETAIL	CKM/STD/LF/REV2017/04
5	LIFT PIT DETAIL AND LIFT PIT WITH SUMP DETAIL	CKM/STD/LF/REV2017/05
6	ANTI VANDALISME FEATURES	CKM/STD/LF/REV2017/06
7	DETAIL OF HANDICAP FEATURES	CKM/STD/LF/REV2017/07
8	DETAIL OF ARCHITRAVE	CKM/STD/LF/REV2017/08
9	DETAIL OF THROUGH DOOR LIFT	CKM/STD/LF/REV2017/09
10	DETAIL OF STRETCHER	CKM/STD/LF/REV2017/10
11	TYPE OF HANDRAIL	CKM/STD/LF/REV2017/11
12	DETAIL OF MOTOR ROOM LESS LIFT	CKM/STD/LF/REV2017/12
B	ESCALATOR SYSTEM	
1	ESCALATOR DETAIL	CKM/STD/ESC/REV2017/01
C	DUMB WATER SYSTEM	
1	TYPICAL DUMB WATER EQUIPMENT	CKM/STD/DW/REV2017/01
2	TYPICAL DUMB WATER INSTALLATION (FRONT BACK)	CKM/STD/DW/REV2017/02
3	TYPICAL DUMB WATER INSTALLATION (SAME SIDE)	CKM/STD/DW/REV2017/03




JASA KEPADA RAKYAT

CAWANGAN KEJURUTERAAN MEKANIKAL
Ibu Pejabat JKR Malaysia

LIFT AND ESCALATOR SYSTEM


DRAWING NUMBER

DATE	SCALE
2017	NTS

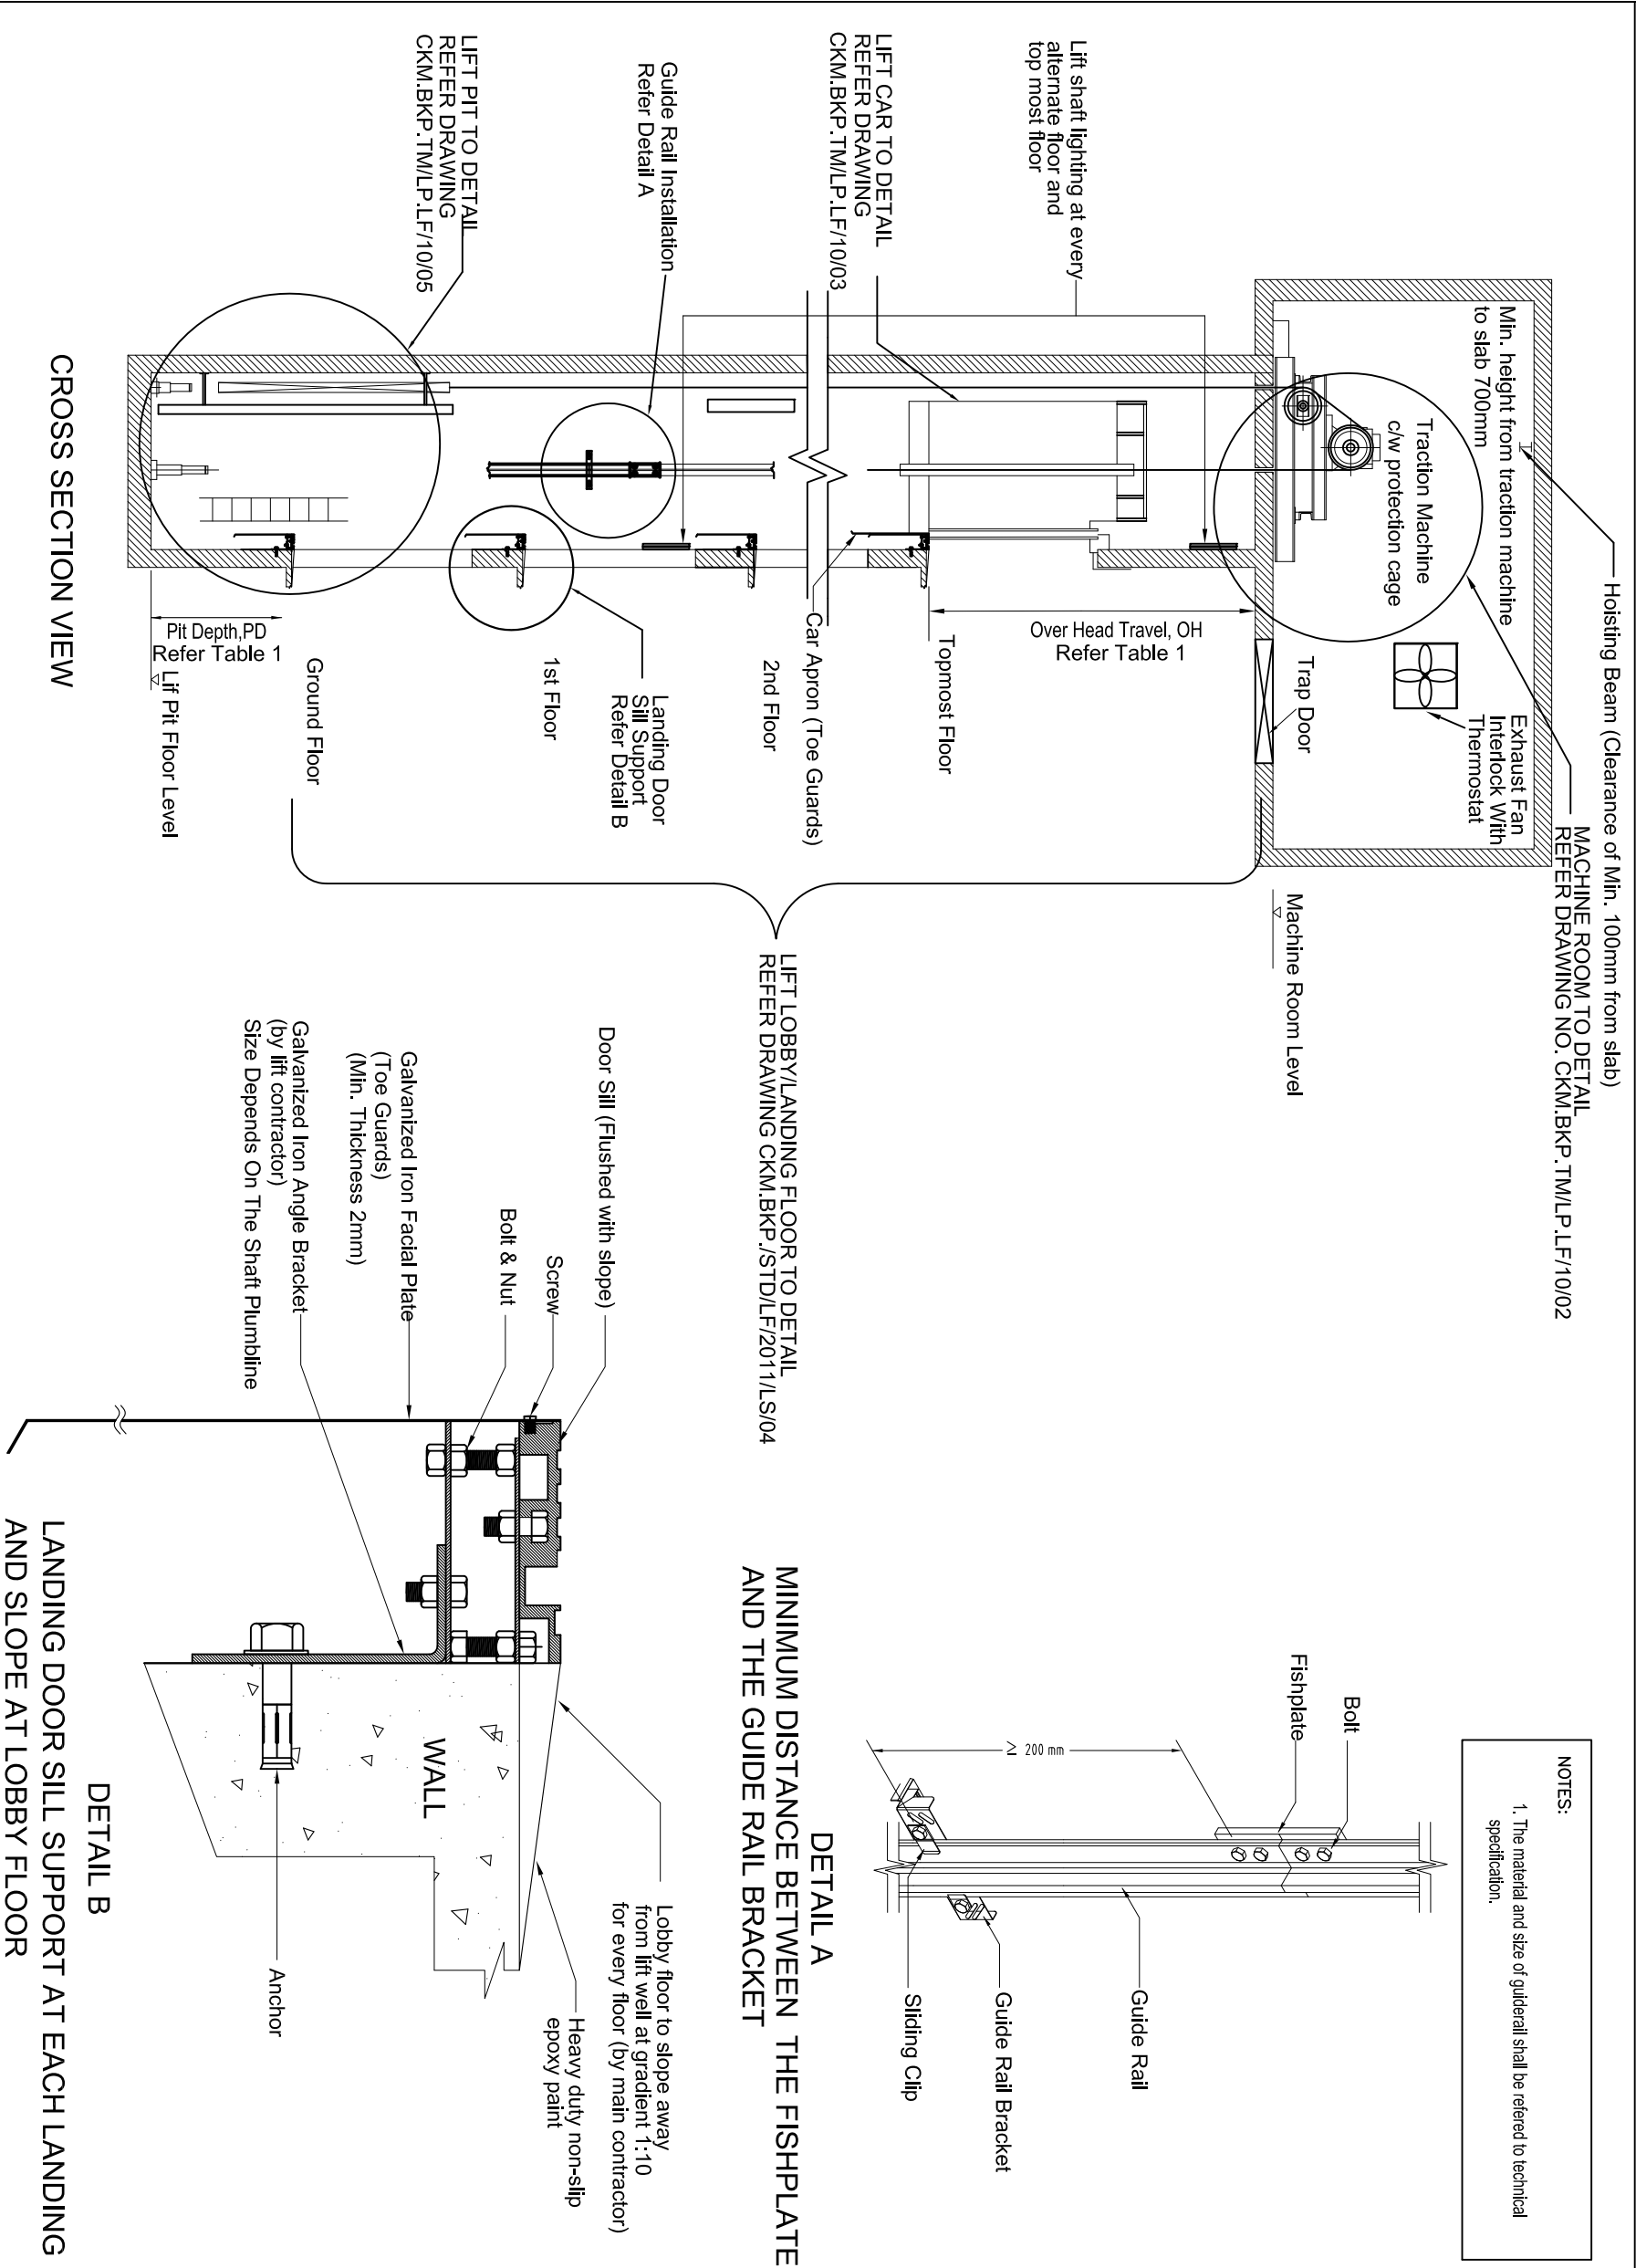


NOTE:		NOTE:	
1. This is a tender drawing and should not be taken as working drawing.		1. This is a tender drawing and should not be taken as working drawing.	
2. The standard details shown shall serve as guidelines only, contractor shall install and modify if necessary to suit the site condition and subject to S.O approval.		2. The standard details shown shall serve as guidelines only, contractor shall install and modify if necessary to suit the site condition and subject to S.O approval.	


CAWANGAN KEJURUTERAAN MEKANIKAL		JAS A KEPADA RAKYAT	
Ibu Pejabat JKR Malaysia			
LUKISAN PERINCIAAN PAJWA PEMASANGAN		SISTEM LIFT	
LIFT HOISTWAY INSTALLATION DETAIL			
DATE	2017	SCALE	NTS
DRAWING NUMBER	CKM/STD/LF/REV2017/01		

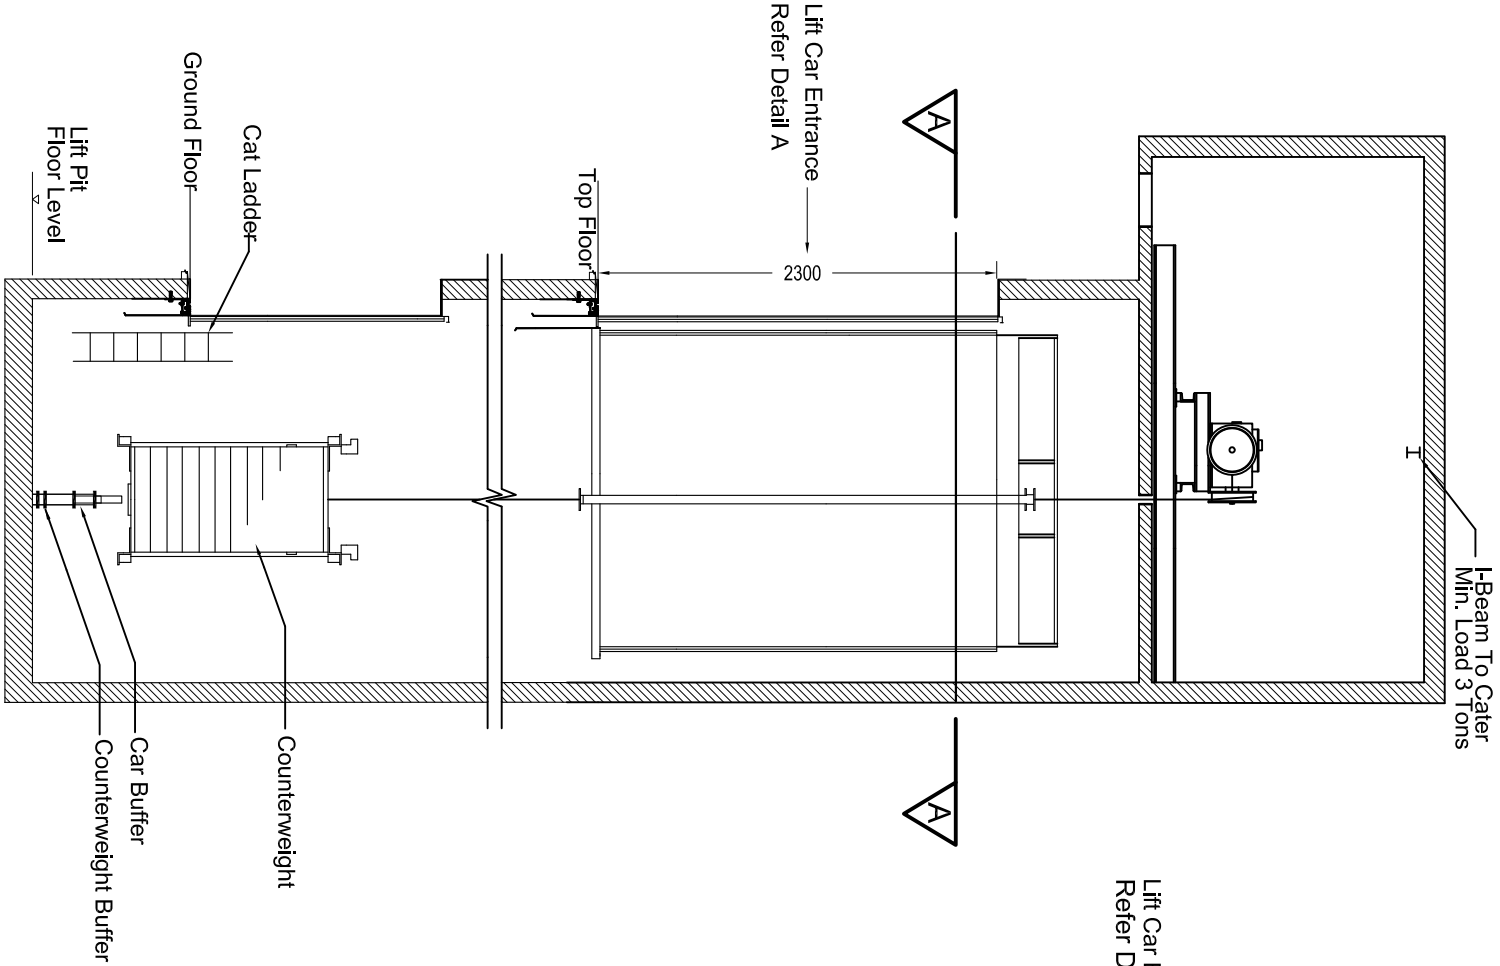

CROSS SECTION VIEW

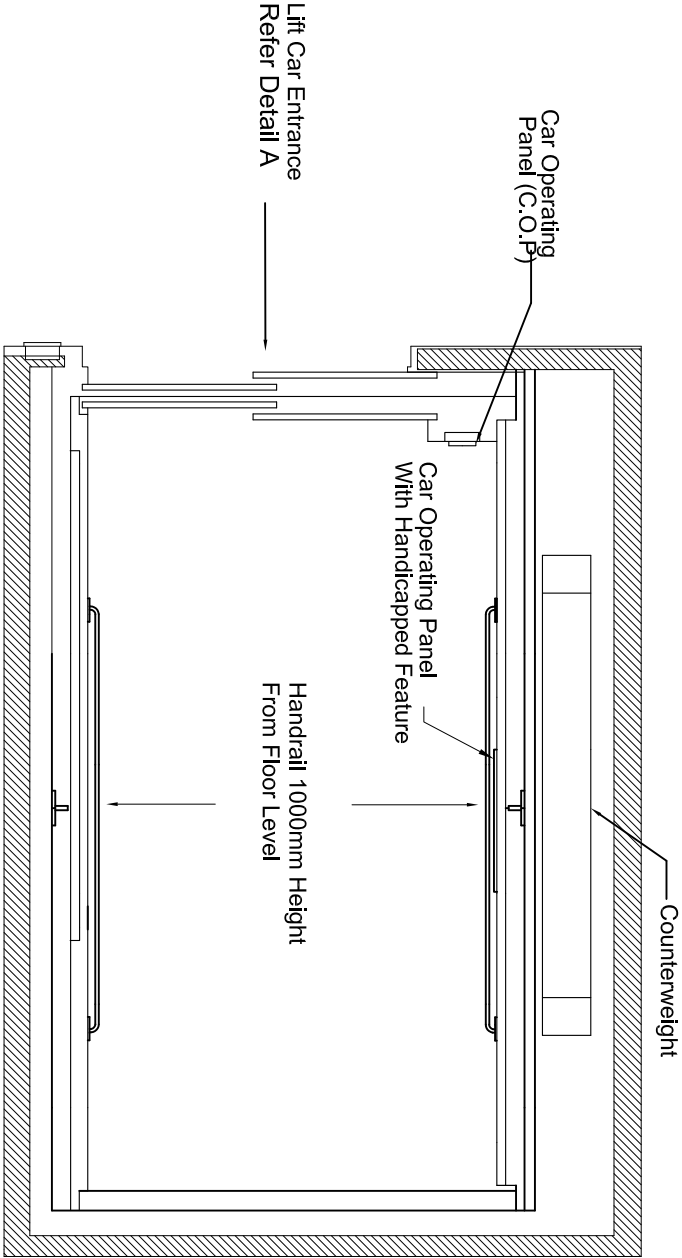

SECTION A-A

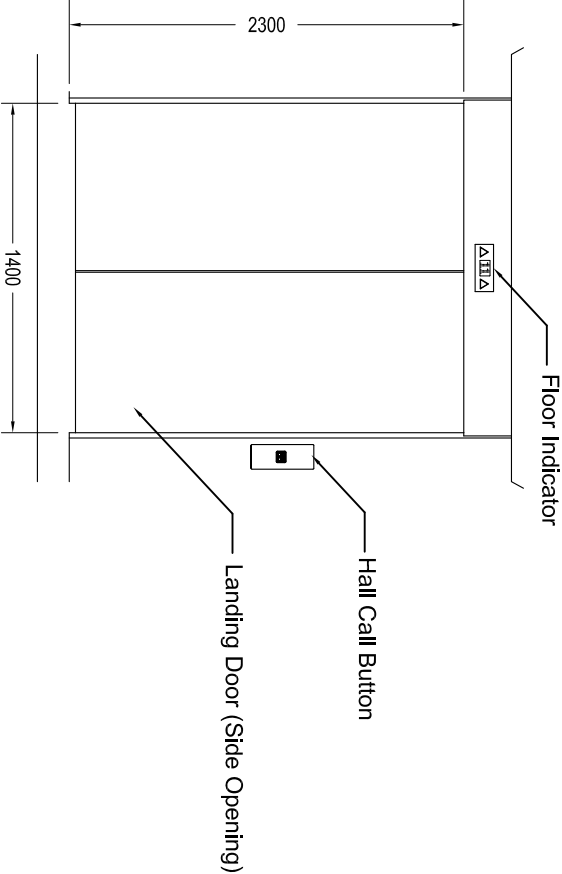

DETAIL A

DETAIL OF STRETCHER LIFT

N.T.S



JASA KEPADA RAKYAT

CAWANGAN KEJURUTERAAN MEKANIKAL
Ibu Pejabat JKR Malaysia


LUKISAN PERINCIAAN PLAWAI PEMASANGAN
SISTEM LIFT

DETAIL OF STRETCHER LIFT

DATE	SCALE
2017	NTS
DRAWING NUMBER	
CKM/STD/LF/REV2017/10	


NOTE:

1. This is a tender drawing and should not be taken as working drawing.
2. The standard details shown shall serve as guidelines only, contractor shall install and modify if necessary to suit the site condition and subject to S.O. approval.

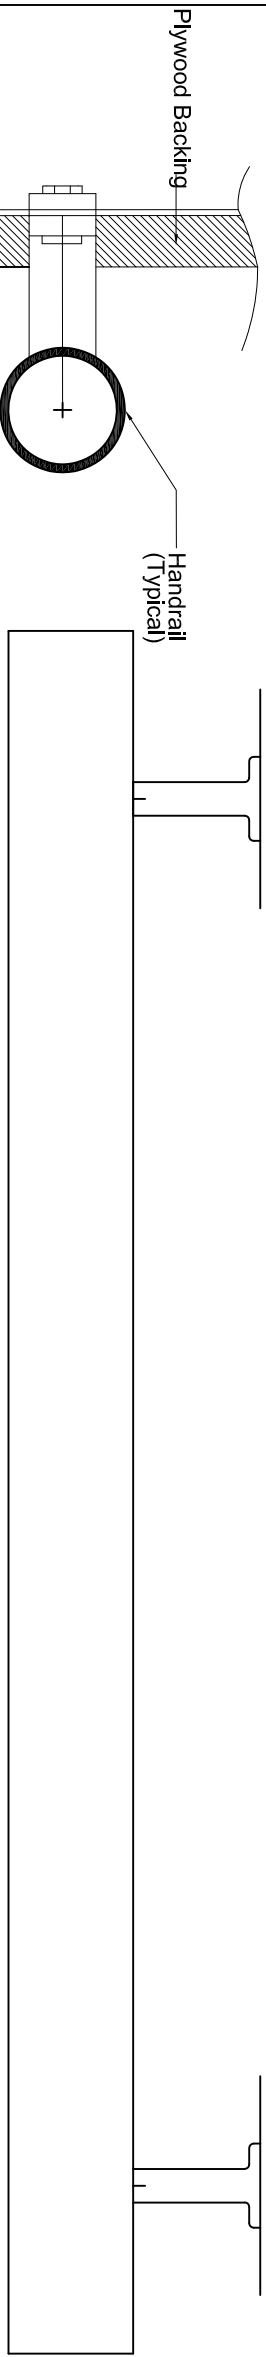


Plan View

ROUND-STRAIGHT HANDRAIL

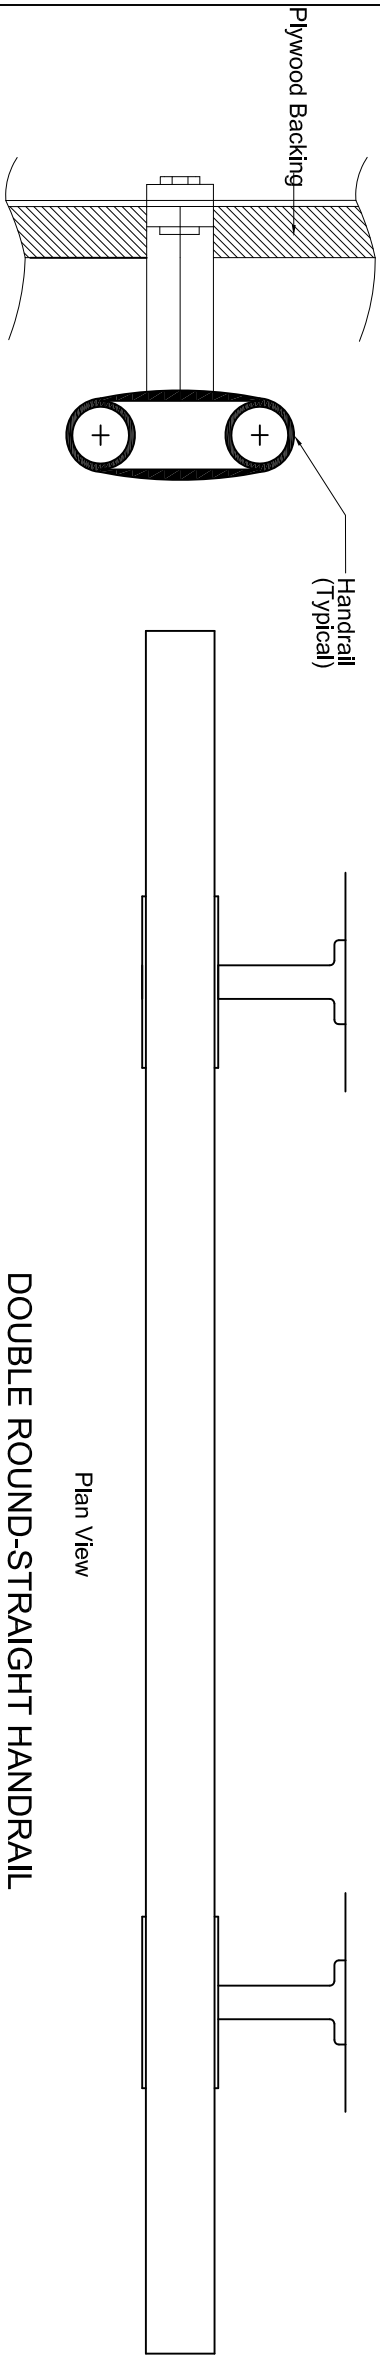


Plan View

DOUBLE ROUND-STRAIGHT HANDRAIL

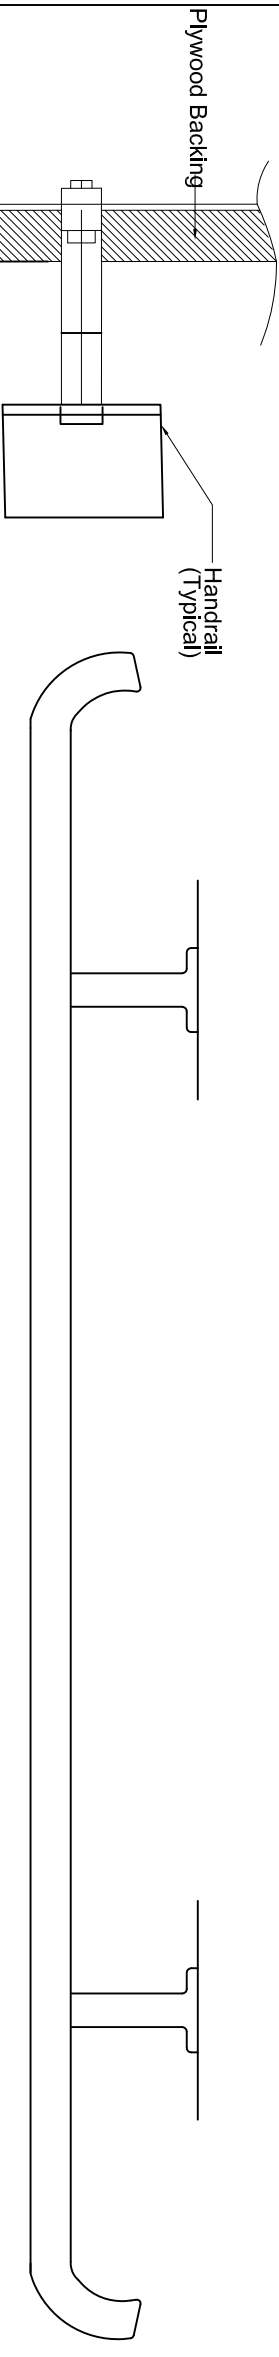

Plan View


FLAT-CURVE HANDRAIL TYPE 1

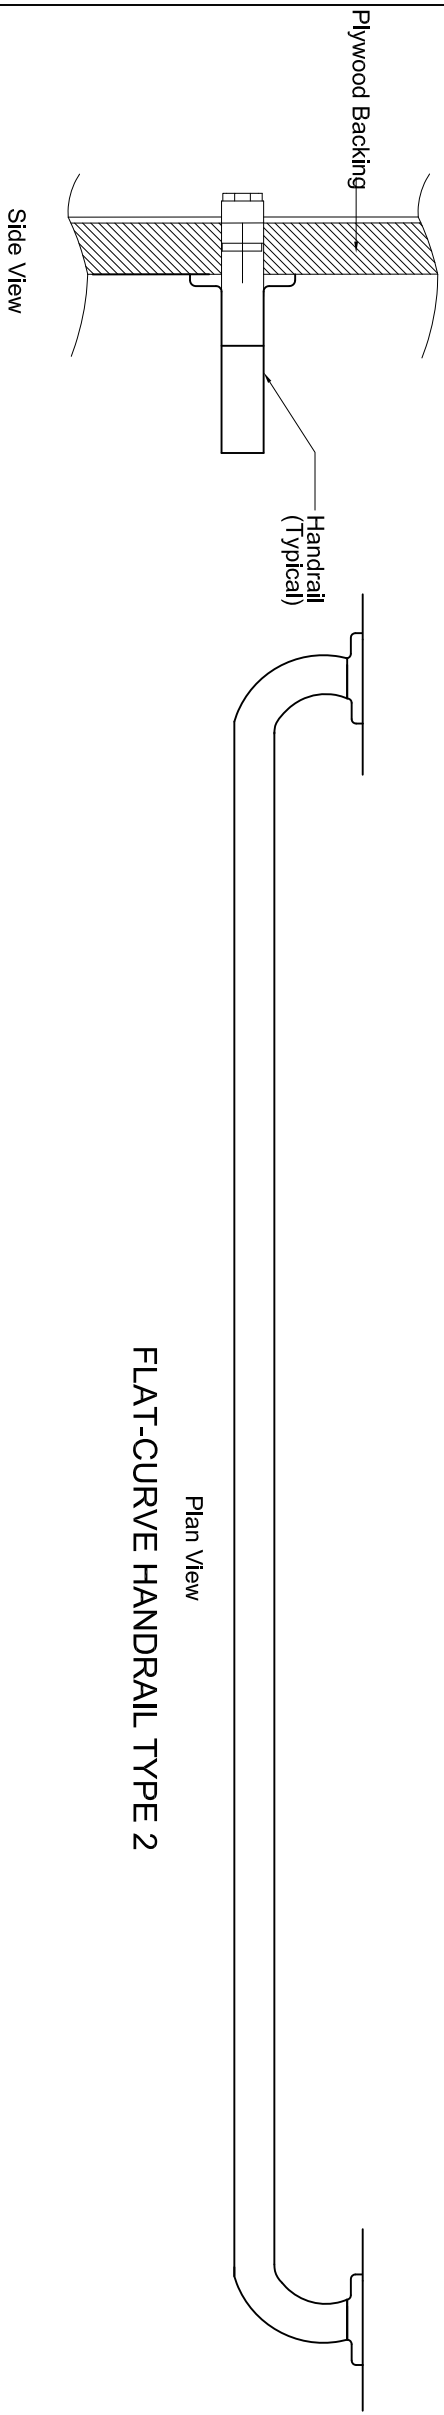


Plan View

FLAT-CURVE HANDRAIL TYPE 2


 JASA KEPADA RAKYAT		CAWANGAN KEJURUTERAAN MEKANIKAL Ibu Pejabat UKR Malaysia
LUKISAN PERINCINAN PIAWAI PEMASANGAN SISTEM LIFT TYPE OF HANDRAIL		
DATE	2017	SCALE
DRAWING NUMBER		NTS
CKM/STD/LF/REV/2017/11		

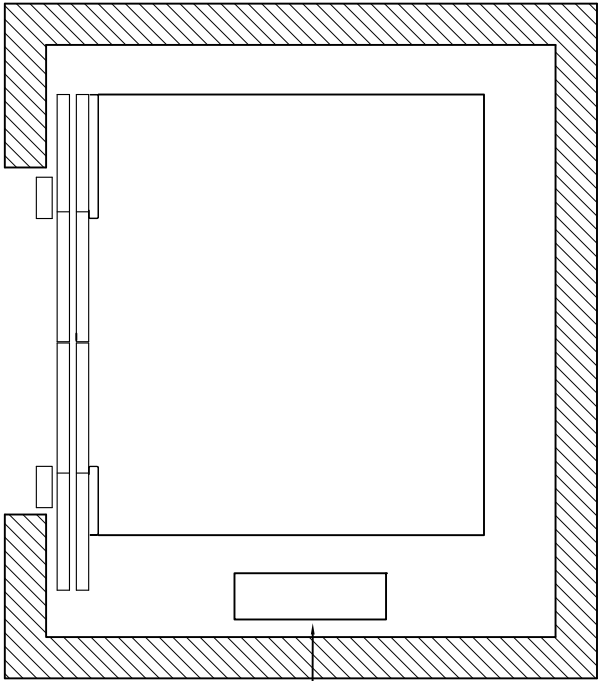

PLAN VIEW AT TOP MOST FLOOR

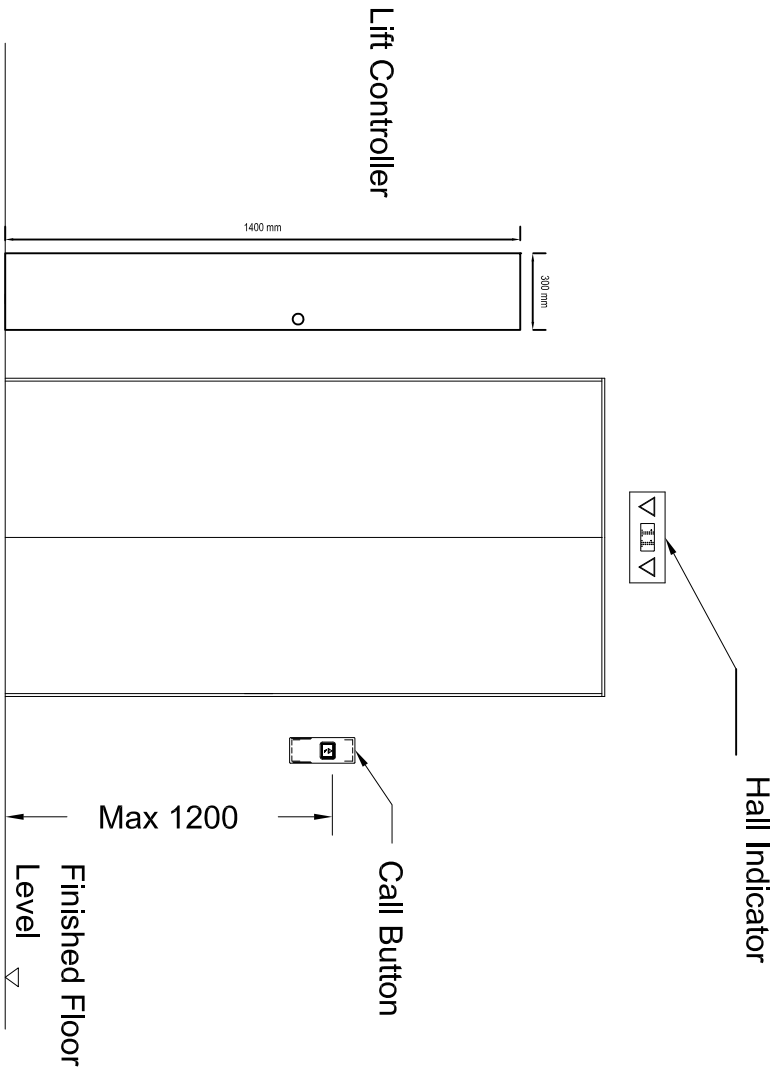

FRONT VIEW AT TOP MOST FLOOR

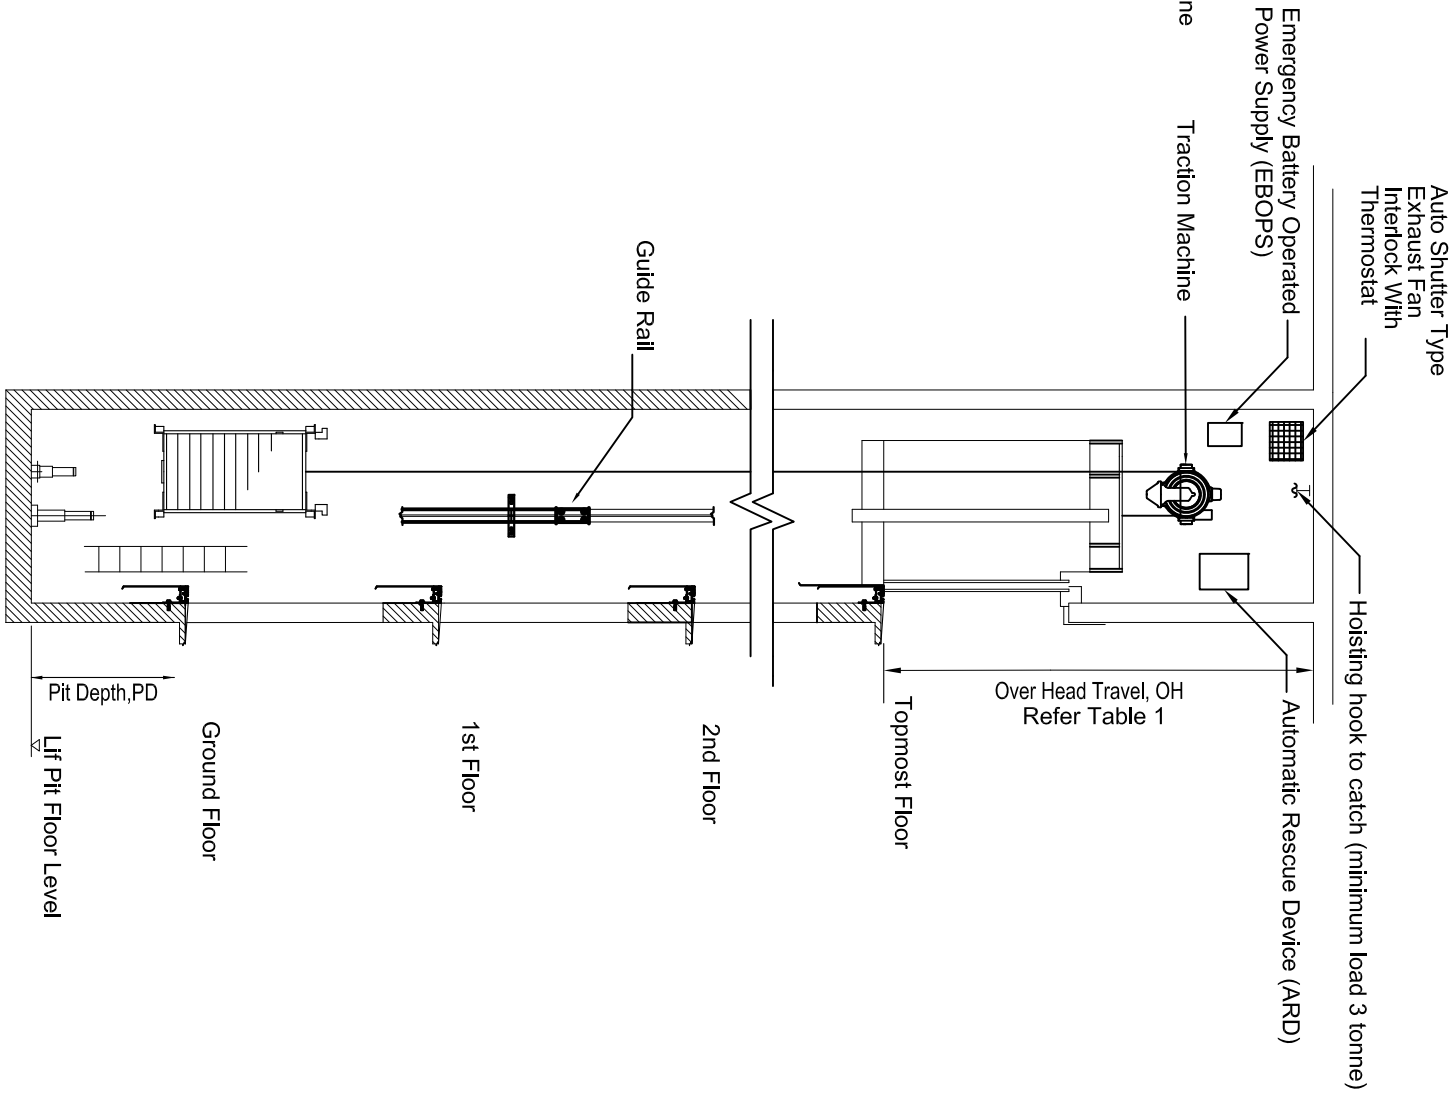

CROSS SECTION VIEW

NOTE:

1. This is a tender drawing and should not be taken as working drawing.
2. The standard details shown shall serve as guidelines only, contractor shall install and modify if necessary to suit the site condition and subject to S.O approval.




JASA KEPADA RAKYAT


CAWANGAN KEJURUTERAAN MEKANIKAL
Ibu Pejabat JKR Malaysia

LUKISAN PERINCAN PLAWA PEMASANGAN
SISTEM LIFT
DETAIL OF MACHINE ROOMLESS LIFT

DATE	SCALE
2017	NTS
DRAWING NUMBER	
CKM/STD/LF/REV2017/12	

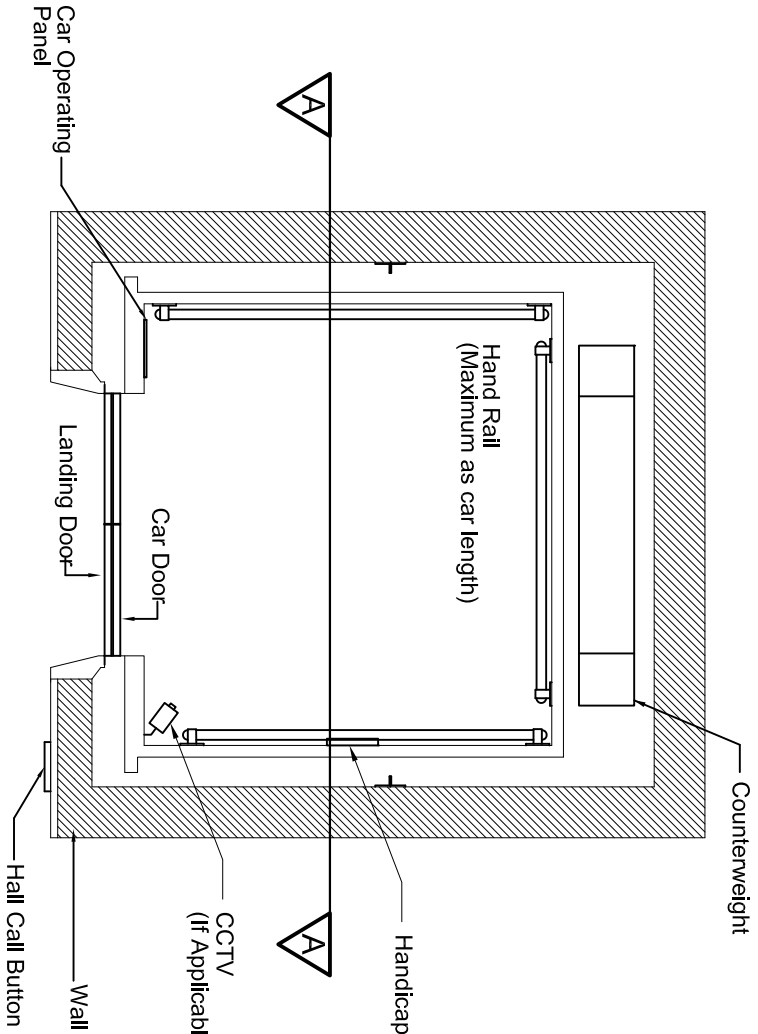


PLAN VIEW

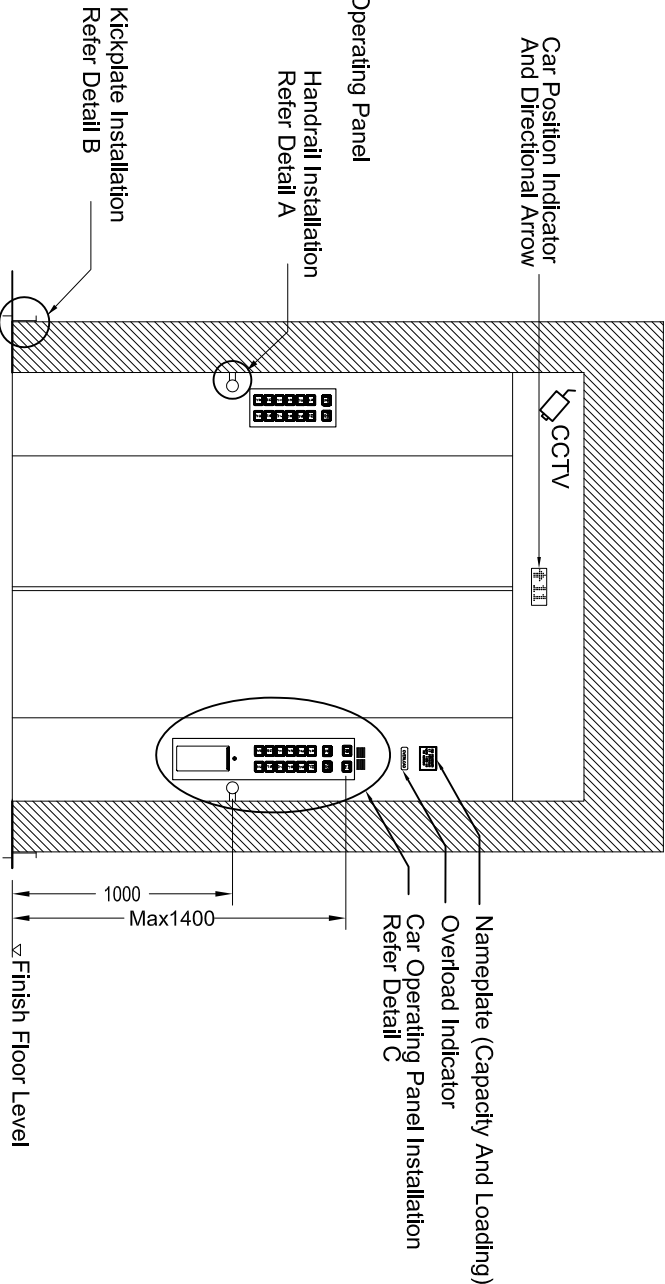


SECTION A-A

TYPICAL INTERNAL LIFT CAR FEATURES

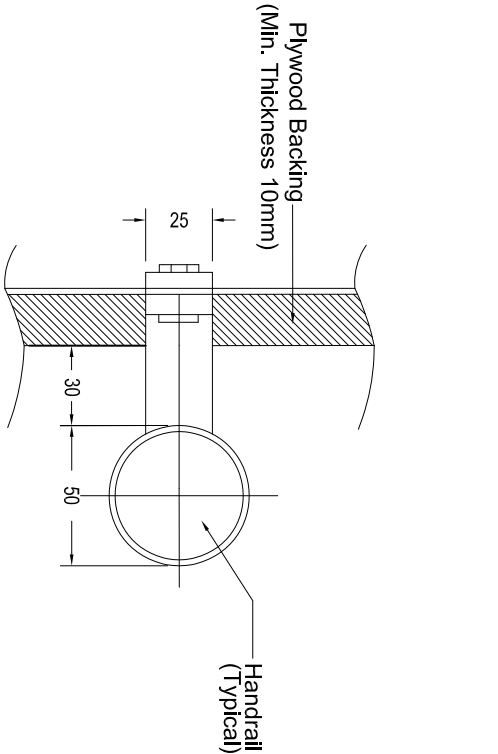


DETAIL A

TYPICAL HANDRAIL INSTALLATION

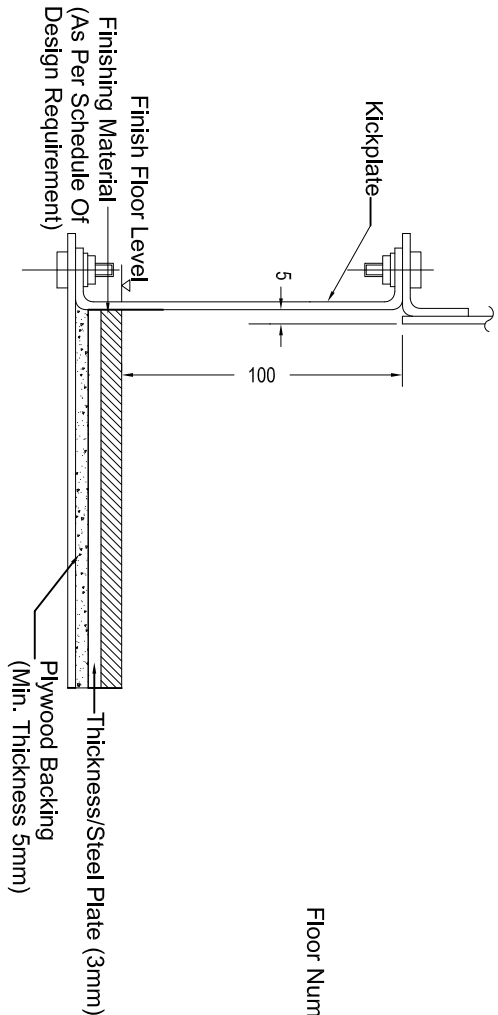

DETAIL B

KICKPLATE INSTALLATION

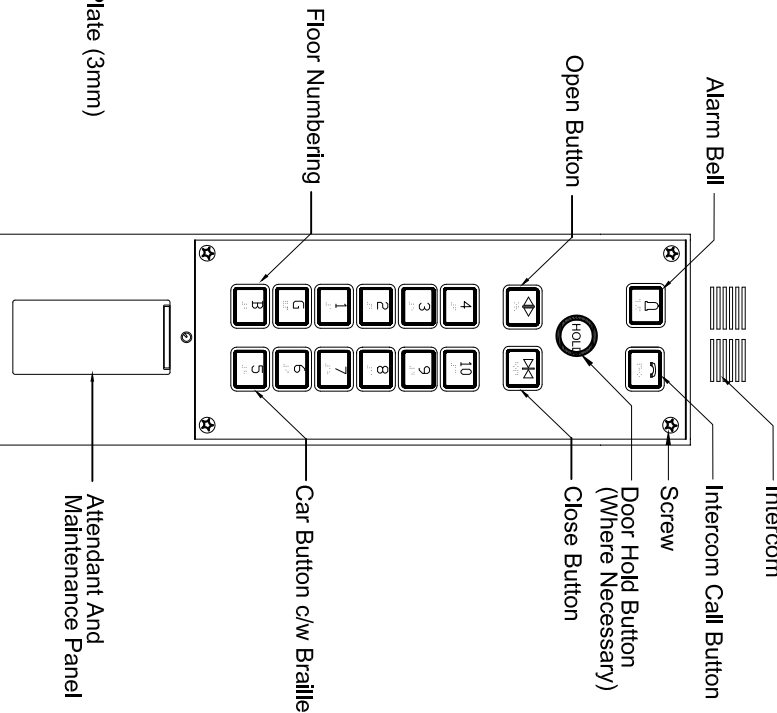

DETAIL C

TYPICAL CAR OPERATING PANEL INSTALLATION

- NOTES:
1. Exact quantity of car operating panel (C.O.P) as per Schedule of Design Requirement.
 2. Type of handrail shall be as per Schedule of Design Requirement.
 3. Emergency escape door on top of lift car shall be provided with minimum 350 mm x 500 mm

- NOTE:
1. This is a tender drawing and should not be taken as working drawing.
 2. The standard details shown shall serve as guidelines only, contractor shall install and modify if necessary to suit the site condition and subject to S.O approval.



JASA KEPADA RAKYAT

CAWANGAN KEJURUTERAAN MEKANIKAL
Ibu Pejabat JKR Malaysia




LUKISAN PERINCIAAN PLAWA PEMASANGAN
SISTEM LIFT

LIFT CAR INTERNAL INSTALLATION DETAIL

DATE	SCALE
2017	NTS
DRAWING NUMBER	
CKM/STD/LF/REV2017/03	

- NOTES:
1. Floor number indicator are compulsory for main lobby only, but requirement for others floor are subject to Schedule of Design Requirement.
 2. Firemen's switch shall be located at firemen's access level.
 3. Minimum thickness of faceplate shall be 3mm.
 4. All measurement for hall indicator and call button are in typical size.
 5. All landing door shall be 2 hours fire rated for protected lobby and 1 hour fire rated for unprotected lobby.

- NOTE:
1. This is a tender drawing and should not be taken as working drawing.
 2. The standard details shown shall serve as guidelines only, contractor shall install and modify if necessary to suit the site condition and subject to S.O approval.

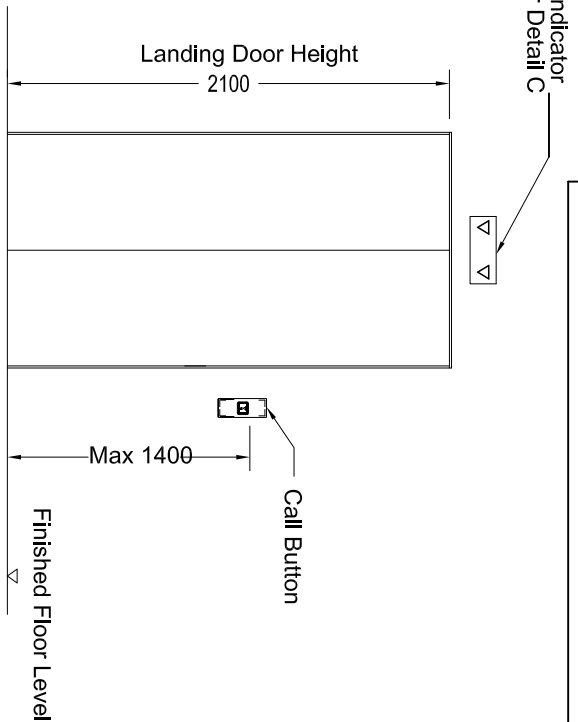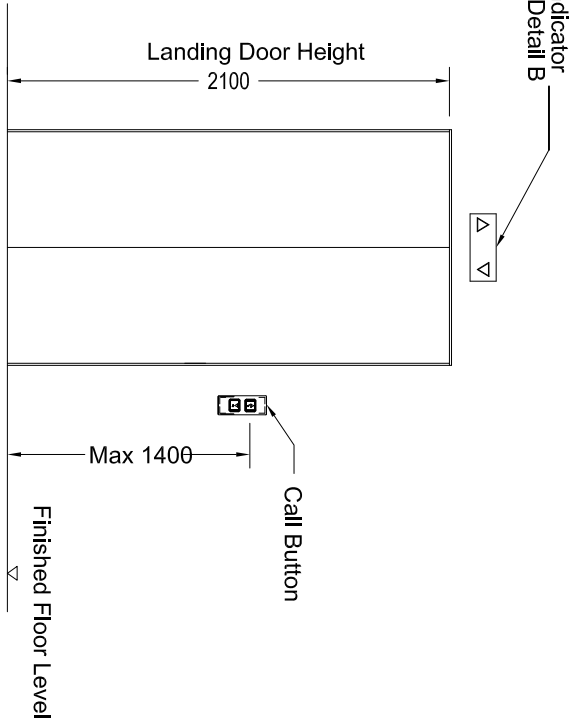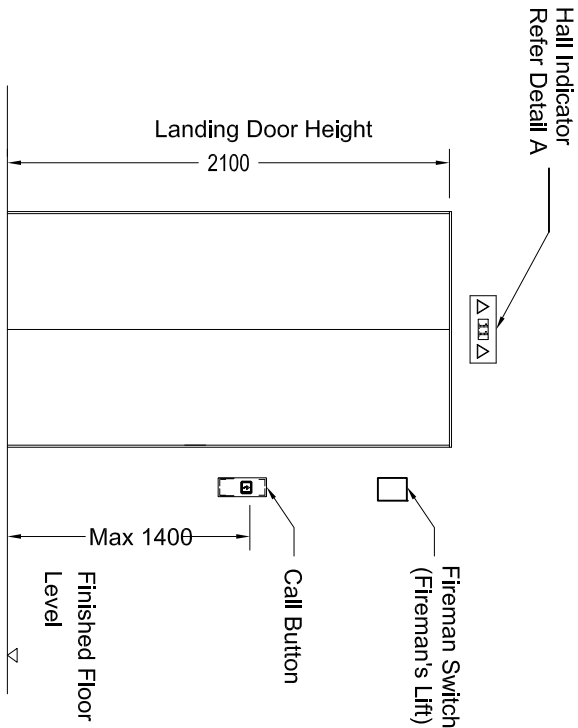

FRONT VIEW AT LOWEST FLOOR

FRONT VIEW AT INTERMEDIATE FLOOR LANDINGS

FRONT VIEW AT HIGHEST FLOOR LANDING

KERAJAAN MALAYSIA



JASA KEPADA RAKYAT

CAWANGAN KEJURUTERAAN MEKANIKAL
Ibu Pejabat JKR Malaysia









JASA KEPADA RAKYAT

CAWANGAN KEJURUTERAAN MEKANIKAL
Ibu Pejabat JKR Malaysia

LUKSAN PERINCIAAN PIAMAI PEMASANGAN
SISTEM LIFT

LIFT LOBBY INSTALLATION DETAIL

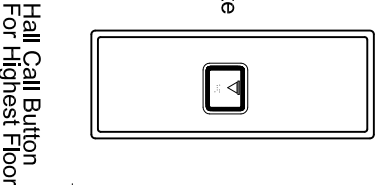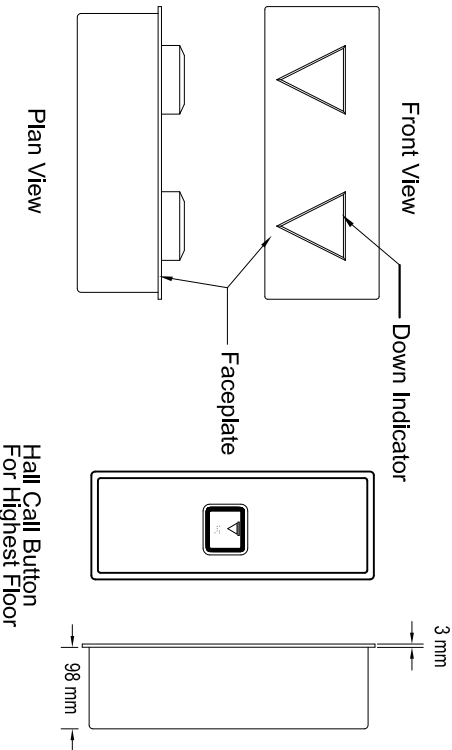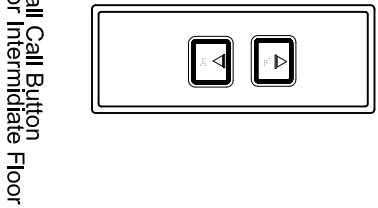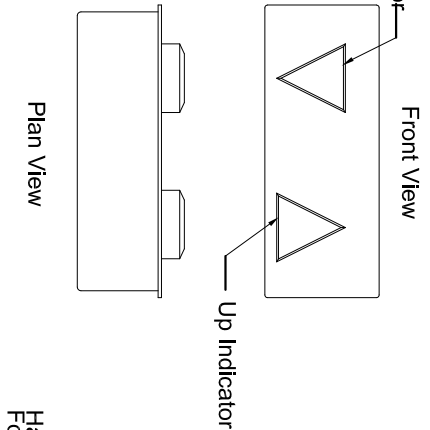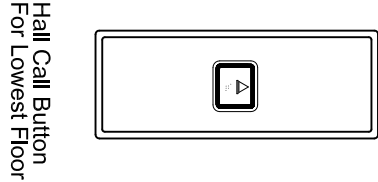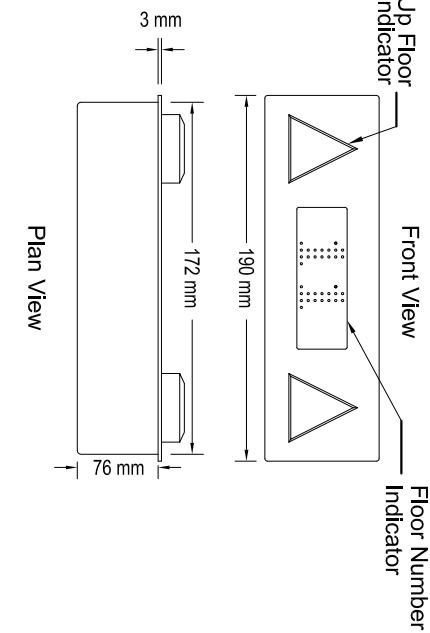

DETAIL A

HALL INDICATOR DESIGN WITH
HALL LANTERN FOR LOWEST FLOOR

DETAIL B

HALL INDICATOR DESIGN WITH
HALL LANTERN FOR INTERMEDIATE FLOORS


DETAIL C

HALL INDICATOR DESIGN WITH
HALL LANTERN FOR HIGHEST FLOOR

LIFT LOBBY INSTALLATION DETAIL

N.T.S

DATE	SCALE
2017	NTS
DRAWING NUMBER	
CKM/STD/LF/REV2017/04	

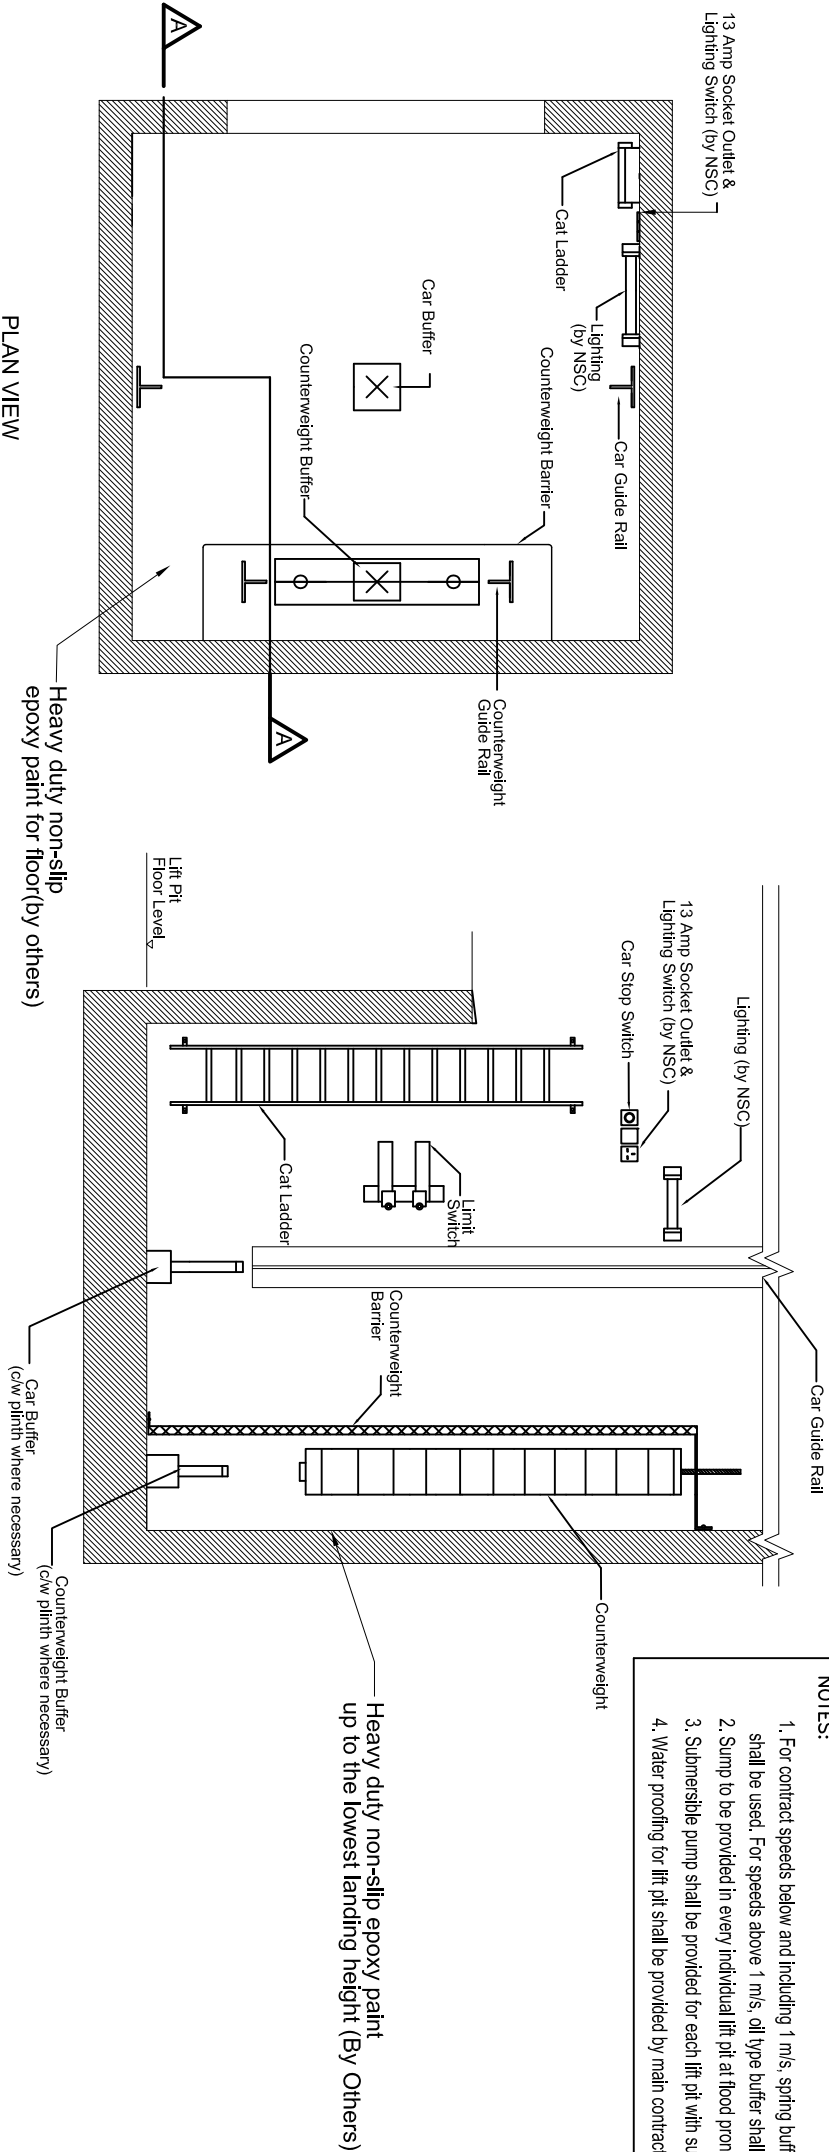


PLAN VIEW

LIFT PIT DETAIL
N.T.S

SECTION A-A

- NOTES:
1. For contrad speeds below and including 1 m/s, spring buffers shall be used. For speeds above 1 m/s, oil type buffer shall be used.
 2. Sump to be provided in every individual lift pit at flood prone area.
 3. Submersible pump shall be provided for each lift pit with sump.
 4. Water proofing for lift pit shall be provided by main contractor.

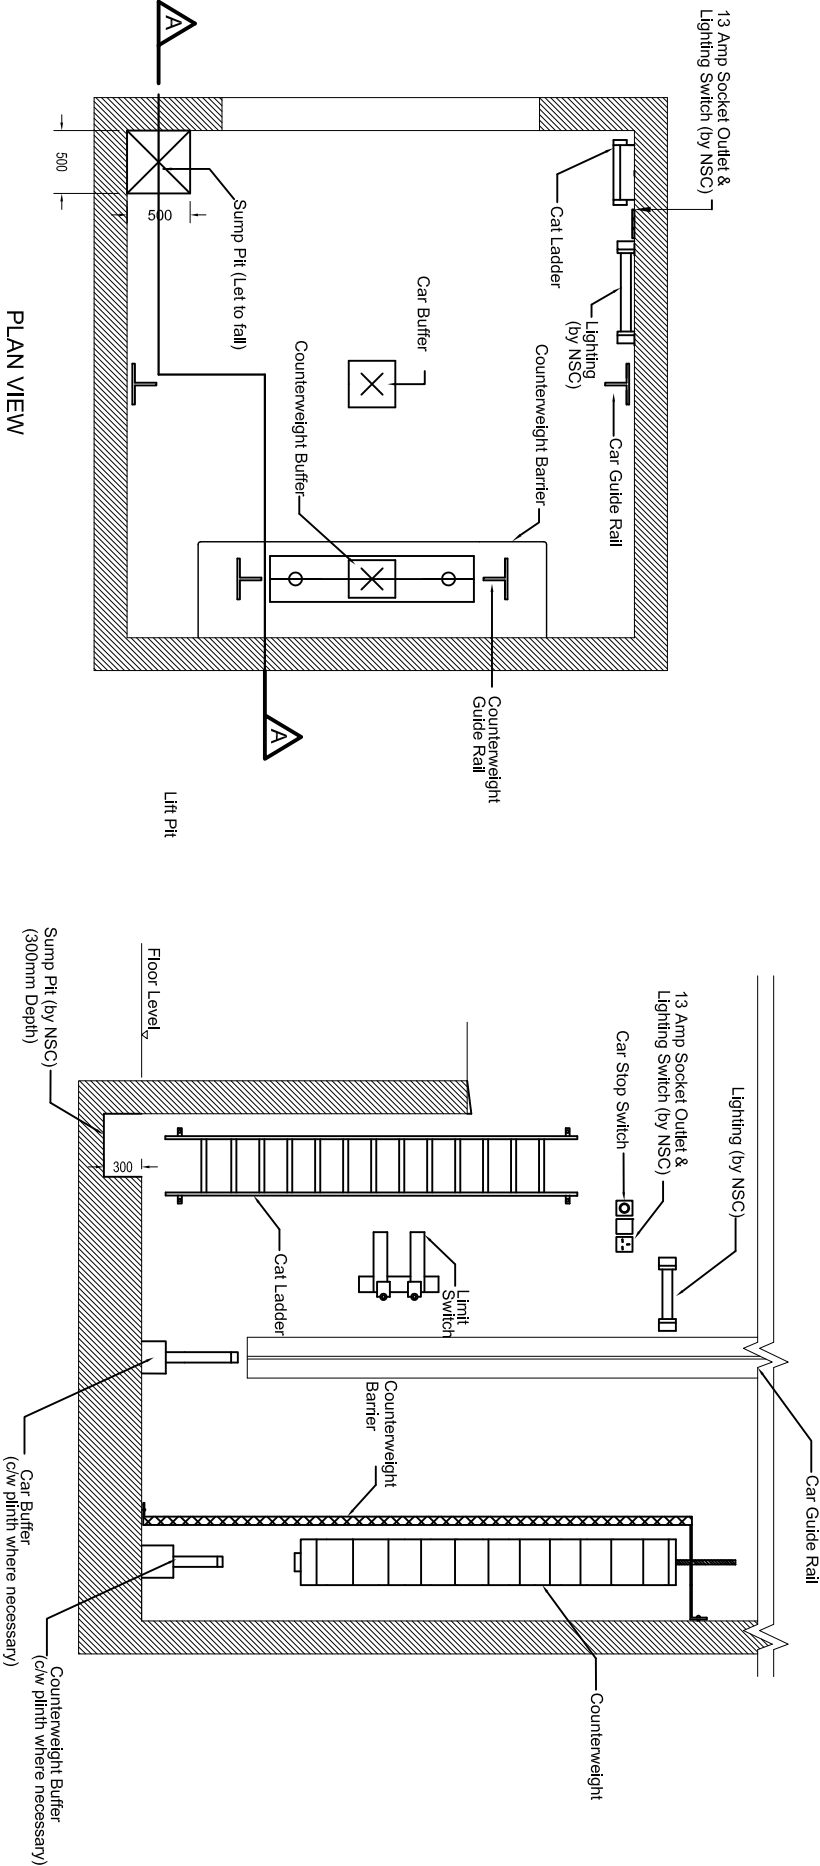

PLAN VIEW

SECTION A-A

LIFT PIT WITH SUMP DETAIL

N.T.S

NOTE:

1. This is a tender drawing and should not be taken as working drawing.
2. The standard details shown shall serve as guidelines only, contractor shall install and modify if necessary to suit the site condition and subject to S.O approval.





JASA KEPADA RAKYAT

CAWANGAN KEJURUTERAAN MEKANIKAL
Ibu Pejabat JKR Malaysia

LUKISAN PERINCIAAN PAJAW PEMASANGAN
SISTEM LIFT

LIFT PIT DETAIL AND LIFT PIT WITH SUMP DETAIL

DATE	SCALE
2017	NTS
DRAWING NUMBER	
CKM/STD/LF/REV2017/05	

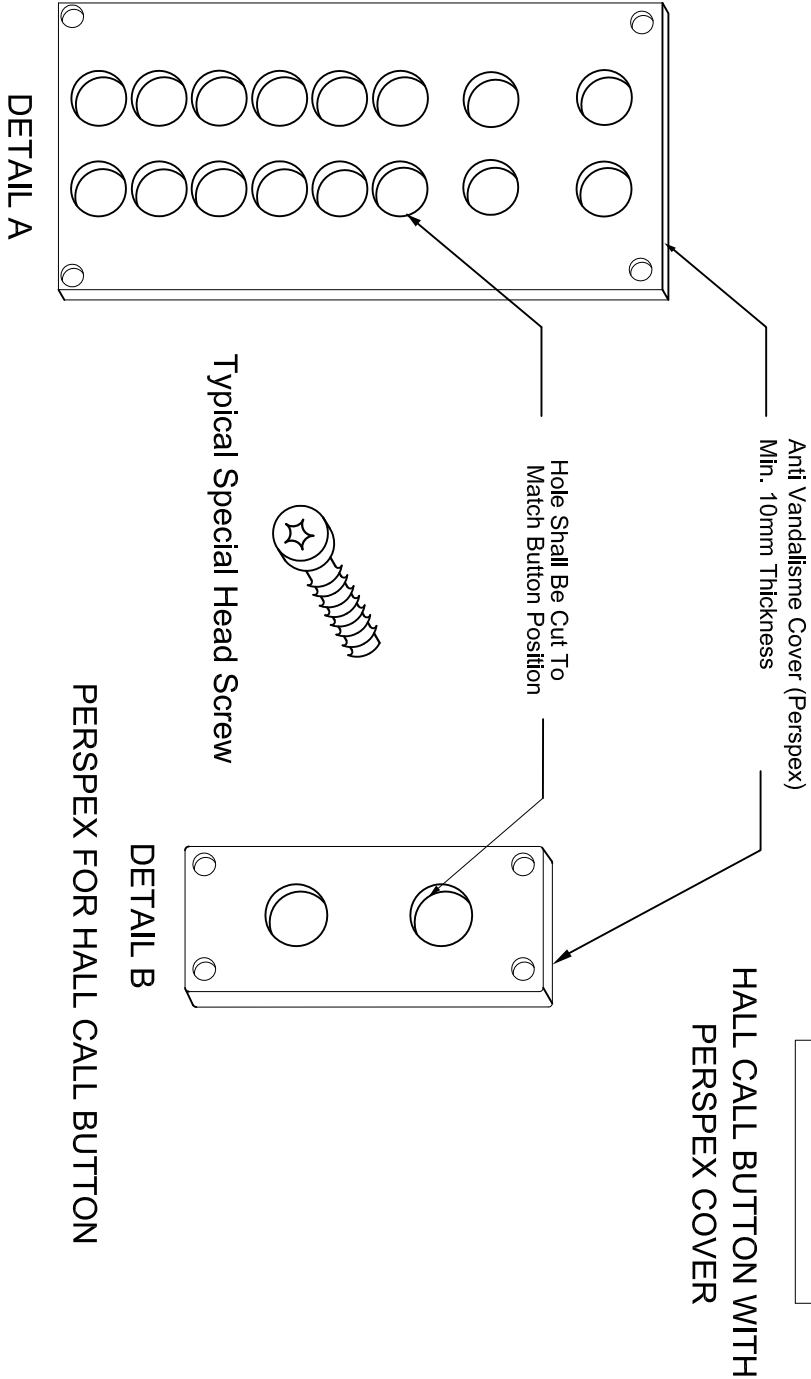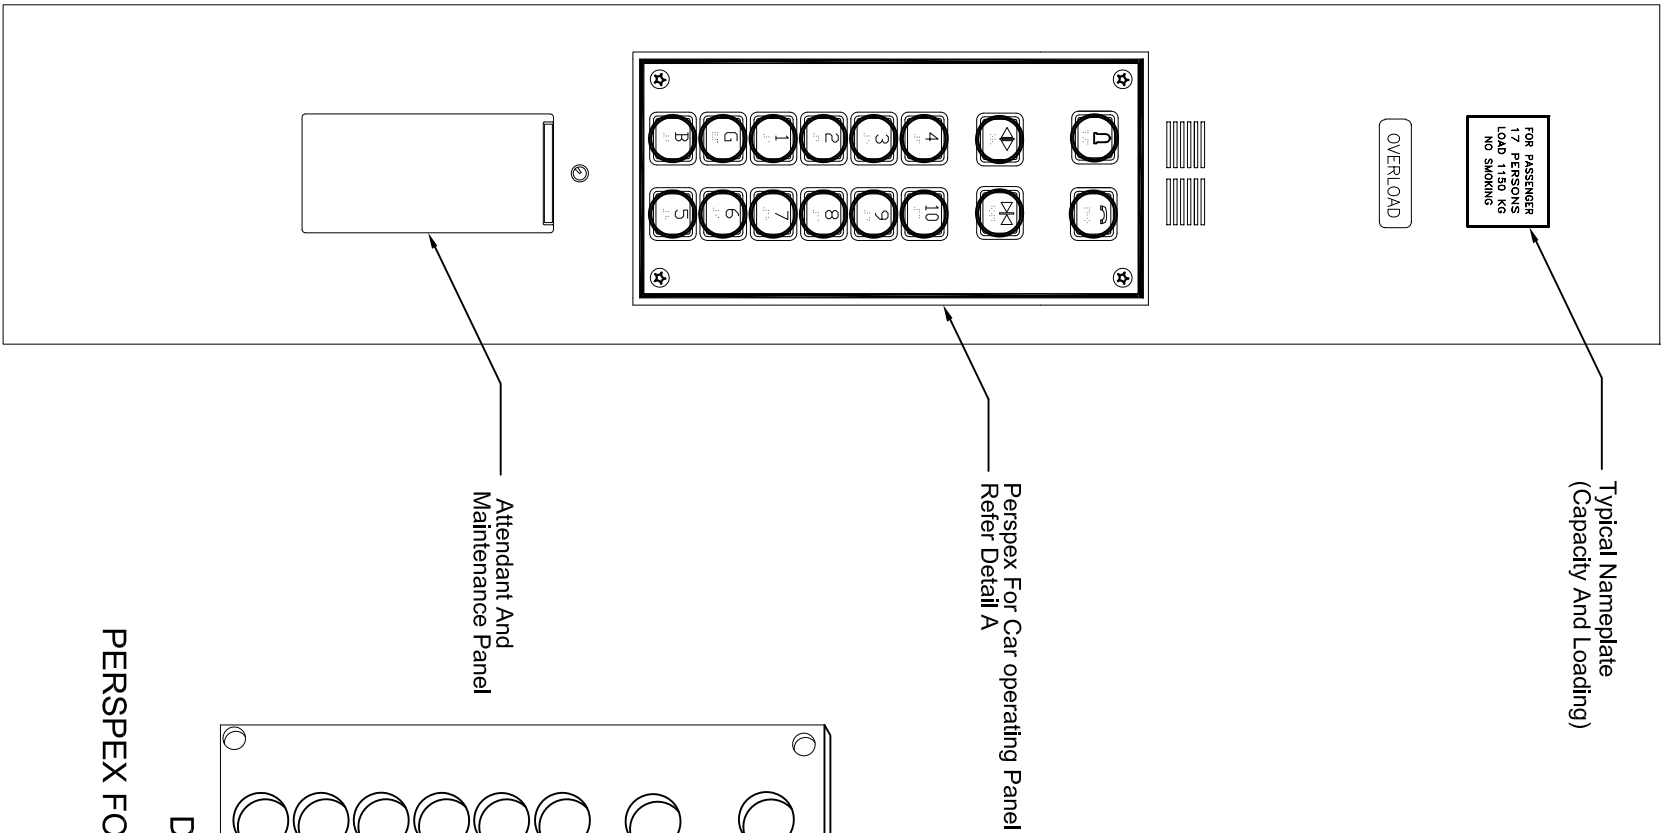

NOTE:
1. Anti vandalisme perspex cover shall be mounted using
special head screw.

NOTE:
1. This is a tender drawing and should not be taken as working
drawing.
2. The standard details shown shall serve as guidelines only,
contractor shall install and modify if necessary to suit the
site condition and subject to S.O approval.





CAR OPERATING PANEL WITH PERSPEX COVER

ANTI-VANDALISME FEATURES
N.T.S



JASA KEPADA RAKYAT
CAWANGAN KEJURUTERAAN MEKANIKAL
Ibu Pejabat JKR Malaysia

DATE	SCALE
2017	NTS
DRAWING NUMBER	
CKM/STD/LF/REV2017/06	

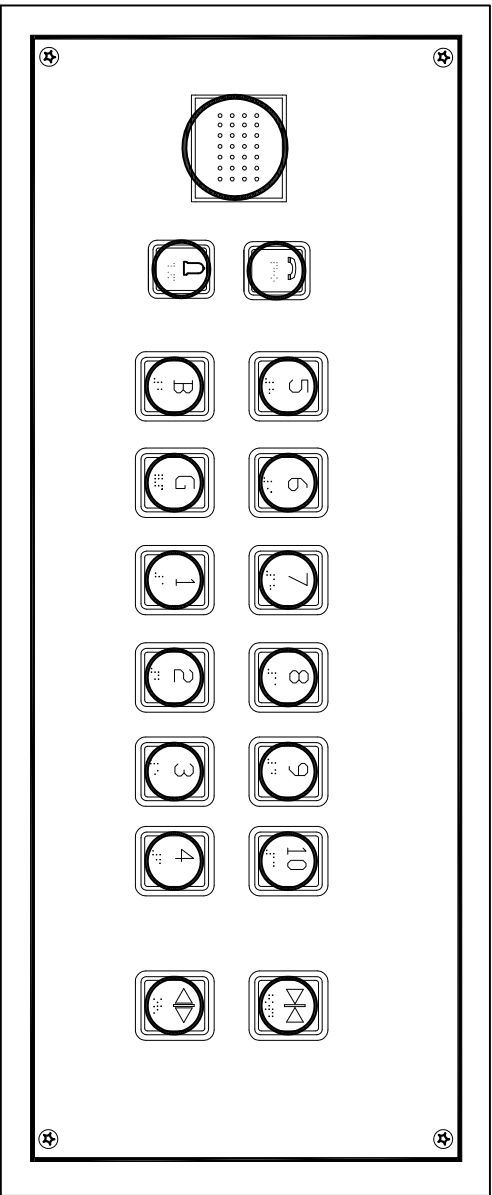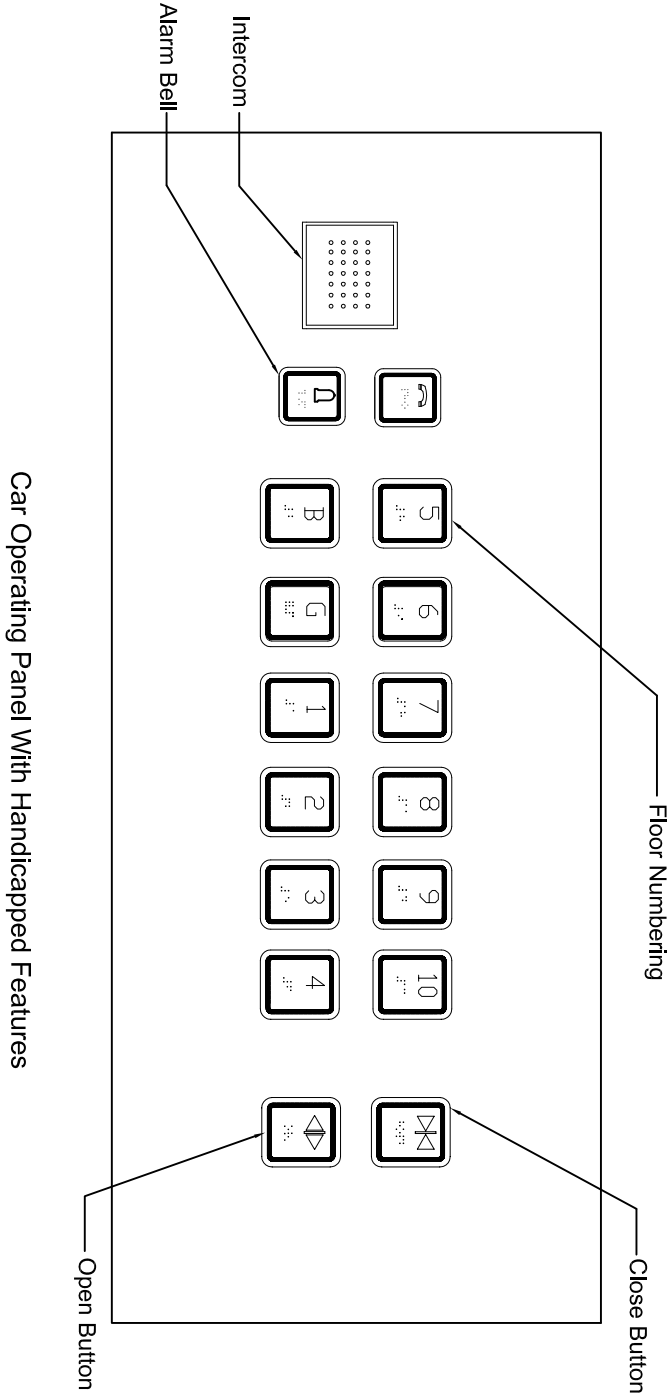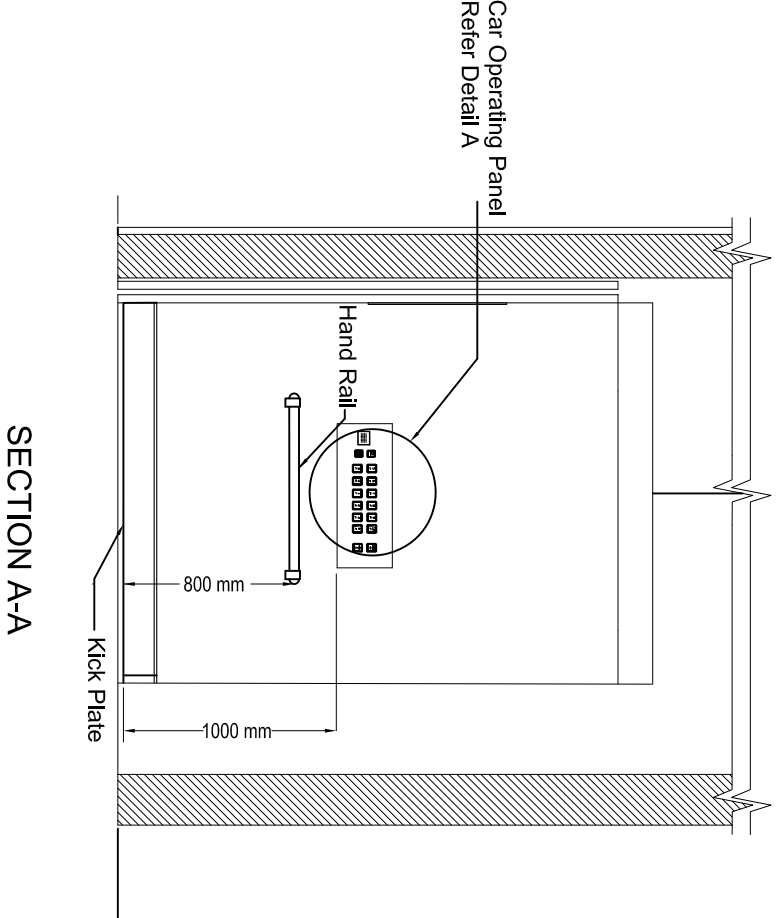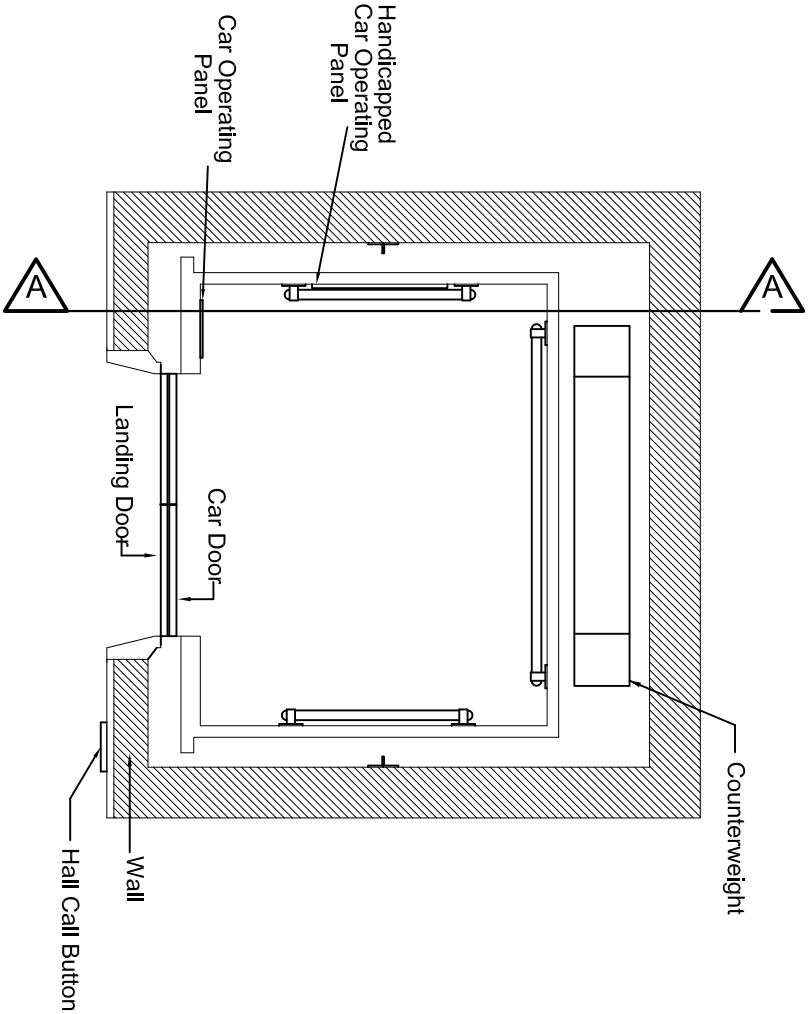

NOTE:

1. This is a tender drawing and should not be taken as working drawing.
2. The standard details shown shall serve as guidelines only, contractor shall install and modify if necessary to suit the site condition and subject to S.O approval.



JASA KEPADA RAKYAT

CAWANGAN KEJURUTERAAN MEKANIKAL
Ibu Pejabat JKR Malaysia

LUKISAN PERINCIAN PIAWAI PEMASANGAN
SISTEM LIFT

DETAIL OF HANDICAPPED FEATURES

DATE 2017 SCALE NTS


DRAWING NUMBER

CKM/STD/LF/REV2017/07


DETAIL OF HANDICAPPED FEATURES

N.T.S


NOTE:
1. Architrave shall be 300 mm for main lobby and for other floors shall be as per Schedule of Design Requirement.
2. Hall Indicator shall be considered at site.

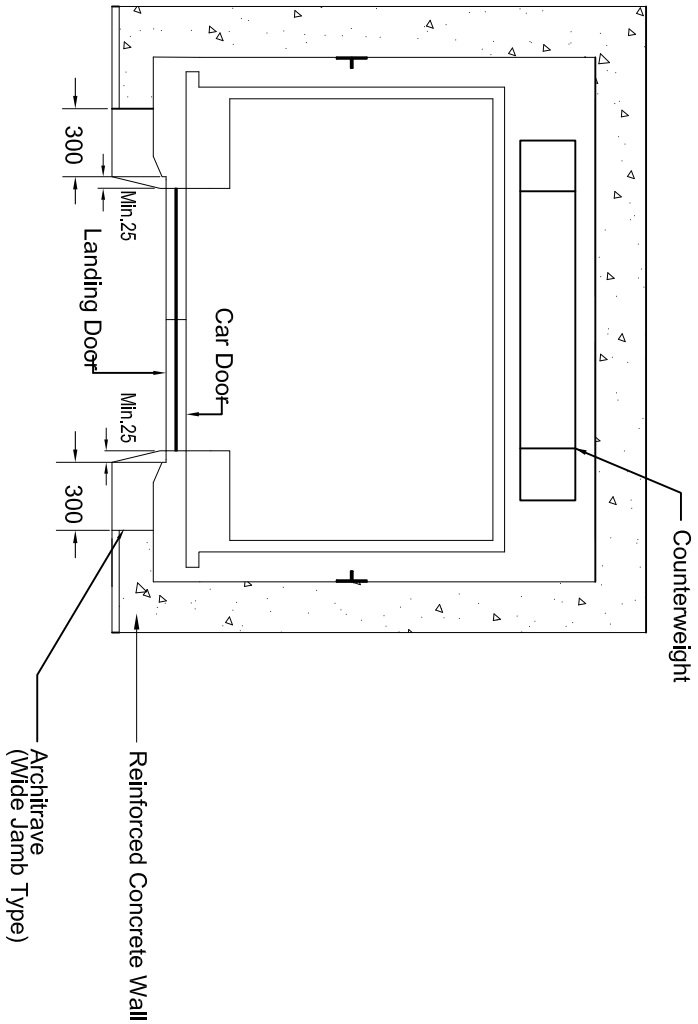

PLAN VIEW

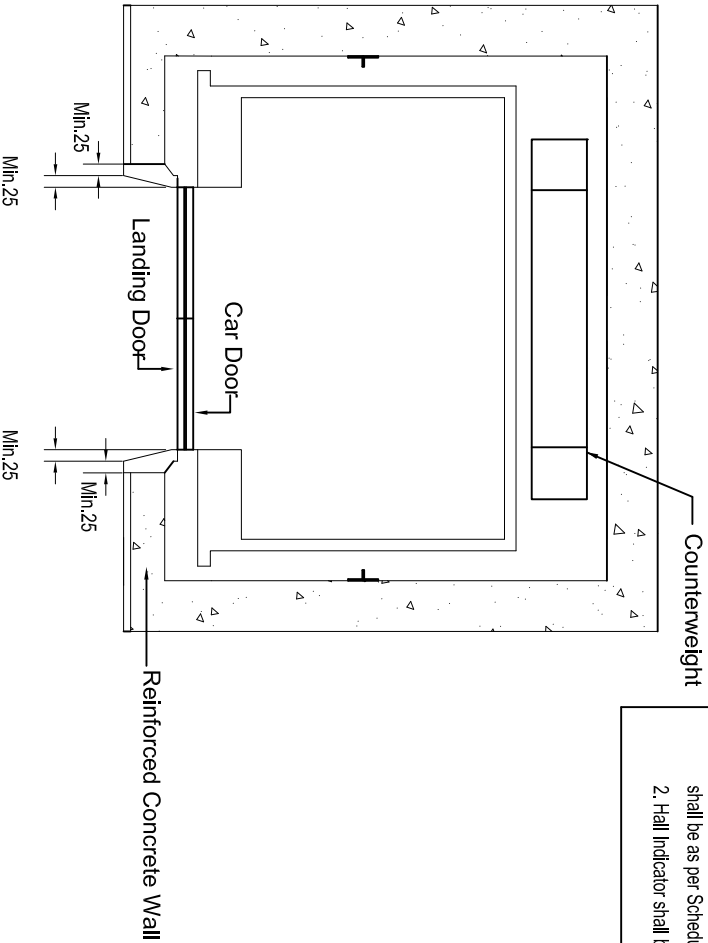


PLAN VIEW

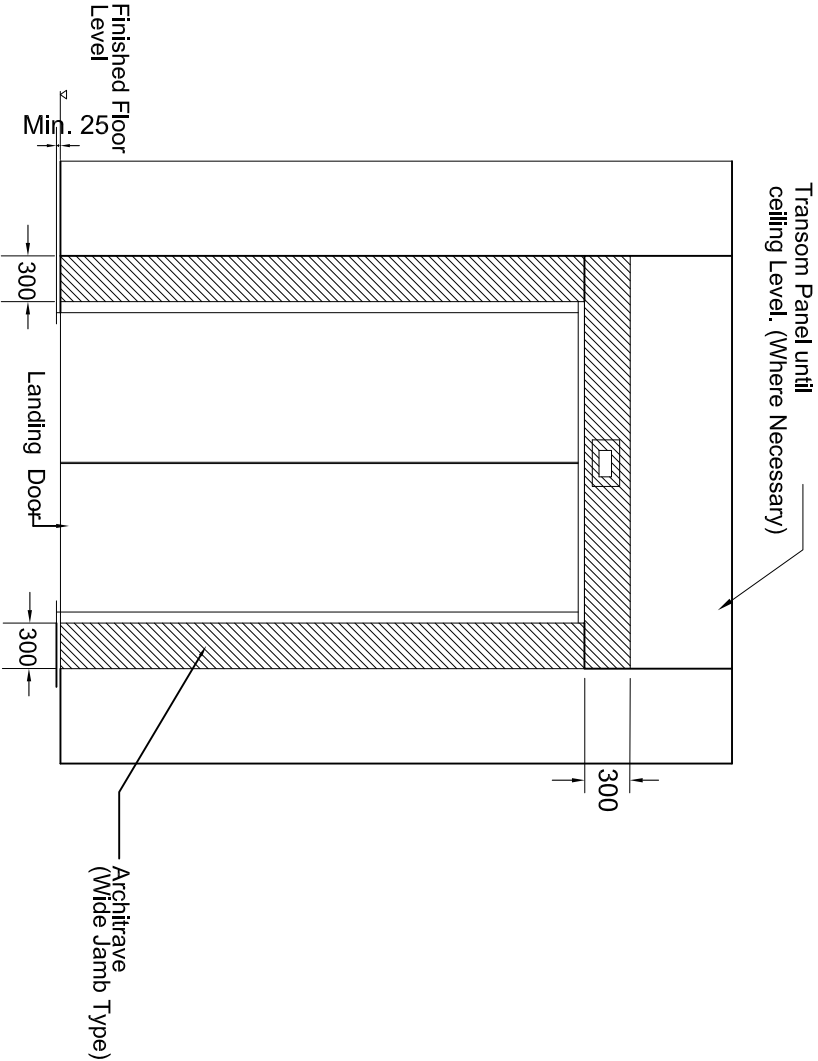

FRONT VIEW

MAIN LOBBY

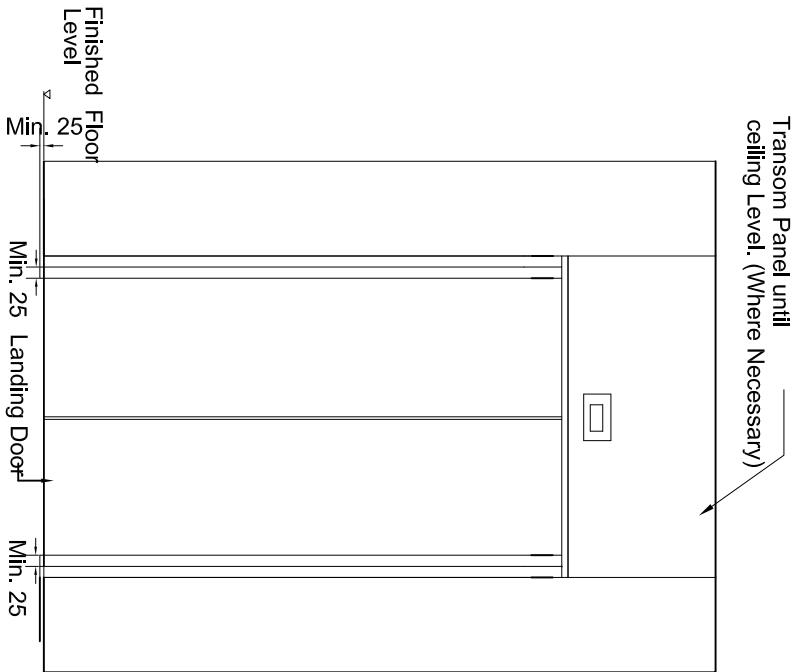

FRONT VIEW

OTHER TYPICAL FLOORS

DETAIL OF ARCHITRAVE

N.T.S







JASA KEPADA RAKYAT

CAWANGAN KEJURUTERAAN MEKANIKAL
Ibu Pejabat JKR Malaysia

LUKISAN PERINCIAAN PIAWAI PEMASANGAN
SISTEM LIFT

DETAIL OF ARCHITRAVE

DATE	SCALE
2017	NTS
DRAWING NUMBER	
CKM/STD/LF/REV2017/08	

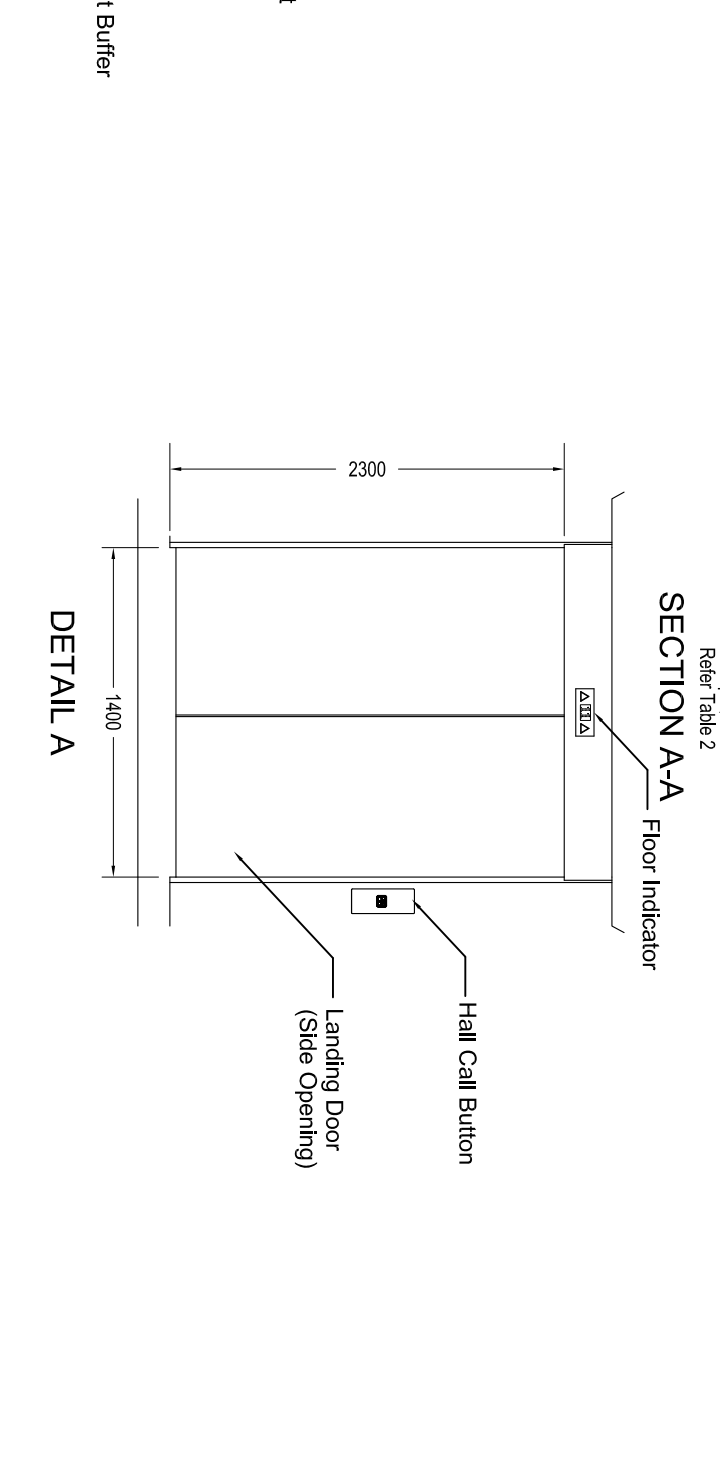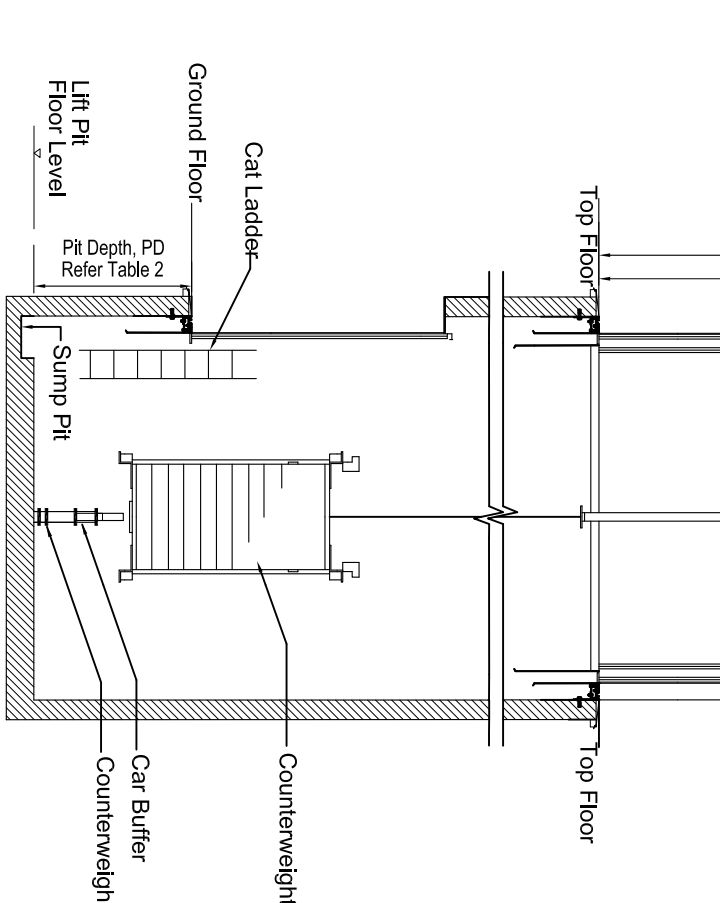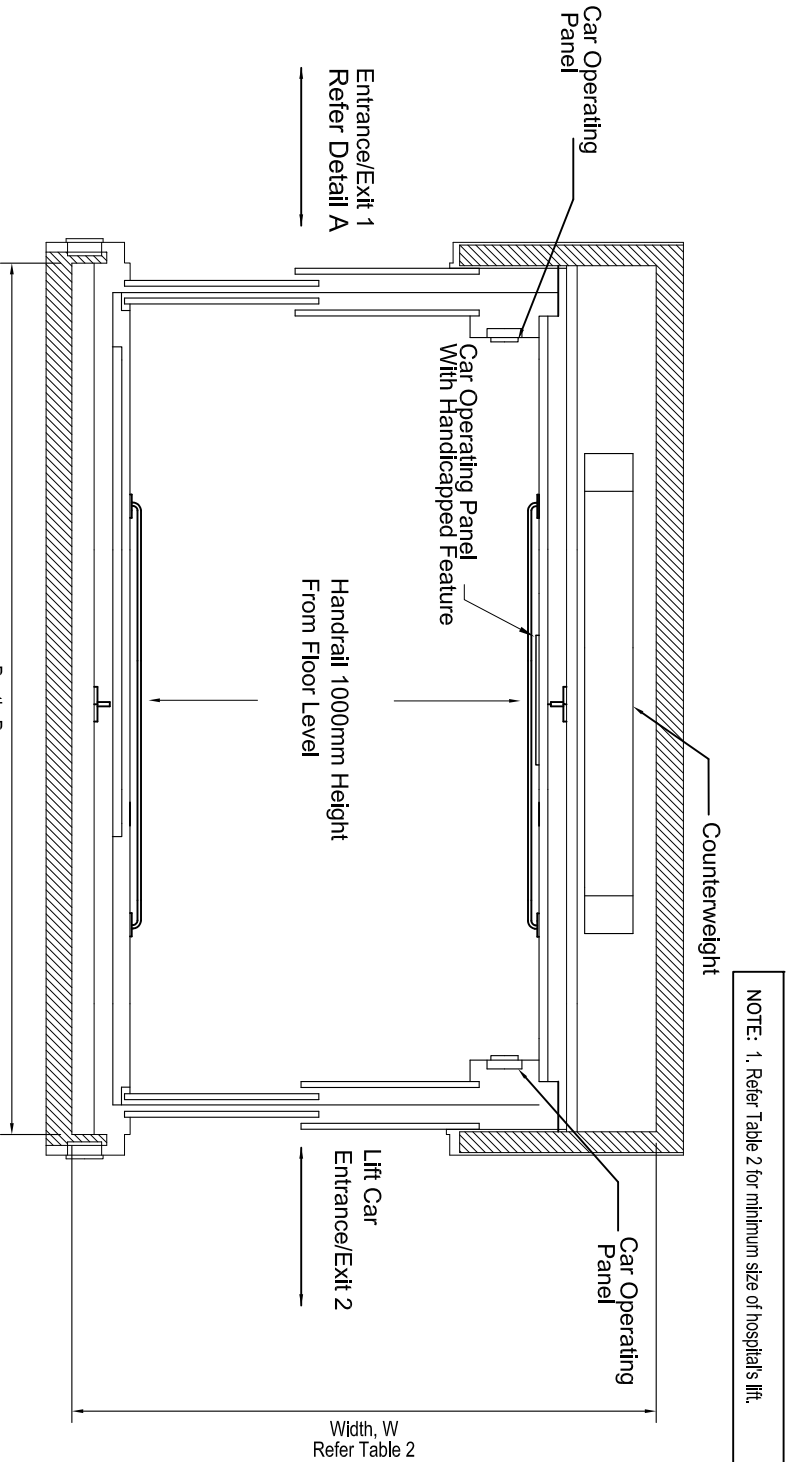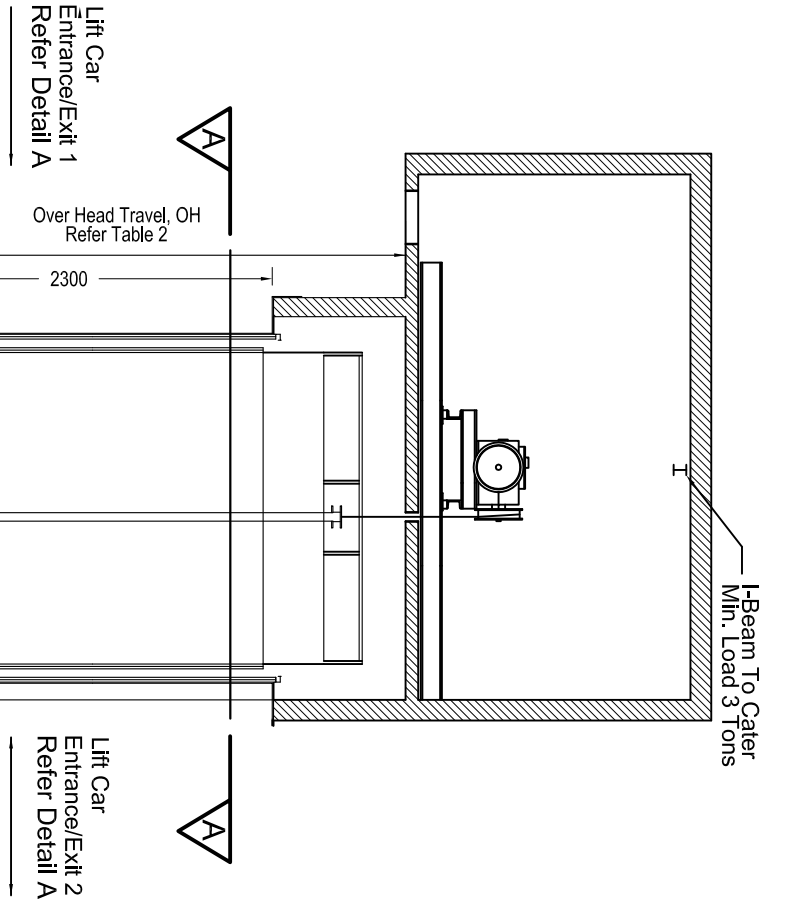

CROSS SECTION VIEW

TABLE 2: MINIMUM SIZE FOR HOSPITAL (STRETCHER/BED LIFT)

LIFT CAPACITY (kg)/TYPE	Internal Car Size (mm) [W x D]	SPEED (m/s)	OPENING DOOR (mm)	LIFT SHAFT CLEARANCE (HOISTWAY)				STRUCTURAL OPENING FOR EACH LANDING DOOR (mm)	
				PIT DEPTH (PD)	OVER HEAD TRAVEL (OH)	WIDTH (W)	DEPTH (D)	WIDTH (SW)	HEIGHT (SH)
1,600 KG STRETCHER	1,400x2,400	1.0	1,400	1,900	5,100	3,000	3,400	1,600	2,300
1,600 KG STRETCHER	1,400x2,400	1.5-2.0	1,400	2,100	5,200	3,000	3,400	1,600	2,300
1,800 KG GOODS LIFT	1,600x2,400	1.0	1,400	1,900	5,100	3,000	3,400	1,600	2,300
1,800 KG GOODS LIFT	1,600x2,400	1.5	1,400	2,100	5,200	3,000	3,400	1,600	2,300
2,500 KG ICU BED	1,800x2,700	1.0-1.5	1,400	2,100	5,200	3,000	3,700	1,600	2,300

NOTE: 1. Refer Table 2 for minimum size of hospital's lift.

NOTE:

1. This is a tender drawing and should not be taken as working drawing.
2. The standard details shown shall serve as guidelines only, contractor shall install and modify if necessary to suit the site condition and subject to S.O approval.




JASA KEPADA RAKYAT

CAWANGAN KEJURUTERAAN MEKANIKAL
Ibu Pejabat JKR Malaysia

LUKSIAN PERINCIAAN PIAVAI PEMASANGAN
SISTEM LIFT


DETAIL OF THROUGH DOOR LIFT

DATE 2017 SCALE NTS
DRAWING NUMBER CKM/STD/LF/REV2017/09

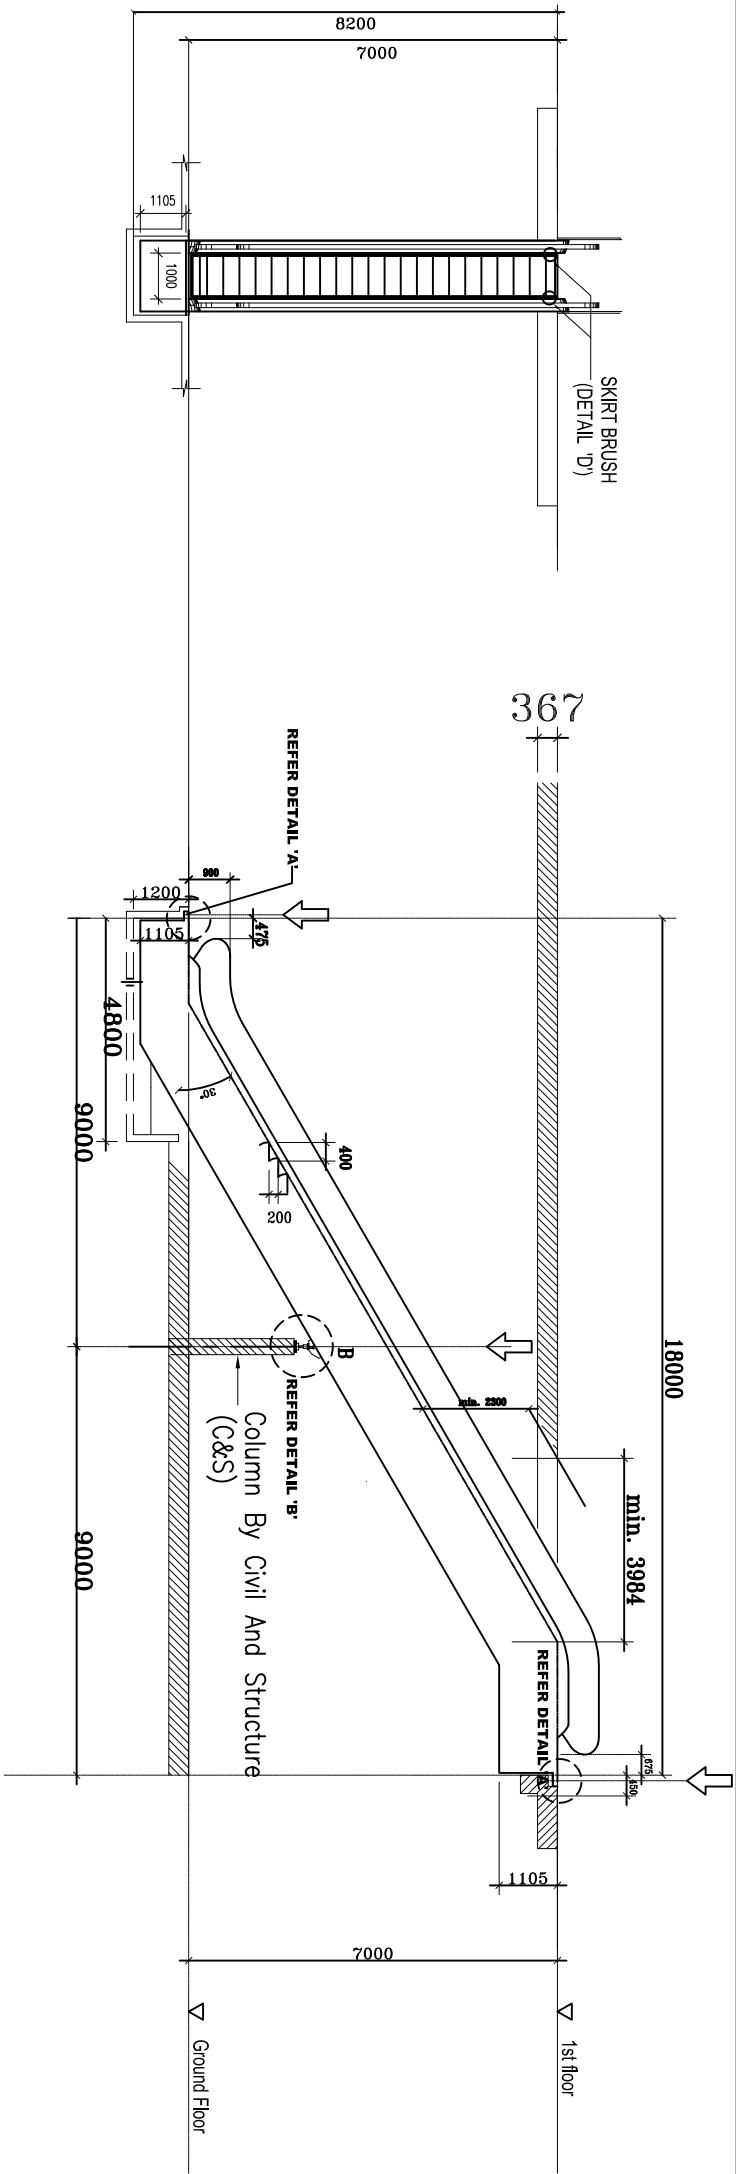


FRONT VIEW

SIDE VIEW

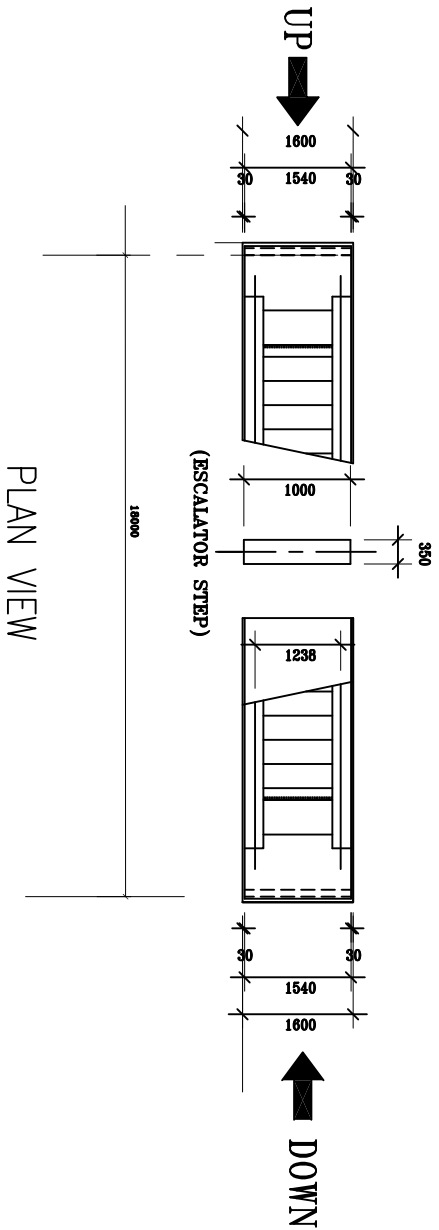


PLAN VIEW

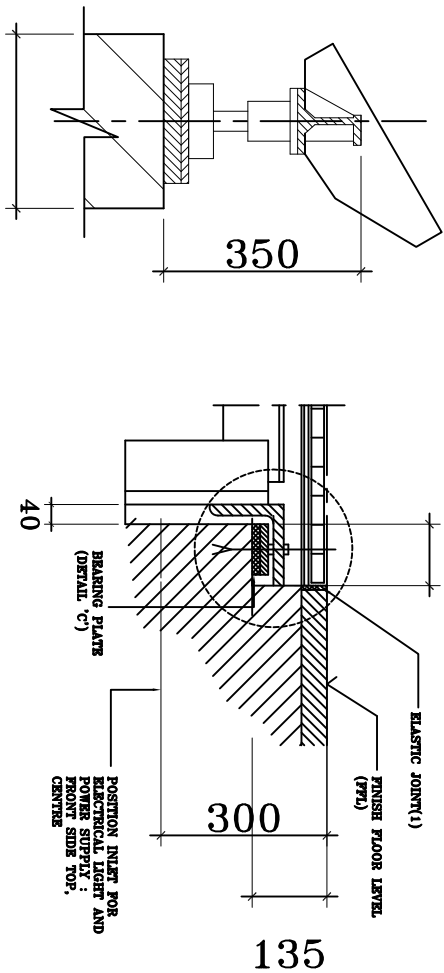


min. 350mm
(Scale - NOT TO SCALE)

DETAIL A
(Scale - NOT TO SCALE)

DETAIL B

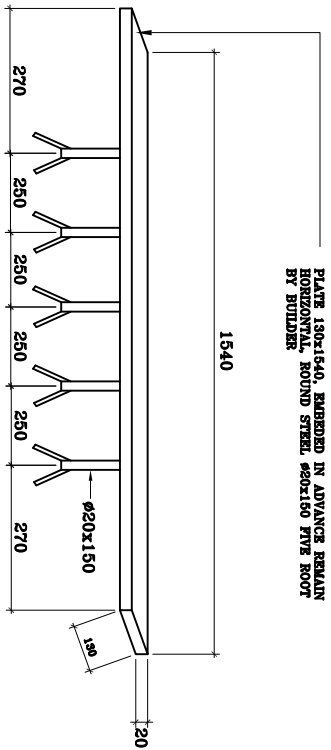

BEARING PLATE DETAIL 'C'
(By Civil And Structure (C&S))

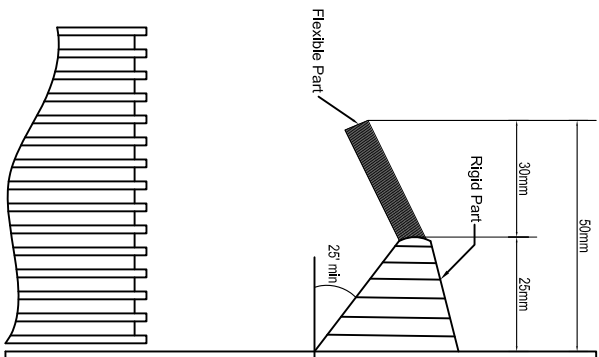

ESCALATOR DETAIL





JASA KEPADA RAKYAT

CAWANGAN KEJURUTERAAN MEKANIKAL
Ibu Pejabat JKR Malaysia


DATE	2017	SCALE	NTS
DRAWING NUMBER	CKM/STD/ESCALATOR/REV2017/01		

NOTE:

1. This is a tender drawing and should not be taken as working drawing.
2. The standard details shown shall serve as guidelines only, contractor shall install and modify if necessary to suit the site condition and subject to S.O approval.
3. mm- Dimension as per specification & design requirement

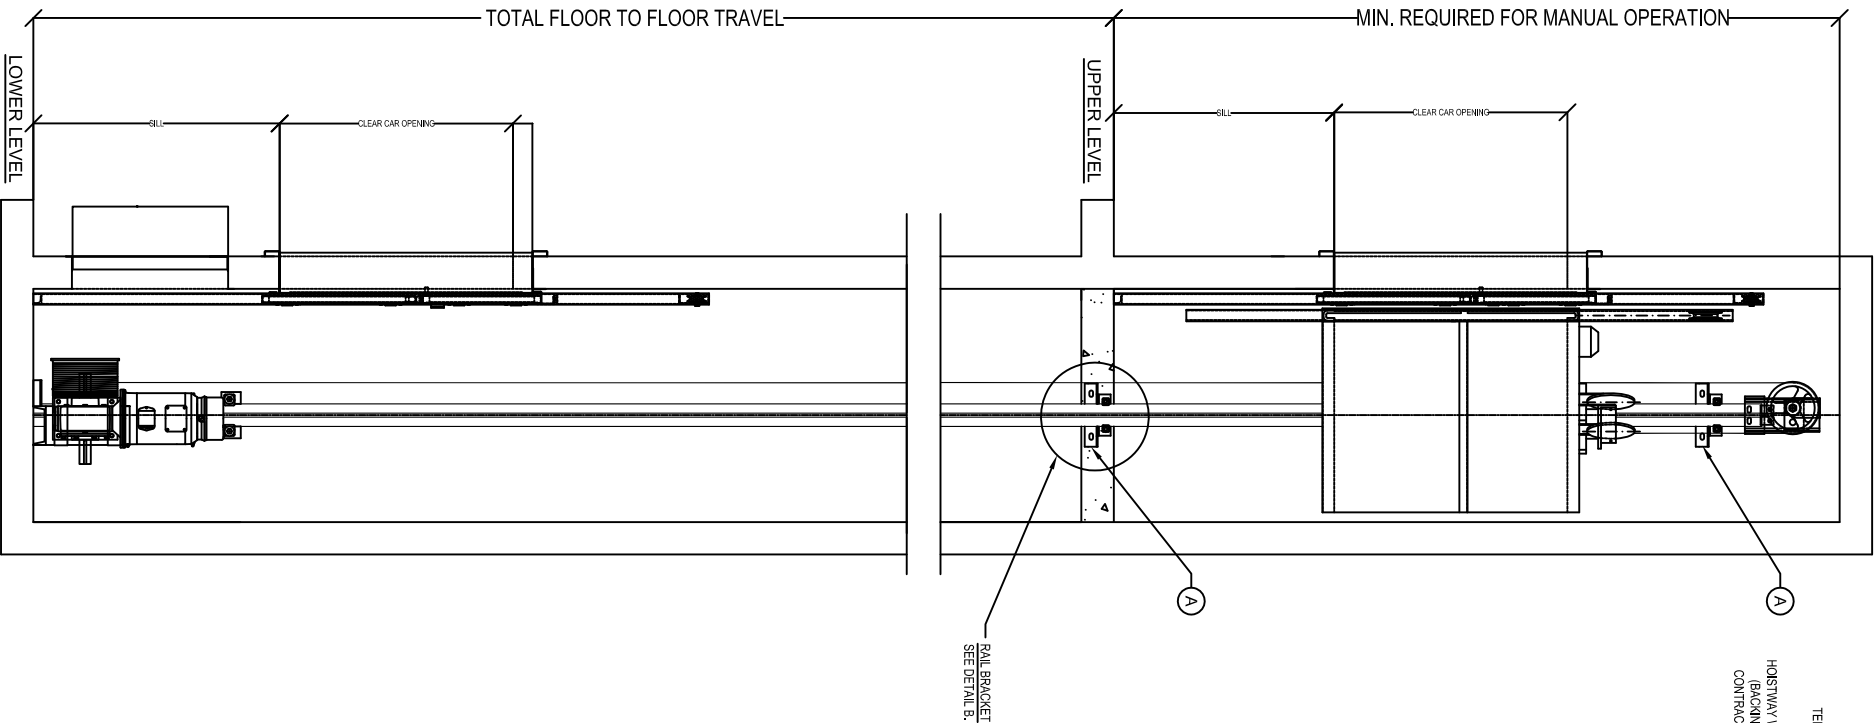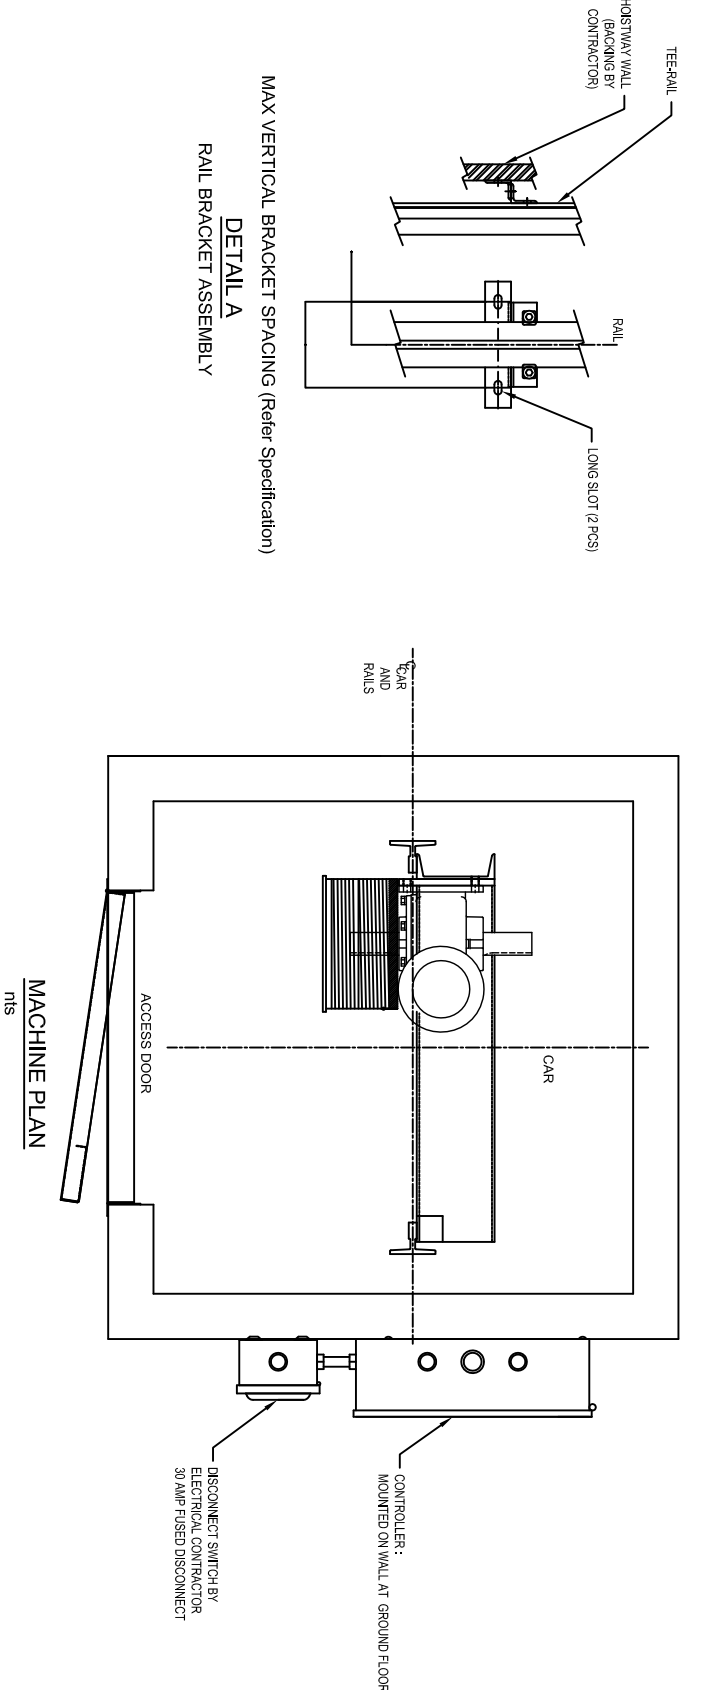

HOISTWAY DIMENSIONS WILL CHANGE PROPORTIONALLY TO CAR SIZE CHANGES

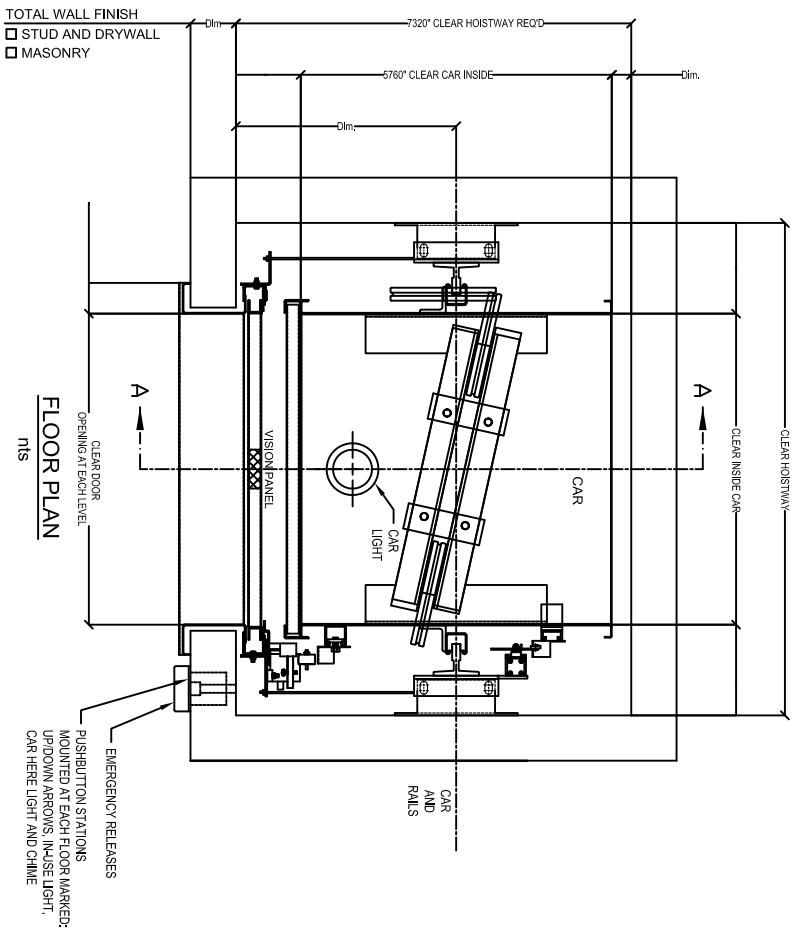

JASA KEPADA RAKYAT

CAWANGAN KEJURUTERAAN MEKANIKAL
Ibu Pejabat JKR Malaysia



TYPICAL DUMB WATER EQUIPMENT

DATE	SCALE
2017	NTS
DRAWING NUMBER	
CKM/STD/DUMB WATER/REV2017/01	

NOTE: 1. This is a tender drawing and should not be taken as working drawing. 2. The standard details shown shall serve as guidelines only, contractor shall install and modify if necessary to suit the site condition and subject to S.O approval. 3. mm- Dimension as per specification & design requirement	This diagram shows a dumbwater installation with a pit at ground level. It includes a 1st Level and a 2nd Level. A cable runs from the 2nd Level down to the 1st Level, where it connects to a motor. The motor is located in a room that may be at floor level if a machine room is used. The door height may be at floor level. The total travel distance is TBD. The door is labeled 'Access Door' and the electrical disconnect is labeled 'Electrical Disconnect'. The door may be at floor level if a machine room is used. The door height may be at floor level. The total travel distance is TBD. The door is labeled 'Access Door' and the electrical disconnect is labeled 'Electrical Disconnect'. This diagram shows a dumbwater installation with a pit overhead motor. It includes a 1st Level and a 2nd Level. A cable runs from the 2nd Level down to the 1st Level, where it connects to a motor. The motor is located in a room that may be at floor level if a machine room is used. The door height may be at floor level. The total travel distance is TBD. The door is labeled 'Access Door' and the electrical disconnect is labeled 'Electrical Disconnect'. The door may be at floor level if a machine room is used. The door height may be at floor level. The total travel distance is TBD. The door is labeled 'Access Door' and the electrical disconnect is labeled 'Electrical Disconnect'.
---	---

NOTE:

1. This is a tender drawing and should not be taken as working drawing.
2. The standard details shown shall serve as guidelines only, contractor shall install and modify if necessary to suit the site condition and subject to S.O approval.
3. Dimension as per specification & design requirement

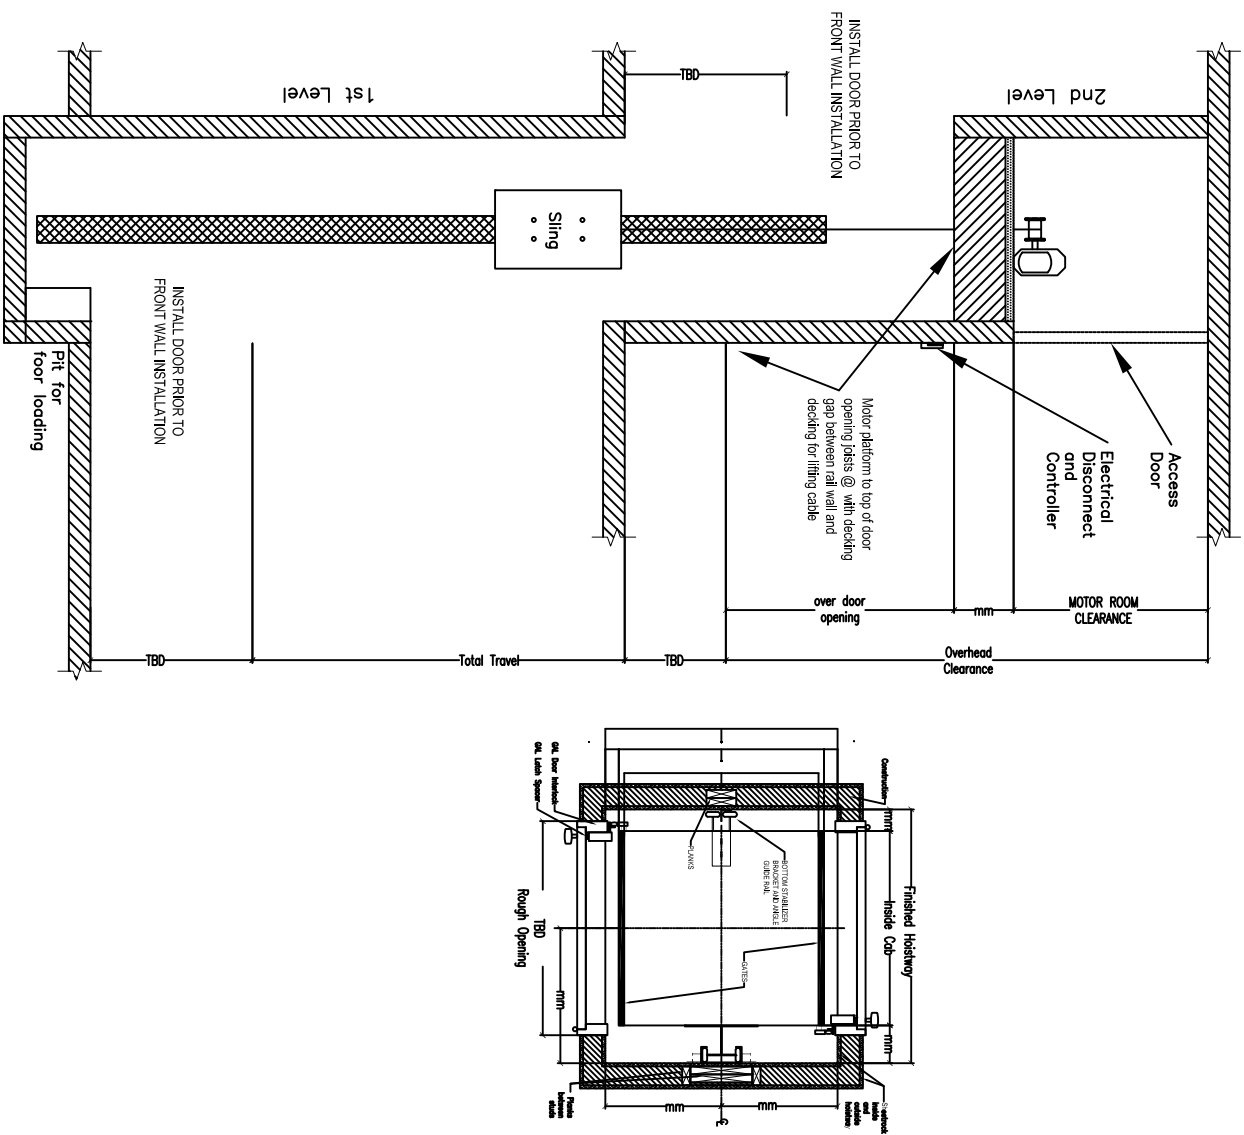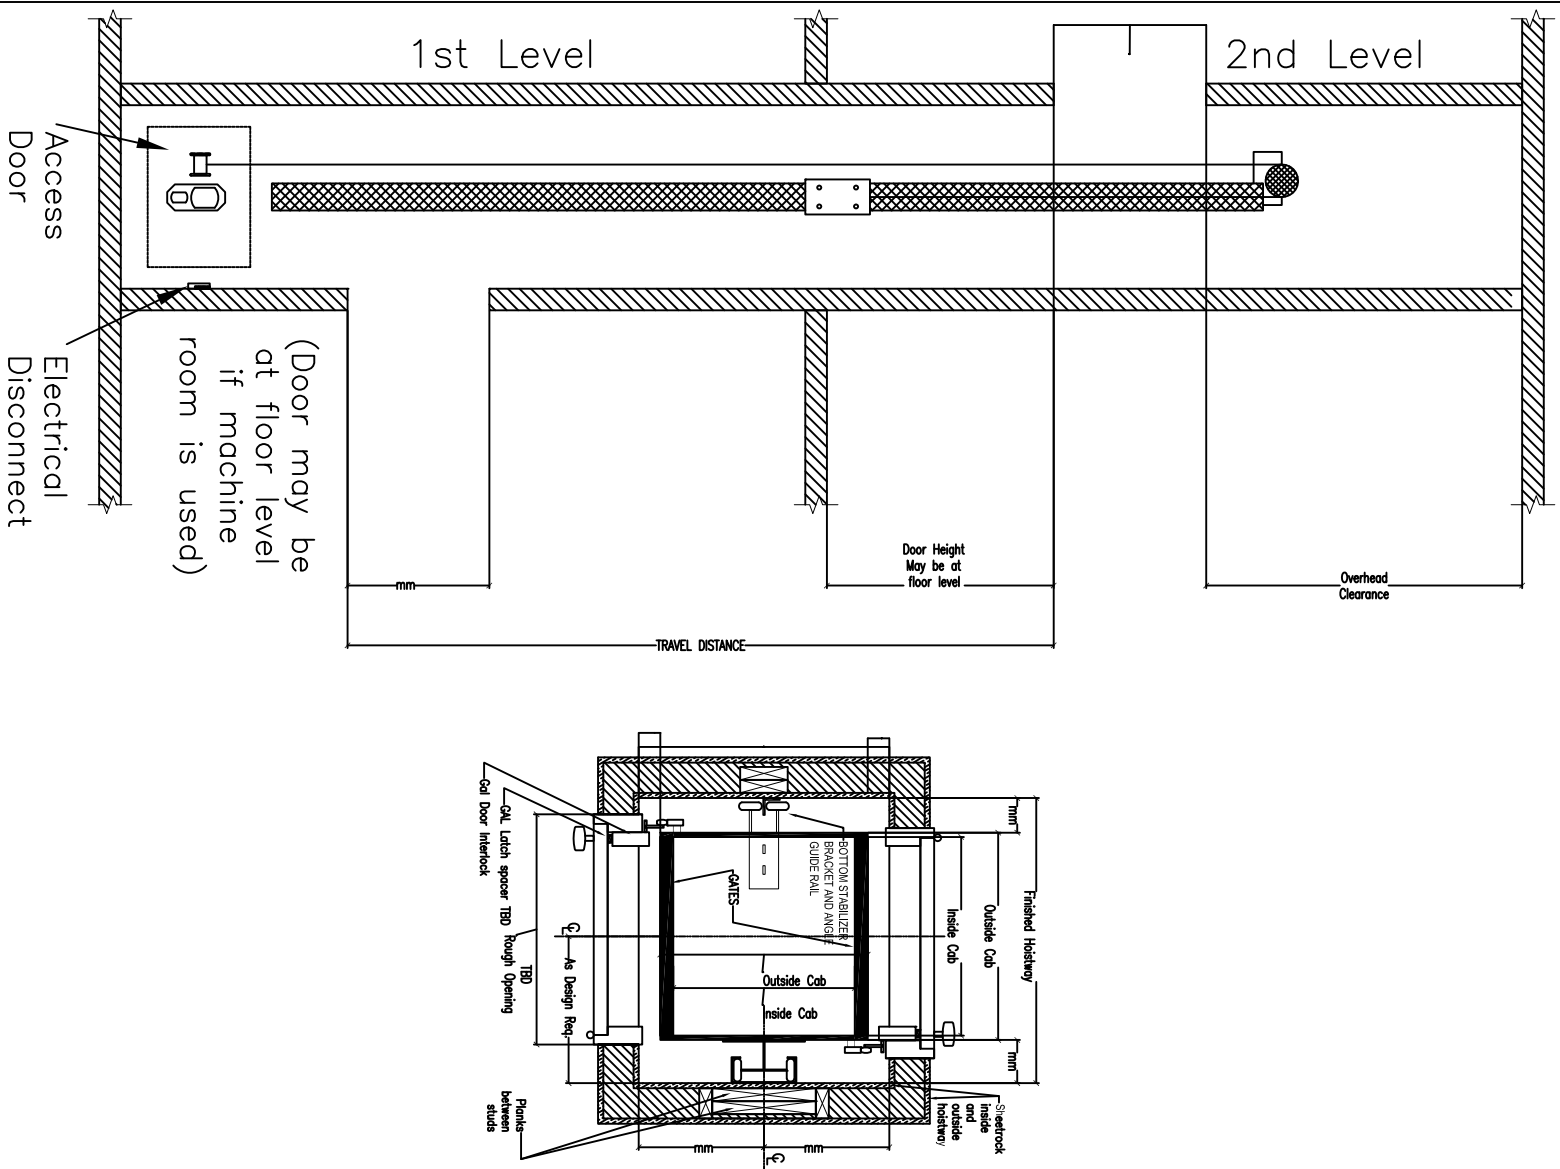

TYPICAL DUMBWAITER INSTALLATION (FRONT BACK)
(WITH PIT AT GROUND LEVEL)

TYPICAL DUMBWAITER INSTALLATION (FRONT BACK),
(WITH PIT OVERHEAD MOTOR)

TYPICAL DUMBWAITER INSTALLATION (FRONT BACK)

**TYPICAL DUMB WATER INSTALLATION
(FRONT BACK)**

SAWANGAN KEJURUTERAAN MEKANIKAL
Ibu Pejabat JKR Malaysia



JASA KEPADA RAKYAT

DATE	SCALE
2017	NTS
DRAWING NUMBER	

CKM/STD/DUMB WAITER/REV2017/03

STANDARD MECHANICAL DESIGN DETAIL DRAWING FOR MECHANICAL SYSTEMS IN BUILDINGS

SECTION IV : INTERNAL COLD WATER AND SANITARY PLUMBING SYSTEM

CAWANGAN KEJURUTERAAN MEKANIKAL
IBU PEJABAT JKR MALAYSIA
KUALA LUMPUR



JASA KEPADA RAKYAT

2017

LIST OF DRAWINGS

NO.	DRAWING TITLE	DRAWING NUMBER
A	INTERNAL COLD WATER AND SANITARY PLUMBING SYSTEM	
1	ADJUSTABLE STEEL BAND HANGER	CKM/STD/CWSP/PIPE/REV2017/01
2	ADJUSTABLE CLEVIS HANGER	CKM/STD/CWSP/PIPE/REV2017/02
3	U-BOLT HANGER	CKM/STD/CWSP/PIPE/REV2017/03
4	PIPE CLIPS VERTICAL SUPPORT	CKM/STD/CWSP/PIPE/REV2017/04
5	U-BOLT VERTICAL SUPPORT	CKM/STD/CWSP/PIPE/REV2017/05
6	ADJUSTABLE BAND HANGER DETAILS	CKM/STD/CWSP/PIPE/REV2017/06
7	ADJUSTABLE CLEVIS HANGER DETAILS	CKM/STD/CWSP/PIPE/REV2017/07
8	U-BOLT (NOT TO GRIP PIPE) DETAILS	CKM/STD/CWSP/PIPE/REV2017/08
9	TYPICAL HORIZONTAL PIPE ARRANGEMENT USING U-BOLT HANGER	CKM/STD/CWSP/PIPE/REV2017/09
10	SPACING BETWEEN VARIOUS SIZE OF PIPE USING U-BOLT HANGER	CKM/STD/CWSP/PIPE/REV2017/10
11	PIPE CLIPS SUPPORT DETAILS	CKM/STD/CWSP/PIPE/REV2017/11
12	RECOMMENDED INSTALLATION FOR HORIZONTAL PIPE CLIPS SUPPORT	CKM/STD/CWSP/PIPE/REV2017/12
13	DETAIL OF ABS PIPE THERMAL EXPANSION	CKM/STD/CWSP/PIPE/REV2017/13
14	DETAIL OF PIPE SLEEVE THROUGH FLOOR / SLAB	CKM/STD/CWSP/PIPE/REV2017/14
15	DETAIL OF PIPE SLEEVE THROUGH WALL	CKM/STD/CWSP/PIPE/REV2017/15
B	INTERNAL COLD WATER PLUMBING SYSTEM	
1	RECOMMENDED INSTALLATION METHOD OF INCOMING STAINLESS STEEL PIPE FOR HOT WATER CYLINDER	CKM/STD/CWSP/CW/REV2017/01
2	RECOMMENDED INSTALLATION METHOD OF INCOMING HDPE PIPE FOR HOT WATER CYLINDER	CKM/STD/CWSP/CW/REV2017/02
3	TYPICAL INSTALLATION OF PLASTIC PIPE LAY IN CONCRETE	CKM/STD/CWSP/CW/REV2017/03
4	DETAILS OF HDPE TANK INSTALLATION	CKM/STD/CWSP/CW/REV2017/04
5	DETAILS OF POLY TANK INSTALLATION	CKM/STD/CWSP/CW/REV2017/05
6	DETAILS OF FRP TANK INSTALLATION	CKM/STD/CWSP/CW/REV2017/06
7	DETAILS OF FRP TANK-PIPE & MANHOLE INSTALLATION	CKM/STD/CWSP/CW/REV2017/07
8	DETAILS OF FRP TANK-STEEL BASE INSTALLATION	CKM/STD/CWSP/CW/REV2017/08
9	DETAILS OF FRP TANK INTERNAL REINFORCEMENT SUPPORT & PANEL	CKM/STD/CWSP/CW/REV2017/09
10	DETAILS OF WATER LEVEL INDICATOR INSTALLATION	CKM/STD/CWSP/CW/REV2017/10
11	INSTALLATION METHOD OF WATER HAMMER ARRESTER (WHA) FOR PRESSURE NOT EXCEEDING 150 PSI (10.3 BAR)	CKM/STD/CWSP/CW/REV2017/11
12	INSTALLATION METHOD OF WATER HAMMER ARRESTER (WHA) FOR PRESSURE NOT EXCEEDING 232 PSI (16 BAR)	CKM/STD/CWSP/CW/REV2017/12
13	TYPICAL DETAILS OF PACKAGE BOOSTER PUMP SYSTEM INSTALLATION	CKM/STD/CWSP/CW/REV2017/13
14	DETAILS FOR BOOSTER PUMP	CKM/STD/CWSP/CW/REV2017/14
15	TYPICAL BOOSTER PUMP SWITCHBOARD	CKM/STD/CWSP/CW/REV2017/15
16	SCHEMATIC DETAILS OF PACKAGE BOOSTER PUMP SYSTEM	CKM/STD/CWSP/CW/REV2017/16
17	DETAILS OF FLANGE & NEOPRENE PAD INSTALLATION	CKM/STD/CWSP/CW/REV2017/17
18	DETAILS OF PRESSURE REDUCING VALVE (PRV) INSTALLATION	CKM/STD/CWSP/CW/REV2017/18

NOTE:

1. This is a tender drawing and should not be taken as working drawing.
2. The standard details shown shall serve as guidelines only, contractor shall install and modify if necessary to suit the site condition and subject to S.O approval.



JASA KEPADA RAKYAT

CAWANGAN KEJURUTERAAN MEKANIKAL
Ibu Pejabat JKR Malaysia

INTERNAL COLD WATER AND SANITARY
PLUMBING SYSTEM

LIST OF DRAWINGS

DATE	SCALE
2017	NTS

LIST OF DRAWINGS

NO.	DRAWING TITLE	DRAWING NUMBER
C	SANITARY PLUMBING SYSTEM	
1	DETAILS OF SANITARY PIPE INSTALLATION FOR SINK-GROUND FLOOR	CKM/STD/CWSP/SP/REV2017/01
2	DETAILS OF SANITARY PIPE INSTALLATION FOR ASIAN WATER CLOSET (AWC)-GROUND FLOOR	CKM/STD/CWSP/SP/REV2017/02
3	DETAILS OF SANITARY PIPE INSTALLATION FOR EUROPEAN WATER CLOSET (EWC)-GROUND FLOOR	CKM/STD/CWSP/SP/REV2017/03
4	DETAILS OF SANITARY PIPE INSTALLATION FOR BASIN & FLOOR TRAP-ABOVE GROUND FLOOR	CKM/STD/CWSP/SP/REV2017/04
5	DETAILS OF SANITARY PIPE INSTALLATION FOR EUROPEAN WATER CLOSET (EWC) ABOVE GROUND FLOOR	CKM/STD/CWSP/SP/REV2017/05
6	DETAILS OF SANITARY PIPE INSTALLATION FOR ASIAN WATER CLOSET (AWC)-ABOVE GROUND FLOOR	CKM/STD/CWSP/SP/REV2017/06
7	DETAILS OF SANITARY PIPE INSTALLATION FOR FLOOR TRAP UNDER GROUND	CKM/STD/CWSP/SP/REV2017/07
8	DETAILS OF SANITARY PIPE INSTALLATION FOR FLOOR TRAP ABOVE GROUND	CKM/STD/CWSP/SP/REV2017/08
9	DETAILS OF VENT COWL INSTALLATION	CKM/STD/CWSP/SP/REV2017/09
10	DETAILS OF GULLY TRAP INSTALLATION	CKM/STD/CWSP/SP/REV2017/10
11	DETAILS OF GREASE TRAP INSTALLATION	CKM/STD/CWSP/SP/REV2017/11
12	DETAILS OF STAINLESS STEEL OR MILD STEEL WEATHERPROOF LOCKABLE CABINET FOR AUTO DOSING UNIT (ADU) STORAGE	CKM/STD/CWSP/SP/REV2017/12
13	TYPE OF INSTALLATION FOR GREASE TRAP	CKM/STD/CWSP/SP/REV2017/13
14	DETAILS OF INSTALLATION FOR NEUTRALIZATION TANK	CKM/STD/CWSP/SP/REV2017/14
15	DETAILS OF INSPECTION CHAMBER	CKM/STD/CWSP/SP/REV2017/15

NOTE:

1. This is a tender drawing and should not be taken as working drawing.
2. The standard details shown shall serve as guidelines only, contractor shall install and modify if necessary to suit the site condition and subject to S.O approval.



JASA KEPADA RAKYAT

CAWANGAN KEJURUTERAAN MEKANIKAL
Ibu Pejabat JKR Malaysia

INTERNAL COLD WATER AND SANITARY
PLUMBING SYSTEM


LIST OF DRAWINGS

DATE	SCALE
2017	NTS

INTERNAL COLD WATER AND SANITARY PLUMBING SYSTEM



JASA KEPADA RAKYAT

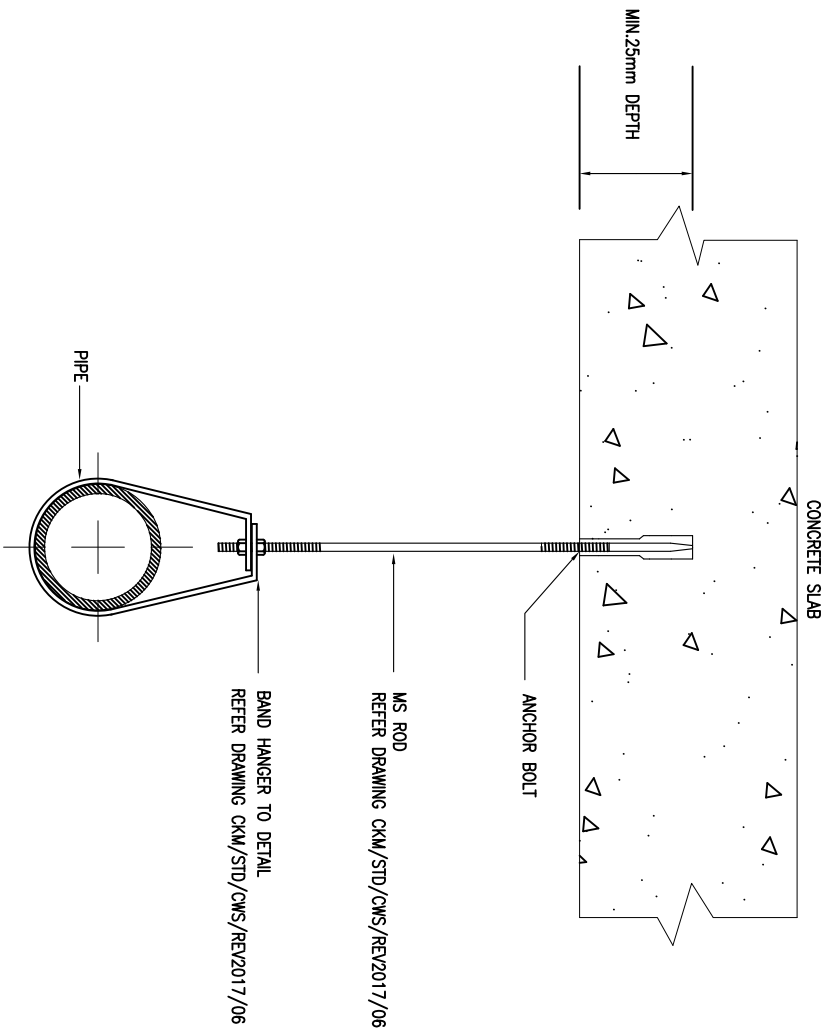

ADJUSTABLE STEEL BAND HANGER
SCALE : NTS

NOTE: For pipe diameter equal or less than 100mm
STEEL BAR (M&E PURLIN) BY MAIN CONTRACTOR

RECOMMENDED MAXIMUM SPACING OF SUPPORT
FOR ALL CLASSES OF METAL & NON-METAL
PIPE FOR WATER (HORIZONTAL)

PIPE SIZE (mm)	RECOMMENDED MAXIMUM SPACING OF SUPPORTS (m)	
	NON-METAL	METAL
20	0.8	1.5
25	0.85	1.8
32	1.0	2.4
40	1.1	2.4
50	1.25	2.4
80	1.65	3.0
100	1.9	3.0


(SOURCE: British Standard Institute. (2010). BS EN 806-4: Specifications
installations inside buildings conveying water for human
consumption. Installation)
NOTE: Water temperature should not exceed 65°C



JASA KEPADA RAKYAT
CAWANGAN KEJURUTERAAN MEKANIKAL
Ibu Pejabat JKR Malaysia

INTERNAL COLD WATER AND SANITARY
PLUMBING SYSTEM

ADJUSTABLE STEEL BAND HANGER

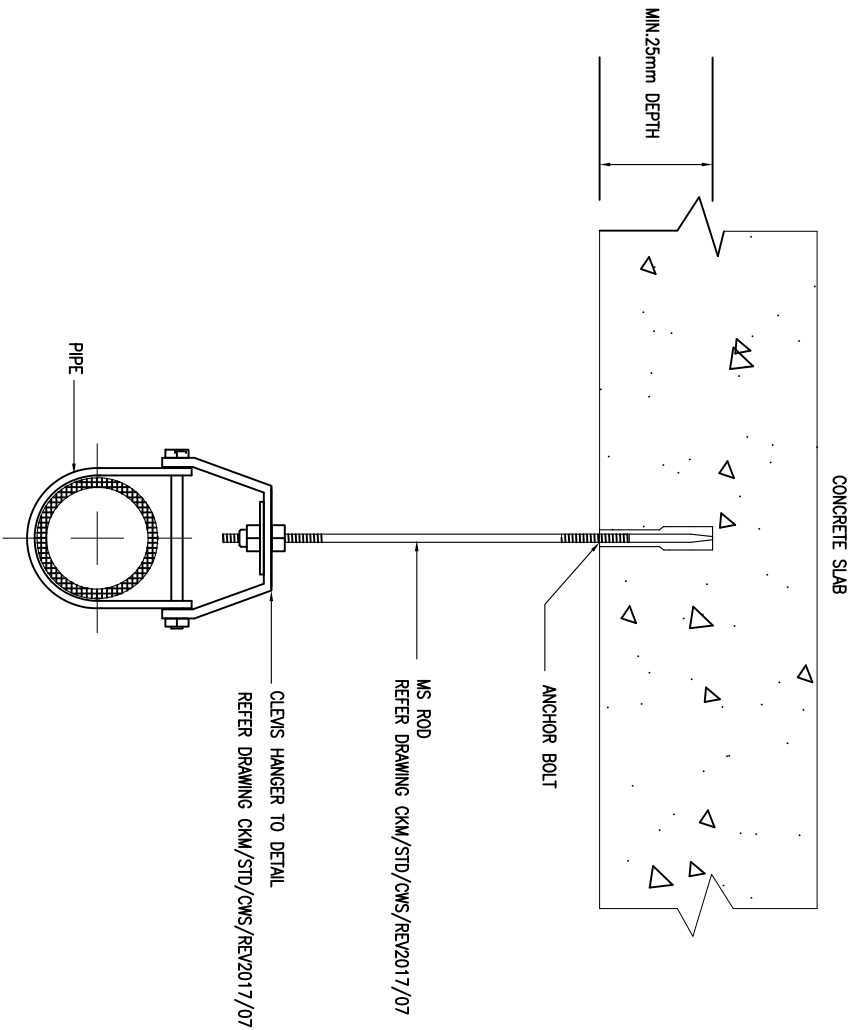

ADJUSTABLE CLEVIS HANGER
SCALE : NTS

NOTE: For pipe diameter more than 100mm
STEEL BAR (M&E PURLIN) BY MAIN CONTRACTOR

RECOMMENDED MAXIMUM SPACING OF SUPPORT
FOR ALL CLASSES OF METAL & NON-METAL
PIPE FOR WATER (HORIZONTAL)

PIPE SIZE (mm)	RECOMMENDED MAXIMUM SPACING OF SUPPORTS (m)	
	NON-METAL	METAL
20	0.8	1.5
25	0.85	1.8
32	1.0	2.4
40	1.1	2.4
50	1.25	2.4
80	1.65	3.0
100	1.9	3.0


(SOURCE: British Standard Institute. (2010). BS EN 806–4: Specifications
installations inside buildings conveying water for human
consumption. Installation)
NOTE: Water temperature should not exceed 65°C



JASA KEPADA RAKYAT
CAWANGAN KEJURUTERAAN MEKANIKAL
Ibu Pejabat JKR Malaysia

INTERNAL COLD WATER AND SANITARY
PLUMBING SYSTEM

ADJUSTABLE CLEVIS HANGER

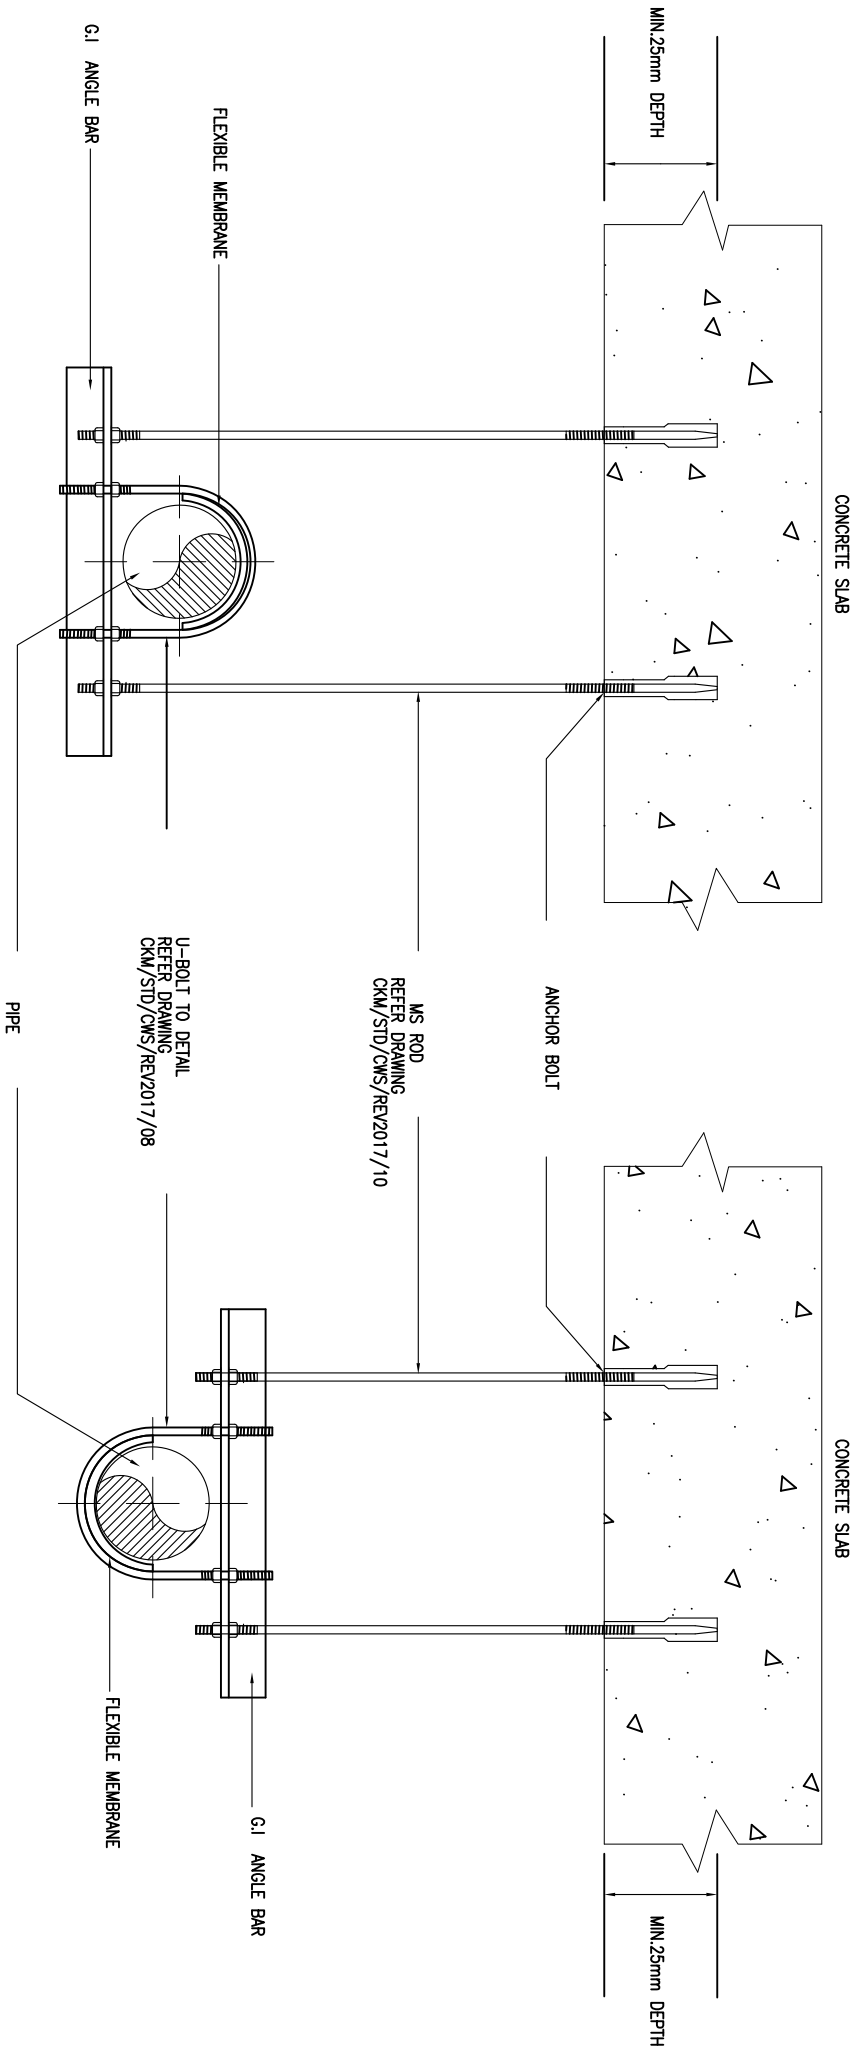

U-BOLT HANGER
SCALE : NTS
STEEL BAR (M&E PURLIN) BY MAIN CONTRACTOR

RECOMMENDED MAXIMUM SPACING OF SUPPORT
FOR ALL CLASSES OF METAL & NON-METAL
PIPE FOR WATER (HORIZONTAL)


PIPE SIZE (mm)	RECOMMENDED MAXIMUM SPACING OF SUPPORTS (m)	
	NON-METAL	METAL
20	0.8	1.5
25	0.85	1.8
32	1.0	2.4
40	1.1	2.4
50	1.25	2.4
80	1.65	3.0
100	1.9	3.0

(SOURCE: British Standard Institute. (2010). BS EN 806-4: Specifications
installations inside buildings conveying water for human
consumption. Installation)
NOTE: Water temperature should not exceed 65°C



JASA KEPADA RAKYAT
CAWANGAN KEJURUTERAAN MEKANIKAL
Ibu Pejabat JKR Malaysia

INTERNAL COLD WATER AND SANITARY
PLUMBING SYSTEM
U-BOLT HANGER

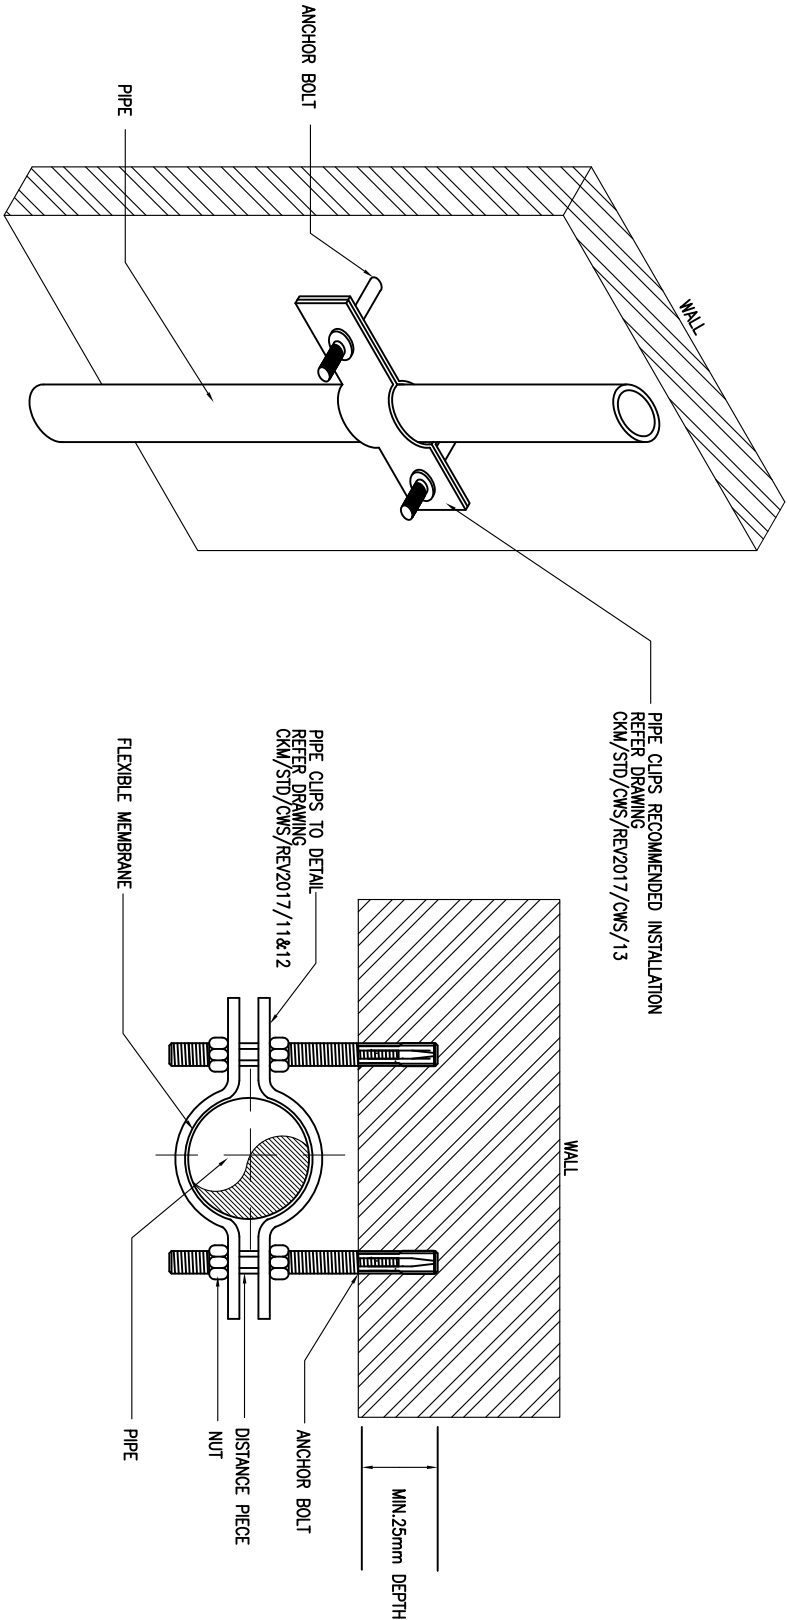

ISOMETRIC VIEW

SECTION VIEW

PIPE CLIPS VERTICAL SUPPORT

SCALE : NTS

RECOMMENDED MAXIMUM SPACING OF SUPPORT
FOR ALL CLASSES OF PIPE FOR WATER (VERTICAL)

PIPE SIZE (mm)	RECOMMENDED MAXIMUM SPACING OF SUPPORTS (m)	
	NON-METAL	METAL
20	1.0	2.4
25	1.1	2.4
32	1.3	3.0
40	1.3	3.0
50	1.6	3.6
80	2.1	3.6
100	2.5	3.6

(SOURCE: British Standard Institute. (2010). BS EN 806-4: Specifications
installations inside buildings conveying water for human
consumption. Installation)

NOTE: Water temperature should not exceed 65°C




JASA KEPADA RAKYAT

CAWANGAN KEJURUTERAAN MEKANIKAL
Ibu Pejabat JKR Malaysia

INTERNAL COLD WATER AND SANITARY
PLUMBING SYSTEM

PIPE CLIPS VERTICAL SUPPORT

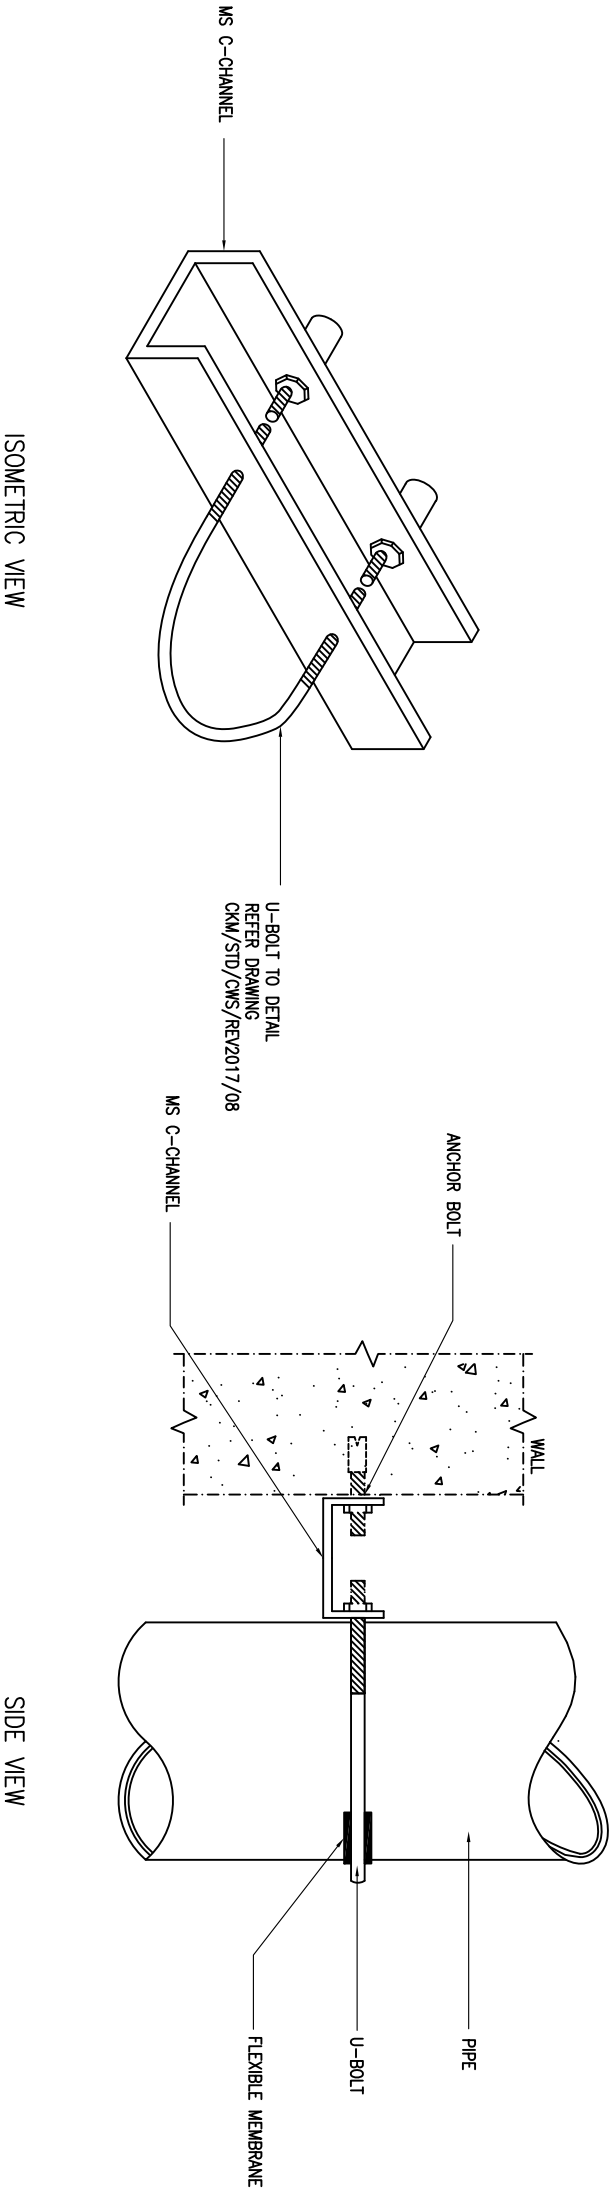

U-BOLT VERTICAL SUPPORT
SCALE : NTS

RECOMMENDED MAXIMUM SPACING OF SUPPORT
FOR ALL CLASSES OF PIPE FOR WATER (VERTICAL)



PIPE SIZE (mm)	RECOMMENDED MAXIMUM SPACING OF SUPPORTS (m)	
	NON-METAL	METAL
20	1.0	2.4
25	1.1	2.4
32	1.3	3.0
40	1.3	3.0
50	1.6	3.6
80	2.1	3.6
100	2.5	3.6

(SOURCE: British Standard Institute. (2010). BS EN 806-4: Specifications installations inside buildings conveying water for human consumption. Installation)
NOTE: Water temperature should not exceed 65°C



JASA KEPADA RAKYAT
CAWANGAN KEJURUTERAAN MEKANIKAL
Ibu Pejabat JKR Malaysia

INTERNAL COLD WATER AND SANITARY
PLUMBING SYSTEM
U-BOLT VERTICAL SUPPORT

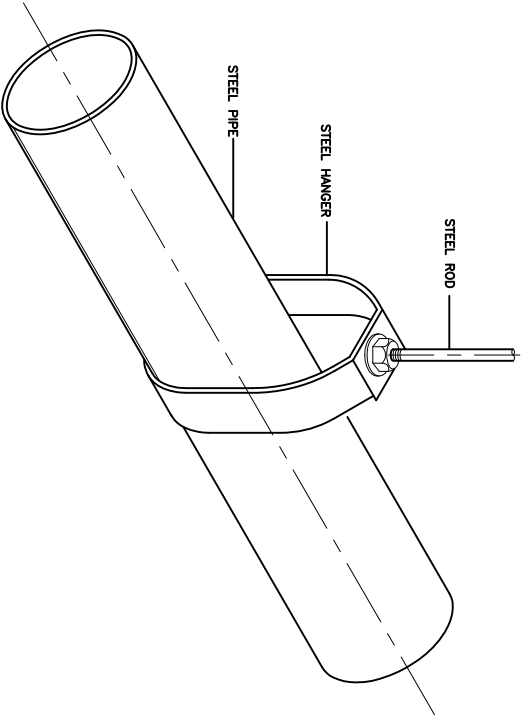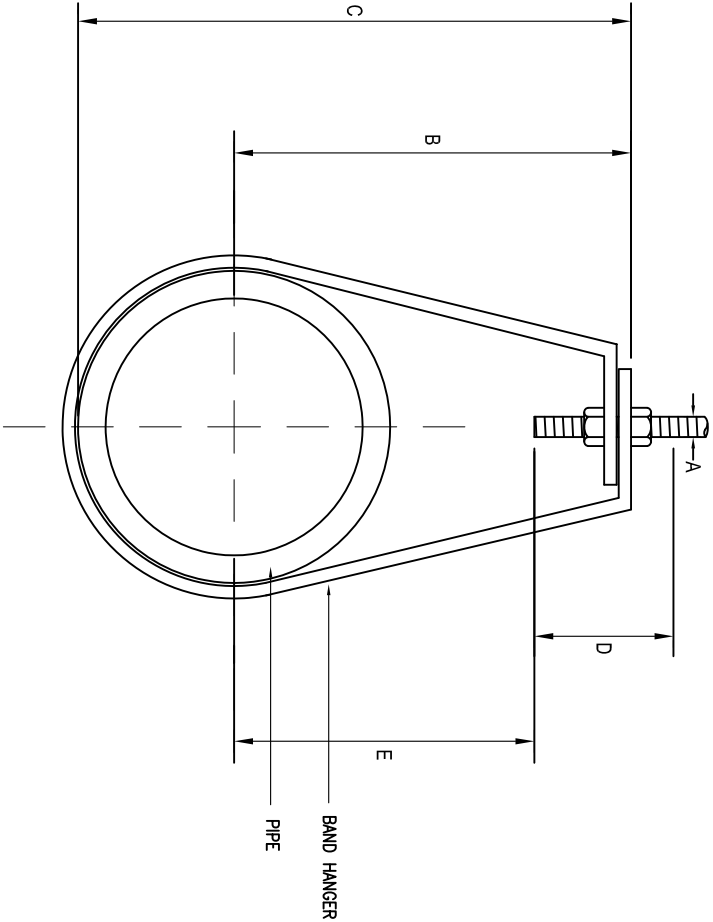

ADJUSTABLE BAND HANGER DETAILS
SCALE : NTS

ISOMETRIC VIEW
SCALE : NTS

DIMENSIONS OF ADJUSTABLE BAND HANGER
ALL DIMENSIONS IN MM

NOM. PIPE SIZE (mm)	A	B	C	D	E	MAX. RECOMMENDED LOAD (KG)
15	10	46.0	58.7	63.5	28.6	277
20	10	52.4	66.7	63.5	33.3	277
25	10	55.6	73.0	63.5	36.5	277
32	10	65.1	87.3	63.5	46.0	277
40	10	69.9	93.7	63.5	49.2	277
50	10	76.2	106.4	63.5	55.6	277
65	13	98.4	134.9	88.9	76.2	440
80	13	108.0	152.4	88.9	84.1	440
90	13	114.3	165.1	88.9	90.5	440
100	16	123.8	181.0	101.6	96.8	567



(SOURCE: MSS SP-58:2002)



JASA KEPADA RAKYAT
CAWANGAN KEJURUTERAAN MEKANIKAL
Ibu Pejabat JKR Malaysia

INTERNAL COLD WATER AND SANITARY
PLUMBING SYSTEM

ADJUSTABLE BAND HANGER DETAILS

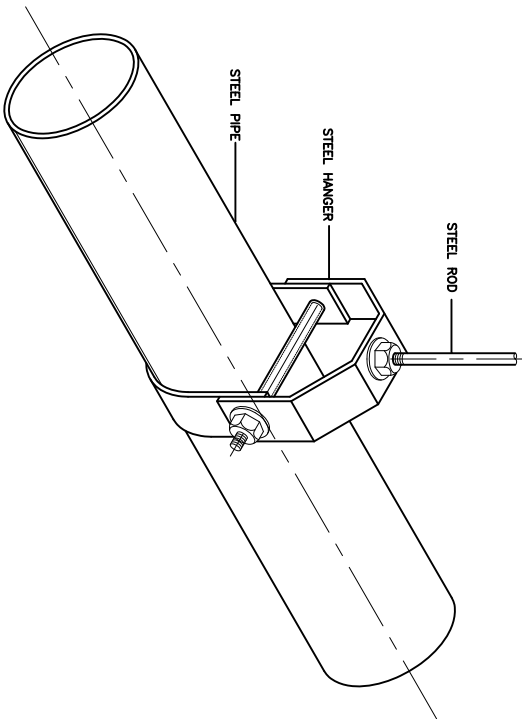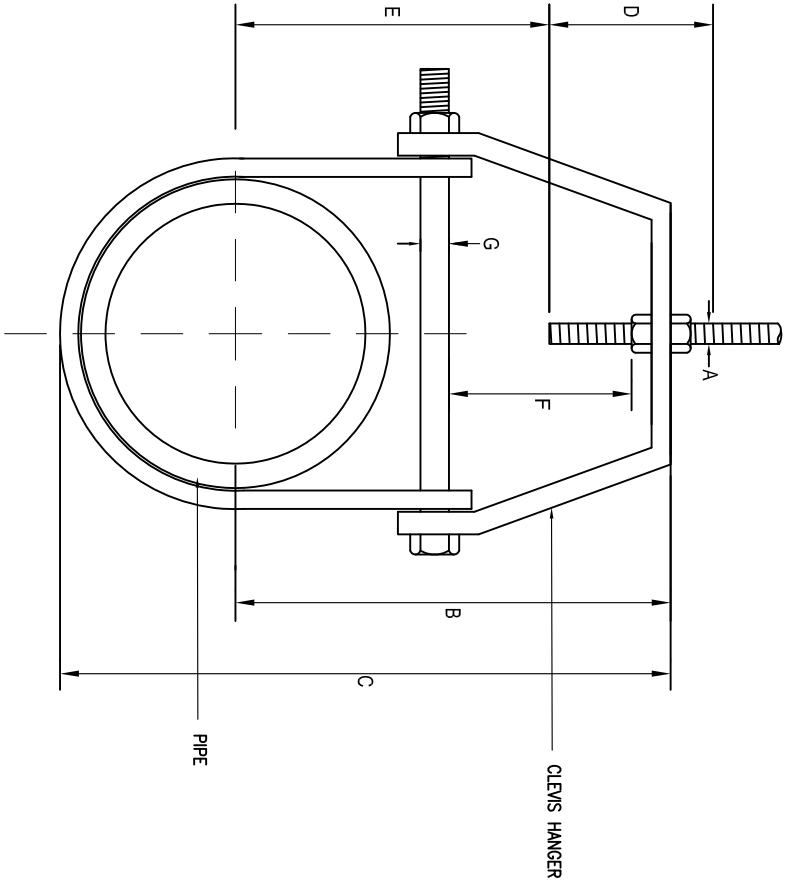

ADJUSTABLE CLEVIS HANGER DETAILS
SCALE : NTS

ISOMETRIC VIEW
SCALE : NTS

DIMENSIONS OF ADJUSTABLE CLEVIS HANGER
ALL DIMENSIONS IN MM

NOM. PIPE SIZE (mm)	A	B	C	D	E	F	G	MAX. RECOMMENDED LOAD (KG)
15	10	42.9	54.0	63.5	22.2	11.1	6.4	331
20	10	47.6	61.9	63.5	25.4	12.7	6.4	331
25	10	54.0	71.4	63.5	31.8	15.9	6.4	331
32	10	65.1	87.3	63.5	44.5	22.2	6.4	331
40	10	76.2	101.6	63.5	54.0	27.0	6.4	331
50	10	93.7	123.8	63.5	74.6	41.3	6.4	331
65	13	119.1	155.6	76.2	96.8	50.8	9.5	612
80	13	120.7	166.7	76.2	98.4	44.5	9.5	612
90	13	125.4	176.2	76.2	103.2	44.5	9.5	612
100	16	141.3	198.4	88.9	114.3	49.2	9.5	649


(SOURCE: MSS SP-58:2002)



JASA KEPADA RAKYAT
CAWANGAN KEJURUTERAAN MEKANIKAL
Ibu Pejabat JKR Malaysia

INTERNAL COLD WATER AND SANITARY
PLUMBING SYSTEM

ADJUSTABLE CLEVIS HANGER DETAILS

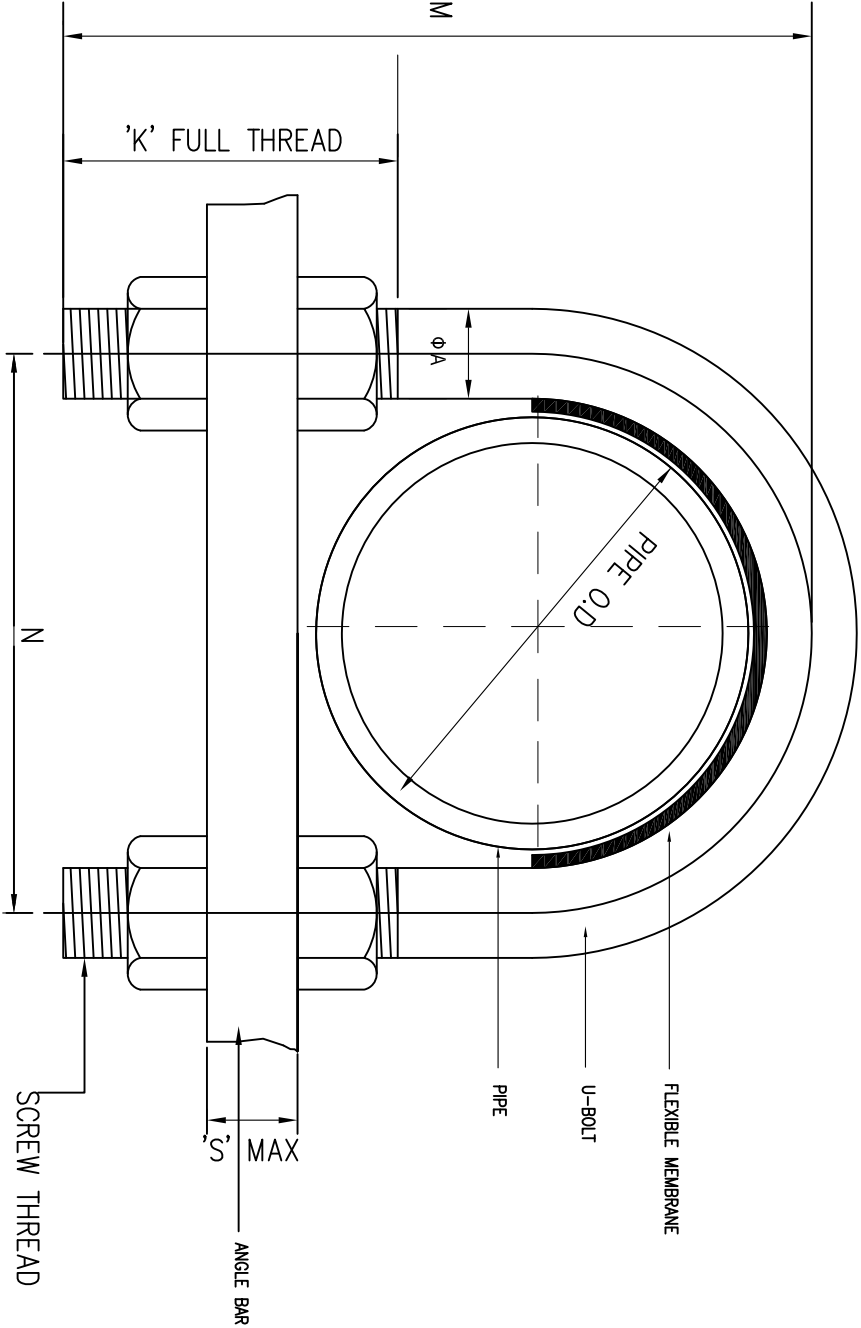

NOTE: Where used on taper flanges of steelwork
taper washers are to be provided

U-BOLT (NOT TO GRIP PIPE) DETAILS
SCALE : NTS

DIMENSIONS OF U-BOLTS (NOT TO GRIP TYPE)
ALL DIMENSIONS IN MM

NOM. PIPE SIZE (mm)	A	N	M	K	S MAX
15	8	40	45	25	10
20	8	45	55	30	10
25	8	50	60	30	10
32	8	60	70	30	10
40	10	65	85	40	16
50	10	80	100	40	16
65	12	95	120	50	19
80	16	110	140	55	19
100	16	140	165	55	19
125	16	165	190	55	19
150	20	195	225	65	19
175	20	220	250	65	19
200	20	250	275	65	19

*THESE U-BOLTS ARE IDENTICAL WITH THE EQUIVALENT SIZES FOR STEEL PIPE
(BS 3974 PART 1:1974)



JASA KEPADA RAKYAT


CAWANGAN KEJURUTERAAN MEKANIKAL
Ibu Pejabat JKR Malaysia

INTERNAL COLD WATER AND SANITARY
PLUMBING SYSTEM


U-BOLT (NOT TO GRIP PIPE) DETAILS

NOTE:

1. Material for U-bolt, angle bar and U-hanger shall be of Galvanized Iron (GI) or S.O approval.

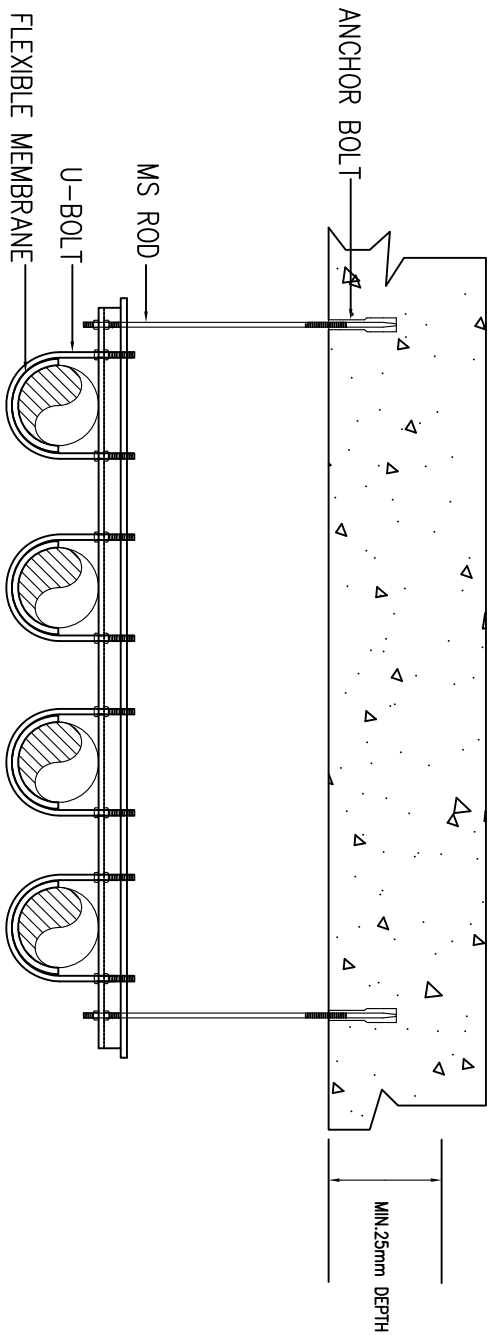

OPTION 1

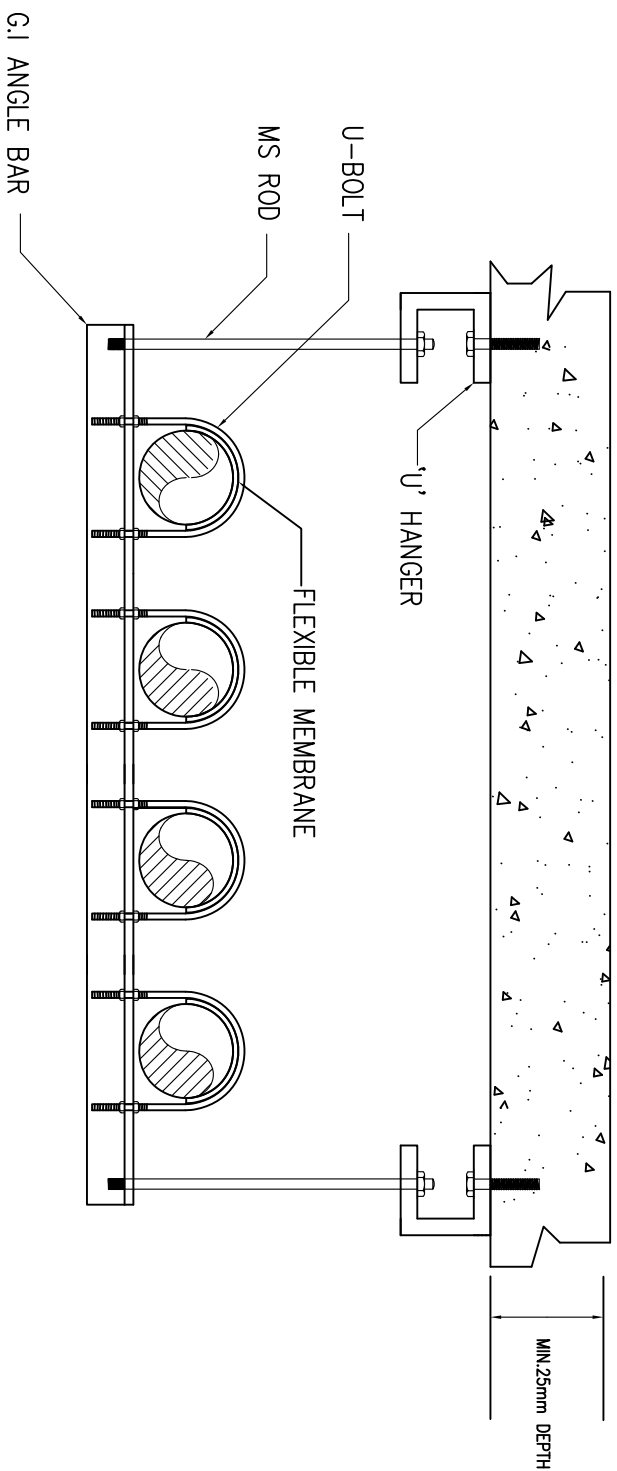

OPTION 2

TYPICAL HORIZONTAL PIPE ARRANGEMENT USING U-BOLT HANGER
SCALE : NTS



JKR
MEKANIKAL

JASA KEPADA RAKYAT

CAWANGAN KEJURUTERAAN MEKANIKAL

Ibu Pejabat JKR Malaysia

INTERNAL COLD WATER AND SANITARY PLUMBING SYSTEM

TYPICAL HORIZONTAL PIPE ARRANGEMENT USING U-BOLT HANGER


DATE: 2017

SCALE: NTS

DRAWING NUMBER: CKM/STD/CWSP/PIPE/REV/2017/09

NOTE:

1. Material for U-bolt, angle bar and U-hanger shall be of Galvanized Iron (GI) or S.O approval.

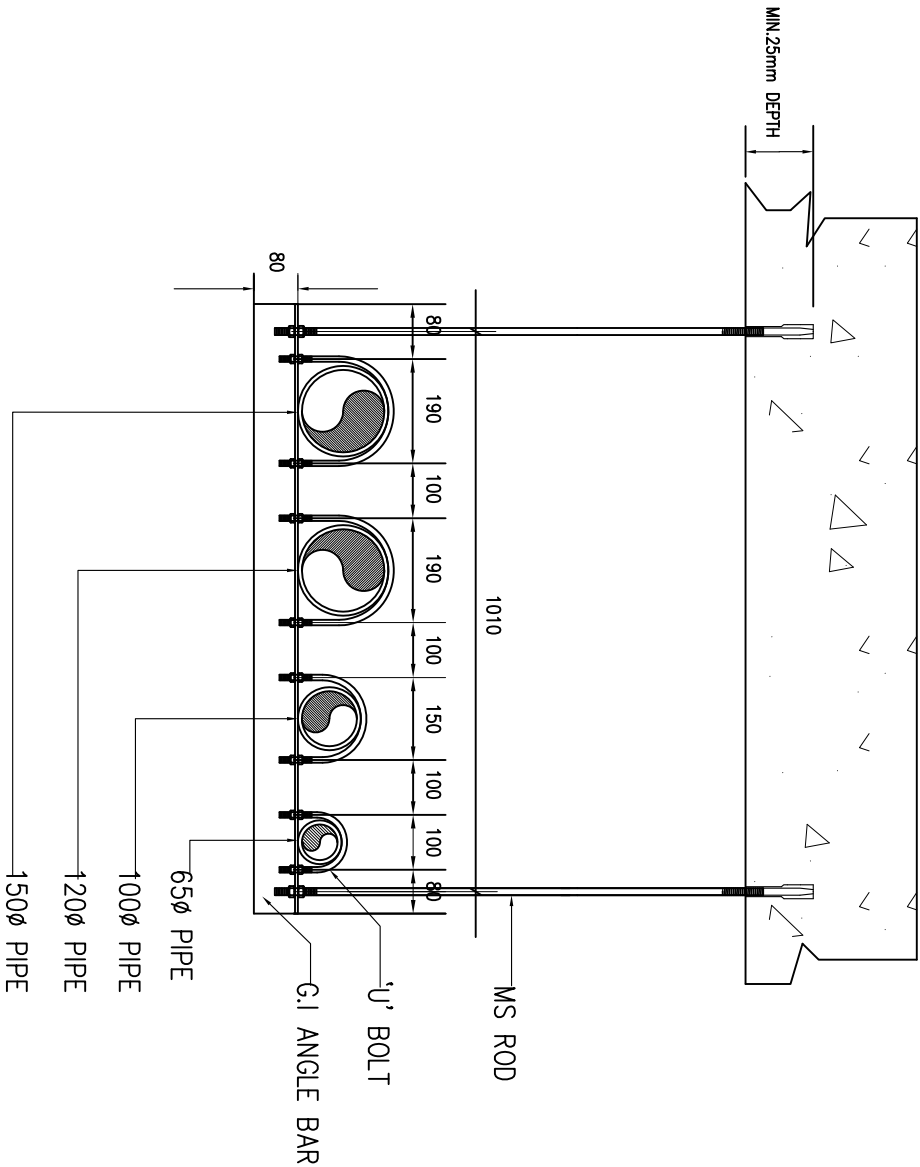

Note : Dimension in mm

SPACING BETWEEN VARIOUS SIZE OF PIPE USING U-BOLT HANGER

SCALE : NTS

MAXIMUM RECOMMENDED LOAD
FOR VARIOUS MS ROD SIZE
ALL DIMENSIONS IN MM

MS ROD SIZE (mm)	ROOT AREA OF THREAD (mm²)	MAX. SAFE LOAD AT ROD TEMP. OF 650 F (343 C) (kN)
M10	49.49	3.66
M12	72.40	5.35
M16	138.3	10.2
M20	217.1	16.0
M24	312.8	23.1
M30	503.0	37.2
M36	738.0	54.5
M42	1018	75.2

(SOURCE: MSS SP-58:2009)

- NOTE: a) Tabulated loads are based on a minimum actual tensile stress of 345MPa divided by a safety factor of 3.5, reduced by 25% resulting in an allowable stress of 73.9MPa. (The 25% reduction is to allow for normal installation and service conditions.)
- b) Rod sizes are based on min. root diameters for standard coarse thread class 6g. Taken from ASME B1.13M for metric thread forms.



JASA KEPADA RAKYAT

CAWANGAN KEJURUTERAAN MEKANIKAL


Ibu Pejabat JKR Malaysia

INTERNAL COLD WATER AND SANITARY
PLUMBING SYSTEM

SPACING BETWEEN VARIOUS SIZE OF PIPE USING
U-BOLT HANGER


DATE: 2017 SCALE: NTS

DRAWING NUMBER: CKM/STD/CWSP/PIPE/REV/2017/10


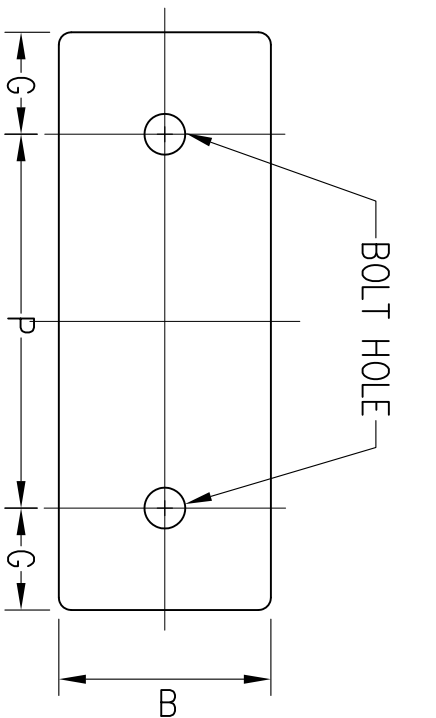


FRONT VIEW

PIPE CLIPS SUPPORT DETAILS

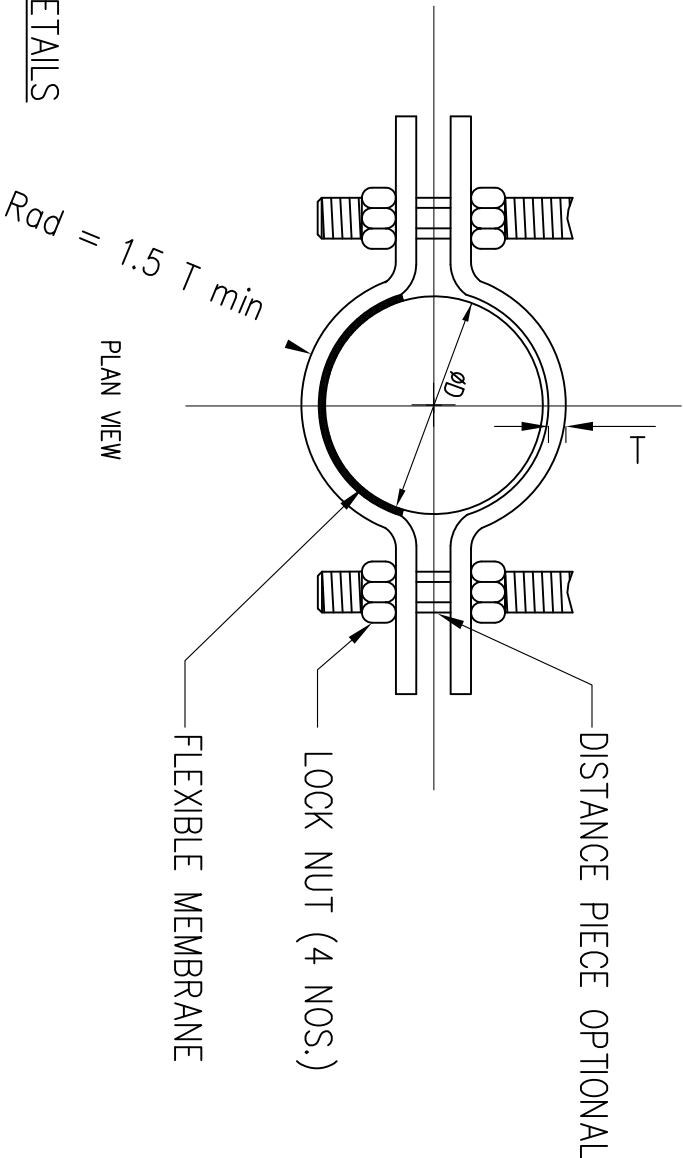

PLAN VIEW

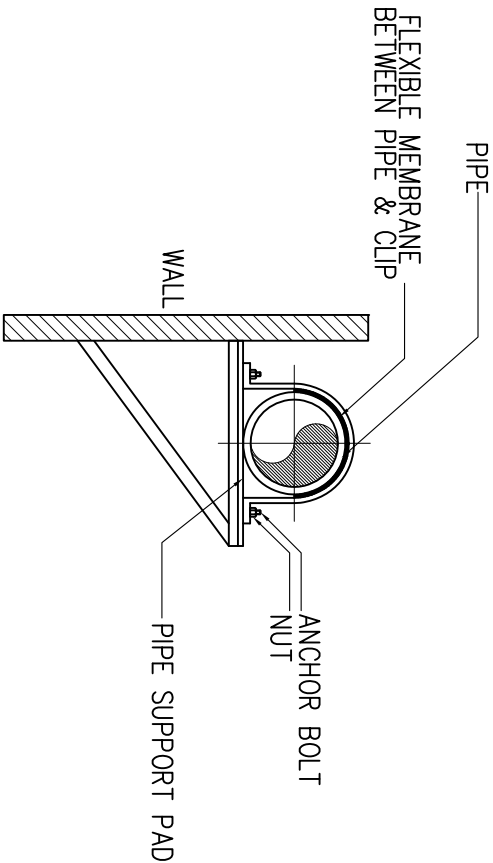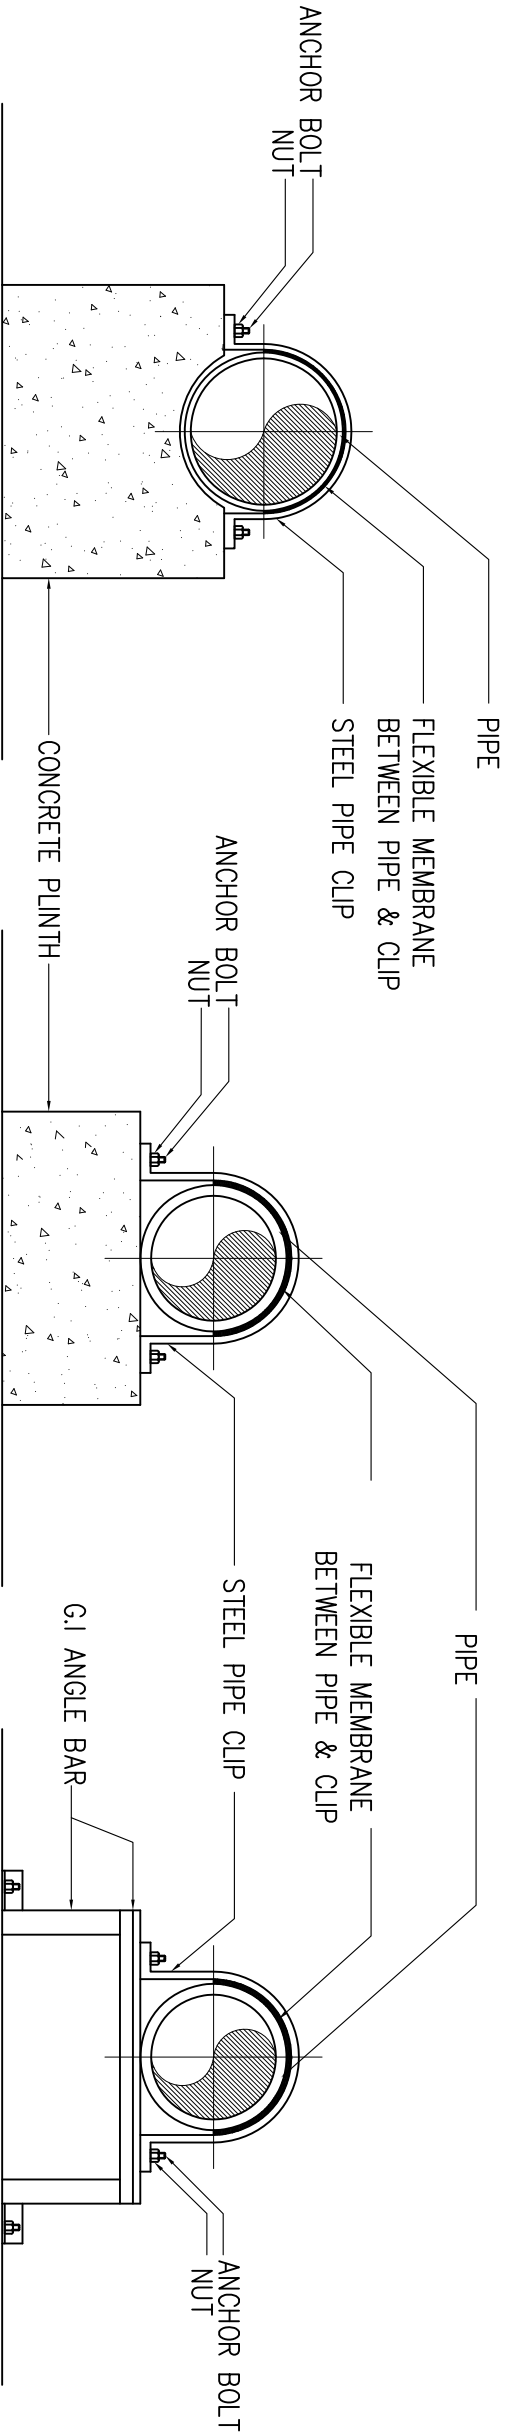

OPTION 4

SCALE : NTS

RECOMMENDED INSTALLATION FOR HORIZONTAL PIPE CLIPS SUPPORT

SCALE : NTS



JASA KEPADA RAKYAT
BAHAGIAN PEMBANGUNAN KEPAKARAN
CAWANGAN KEJURUTERAAN MEKANIKAL
Ibu Pejabat JKR Malaysia

INTERNAL COLD WATER AND SANITARY
PLUMBING SYSTEM

PIPE CLIPS SUPPORT DETAILS

DATE:	2017	SCALE:	NTS
DRAWING NUMBER:	CKM/STD/CWSP/PIPE/REV/2017/11		

NOTE:

1. The mortar thrust block are not recommended to be used as the support of the ABS pipeline exposed to sunlight.

DIMENSIONS OF PIPE CLIPS
(ALL DIMENSIONS IN MM)

PIPE SIZE		Light Series							Heavy Series						
Nom. size	Outside dia.	D dia.	Clip dimensions B x T	P	Bolts Size		G	Safe working load	D dia.	Clip dimensions B x T	P	Bolts Size		G	Safe working load
					Metric Size	Hole dia.						Metric Size	Hole dia.		
mm	mm	mm	mm	mm		mm		kgf	mm	mm	mm		mm	mm	kgf
15	21.3	USE HEAVY SERIES													
20	26.9														
25	33.7														
32	42.4														
40	48.3														
50	60.3														
65	76.1	80	35 x 5	125	M 12	15	18	165	80	35 x 5	155	M 16	19	24	450
80	88.9	92	35 x 5	135	M 12	15	18	165	92	35 x 5	165	M 16	19	24	450
100	114.3	118	35 x 5	170	M 12	15	18	165	118	35 x 5	190	M 16	19	24	450
125	139.7	144	35 x 5	195	M 16	19	24	280	144	35 x 5	215	M 16	19	24	450
150	168.3	172	35 x 5	225	M 16	19	24	280	172	35 x 5	245	M 16	19	24	450
175	193.7	198	35 x 8	270	M 16	19	24	450	198	45 x 10	280	M 16	19	24	900
200	219.1	224	35 x 8	295	M 16	19	24	450	224	45 x 10	305	M 16	19	24	900

(BS 3974 PART 1:1974)



JASA KEPADA RAKYAT

CAWANGAN KEJURUTERAAN MEKANIKAL
Ibu Pejabat JKR Malaysia

INTERNAL COLD WATER AND SANITARY
PLUMBING SYSTEM


RECOMMENDED INSTALLATION FOR HORIZONTAL
PIPE CLIPS SUPPORT

DATE: 2017 SCALE: NTS


DRAWING NUMBER: CKM/STD/CWSP/PIPE/REV/2017/12

NOTE:

1. All pipe clips should permit free axial pipe movement at all temperatures and should give good bearing support to the pipe.

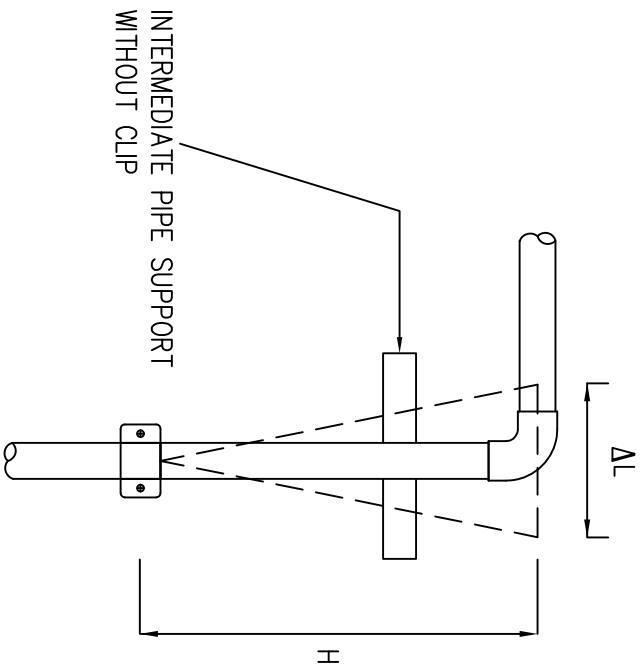

EXPANSION ARM

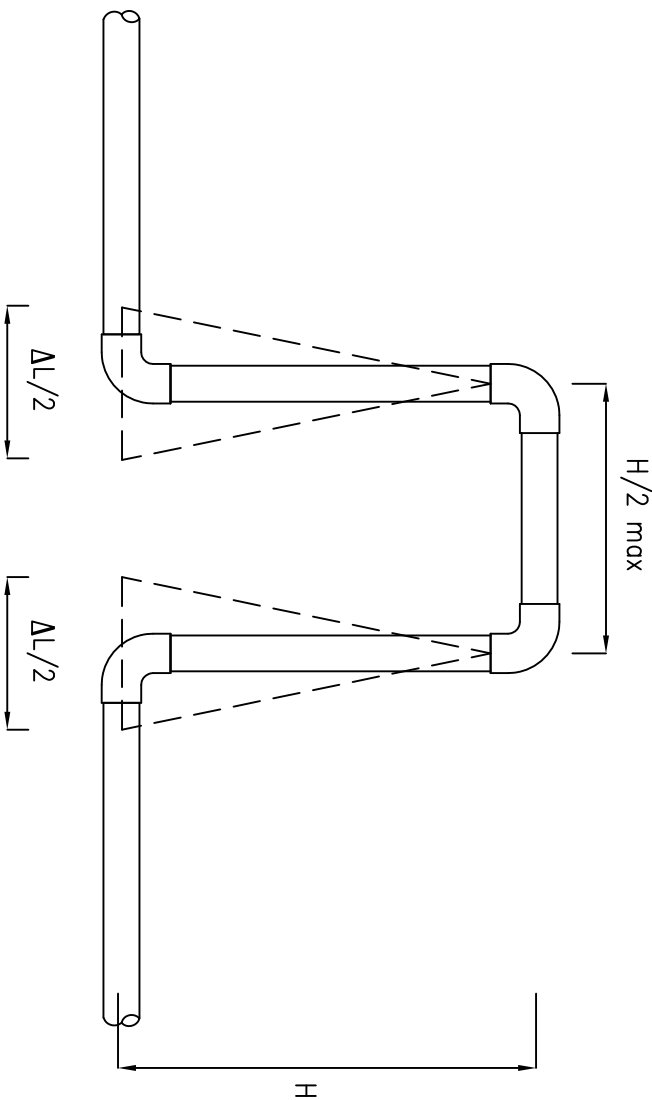

EXPANSION LOOP

GUIDE FOR ABS PIPE THERMAL EXPANSION CALCULATION

1.) CALCULATE PIPE EXPANSION (ΔL)

$$\Delta L = L \times C \times \Delta T$$

where :

ΔL= pipe expansion/contraction,(m)

L= original pipe length,(m)

C= linear coefficient of thermal expansion, as per manufacturer recommendation (m/m°C)

ΔT= pipe wall temperature variation,(°C)

The variation in pipe wall temperature can be calculated as:

$$\Delta T = 0.65 \Delta T_L + 0.10 \Delta T_A$$

where :

ΔT = pipe wall temperature variation(°C)

ΔT_L = maximum temperature variation in pipe content,(°C)

ΔT_A = maximum temperature variation of external air,(°C)

The temperature variation used should considered both pipe operating and shut down conditions

2.) CALCULATE LOOP LEG LENGTH (H)

$$H = K \times \sqrt{OD \times \Delta L}$$

where

K = constant as per manufacturer recommendation

OD = Outside diameter of pipe (mm)

ΔL = Linear expansion (mm)



JASA KEPADA RAKYAT

CAWANGAN KEJURUTERAAN MEKANIKAL
Ibu Pejabat JKR Malaysia

INTERNAL COLD WATER AND SANITARY
PLUMBING SYSTEM


DETAIL OF ABS PIPE THERMAL EXPANSION

DATE: 2017 SCALE: NTS

DRAWING NUMBER: CKM/STD/CWSP/PIPE/REV/2017/13

DETAIL OF ABS PIPE THERMAL EXPANSION

SCALE : NTS

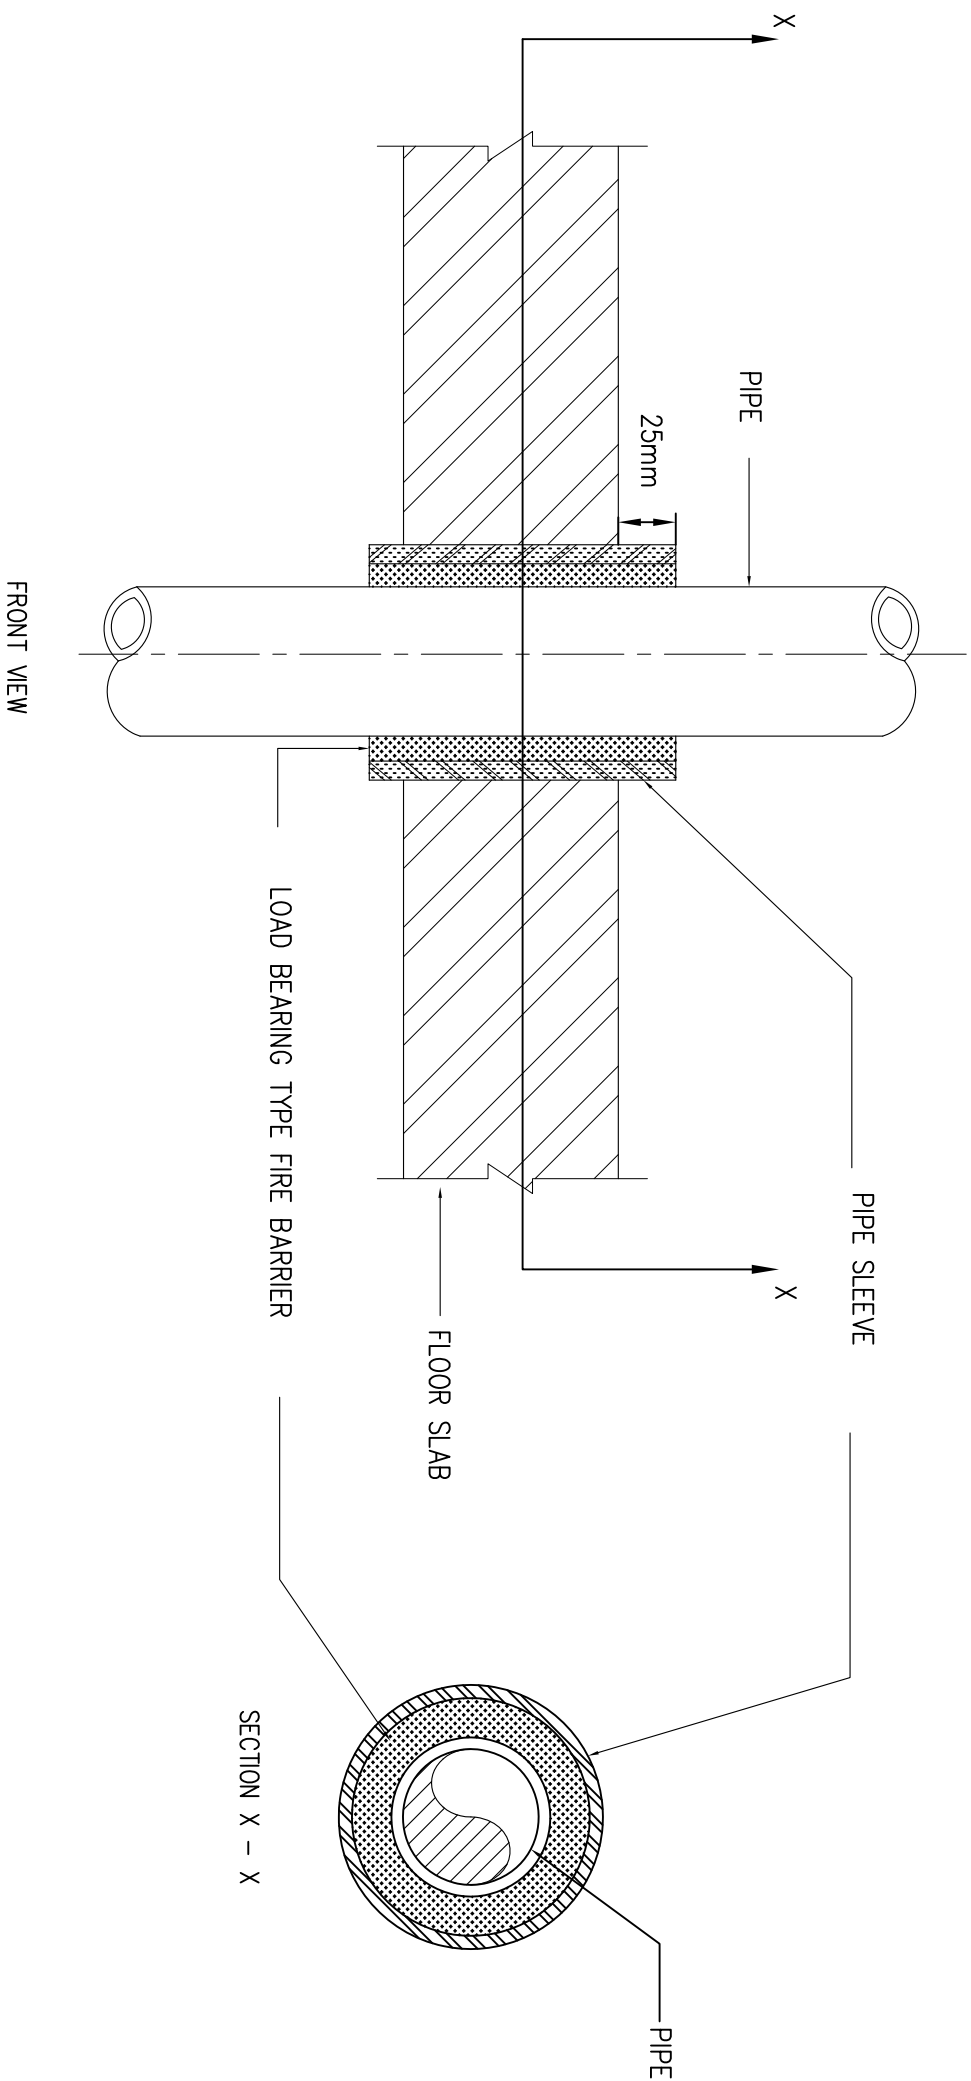

DETAIL OF PIPE SLEEVE THROUGH FLOOR / SLAB

SCALE : NTS

NOTES : SLEEVE SHALL BE SAME MATERIAL OF PIPE



JASA KEPADA RAKYAT

CAWANGAN KEJURUTERAAN MEKANIKAL
Ibu Pejabat JKR Malaysia

INTERNAL COLD WATER AND SANITARY
PLUMBING SYSTEM

DETAIL OF PIPE SLEEVE THROUGH FLOOR / SLAB


DATE: 2017 SCALE: NTS

DRAWING NUMBER:


CKM/STD/CWSP/PIPE/REV/2017/14

RECOMMENDED PIPE SLEEVE MATERIAL

PIPE MATERIAL	PIPE SLEEVE MATERIAL
METAL	GALVANIZED IRON
NON-METAL	UPVC (HEAVY DUTY)

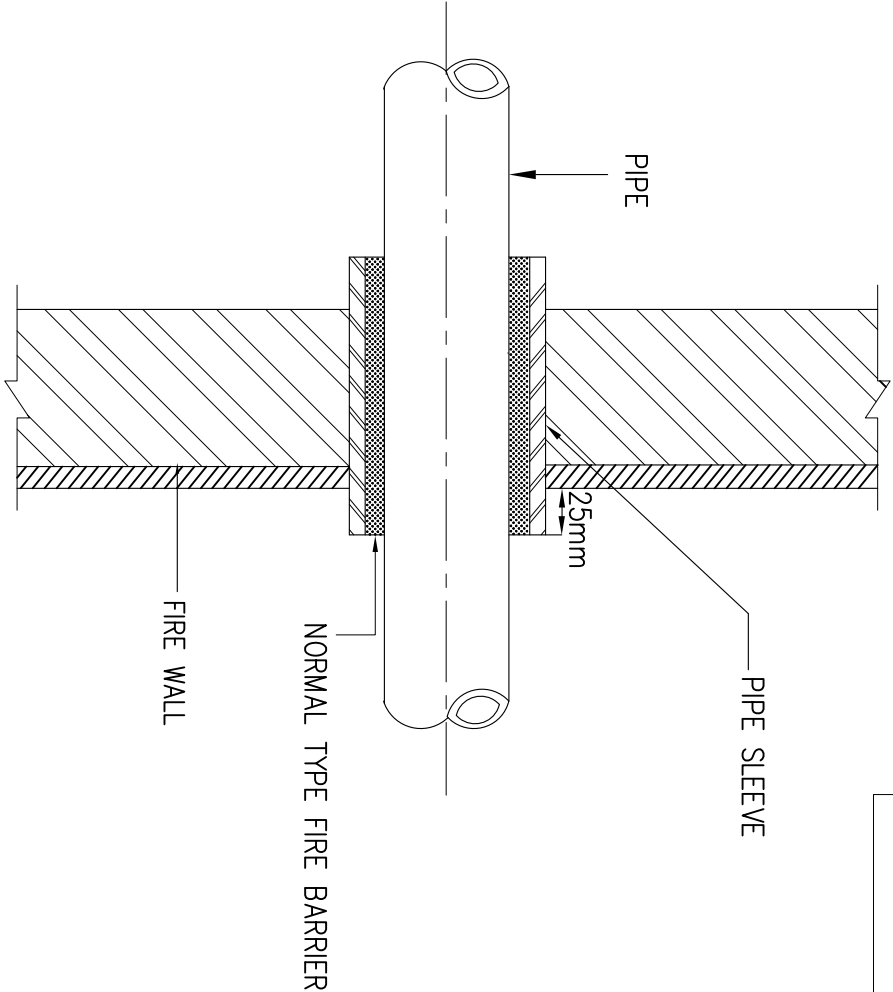

PIPE SLEEVE FOR PIPE THROUGH FIRE WALL
SCALE : NTS

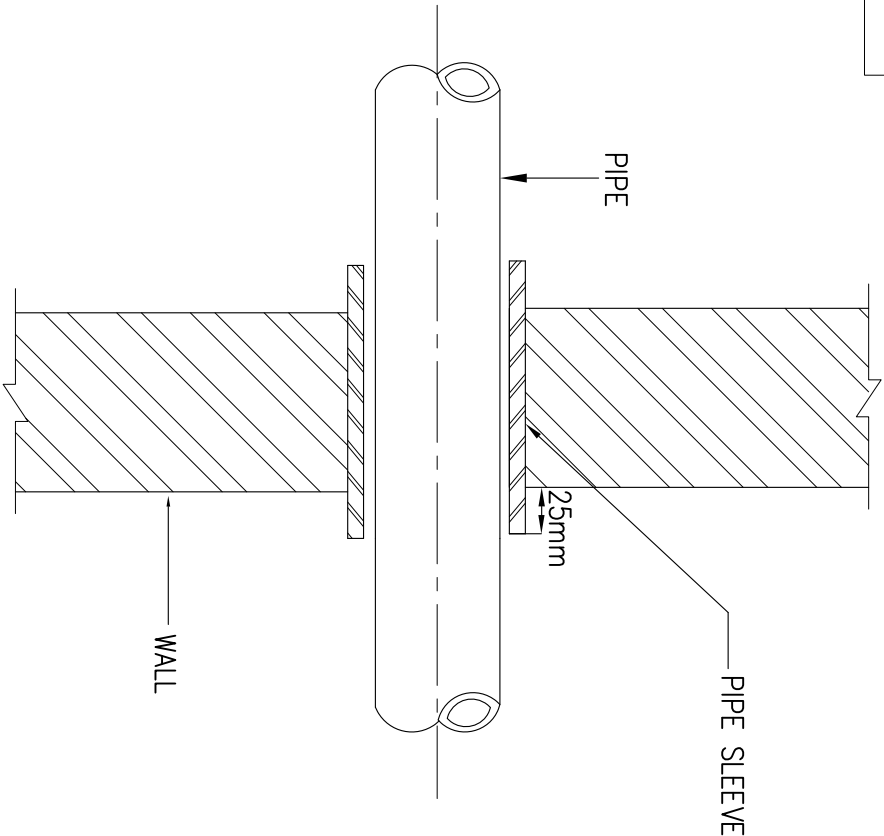

PIPE SLEEVE FOR PIPE THROUGH WALL
SCALE : NTS



JASA KEPADA RAKYAT

CAWANGAN KEJURUTERAAN MEKANIKAL
Ibu Pejabat JKR Malaysia


INTERNAL COLD WATER AND SANITARY
PLUMBING SYSTEM
DETAIL OF PIPE SLEEVE THROUGH WALL

DATE:	2017	SCALE:	NTS
DRAWING NUMBER:			
CKM/STD/CWSP/PIPE/REV/2017/15			

INTERNAL COLD WATER PLUMBING SYSTEM



JASA KEPADA RAKYAT

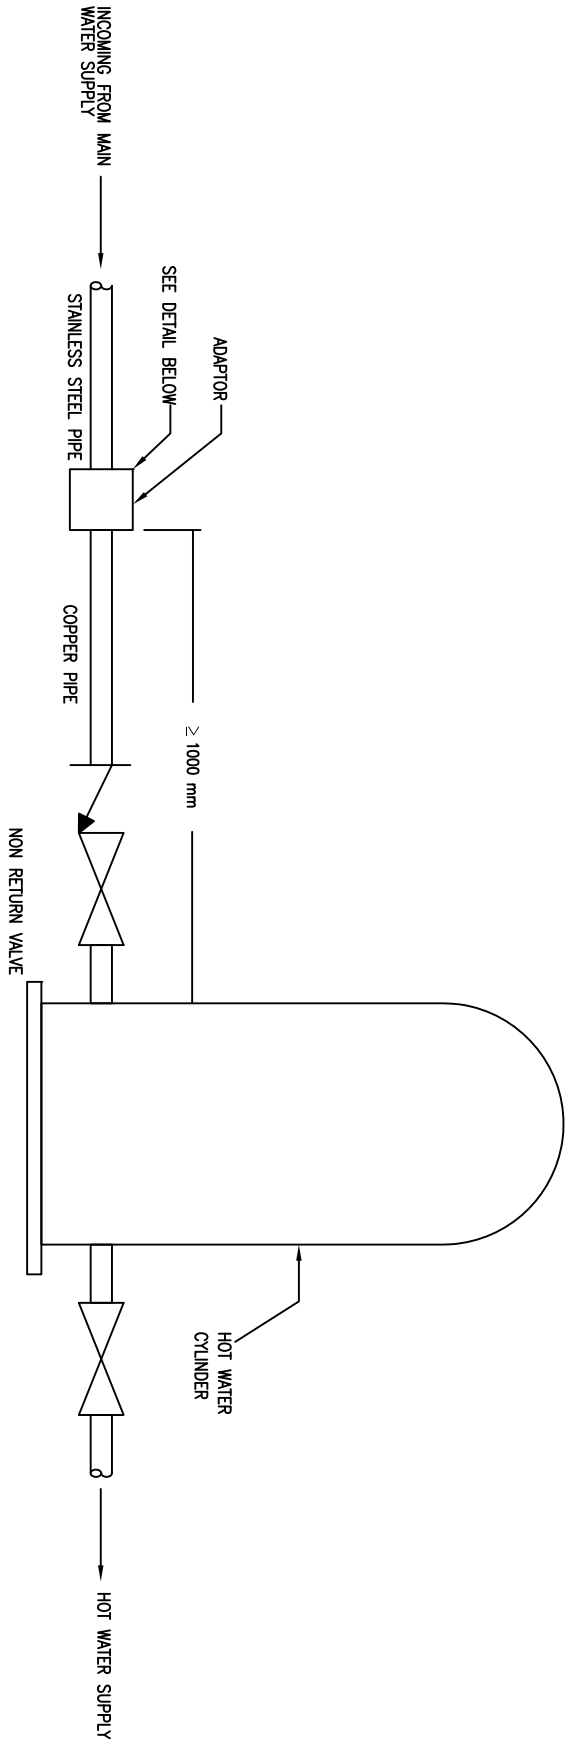


STAINLESS STEEL PIPING SHALL BE AT LEAST 1000mm FROM A HOT WATER CYLINDER

RECOMMENDED INSTALLATION METHOD OF INCOMING STAINLESS STEEL PIPE FOR HOT WATER CYLINDER


SCALE : NTS

COPPER FEMALE CONNECTOR

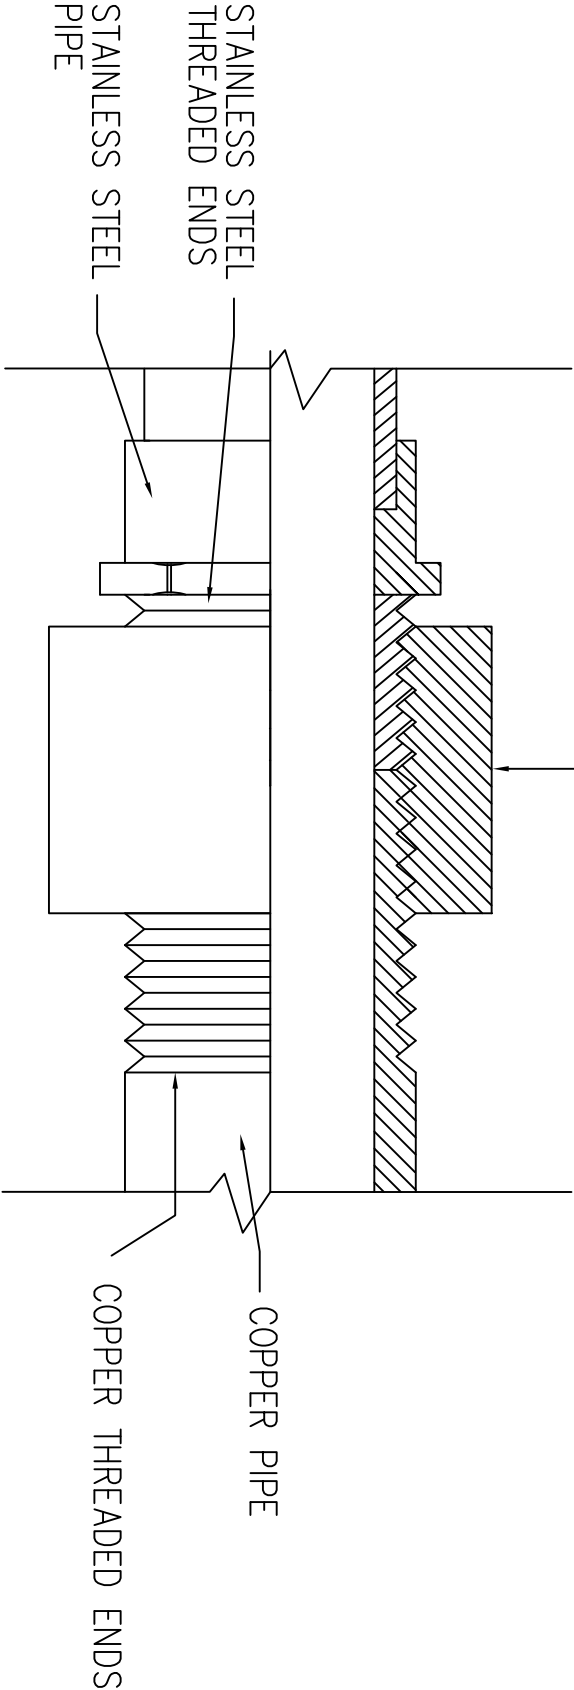

ADAPTOR : MALE & FEMALE CONNECTOR (CAPILLARY JOINT WITH A THREADED END)

SCALE : NTS

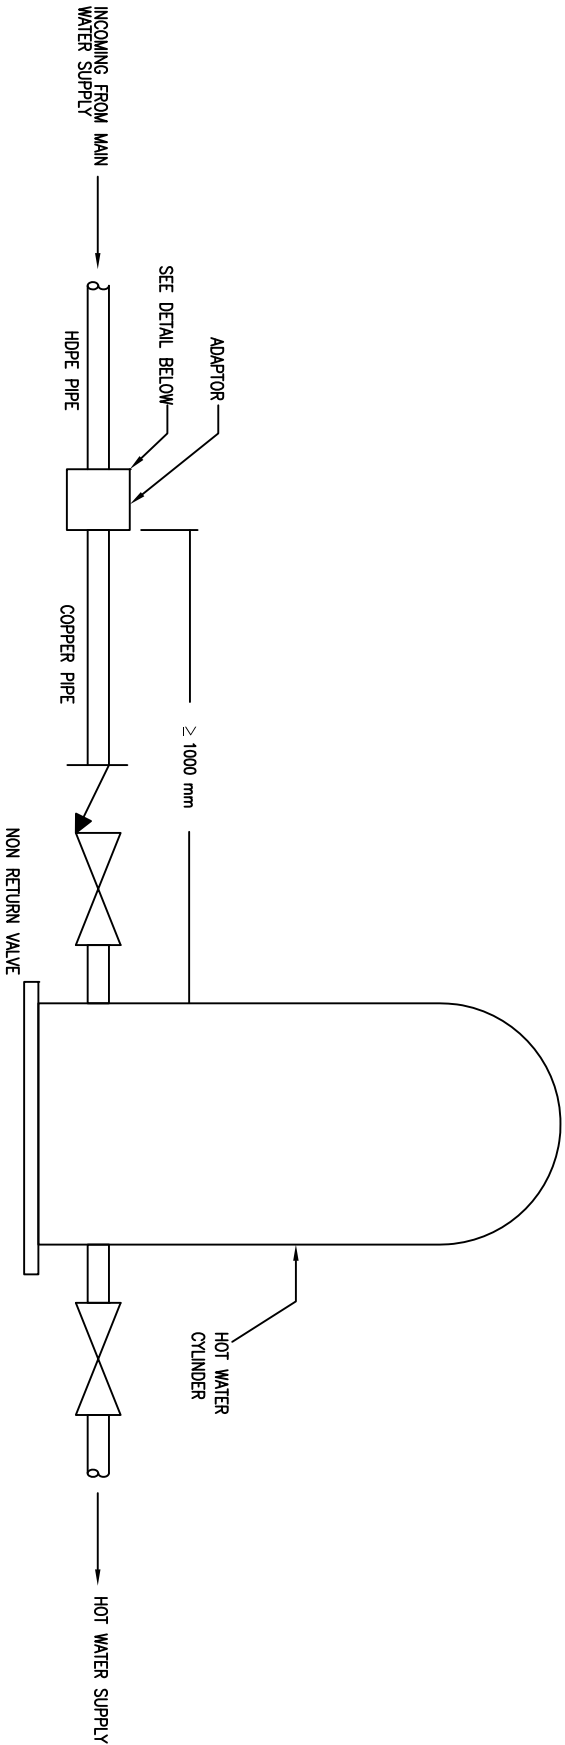


HDPE PIPING SHALL BE AT LEAST 1000mm FROM A HOT WATER CYLINDER

RECOMMENDED INSTALLATION METHOD OF INCOMING HDPE PIPE FOR HOT WATER CYLINDER

SCALE : NTS

COPPER FEMALE CONNECTOR

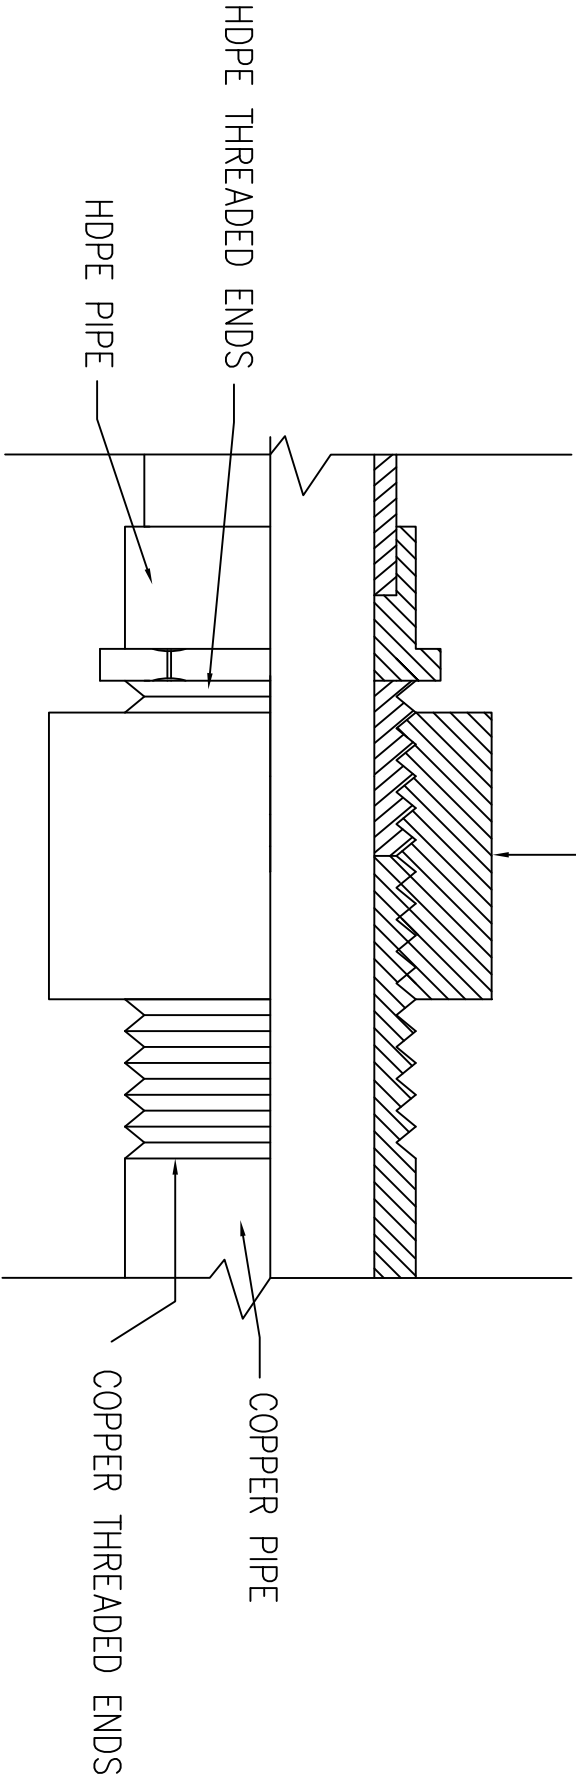

ADAPTOR : MALE & FEMALE CONNECTOR (CAPILLARY JOINT WITH A THREADED END)

SCALE : NTS



JASA KEPADA RAKYAT


CAWANGAN KEJURUTERAAN MEKANIKAL
Ibu Pejabat JKR Malaysia

INTERNAL COLD WATER PLUMBING SYSTEM
RECOMMENDED INSTALLATION METHOD
OF INCOMING HDPE PIPE FOR HOT WATER
CYLINDER

DATE	2017	SCALE	NTS
DRAWING NUMBER:	CKM/STD/CWSP/CW/REV2017/02		

NOTE:

1. Avoid scoring and scratching pipes when installed in concrete
(SOURCE: MS 1419, PART 4:2007)

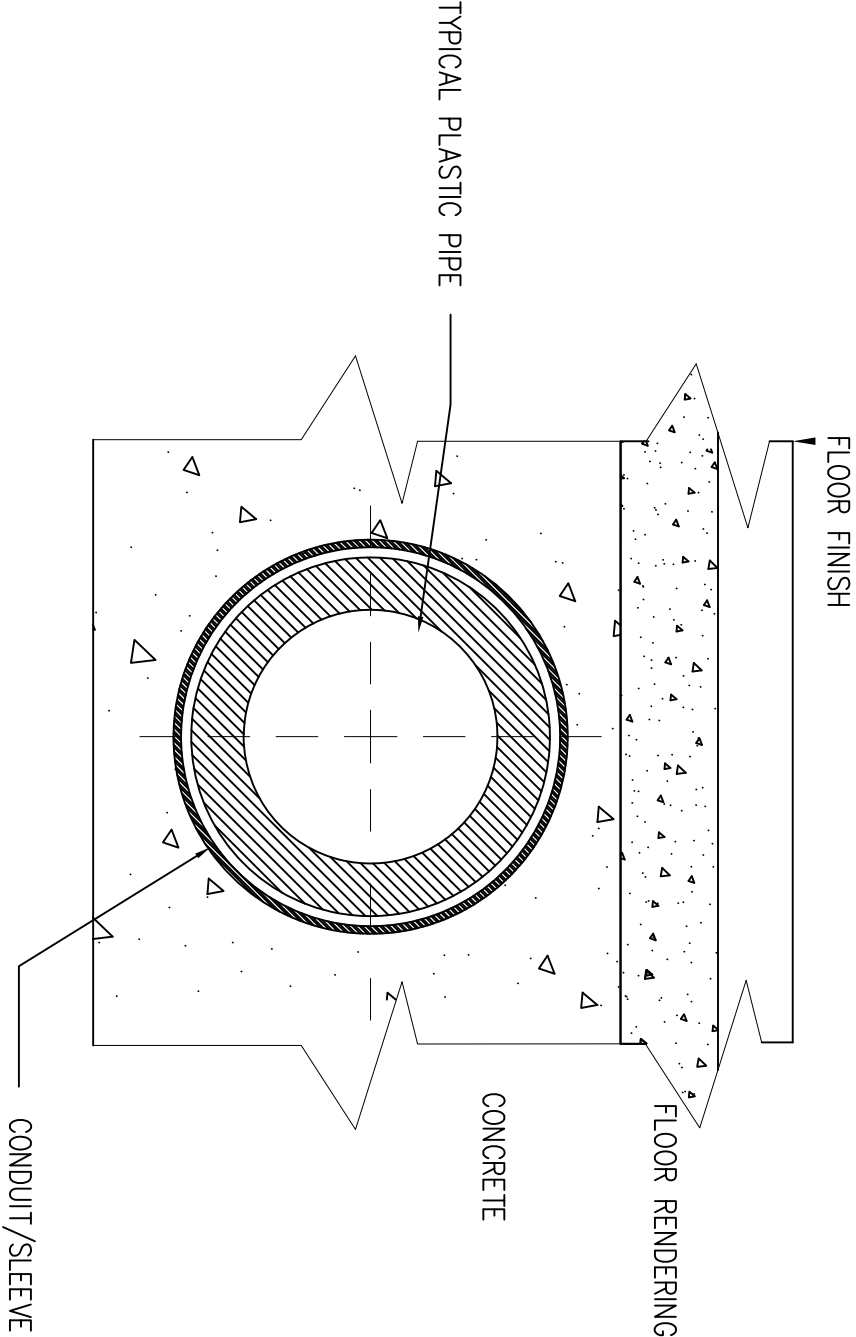

TYPICAL INSTALLATION OF PLASTIC PIPE (ABS/HDPE/PPE/PVC/PPR PIPE) LAY IN CONCRETE
SCALE : NTS




JASA KEPADA RAKYAT

CAWANGAN KEJURUTERAAN MEKANIKAL
Ibu Pejabat JKR Malaysia

INTERNAL COLD WATER PLUMBING SYSTEM

TYPICAL INSTALLATION OF PLASTIC PIPE
LAY IN CONCRETE

DATE	SCALE
2017	NTS
DRAWING NUMBER:	
CKMSTD/CWSP/CW/REV2017/03	

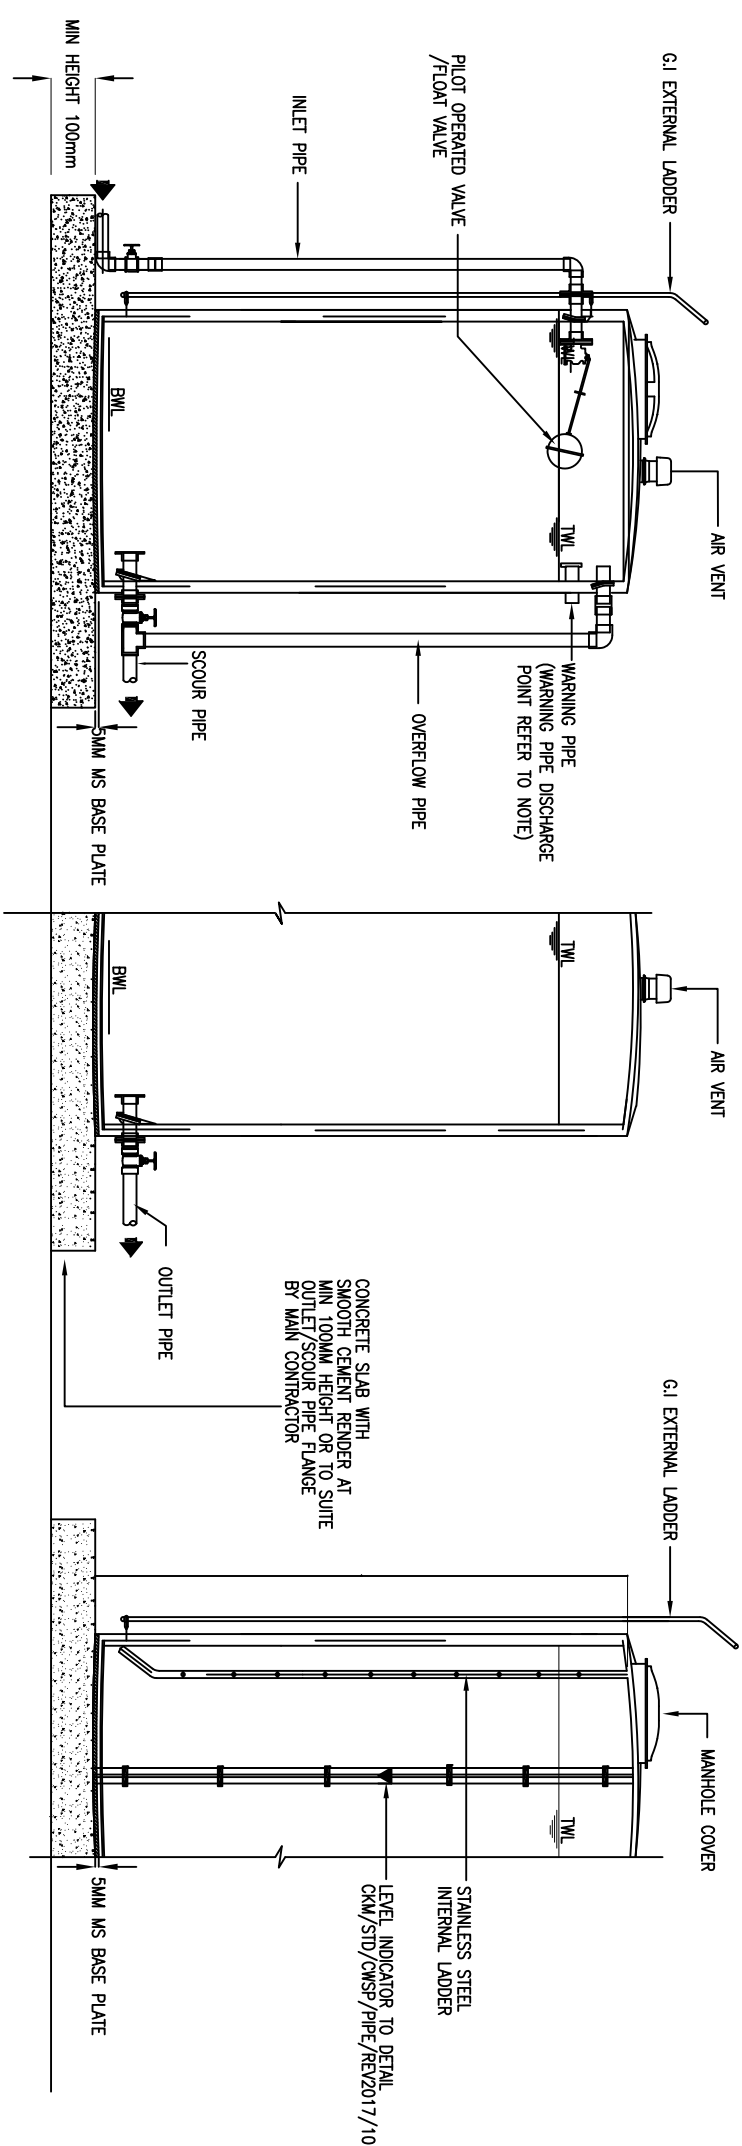

DETAILS OF INLET, OVERFLOW AND SCOUR PIPE

DETAILS OF PIPE OUTLET

DETAILS OF MANHOLE EXTERNAL AND INTERNAL LADDER

DETAILS OF HIGH DENSITY POLYETHYLENE (HDPE) TANK INSTALLATION

SCALE : NTS

(SOURCE: MS 1225, PART 1:2004)

- NOTE:
- 1. HDPE Tank which is manufactured should comply to MS 1225
 - 2. Warning pipe shall discharge in a conspicuous position preferably outside the building where this is appropriate.
 - 3. For pipe support refer to CKM/STD/CWSP/PIPE/REV2017/12
 - 4. Warning pipe/overflow pipe/scour pipe shall be discharge to the nearest drain.
 - 5. Size for overflow pipe & scour pipe shall be size bigger than inlet pipe.
 - 6. Overflow and warning pipe shall be combined for tank capacity less than 4,500 liters (1,000 gallons).
 - 7. Tank with > 2 metres depth shall be provided with internal and external ladder.

LEGEND:

- T.W.L. TOP WATER LEVEL
- B.W.L. BOTTOM WATER LEVEL
- MS MILD STEEL
- G.I GALVANIZED IRON



JAS A KEPADA RAKYAT

CAWANGAN KEJURUTERAAN MEKANIKAL

Ibu Pejabat JKR Malaysia

INTERNAL COLD WATER PLUMBING SYSTEM


DETAILS OF HDPE TANK INSTALLATION

DATE	2017	SCALE	NTS
DRAWING NUMBER:			
CKM/STD/CWSP/CW/REV2017/04			

- NOTE:
1. Poly tank which is manufactured should comply with MS 1225
 2. Warning pipe shall discharge in a conspicuous position preferably outside the building where this is appropriate.
 3. Warning pipe/overflow pipe/scour pipe shall be discharged to the nearest drain.
 4. Size for overflow pipe & scour pipe shall be bigger size than inlet pipe.
 5. Overflow and warning pipe shall be combined for tank capacity less than 4,500 litres (1,000 gallons).

LEGEND:	
TWL	TOP WATER LEVEL
BWL	BOTTOM WATER LEVEL
MS	MILD STEEL
GJ	GALVANIZED IRON


CONCRETE SLAB WITH
SMOOTH CEMENT RENDER AT
MIN 100MM HEIGHT OR TO SUIT
OUTLET/SCOUR PIPE FLANGE
BY MAIN CONTRACTOR

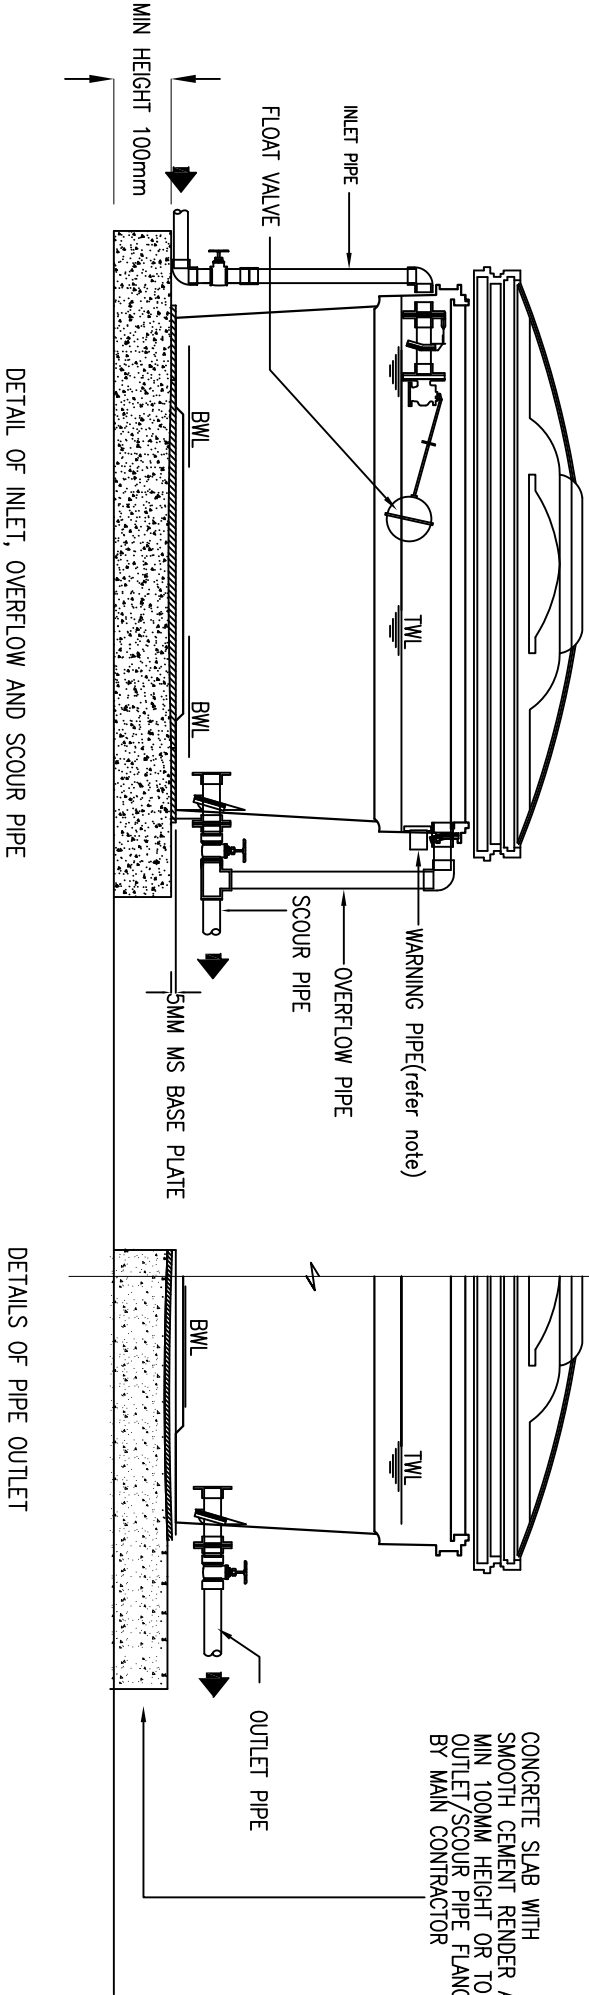

DETAILS OF POLY TANK(P) TANK INSTALLATION

SCALE : NTS

 JASA KEPADA RAKYAT CAWANGAN KEJURUTERAAN MEKANIKAL Ibu Pejabat JKR Malaysia	
INTERNAL COLD WATER PLUMBING SYSTEM	
DETAILS OF POLY TANK INSTALLATION	
DATE	SCALE
2017	NTS
DRAWING NUMBER:	
CKM/STD/CWSP/CW/REV2017/05	

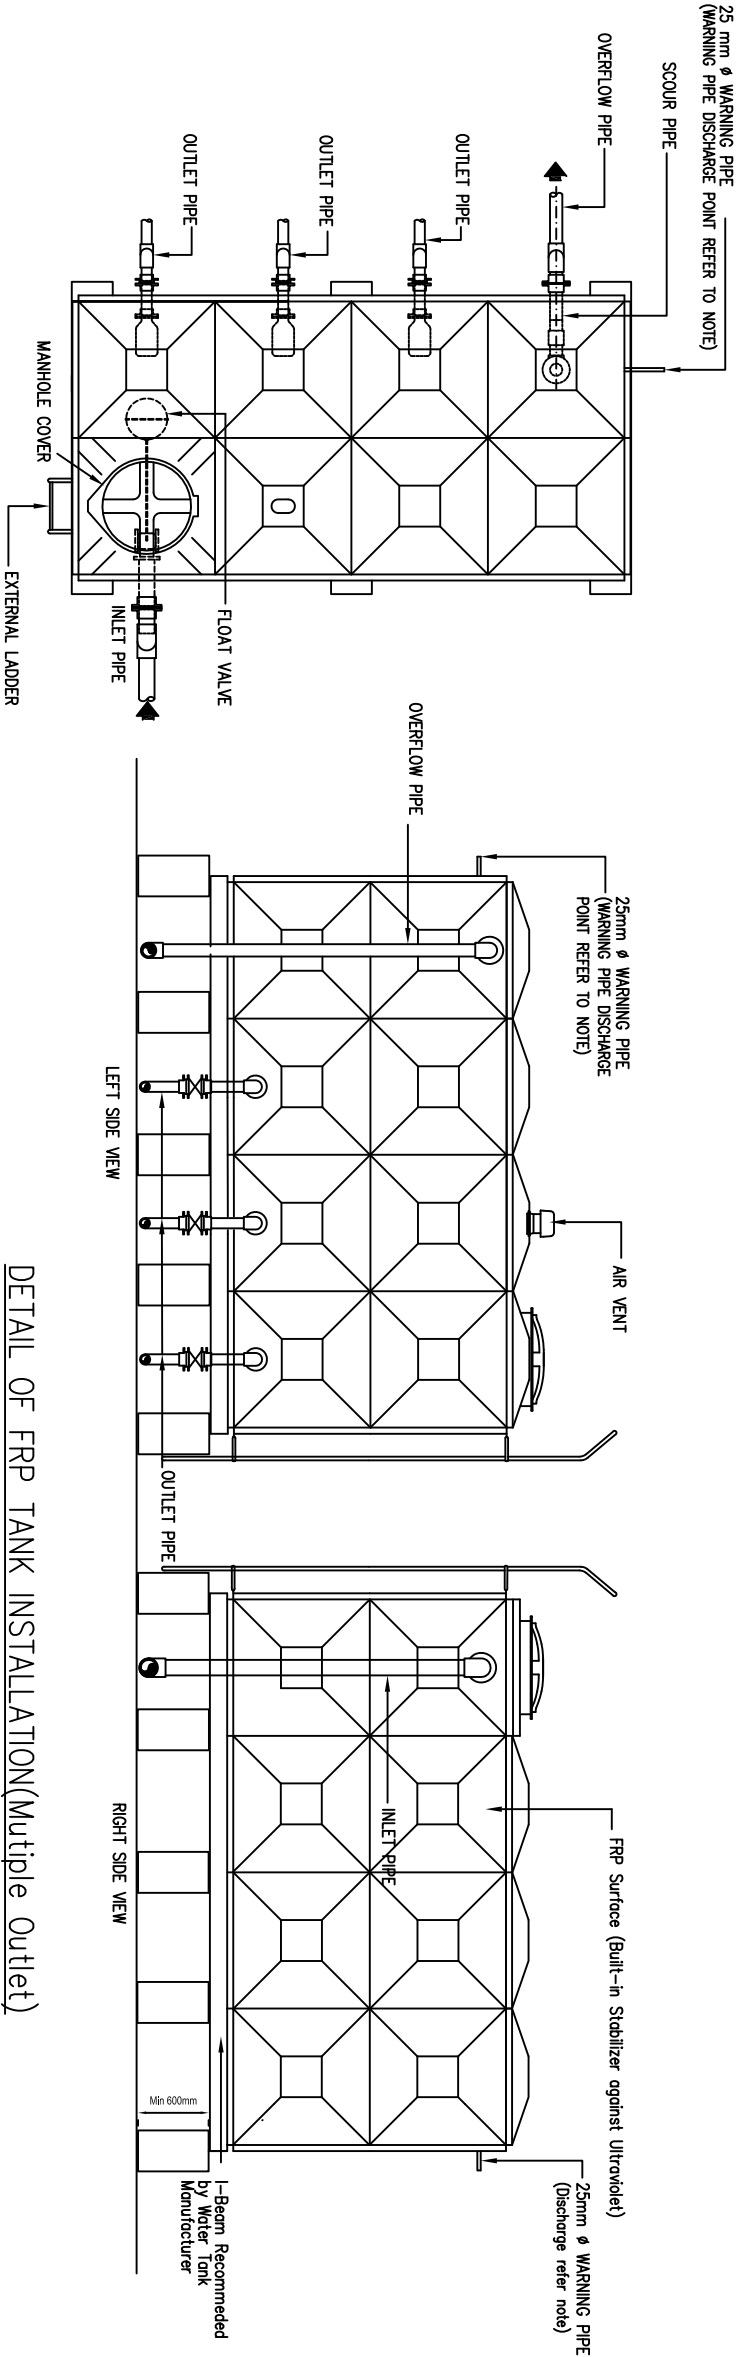


PLAN VIEW

SCALE : NTS

DETAIL OF FRP TANK INSTALLATION(Multiple Outlet)

SCALE : NTS

(SOURCE: MS 1390:2010)

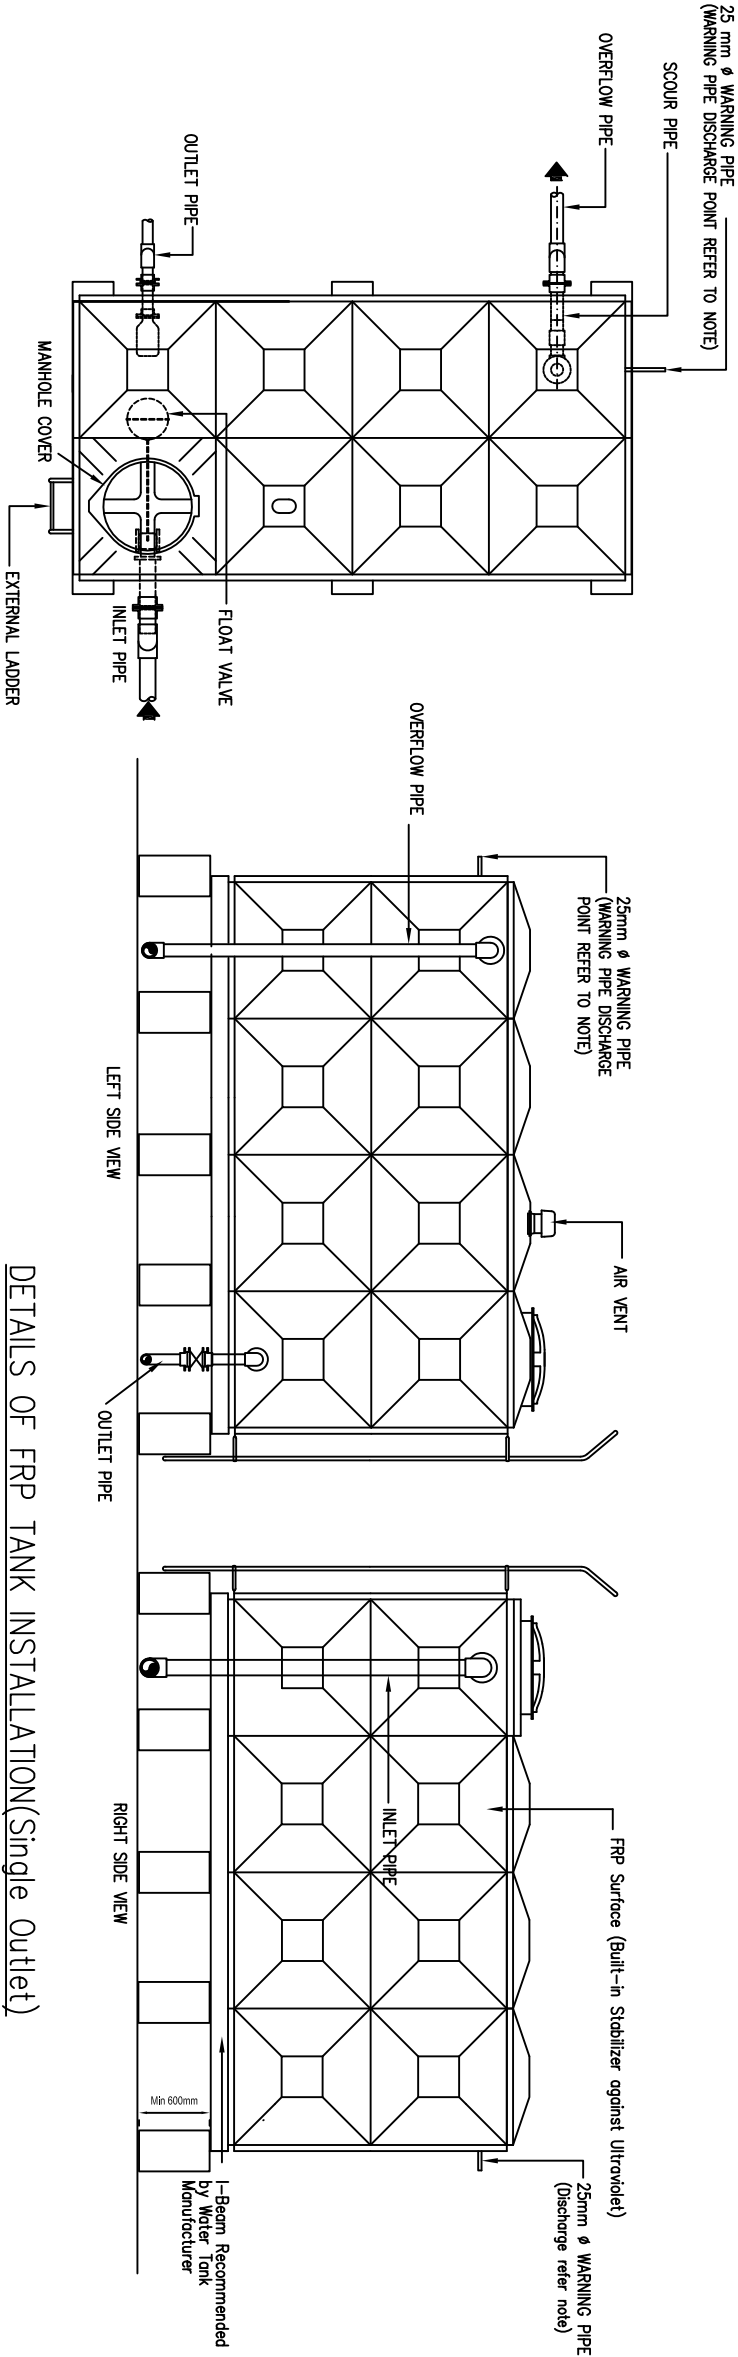

PLAN VIEW

SCALE : NTS

DETAILS OF FRP TANK INSTALLATION(Single Outlet)

SCALE : NTS

(SOURCE: MS 1390:2010)

NOTE:

1. All pipe routes and layouts are for guidance only.
2. The exact position for all outlet, pipe, scour, overflow, warning, sampling and connection pipes and also valves at the site will be determined by S.O.
3. Warning pipe shall discharge in a conspicuous position preferably outside the building where this is appropriate.
4. The exact location for all ventilating panels, manhole (w/ external and internal ladder) will be determined by S.O
5. Details drawing for concrete plinth water tank foundation shall refer to structural drawing.
6. Size for overflow pipe & scour pipe shall be bigger size than inlet pipe.
7. The maximum height from floor to first ladder step shall be 300mm.

LEGEND:

- TWL TOP WATER LEVEL
- BWL BOTTOM WATER LEVEL
- G1 GALVANIZED IRON





JASA KEPADA RAKYAT

CAWANGAN KEJURUTERAAN MEKANIKAL
Ibu Pejabat JKR Malaysia

INTERNAL COLD WATER PLUMBING SYSTEM

DETAILS OF FRP TANK INSTALLATION

DATE	2017	SCALE	NTS
DRAWING NUMBER:	CKM/STD/CWSP/CW/REV2017/06		

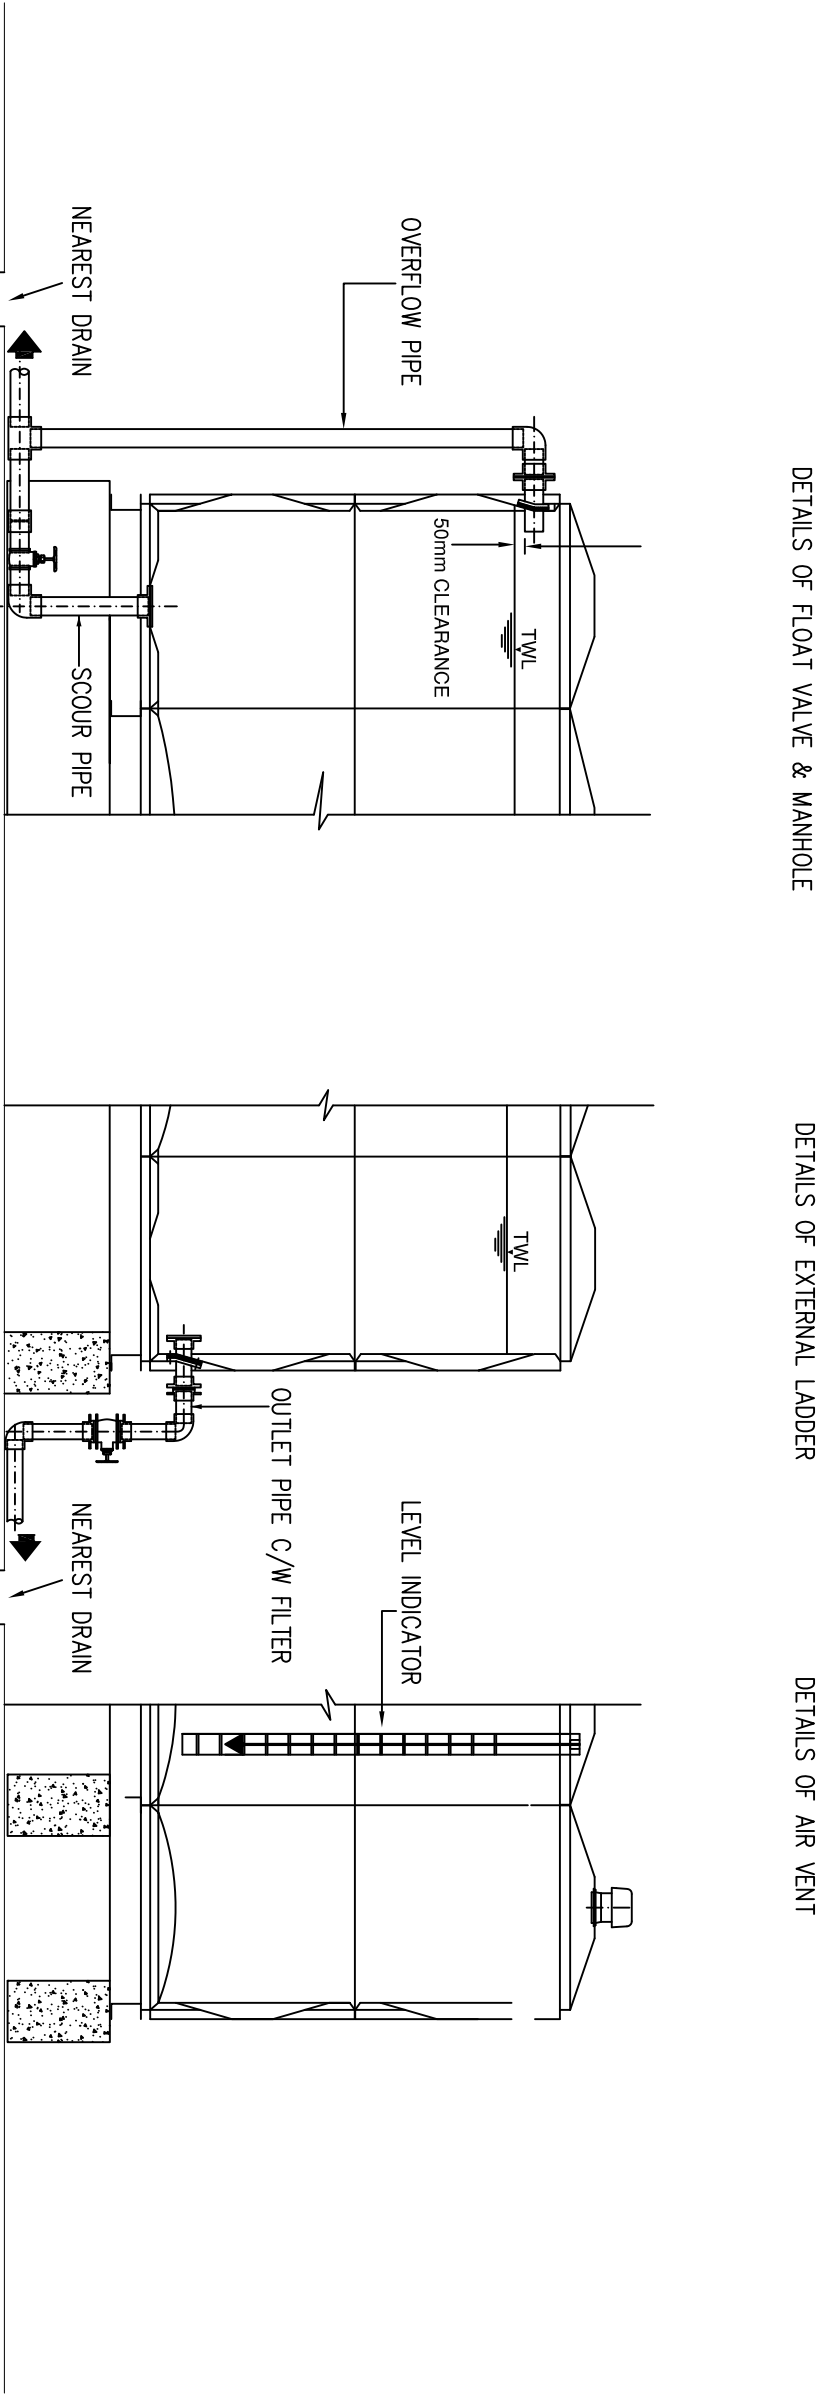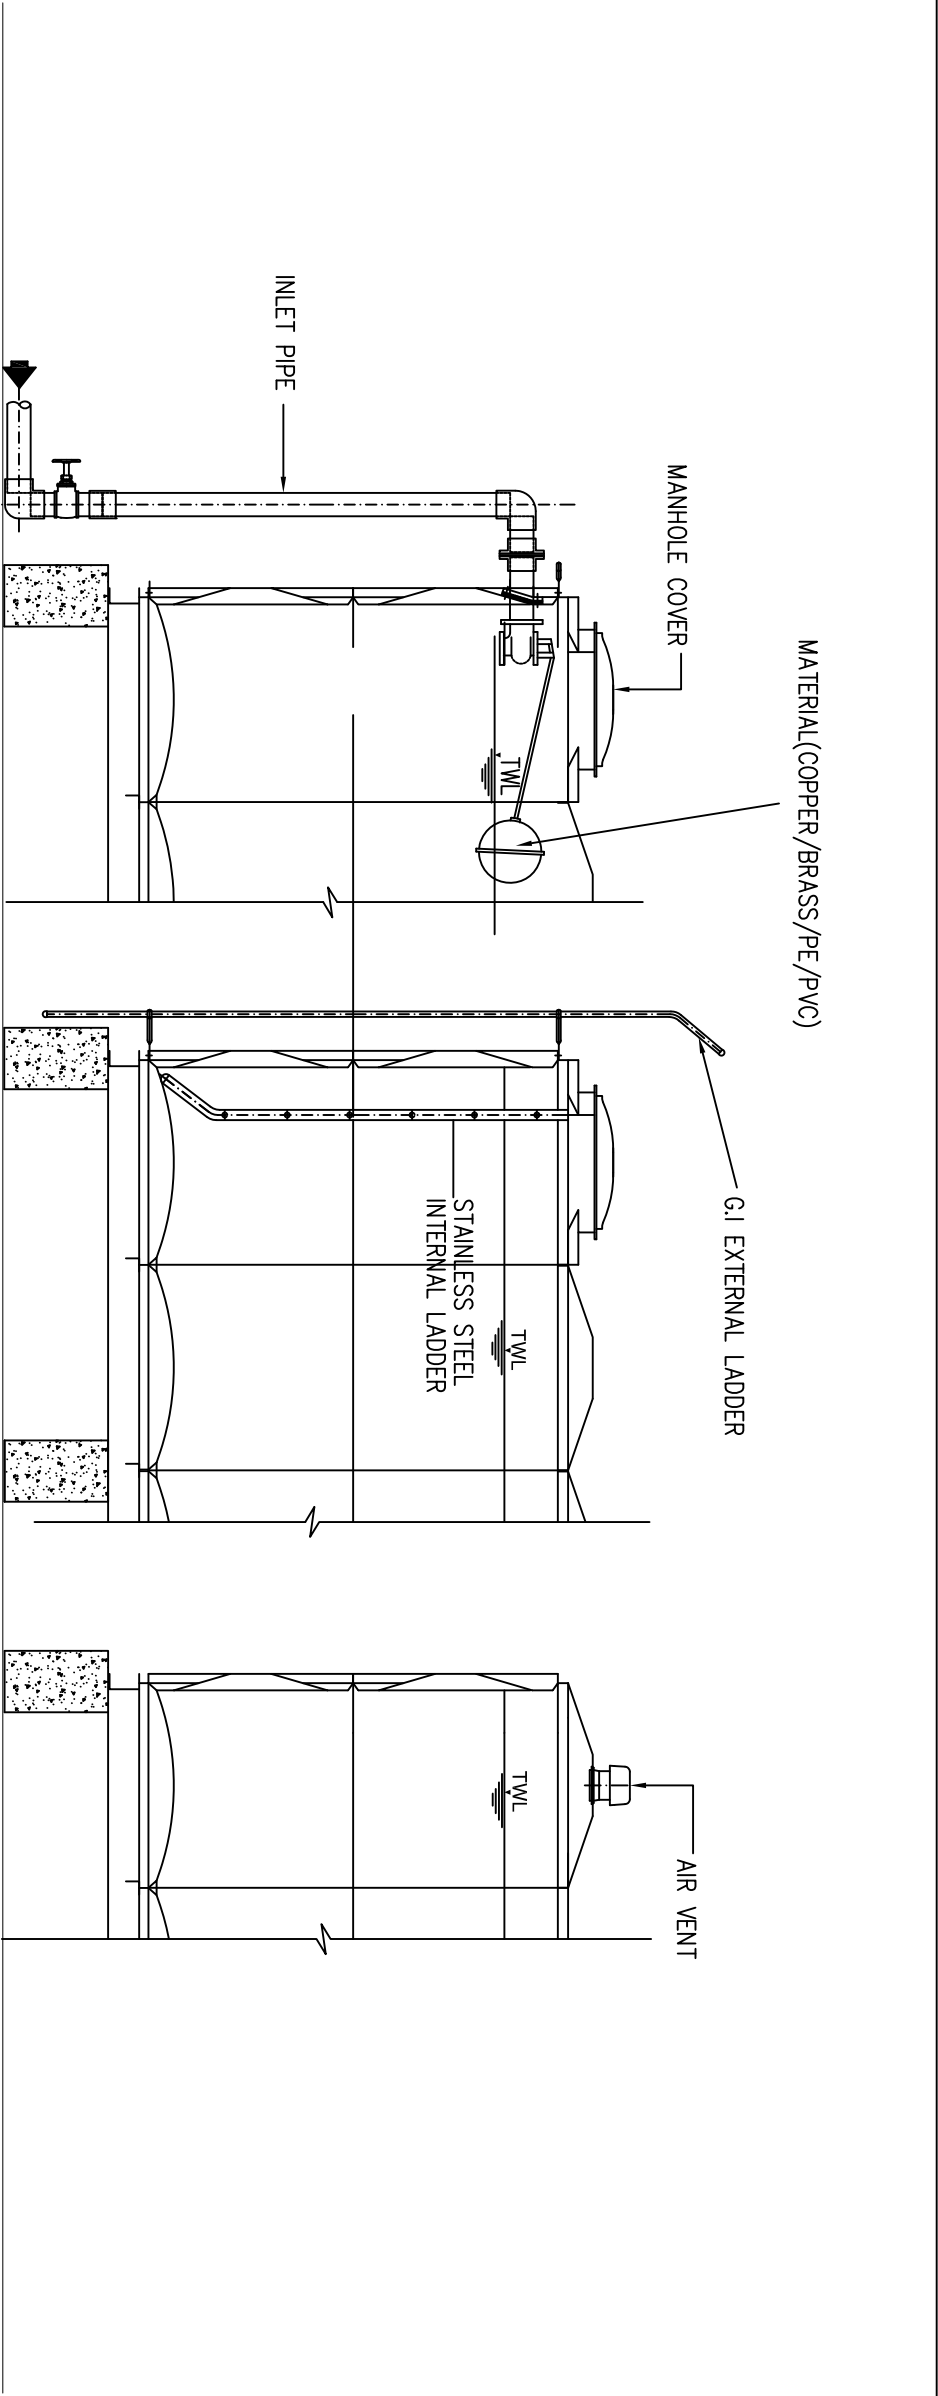

MATERIAL(COPPER/BRASS/PE/PVC)

GI EXTERNAL LADDER

STAINLESS STEEL
INTERNAL LADDER

AIR VENT

DETAILS OF FLOAT VALVE & MANHOLE

DETAILS OF EXTERNAL LADDER

DETAILS OF AIR VENT

DETAIL OF OVERFLOW AND SCOUR PIPE

DETAIL OF PIPE OUTLET

DETAIL OF LEVEL INDICATOR
REFER TO CKM/STD/CWSP/PIPE/REV2017/10

DETAILS OF FRP TANK-PIPE & MANHOLE INSTALLATION

SCALE : NTS
(SOURCE: MS 1390:2010)

NOTE:

1. All pipe's routes and layouts are for guidance only.
2. The exact position for all outlet, pipe, scour, overflow, warning, sampling and connection pipes and also valves at the site will be determined by S.O.
3. Warning pipe shall discharge in a conspicuous position preferably outside the building where this is appropriate.
4. The exact location for all ventilating panels, manhole (c/w external and internal ladder) will be determined by S.O
5. Warning pipe/overflow pipe/scour pipe shall be discharge to the nearest drain.

LEGEND:

- TWL TOP WATER LEVEL
- BWL BOTTOM WATER LEVEL
- GI GALVANIZED IRON




JASA KEPADA RAKYAT

CAWANGAN KEJURUTERAAN MEKANIKAL
Ibu Pejabat JKR Malaysia

INTERNAL COLD WATER PLUMBING SYSTEM
DETAILS OF FRP TANK-PIPE & MANHOLE
INSTALLATION

DATE	2017	SCALE	NTS
DRAWING NUMBER:	CKM/STD/CWSP/CW/REV2017/07		

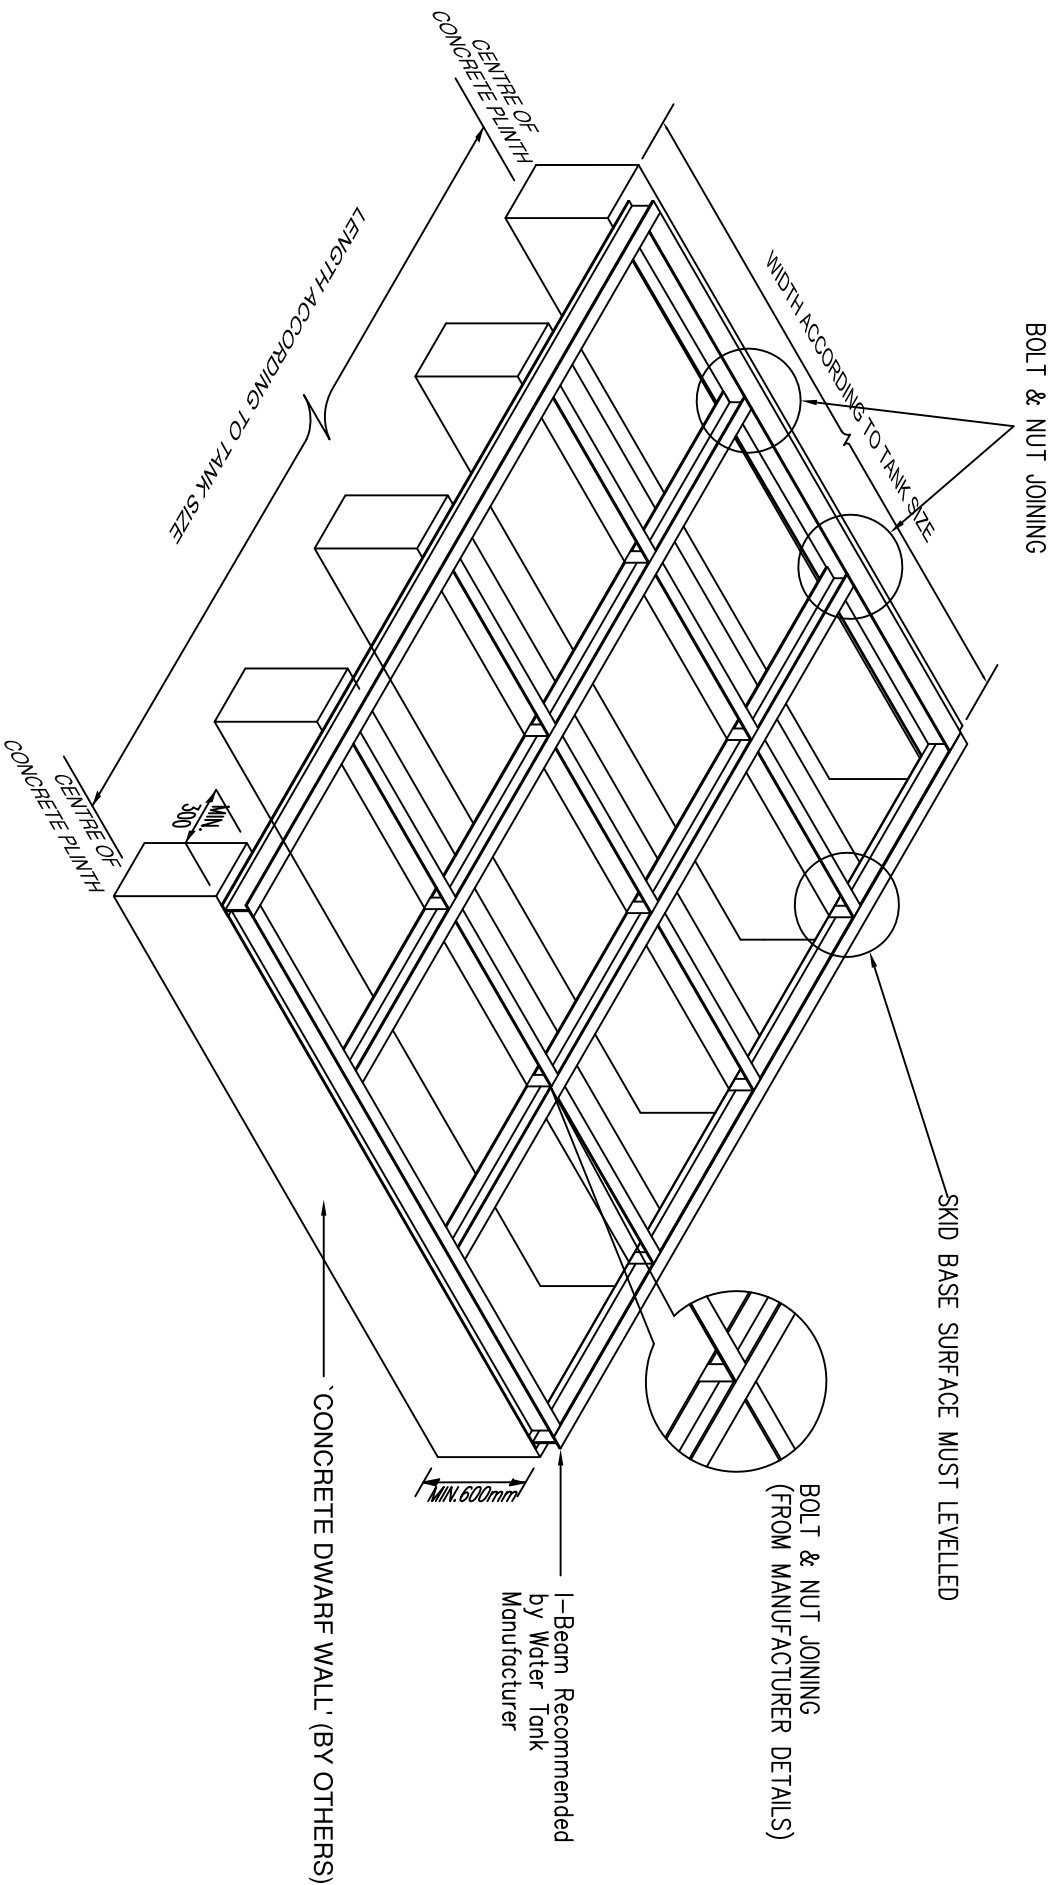

DETAILS OF FRP TANK-STEEL BASE INSTALLATION

SCALE : NTS

(SOURCE: MS 1390: 2010)




JASA KEPADA RAKYAT

CAWANGAN KEJURUTERAAN MEKANIKAL
Ibu Pejabat JKR Malaysia

INTERNAL COLD WATER PLUMBING SYSTEM

DETAILS OF FRP TANK-STEEL BASE
INSTALLATION

DATE	2017	SCALE	NTS
DRAWING NUMBER:	CKM/STD/CWSP/CW/REV2017/08		

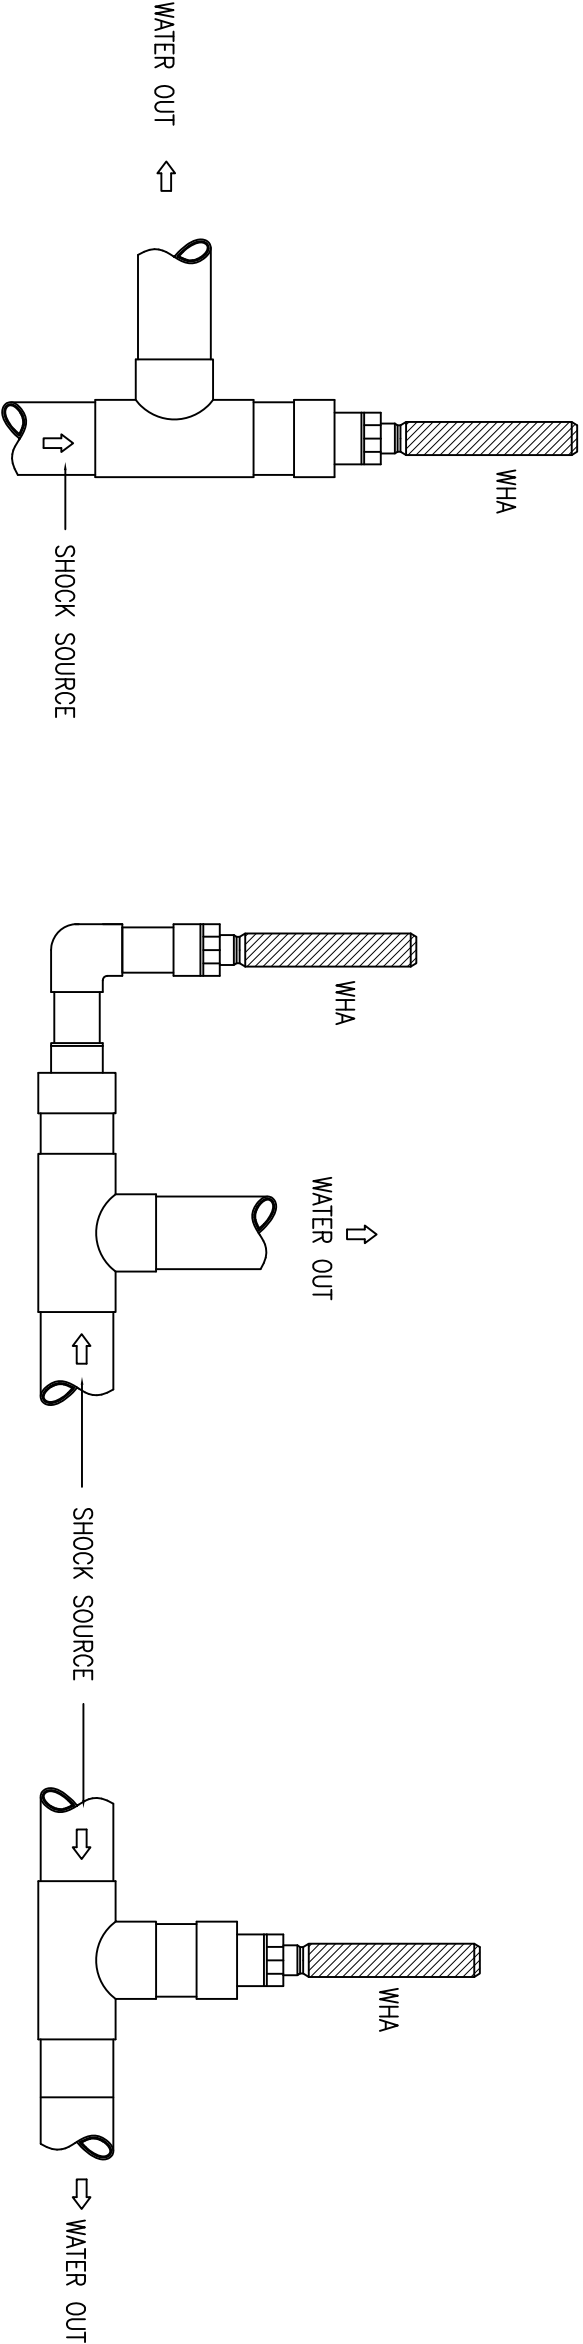


Details 'A'– Tee

Details 'B'– Elbow

Details 'C'– Tee

TYPICAL INSTALLATION METHOD OF WATER HAMMER ARRESTER (WHA)
FOR PRESSURE NOT EXCEEDING 150 PSI (10.3 BAR)

SCALE : NTS

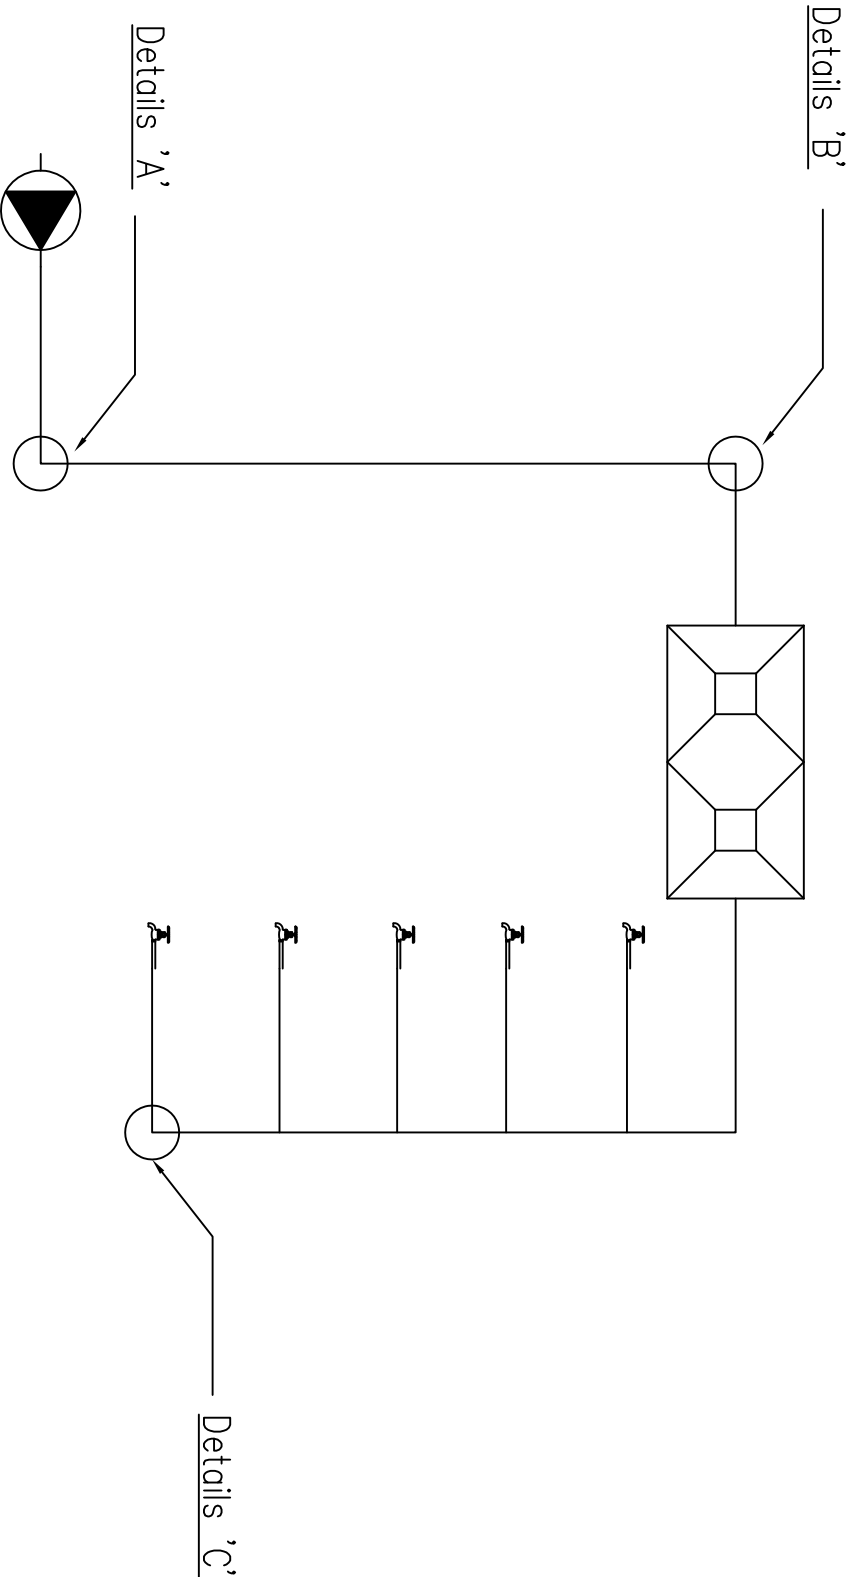


SCHEMATIC INSTALLATION LOCATION FOR WATER HAMMER ARRESTER (WHA)


SCALE : NTS

NOTE:

1. Maximum working temperature = 60°C

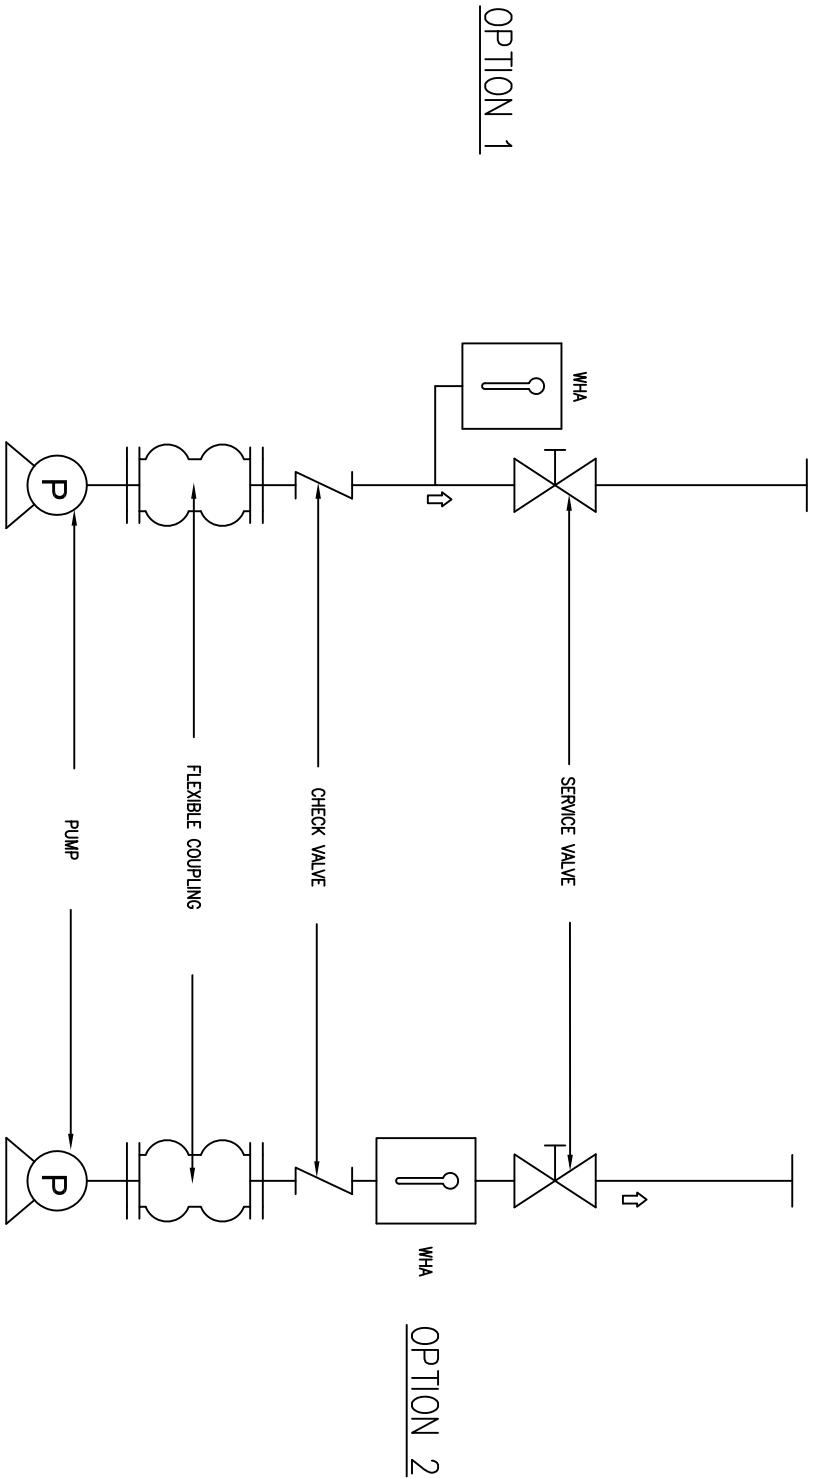

WHA INSTALLED AFTER COLD WATER PUMPING SYSTEM

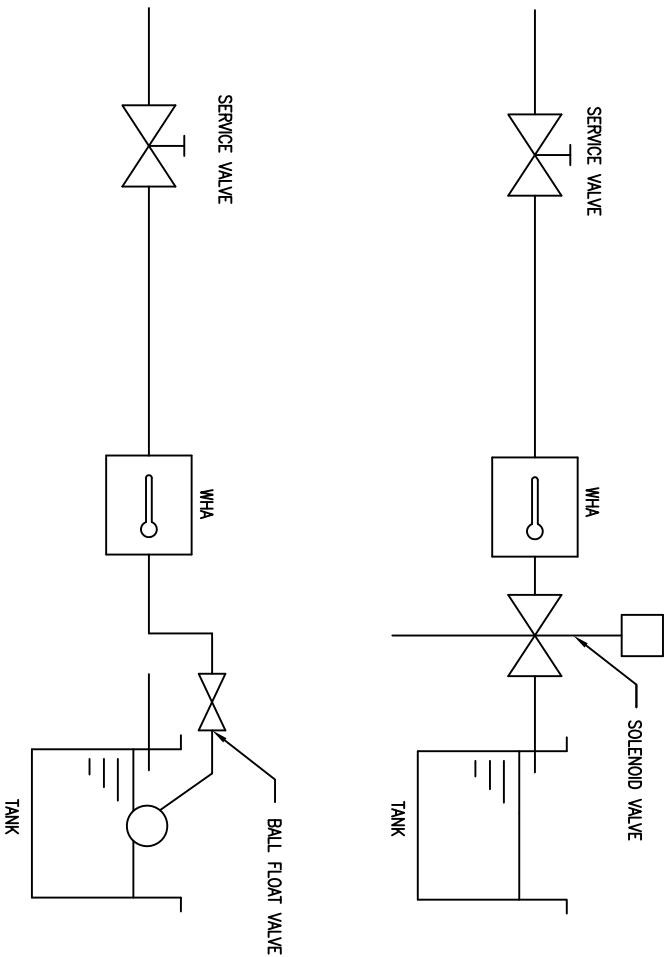

WHA INSTALLED NEXT TO SOLENOID VALVE OR BALL FLOAT VALVE

WHA TO TANK INLET
(IF APPLICABLE)

INSTALLATION METHOD OF WATER HAMMER ARRESTER (WHA)

FOR PRESSURE NOT EXCEEDING 232 PSI (16 BAR)

SCALE : NTS




JASA KEPADA RAKYAT

CAWANGAN KEJURUTERAAN MEKANIKAL
Ibu Pejabat JKR Malaysia


INTERNAL COLD WATER PLUMBING SYSTEM

INSTALLATION METHOD OF WATER HAMMER
ARRESTER (WHA) FOR PRESSURE
NOT EXCEEDING 232 PSI (16 BAR)


DATE	SCALE
2017	NTS
DRAWING NUMBER:	
CKMSTD/CWSP/CW/REV2017/12	

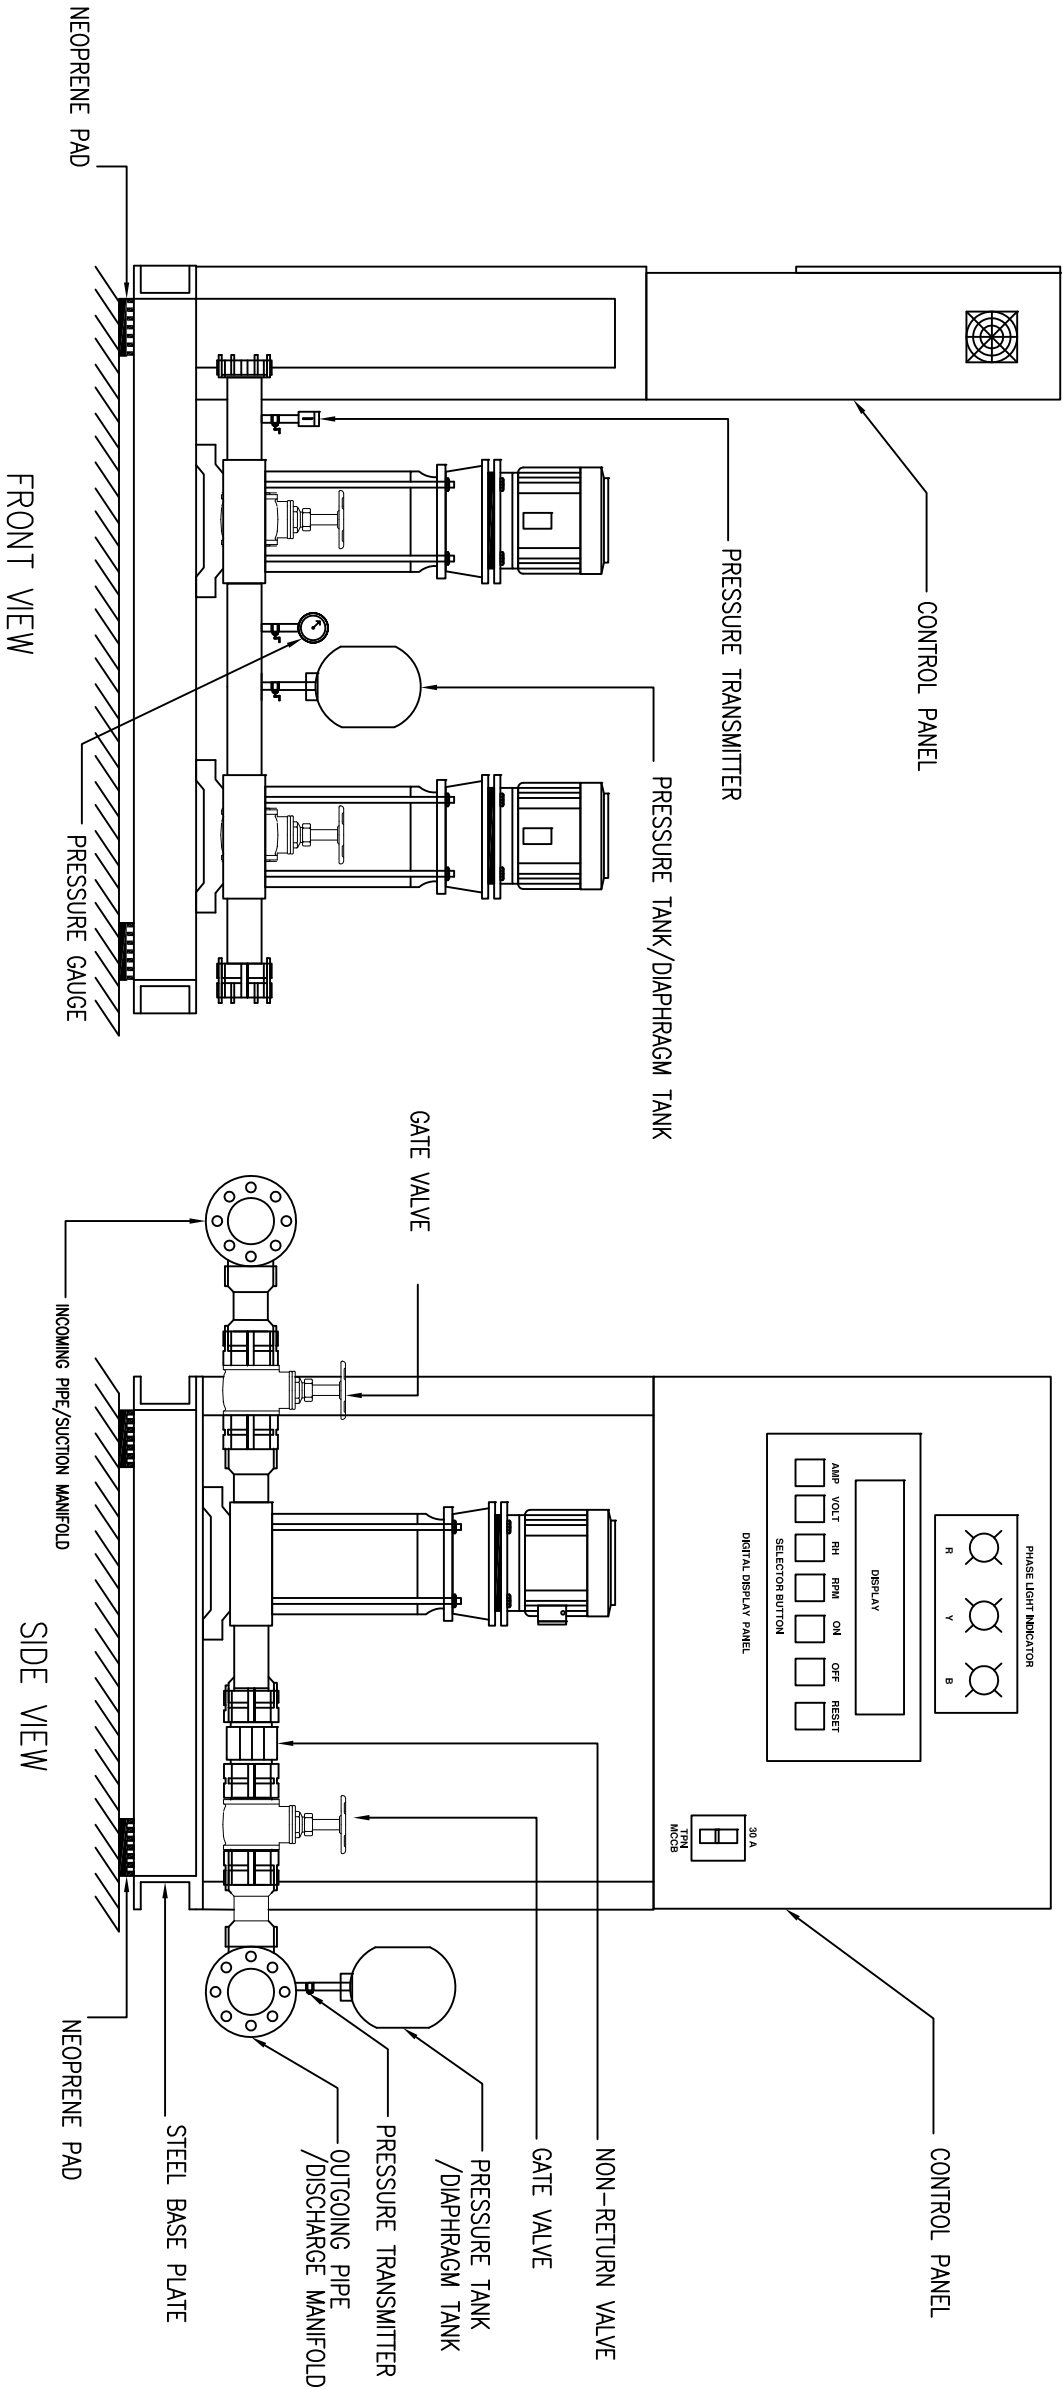

TYPICAL DETAILS OF PACKAGE BOOSTER PUMP SYSTEM INSTALLATION
SCALE : NTS

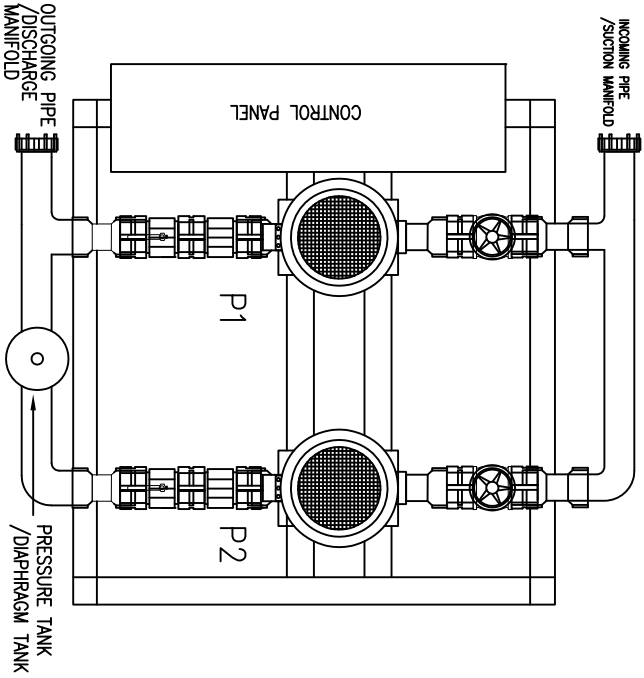

PLAN VIEW
SCALE : NTS

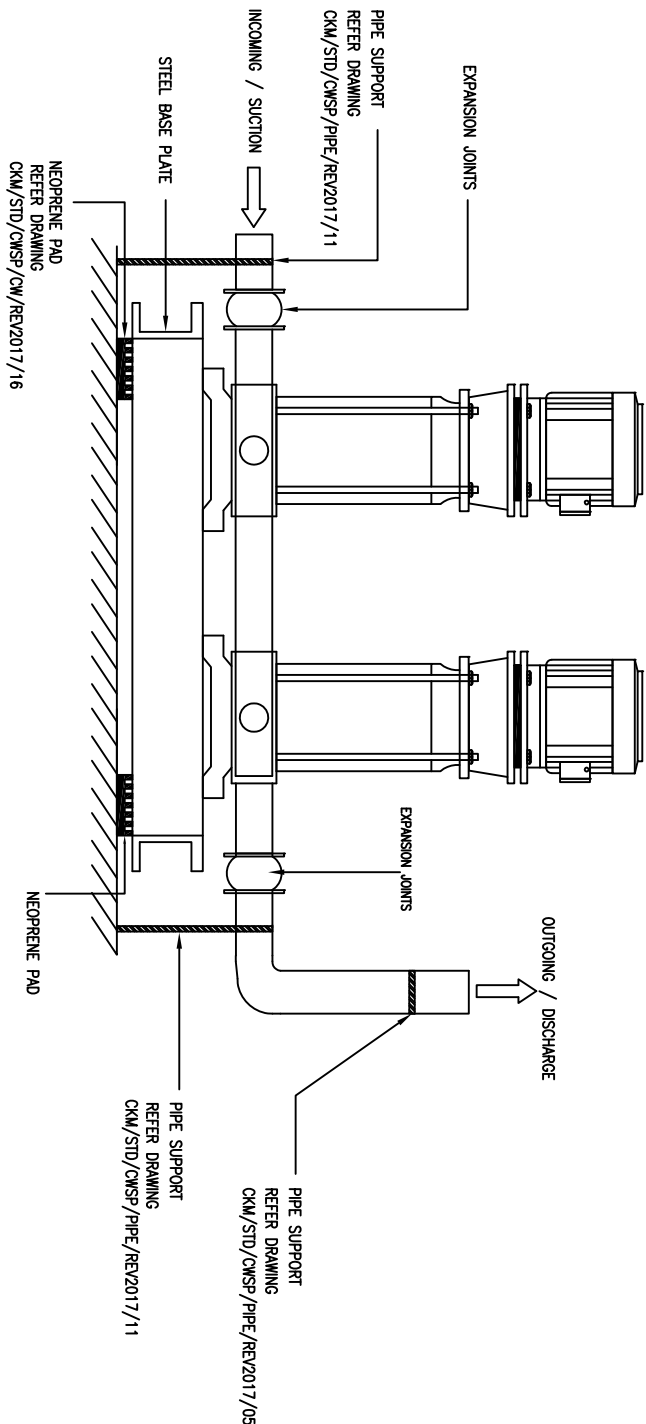

EXPANSION JOINTS AND PIPE SUPPORT INSTALLATION DETAILS
SCALE : NTS

LEGEND:






JASA KEPADA RAKYAT

CAWANGAN KEJURUTERAAN MEKANIKAL
Ibu Pejabat JKR Malaysia

INTERNAL COLD WATER PLUMBING SYSTEM
TYPICAL DETAILS OF PACKAGE
BOOSTER PUMP SYSTEM INSTALLATION

DATE: 2017 SCALE: NTS
DRAWING NUMBER: CKM/STD/CWSP/CW/REV2017/13


LEGEND:

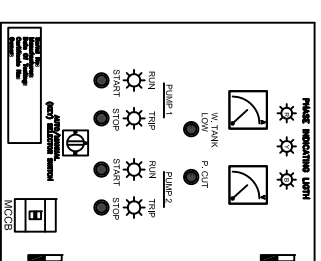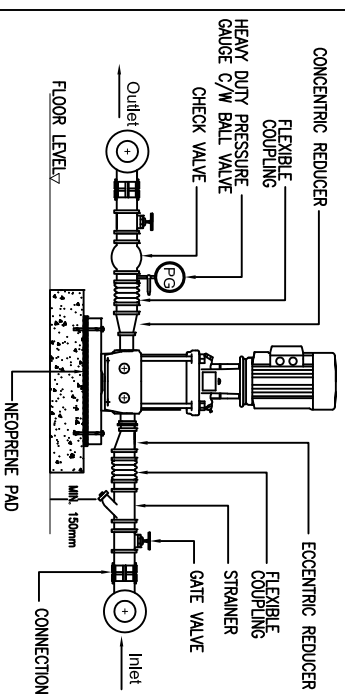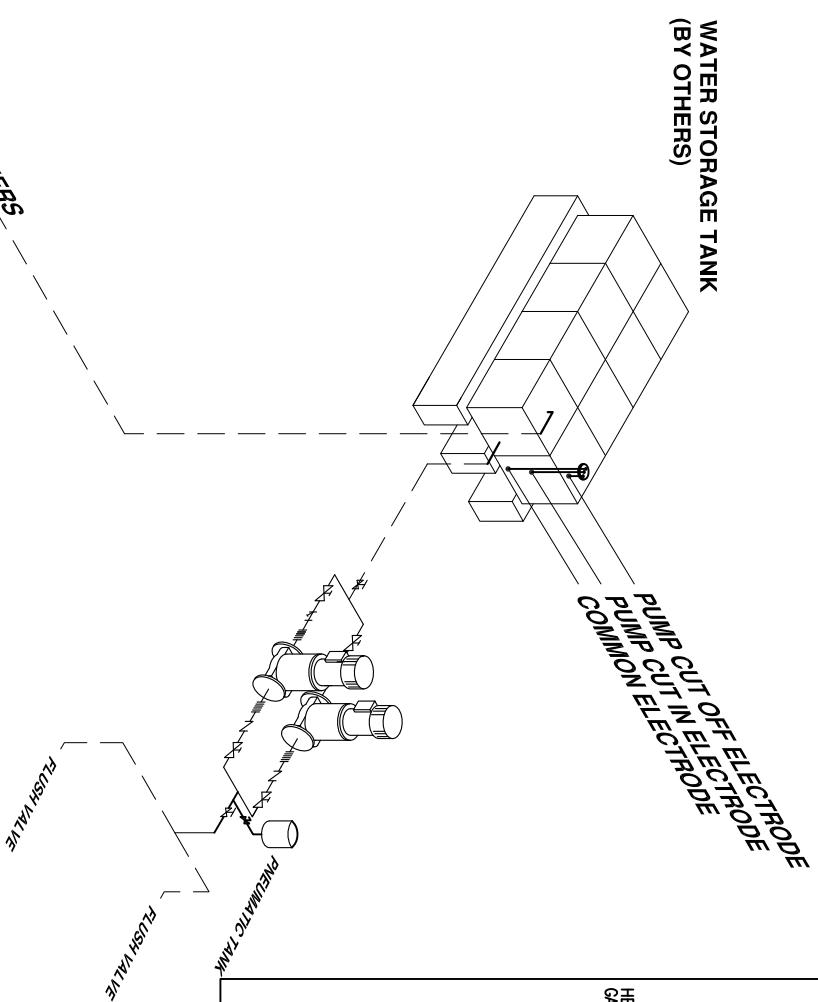

TYPICAL VALVES ARRANGEMENT
SCALE : NTS


**TYPICAL CONTROL PANEL
SCALE : NTS**

DETAIL FOR BOOSTER PUMP

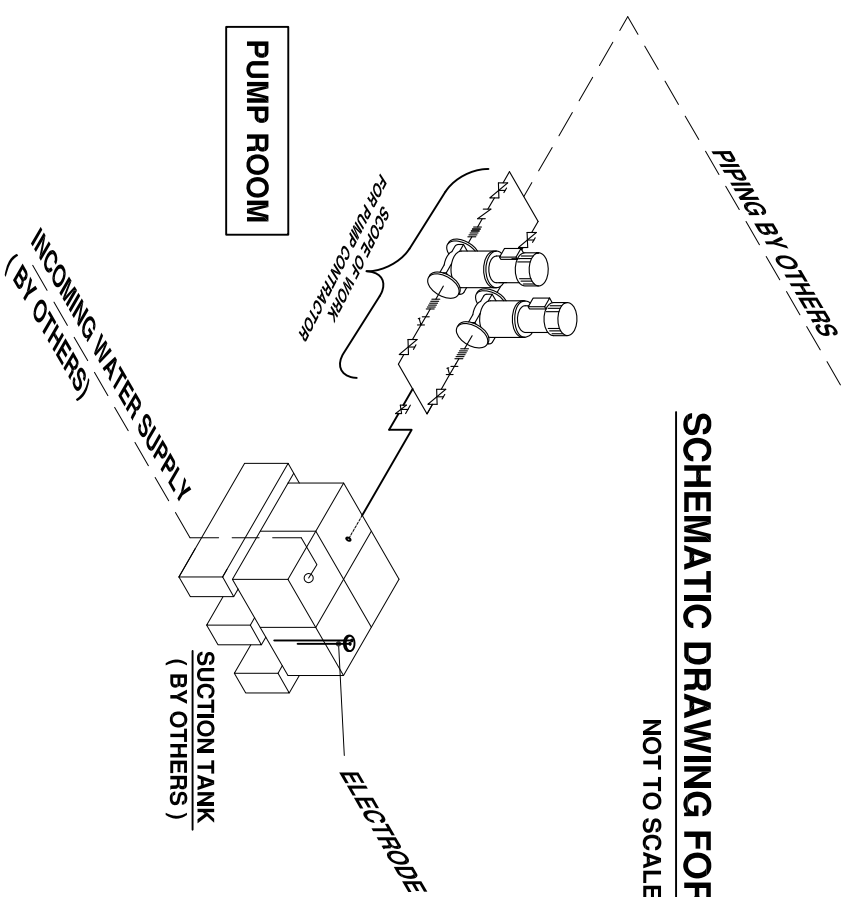

SCHEMATIC DRAWING FOR BOOSTER PUMP

NOT TO SCALE

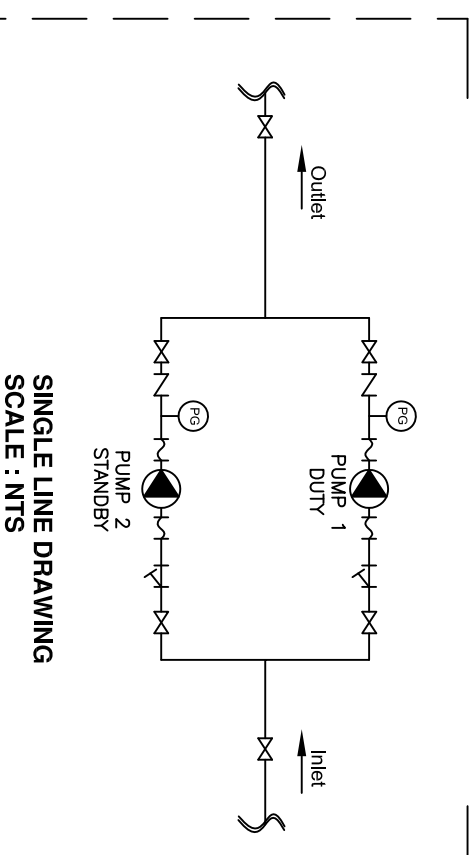

**SINGLE LINE DRAWING
SCALE: NTS**



JASA KEPADA RAKYAT

CAWANGAN KEJURUTERAAN MEKANIKAL
Ibu Pejabat JKR Malaysia

Ibu Pejabat JKR Malaysia


INTERNAL COLD WATER PLUMBING SYSTEM

DETAILS FOR BOOSTER PUMP


DATE	SCALE
2017	N.T.S

DRAWING NUMBER:



CKM/STD/CWSP/CW/REV2017/14

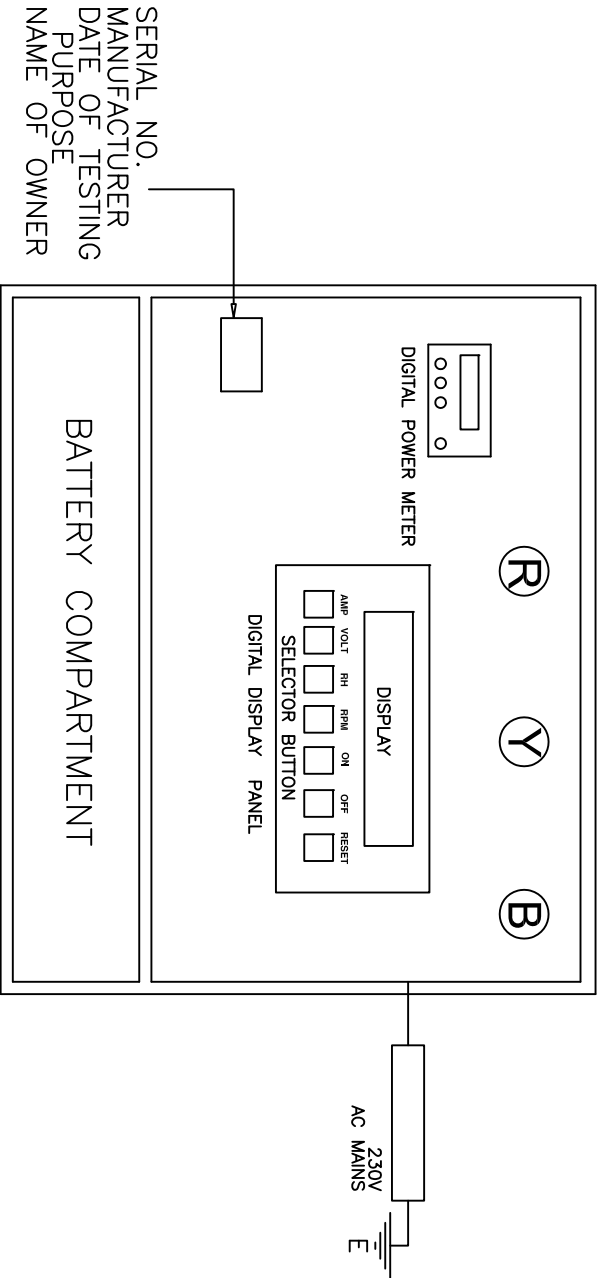

TYPICAL BOOSTER PUMP DIGITAL SWITCHBOARD

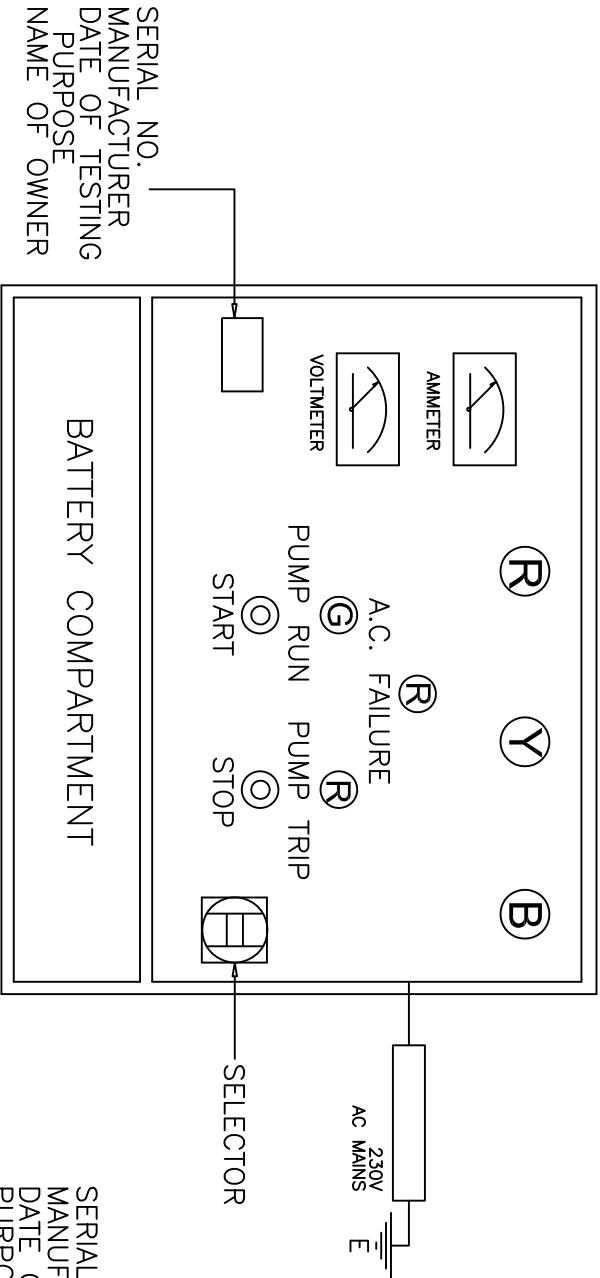

TYPICAL BOOSTER PUMP SWITCHBOARD

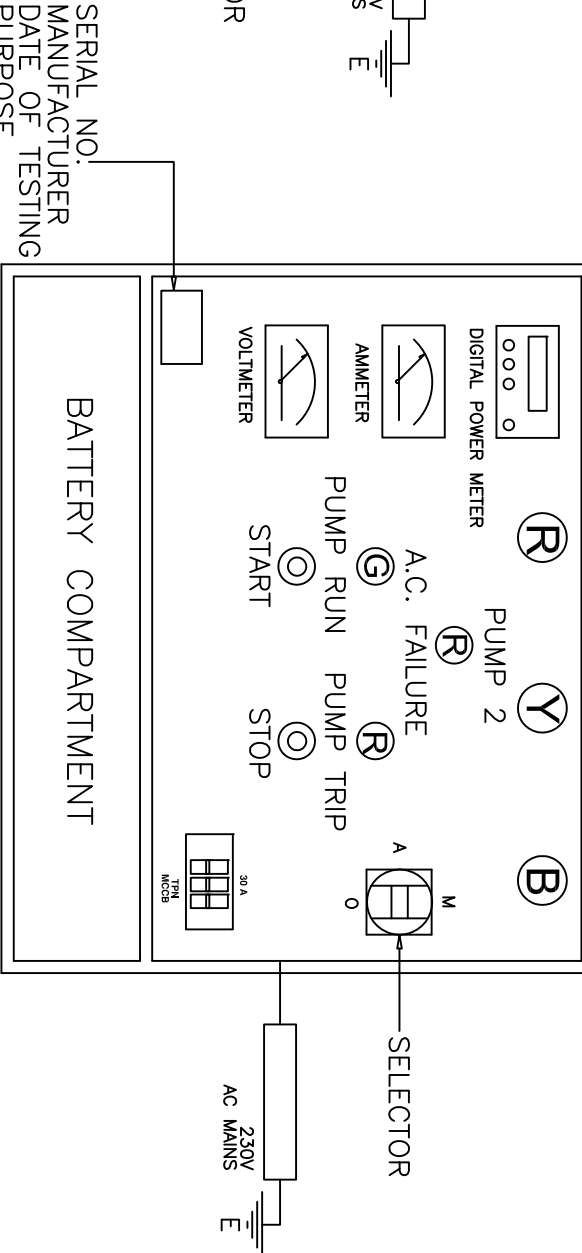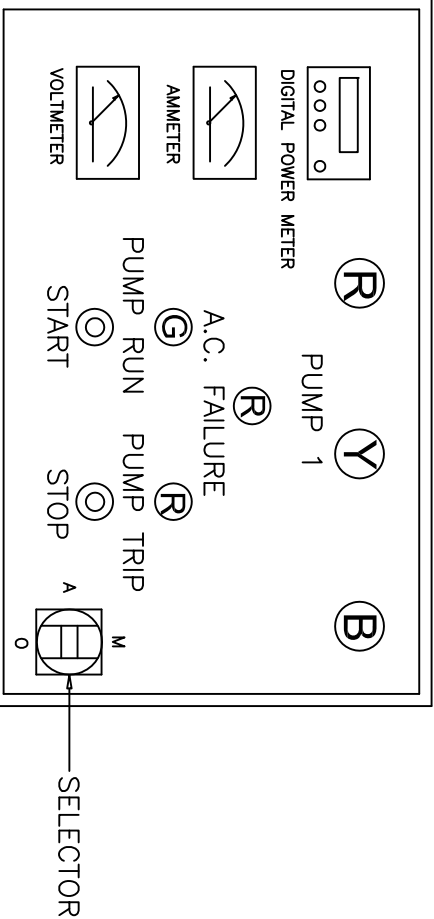

TYPICAL BOOSTER PUMP SWITCHBOARD

- LEGEND:
- (R) RED INDICATOR LIGHT
 - (Y) YELLOW INDICATOR LIGHT
 - (B) BLUE INDICATOR LIGHT
 - (G) GREEN INDICATOR LIGHT




CAWANGAN KEJURUTERAAN MEKANIKAL
Ibu Pejabat JKR Malaysia

INTERNAL COLD WATER PLUMBING SYSTEM

TYPICAL BOOSTER PUMP SWITCHBOARD

DATE	SCALE
2017	NT.S
DRAWING NUMBER:	
CKM/STD/CWSP/CW/REV2017/15	

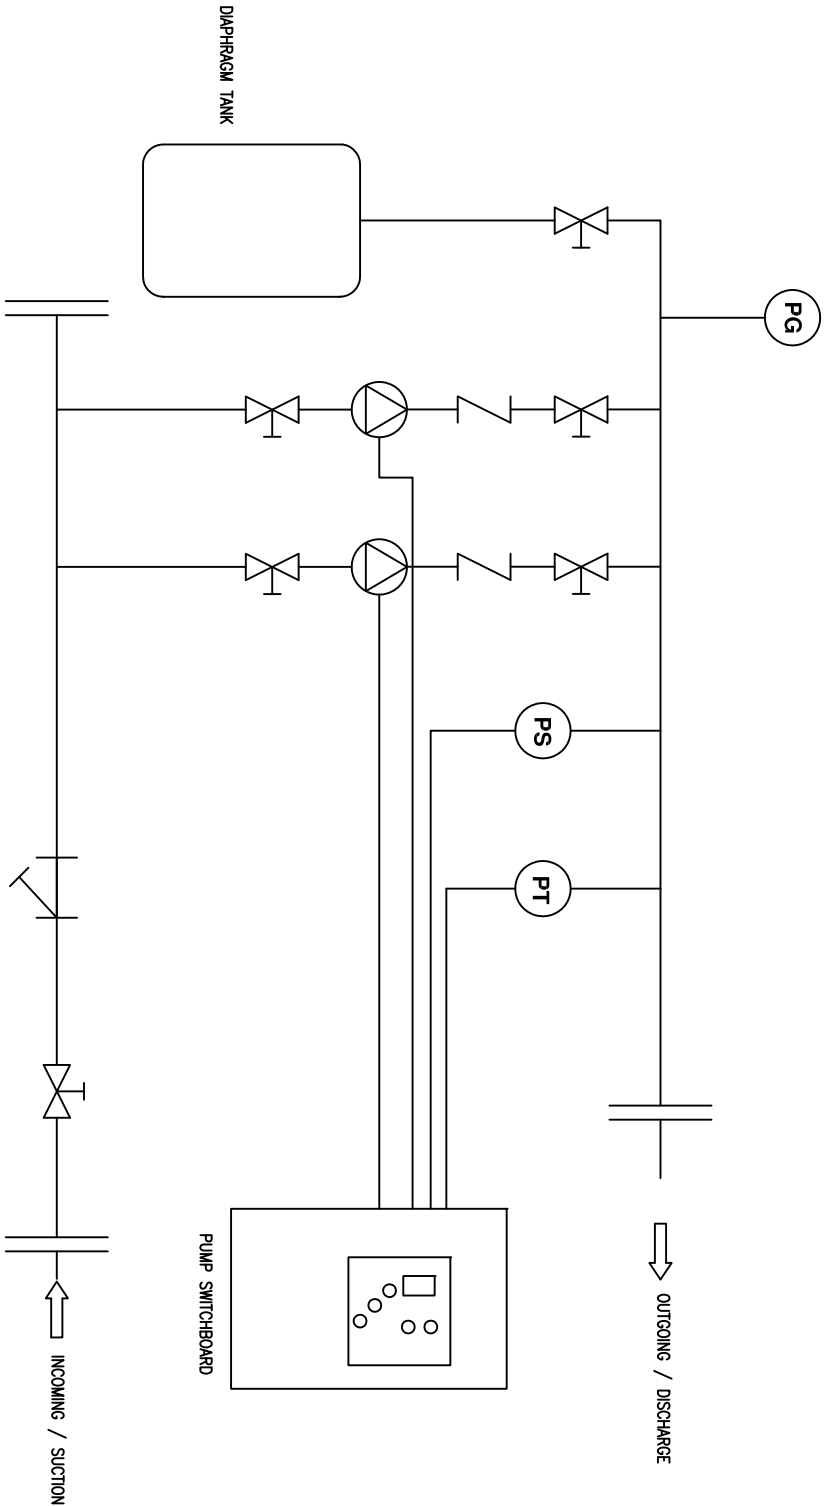

SCHEMATIC DETAILS OF PACKAGED BOOSTER PUMP SYSTEM
SCALE : NTS


- LEGEND:
- PG PRESSURE GAUGE
 - PS PRESSURE SWITCH
 - PT PRESSURE TRANSMITTER
 - PUMP
 - GATE VALVE
 - NON-RETURN VALVE
 - FLANGE COUPLING
 - STRAINER




JASA KEPADA RAKYAT
CAWANGAN KEJURUTERAAN MEKANIKAL
Ibu Pejabat JKR Malaysia

INTERNAL COLD WATER PLUMBING SYSTEM
SCHEMATIC DETAILS OF PACKAGE BOOSTER
PUMP SYSTEM


DATE	2017	SCALE	NTS
DRAWING NUMBER: CKMSTD/CWSP/CW/REV2017/16			

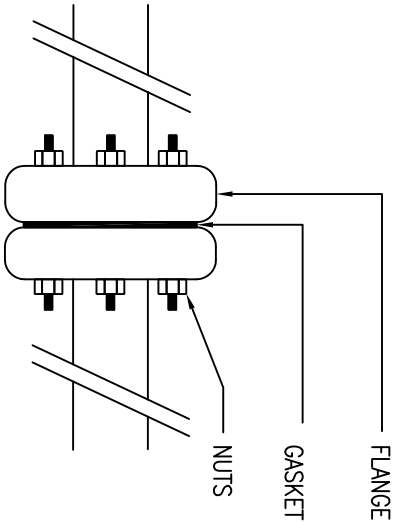


FLANGE INSTALLATION DETAILS

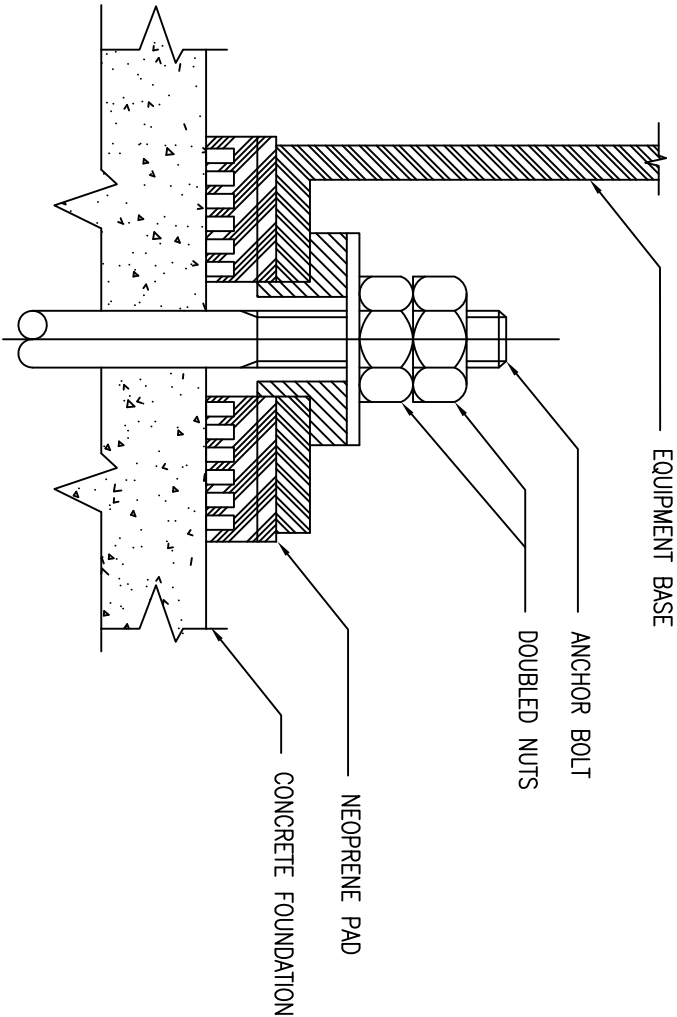

NEOPRENE PAD INSTALLATION DETAILS

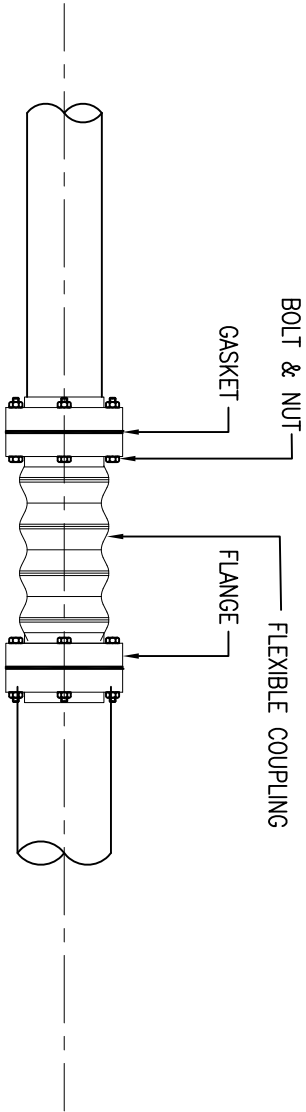

TYPICAL FLEXIBLE COUPLING/EXPANSION JOINT CONNECTION
SCALE : NTS

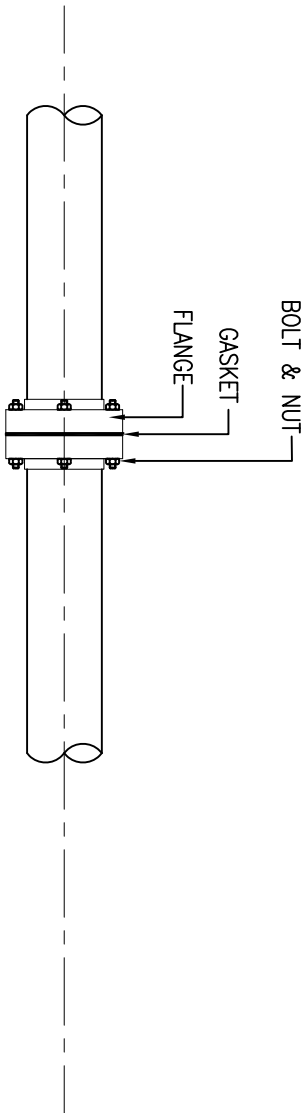

TYPICAL FLANGE JOINT CONNECTION
SCALE : NTS

LEGEND:



JASA KEPADA RAKYAT

CAWANGAN KEJURUTERAAN MEKANIKAL
Ibu Pejabat JKR Malaysia

INTERNAL COLD WATER PLUMBING SYSTEM
DETAILS OF FLANGE & NEOPRENE PAD
INSTALLATION

DATE	2017	SCALE	NTS
DRAWING NUMBER:	CKMSTD/CWSP/CW/REV2017/17		


NOTE:

- 1. The valve should be installed by licenced plumber in accordance with local codes and ordinances.
 - 2. The valve should be installed where it is accessible with sufficient clearance for cleaning, service or adjustment.
 - 3. The designer should advise architect the size of service shift to accomodate the PRV installation.
 - 4. PRV shall be reduces the pressures of the water goes through it and obtaining a regulated and constant value at its outlet.
 - 4. PRV shall protect the whole installation from problems due to excess pressure : noise in pipes, water hammer & premature wear
- The PRV shall be completely automatic.


LEGEND:

-  SHUT OFF VALVE
-  PRESSURE REDUCING VALVE (PRV)
-  CHECK VALVE
-  PRESSURE GAUGE


TYPICAL INSTALLATION

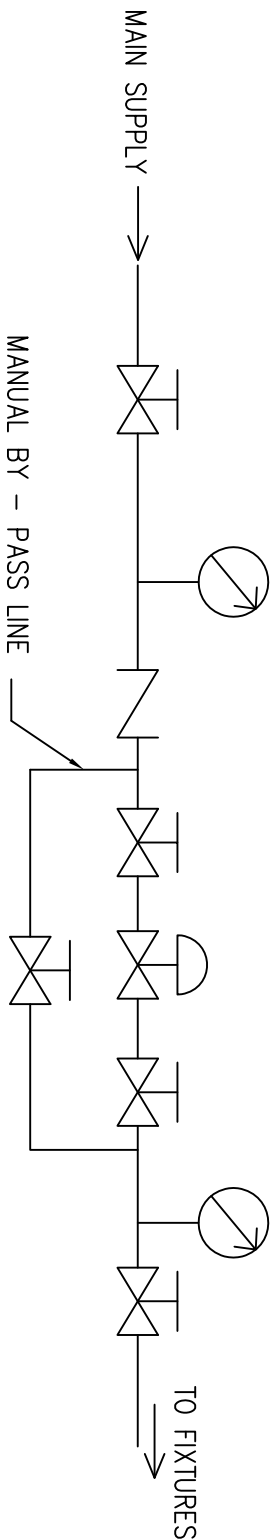

SERIES INSTALLATION

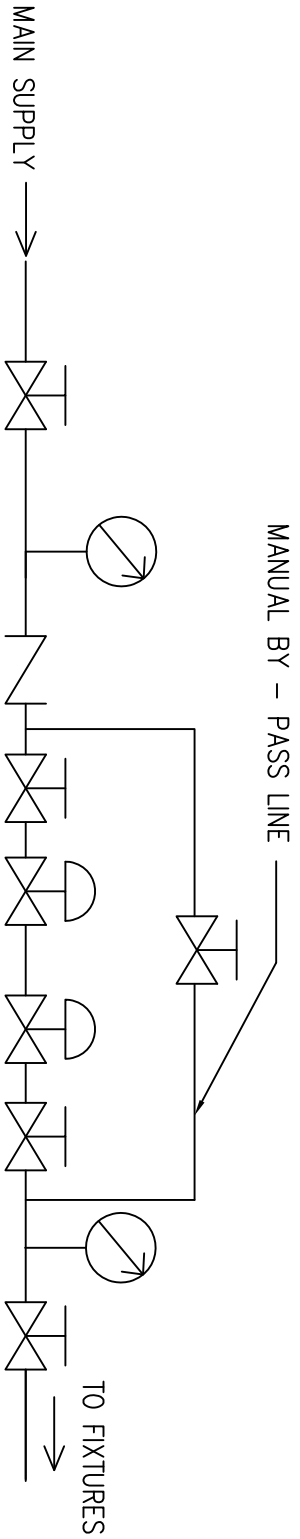

PARALLEL INSTALLATION

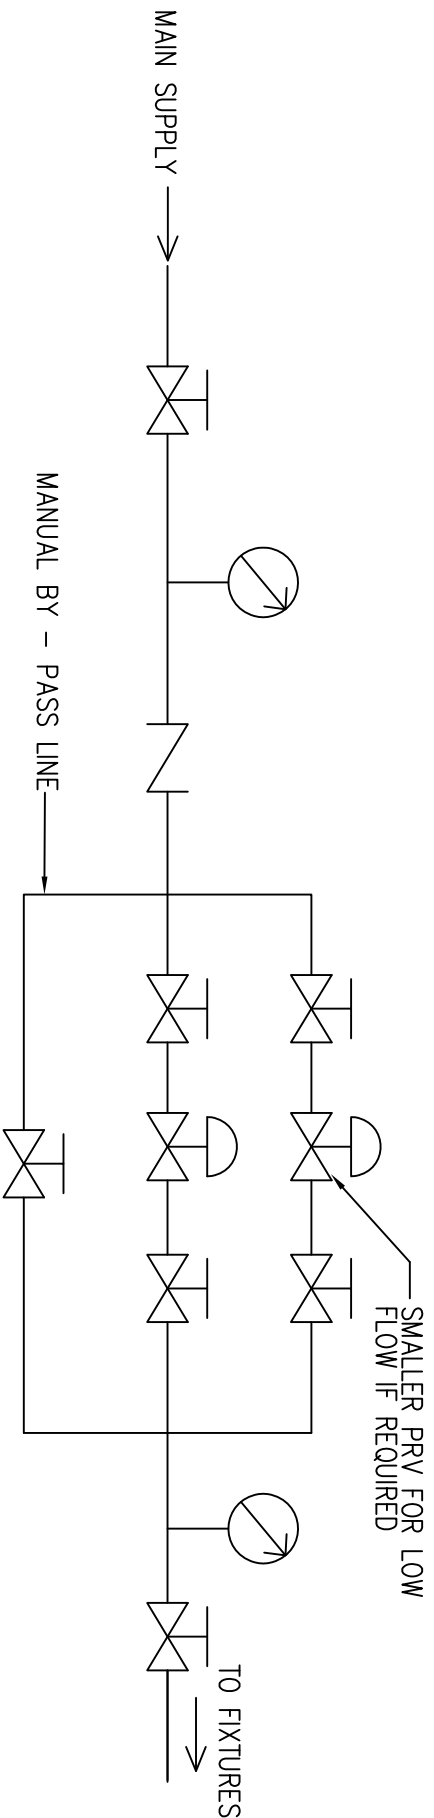

DETAILS OF PRESSURE REDUCING VALVE (PRV) INSTALLATION

SCALE : NTS



JASA KEPADA RAKYAT

CAWANGAN KEJURUTERAAN MEKANIKAL


Ibu Pejabat JKR Malaysia

INTERNAL COLD WATER PLUMBING SYSTEM

DETAILS OF PRESSURE REDUCING VALVE (PRV) INSTALLATION

DATE	SCALE
2017	NTS
DRAWING NUMBER:	
CKM/STD/CWSP/CW/REV2017/18	

SANITARY PLUMBING SYSTEM

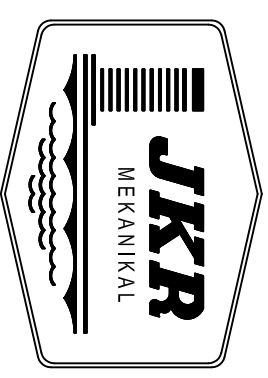


JASA KEPADA RAKYAT

Diameter (mm)	Surface Water Drains		Fouls Drains	
	Main Drain 100% gradient	Branch Drain 50% gradient	Main Drain 80% gradient	Branch Drain 40% gradient
75	1 : 75	1 : 35	1 : 60	1 : 30
100	1 : 100	1 : 50	1 : 80	1 : 40
150	1 : 150	1 : 75	1 : 120	1 : 60
225	1 : 225	1 : 110	1 : 180	1 : 90
300	1 : 300	1 : 150	1 : 240	1 : 120

RECOMMENDED MINIMUM GRADIENTS			
Peak flow (litres/sec)	Pipe Size (mm)	Minimum Gradient (1 in)	Maximum Capacity (litres/sec)
< 1	75	1 : 40	4.1
	100	1 : 40	9.2
> 1	75	1 : 80	2.8
	100	1 : 80 *	6.3
	150	1 : 150 **	15.0

Notes :
* – Minimum 1 WC
** – Minimum 5 WCs

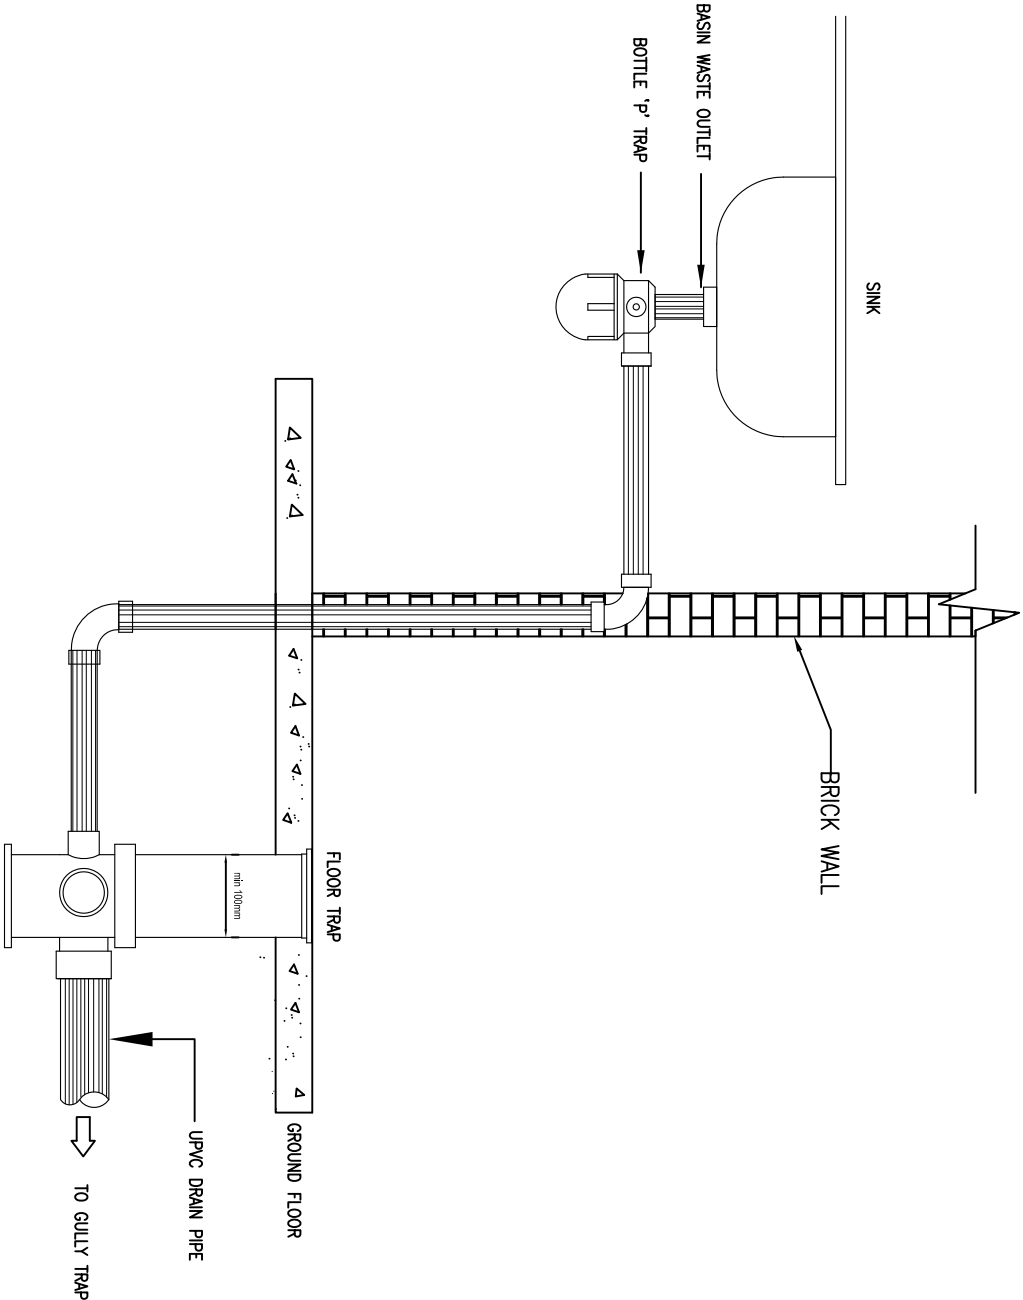

DETAILS OF SANITARY PIPE INSTALLATION FOR SINK–GROUND FLOOR

[Gradient pipe refer to BS EN 12056 Part 2 (2000)]

SCALE: N.T.S



JKR
MEKANIKAL

JASA KEPADA RAKYAT

CAWANGAN KEJURUTERAAN MEKANIKAL

Ibu Pejabat JKR Malaysia

SANITARY PLUMBING SYSTEM

DETAILS OF SANITARY PIPE INSTALLATION
FOR SINK-GROUND FLOOR

DATE:	SCALE:
2017	NTS


DRAWING NUMBER:

CKM/STD/CWSP/SP/REV2017/01

Diameter (mm)	Surface Water Drains		Fouls Drains	
	Main Drain 100% gradient	Branch Drain 50% gradient	Main Drain 80% gradient	Branch Drain 40% gradient
75	1 : 75	1 : 35	1 : 60	1 : 30
100	1 : 100	1 : 50	1 : 80	1 : 40
150	1 : 150	1 : 75	1 : 120	1 : 60
225	1 : 225	1 : 110	1 : 180	1 : 90
300	1 : 300	1 : 150	1 : 240	1 : 120

RECOMMENDED MINIMUM GRADIENTS			
Peak flow (litres/sec)	Pipe Size (mm)	Minimum Gradient (1 in)	Maximum Capacity (litres/sec)
< 1	75 100	1 : 40 1 : 40	4.1 9.2
> 1	75 100 150	1 : 80 1 : 80 * 1 : 150 **	2.8 6.3 15.0

Notes :
* – Minimum 1 WC
** – Minimum 5 WCs

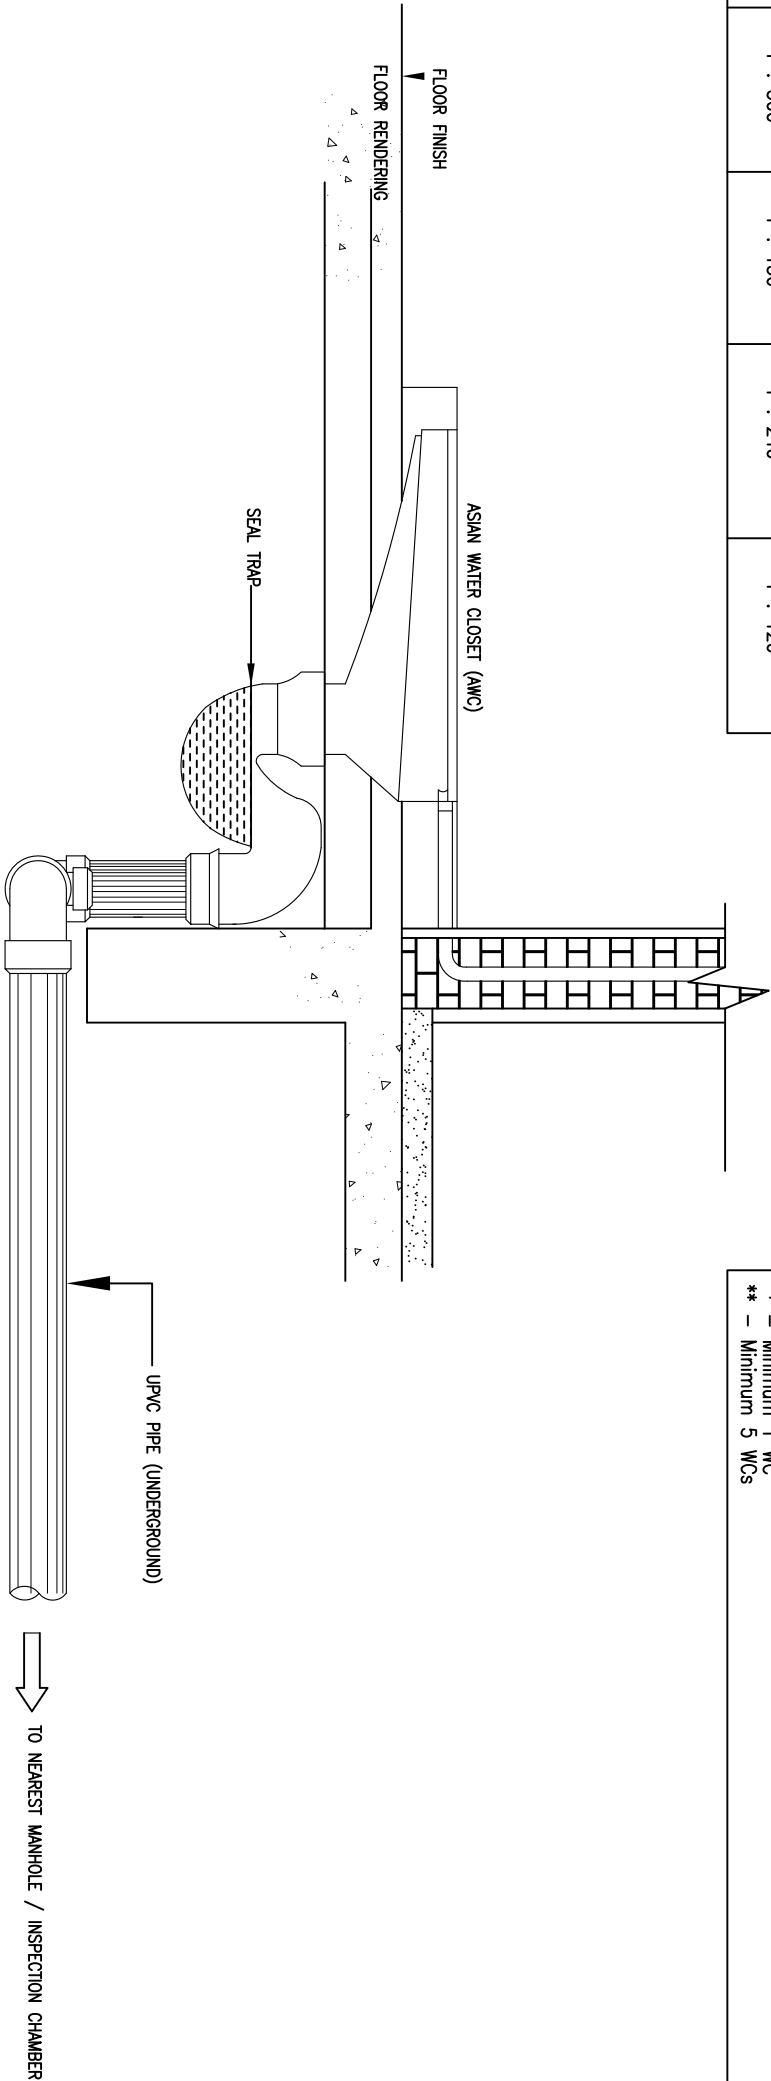

DETAILS OF SANITARY PIPE INSTALLATION FOR
ASIAN WATER CLOSET (AWC) –GROUND FLOOR
[Gradient pipe refer to BS EN 12056 Part 2 (2000)]

SCALE: N.T.S



JASA KEPADA RAKYAT

CAWANGAN KEJURUTERAAN MEKANIKAL
Ibu Pejabat JKR Malaysia

SANITARY PLUMBING SYSTEM

DETAILS OF SANITARY PIPE INSTALLATION
FOR ASIAN WATER CLOSET (AWC)
-GROUND FLOOR


DATE:	SCALE:
2017	NTS

DRAWING NUMBER:
CKM/STD/CWSP/SP/REV2017102

Diameter (mm)	Surface Water Drains		Fouls Drains	
	Main Drain 100% gradient	Branch Drain 50% gradient	Main Drain 80% gradient	Branch Drain 40% gradient
75	1 : 75	1 : 35	1 : 60	1 : 30
100	1 : 100	1 : 50	1 : 80	1 : 40
150	1 : 150	1 : 75	1 : 120	1 : 60
225	1 : 225	1 : 110	1 : 180	1 : 90
300	1 : 300	1 : 150	1 : 240	1 : 120

SINK TANK

EUROPEAN WATER CLOSET (EWC)

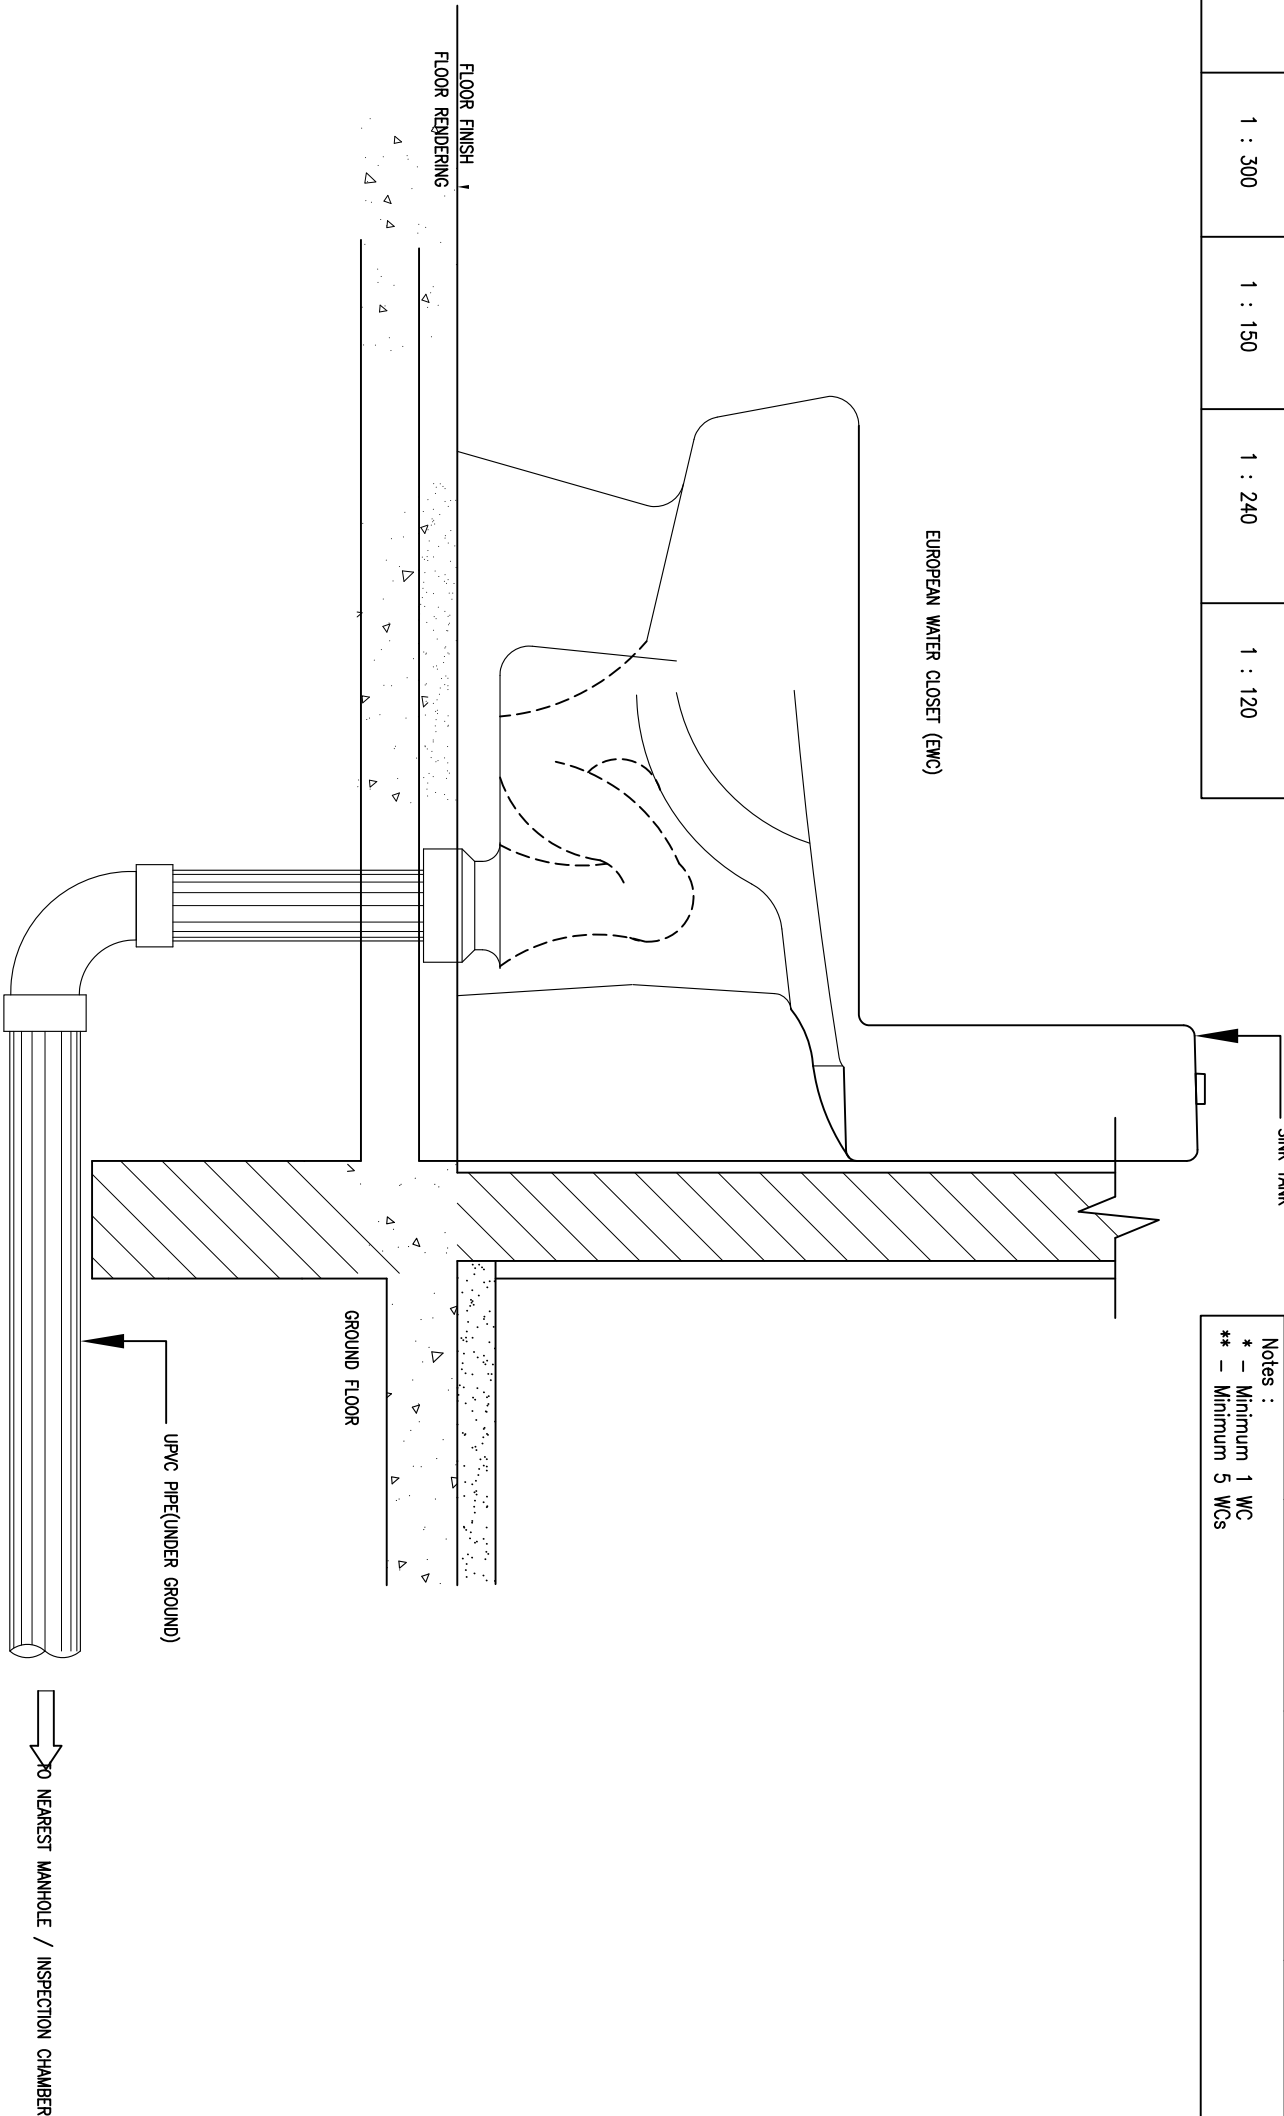

RECOMMENDED MINIMUM GRADIENTS			
Peak flow (litres/sec)	Pipe Size (mm)	Minimum Gradient (1 in)	Maximum Capacity (litres/sec)
< 1	75 100	1 : 40 1 : 40	4.1 9.2
> 1	75 100 150	1 : 80 1 : 80 * 1 : 150 **	2.8 6.3 15.0

Notes :
* – Minimum 1 WC
** – Minimum 5 WCs



JASA KEPADA RAKYAT
CAWANGAN KEJURUTERAAN MEKANIKAL
Ibu Pejabat JKR Malaysia

SANITARY PLUMBING SYSTEM

DETAILS OF SANITARY PIPE INSTALLATION
FOR EUROPEAN WATER CLOSET (EWC)
-GROUND FLOOR

DETAILS OF SANITARY PIPE INSTALLATION FOR


EUROPEAN WATER CLOSET (EWC)–GROUND FLOOR

[Gradient pipe refer to BS EN 12056 Part 2 (2000)]

SCALE: N.T.S

DATE:	2017	SCALE:	NTS
DRAWING NUMBER:			
CKM/STD/CWSP/SP/REV2017/03			

RECOMMENDED MINIMUM GRADIENTS			
Peck flow (lites/sec)	Pipe Size (mm)	Minimum Gradient (1 in)	Maximum Capacity (lites/sec)
< 1	75	1 : 40	4.1
	100	1 : 40	9.2
> 1	75	1 : 80	2.8
	100	1 : 80 *	6.3
	150	1 : 150 **	15.0
Notes : * – Minimum 1 WC ** – Minimum 5 WCs			

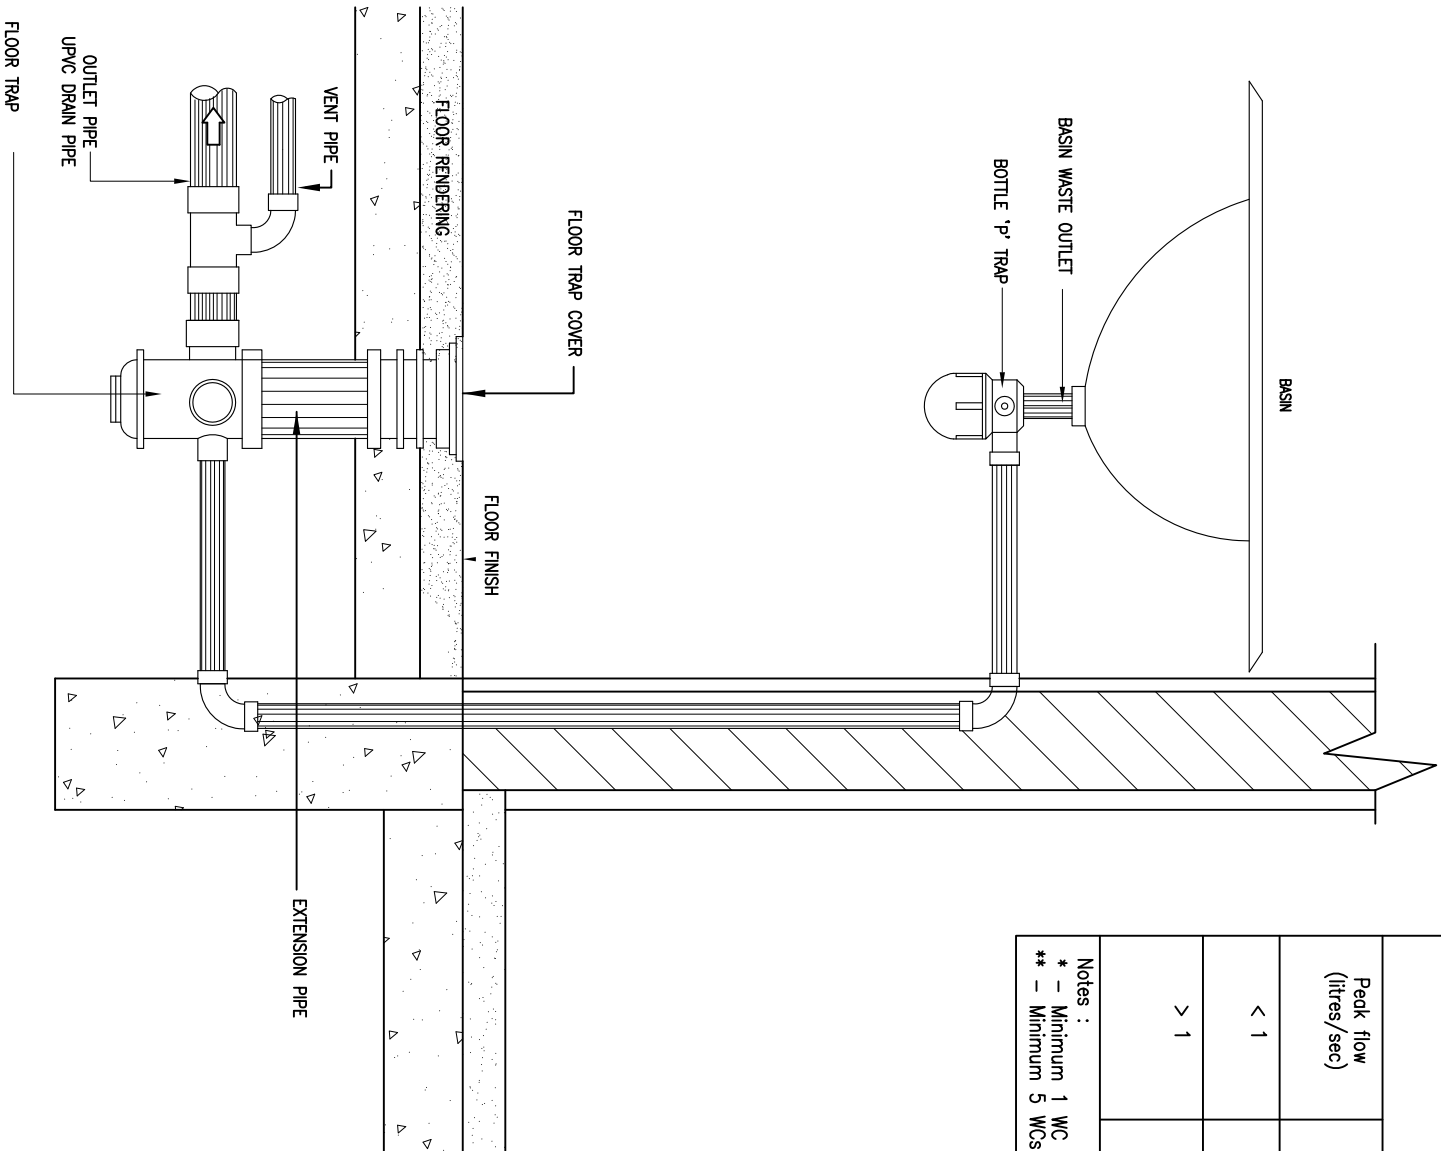


DETAILS OF SANITARY PIPE INSTALLATION FOR
BASIN & FLOOR TRAP-ABOVE GROUND FLOOR
[Gradient pipe refer to BS EN 12056 Part 2 (2000)]
SCALE: N.T.S



CAWANGAN KEJURUTERAAN MEKANIKAL
Ibu Pejabat JKR Malaysia

SANITARY PLUMBING SYSTEM
DETAILS OF SANITARY PIPE INSTALLATION
FOR BASIN & FLOOR TRAP
- ABOVE GROUND FLOOR

DATE:	2017	SCALE:	NTS
DRAWING NUMBER: CKM/STD/CWSP/SP/REV2017/04			

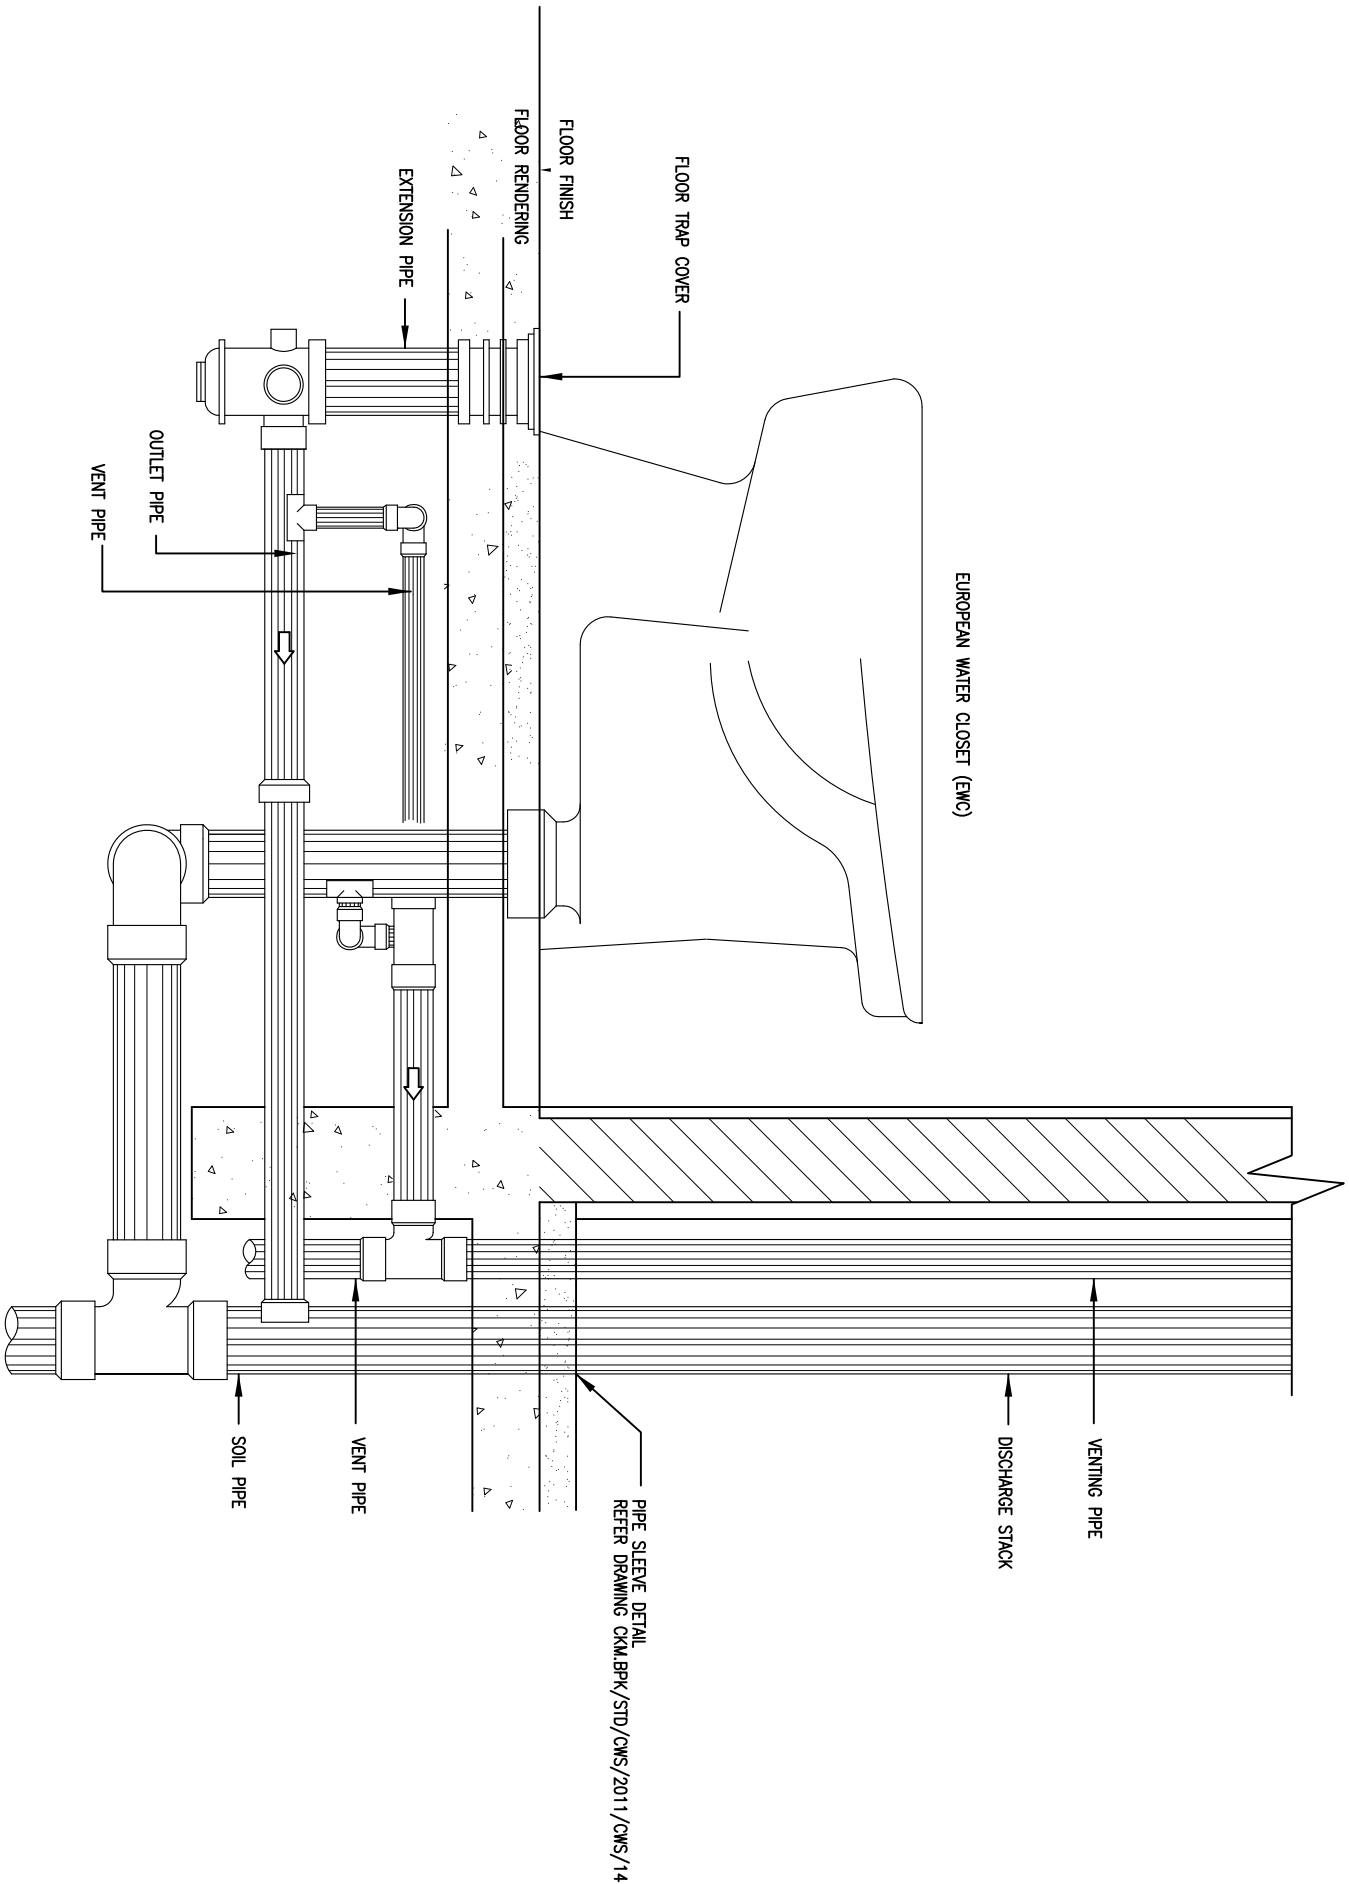

DETAILS OF SANITARY PIPE INSTALLATION
FOR EUROPEAN WATER CLOSET (EWC)
ABOVE GROUND FLOOR
SCALE: N.T.S




JASA KEPADA RAKYAT

CAWANGAN KEJURUTERAAN MEKANIKAL
Ibu Pejabat JKR Malaysia

SANITARY PLUMBING SYSTEM

DETAILS OF SANITARY PIPE INSTALLATION
FOR EUROPEAN WATER CLOSET (EWC)
ABOVE GROUND FLOOR

DATE:	2017	SCALE:	NTS
DRAWING NUMBER:	CKM/STD/CWSP/SP/REV2017/05		

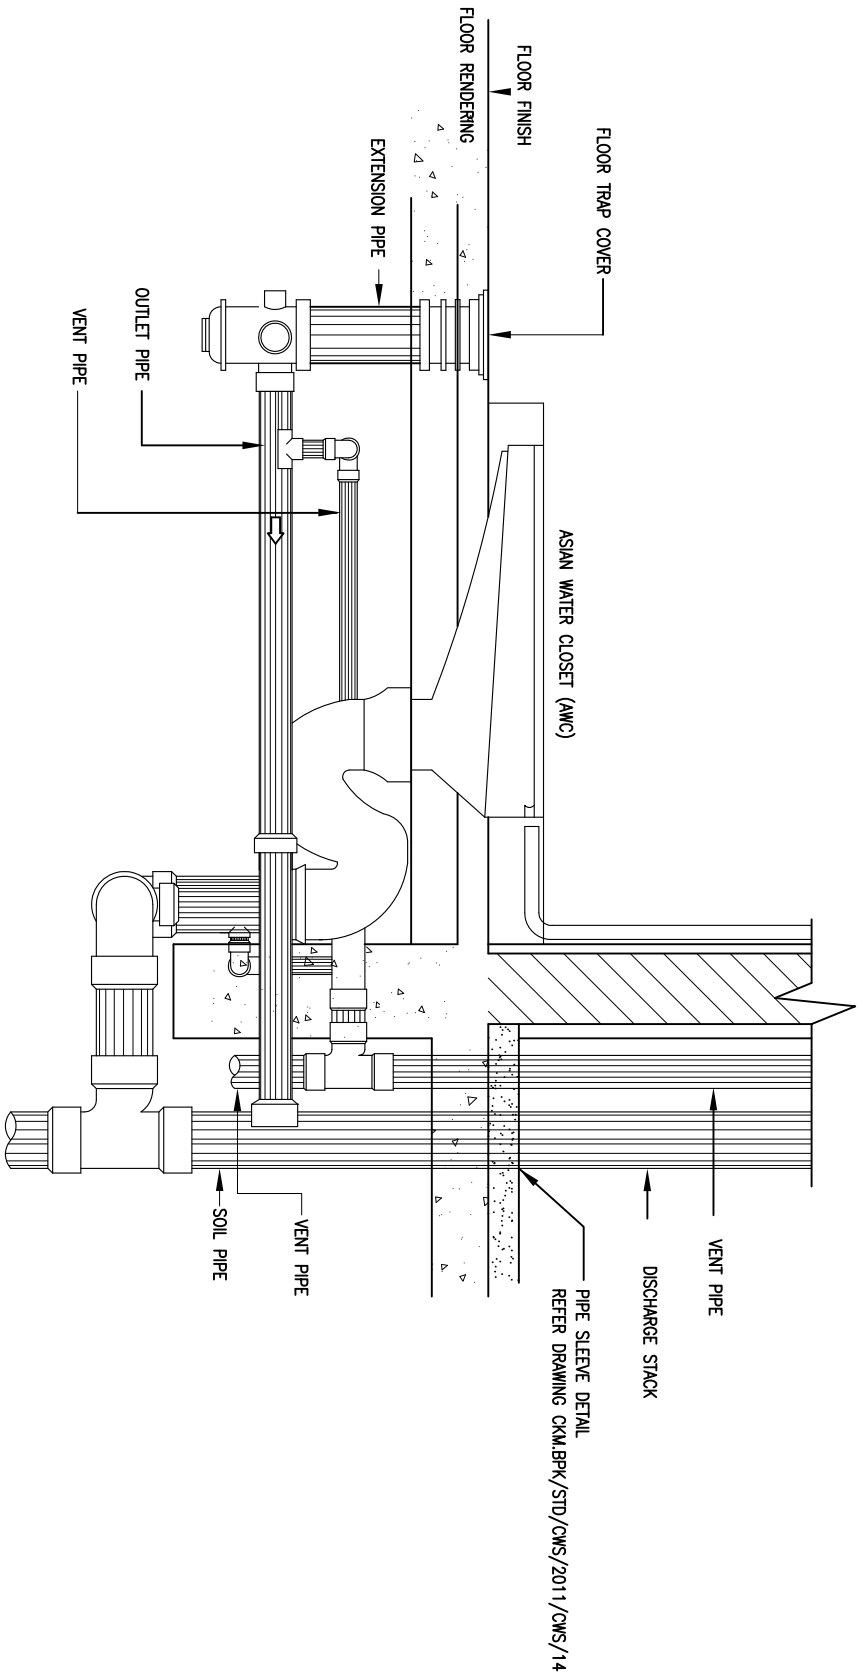

DETAILS OF SANITARY PIPE INSTALLATION FOR
ASIAN WATER CLOSET (AWC) – ABOVE GROUND FLOOR
SCALE: N.T.S





JASA KEPADA RAKYAT

CAWANGAN KEJURUTERAAN MEKANIKAL
Ibu Pejabat JKR Malaysia

SANITARY PLUMBING SYSTEM

DETAILS OF SANITARY PIPE INSTALLATION
FOR ASIAN WATER CLOSET (AWC)
- ABOVE GROUND FLOOR


DATE:	SCALE:
2017	NTS
DRAWING NUMBER:	
CKM/STD/CWSP/SP/REV/2017/06	

  


DETAILS OF SANITARY PIPE INSTALLATION FOR FLOOR TRAP UNDER GROUND

SCALE: N.T.S

	
JASA KEPADA RAKYAT	
CAWANGAN KEJURUTERAAN MEKANIKAL	
Ibu Pejabat JKR Malaysia	
<u>SANITARY PLUMBING SYSTEM</u>	
DETAILS OF SANITARY PIPE INSTALLATION FOR FLOOR TRAP UNDER GROUND	
DATE:	2017
SCALE:	1:10
DRAWING NUMBER:	CKM/STD/CWSP/SP/REV/2017/07

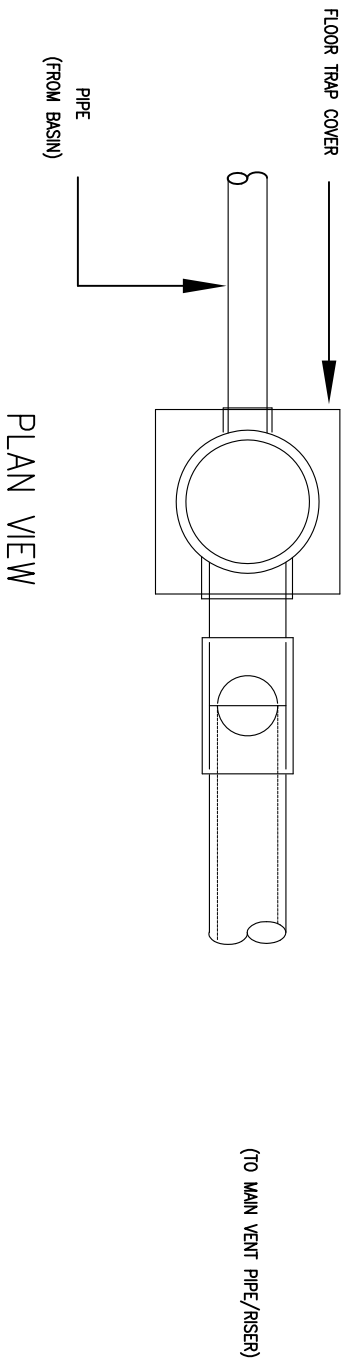

PLAN VIEW

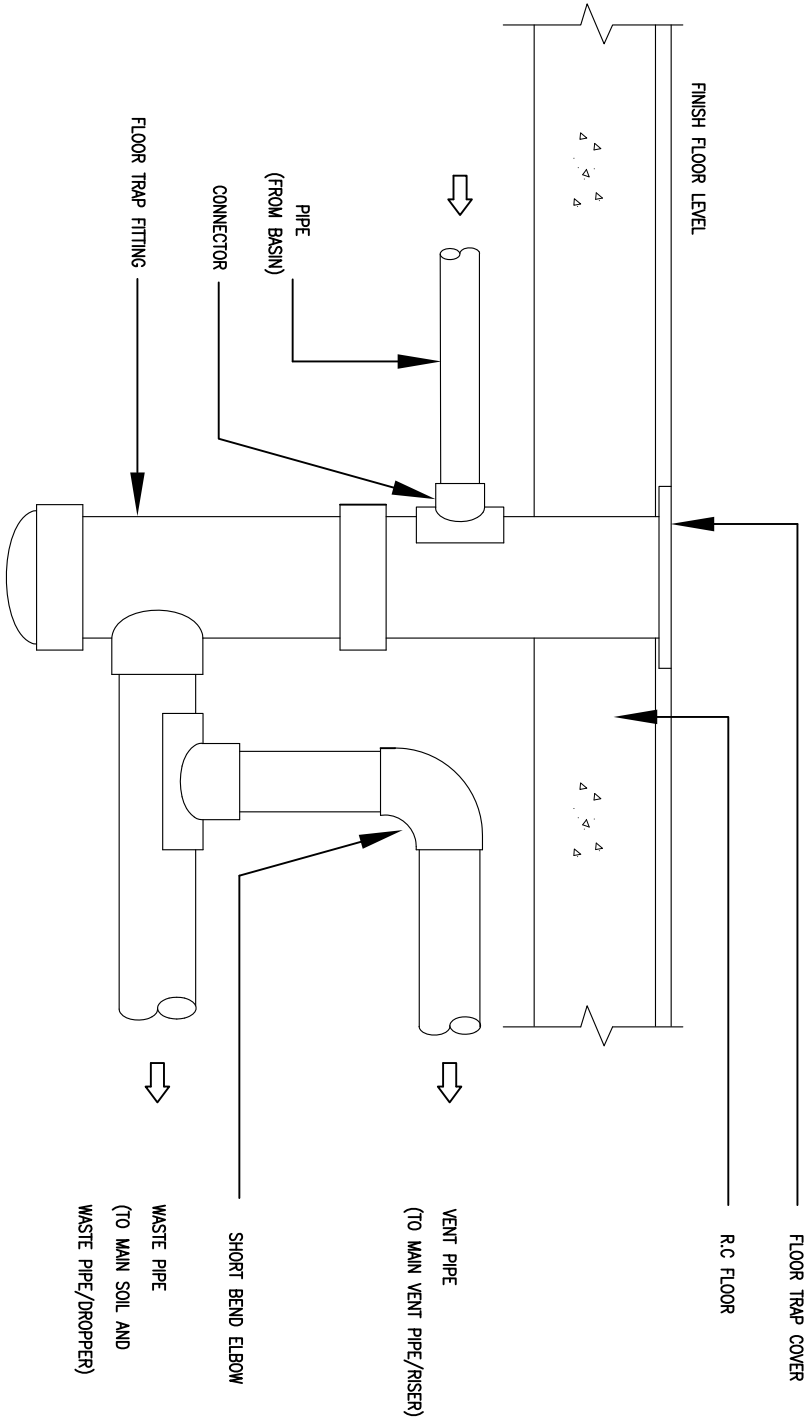

SIDE VIEW

DETAILS OF SANITARY PIPE INSTALLATION-FOR FLOOR TRAP ABOVE GROUND

SCALE: N:1'S



JAS A KEPADA RAKYAT


CAWANGAN KEJURUTERAAN MEKANIKAL

Ibu Pejabat JKR Malaysia

SANITARY PLUMBING SYSTEM


DETAILS OF SANITARY PIPE INSTALLATION FOR FLOOR TRAP ABOVE GROUND

DATE:	2017	SCALE:	NTS
DRAWING NUMBER:			
CKM/STD/CWSP/SP/REV/2017/08			

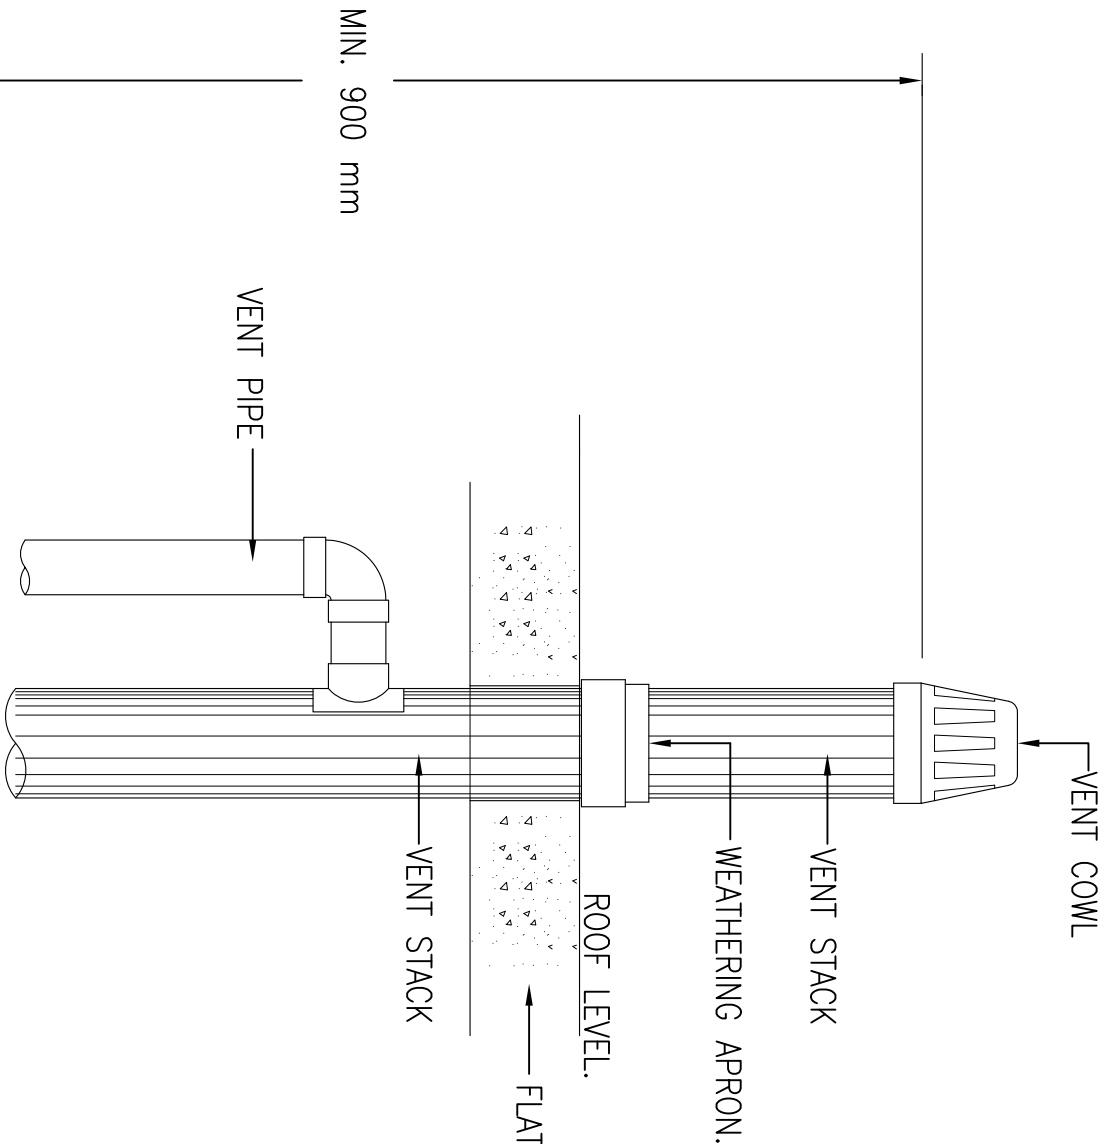

DETAILS OF VENT COWL INSTALLATION

SCALE: N:1'S

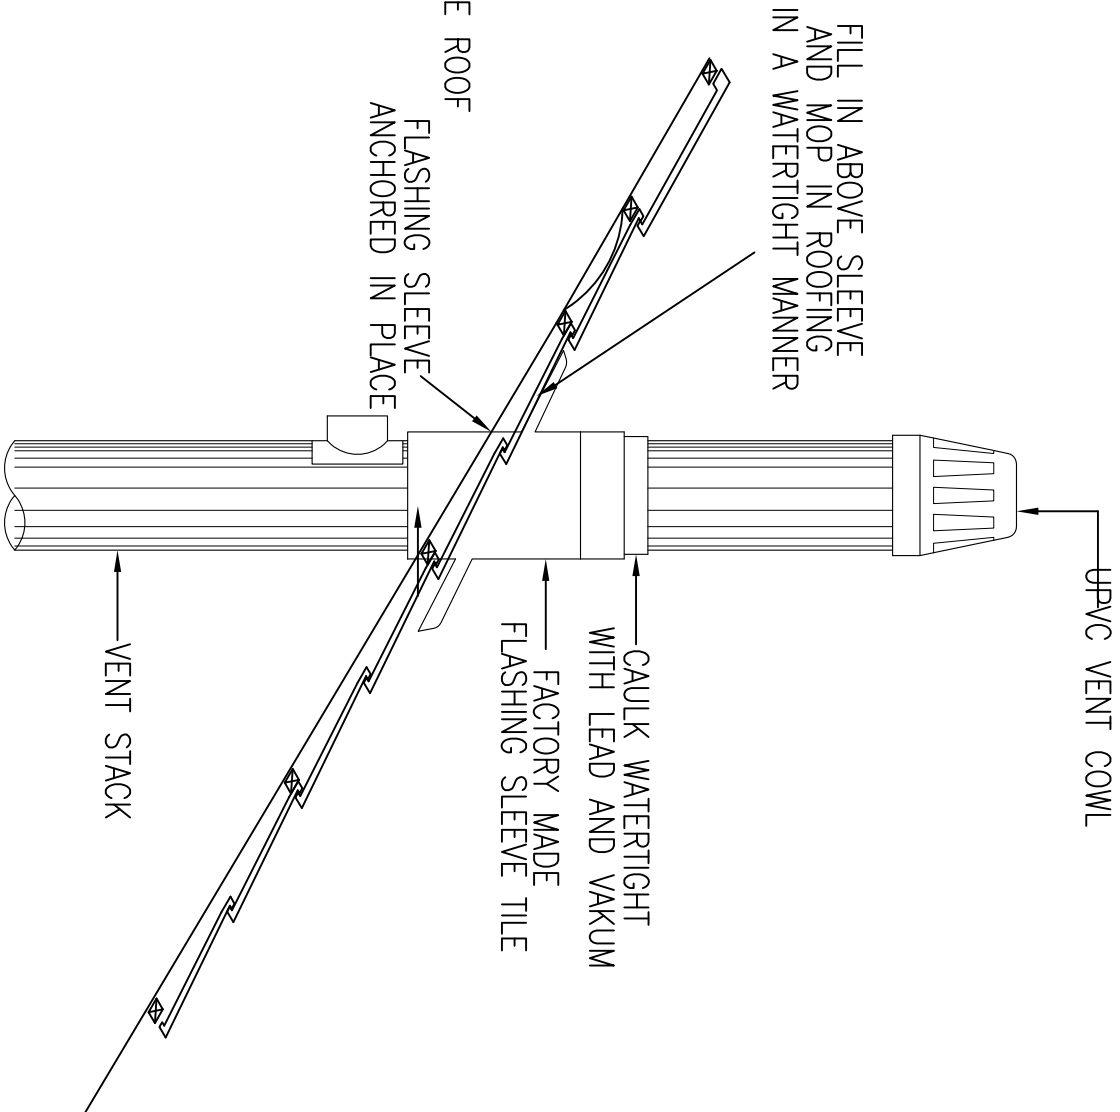

UPVC PIPE PENETRATION DETAIL THROUGH PITCH ROOF

SCALE: N:1'S

- NOTE:
1. The stack is not less than 900 mm above the head of any window or other opening into a building and with a horizontal distance of 3 m. (SOURCE: BS 5572)
 2. All main stack shall be minimum 150 mm diameter or subject to S.O approval.



JASA KEPADA RAKYAT

CAWANGAN KEJURUTERAAN MEKANIKAL
Ibu Pejabat JKR Malaysia


SANITARY PLUMBING SYSTEM

DETAILS OF VENT COWL INSTALLATION


DATE:	2017	SCALE:	NTS
DRAWING NUMBER:	CKM/STD/CWSP/SP/REV2017/09		

NOTE:

1. Maximum 4 incoming inlet pipe are allowed per 1 gully trap

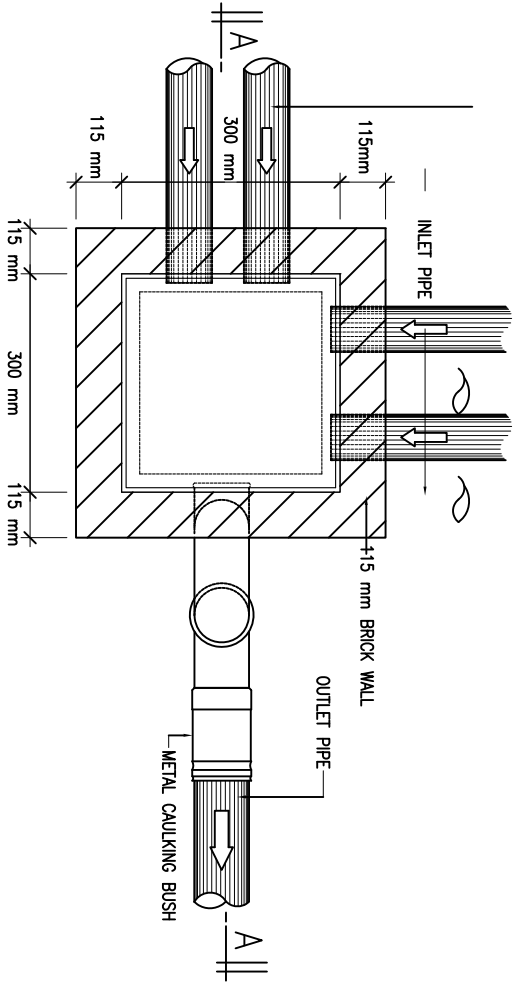

PLAN VIEW
(Maximum 4 inlet from floor trap & basin to gully trap)

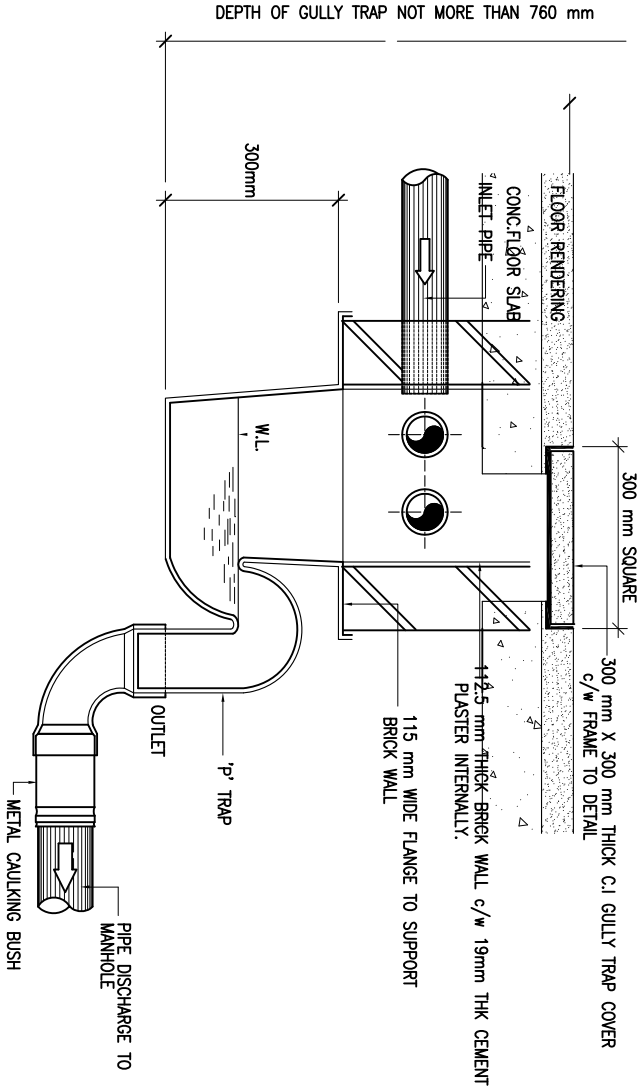

SECTION A-A



JASA KEPADA RAKYAT


CAWANGAN KEJURUTERAAN MEKANIKAL
Ibu Pejabat JKR Malaysia

SANITARY PLUMBING SYSTEM


DETAILS OF GULLY TRAP INSTALLATION

DATE:	SCALE:
2017	NTS

DRAWING NUMBER:
CKM/STD/CWSP/SP/REV2017/10

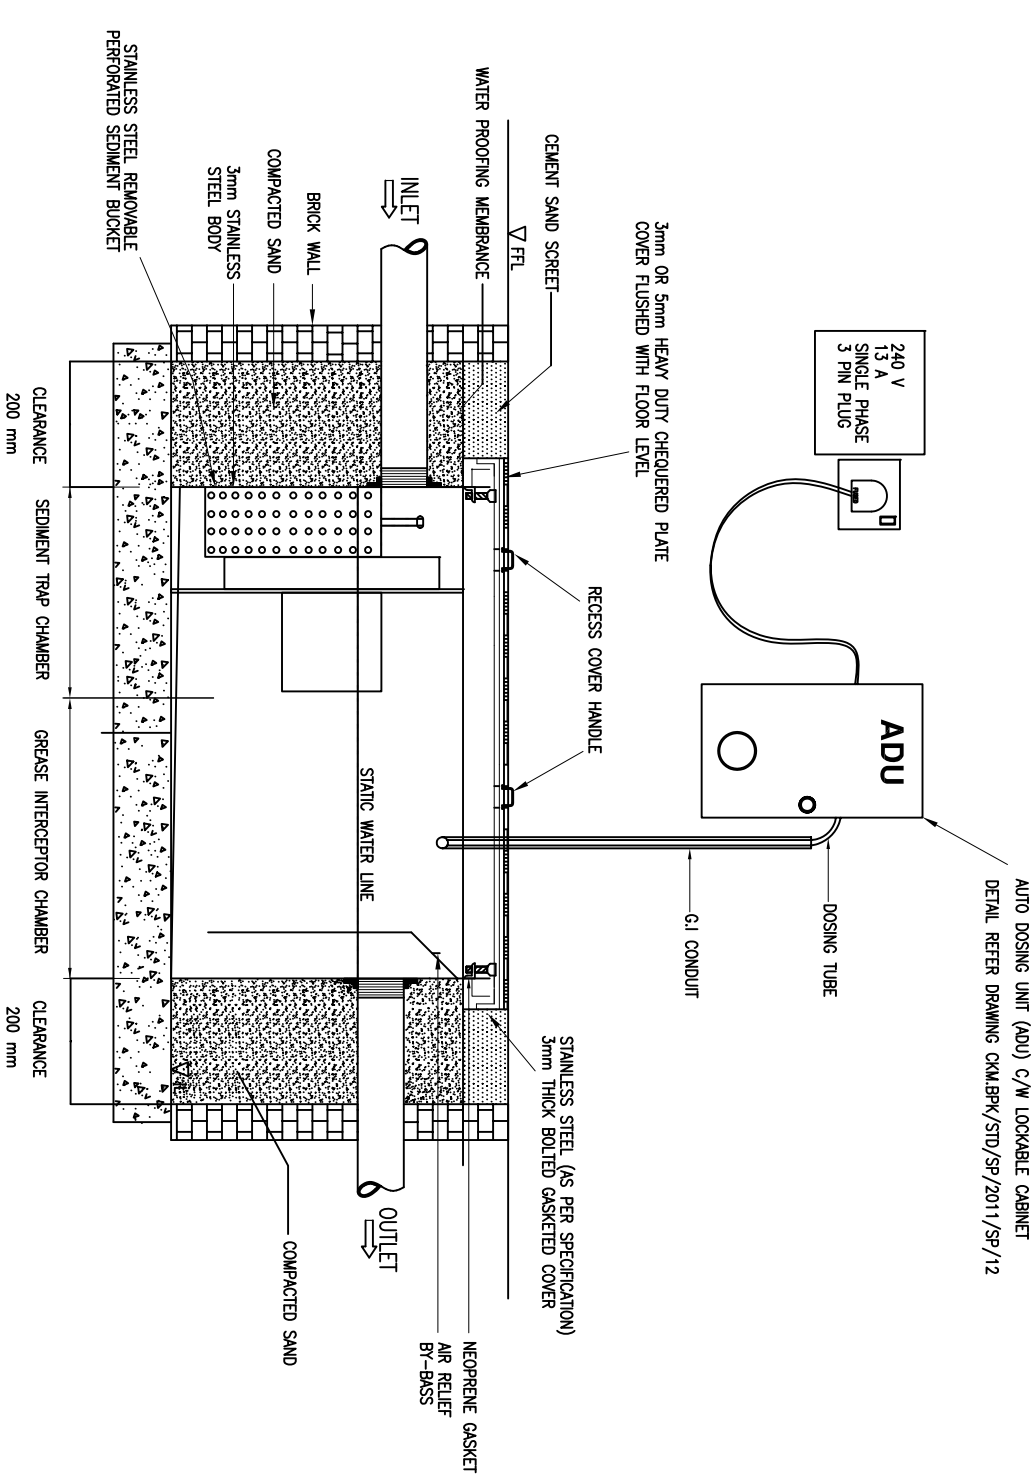

AUTO DOSING UNIT (ADU) C/W LOCKABLE CABINET
DETAIL REFER DRAWING CKM/BPK/STD/SP/2011/SP/12

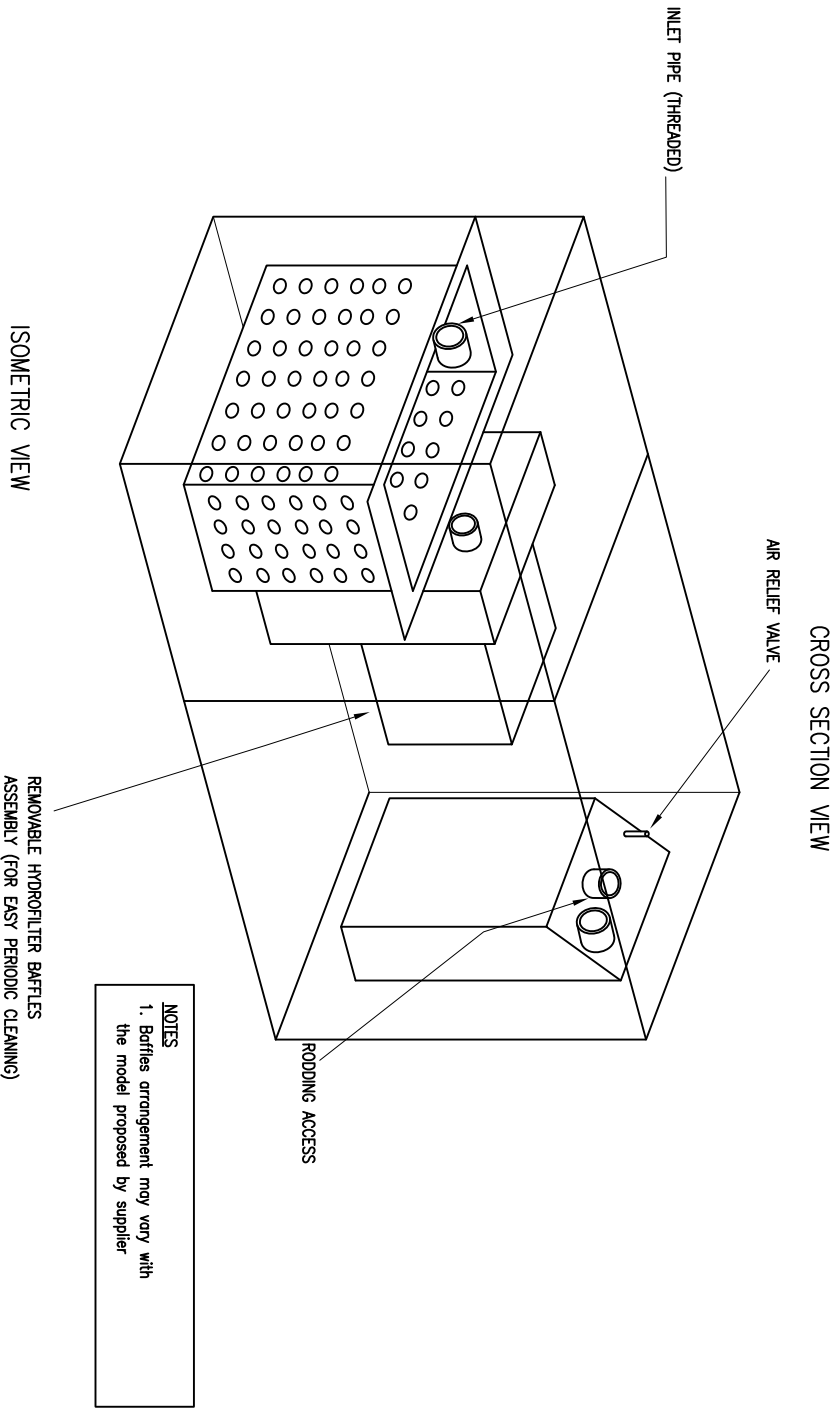

DETAILS OF GREASE TRAP INSTALLATION

SCALE : N.T.S.

NOTE:

- Grease trap must be maintained regularly, i.e.
 - Bucket to be cleared daily.
 - Grease to be skimmed off at the minimum on alternate days. However for heavy usage, grease must be skimmed daily.
 - Shall use Bioenzymes to biocentically degrade fats, oil & grease trapped on the grease trap.
 - Liquid or powder type of bioenzymes can be used.

LEGEND:

- IL Invert Level
FFL Finish Floor Level
ADU Automatic Dosing Unit



JASA KEPADA RAKYAT

CAWANGAN KEJURUTERAAN MEKANIKAL
Ibu Pejabat JKR Malaysia

SANITARY PLUMBING SYSTEM


DETAILS OF GREASE TRAP INSTALLATION

DATE: 2017

SCALE: NTS

DRAWING NUMBER:

CKM/STD/CWSP/SP/REV2017/11

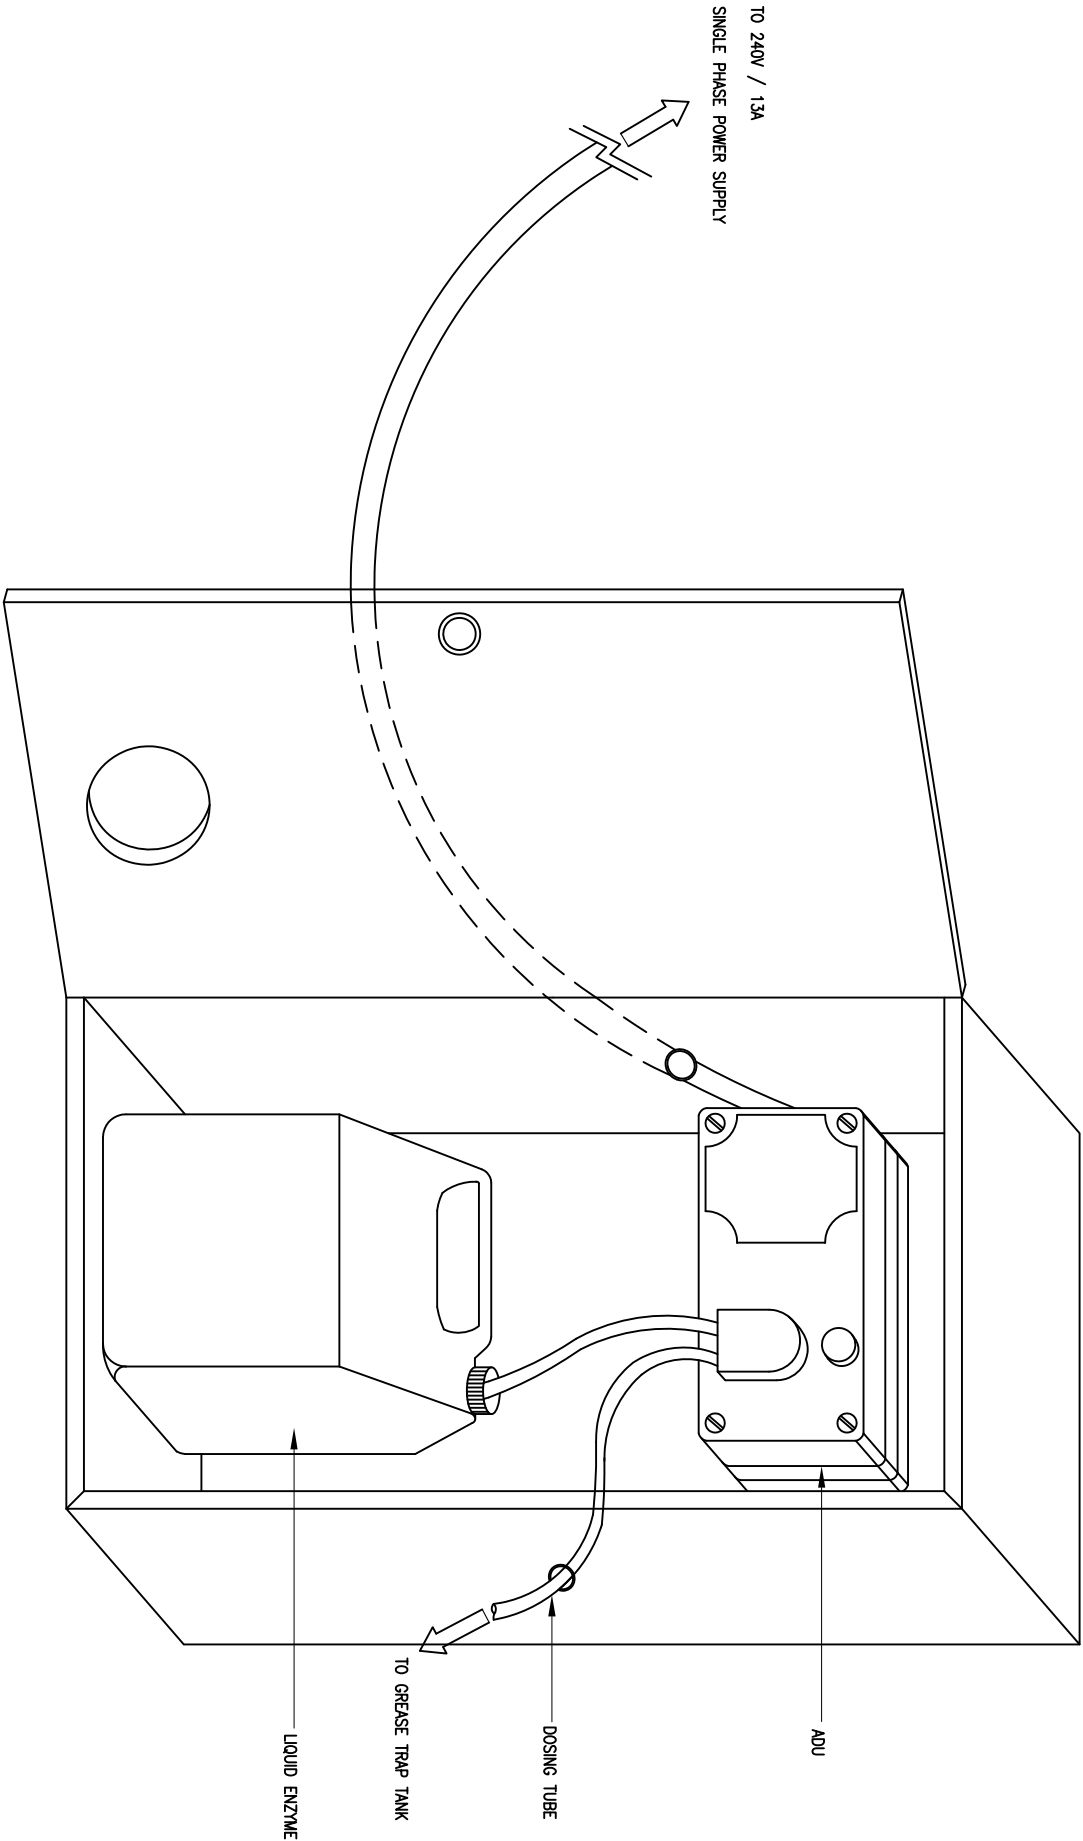

JASA KEPADA RAKYAT


CAWANGAN KEJURUTERAAN MEKANIKAL
Ibu Pejabat JKR Malaysia

SANITARY PLUMBING SYSTEM

DETAILS OF STAINLESS STEEL OR MILD STEEL
WEATHERPROOF LOCKABLE CABINET FOR
AUTO DOSING UNIT (ADU) STORAGE

DATE:	SCALE:
2017	NTS

DRAWING NUMBER:
CKM/STD/CWSP/SP/REV2017/1/2

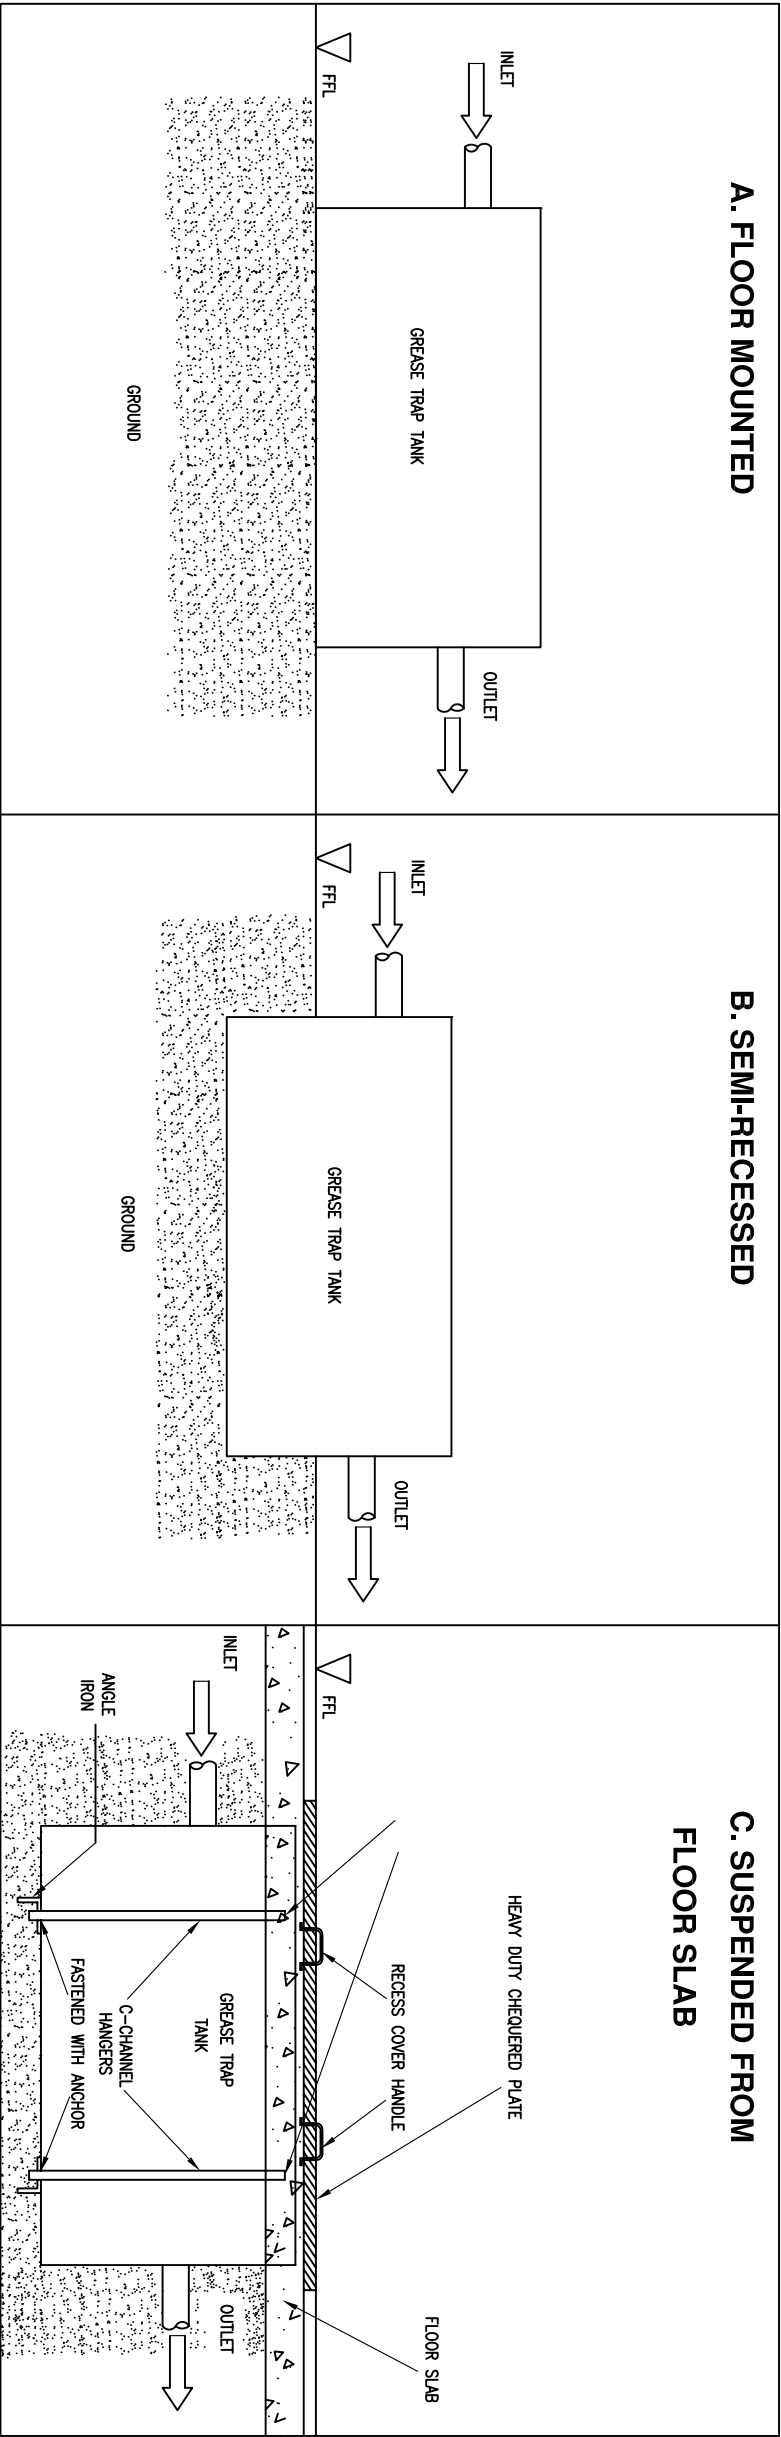

TYPE OF INSTALLATION FOR GREASE TRAP

SCALE : NTS




JASA KEPADA RAKYAT

CAWANGAN KEJURUTERAAN MEKANIKAL
Ibu Pejabat JKR Malaysia

SANTARY PLUMBING SYSTEM

TYPE OF INSTALLATION FOR GREASE TRAP

DATE:	2017	SCALE:	NTS
DRAWING NUMBER:	CKM/STD/CWSP/SP/REV2017/13		

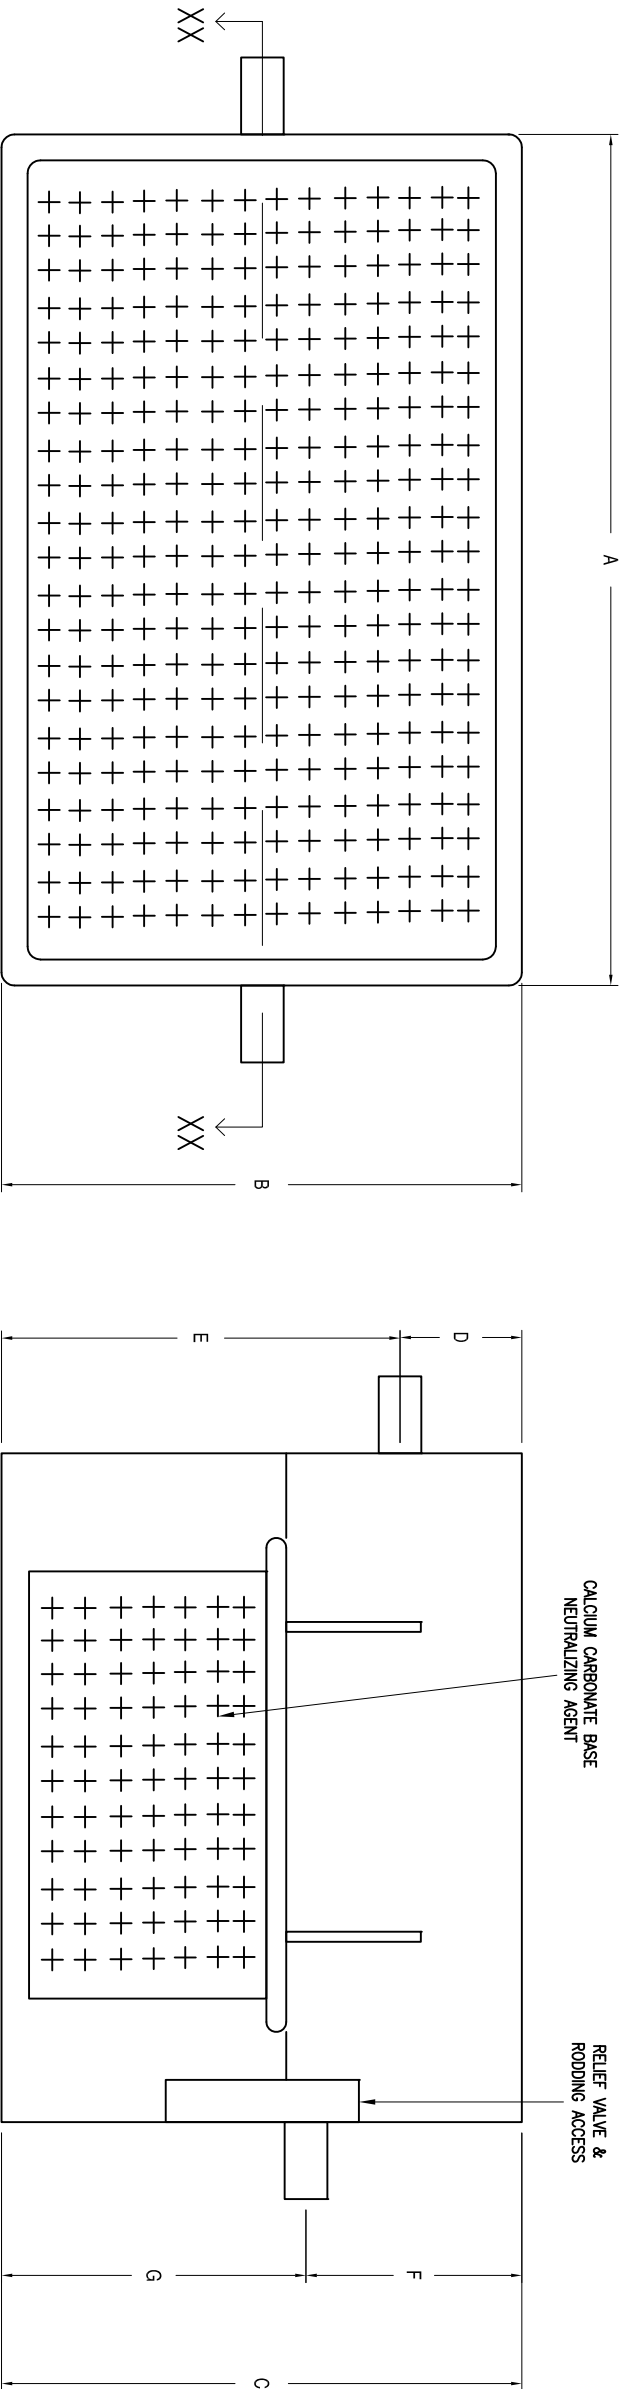


PLAN VIEW

SIDE VIEW – XX

DIMENSION DATA

Average Continuous Flowrate (litres/min)	No. of Sink / Tab	Capacity (litres)	Inlet & Outlet (mm)
10	1-10	50	75
17	1-20	85	75
25	21-30	125	75
30	31-40	150	75
40	41-50	200	100

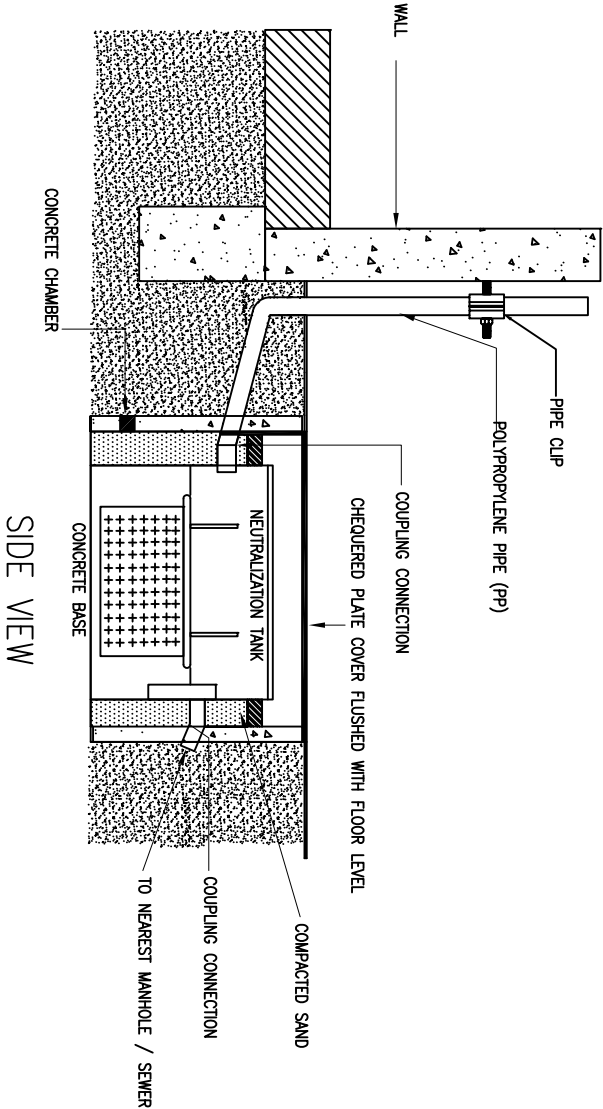

SIDE VIEW

DETAILS OF INSTALLATION FOR NEUTRALIZATION TANK

SCALE : N:1.S



JASA KEPADA RAKYAT

CAWANGAN KEJURUTERAAN MEKANIKAL
Ibu Pejabat JKR Malaysia

SANITARY PLUMBING SYSTEM


DETAILS OF INSTALLATION FOR NEUTRALIZATION
TANK

DATE: 2017

SCALE: NTS


DRAWING NUMBER:

CKM/STD/CWSP/SP/REV2017/14

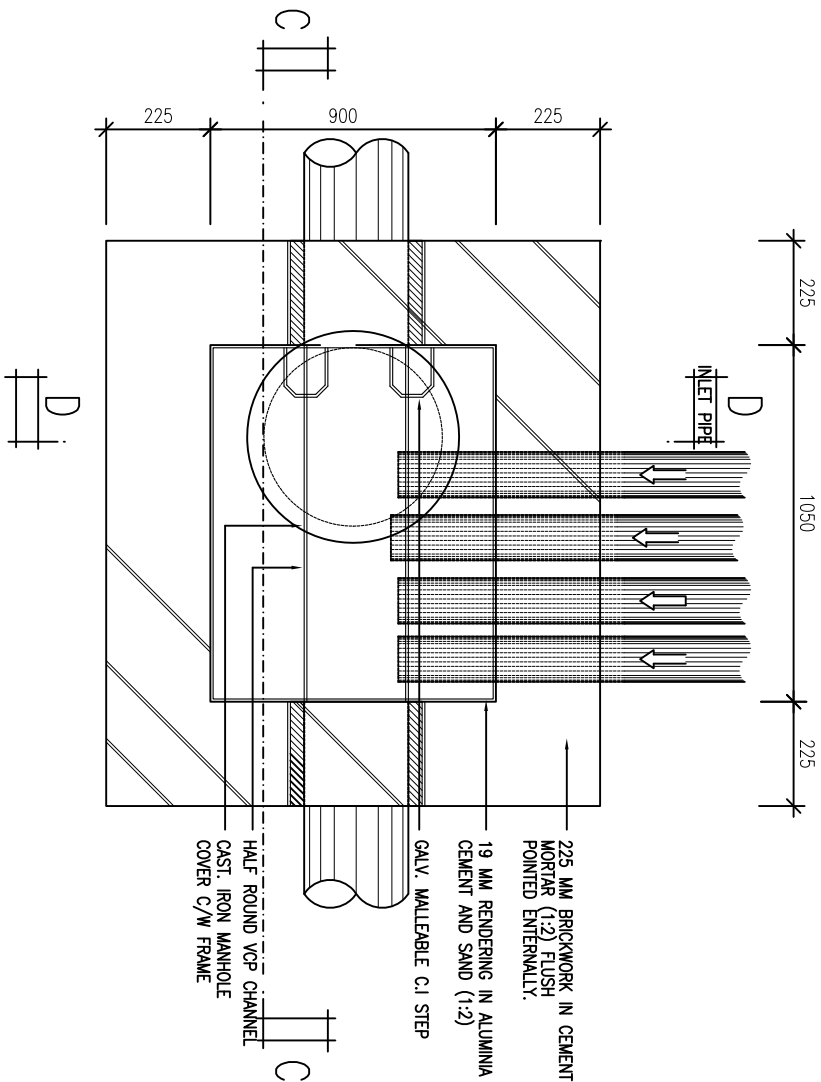


PLAN VIEW

(Maximum 4 inlet from gully trap/wc/stack pipe to inspection chamber)

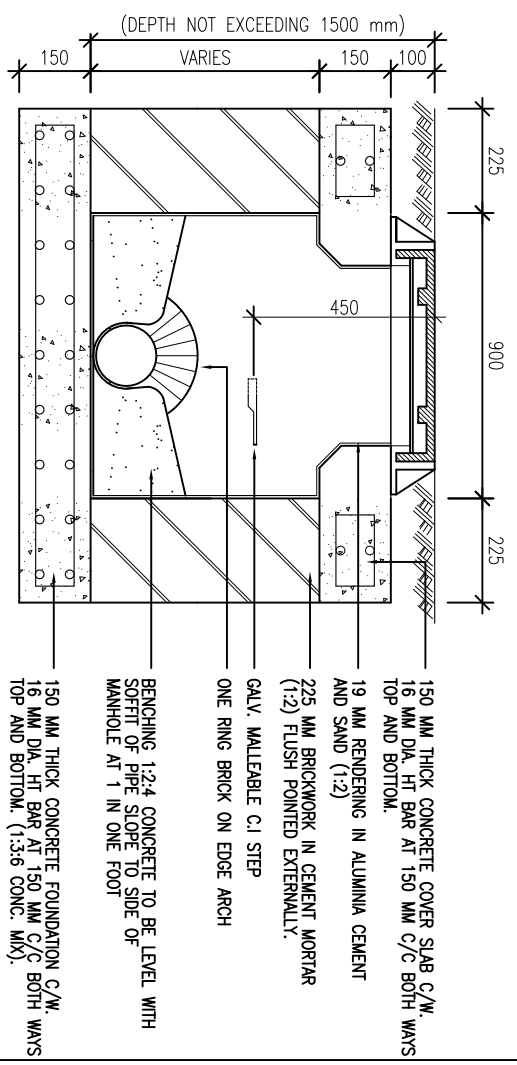

SECTION 'D - D'

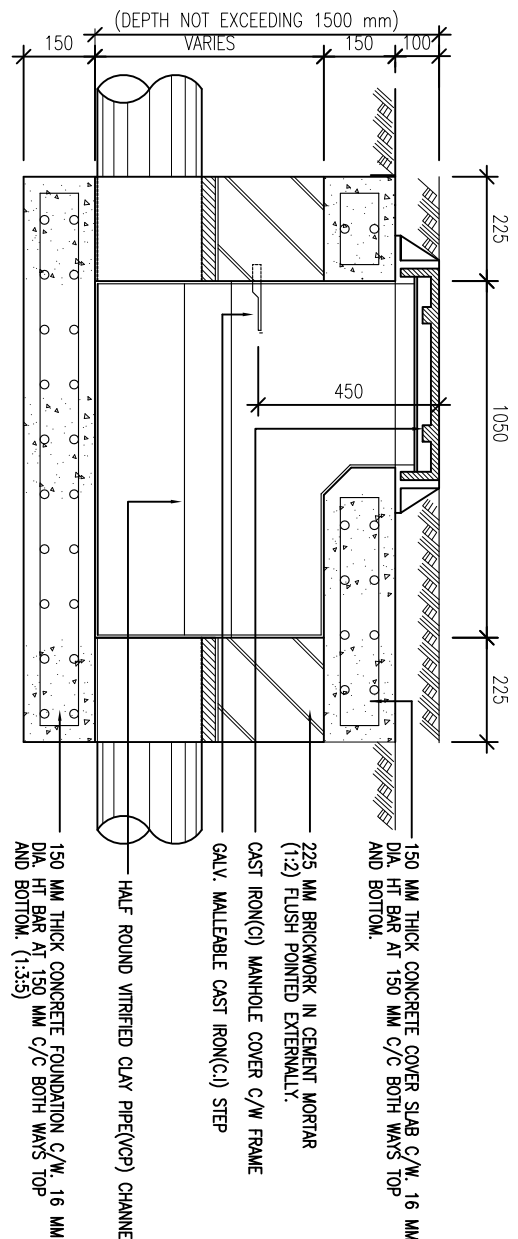

SECTION 'C - C'

DETAILS OF INSPECTION CHAMBER

SCALE: N.T.S



JASA KEPADA RAKYAT

CAWANGAN KEJURUTERAAN MEKANIKAL
Ibu Pejabat JKR Malaysia

SANITARY PLUMBING SYSTEM

DETAILS OF INSPECTION CHAMBER

DATE:	2017	SCALE:	NTS
DRAWING NUMBER:	CKM/STD/CWSP/SP/REV2017/1/5		